

DRAWING INDEX

A8.01 DOOR AND GLAZING SCHEDULES

A8.02 DOOR & WINDOW DETAILS A8.03 DOOR & WINDOW DETAILS A9.01 REFLECTED CEILING PLAN A11.10 PROJECT SPECIFICATIONS A11.11 PROJECT SPECIFICATIONS

GENERAL STRUCTURAL A0.00 COVER SHEET S100 COVER / GENERAL STRUCTURAL DATA S200 FOUNDATION PLAN C0 LOCATION MAP AND DRAWING INDEX S210 FOUNDATION DETAILS C1 FOUNDATION DETAILS GENERAL NOTES AND LEGEND S211 C2 **EXISTING CONDITIONS** S300 LOW ROOF FRAMING PLAN C3 SITE PLAN S301 UPPER ROOF FRAMING PLAN C4 S310 FRAMING DETAILS UTILITY PLAN S311 FRAMING DETAILS C5 **GRADING PLAN** C6 EROSION AND SEDIMENT CONTROL PLAN C7 SWPPP GENERAL NOTES AND DETAILS C8 STORM SEWER PLAN AND PROFILE MECHANICAL, ELECTRICAL, PLUMBING COVER SHEET C9 STORM SEWER PLAN AND PROFILE MEP2 SITE UTILITIES PLAN C10 MEP3 SITE LIGHTING PLAN EXISTING DRAINAGE AREA MAP C11 PROPOSED DRAINAGE AREA MAP EQ100 EQUIPMENT PLAN C12 **DETAILS** C13 **DETAILS** MECHANICAL **DETAILS** C14 M100 HVAC PLAN MD100 HVAC DETAILS AND SCHEDULES C15 LANDSCAPE PLAN C16 PHOTOMETRICS PLAN ELECTRICAL ARCHITECTURAL EP100 POWER PLAN A0.01 LEGENDS & GENERAL NOTES EP101 POWER PLAN - UNDERGROUND CONDUITS A0.10 ARCHITECTURAL SITE PLAN EP102 POWER ELEVATIONS A0.11 TRASH ENCLOSURE AND DETAILS EP103 SECURITY CAMERA PLAN EL100 LIGHTING PLAN A1.01 FIRST FLOOR PLAN ENLARGED PLANS AND DETAILS ED100 POWER DETAILS & SCHEDULES ED200 TUNNEL CONTROLLER SCHEDULES A3.01 ROOF PLAN AND DETAILS EXTERIOR ELEVATIONS A4.01 **PLUMBING** A5.01 WALL SECTIONS PS100 SANITARY SEWER AND VENT PLAN A5.02 WALL SECTIONS WALL SECTIONS PW100 WATER & GAS PIPING PLAN A5.03 PW101 PLUMBING ELEVATIONS A5.04 WALL SECTIONS

PD100 PLUMBING DETAILS & SCHEDULES

ARCHITECT FINKLE + WILLIAMS ARCHITECTURE 8787 Renner Blvd, Suite 100 Lenexa, Kansas 66219 PH. 913.498.1550

COCHRAN ENGINEERING 8 East Main Street Wentzville, MO 63385 PH. 636.332.4574

LANDSCAPE COCHRAN ENGINEERING 8 East Main Street Wentzville, MO 63385 PH. 636.332.4574


STRUCTURAL CROCKETT ENGINEERING 1000 W NiFong Blvd, Bldg. 1 Columbia, MO 65203 PH. 573.447.0292

CONTRACTOR

MECHANICAL TIMBERLAKE ENGINEERING 912 South Old Highway 63 Columbia, MO 65201 PH. 573.875.4365

PLUMBING TIMBERLAKE ENGINEERING 912 South Old Highway 63 Columbia, MO 65201 PH. 573.875.4365

ELECTRICAL TIMBERLAKE ENGINEERING 912 South Old Highway 63 Columbia, MO 65201 PH. 573.875.4365

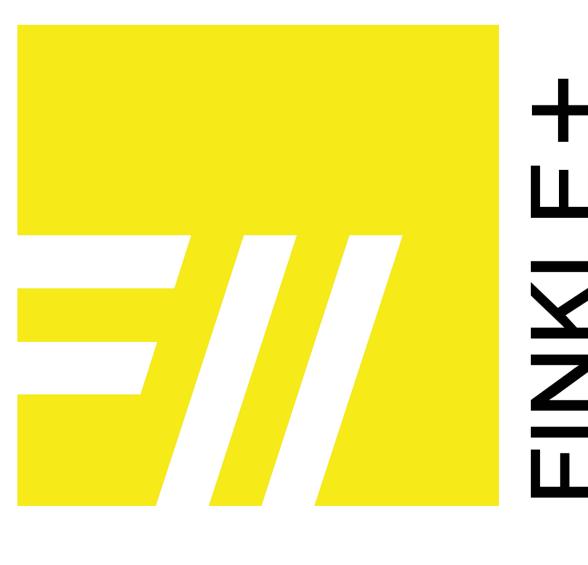

ROOM FINISH SCHEDULE													
ROOM		ELD.	BASE			WALLS				CEILING		DEMARKO	
NO.	NAME	FLR.	N	Е	S	W	N	Е	S	W	MAT.	HT.	REMARKS
101	WASH BAY	CON-1	-	-	-	-	PVC-1	PVC-1	PVC-1	PVC-1	PVC-1	13'-10" +/-	
102	LOBBY	EPF-1	EPB-1	EPB-1	EPB-1	EPB-1	PNT-2	PNT-2	PNT-2	PNT-2	ACT-1	10'-0"	
103	OFFICE	EPF-1	EPB-1	EPB-1	EPB-1	EPB-1	PNT-2	PNT-2	PNT-2	PNT-2	ACT-1	10'-0"	
104	STAFF TOILET	EPF-1	EPB-1	EPB-1	EPB-1	EPB-1	PNT-2	PNT-2	PNT-2	PNT-2	ACT-1	9'-0"	(1) \
105	CUSTOMER TOILET	EPF-1	EPB-1	EPB-1	EPB-1	EPB-1	PNT-2	PNT-2	PNT-2	PNT-2	ACT-1	9'-0"	(1)
107	EQUIPMENT	CON-1	_	-	-	_	PNT-1	PVC-1	PVC-1	PNT-1	PVC-1	STR	

ROOM FINISH LEGEND

FLOOR FINISHES

CON: CONCRETE

CON-1: CONCRETE WITH METZGER/MCGUIRE RE 88 SEMI-RIGID POLYUREA OR EQUAL FLOOR JOINT FILLER.

EPF: EPOXY FLOORING INSTALLED PER MANUFACTURER'S RECOMMENDATION

• EPF-1: MFR: TNEMEC, STYLE: 224 DECKO FLECK, COLOR: 503

BASE FINISHES

EPB: EPOXY FLOORING INSTALLED PER MANUFACTURER'S RECOMMENDATION

• EPB-1: MFR: TNEMEC, STYLE: 224 DECKO FLECK, COLOR: 503

WALL FINISHES

PNT: ACRYLIC LATEX COATING - 2 FINISH COATS OVER PRIMER (PREPRITE PROBLOCK PRIMER/SEALER)

- PNT-1: SHERWIN WILLIAMS, SNOWBOUND, SW7004, SEMI-GLOSS LATEX COATING
- PNT-2: SHERWIN WILLIAMS, EVENING SHADOW, SW7662, SEMI-GLOSS LATEX COATING PNT-3: SHERWIN WILLIAMS, BLACK MAGIC, SW6991, SEMI-GLOSS LATEX COATING

PVC: PLASTIC WALL LINER PANELS

PVC-1: RELINE WALL PANELS, NUFORM BUILDING TECHNOLOGIES, 12" WIDE APPLIED DIRECTLY OVER RIGID INSULATION TO CMU WALL; PANELS AND FASTENERS OWNER PROVIDED AND

CEILING FINISHES REFERENCE REFLECTED CEILING PLAN(S) FOR CEILING FINISH LOCATIONS & TRANSITIONS.

ACT: ACOUSTICAL CEILING TILE

ACT-1: SIZE: 24" X 24" X 1/2" SQUARE EDGE (WHITE), MFR: USG SHEETROCK BRAND LAY-IN GYPSUM CEILING PANELS, STYLE: CLIMAPLUS PERFORMANCE (VINYL FACED), GRID: 15/16" DON BRAND DX/DXL

EXP: EXPOSED TO STRUCTURE

• EXP-1: PAINT ALL EXPOSED MECHANICAL, DUCTS, PIPES, STRUCTURE, AND DECKING PNT-1

PVC: PVC PLASTIC CEILING PANELS

PVC-1: RELINE WALL PANELS, NUFORM BUILDING TECHNOLOGIES, 12" WIDE ON 2X4 FURRING STRIPS; PANELS AND FURRING OWNER PROVIDED AND INSTALLED

CASEWORK FINISHES

LAM: HIGH PRESSURE LAMINATE

• LAM-1: MFR: WILSONART: PATTERN: 1595 BLACK IN MATTE FINISH

GENERAL FINISH NOTES

PAINT ALL HOLLOW METAL DOORS AND FRAMES WITH PNT-3, U.N.O. PAINT METAL WALL-MOUNTED ACCESS DOORS, GRILLES AND UNFINISHED COVER PLATES TO MATCH ADJACENT WALL SURFACE.

FINISH REMARKS

(1) PAINT USED IN RESTROOMS TO BE EPOXY BASED

 $\overbrace{}$

- ALL ACCESSORIES SHALL BE STAINLESS STEEL UNLESS NOTED OTHERWISE.
- ALL ACCESSORIES SHALL BE DESIGNED TO MEET ADA STANDARDS.
- (1) COMBINATION PAPER TOWEL DISPENSER/WASTE RECEPTACLE, SURFACE MOUNT (BOBRICK B-380349 OR APPROVED EQ., OWNER PROVIDED AND GC INSTALLED)


TOILET ACCESSORY / EQUIPMENT LEGEND

- (2) LIQUID SOAP DISPENSER SURFACE MOUNT (BOBRICK B-4112 OR APPROVED EQ.)
- (OWNER PROVIDED AND GC INSTALLED)
- (3) UNFRAMED MIRROR 24" W x 48" H (GC PROVIDED AND GC INSTALLED)
- (4) MULTI-ROLL TOILET TISSUE DISPENSER W/NO KEYED LOCK (BOBRICK B-2888 OR APPROVED EQ.) (OWNER PROVIDED AND GC INSTALLED)
- (5) GRAB BARS AS SHOWN ON PLANS AND ELEVATIONS (BOBRICK B-6806 SERIES OR APPROVED EQ.)
 - (5A) GRAB BAR (BOBRICK B6806 X 42)
 - LOCATE AS SHOWN IN ACCESSORY MOUNTING HEIGHTS (GC PROVIDED AND GC INSTALLED) (5B) GRAB BAR (BOBRICK B6806 X 36)
 - LOCATE AS SHOWN IN ACCESSORY MOUNTING HEIGHTS (GC PROVIDED AND GC INSTALLED)
 - (5C) GRAB BAR (BOBRICK B6806 X 18)
- LOCATE AS SHOWN IN ACCESSORY MOUNTING HEIGHTS (GC PROVIDED AND GC INSTALLED)
- (6) SANITARY NAPKIN DISPOSAL, SURFACE WALL MOUNT (BOBRICK B-254 OR APPROVED EQ.) (OWNER PROVIDED AND GC INSTALLED)
- (7) COAT AND HAT HOOK (BOBRICK B-6827 OR APPROVED EQ.)
- (OWNER PROVIDED AND GC INSTALLED)
- (8) A.D.A. RESTROOM SIGNAGE, REF. SHEET A0.01
- (9) TOILET SEAT COVER DISPENSER (BOBRICK B-221 OR APPROVED EQ.) (OWNER PROVIDED AND GC INSTALLED)

PLAN NOTE LEGEND

- A SCUPPER AND DOWNSPOUT, TO BE COLLECTED UNDERGROUND AND CONTINUED PER CIVIL ENGINEERING PLANS.
- B NOT USED.
- C TRASH PIT WITH METAL GRATE, REF. STRUCTURAL DRAWINGS
- D CT CABINET PER ELECTRICAL DRAWINGS
- E CT METER PER ELECTRICAL DRAWINGS F GAS METER PER PLUMBING DRAWINGS
- G ROOF ACCESS LADDER, COORDINATE LOCATION WITH ROOF HATCH AND PERLINS
- H LINE OF TRENCH EDGE; SEE STRUCTURAL DRAWINGS
- I LINE OF AWNING ABOVE, TYP.
- J BLACK MOTORIZED LOUVER, REF. MECH
- K TRENCH DRAIN PER PLUMBING DRAWINGS

TOILET ACCESSORY MOUNTING HEIGHTS

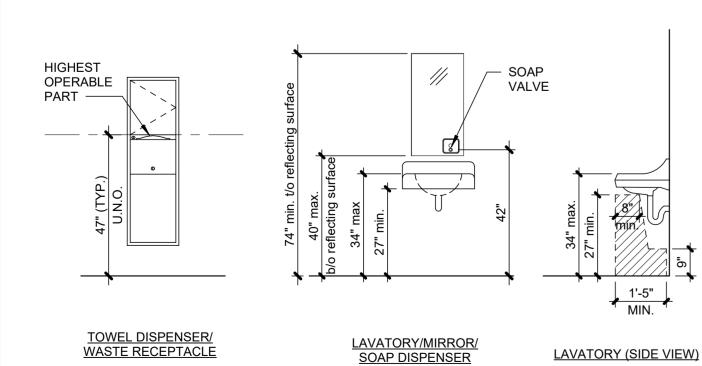

Maximum Reach Depth	.05 inch	2 inches	5 inches	6 inches	9 inches	11 inches					
Maximum Reach Height	48 inches	46 inches	42 inches	40 inches	36 inches	34 inches					
TABLE 603.6 - ANSI-117.1-2009											

GRAB BARS GRAB BARS SEAT COVER 42" min DISPENSER SANITARY NAPKIN DISPOSAL **TOILET TISSUE** DISPENSER -WATER CLOSET FLUSH VALVE — (ON OPEN SIDE OF WC) - WATER CLOSET (SIDE VIEW) LAVATORY (SIDE VIEW)

WHEELCHAIR ACCESSIBLE TOILET

ROOF HATCH SECTION

ROOF TYPE PER

LEGEND. REF. A3.01

BLOCKING AS REQUIRED

BENT PLATE CLIP. TYP. OF 3.

SEE STRUCTURAL DRAWINGS

PAINTED STEEL LADDER PNT-3

2" x1/4" STEEL PLATE SIDE

BARS PER STRUCTURAL

COVERS @ 12" O.C.

RAILS w/ 1 1/2" Ø x 20" WIDE

DRAWINGS, w/ ANTI-SLIP RUNG


2" x 1/4" ANGLE EA. SIDE. WELD

SLAB W/ EXPANSION ANCHORS

TO SIDE RAILS & FASTEN TO

TO MEET ALL OSHA

REQUIREMENTS

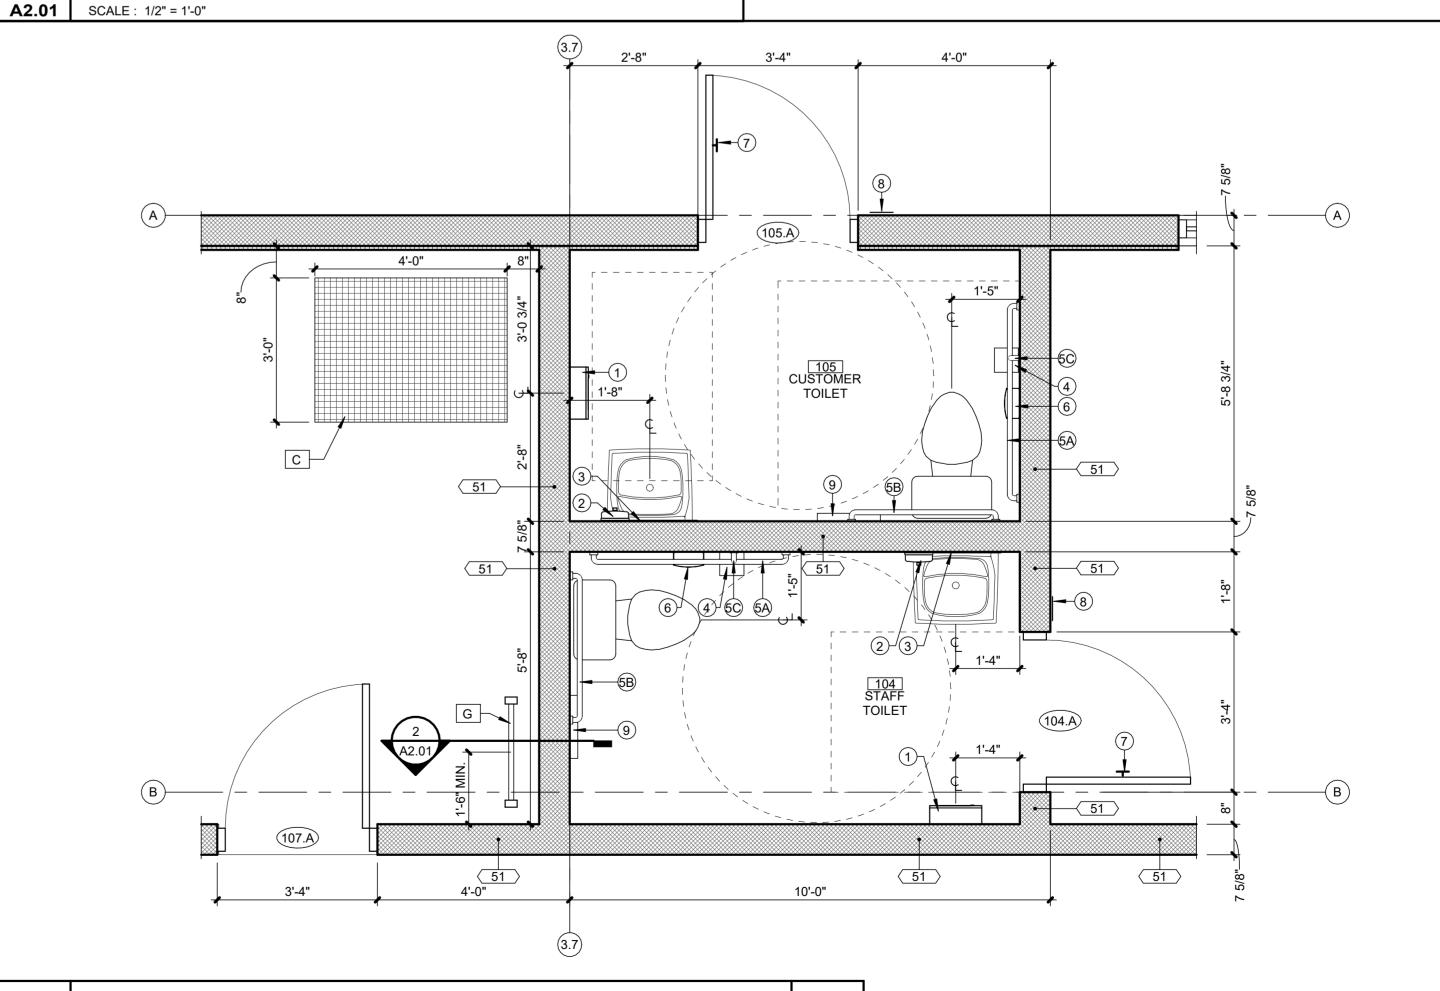

ENLARGED TOILET PLAN A2.01 SCALE: 1/2" = 1'-0"

 $\sim\sim\sim\sim\sim\sim\sim$ BILCO TYPE S 36" x 30" ROOF HATCH w/ ALUM. COVER & FRAME ON PREFABRICATED CURB,

w/ INTEGRAL CAP FLASHING, MANUAL OPERATION FROM INTERIOR & EXTERIOR (LOCKABLE FROM INTERIOR), PROVIDE SRC 360 MOBILE SAFETY RAILING SYSTEM. munum.

RETRACTABLE SAFETY POST

SEE FLOOR PLANS FOR WALL TYPES

> - CMU WALL PER PLAN - BENT PLATE CLIP, TYP.

- LADDER PER BELOW

DRAWINGS

DETAIL

OF 3, SEE STRUCTURAL

}

SEE DETAIL




CCW - LEE'S SUMMIT, MO

1021 JEFFERSON CROSSING LEE'S SUMMIT. MO 64081

Project No.: 20015.155 07/25/2025 Issued For: PERMIT

COMMENTS

REGISTRATION

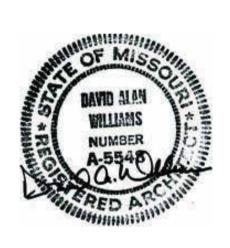

PROJECT TEAM FINKLE+WILLIAMS ARCHITECT

COCHRAN **ENGINEERING** LANDSCAPE COCHRAN **ENGINEERING**

STRUCTURAL **ENGINEERING** PLUMBING

MECHANICAL TIMBERLAKE **ENGINEERING ELECTRICAL** TIMBERLAKE **ENGINEERING**


ENGINEERING

FINKLE+

WILLIAMS ARCHITECTURE LENEXA, KANSAS 66219 913.498.1550 www.finklewilliams.com

SHEET TITLE **ENLARGED** PLANS AND **DETAILS**

SHEET NUMBER

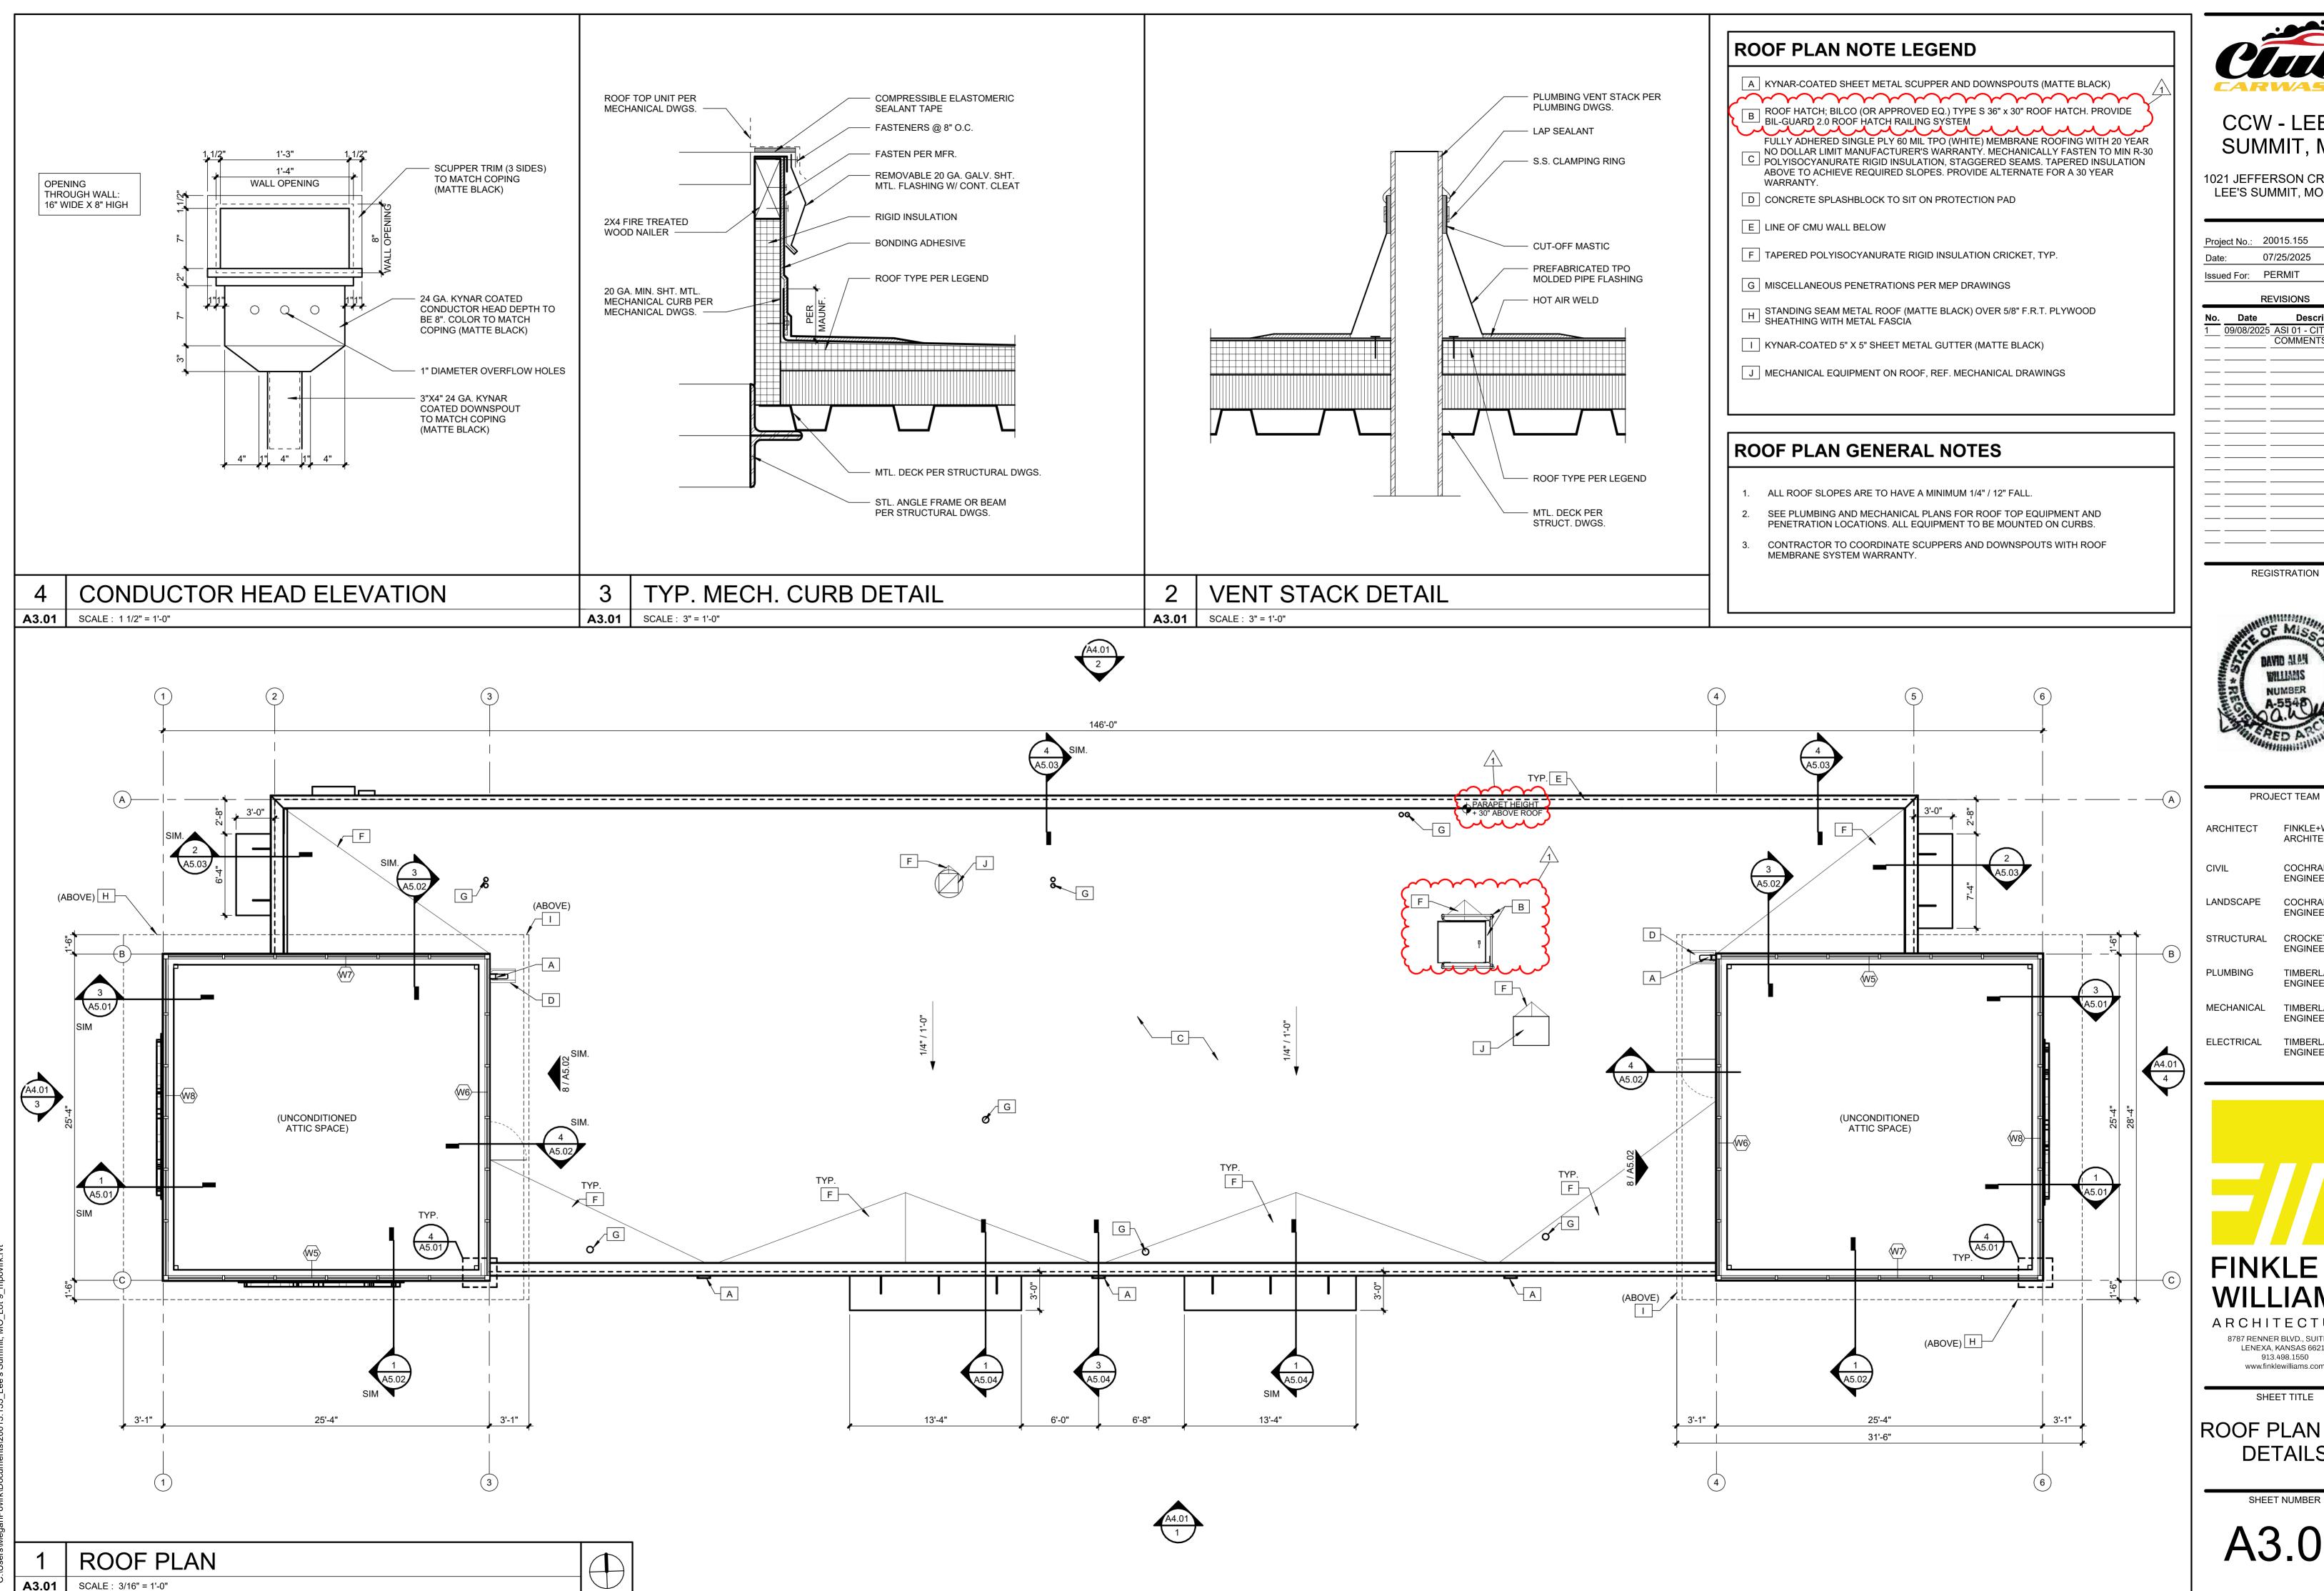

CCW - LEE'S SUMMIT, MO

1021 JEFFERSON CROSSING LEE'S SUMMIT, MO 64081

Project No.: 20015.155 07/25/2025 Issued For: PERMIT

PROJECT TEAM

FINKLE+WILLIAMS

COCHRAN ENGINEERING COCHRAN ENGINEERING

FINKLE+

WILLIAMS

8787 RENNER BLVD., SUITE 100 LENEXA, KANSAS 66219 913.498.1550 www.finklewilliams.com

SHEET TITLE

ROOF PLAN AND DETAILS