
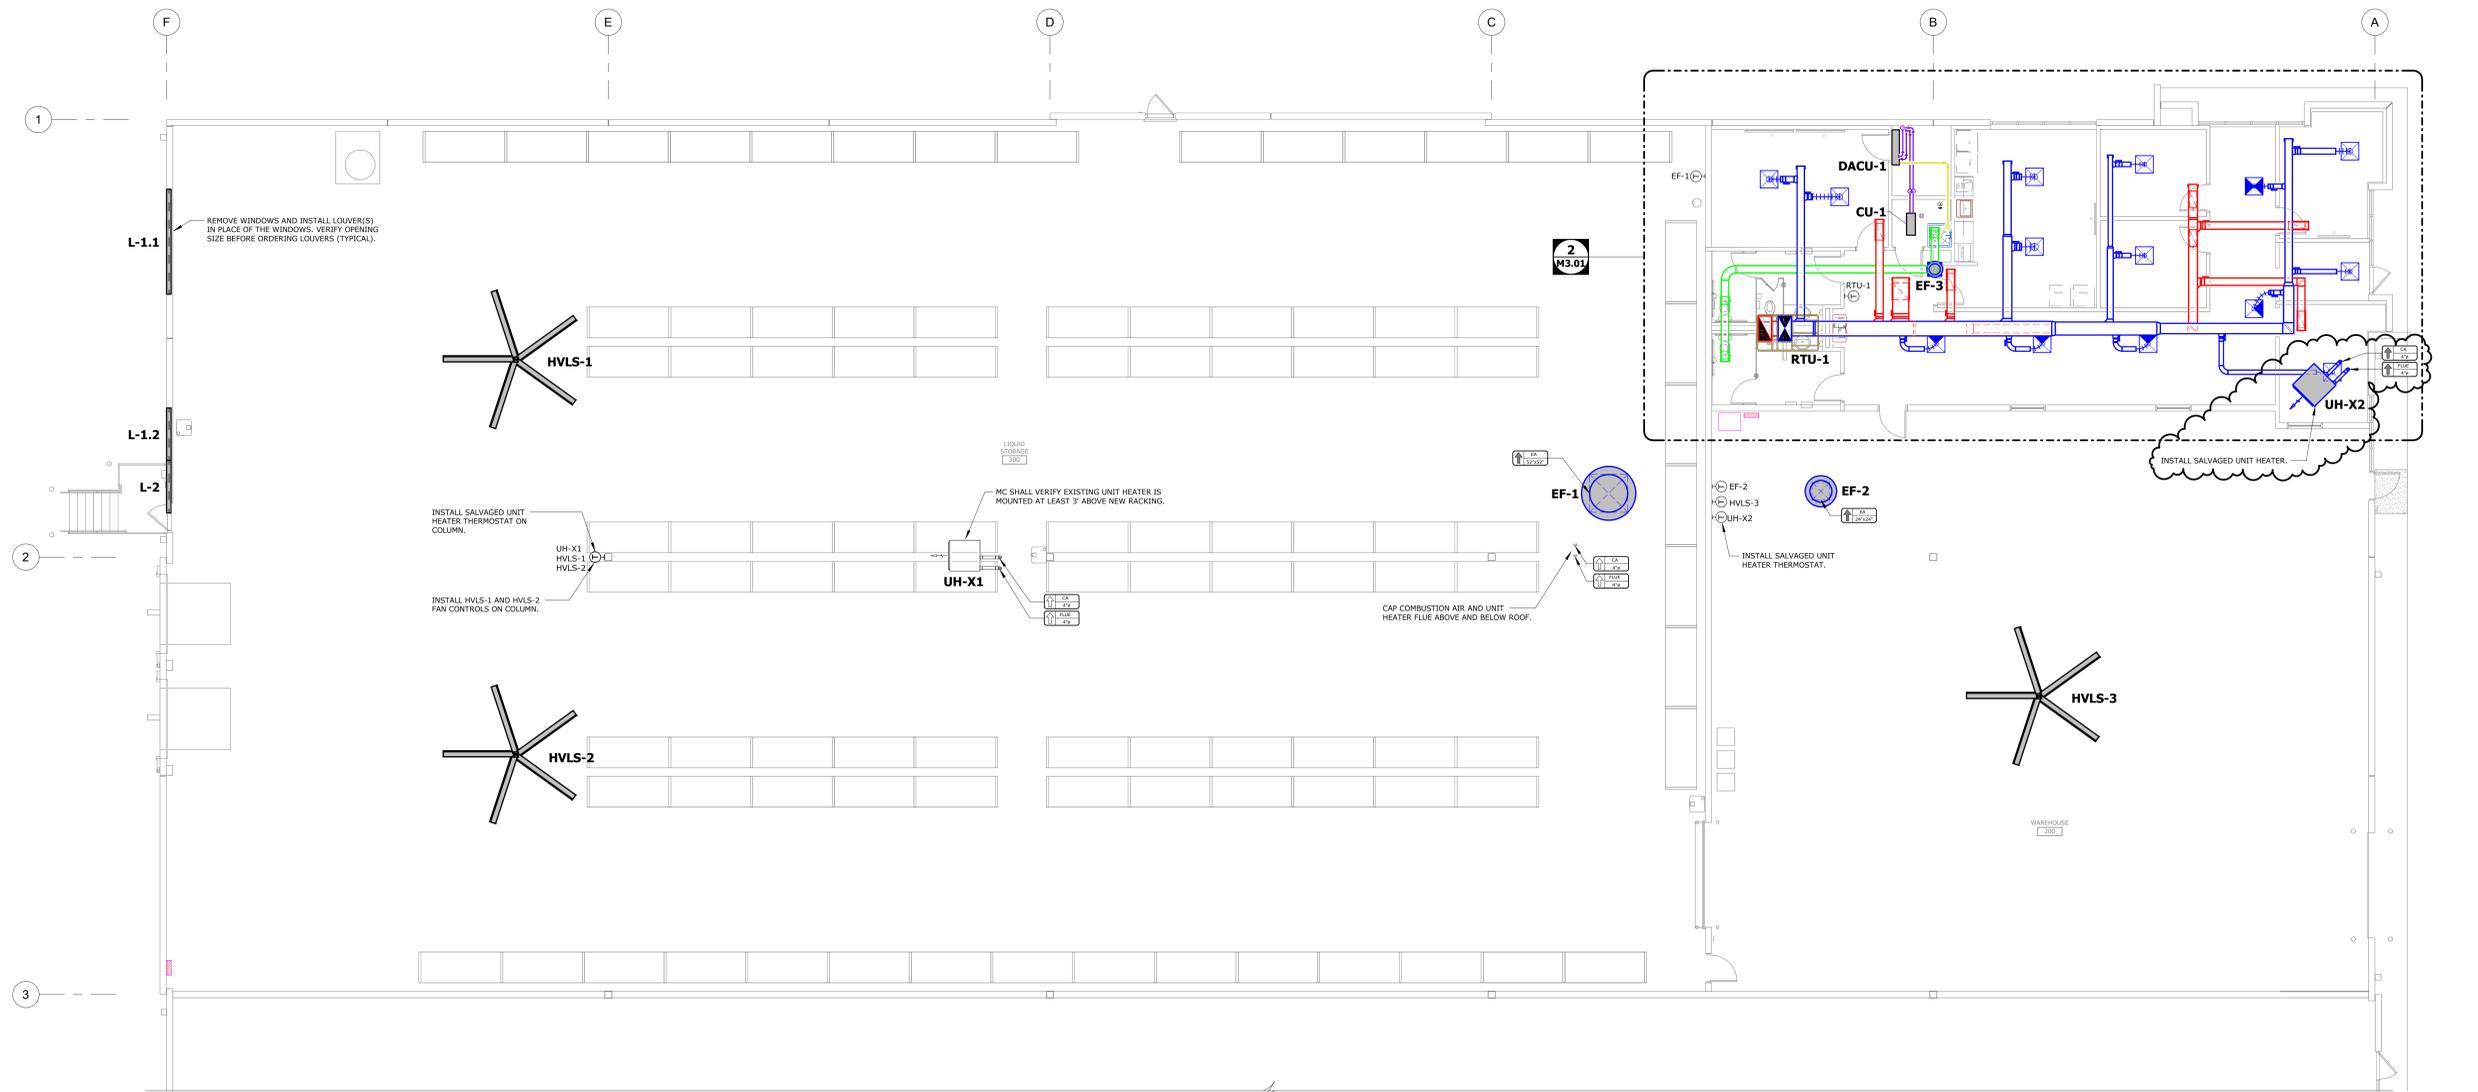


C:\Users\mmurach\Documents\138-25-25 MFP R25_murachKDEQU.rvt

12/15/2025 3:55:19 PM

- DRAWING INTERPRETATION NOTES:**
- EXISTING LINETYPE: THIN (LIGHT) SOLID LINES REPRESENT ITEMS THAT ARE EXISTING TO REMAIN OR ARE FURNISHED BY OTHERS.
 - NEW LINETYPE: THICK (DARK) SOLID LINES REPRESENT ITEMS THAT ARE NEW OR RELOCATED.
 - RELEVANT EXISTING CONDITIONS SHOWN ARE BASED ON RECORD DRAWINGS AND FIELD OBSERVATION(S). NOT ALL EXISTING ITEMS ARE SHOWN, OR COULD BE FIELD VERIFIED. ONCE AREAS OBSCURED FROM VIEW ARE EXPOSED, VERIFY THAT CONDITIONS ARE AS INDICATED ON THIS DRAWING. BEFORE PROCEEDING WITH WORK, NOTIFY THE ENGINEER IF CONDITIONS DIFFER FROM WHAT IS SHOWN.
 - EQUIPMENT SHOWN GRAY-SHADED OR TAGGED HAVE AN ASSOCIATED EQUIPMENT SCHEDULE. SEE SCHEDULE SHEET(S).
 - EQUIPMENT AND ITEMS TO BE RELOCATED ARE IDENTIFIED ON THE PLANS AND/OR EQUIPMENT SCHEDULE(S).

- DUCTWORK NEW WORK NOTES:**
- BRANCH DUCTWORK RUNOUTS TO GRILLES/DIFFUSERS SHALL BE THE NECK SIZE OF THE GRILLE/DIFFUSER, UNLESS NOTED OTHERWISE.
 - DUCT SIZES NOTED REPRESENT THE ACTUAL SHEET METAL SIZE. WHERE INTERIOR DUCT LINING IS USED, DUCT SIZES HAVE ALREADY ACCOUNTED FOR THE LINING.
 - SEE SHEETMETAL FITTING DETAILS FOR FITTING CONSTRUCTION REQUIREMENTS. CONSULT ENGINEER IF UNCERTAIN WHICH TYPE OF FITTING IS REQUIRED IN A SPECIFIC LOCATION.
 - DO NOT INSTALL ANY DUCTWORK BENEATH OR ADJACENT TO ANY EQUIPMENT THAT WOULD HINDER MAINTENANCE ACCESS TO EQUIPMENT OR THE FUTURE REMOVAL OF EQUIPMENT.

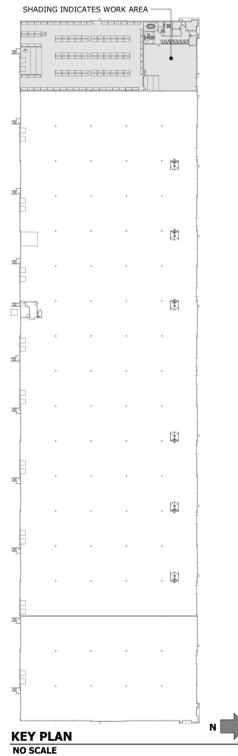

FIRST FLOOR - DUCTWORK AND PIPING PLAN
 SCALE: 1/8" = 1'-0"

STATE OF MISSOURI
 PATRICK W. KLAMAC
 LICENSE NUMBER 22926
 PROFESSIONAL ENGINEER

FOUNDATION
 ARCHITECTURE LLC
 275 SPRINGSIDE DR., SUITE 300
 AKRON, OHIO 44333
 PHONE: 330-666-3702
 PTAENGINEERING.COM

pta
 engineering

275 Springside Dr., Suite 300
 Akron, Ohio 44333
 Phone: 330-666-3702
 ptaengineering.com

PROJECT:

TENANT IMPROVEMENTS FOR:
SONNY'S
 2201 NE TOWN CENTRE BOULEVARD
 LEE'S SUMMIT, MISSOURI 64064

MARK	ISSUE	DATE
	ISSUED	08/15/2025
	REVISION 3	12/15/2025

PROJECT #: 016-0402
 DRAWN BY: PTA, INC. CHECKED BY: JSC

The Foundation Architecture, LLC and their Consultants shall be deemed the authors and owners of their respective instruments of service and shall retain all copyright, title, and other intellectual property rights. The instruments of service shall not be used for future projects or otherwise in the future for any purpose, without the prior written agreement of The Foundation Architecture, LLC. Any unauthorized use of the instruments of service shall be at the Owner's sole risk and without liability to The Foundation Architecture, LLC and their Consultants.

The Foundation Architecture, LLC © 2025

DRAWING TITLE:
**FIRST FLOOR
 MECHANICAL PLAN**

SHEET #:
M2.01