
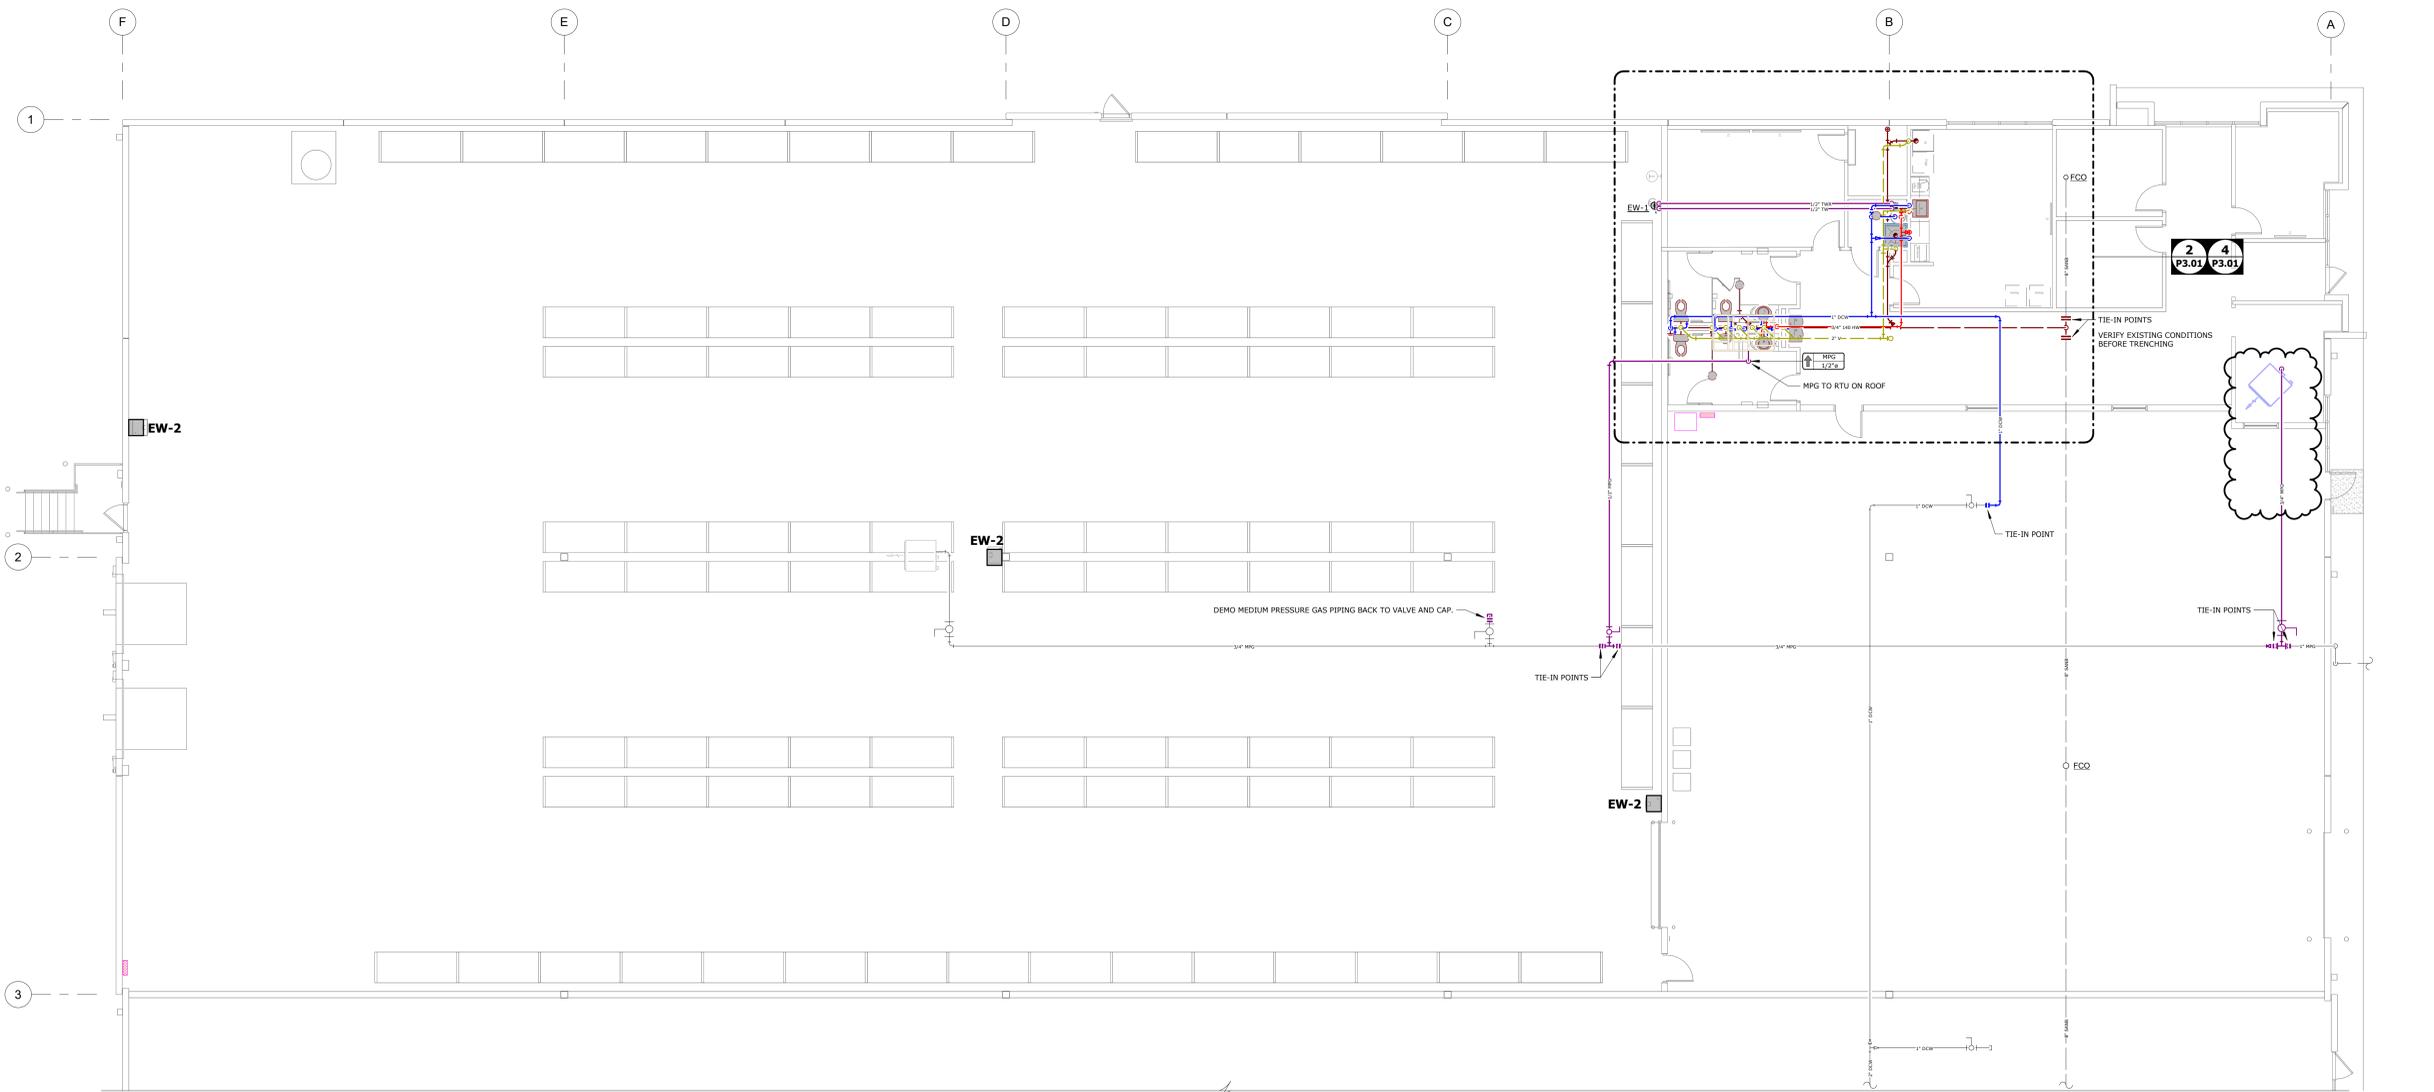


C:\Users\mmurach\Documents\138-25-25 MFP R25_murachKDEQU.rvt

12/15/2025 3:55:26 PM

- PLUMBING PIPING NEW WORK NOTES:**
1. SHUT-OFF VALVES SHALL BE INSTALLED IN ACCESSIBLE LOCATIONS. COORDINATE THE LOCATION OF ACCESS DOORS IN CEILING OR WALLS WITH THE GENERAL CONTRACTOR IF A VALVE IS REQUIRED TO BE LOCATED ABOVE AN INACCESSIBLE CEILING OR IN A WALL OR CHASE.
 2. DO NOT INSTALL ANY PIPING BENEATH OR ADJACENT TO ANY EQUIPMENT THAT WOULD HINDER MAINTENANCE ACCESS TO EQUIPMENT OR THE FUTURE REMOVAL OF EQUIPMENT.
 3. WHERE TYING INTO EXISTING SANITARY LINES, SNAKE SANITARY LINE CLEAR THROUGH TO EXISTING ACTIVE MAIN.
 4. FOR SANITARY AND VENT SIZES NOT SHOWN, REFER TO SANITARY ISOMETRIC. FOR RUNOUT/CONNECTION SIZES REFER TO FIXTURE AND EQUIPMENT SCHEDULES.
 5. FOR DOMESTIC WATER RUNOUT/CONNECTION SIZES REFER TO FIXTURE AND EQUIPMENT SCHEDULES.
 6. FOR NATURAL GAS RUNOUT/CONNECTION SIZES REFER TO FIXTURE AND EQUIPMENT SCHEDULES.
 7. MEDICAL GAS RUNOUT/CONNECTION SIZES UNLESS NOTED OTHERWISE SHALL BE:
MA, O2, NO, N, CO2- 1/2"
MV, WAGD - 3/4"

- DRAWING INTERPRETATION NOTES:**
1. EXISTING LINETYPE: THIN (LIGHT) SOLID LINES REPRESENT ITEMS THAT ARE EXISTING TO REMAIN OR ARE FURNISHED BY OTHERS.
 2. NEW LINETYPE: THICK (DARK) SOLID LINES REPRESENT ITEMS THAT ARE NEW OR RELOCATED.
 3. RELEVANT EXISTING CONDITIONS SHOWN ARE BASED ON RECORD DRAWINGS AND FIELD OBSERVATION(S). NOT ALL EXISTING ITEMS ARE SHOWN, OR COULD BE FIELD VERIFIED. ONCE AREAS OBTAINED FROM VIEW ARE EXPOSED, VERIFY THAT CONDITIONS ARE AS INDICATED ON THIS DRAWING. BEFORE PROCEEDING WITH WORK, NOTIFY THE ENGINEER IF CONDITIONS DIFFER FROM WHAT IS SHOWN.
 4. EQUIPMENT SHOWN GRAY-SHADED OR TAGGED HAVE AN ASSOCIATED EQUIPMENT SCHEDULE. SEE SCHEDULE SHEET(S).

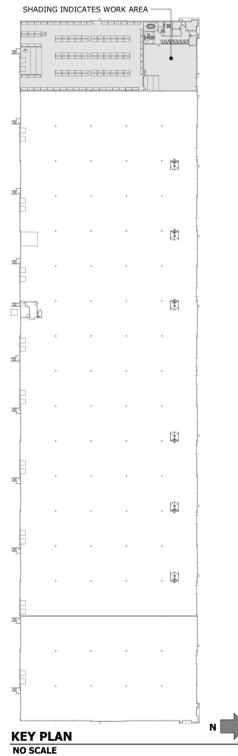

FIRST FLOOR - PLUMBING PLAN
SCALE: 1/8" = 1'-0"



PROJECT:

TENANT IMPROVEMENTS FOR:
SONNY'S
2201 NE TOWN CENTRE BOULEVARD
LEES SUMMIT, MISSOURI 64064

| MARK: | ISSUE: | DATE: |
|-------|------------|------------|
| | ISSUED | 08/15/2025 |
| | REVISION 2 | 12/04/2025 |
| | REVISION 3 | 12/15/2025 |

PROJECT #: 016-0402
DRAWN BY: PTA, INC. CHECKED BY: JSC

The Foundation Architecture, LLC and their Consultants shall be deemed the author and owners of their respective instruments of service and shall retain all copyright law, trademark and other intellectual rights, including copyrights. The instruments of service shall not be used for future editions or alterations to the project or for other projects, without the prior written agreement of The Foundation Architecture, LLC. Any unauthorized use of the instruments of service shall be the Owner's sole risk and without liability to The Foundation Architecture, LLC and their Consultants.

The Foundation Architecture, LLC © 2025

DRAWING TITLE:
FIRST FLOOR PLUMBING PLAN

SHEET #:
P2.01