V2.00

GENERAL NEW WORK NOTES

REFER TO

TA-SERIES

REFER TO

TA-SERIES

REFER TO

TA-SERIES

READ THE SPECIFICATIONS AND REVIEW DRAWINGS OF ALL

DIFFERENCES EXIST IN THE SPECIFICATIONS RELATING TO

DIVISIONS OF WORK AND ALL SUBCONTRACTORS.

DIVISIONS OF WORK. COORDINATE THIS WORK WITH ALL OTHER

ALL WORK SHALL CONFORM TO THE APPLICABLE SPECIFICATIONS

(DIVISION 26, DIVISION 27, DIVISION 28, ETC.) AND THE CUSTOMER

PRE-ESTABLISHED STRUCTURED CABLING STANDARDS; SHOULD

TECHNOLOGY AND THE CLIENT'S PRE-ESTABLISHED STANDARDS THE

TN0.1

CONTRACTOR SHALL CONTACT THE LOW VOLTAGE ENGINEER FOR 2 CAT6A 2,4,5/TN5.1 INTERCOM (CENTERLINE) DATA WALL OUTLET - WIRELESS REFER TO DISPLAY INPUT OUTLET V +14'-0"AFF ACCESS POINT CLARIFICATION THROUGH THE RFI PROCESS. TA-SERIES CABLE SUPPORTS OR J-HOOKS DATA WALL OUTLET 2,4,5/TN5.1 USE THE DEFAULT MOUNTING HEIGHTS SHOWN ABOVE UNO IN THE TELEVISION WALL OUTLET REFER TO √ 4D FULLY COORDINATE ALL CABLE TRAY, FIRE STOP CONDUITS / TA-SERIES CONSTRUCTION DOCUMENTS. MOUNTING HEIGHTS LISTED ARE ABOVE CONDUIT SLEEVE DATA WALL OUTLET 2,4,5/TN5.1 SLEEVES, AND CONDUIT ROUTING WITH STRUCTURAL ELEMENTS. (#) D" FINISHED FLOOR (AFF) OR ABOVE FINISHED GRADE (AFG) TO BOTTOM OF REFER TO **▽** 8D VIDEO OUTPUT OUTLET ("#"=QUANTITY, "D"=CONDUIT DIAMETER) COORDINATE CABLE TRAY AND CONDUIT INSTALLATIONS WITH OUTLET BOX. ALL DEVICES SHALL BE INSTALLED IN COMPLIANCE WITH TA-SERIES TELEPHONE, VoIP WAL OUTLET 4,5,7/TN5.1 ∏FS ARCHITECT, STRUCTURAL ENGINEER, STRUCTURAL CONTRACTOR, CURRENT ADA AND LOCAL REQUIREMENTS. UL FIRESTOP SYSTEM ASSEMBLY ∇ W,1D SECURITY IP END-POINT DEVICES AND GENERAL CONTRACTOR PRIOR TO INSTALLATION. ROUTING IN 1/TN5.1 **ELEVATOR PHONE OUTLET ABBREVIATIONS** CONCRETE SLAB OR UNDER SLAB (WHERE CONDUIT WOULD BE ON PB L"XW"XH" PULL BOX □ ELEV REFER TO TY-SERIES DRAWINGS FOR SECURITY DEVICES GRADE) REQUIRES THE USE OF WET LOCATION RATED CABLES. ("L"=LENGTH, "W"=WIDTH, "H"=HEIGHT) DATA CEILING OUTLET - WIRELESS 2 CAT6A LAN LOCAL AREA NETWORK 5,10/TN5.1 SC ADA AMERICANS WITH LCC LIMITED COMBUSTIBLE CABLE ACCESS POINT ALL TELECOMMUNICATIONS CONTINUOUS PATHWAYS SHALL BE CABLE(S) DETAIL LOCAL EXCHANGE CARRIER MULTI-SERVICE FLOOR BOX WITH DATA 3/TN5.1 DISABILITIES ACT BONDED TO THE TELECOMMUNICATIONS BONDING BACKBONE; FOR REFER TO CEILING SECURITY CAMERA RISER DIAGRAMS AFC ABOVE FINISHED CEILING LED LIGHT-EMITTING DIODE AND POWER OUTLETS, REFER TO CONDUITS, INSULATION BUSHINGS SHALL BE USED AT THE END OF TY-SERIES SPECS FOR FLOOR BOX TYPE ABOVE FINISHED FLOOR LINEAR FEET THE CONDUIT THE FARTHEST AWAY FROM THE SERVING TR; A REFER TO FIBER OPTIC CROSS CONNECT - DETAIL 8/TN5.1 1D WALL SECURITY CAMERA MULTI-SERVICE FLOOR BOX WITH DATA 2 AFG ABOVE FINISHED GRADE MAN METROPOLITAN AREA BONDING BUSHING SHALL BE USED AT THE END CLOSEST TO THE TY-SERIES AND POWER OUTLETS, INC. 2. SPECS FOR FLOOR BOX TYPE AND POWER OUTLETS, REFER TO AHJ AUTHORITY HAVING NETWORK SERVING TR. CONTRACTOR TO REFER TO THE ANSI-STD-J 607 JURISDICTION MATV MASTER ANTENNA STANDARD FOR ADDITIONAL INFORMATION AS TO THE INSTALLATION COPPER UTP CROSS CONNECT ANSI AMERICAN NATIONAL TELEVISION OF THE TELECOMMUNICATIONS BONDING BACKBONE. TELECOMMUNICATIONS END-POINT DEVICES MC MAIN CROSS-CONNECT STANDARDS INSTITUTE MDF MAIN DISTRIBUTION FRAME ACCESS POINT ALL FIRE RATED WALL / FLOOR ASSEMBLIES PENETRATED FOR DEVICE SCHEDULE 110-TYPE PROTECTOR BLOCK MFR MANUFACTURER AUDIO-VIDEO TELECOMMUNICATIONS CABLING PATHWAYS SHALL BE FIRE AWG AMERICAN WIRE GAUGE MH MAINTENANCE HOLE STOPPED WITH THE APPROVED FIRE STOP SYSTEMS (F/S). ALL CABLE(S) DESCRIPTION BAS BUILDING AUTOMATION MM MULTIMODE FIRESTOP SYSTEMS SHALL BE INSTALLED AS DIRECTED BY THE PATCH PANEL PATCH PANEL - DETAIL 6/TN5.1 CLOCK, ANALOG SINGLE SIDED, WALL MPOE MAIN POINT OF ENTRANCE MANUFACTURER AND AS SPECIFIED IN DIVISION 07 07 84 00 -BUILDING DISTRIBUTOR MPOP MAIN POINT OF PRESENCE "FIRESTOPPING". FIRE STOP ASSEMBLY LOCATIONS ARE TO BE CLOCK, DIGITAL DUAL SIDED, CEILING BDF BUILDING DISTRIBUTION MTD MOUNTED COORDINATED WITH CABLE TRAY PATHWAY TO TELECOM GROUND BAR (TGB) - DETAIL 6/TN5.2 MOUNT N/A NOT APPLICABLE TELECOMMUNICATIONS ROOM - SEE DETAIL 2/TN5.2. PAGING CALL BUTTON, WALL MOUNT BFC BELOW FINISHED CEILING NEC NATIONAL ELECTRICAL CODE 9/TN5.1 CONDUIT NFPA NATIONAL FIRE PROTECTION BACK BOXES AND CONDUIT LOCATIONS IN PRECAST CONCRETE TELECOM MAIN GROUND BAR (TMGB) - DETAIL 7/TN5.2 PAGING HORN SPEAKER, RECESSED WALLS SHALL BE COORDINATED WITH ARCHITECT. STRUCTURAL CAT CATEGORY ASSOCATION 9/TN5.1 WALL MOUNT CATV COMMUNITY ANTENNA NIC NOT IN CONTRACT ENGINEER, AND GC PRIOR TO ORDERING THE PRECAST WALLS. PAGING SPEAKER, RECESSED WALL TELEVISION nm NANOMETER 9/TN5.1 TELECOMMUNICATIONS BACKBONE CABLING MOUNT CCTV CLOSED CIRCUIT NRTL NATIONALLY RECOGNIZED ROUTING OF CABLES SHALL BE CONCEALED. CABLES SHALL BE — — — (REFER TO RISER DIAGRAM FOR MORE INFORMATION) PAGING SPEAKER, RECESSED CAN TELEVISION **TESTING LAB** ROUTED IN CONDUIT IN EXPOSED AREAS. MINIMIZE AMOUNT OF 9/TN5.1 CEILING MOUNT CD CAMPUS DISTRIBUTOR OC ON CENTER EXPOSED CONDUIT BY EMBEDDING CONDUIT IN SLAB WHEN TELECOMMUNICATIONS ROOM S RT TILE MOUNT PAGING SPEAKER, RECESSED CEILING OSHA OCCUPATIONAL SAFETY AND CMP COMMUNICATIONS PLENUM POSSIBLE. EMBEDDED CONDUITS AND PENETRATIONS OF 9/TN5.1 HEALTH ADMINISTRATION LADDER RACK - DETAIL 5/TN5.2 STRUCTURE SHALL FOLLOW DETAILS IN STRUCTURAL DRAWINGS. CMR COMMUNICATIONS RISER OSP OUTSIDE PLANT TELECOMMUNICATIONS RESPONSIBILITY MATRIX WHEN CONDUITS CAN ONLY BE INSTALLED EXPOSED, NOTIFY PBX PRIVATE BRANCH EXCHANGE JACKET ARCHITECT PRIOR TO START OF INSTALLATION OF CONDUITS. DAS DISTRIBUTED ANTENNA TELECOM MAIN GROUND BAR (TMGB) - WALL POE POWER OVER ETHERNET CABLES SHALL BE ROUTED IN CONDUIT WHEN ABOVE HARD ELEVATION VIEW SYSTEM PON PASSIVE OPTICAL NETWORK CEILINGS. CONDUITS FOR ELEVATOR PHONES AND FIRE ALARM dB DECIBELS POTS PLAIN OLD TELEPHONE CONTROL PANEL SHALL BE CONTINUOUS (HOMERUN) FROM THE DEMO DEMOLITION TELECOMMUNICATIONS ROOM TO THE APPLICABLE BOX / CABINET. PSTN PUBLIC SWITCHED TELECOM GROUND BAR (TGB) - WALL ELEVATION EXISTING CONTRACTOR SHALL SIZE AND PROVIDE CONDUITS TO MEET TIA-569. Construction Construction Description Comments Owner Owner ELECTRICAL CONTRACTOR TELEPHONE NETWORK ECIA ELECTRONIC COMPONENTS QTY QUANTITY TELECOMMUNICATIONS ROOMS SHALL BE DEDICATED FOR INDUSTRY ASSOCIATION TMGB/TGB - PLAN VIEW RCDD REGISTERED INFORMATION TECHNOLOGY USE (I.E. NO SHARED SPACE WITH A EMI ELECTROMAGNETIC COMMUNICATIONS JANITOR, FIRE ALARM SYSTEM, ETC.) NO SERVICES SHALL PASS DISTRIBUTION DESIGNER INTERFERENCE THROUGH THE SPACE UNLESS DEDICATED TO THE SPACE (NO TELECOM BACKBOARD General Communications EMS ENERGY MANAGEMENT RMC RIGID METAL CONDUIT PLUMBING, MECHANICAL, ELECTRICAL, FIRE, ETC.) SYSTEM RU RACK UNIT Grounding and Bonding EMT ELECTRICAL METALLIC SCS STRUCTURED CABLING Hangers and Supports TWO-POST EQUIPMENT RACK Conduits and Backboxes SF SQUARE FEET ER EQUIPMENT ROOM Cable Trays ETR EXISTING TO REMAIN SM SINGLEMODE Underground pathways for utility entrance and floor boxes SPECS SPECIFICATIONS FAAP FIRE ALARM ANNUNCIATOR FOUR-POST EQUIPMENT RACK Χ TBB TELECOMMUNICATIONS Firestops, Conduit Sleeves, and Sleeve Seals PANEL FACP FIRE ALARM CONTROL BONDING BACKBONE Structured Cabling TBD TO BE DETERMINED Telecom Room Cabinets, Racks, Frames, and Enclosures EQUIPMENT CABINET (REFER TO PLAN NOTES ON FD FLOOR DISTRIBUTOR TIA TELECOMMUNICATIONS Telecom Room Buildout (ex. backboard and ladder rack) ENLARGED PLANS FOR MORE INFORMATION) FMC FLEXIBLE METAL CONDUIT INDUSTRY ASSOCIATION Telecom Room Uninterruptible Power Supply (UPS) TGB TELECOMMUNICATIONS FS FIRE STOP SYSTEM FLR FLOOR GROUND BUS BAR Telecom Room Power Strips TMGB TELECOMMUNICATIONS MAIN F/UTP SCREEN TWISTED PAIR Optical Fiber Backbone Cable and Connectivity GROUND BUS BAR (SHIELDED) Copper Backbone Cable and Connectivity TR TELECOMMUNICATIONS ROOM GENERAL CONTRACTOR Copper Horizontal Cable and Connectivity GROUNDING EQUALIZER TYP TYPICAL **Data Communications** UNO UNLESS NOTED OTHERWISE GYP GYPSUM BOARD UL UNDERWRITER HC HORIZONTAL CROSS-Router / Firewall CONNECT LABORATORIES, INC. Core Switch / Edge Switch HCM HORIZONTAL CABLE UPS UNINTERRUPTIBLE POWER Wireless Access Points MANAGER Servers / Storage and Backup U/UTP UNSHIELDED TWISTED PAIR HH HAND HOLE Laptops / Desktops / Copiers / Printers / Scanners HERTZ V VOLT(S) IMC INTERMEDIATE METAL VCM VERTICAL CABLE MANAGER CONDUIT W WIRE Voice Communications INTERNET PROTOCOL WAN WIDE AREA NETWORK VoIP Gateway / Analog handsets WAO WORK AREA OUTLET INTERNET SERVICE VoIP handset wall mount kit WAP WIRELESS ACCESS POINT PROVIDER ISP INSIDE PLANT CABLE WP WEATHER PROOF VoIP handsets WR WEATHER RESISTANT JB JUNCTION BOX VoIP Network licensing J-BOX JUNCTION BOX WT WATERTIGHT **Audio-Video Communications** XP EXPLOSION-PROOF Conduits and Backboxes for AV systems Χ Χ **ANNOTATION** Refer to AV drawings for AV Scope **Distributed & Monitoring Communications** TECHNOLOGY PLAN CALLOUT K12 Classroom Analog/IP Paging Х Χ Wireless Clock Systems EQUIPMENT DESIGATION (OWNER FURNISHED, CONTRACTOR INSTALLED) Electronic Safety and Security Conduits and Backboxes for Security systems Χ CONNECTION POINT OF NEW WORK TO EXISTING Refer to Security drawings for Security Scope DETAIL REFERENCE UPPER NUMBER INDICATES DETAIL NUMBER. LOWER NUMBER INDICATES SHEET NUMBER 1 SECTION CUT DESIGNATION LINETYPE LEGEND THROUGHOUT THE DRAWINGS DIFFERENT LINE-TYPES ARE USED IN COMBINATION WITH THE SYMBOLS TO INDICATE THE STATUS OF ITEMS AS EXISTING, TO BE DEMOLISHED, TO BE INCLUDED AS PART OF THE NEW WORK AND/OR ITEMS WHICH ARE ANTICIPATED TO BE PROVIDED IN THE FUTURE. THE STATUS OF ITEMS USING THESE LINETYPES ARE RELATIVE TO THE VIEW IN WHICH THEY APPEAR. PHASING SHOWN IN DRAWINGS IS NOT INTENDED TO FULLY DESCRIBE ALL NECESSARY CONSTRUCTION PHASING, WHICH IS DETERMINED BY THE CONTRACTOR AS PART OF THEIR RESPONSIBILITIES. ANY SUCH PHASES DESCRIBED IN THE CONSTRUCTION DOCUMENTS ARE GENERAL AND ONLY INTENDED TO INDICATE A BROAD ORDER FOR THE SAKE OF DESCRIBING THE PROJECT. THE FOLLOWING LINETYPES MAY BE USED ON ANY DEVICE, EQUIPMENT, NOTE, LINE, SHAPE, ETC. NEW DEMOLISH — — — FUTURE

TELECOMMUNICATIONS OUTLETS

DATA WALL OUTLET

DATA WALL OUTLET

DATA WALL OUTLET - WIRELESS

DESCRIPTION

+12'-0"AFF ACCESS POINT

 ∇ 1D

▽ 2D

CABLE(S)

2 CAT6A

2,4,5/TN5.1

2,4,5/TN5.1

2,4,5/TN5.1

AUDIO-VIDEO IP END-POINT DEVICES

DISPLAY INPUT OUTLET

TEACHER CONNECTION OUTLET

TEACHER CONNECTION OUTLET

REFER TO TA-SERIES DRAWINGS FOR AV DEVICES

TELECOMMUNICATIONS SYMBOLS

STANDARD MOUNTING HEIGHTS

TELEPHONE WALL OUTLET (CENTERLINE)

DATA WALL OUTLET

TELEVISION OUTLET

TMGB/TGB (CENTERLINE)

WALL CLOCK (CENTERLINE)

TELECOM BACKBOARD (BOTTOM OF BACKBOARD)

CABLE TRAY / CONDUIT AFC (BOTTOM OF PATHWAY)

LADDER RACK IN TELECOM ROOMS (BOTTOM OF DEVICE)

LIGHT FIXTURE IN TELECOM ROOMS (BOTTOM OF DEVICE)

THIS IS A MASTER LEGEND AND NOT ALL SYMBOLS OR ABBREVIATIONS ARE USED.

SAME AS ADJACENT DEVICE, UNO

REFER TO ARCH DRAWINGS

PATHWAYS

3"(MIN)

108"(MIN)

WIRE MESH CABLE TRAY - DETAILS 1,3,4/TN5.2

(W"=WIDTH, "H"=HEIGHT)

VERTICAL CABLE TRAY

CONDUIT

UNDERGROUND CONDUIT

("D"=CONDUIT DIAMETER)

("D"=CONDUIT DIAMETER)

<u>TECHNOLOGY PLAN NOTES:</u>

T18 DATA OUTLET FOR LIGHTING CONTROL PANEL. COORDINATE MOUNTING HEIGHT AND EXACT REQUIREMENTS WITH ELECTRICAL CONTRACTOR PRIOR TO ROUGH-IN.


T19 DATA OUTLET FOR BAS PANEL. COORDINATE MOUNTING
HEIGHT AND EXACT REQUIREMENTS WITH PANEL INSTALLER
PRIOR TO ROUGH-IN.

PACKAGE 3 - BUILDING & SITE 10/08/20 REVISIONS

13-20102-00 TECHNOLOGY FIRST LEVEL PLAN - AREA A TN1.1A

KEY PLAN

1 TECHNOLOGY FIRST LEVEL PLAN - AREA A 1/8" = 1'-0"

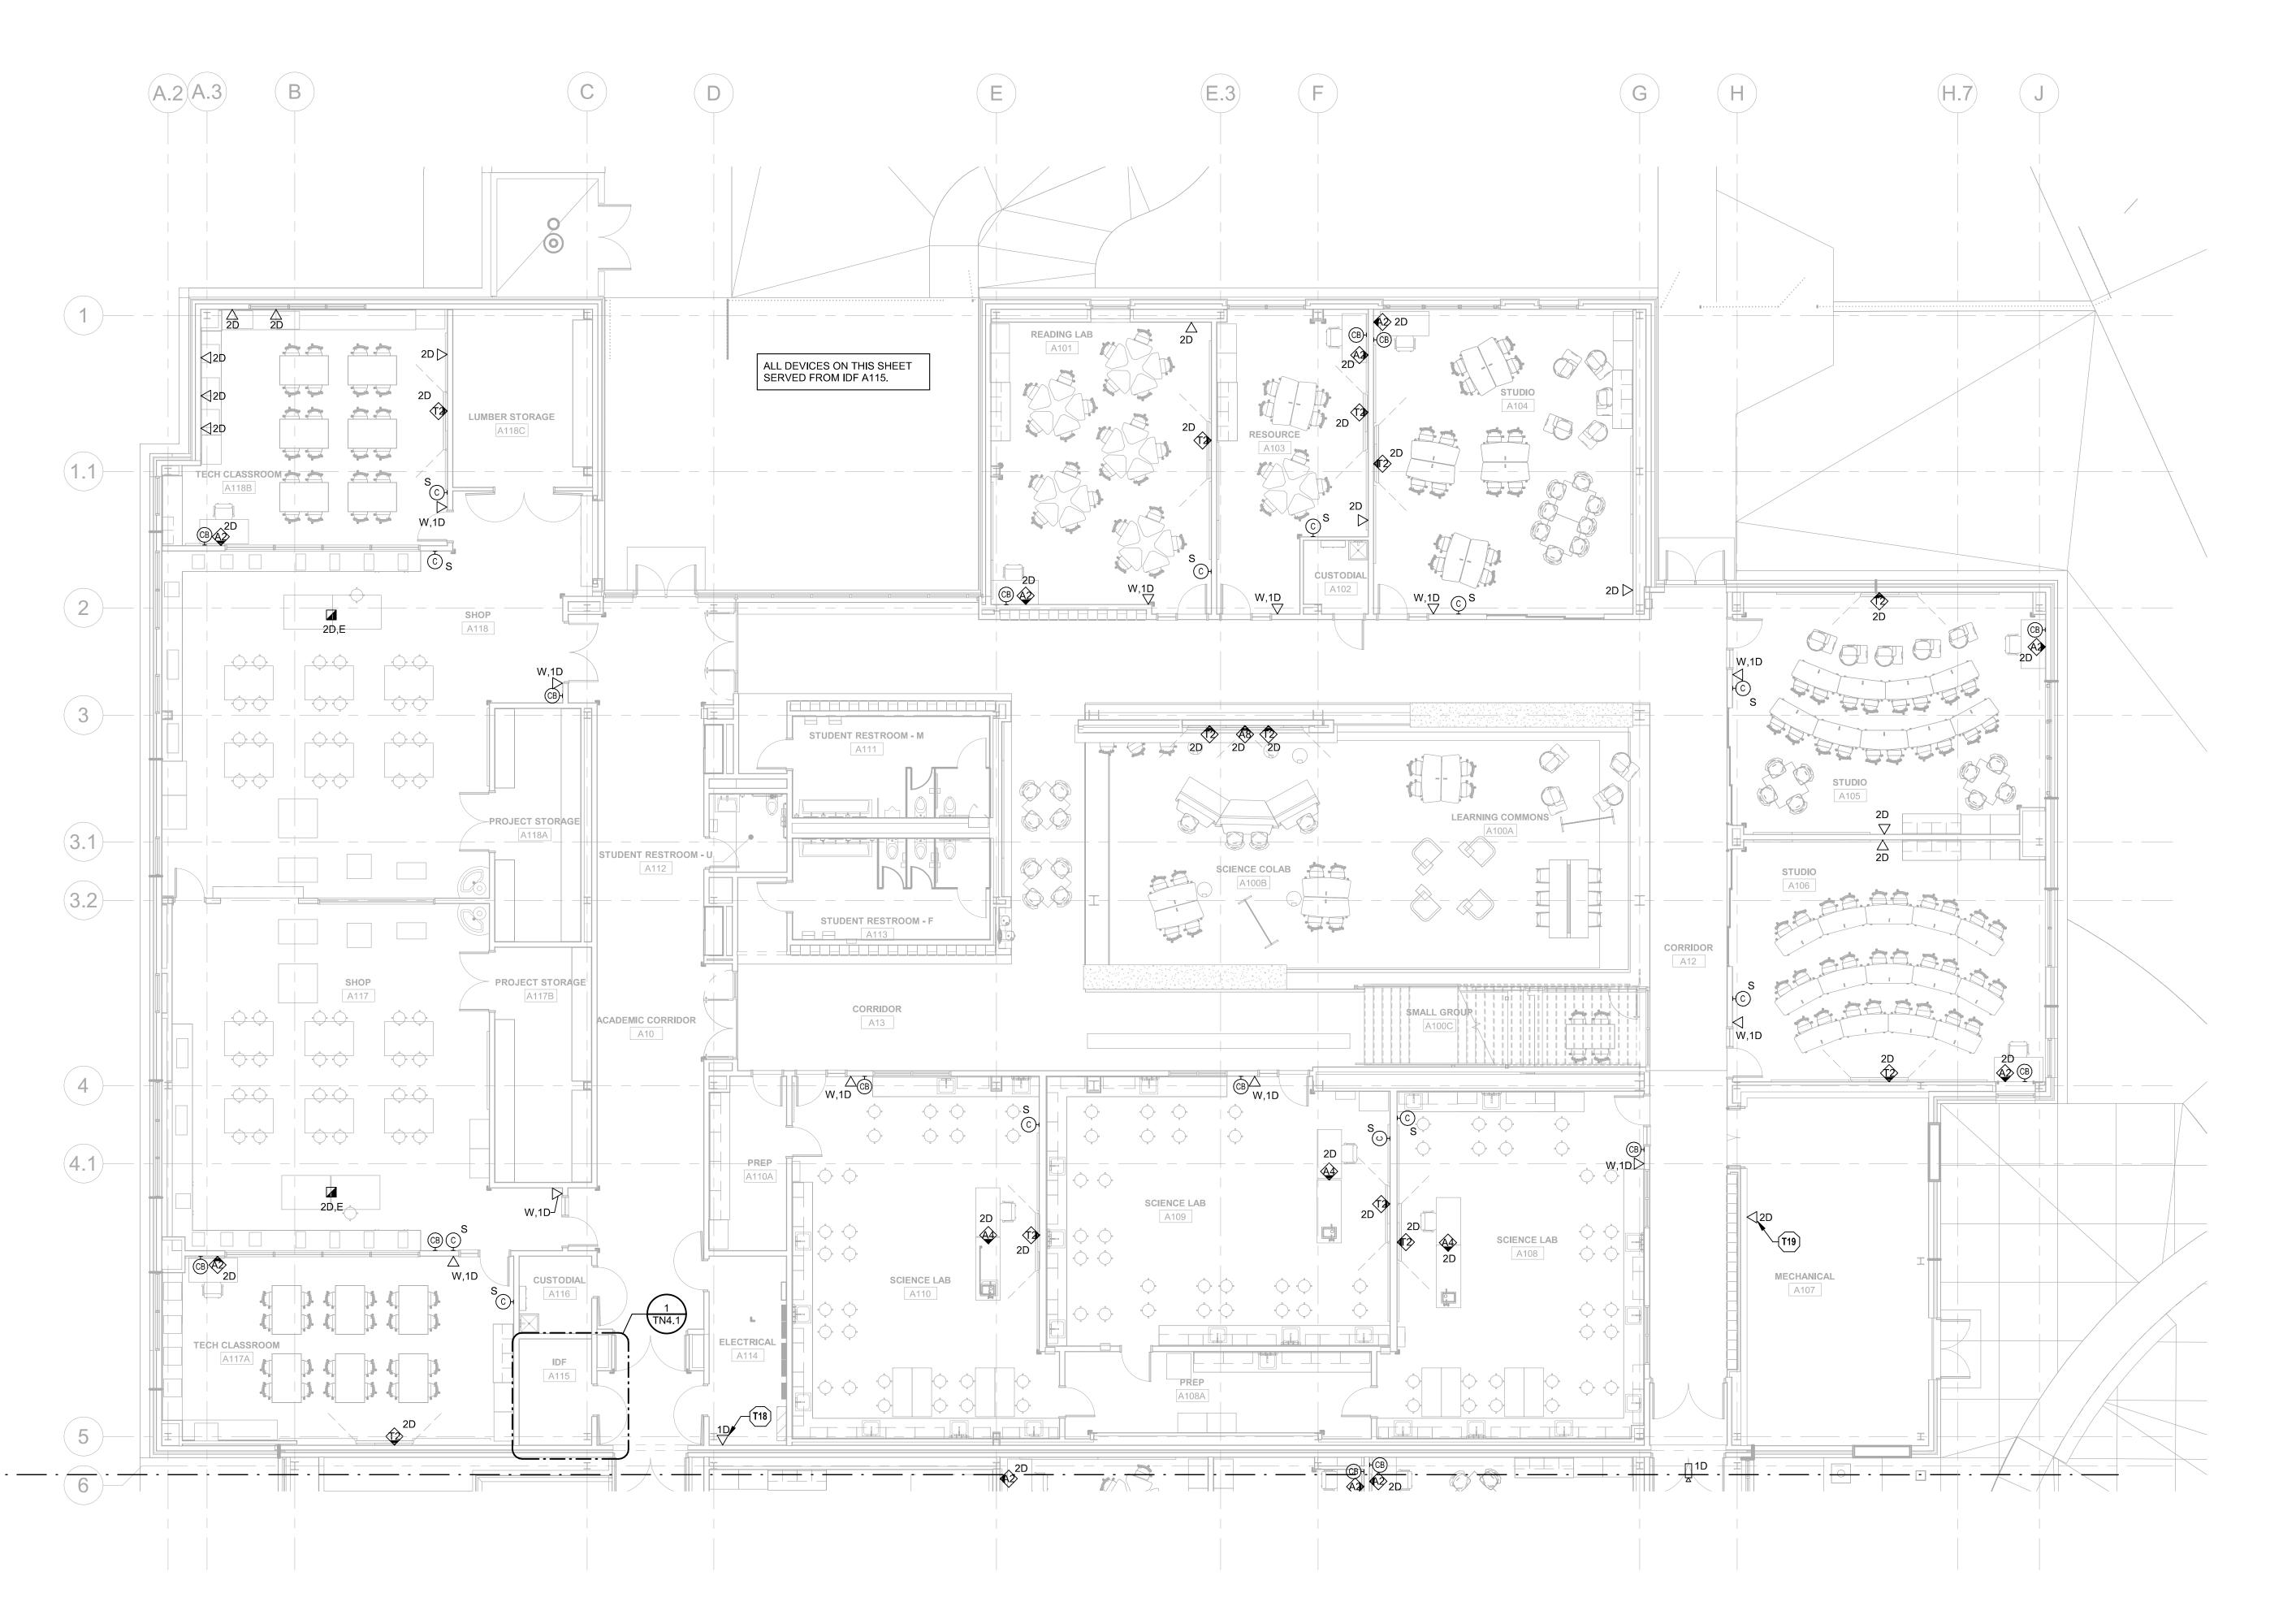


TECHNOLOGY PLAN NOTES:

T18 DATA OUTLET FOR LIGHTING CONTROL PANEL. COORDINATE MOUNTING HEIGHT AND EXACT REQUIREMENTS WITH


T19 DATA OUTLET FOR BAS PANEL. COORDINATE MOUNTING
HEIGHT AND EXACT REQUIREMENTS WITH PANEL INSTALLER
PRIOR TO ROUGH-IN.


ELECTRICAL CONTRACTOR PRIOR TO ROUGH-IN.


PACKAGE 3 - BUILDING & SITE 10/08/20 REVISIONS

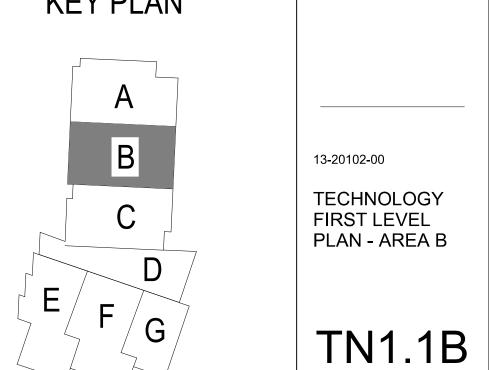

KEY PLAN

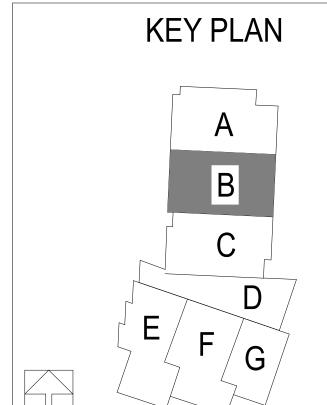

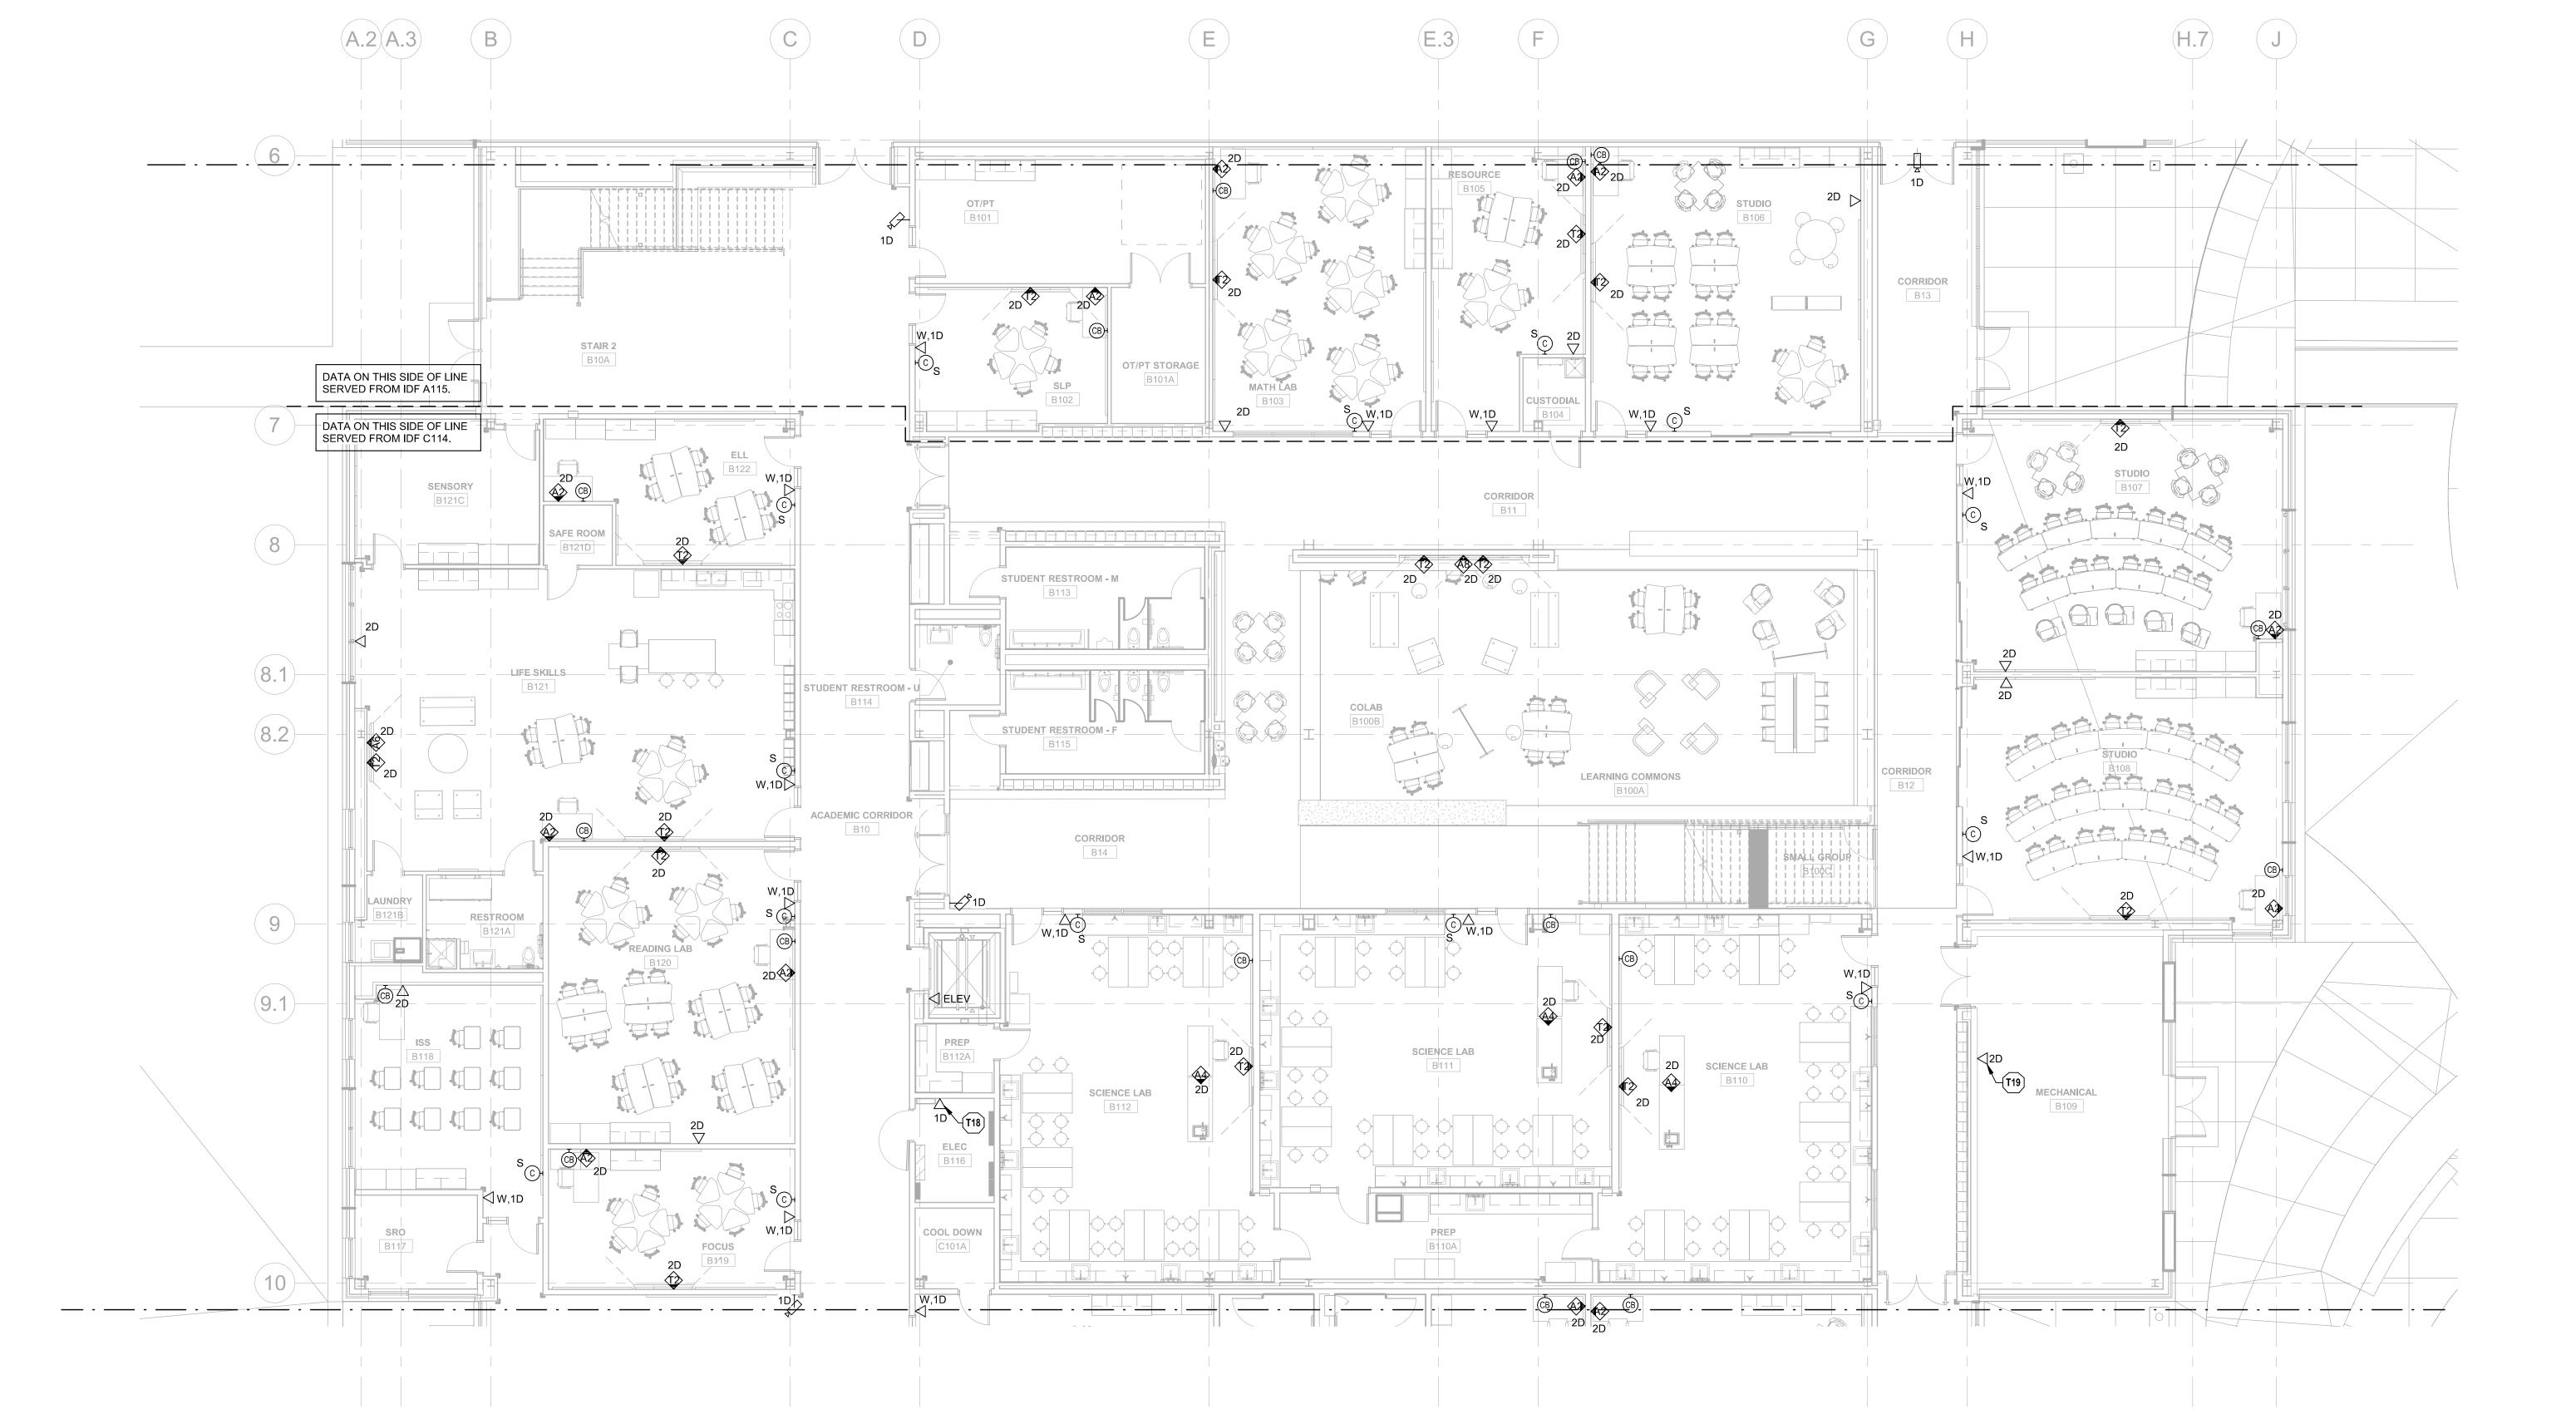

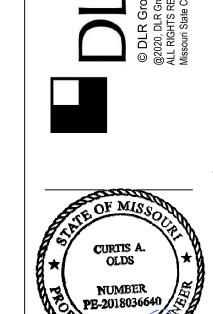

Group

Oct 8 2020 CURTIS A. OLDS LICENSE # PE-2018036640

PACKAGE 3 - BUILDING & SITE

10/08/20 REVISIONS

KEY PLAN 13-20102-00 TECHNOLOGY FIRST LEVEL PLAN - AREA C

TN1.1C

1/8" = 1'-0"

STUDENT RESTROOM - F

STUDENT RESTROOM - M C104

2D MECHANICAL




TECHNOLOGY PLAN NOTES: T18 DATA OUTLET FOR LIGHTING CONTROL PANEL. COORDINATE MOUNTING HEIGHT AND EXACT REQUIREMENTS WITH ELECTRICAL CONTRACTOR PRIOR TO ROUGH-IN. T20 DATA OUTLET FOR AV RACK. COORDINATE MOUNTING HEIGHT AND EXACT REQUIREMENTS WITH AV CONTRACTOR PRIOR TO ROUGH-IN. Oct 8 2020 CURTIS A. OLDS LICENSE # PE-2018036640 DATA ON THIS SIDE OF LINE DATA ON THIS SIDE OF LINE SERVED FROM MDF E120. SERVED FROM IDF G104. **ENTRY CORRIDOR** PACKAGE 3 - BUILDING & SITE 10/08/20 REVISIONS **KEY PLAN** 13-20102-00 TECHNOLOGY FIRST LEVEL PLAN - AREA D



TN1.1D

1 TECHNOLOGY FIRST LEVEL PLAN - AREA E 1/8" = 1'-0"


T18 DATA OUTLET FOR LIGHTING CONTROL PANEL. COORDINATE MOUNTING HEIGHT AND EXACT REQUIREMENTS WITH ELECTRICAL CONTRACTOR PRIOR TO ROUGH-IN. T20 DATA OUTLET FOR AV RACK. COORDINATE MOUNTING HEIGHT AND EXACT REQUIREMENTS WITH AV CONTRACTOR Group

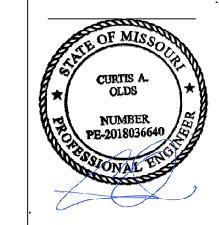

Oct 19 2020 CURTIS A. OLDS LICENSE # PE-2018036640


PACKAGE 3 - BUILDING & SITE 10/08/20 REVISIONS

ADDENDUM 002

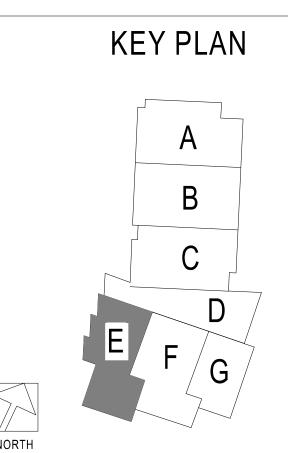


13-20102-00 TECHNOLOGY FIRST LEVEL PLAN - AREA E

TN1.1E

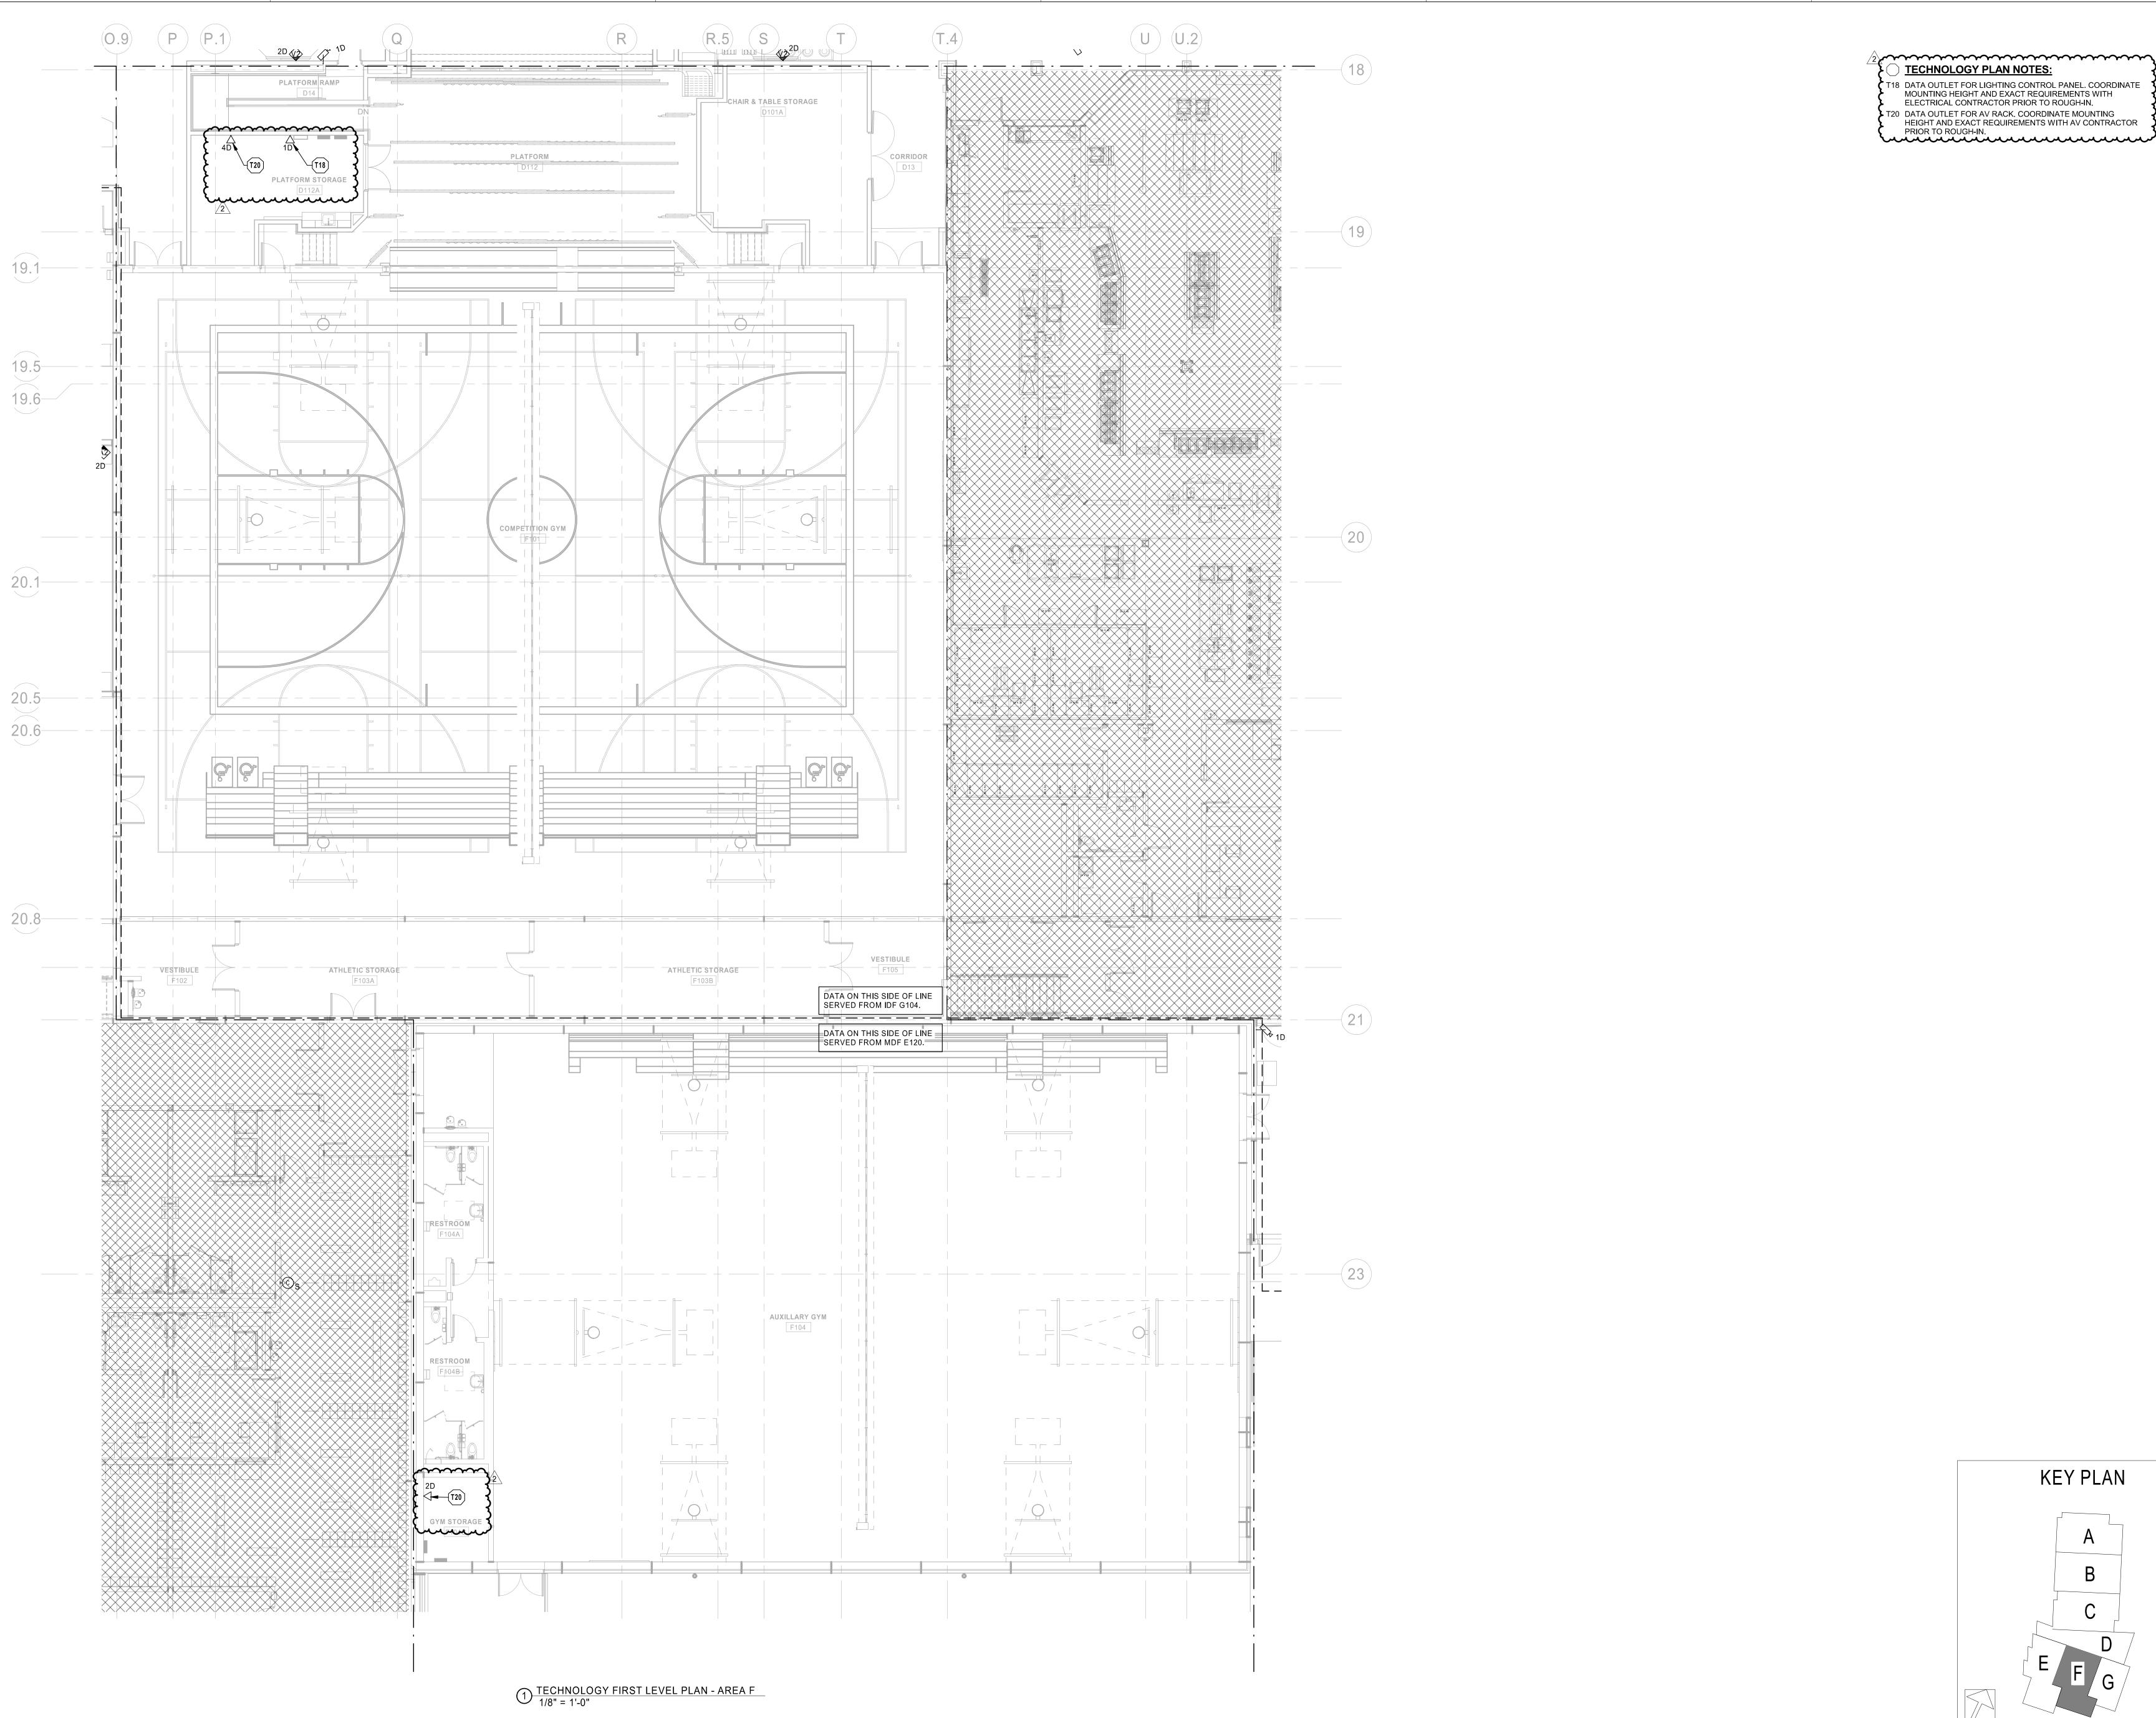

T18 DATA OUTLET FOR LIGHTING CONTROL PANEL. COORDINATE MOUNTING HEIGHT AND EXACT REQUIREMENTS WITH ELECTRICAL CONTRACTOR PRIOR TO ROUGH-IN.


Group

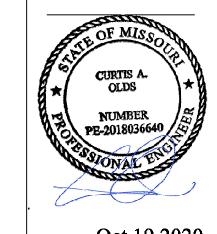

Oct 19 2020 CURTIS A. OLDS LICENSE # PE-2018036640

8345

PACKAGE 3 - BUILDING & SITE 10/08/20 REVISIONS ADDENDUM 002

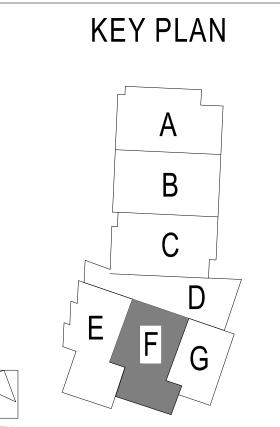

13-20102-00 TECHNOLOGY FIRST LEVEL PLAN - AREA F

TN1.1F

TECHNOLOGY PLAN NOTES:

STAFF DINING

MECHANICAL

CHILLER YARD

MAIN ELEC

TRANSFORMER YARD

W

1 TECHNOLOGY FIRST LEVEL PLAN - AREA G

DATA ON THIS SIDE OF LINE SERVED FROM IDF G104.

DATA ON THIS SIDE OF LINE SERVED FROM MDF E120.

BUILDING STORAGE

SERVERY

OFFICE

CORRIDOR

VESTIBULE

RESTROOM

U U.2

BUILDING STORAGE G112

CORRIDOR


19.6


20.1

20.9

(19)

T18 DATA OUTLET FOR LIGHTING CONTROL PANEL. COORDINATE MOUNTING HEIGHT AND EXACT REQUIREMENTS WITH ELECTRICAL CONTRACTOR PRIOR TO ROUGH-IN.

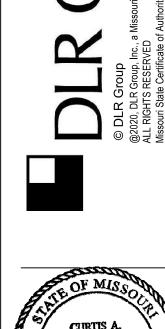

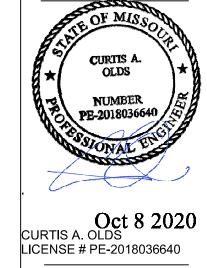

8345 [


PACKAGE 3 - BUILDING & SITE

10/08/20 REVISIONS

13-20102-00

TECHNOLOGY FIRST LEVEL PLAN - AREA G

TN1.1G

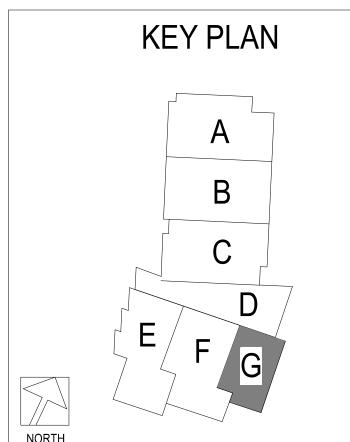

TECHNOLOGY PLAN NOTES:

ADDITIONAL INFORMATION.

T2 PROVIDE TELECOMMUNICATIONS GROUNDING BUS BAR (TGB) MOUNTED AT 7'-0"AFF. SEE DIVISION 27 SPECIFICATIONS FOR ADDITIONAL INFORMATION.


T4 PROVIDE 4'X4' SHEET OF GRADE A/C 3/4" FIRE RATED PLYWOOD BACKBOARD (UNPAINTED) BEHIND RACK. THE A SIDE SHALL BE EXPOSED TO THE INTERIOR OF THE ROOM

AND THE C SIDE PLACED AGAINST THE BUILDING STRUCTURE. SEE DIVISION 27 SPECIFICATIONS FOR


T17 DATA OUTLET FOR SECURITY PANEL. COORDINATE MOUNTING HEIGHT AND EXACT REQUIREMENTS WITH SECURITY CONTRACTOR PRIOR TO ROUGH-IN.

T18 DATA OUTLET FOR LIGHTING CONTROL PANEL. COORDINATE MOUNTING HEIGHT AND EXACT REQUIREMENTS WITH ELECTRICAL CONTRACTOR PRIOR TO ROUGH-IN. T22 FIXED WALL RACK TO SERVE FIELDS. PROVIDE OPTICAL FIBER PANEL AND PATCH PANELS AS REQUIRED TO SUPPORT DATA OUTLETS PER DIVISION 27 SPECIFICATIONS.

TN1.1S

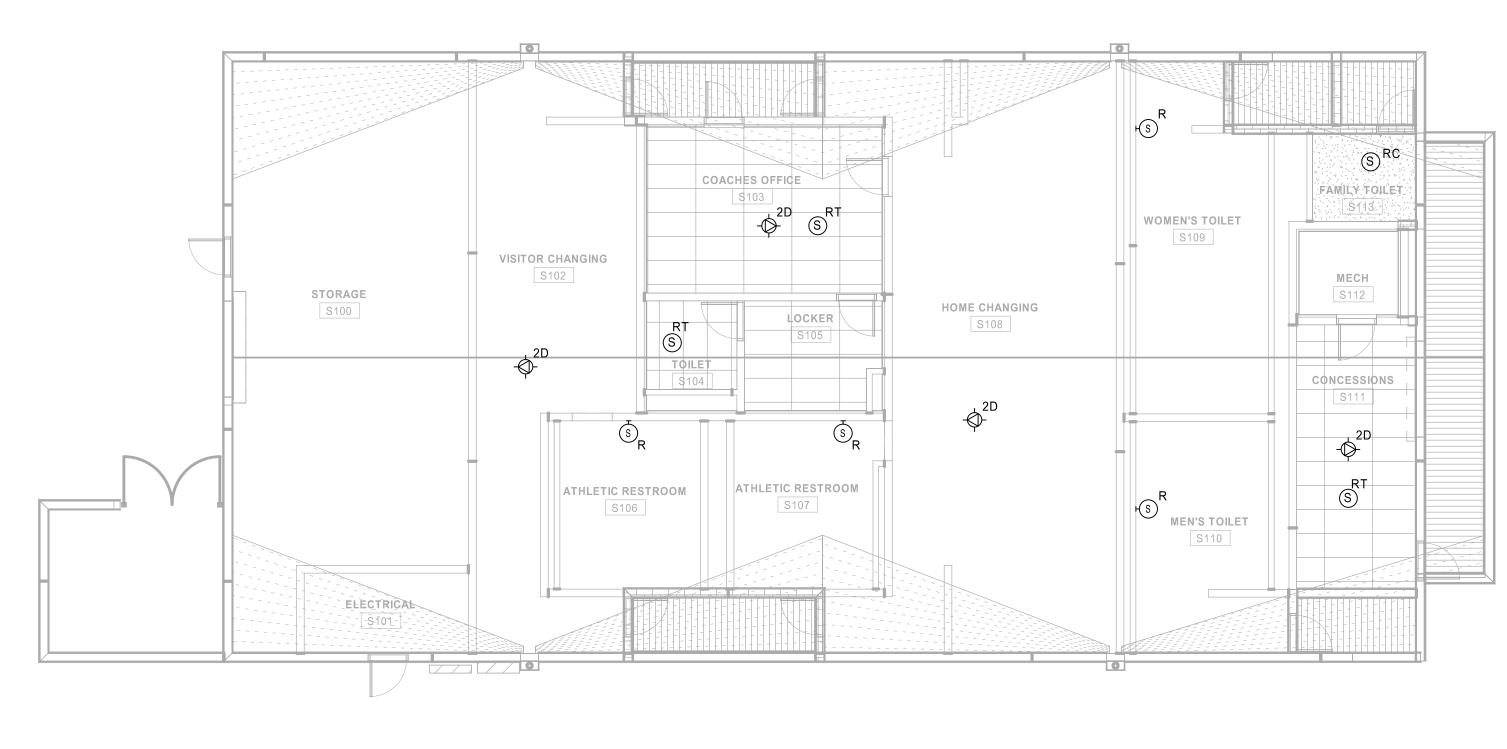

2 TECHNOLOGY FIRST LEVEL RCP - AREA S 1/8" = 1'-0"

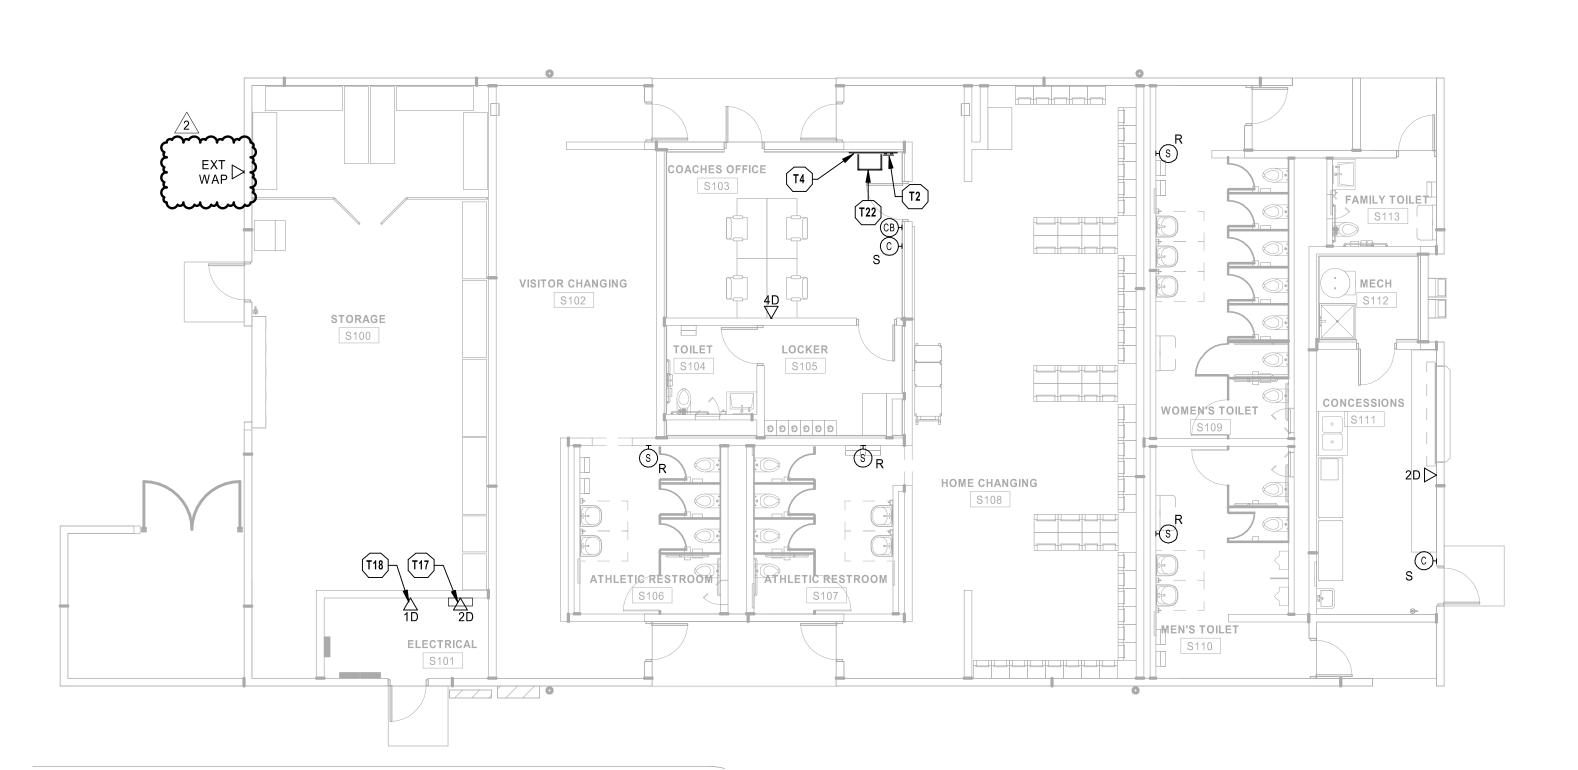

1 TECHNOLOGY FIRST LEVEL PLAN - AREA S
1/8" = 1'-0"

LEE'S SUMMIT R-7 SCHOOL DISTRICT

PACKAGE 3 - BUILDING & SITE

10/08/20 REVISIONS


13-20102-00

TECHNOLOGY


SECOND LEVEL PLAN - AREA A

TN1.2A

KEY PLAN

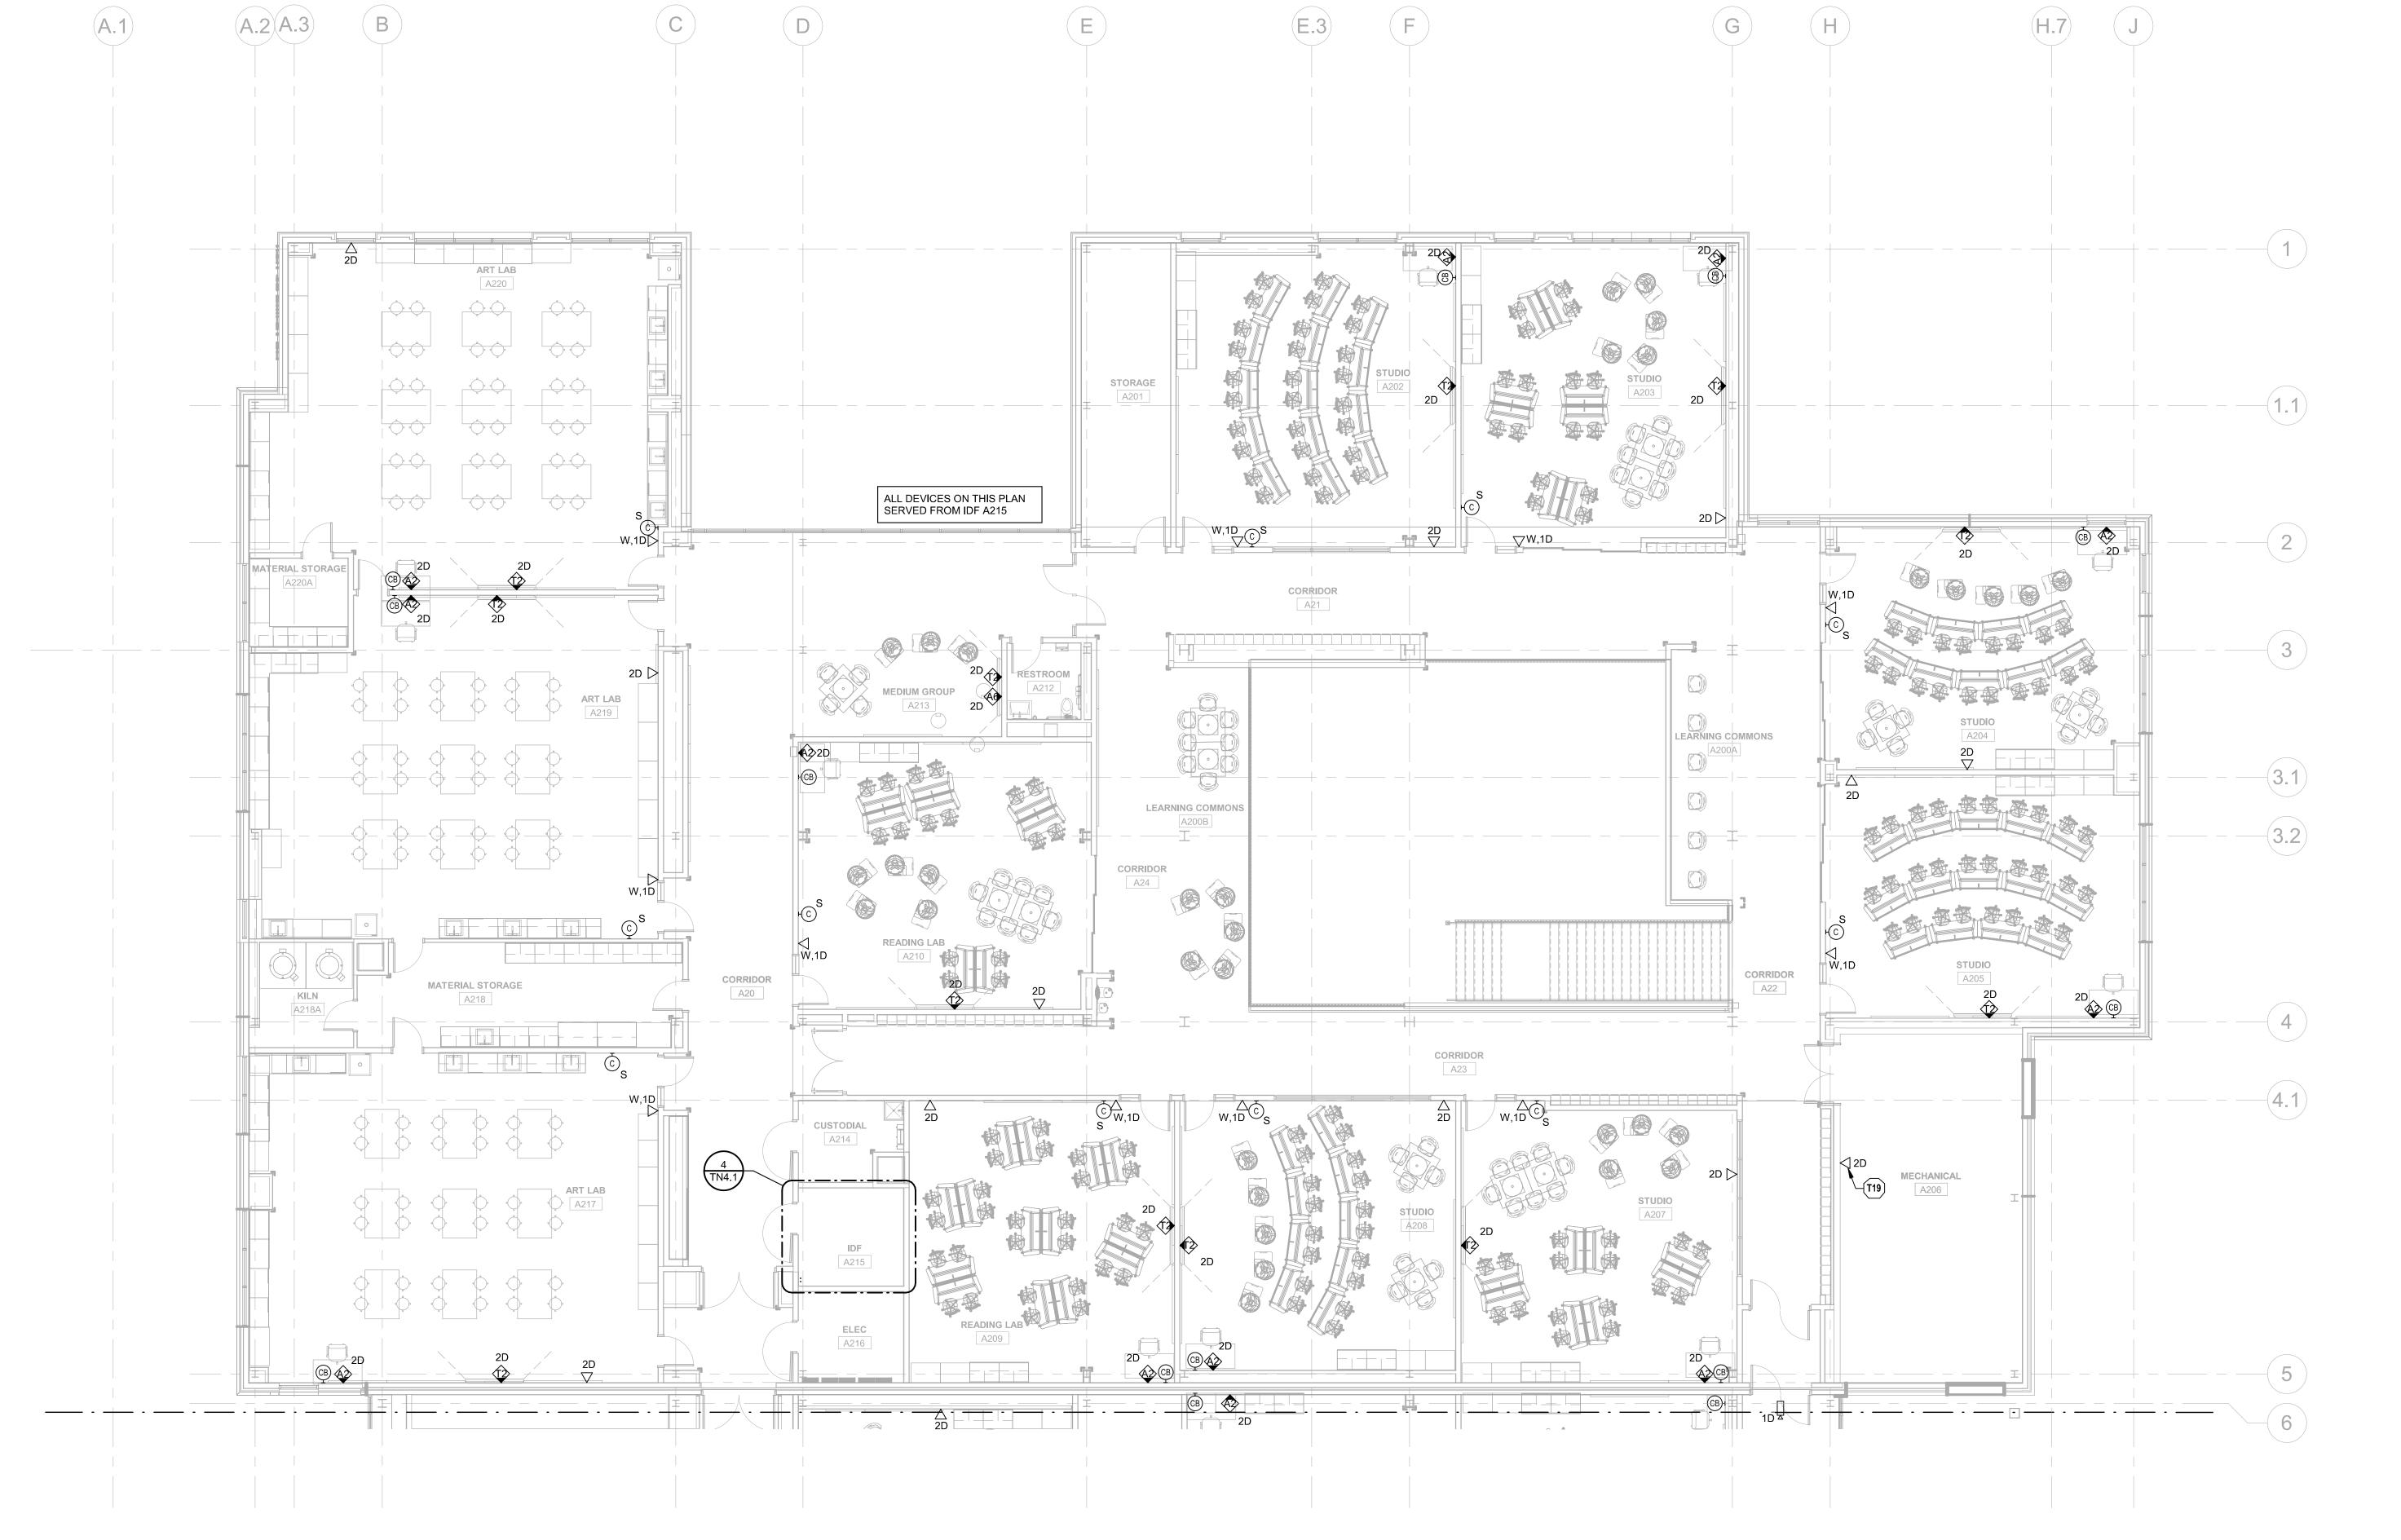

Group

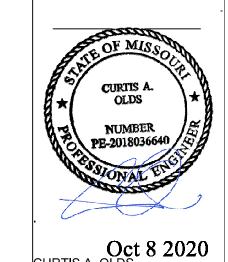

Oct 8 2020 CURTIS A. OLDS LICENSE # PE-2018036640

PACKAGE 3 - BUILDING & SITE 10/08/20 REVISIONS


13-20102-00

TECHNOLOGY

SECOND LEVEL PLAN - AREA B


TN1.2B

KEY PLAN Α

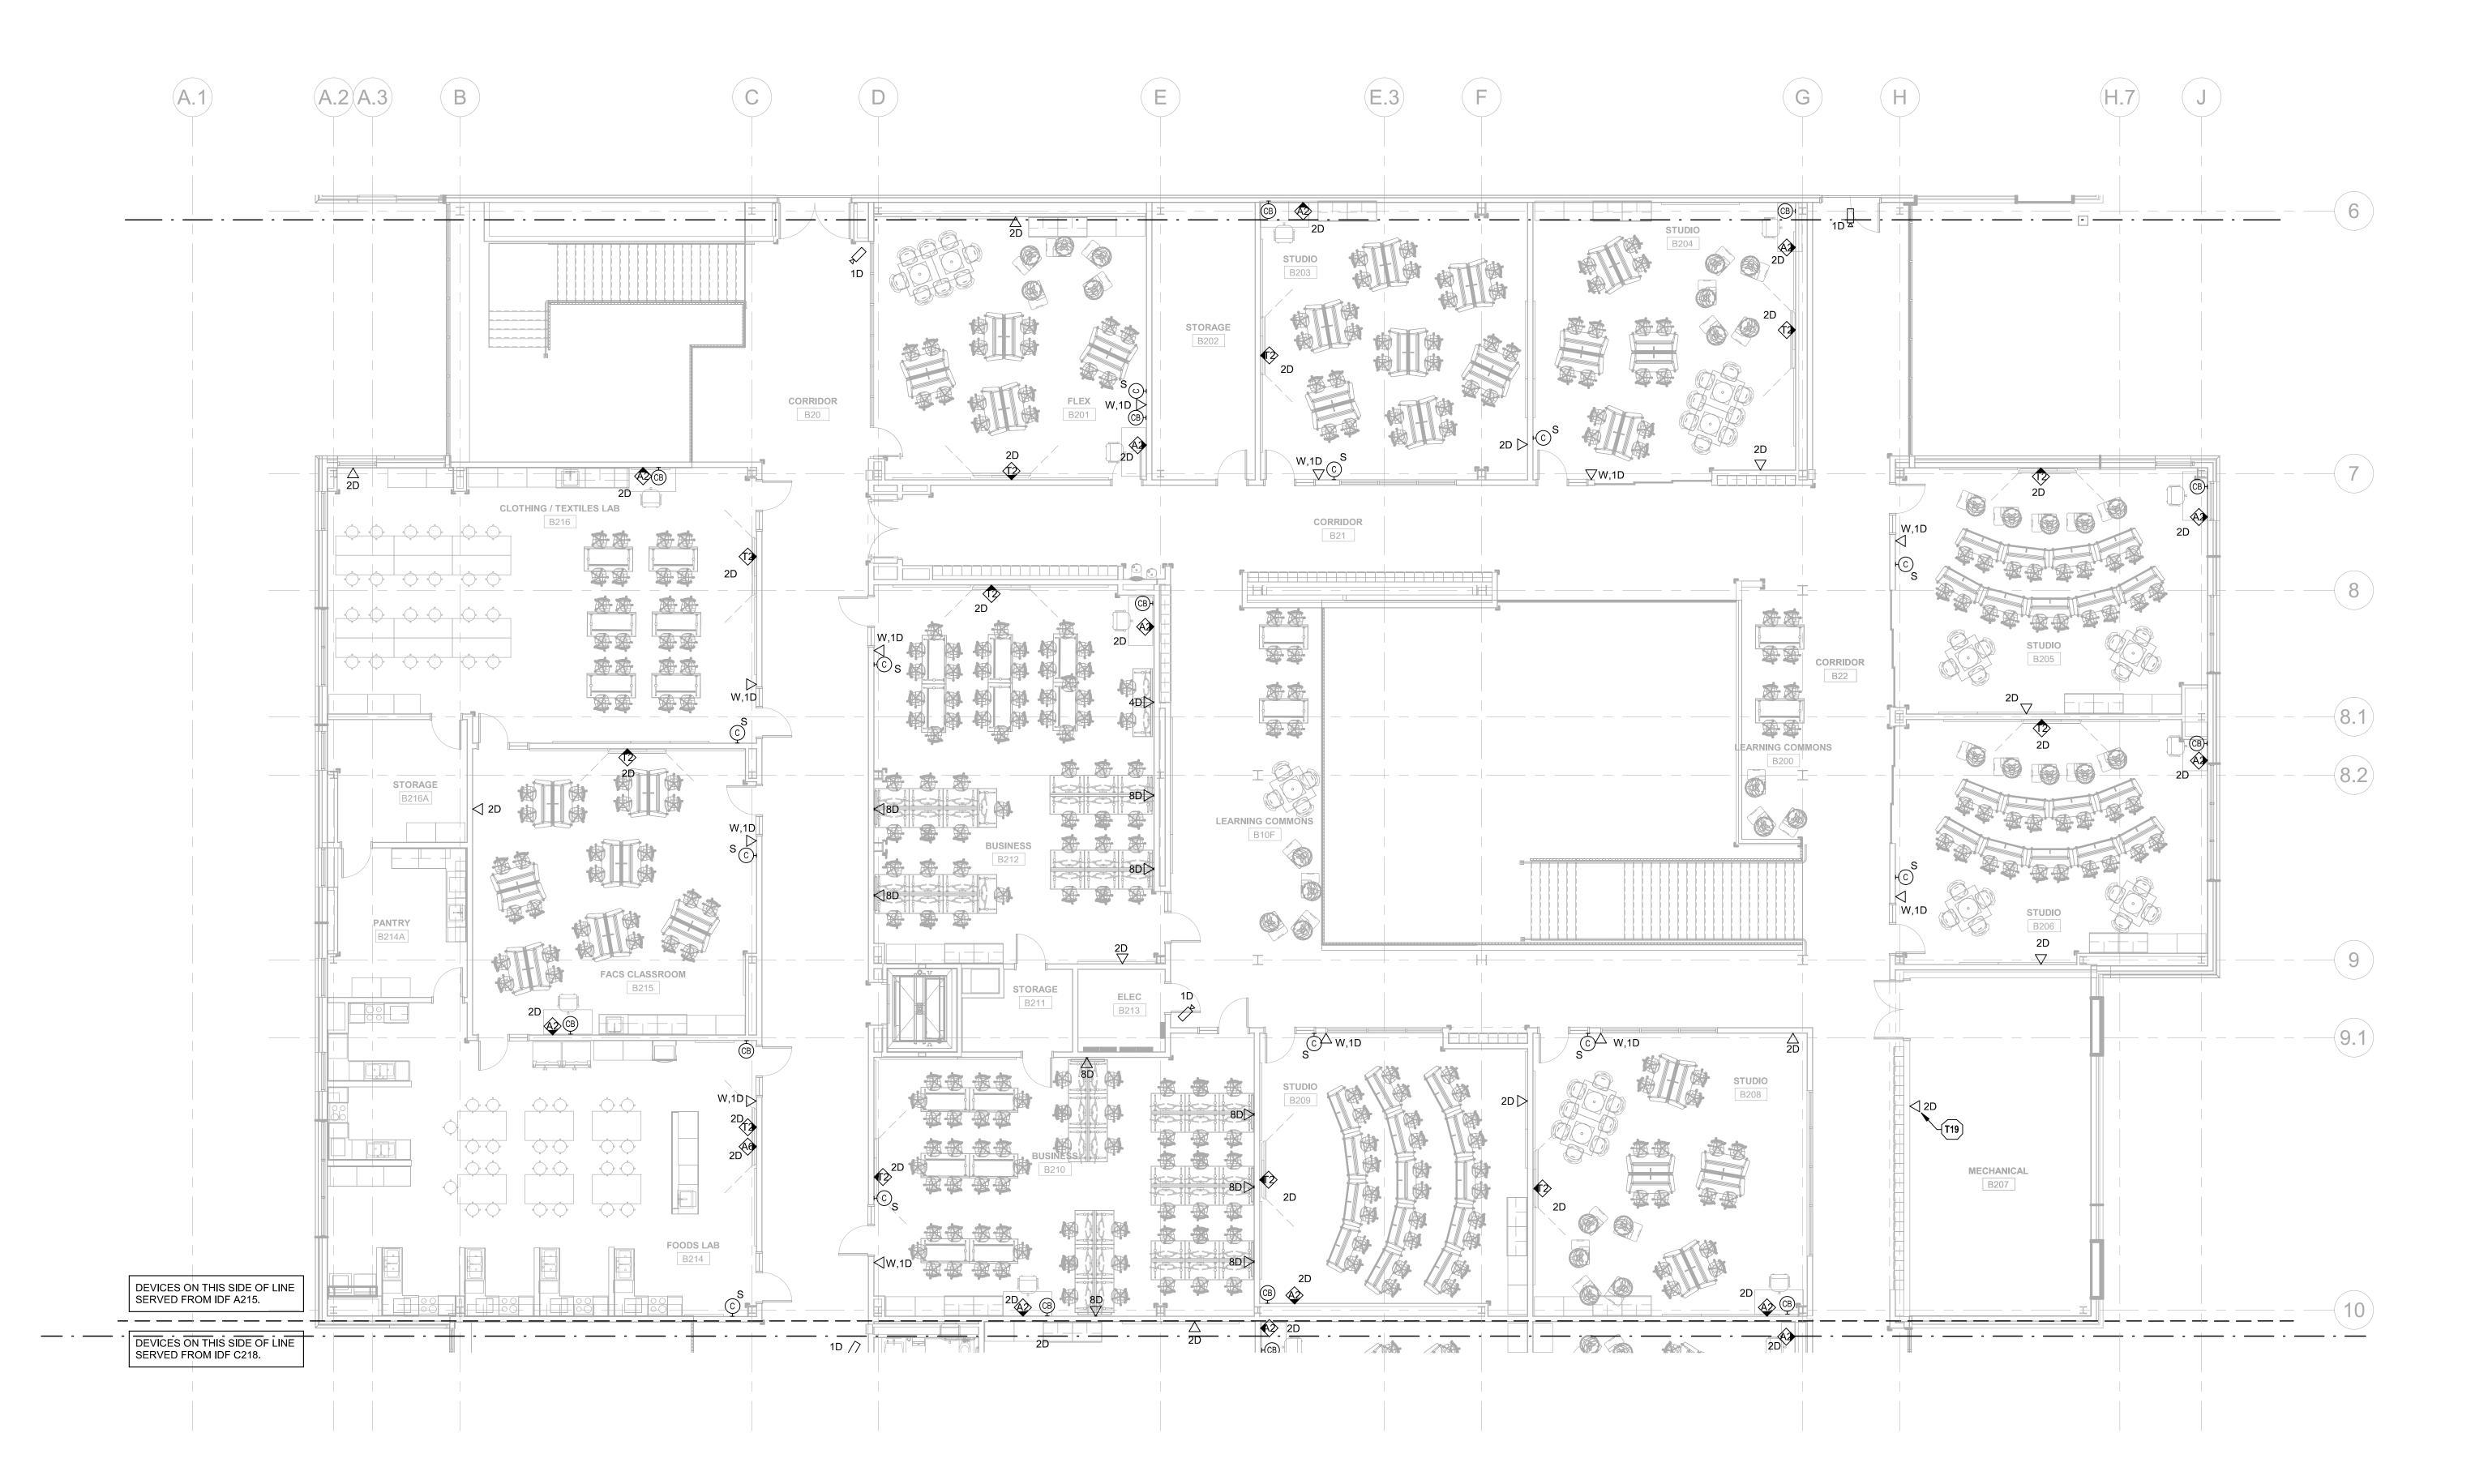

1 TECHNOLOGY SECOND LEVEL PLAN - AREA B 1/8" = 1'-0"

Group

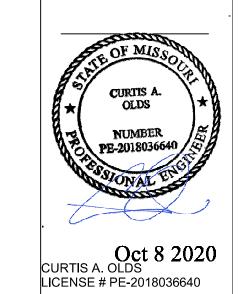

PACKAGE 3 - BUILDING & SITE 10/08/20 REVISIONS


13-20102-00

TECHNOLOGY

SECOND LEVEL PLAN - AREA C

TN1.2C


KEY PLAN

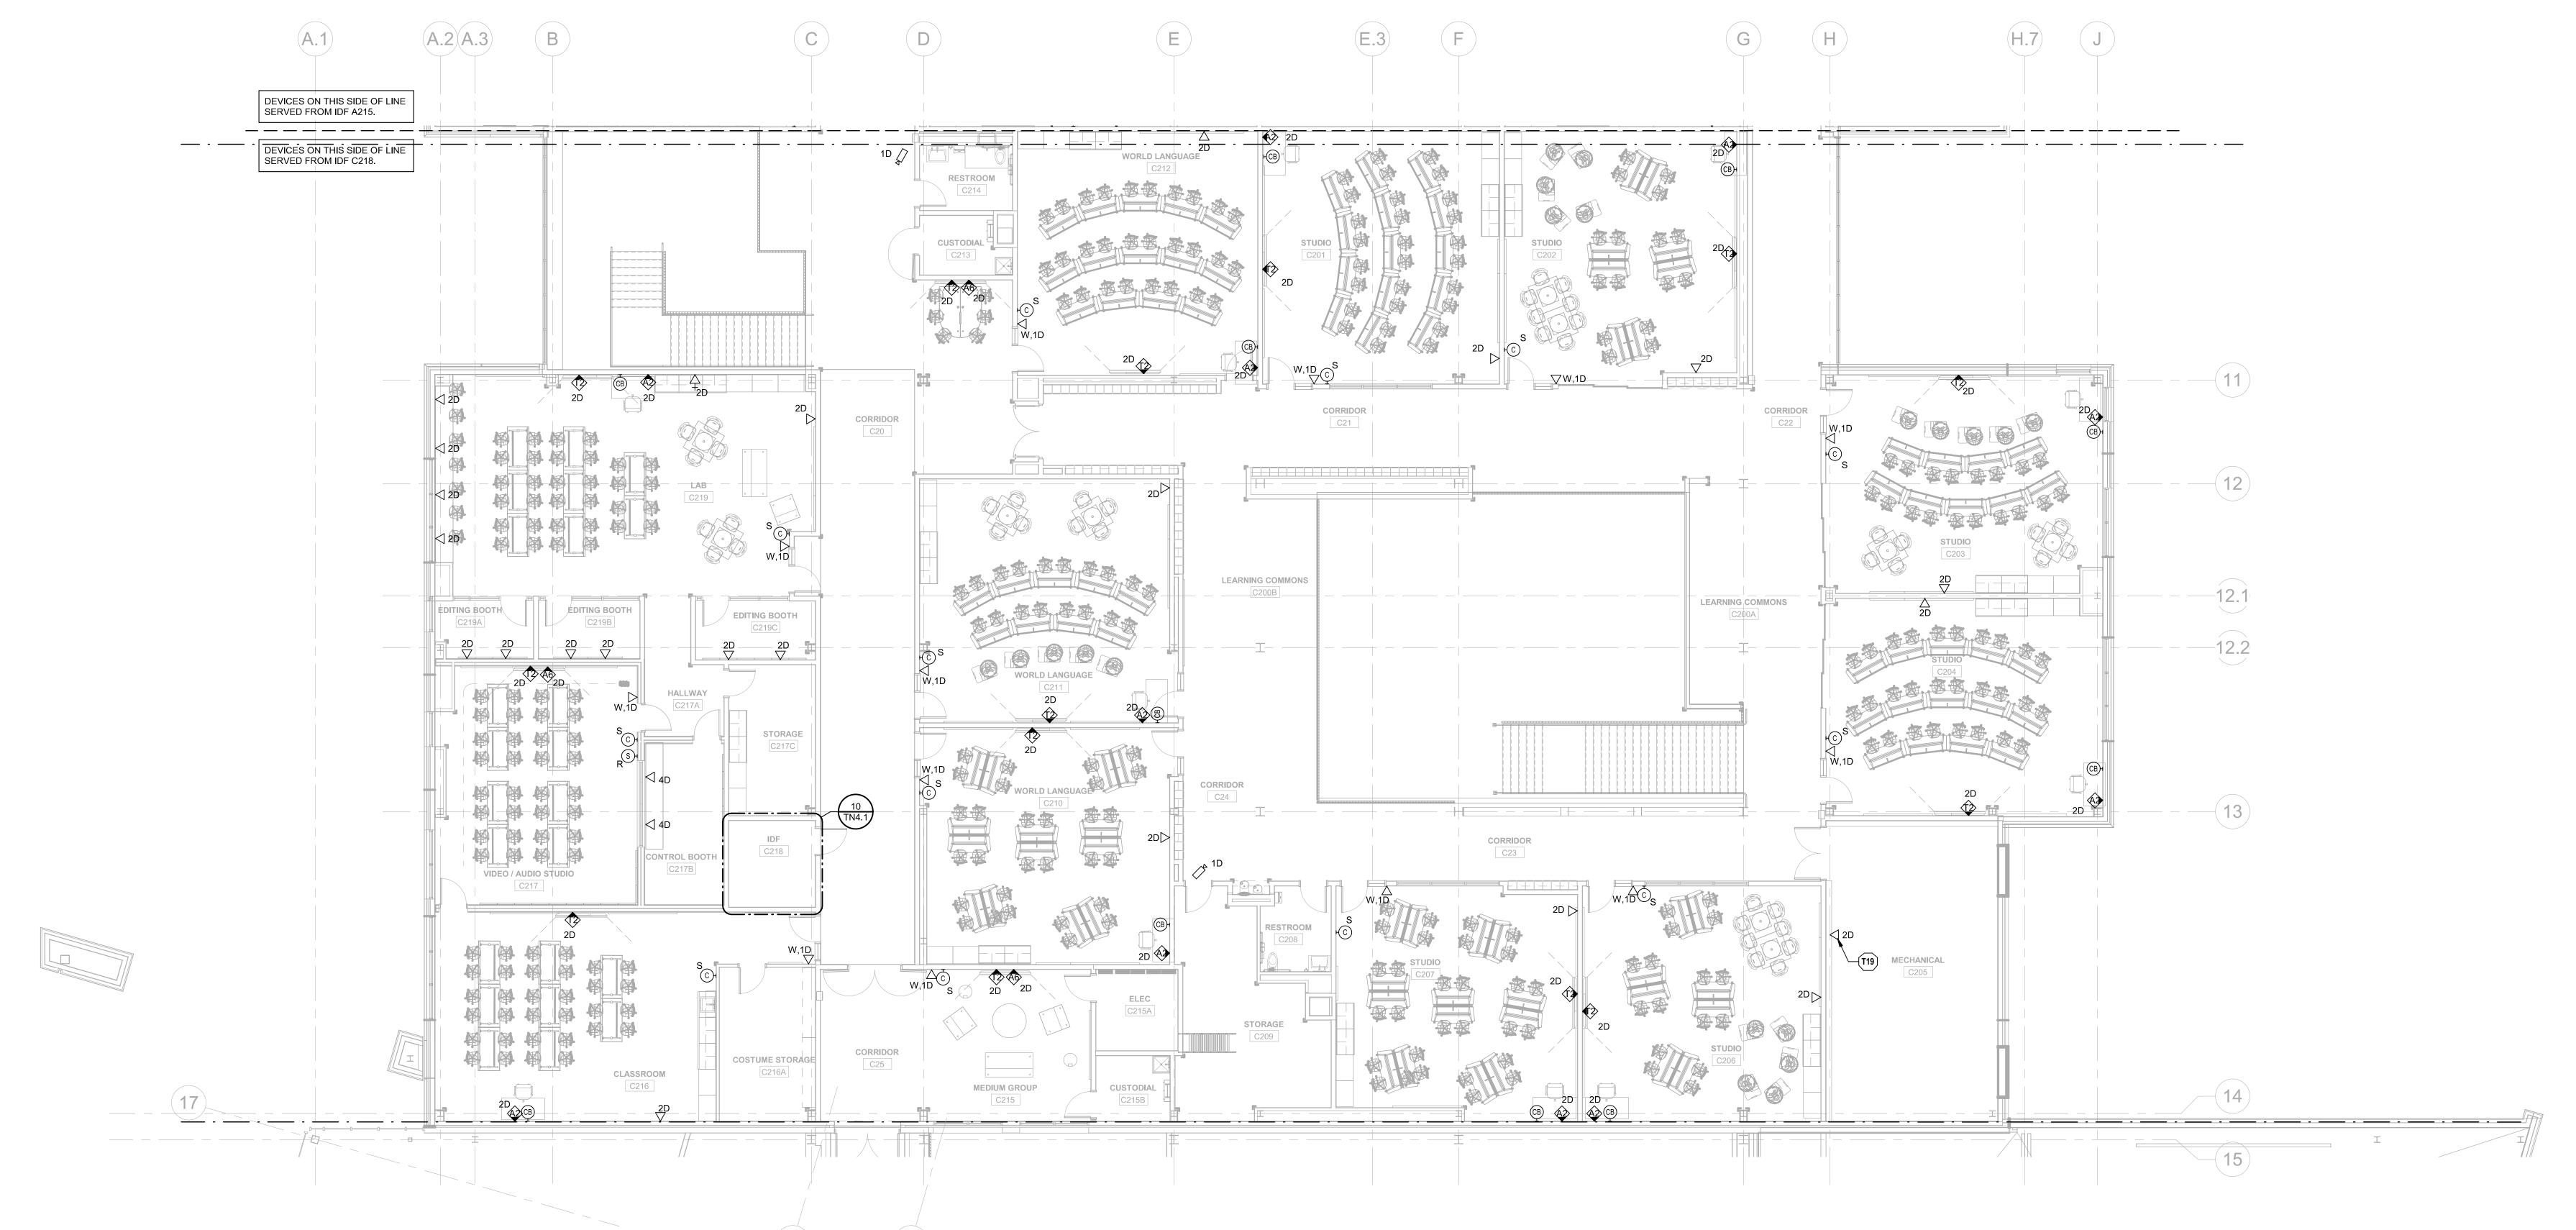

TECHNOLOGY PLAN NOTES:

T19 DATA OUTLET FOR BAS PANEL. COORDINATE MOUNTING
HEIGHT AND EXACT REQUIREMENTS WITH PANEL INSTALLER
PRIOR TO ROUGH-IN.

© DLR Group
@2020, DLR Group, Inc., a Missouri corporation,
ALK REBERVED
Missouri State Certificate of Aurthority #000939

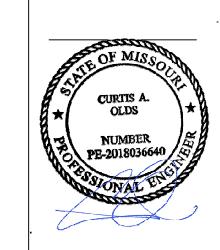

Oct 8 2020
CURTIS A. OLDS
LICENSE # PE-2018036640

ENGINEERS
8345 LENEXA DRIVE, SUITE 300
LENEXA, KS 66214
TEL 913.742.5000 FAX 913.742.5001

WWW.HENDERSONENGINEERS.COM
1950005054
MO. CORPORATE NO: E-556D
EXPIRES 12/31/2020

S SUMMIT R-7 SCHOOL DISTRICT

PACKAGE 3 - BUILDING & SITE
10/08/20
REVISIONS


KEY PLAN

A
B
C
C
F
G

13-20102-00

TECHNOLOGY
SECOND LEVEL
PLAN - AREA E

TN1.2E

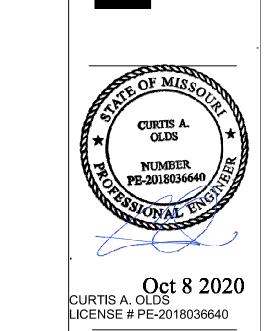

ENGINEERS
8345 LENEXA, RS 66214
TEL 913.742.5000 FAX 913.742.5001

WWW.HENDERSONENGINEERS.COM
1950005054
MO. CORPORATE NO: E-556D
EXPIRES 12/31/2020

S SOMMINI MIDDLE SCHOOL #4

PACKAGE 3 - BUILDING & SITE
10/08/20
REVISIONS

KEY PLAN


A


B

13-20102-00


TECHNOLOGY
SECOND LEVEL
PLAN - AREA F

TN1.2F

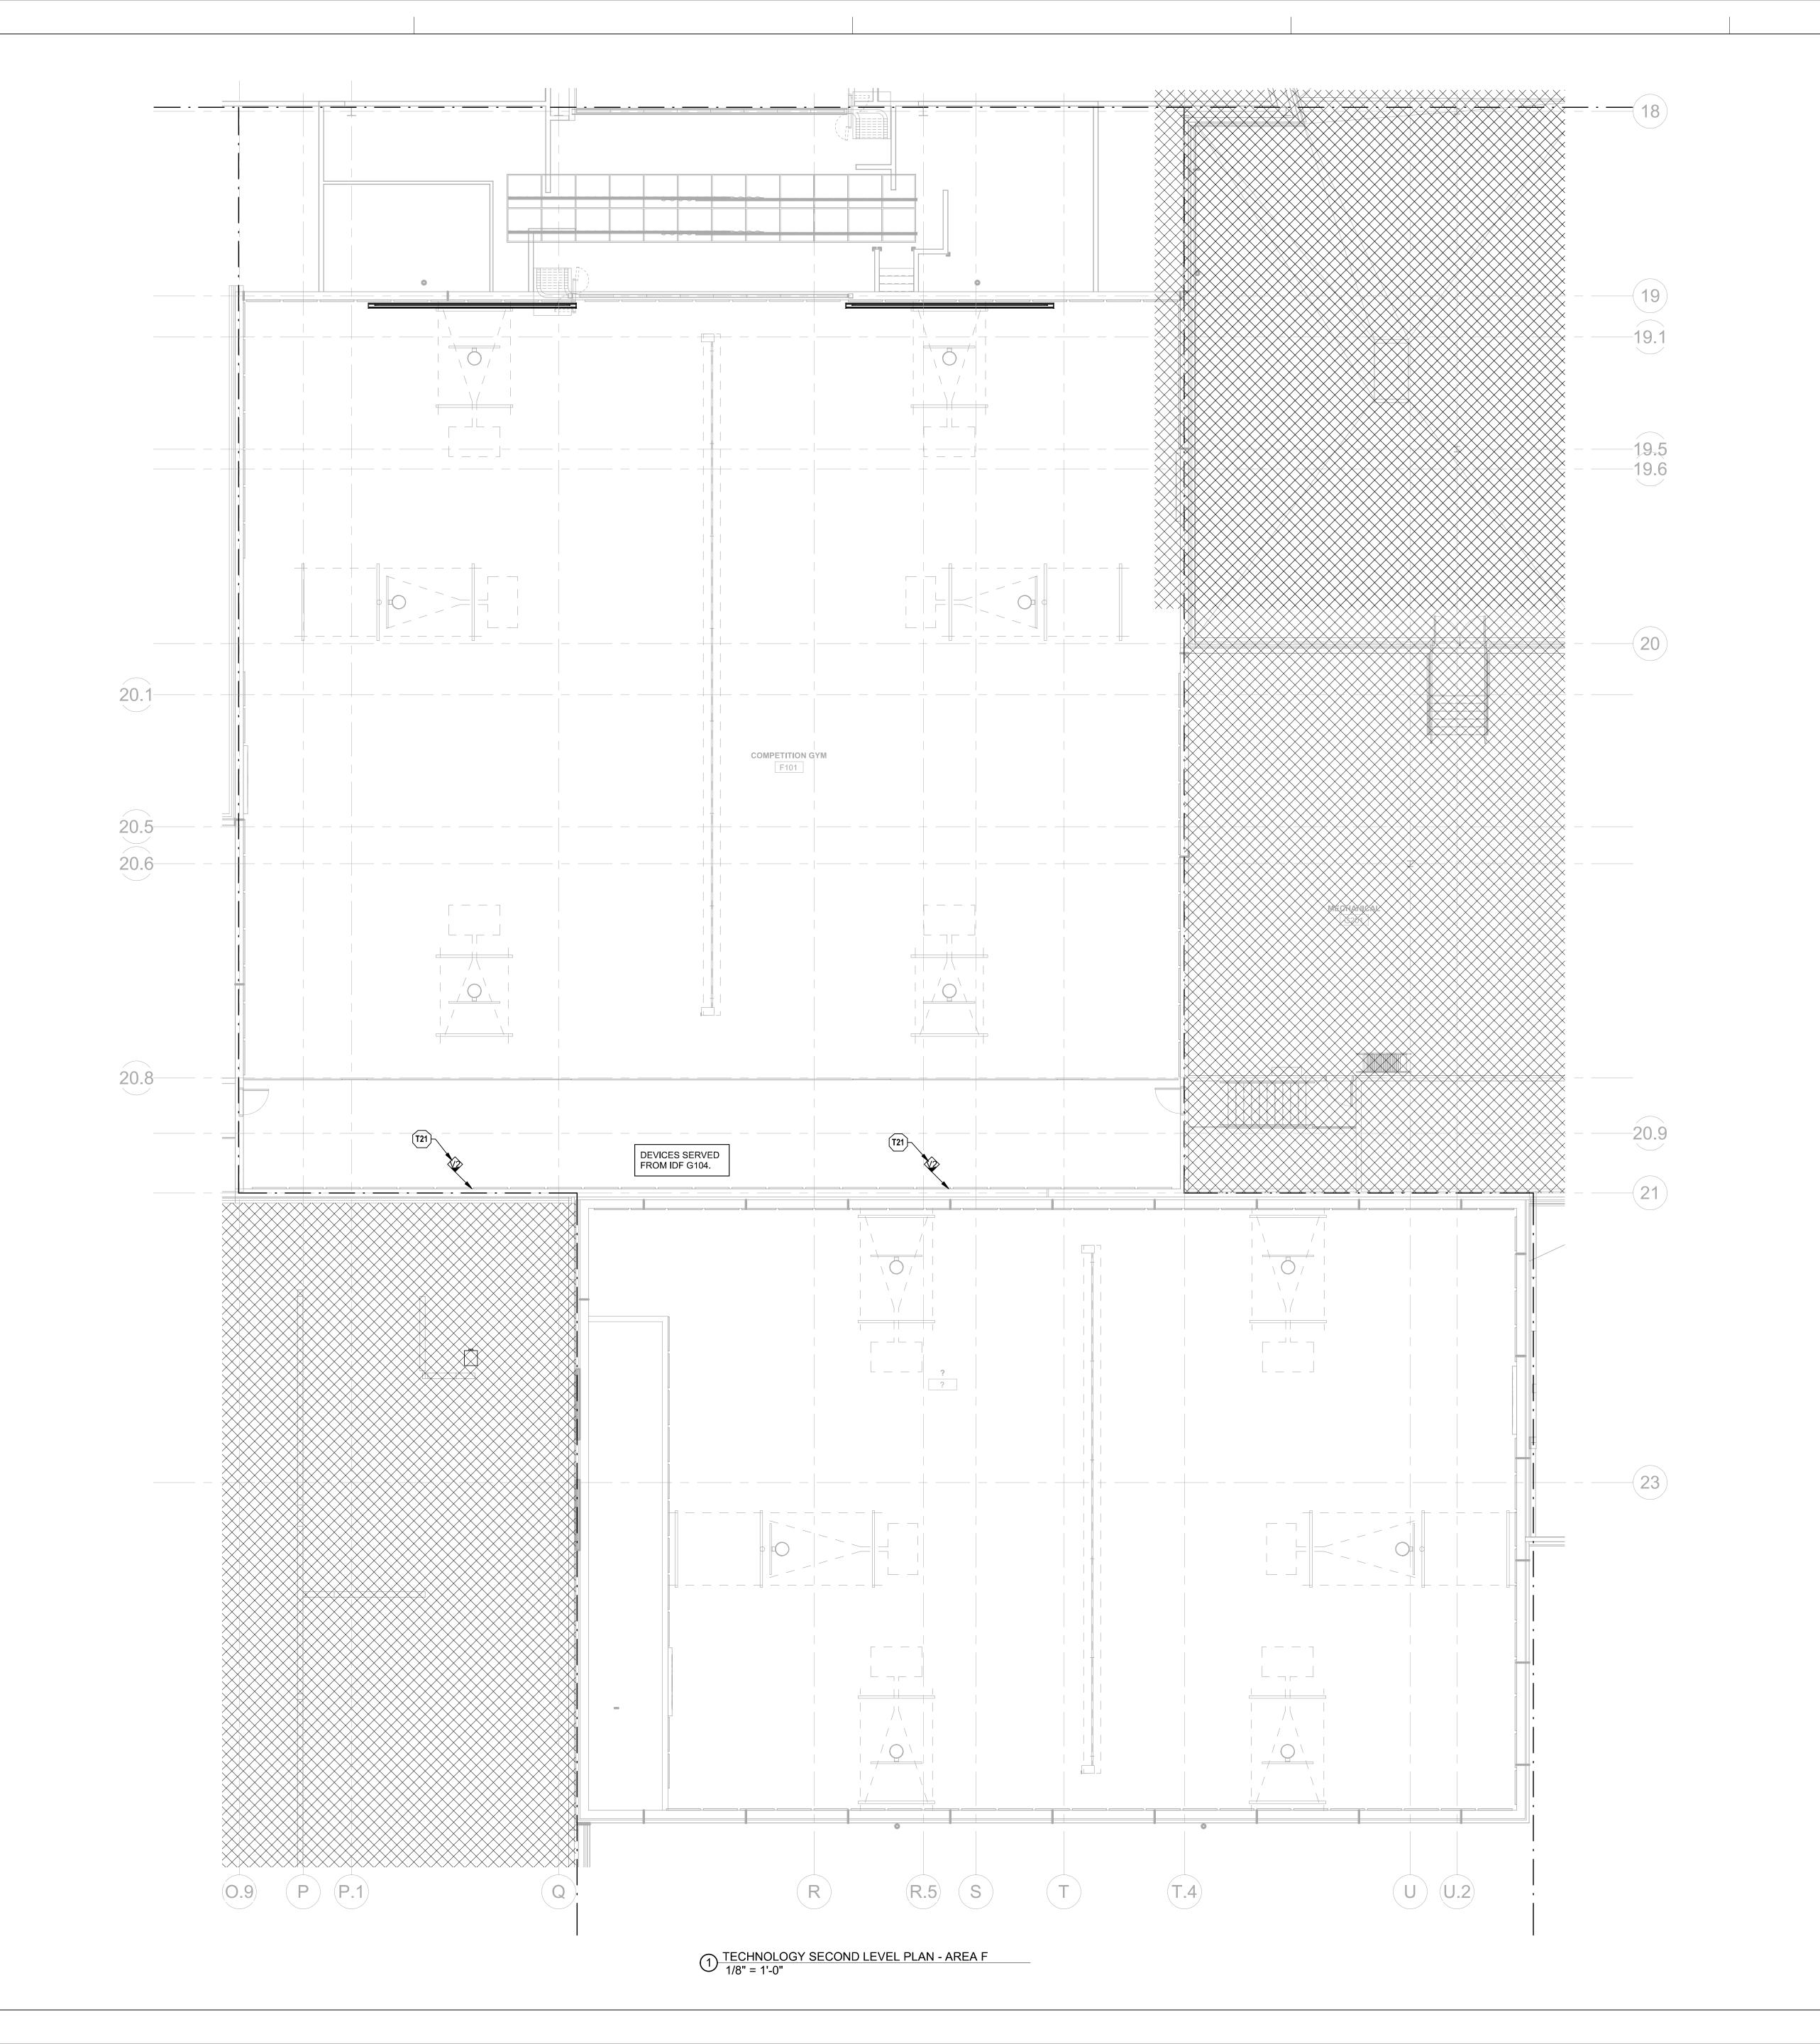

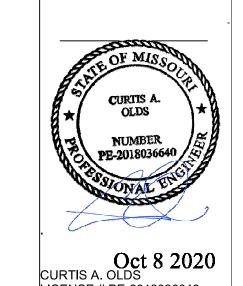

PACKAGE 3 - BUILDING & SITE REVISIONS

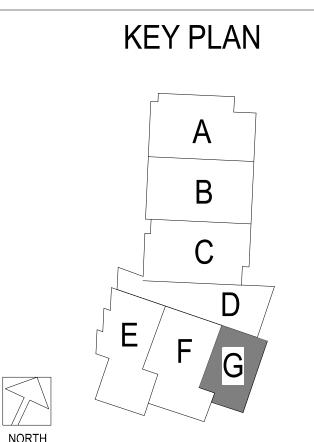


TN1.2G

13-20102-00

TECHNOLOGY


SECOND LEVEL PLAN - AREA G

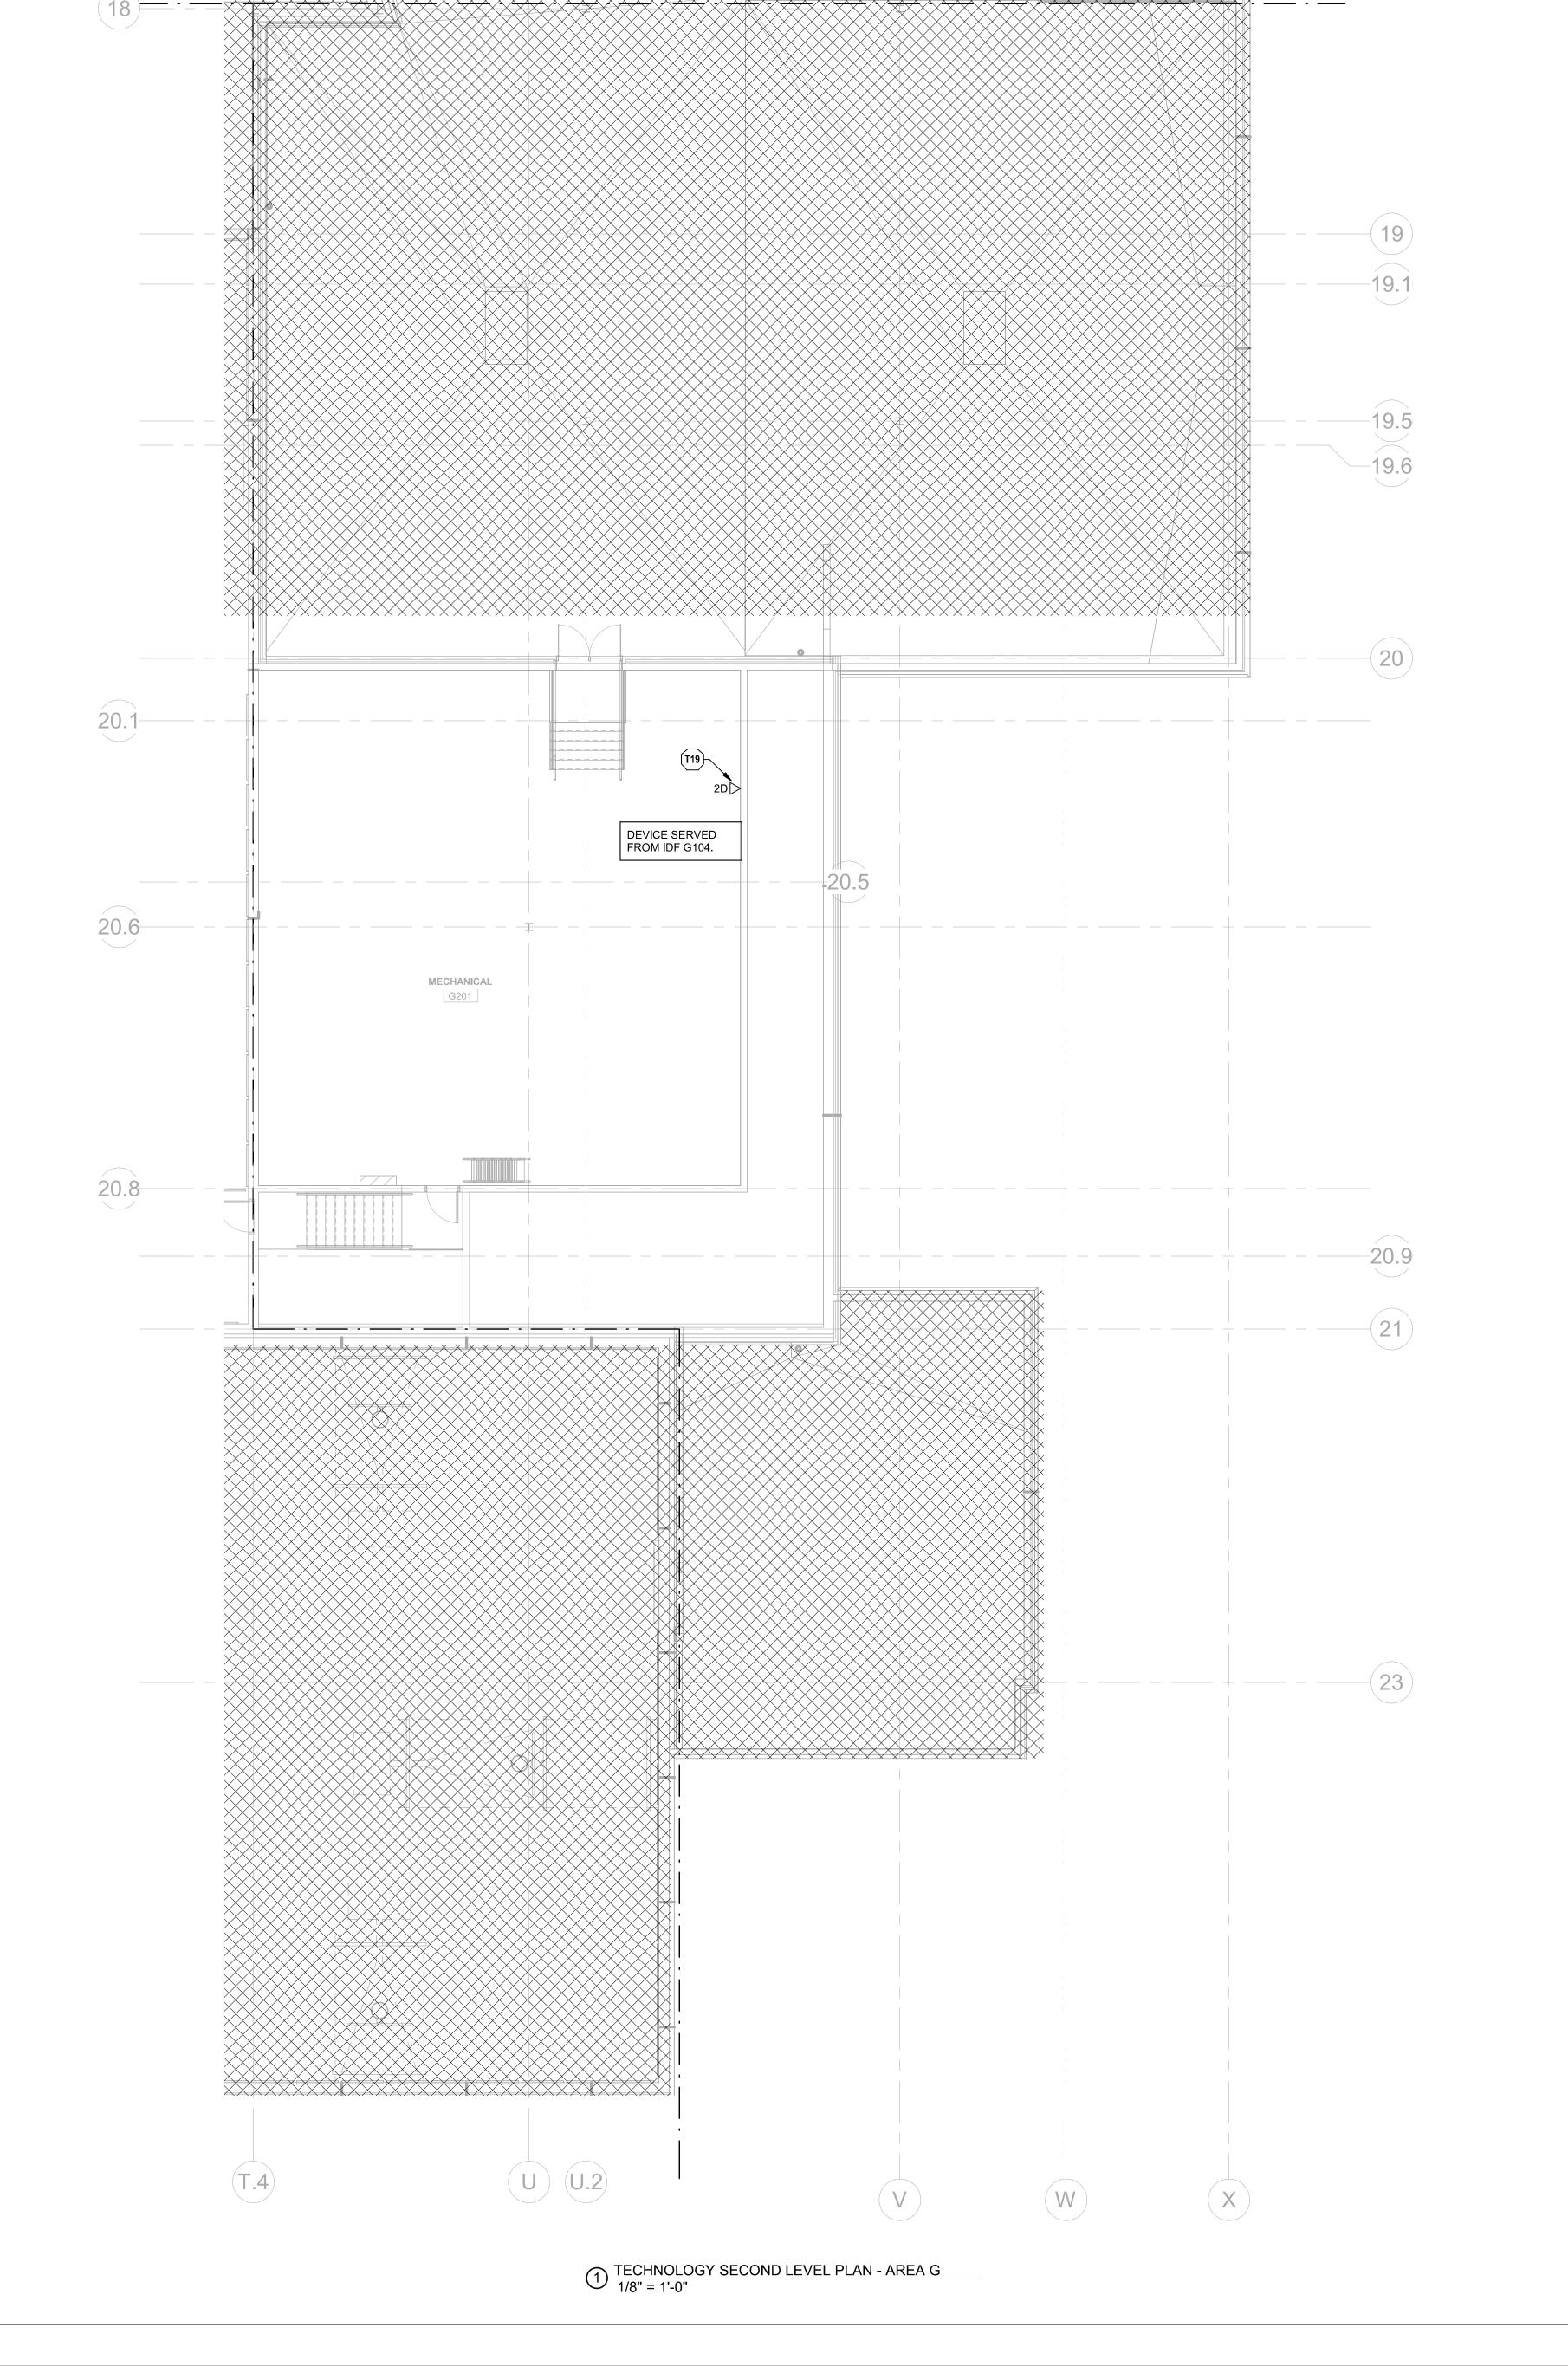

13-20102-00

TECHNOLOGY
FIRST LEVEL RCP
- AREA A

TN2.1A

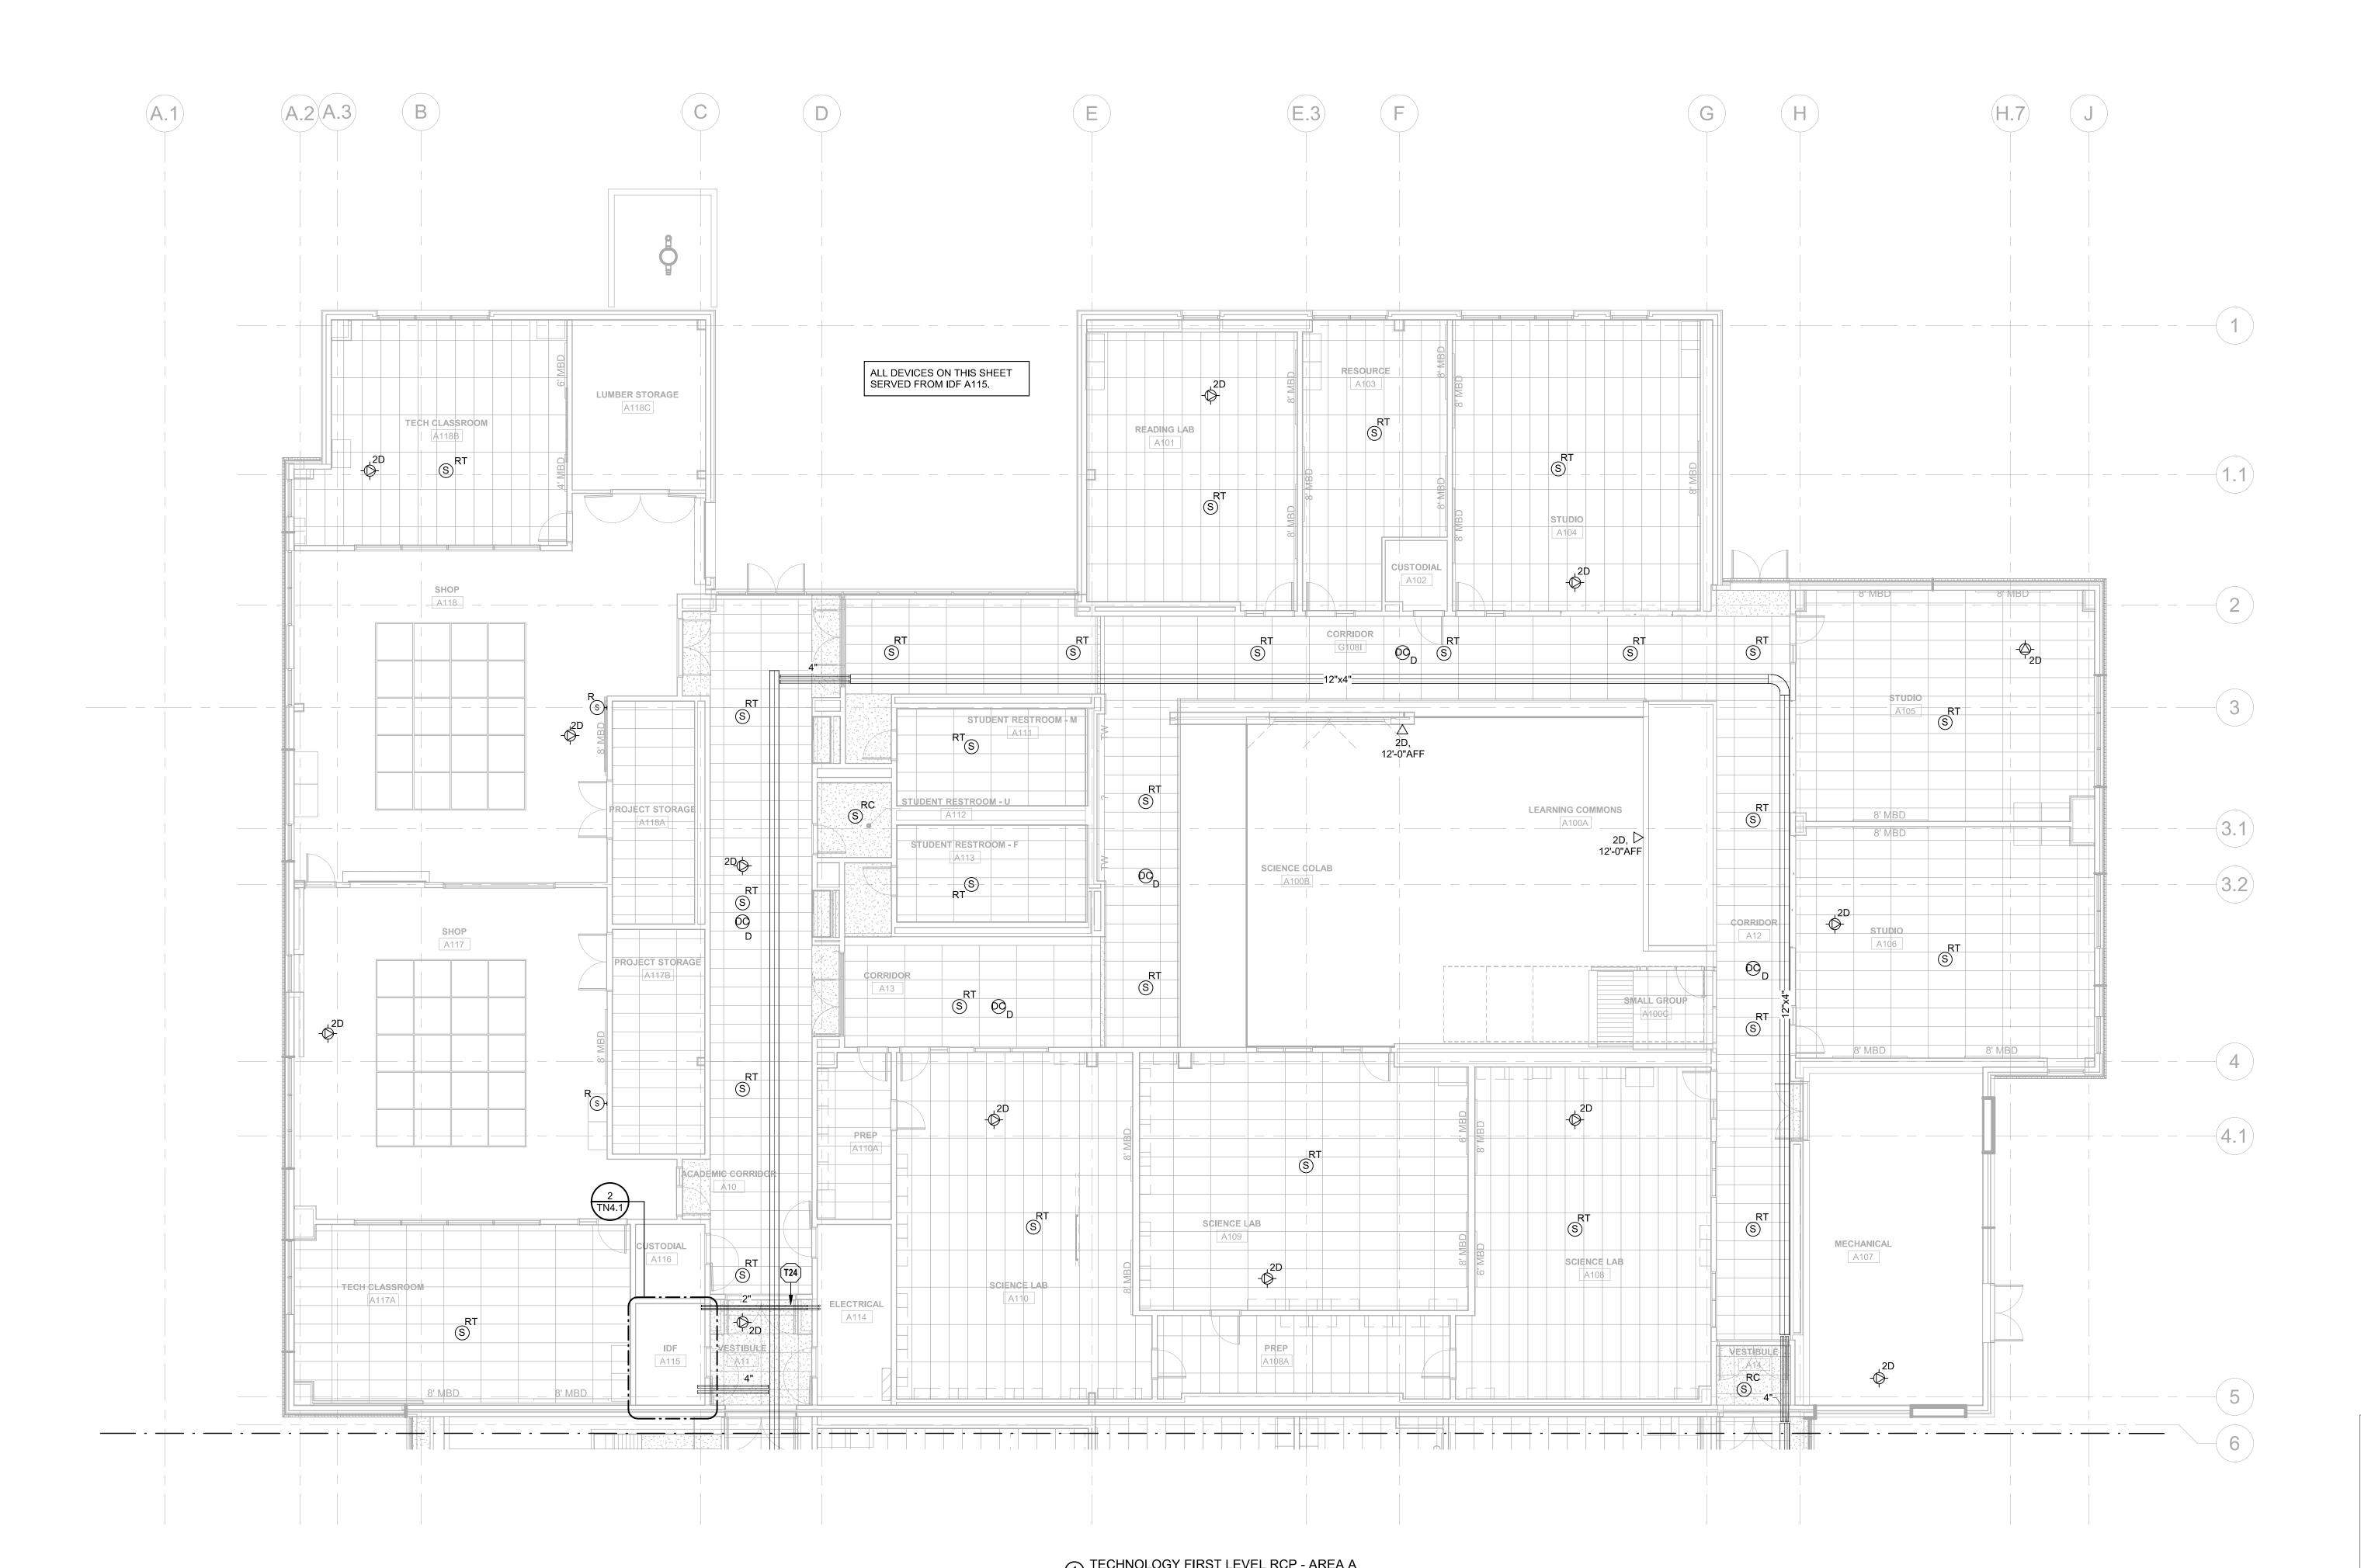


PACKAGE 3 - BUILDING & SITE REVISIONS

13-20102-00

TECHNOLOGY FIRST LEVEL RCP - AREA B

TN2.1B

KEY PLAN Α

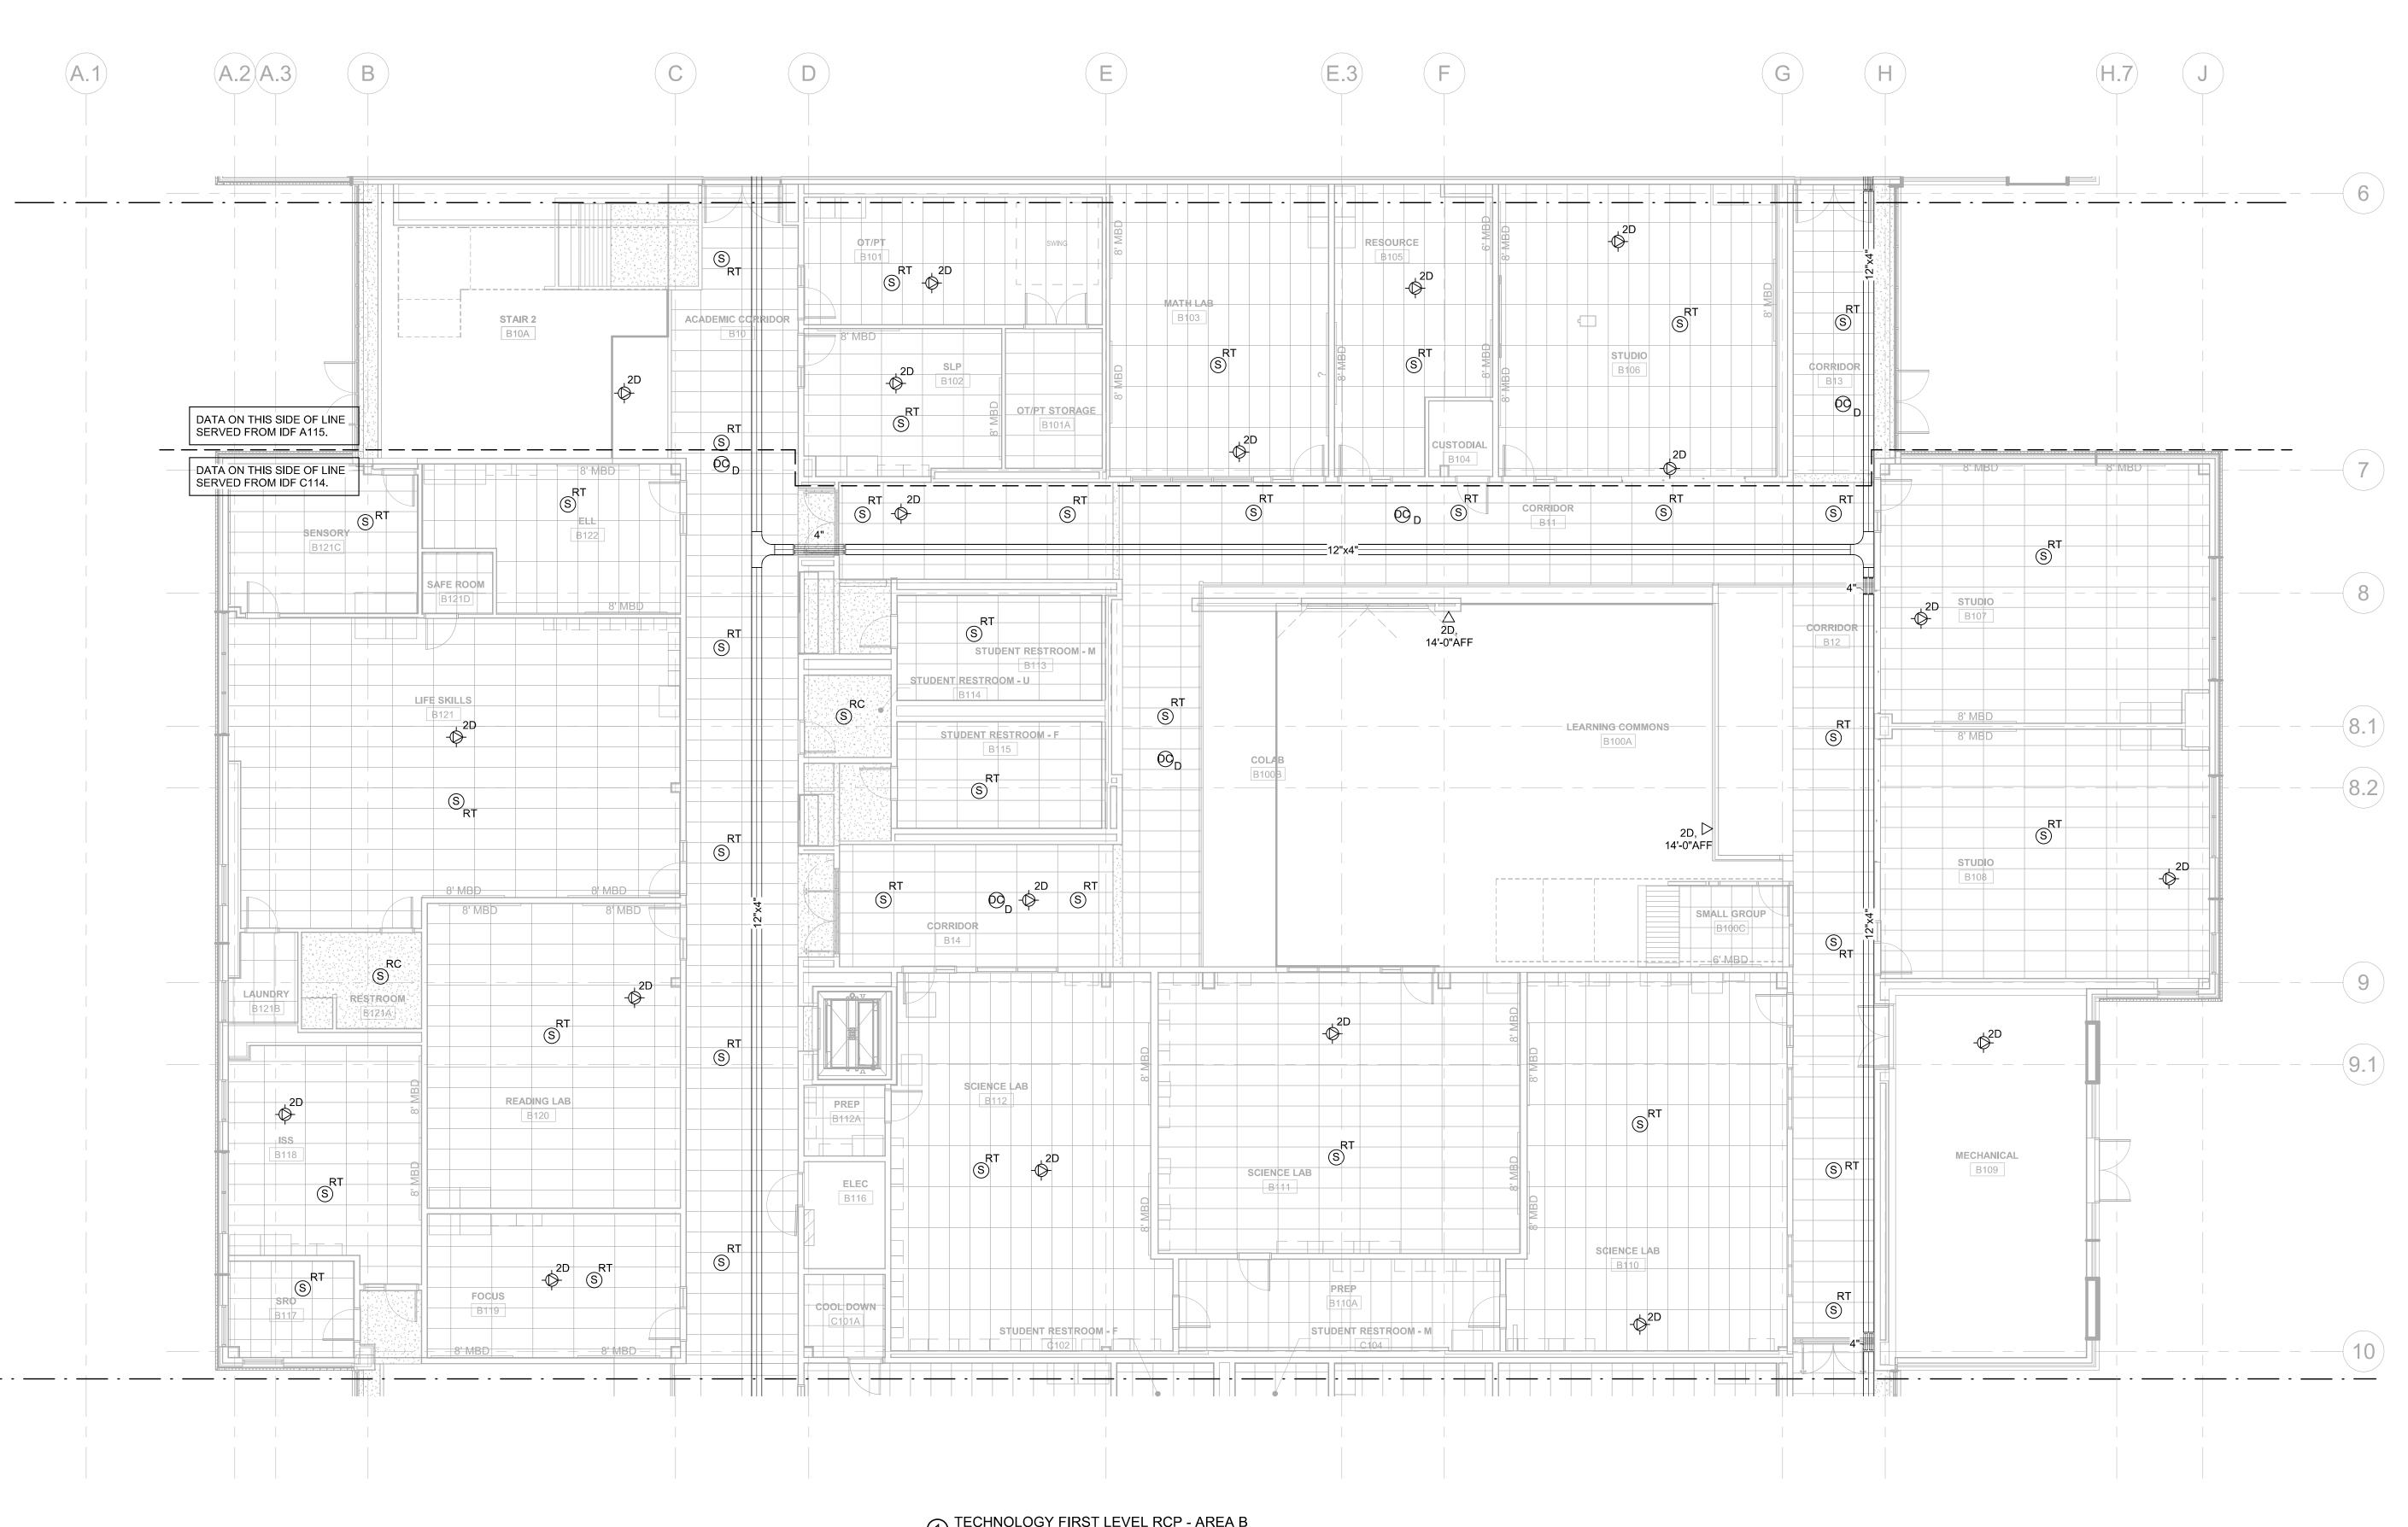

1 TECHNOLOGY FIRST LEVEL RCP - AREA B 1/8" = 1'-0"

PACKAGE 3 - BUILDING & SITE 10/08/20

REVISIONS

KEY PLAN

Α

13-20102-00 TECHNOLOGY FIRST LEVEL RCP - AREA C

TN2.1C



TECHNOLOGY FIRST LEVEL RCP - AREA C
1/8" = 1'-0"


STUDENT RESTROOM - M

STUDENT RESTROOM - F

(A.1)

(A.2)(A.3)

Group

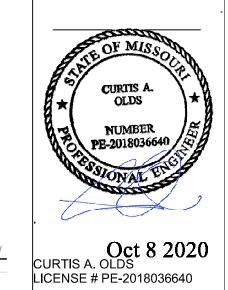



PACKAGE 3 - BUILDING & SITE 10/08/20 REVISIONS

KEY PLAN

13-20102-00 TECHNOLOGY FIRST LEVEL RCP - AREA D

TN2.1D

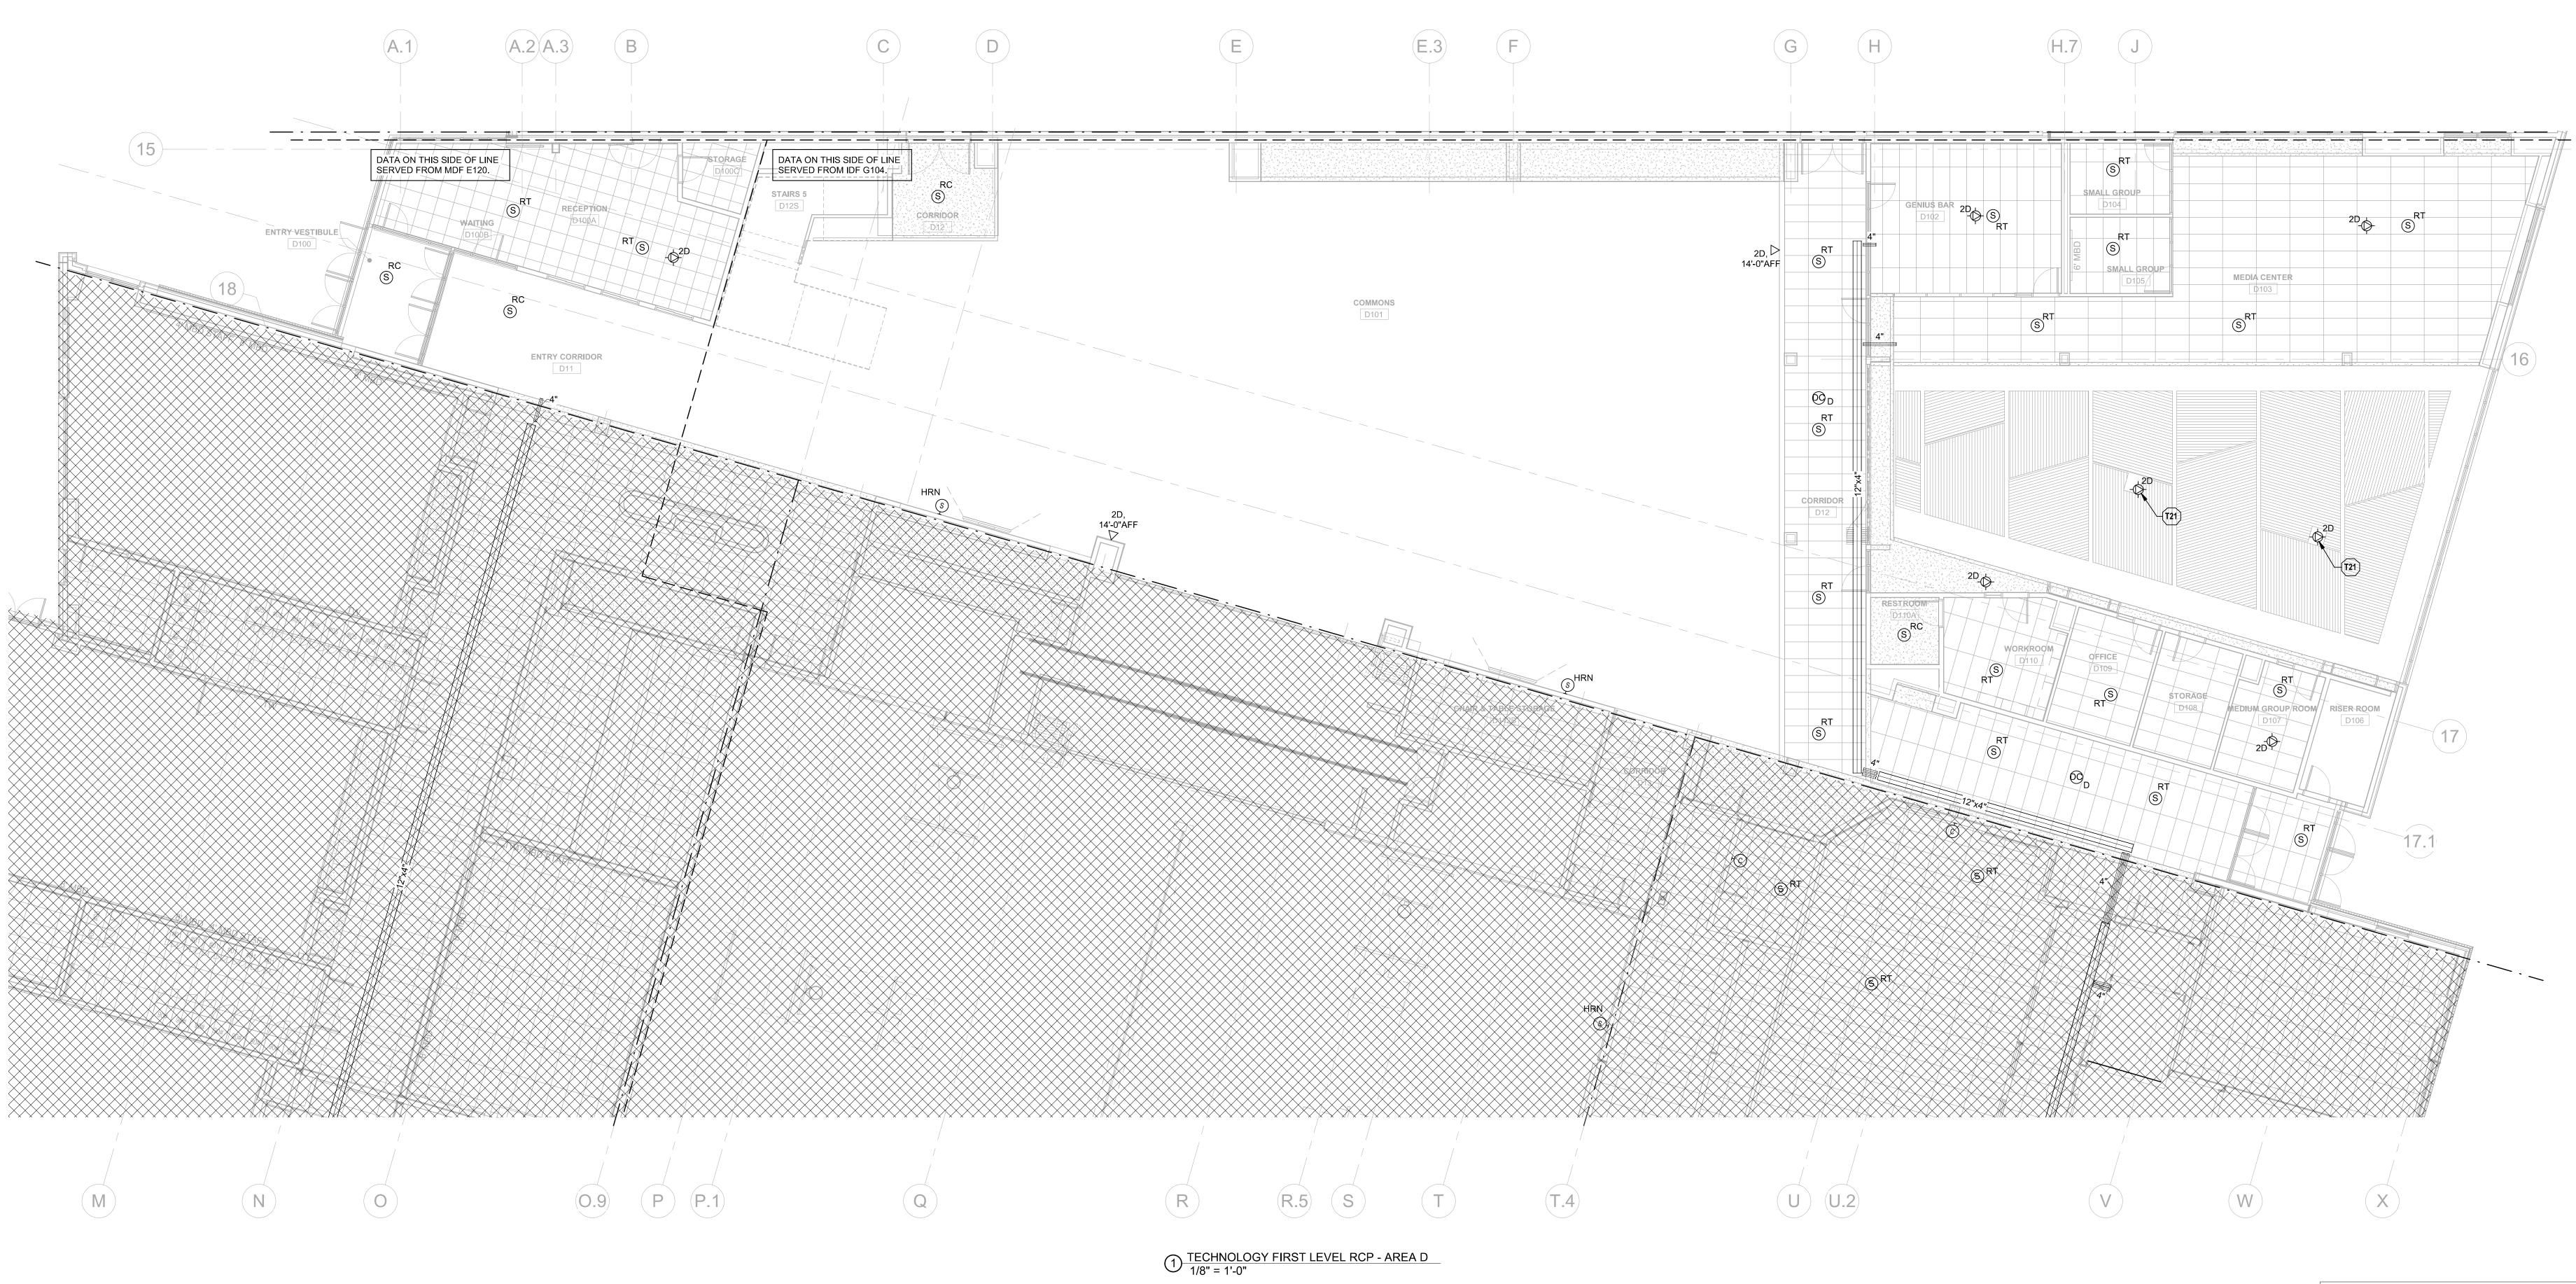

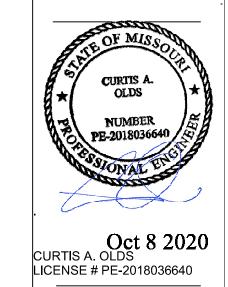


ENGINEERS
8345 LENEXA, KS 66214
TEL 913.742.5000 FAX 913.742.5001

WWW.HENDERSONENGINEERS.COM
1950005054
MO. CORPORATE NO: E-556D
EXPIRES 12/31/2020

LEE'S SUMMIT MIDDLE SCHOOL #4

PACKAGE 3 - BUILDING & SITE


REVISIONS

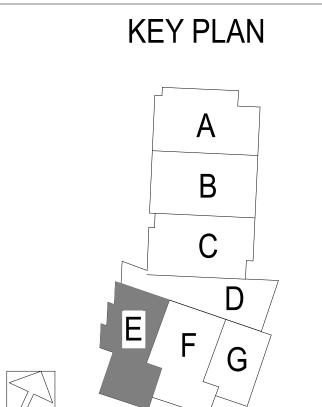

13-20102-00

TECHNOLOGY
FIRST LEVEL RCP
- AREA E

TN2.1E

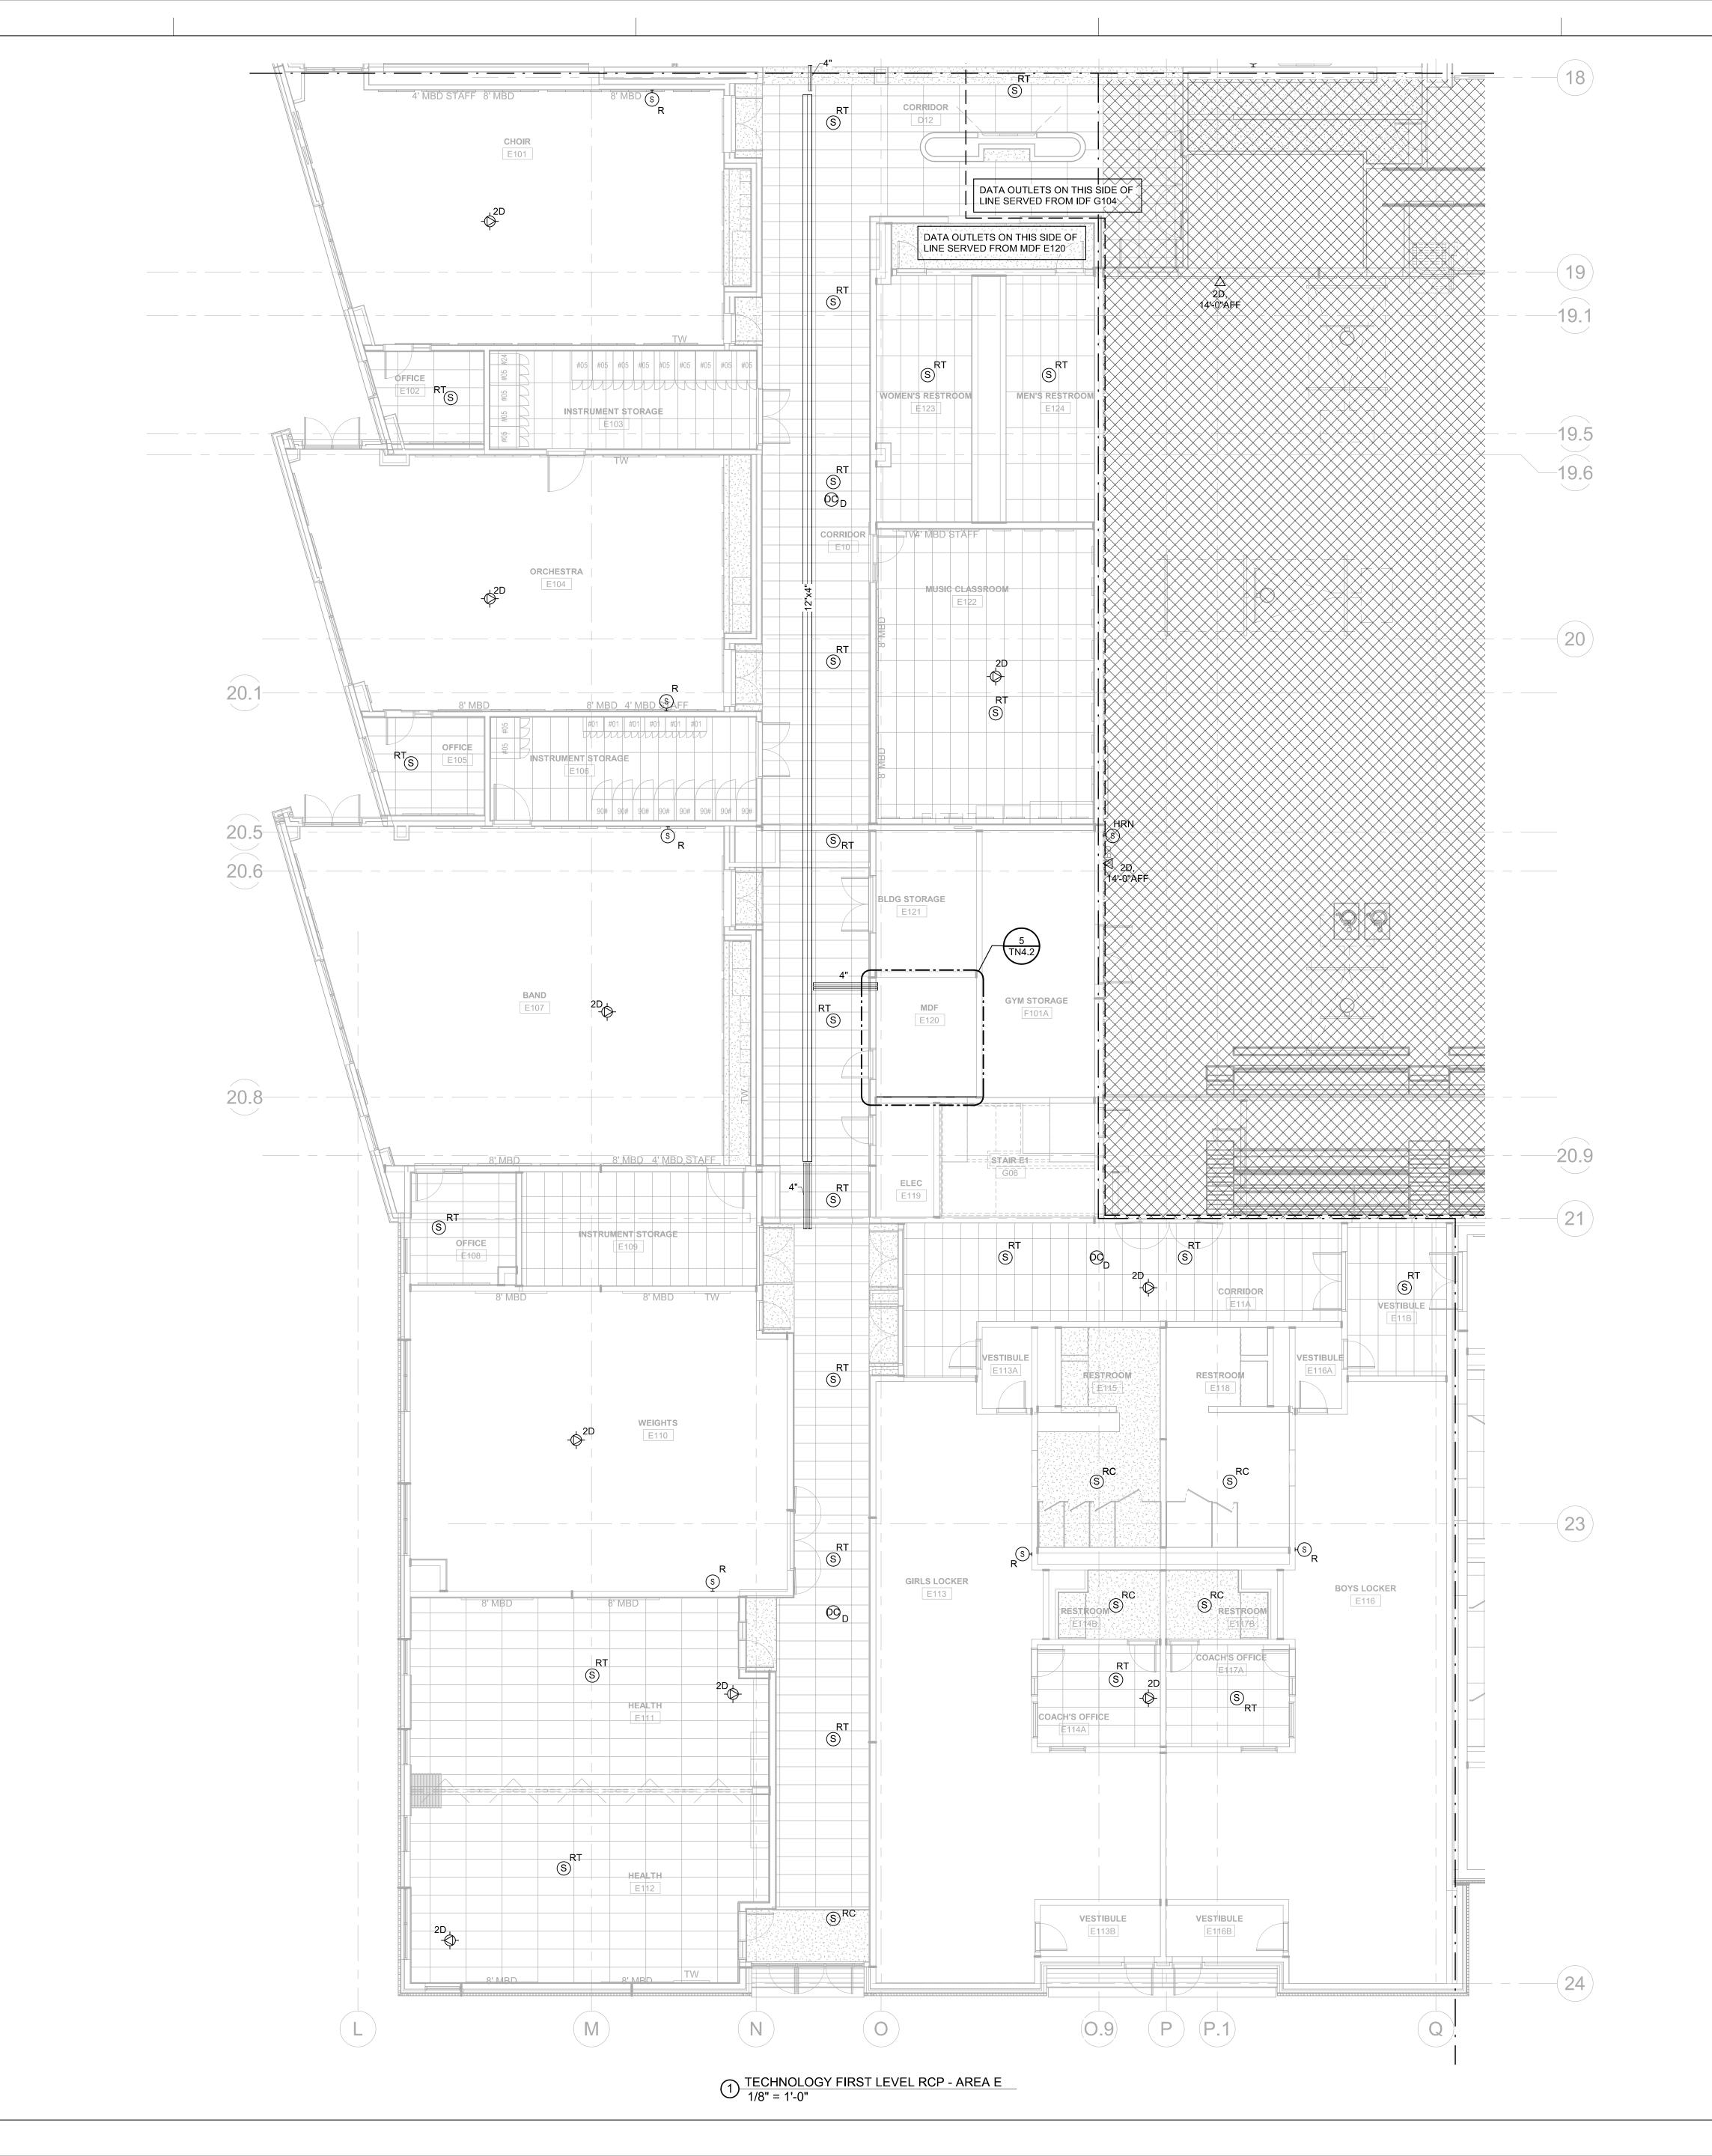



PACKAGE 3 - BUILDING & SITE 10/08/20 REVISIONS

13-20102-00

TECHNOLOGY FIRST LEVEL RCP - AREA F

TN2.1F

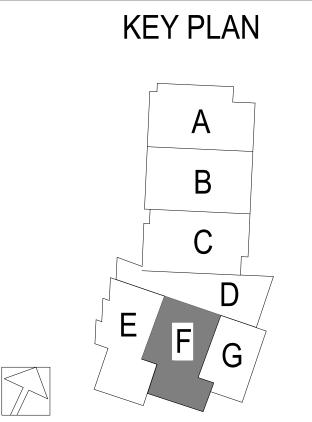


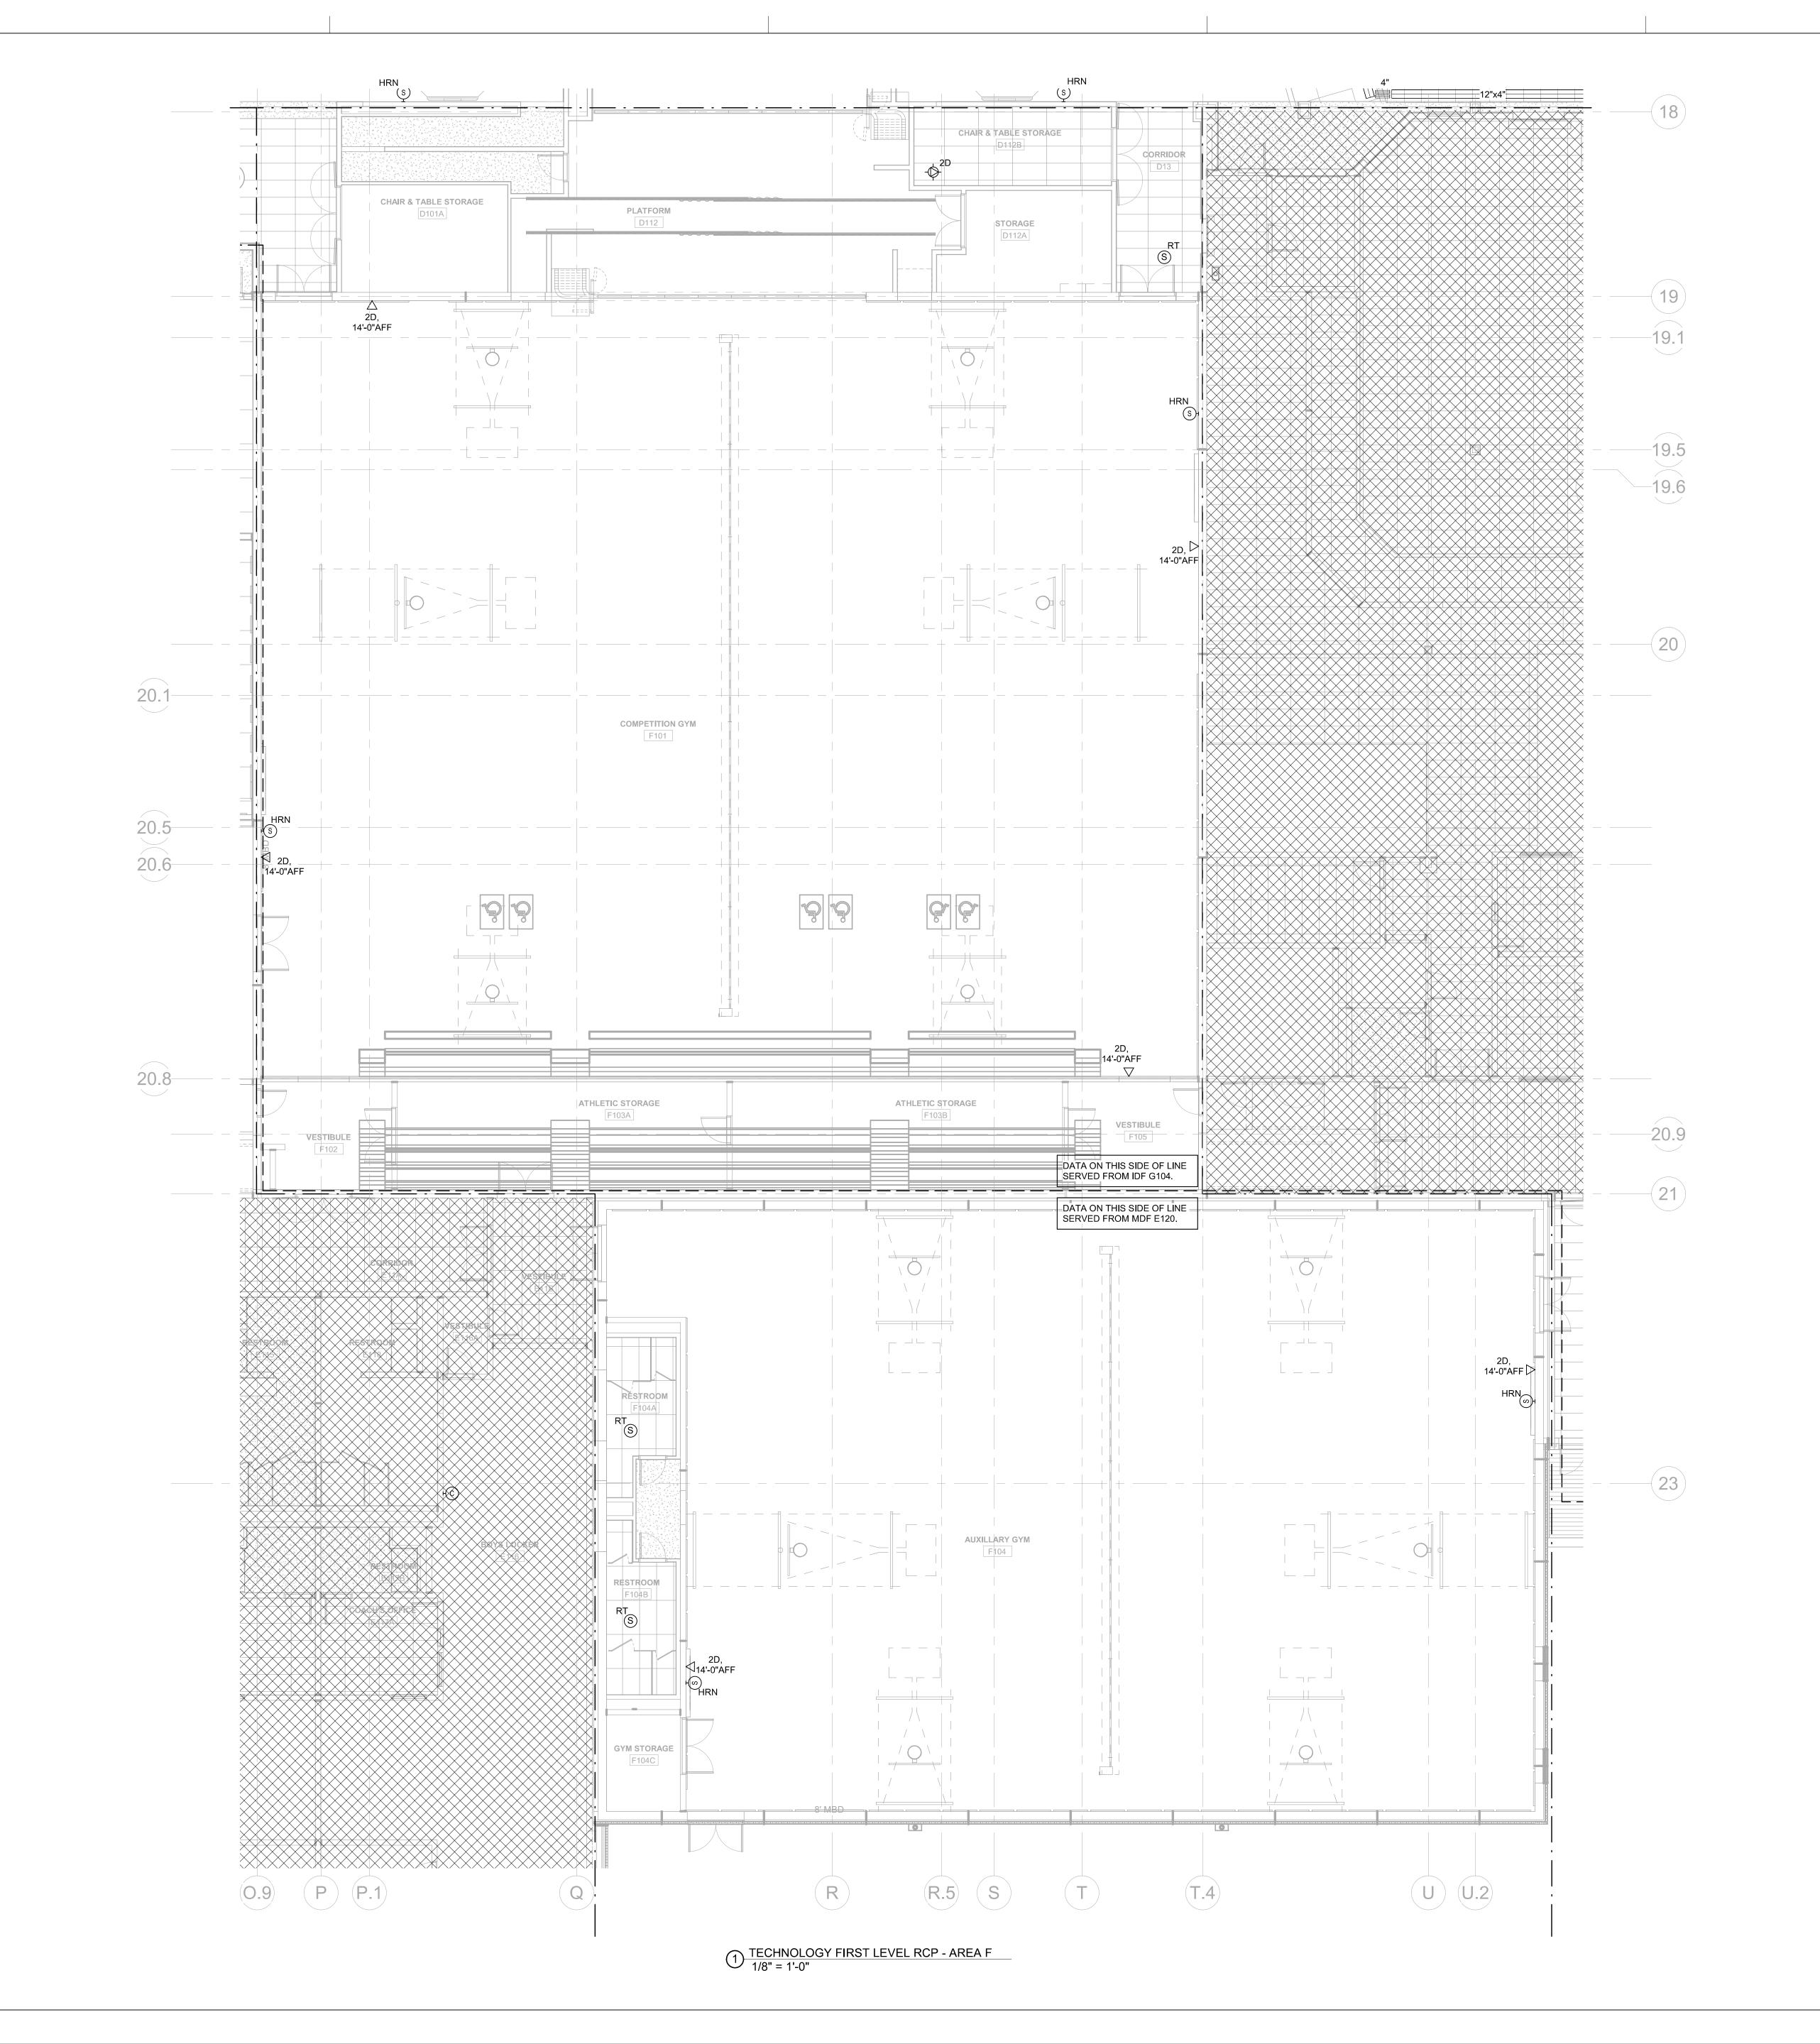


13-20102-00

TECHNOLOGY FIRST LEVEL RCP - AREA G

TN2.1G

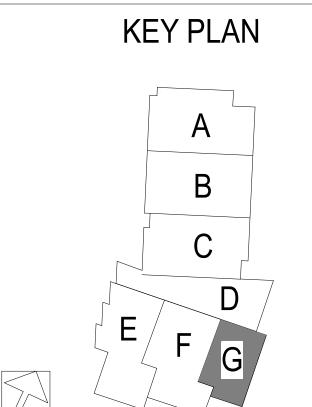

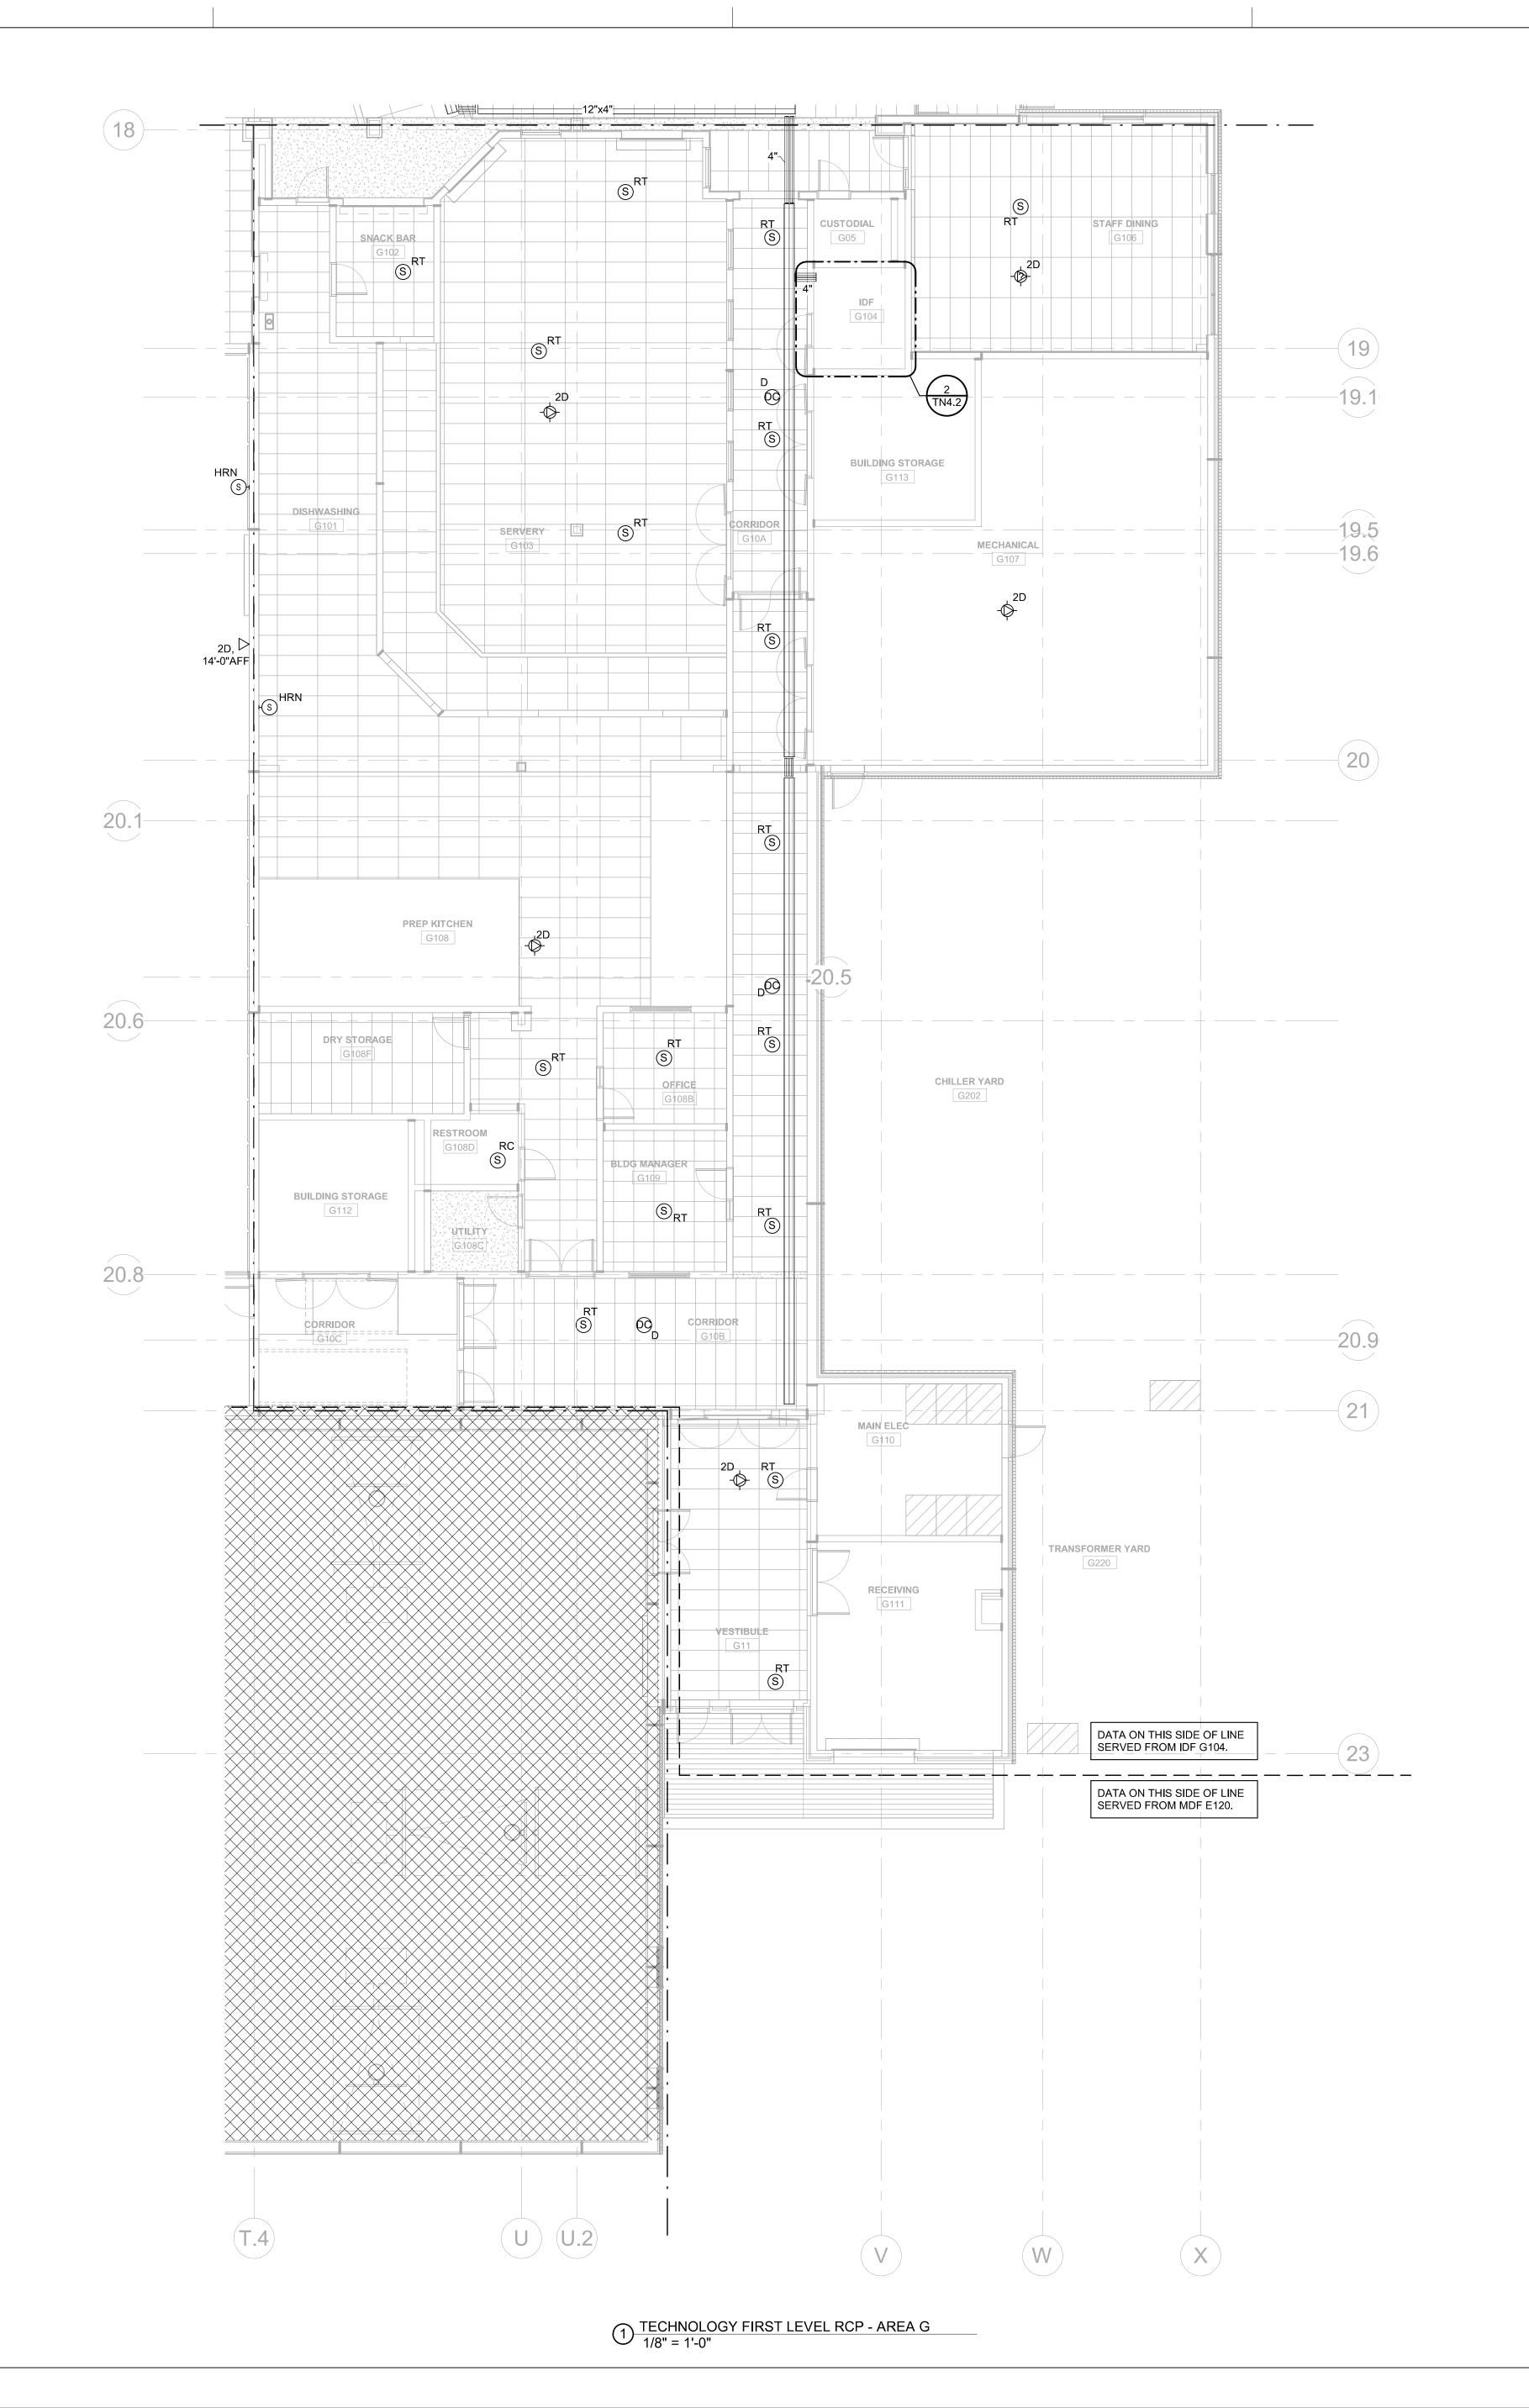

OL #4

E'S SUMMIT R-7 SCHOOL DISTRICT

PACKAGE 3 - BUILDING & SITE


REVISIONS

KEY PLAN

13-20102-00

TECHNOLOGY
SECOND LEVEL
RCP - AREA A

TN2.2A

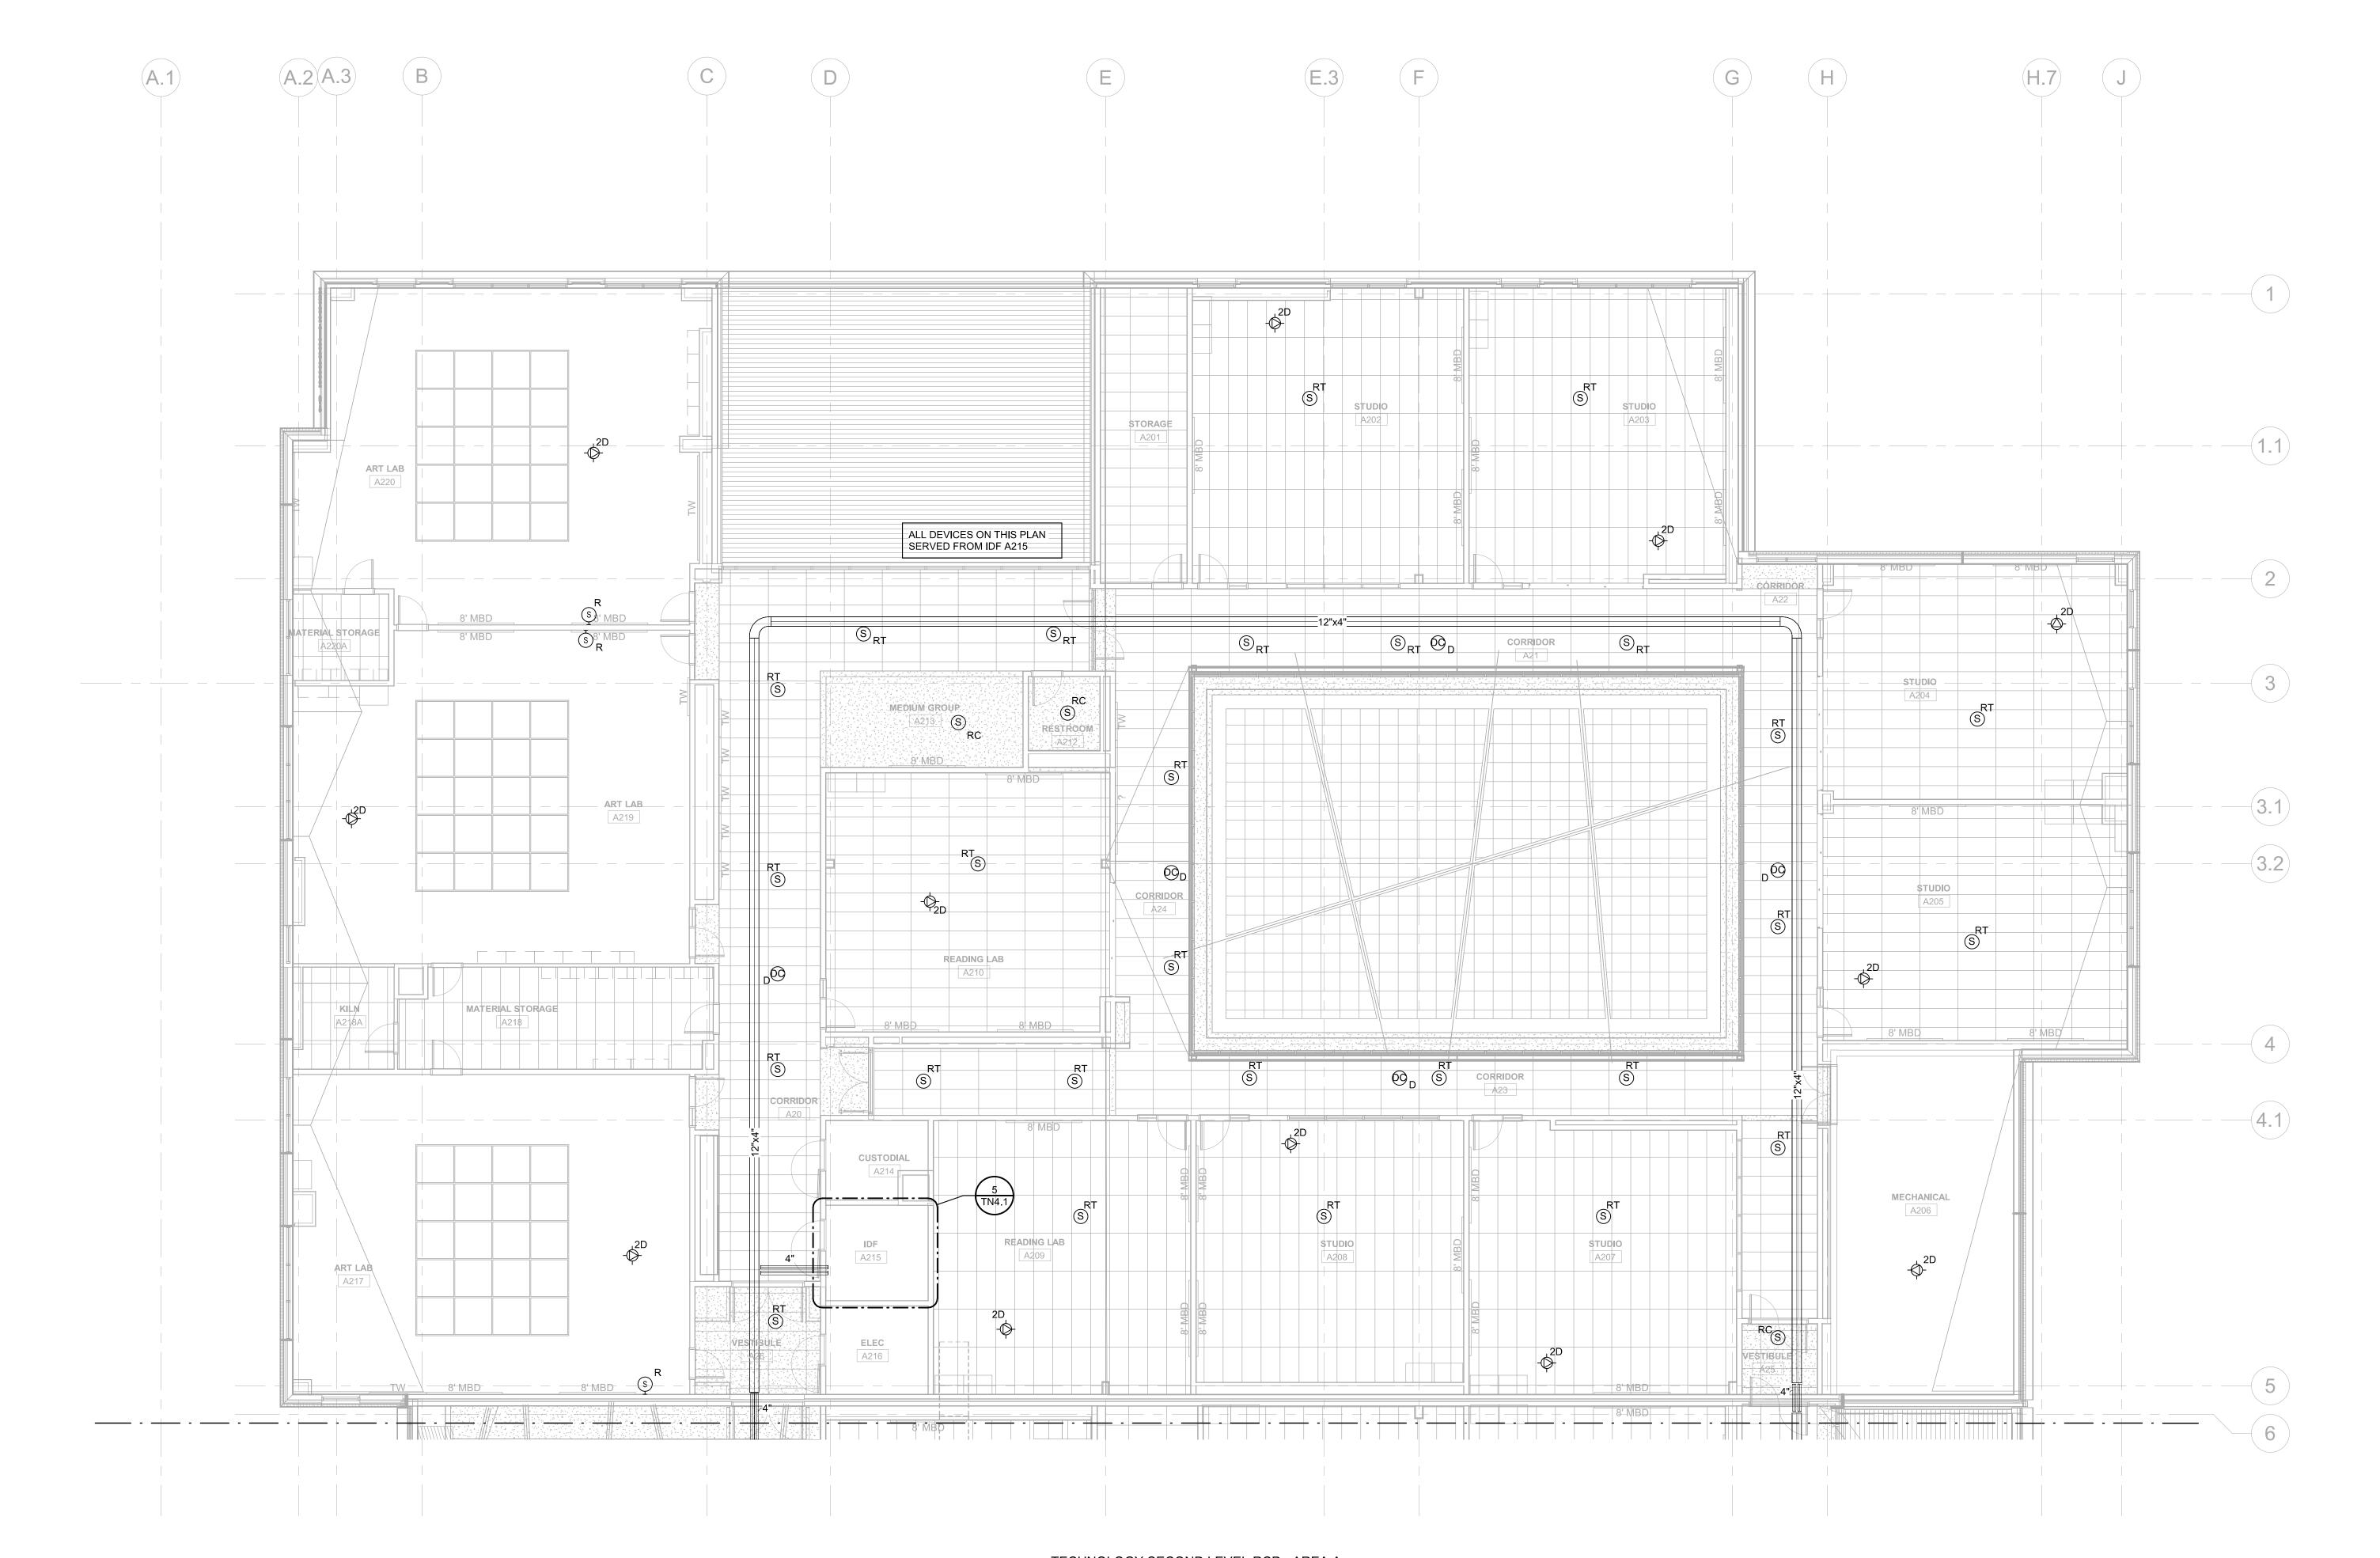

1 TECHNOLOGY SECOND LEVEL RCP - AREA A 1/8" = 1'-0"

JRTIS A. OLDS


13-20102-00

TECHNOLOGY SECOND LEVEL RCP - AREA B

TN2.2B

KEY PLAN


A
B
C
F
G
NORTH

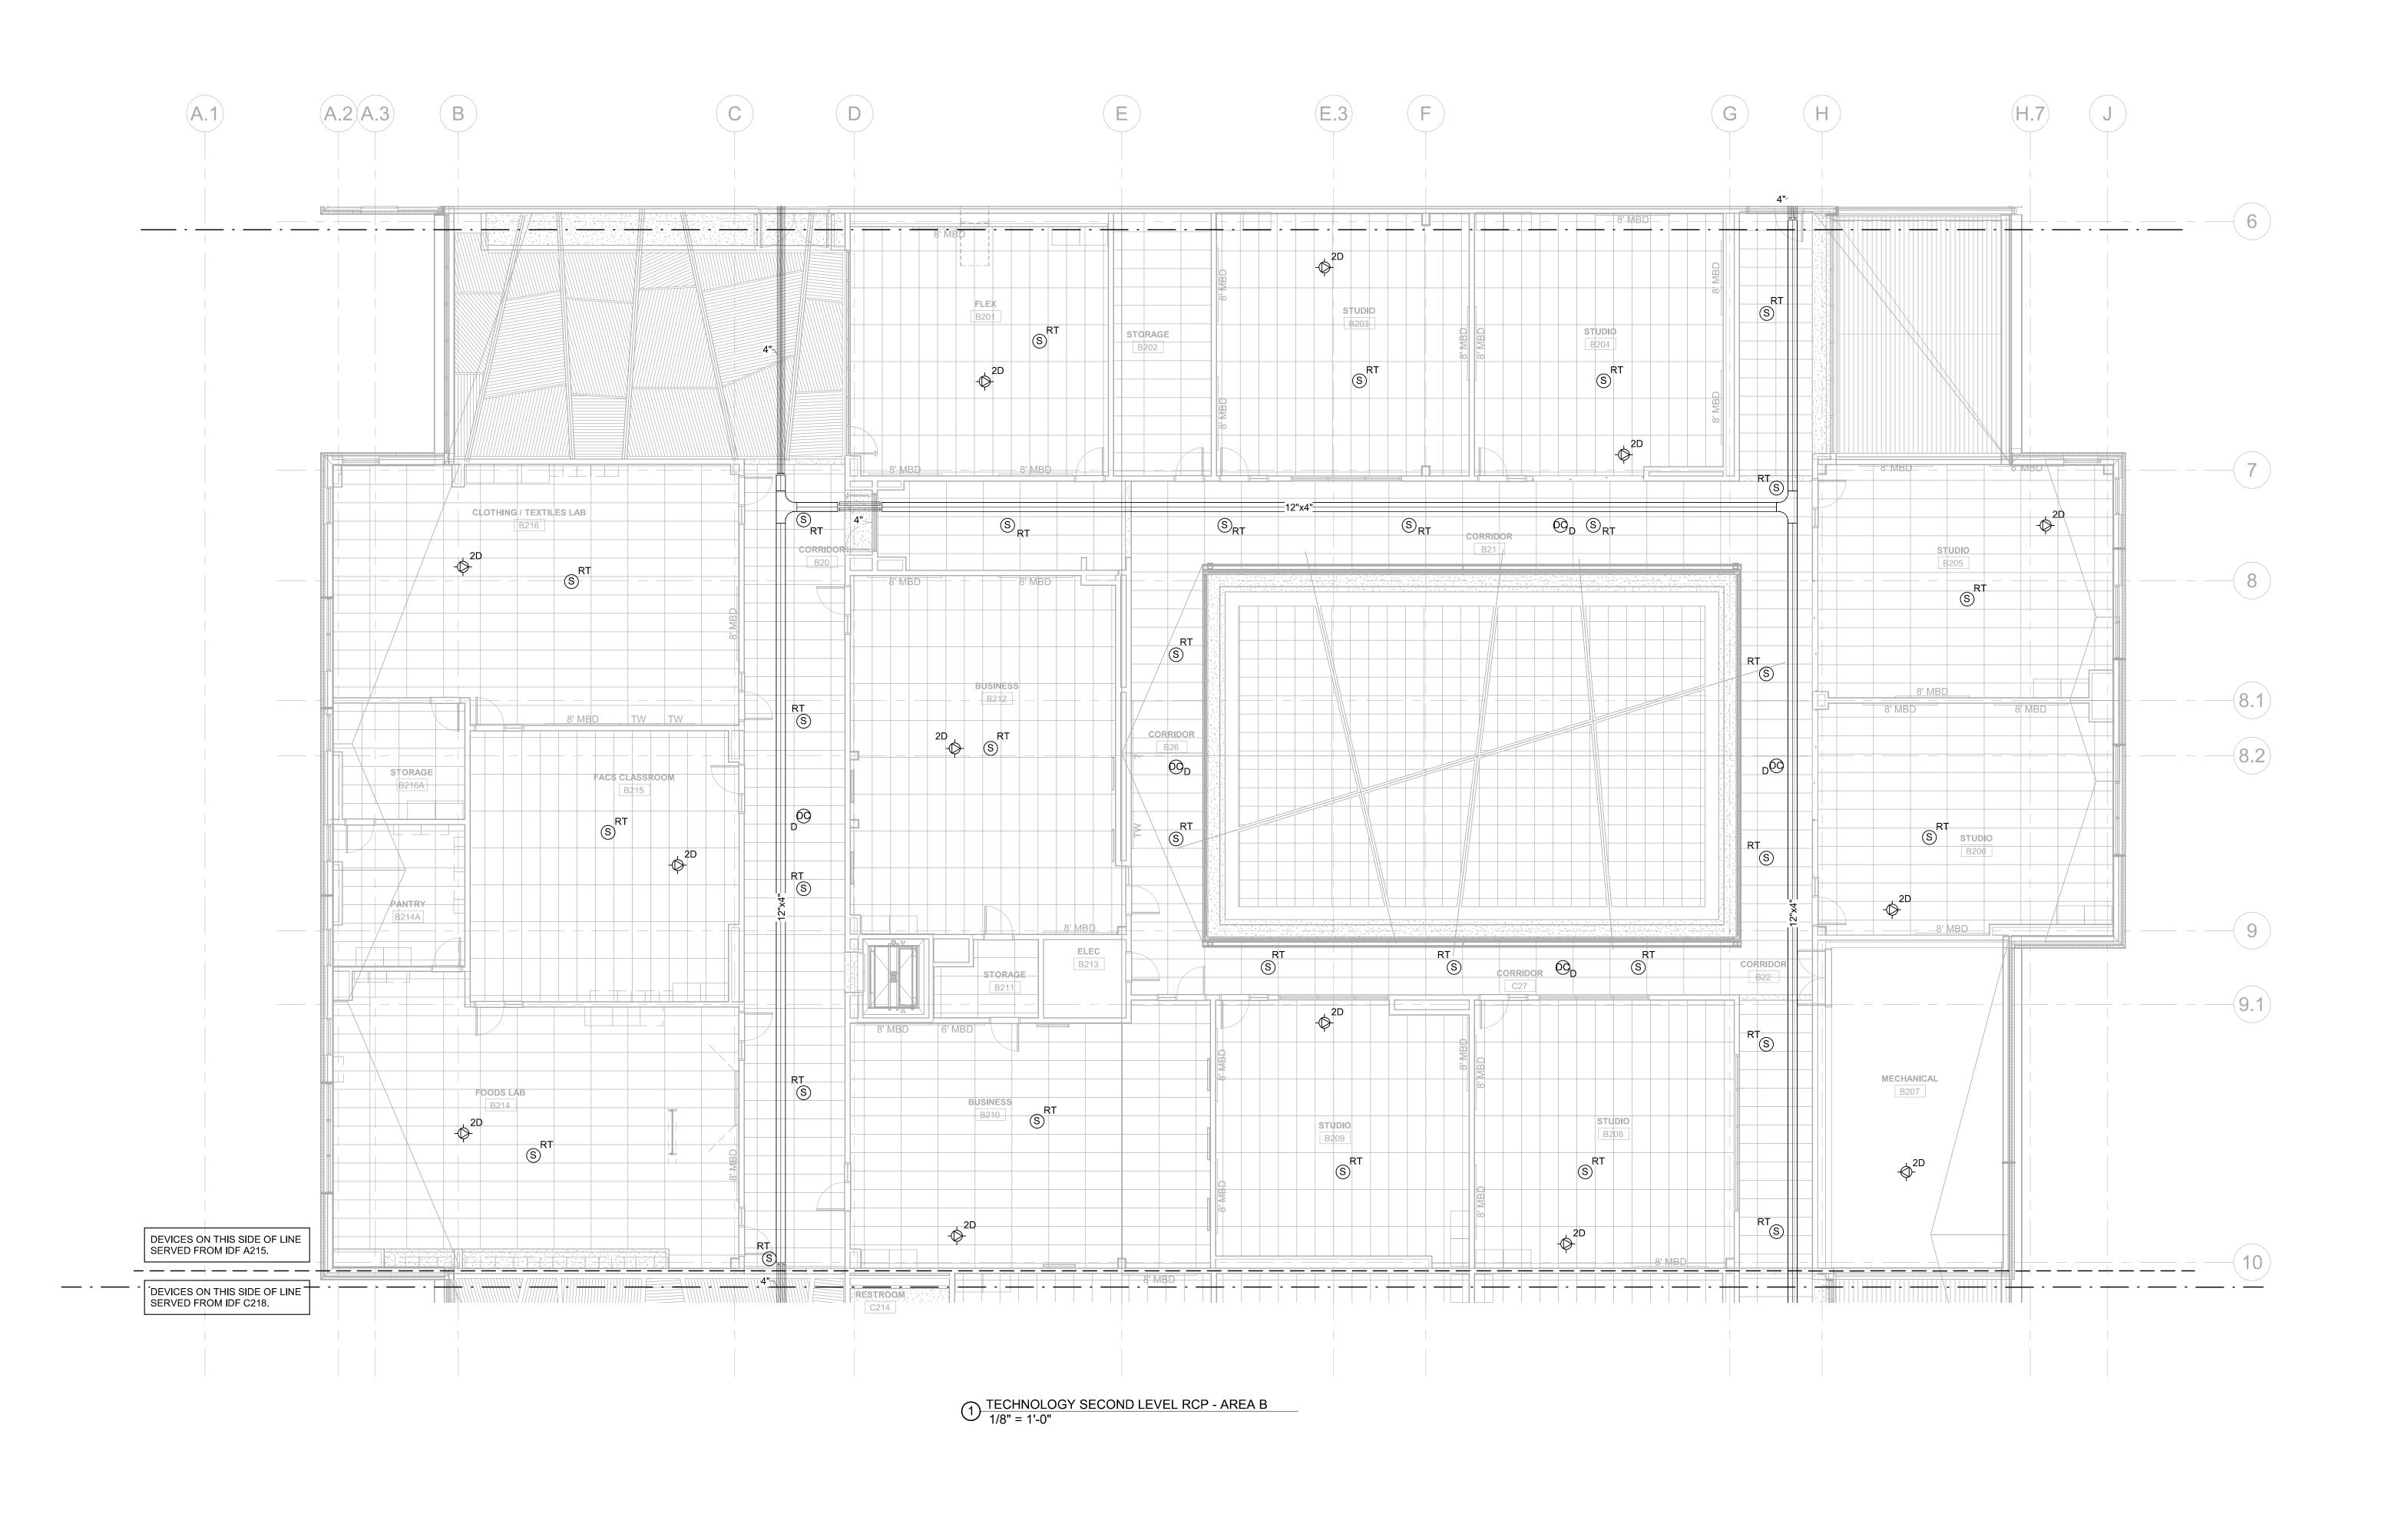



13-20102-00 TECHNOLOGY SECOND LEVEL RCP - AREA C

KEY PLAN

TN2.2C

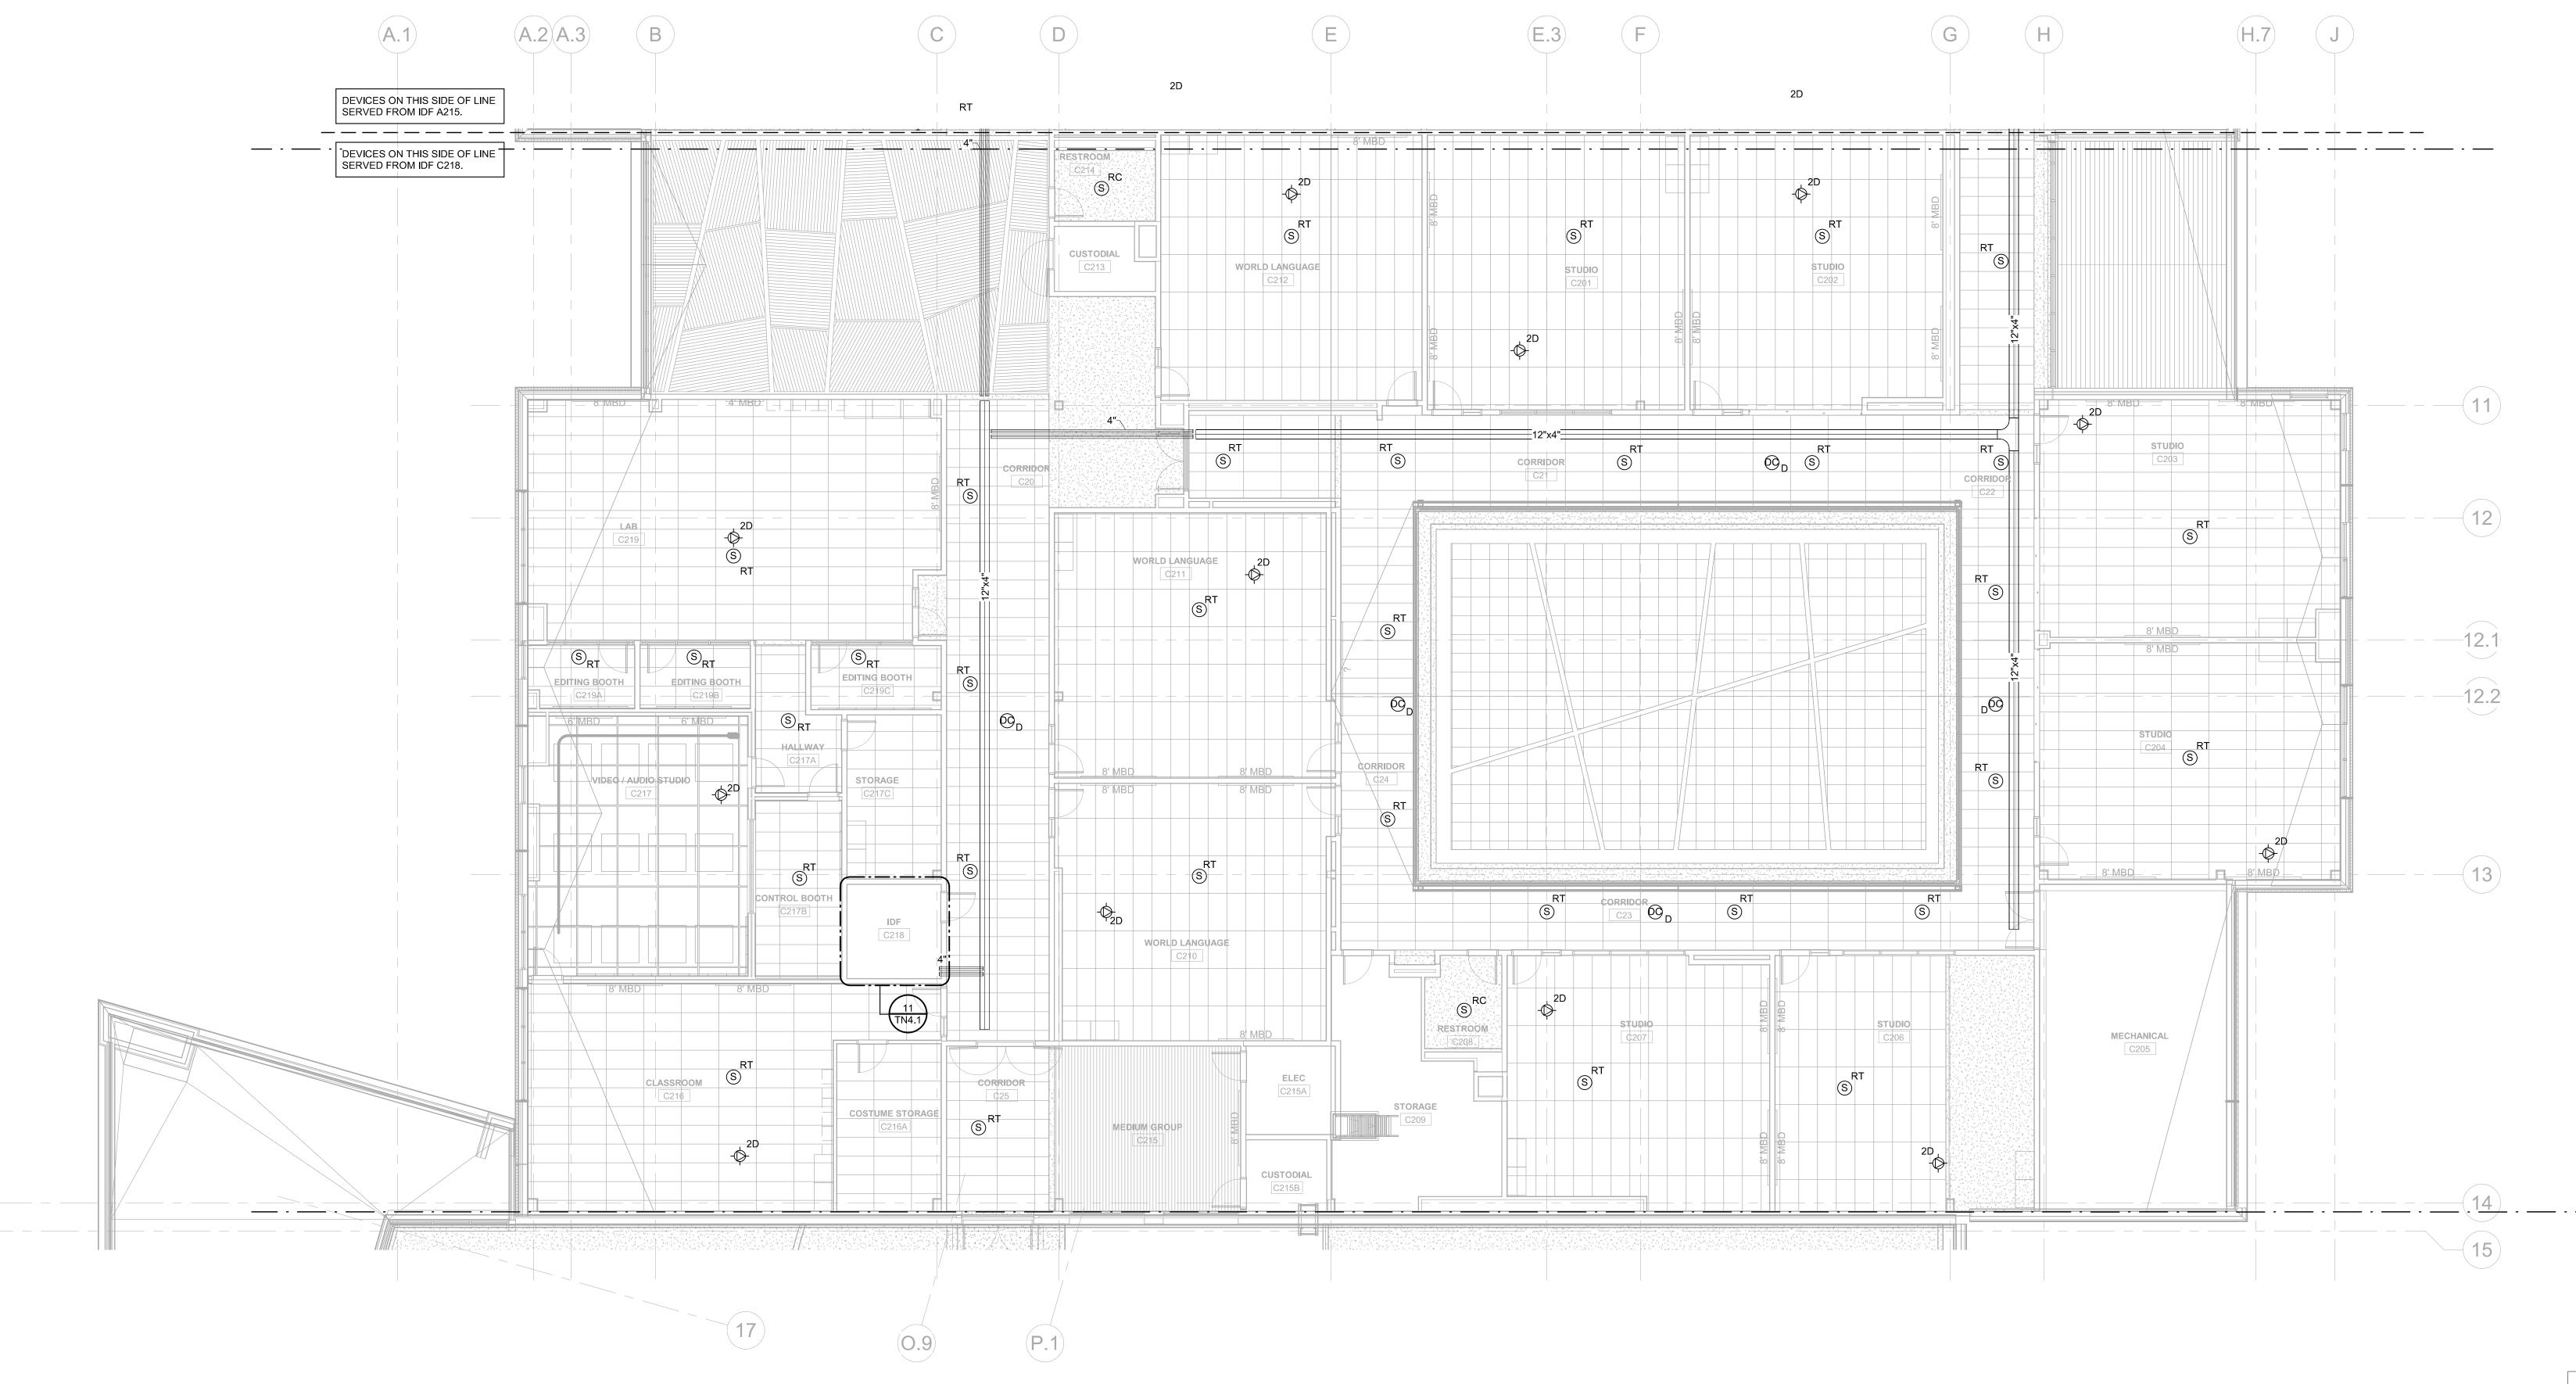

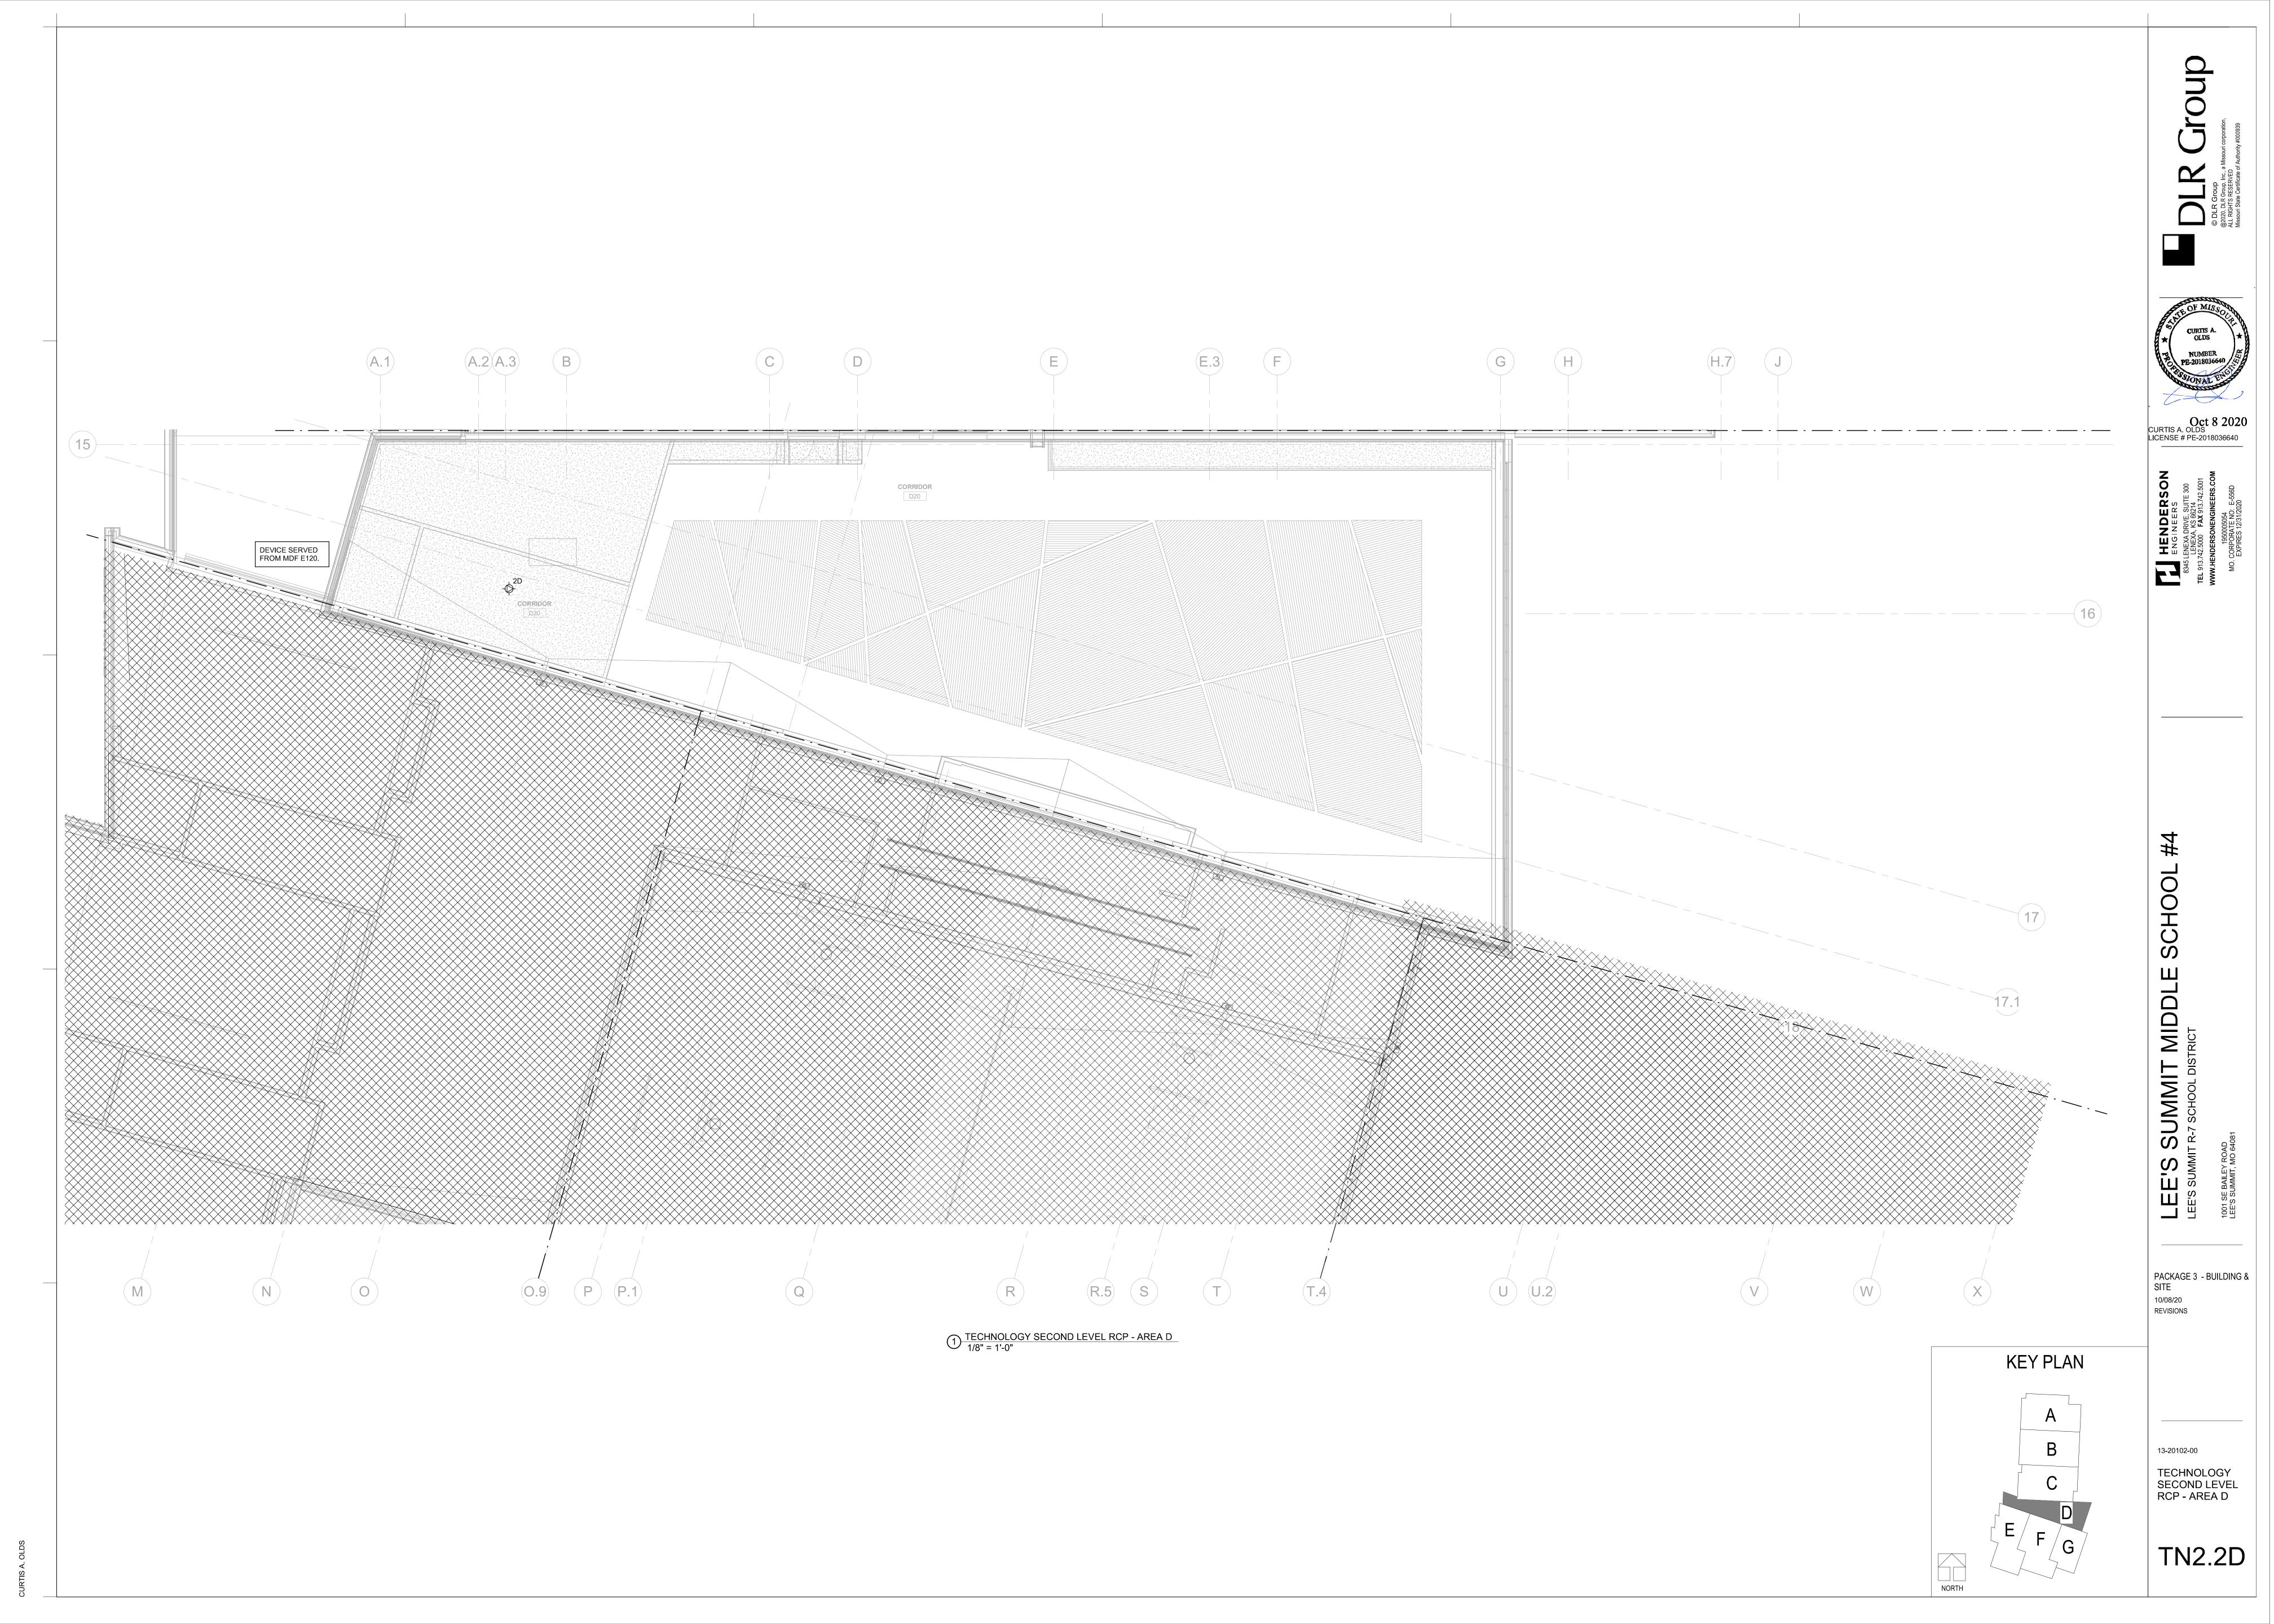

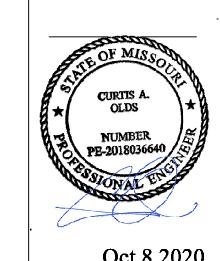

Oct 8 202 CURTIS A. OLDS LICENSE # PE-2018036640

ENGINEERS

8345 LENEXA, DRIVE, SUITE 300
LENEXA, KS 66214

TEL 913.742.5000 FAX 913.742.5001


WWW.HENDERSONENGINEERS.COM

1950005054
MO. CORPORATE NO: E-556D

EXPIRES 12/31/2020

EE'S SUMMIT R-7 SCHOOL DISTRICT


PACKAGE 3 - BUILDING & SITE
10/08/20
REVISIONS

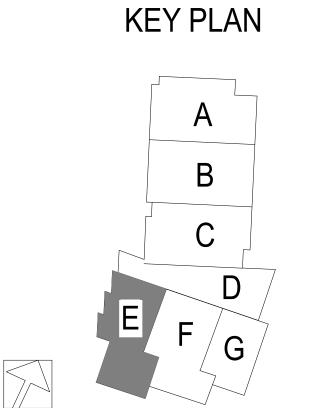

13-20102-00

TECHNOLOGY
SECOND LEVEL
RCP - AREA E

TN2.2E

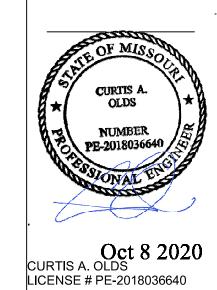


PACKAGE 3 - BUILDING & SITE REVISIONS

13-20102-00

TECHNOLOGY SECOND LEVEL RCP - AREA G

TN2.2G

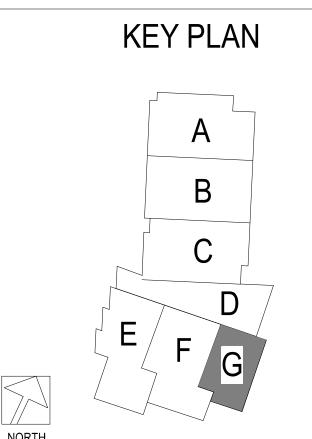

T.4 U U.2 1 TECHNOLOGY SECOND LEVEL RCP - AREA G
1/8" = 1'-0"

20.1

DEVICE SERVED FROM IDF G104.

TECHNOLOGY PLAN NOTES:

INFORMATION.

T2 PROVIDE TELECOMMUNICATIONS GROUNDING BUS BAR (TGB) MOUNTED AT 7'-0"AFF. SEE DIVISION 27 SPECIFICATIONS FOR ADDITIONAL INFORMATION. T3 PROVIDE TELECOMMUNICATIONS BACKBOARD. GRADE A/C 3/4" FIRE RATED PLYWOOD BACKBOARD (UNPAINTED) STARTING AT 4" AFF AND EXTEND UPWARDS 8'-0" ON ALL WALLS AS INDICATED ON DRAWINGS. THE A SIDE SHALL BE EXPOSED TO THE INTERIOR OF THE ROOM AND THE C SIDE PLACED AGAINST THE BUILDING STRUCTURE. SEE DIVISION

27 SPECIFICATIONS FOR ADDITIONAL INFORMATION. T5 PROVIDE 18" WIDE LADDER RACK WITH 9" RUNG SPACING. SEE DIVISION 27 SPECIFICATIONS FOR ADDITIONAL

T6 PROVIDE 2-POST EQUIPMENT RACK. SEE DIVISION 27 SPECIFICATIONS FOR ADDITIONAL INFORMATION. T8 PROVIDE VERTICAL CABLE MANAGER. SEE DIVISION 27 SPECIFICATIONS FOR ADDITIONAL INFORMATION.

T9 PROVIDE HORIZONTAL CABLE MANAGER. SEE DIVISION 27

SUPPORT WIRELESS ACCESS POINTS. PROVIDE QUANTITY AS REQUIRED TO SUPPORT ALL CATEGORY 6A DATA

OUTLETS SERVED BY TELECOM ROOM PLUS SPARES AS

QUANTITY AS REQUIRED TO SUPPORT ALL CATEGORY 6 DATA OUTLETS SERVED BY TELECOM ROOM PLUS SPARES

T12 PROVIDE 48-PORT CATEGORY 6 PATCH PANEL. PROVIDE

T13 INSTALL OWNER FURNISHED UNINTERRUPTIBLE POWER

T15 PROVIDE 4" CONDUIT SLEEVES. PROVIDE UL FIRESTOP SYSTEM ASSEMBLY AS REQUIRED. SEE DIVISION 27 SPECIFICATIONS FOR ADDITIONAL INFORMATION.

MOUNTING HEIGHT AND EXACT REQUIREMENTS WITH

T17 DATA OUTLET FOR SECURITY PANEL. COORDINATE

SECURITY CONTRACTOR PRIOR TO ROUGH-IN. T24 (2) 2" CONDUITS FOR BACKBONE CABLING BETWEEN IDF

SPECIFICATIONS FOR ADDITIONAL INFORMATION. T10 PROVIDE OPTICAL FIBER PANEL, SEE DIVISION 27

SPECIFICATIONS FOR ADDITIONAL INFORMATION.

T11 PROVIDE 48-PORT CATEGORY 6A PATCH PANEL TO

NOTED IN DIVISION 27 SPECIFICATIONS.

AS NOTED IN DIVISION 27 SPECIFICATIONS.

T14 INSTALL OWNER FURNISHED VERTICAL POWER DISTRIBUTION UNIT ON BACK OF RACK.

T16 OWNER PROVIDED NETWORK SWITCH.

À115 AND IDF A215. T25 12"X4" VERTICAL CABLE TRAY.

SUMMIT IIT R-7 SCHOOL DIST

REVISIONS

PACKAGE 3 - BUILDING & SITE 10/08/20

13-20102-00 TECHNOLOGY **ENLARGED**


TN4.1


PLANS


T2 -1/2" = 1'-0" 7 IDF C114 - ENLARGED PLAN 1/2" = 1'-0" 10 IDF C218 - ENLARGED PLAN 1/2" = 1'-0"


A115

1) IDF A115 - ENLARGED PLAN 1/2" = 1'-0"

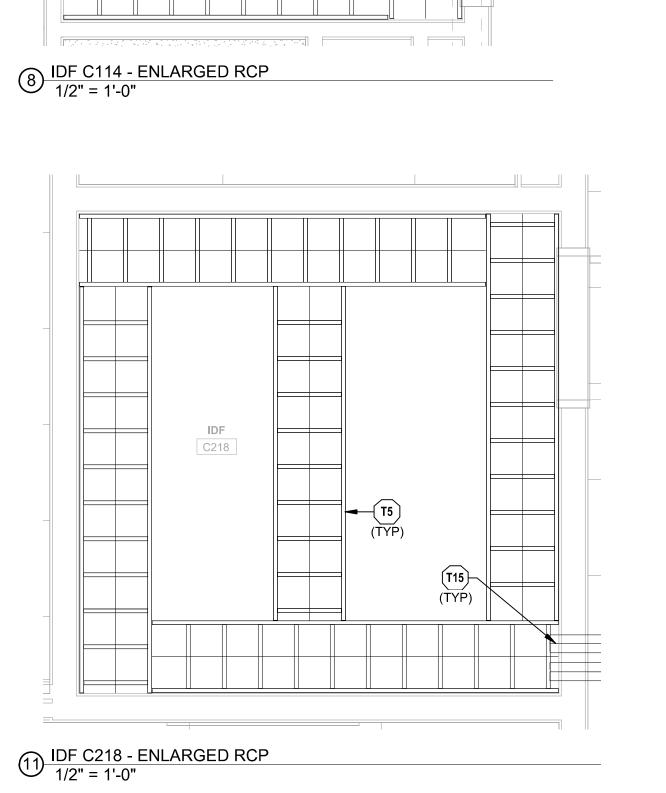

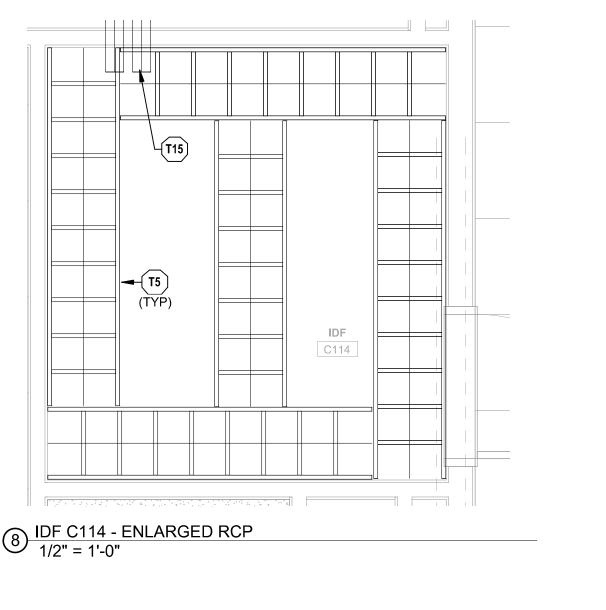


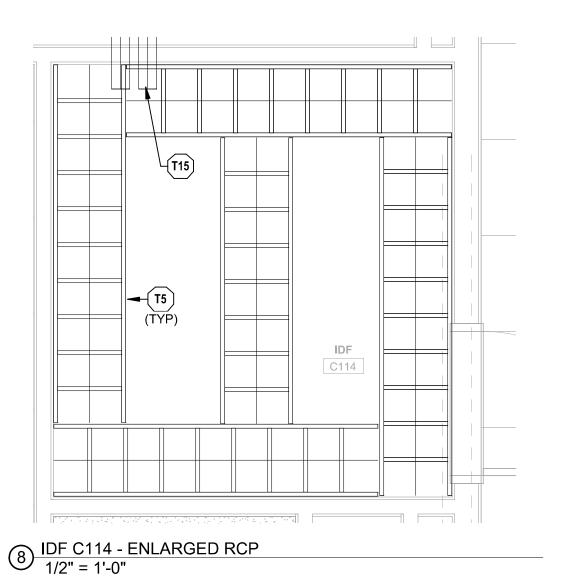


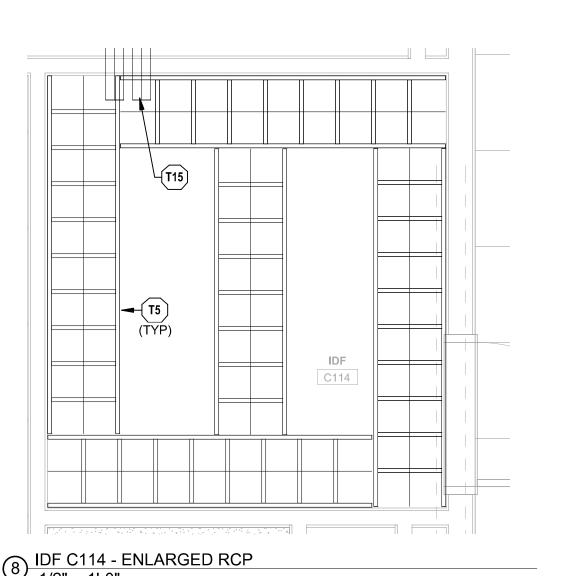



2 IDF A115 - ENLARGED RCP 1/2" = 1'-0"


5 IDF A215 - ENLARGED RCP 1/2" = 1'-0"

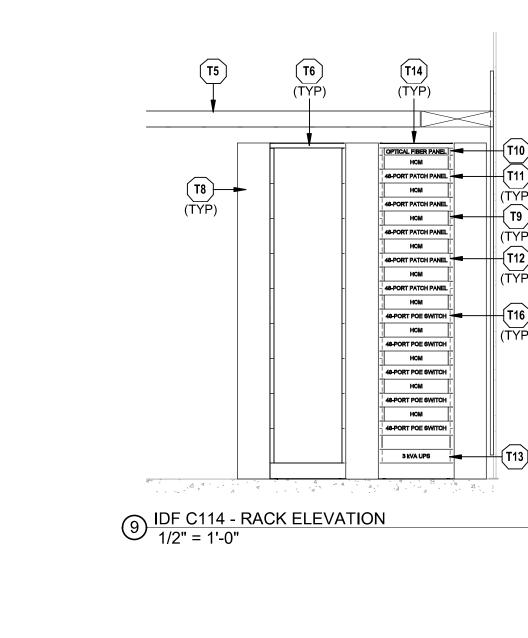

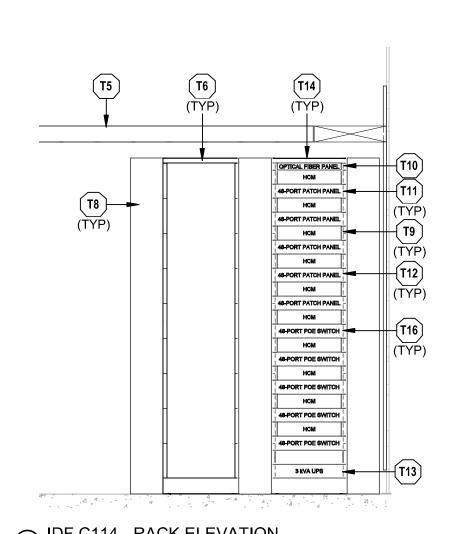

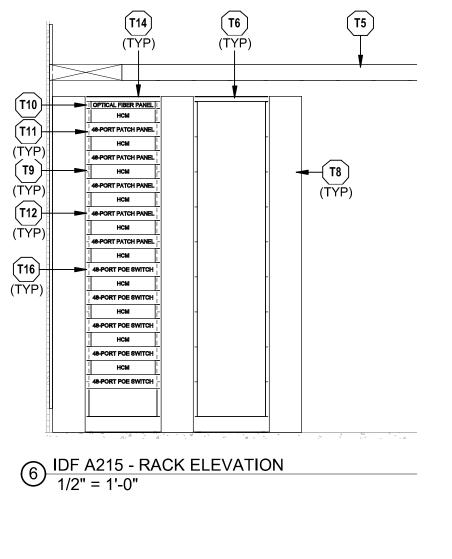

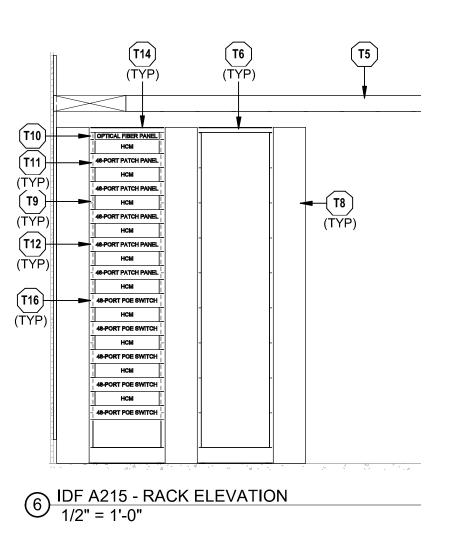

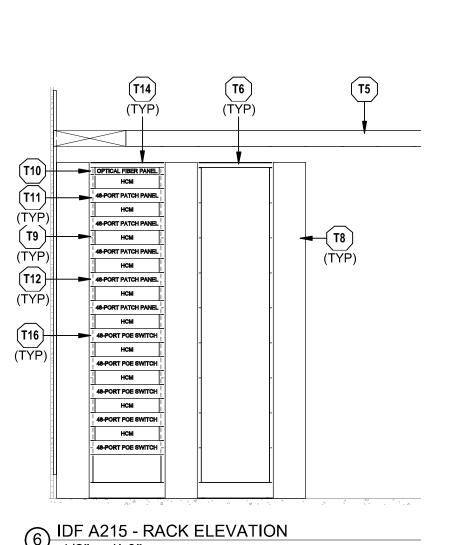

(T8)

3 IDF A115 - RACK ELEVATION 1/2" = 1'-0"

48-PORT PATCH PANEL

48-PORT PATCH PANEL


48-PORT PATCH PANEL


48-PORT POE SWITCH


48-PORT POE SWITCH

48-PORT POE SWITCH


48-PORT POE SWITCH

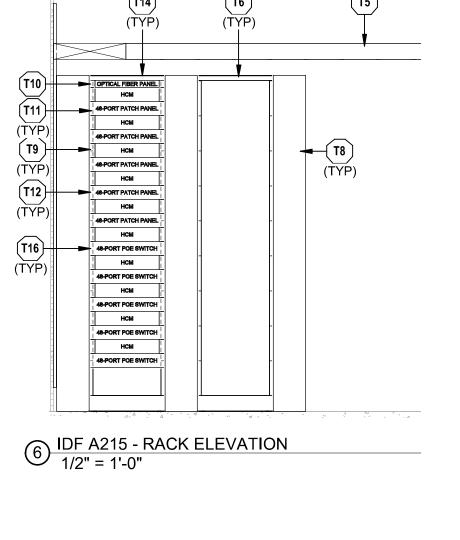

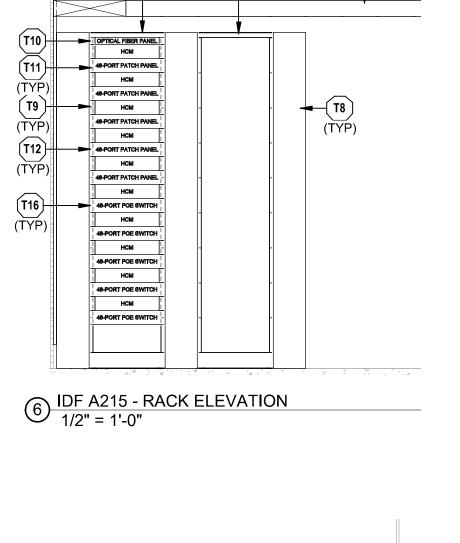

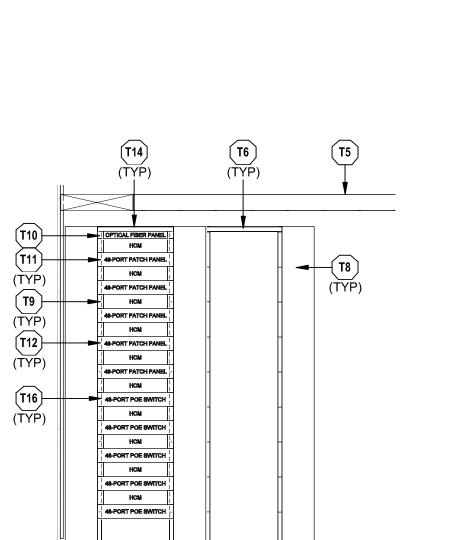

12 IDF C218 - RACK ELEVATION 1/2" = 1'-0"

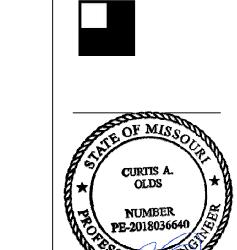

DATA OUTLETS SERVED BY TELECOM ROOM PLUS SPARES AS NOTED IN DIVISION 27 SPECIFICATIONS. T13 INSTALL OWNER FURNISHED UNINTERRUPTIBLE POWER T14 INSTALL OWNER FURNISHED VERTICAL POWER DISTRIBUTION UNIT ON BACK OF RACK.

T15 PROVIDE 4" CONDUIT SLEEVES. PROVIDE UL FIRESTOP SYSTEM ASSEMBLY AS REQUIRED. SEE DIVISION 27 SPECIFICATIONS FOR ADDITIONAL INFORMATION. T16 OWNER PROVIDED NETWORK SWITCH. T17 DATA OUTLET FOR SECURITY PANEL. COORDINATE

TECHNOLOGY PLAN NOTES:

T1 PROVIDE TELECOMMUNICATIONS MAIN GROUNDING BUS BAR (TMGB) MOUNTED AT 7'-0" AFF. SEE DIVISION 27 SPECIFICATIONS FOR ADDITIONAL INFORMATION. T2 PROVIDE TELECOMMUNICATIONS GROUNDING BUS BAR (TGB) MOUNTED AT 7'-0"AFF. SEE DIVISION 27 SPECIFICATIONS FOR ADDITIONAL INFORMATION. T3 PROVIDE TELECOMMUNICATIONS BACKBOARD. GRADE A/C 3/4" FIRE RATED PLYWOOD BACKBOARD (UNPAINTED) STARTING AT 4" AFF AND EXTEND UPWARDS 8'-0" ON ALL WALLS AS INDICATED ON DRAWINGS. THE A SIDE SHALL BE EXPOSED TO THE INTERIOR OF THE ROOM AND THE C SIDE PLACED AGAINST THE BUILDING STRUCTURE. SEE DIVISION 27 SPECIFICATIONS FOR ADDITIONAL INFORMATION. T5 PROVIDE 18" WIDE LADDER RACK WITH 9" RUNG SPACING. SEE DIVISION 27 SPECIFICATIONS FOR ADDITIONAL

T6 PROVIDE 2-POST EQUIPMENT RACK. SEE DIVISION 27 SPECIFICATIONS FOR ADDITIONAL INFORMATION. T7 PROVIDE 4-POST EQUIPMENT RACK. SEE DIVISION 27 SPECIFICATIONS FOR ADDITIONAL INFORMATION. T8 PROVIDE VERTICAL CABLE MANAGER. SEE DIVISION 27 SPECIFICATIONS FOR ADDITIONAL INFORMATION. T9 PROVIDE HORIZONTAL CABLE MANAGER. SEE DIVISION 27 SPECIFICATIONS FOR ADDITIONAL INFORMATION.

T10 PROVIDE OPTICAL FIBER PANEL. SEE DIVISION 27 SPECIFICATIONS FOR ADDITIONAL INFORMATION.

T11 PROVIDE 48-PORT CATEGORY 6A PATCH PANEL TO

NOTED IN DIVISION 27 SPECIFICATIONS.


SUPPORT WIRELESS ACCESS POINTS. PROVIDE QUANTITY


AS REQUIRED TO SUPPORT ALL CATEGORY 6A DATA OUTLETS SERVED BY TELECOM ROOM PLUS SPARES AS


T12 PROVIDE 48-PORT CATEGORY 6 PATCH PANEL. PROVIDE

QUANTITY AS REQUIRED TO SUPPORT ALL CATEGORY 6

MOUNTING HEIGHT AND EXACT REQUIREMENTS WITH SECURITY CONTRACTOR PRIOR TO ROUGH-IN. T23 SPACE RESERVED FOR INCOMING SERVICE PROVIDER EQUIPMENT.

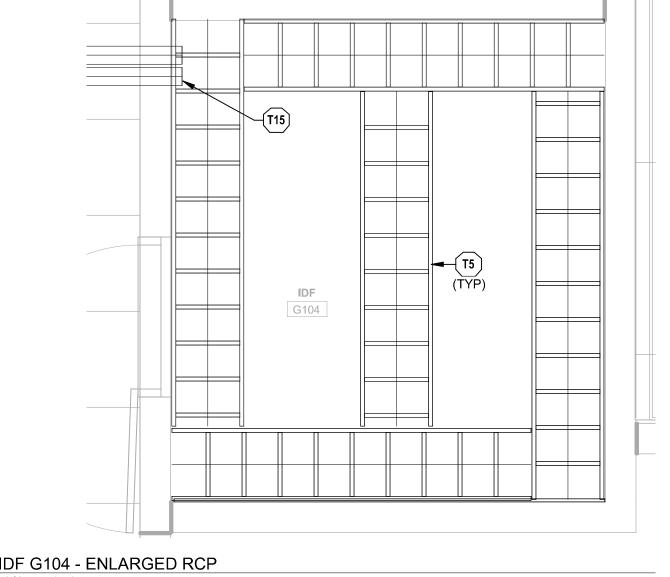


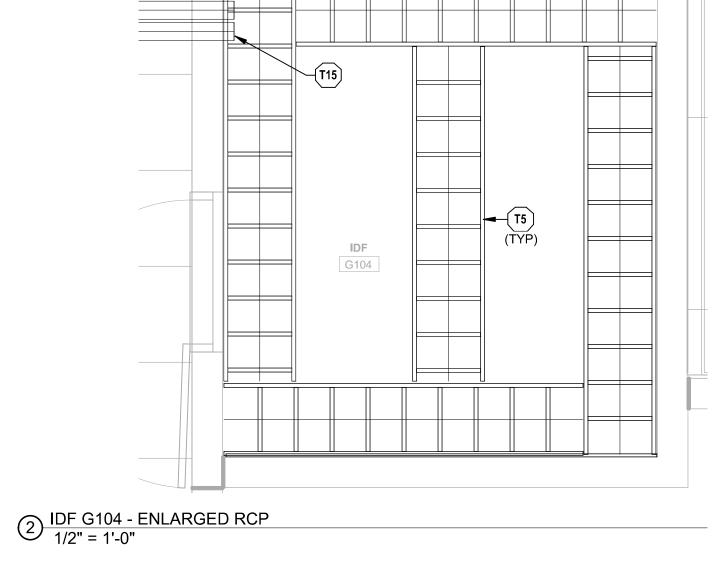


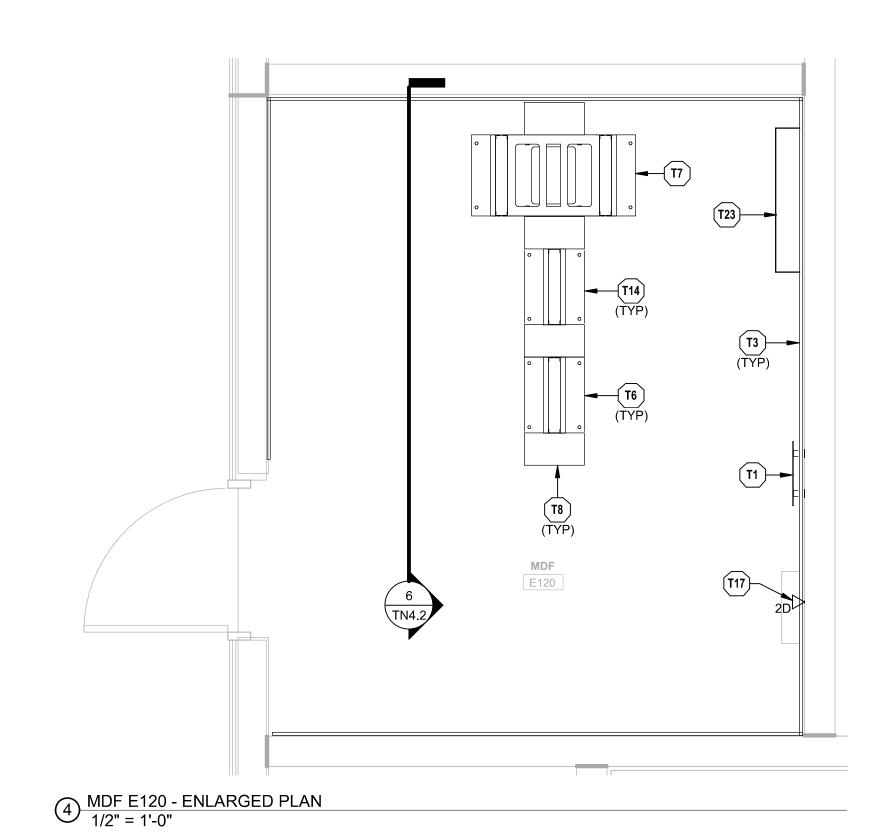

G104

1) IDF G104 - ENLARGED PLAN 1/2" = 1'-0"

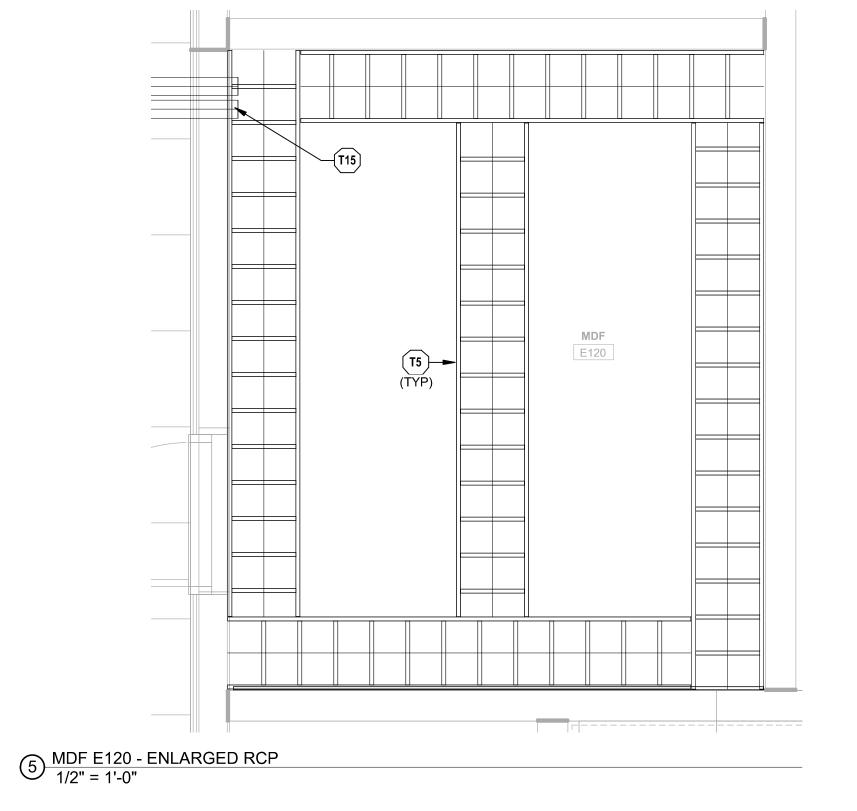

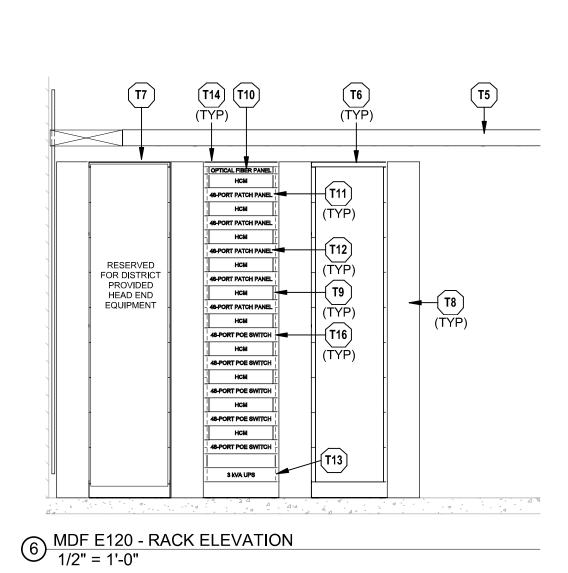

48-PORT PATCH PANEL

48-PORT PATCH PANEL

48-PORT PATCH PANEL


48-PORT PATCH PANEL

48-PORT POE SWITCH


3 IDF G104 - RACK ELEVATION 1/2" = 1'-0"

PACKAGE 3 - BUILDING & SITE 10/08/20 REVISIONS

13-20102-00 TECHNOLOGY ENLARGED PLANS

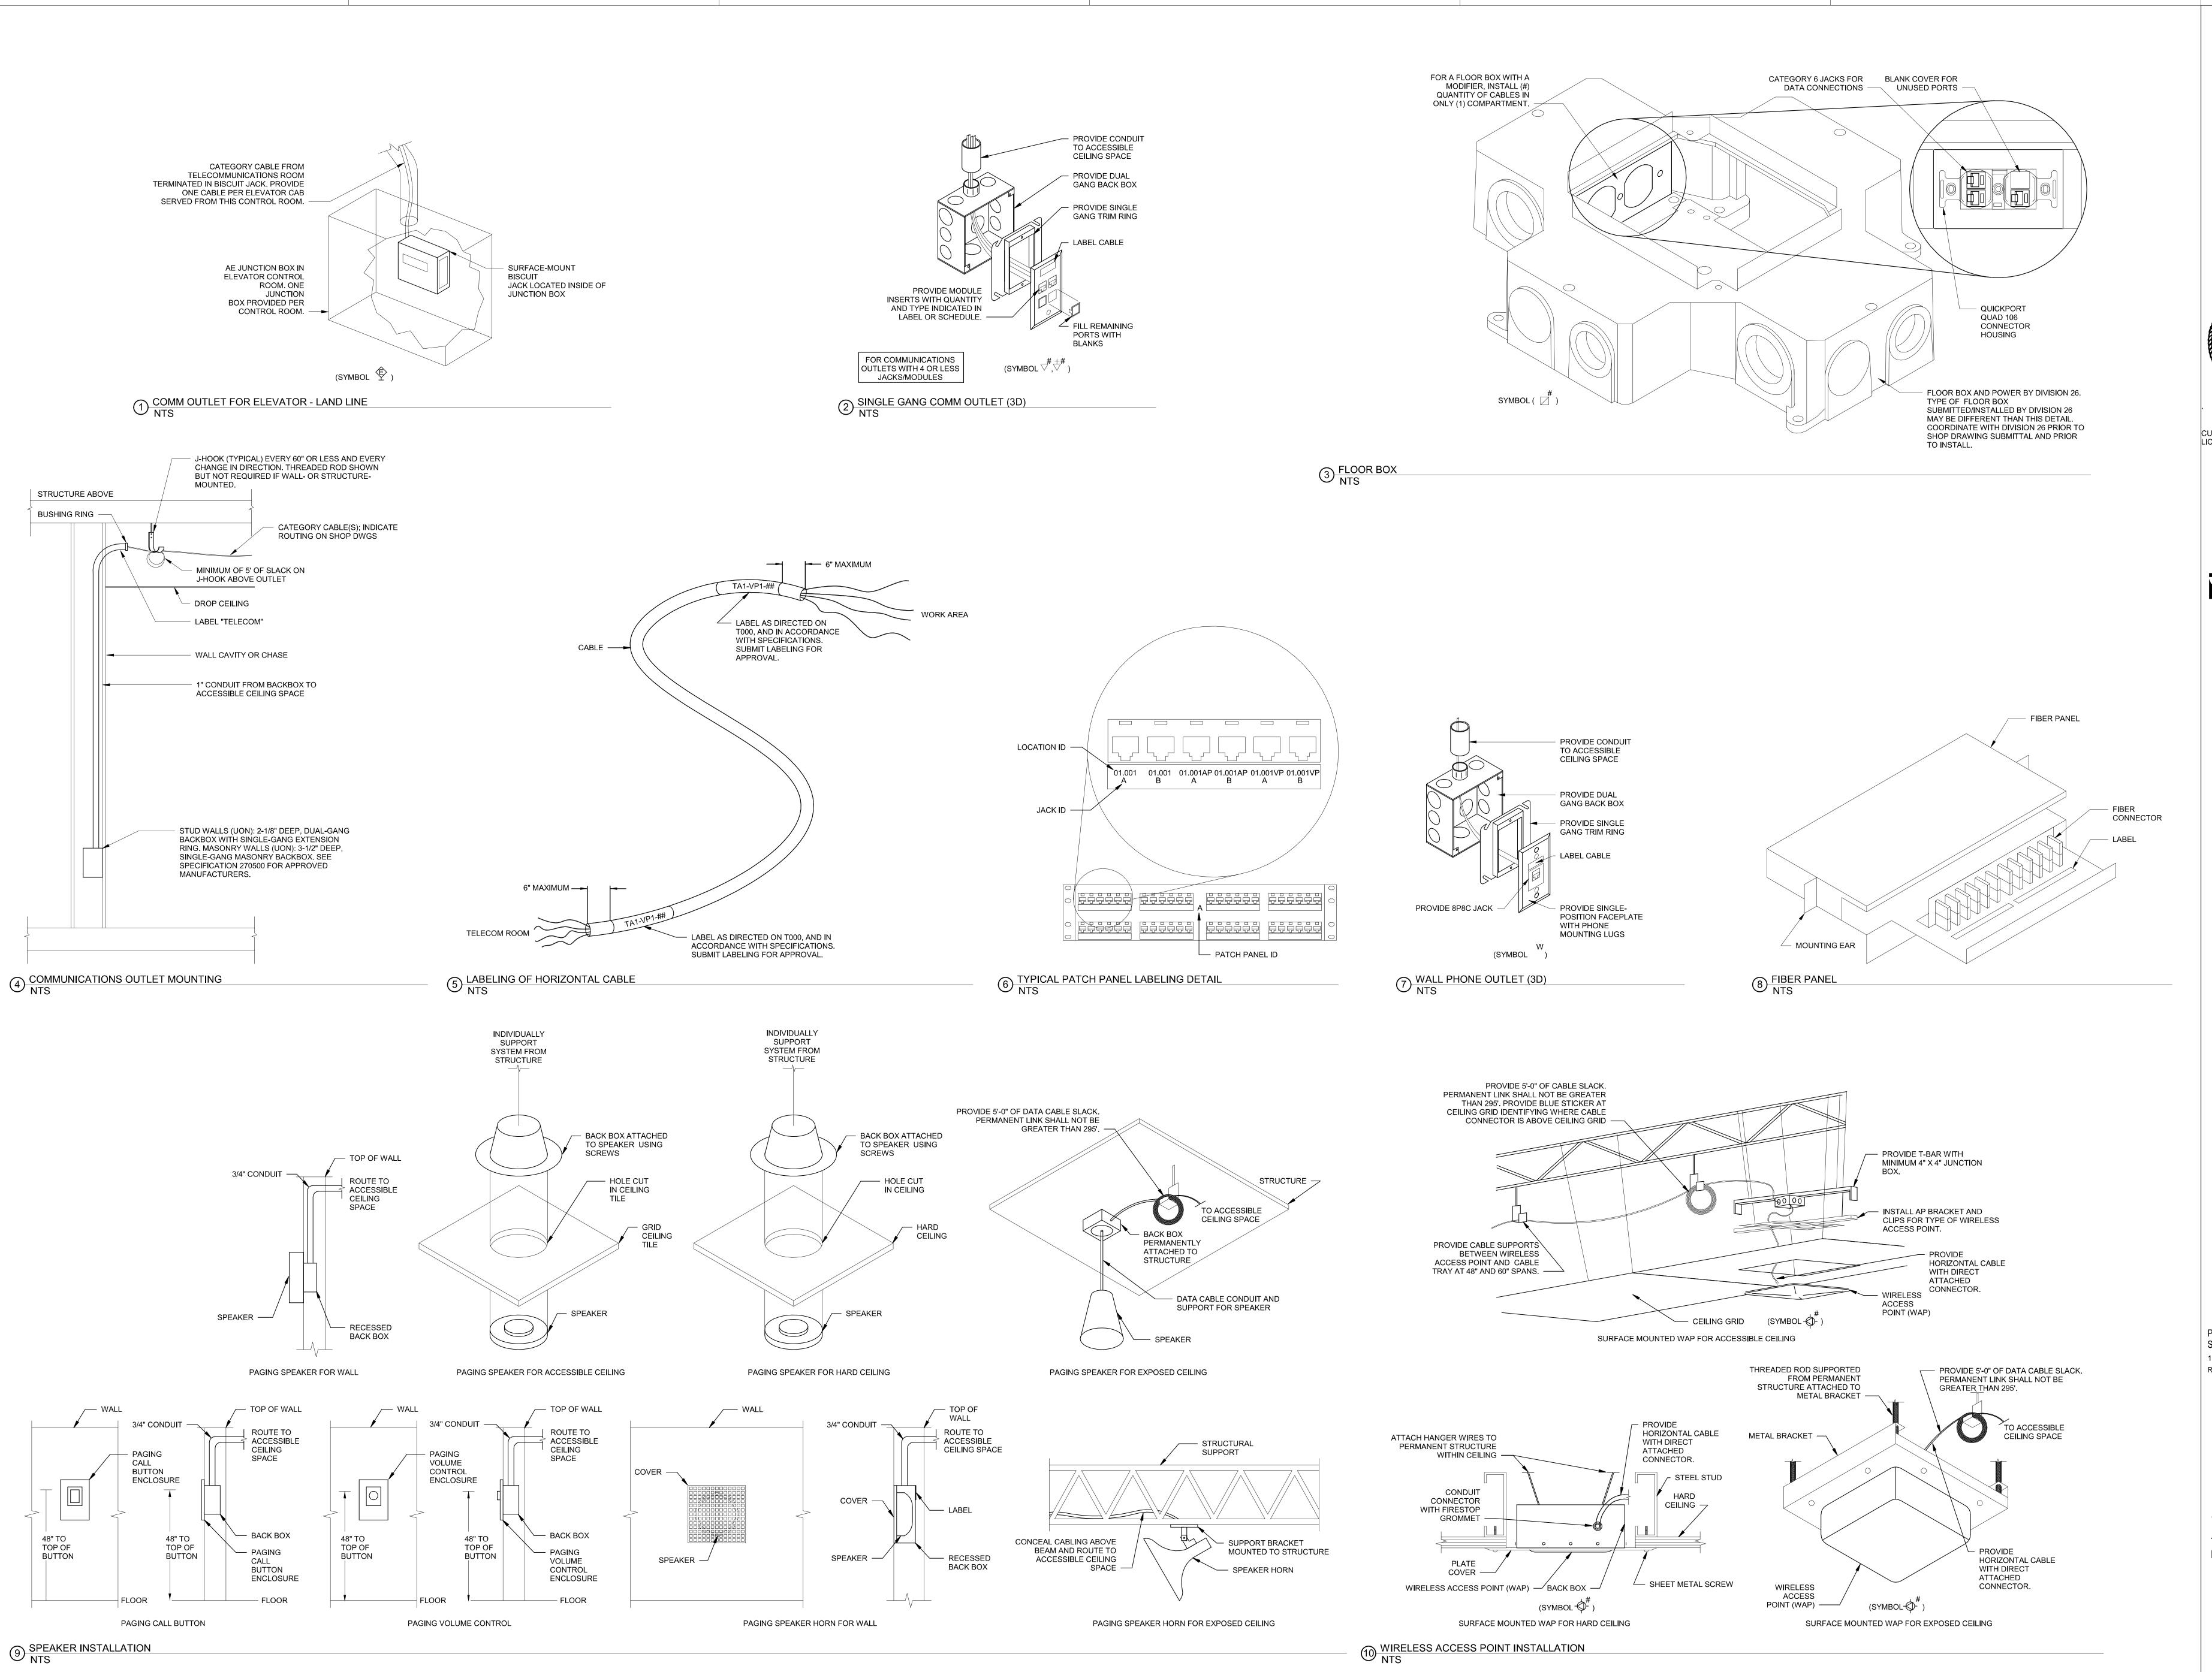

Grou

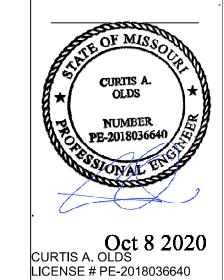

PACKAGE 3 - BUILDING & 10/08/20 REVISIONS

13-20102-00 TECHNOLOGY **DETAILS**

TN5.1

- GROUND WIRE CONTINUES THROUGH CONDUIT

- GROUND WIRE (MIN.


#6 AWG, UON)

— CONDUIT

PACKAGE 3 - BUILDING & 10/08/20 REVISIONS

13-20102-00 TECHNOLOGY DETAILS

TN5.2

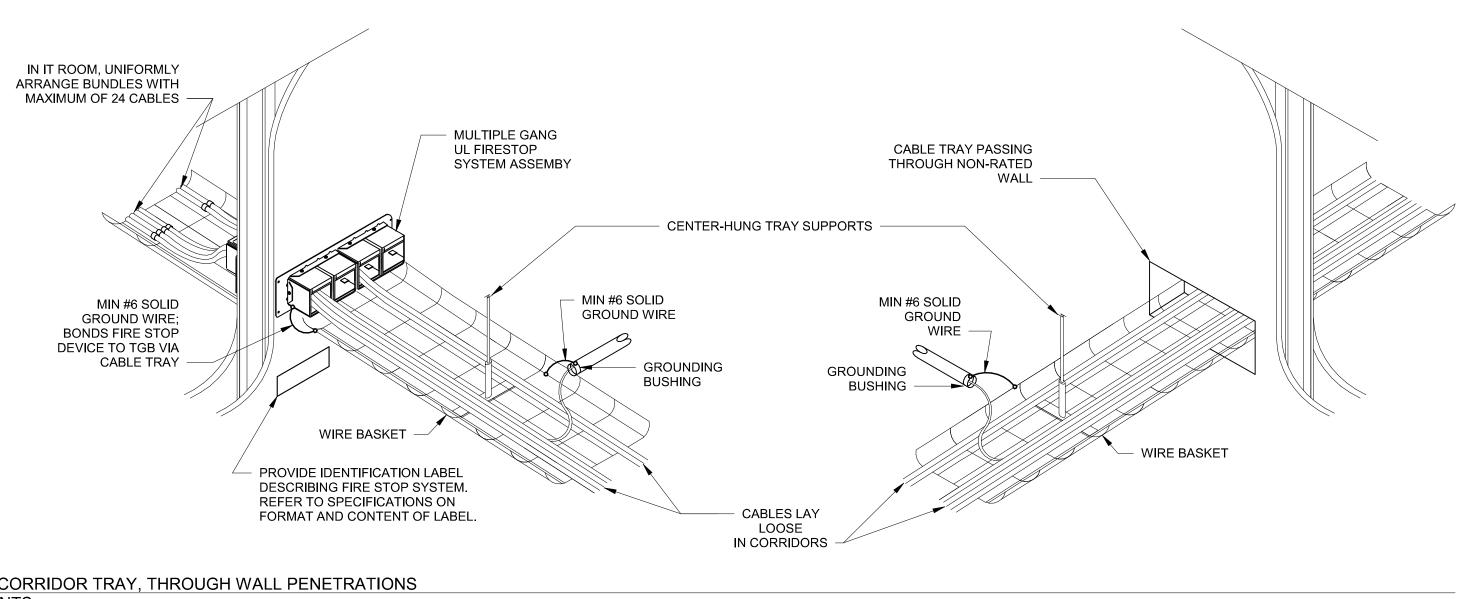

ORRIDOR TRAY, THROUGH WALL PENETRATIONS
NTS FIRESTOP LABEL - STRUCTURE HEAD ROOM REQ'D ABOVE TOP OF CABLE - THREADED ROD HORIZONTAL DIMENSION OF CABLE TRAY CARRIES. OUTER THREADED ROD IS TO BE PLACED ON OUTSIDE OF TRAY, EVERY 4 FT. (MIN) RADIUS DEVICE SHALL BE USED WHERE CABLE PATHWAY IS NOT PLACEMENT OF CABLE TRAY OR HORIZONTALLY IN LINE WITH CABLE AS OTHER TYPES OF IT EGRESSES FROM FIRE STOP DEVICE UL FIRE STOP SYSTEM ASSEMBLY, QUANTITIES AS REQUIRED TO TO CABLE PATHWAY SHALL NOT BLOCK ACCESS TO LAY-IN CEILING OTHER FIRE / MECHANICAL / ELECTRICAL OR PLUMBING MAINTAIN FILL RATIO -DEVICES SUCH AS (BUT NOT LIMITED TO) VAV BÒXES, AIR DISTRIBUTION PANELS, FIRE ALARM PANELS, ELECTRICAL PANELS, ETC. VERTICALLY MOUNTED - HOOK AND LADDER RACK -WALL -LOOP STRAPS `— WALL CORRIDOR HORIZONTALLY MOUNTED LADDER RACK

3 TECHNOLOGY PATHWAY CLEARANCES NTS

HORIZONTAL PERMANENT LINK CABLE IN TRAY
AT EACH WORK AREA OUTLET. — TELECOMMUNICATIONS PATHWAYS 4 TECHNOLOGY PATHWAY GROUND AND BOND CONNECT NTS

CONDUIT SLEEVES

(TYPICAL)

PROVIDE TBB TO EXISTING USE APPROPRIATE BONDING STRAPS OR FITTINGS LISTED FOR USE APPROPRIATE LISTED TELECOMMUNICATIONS GROUNDING AND GROUNDING LUGS TO MAKE
CONNECTIONS — BOND SYSTEM. FOLLOW TIA-607-C APPROPRIATE USE BETWEEN SECTIONS AND JUNCTIONS IN TECHNOLOGY RACEWAY MINIMUM #6 AWG BONDING CONDUCTOR FOR LADDER RACKING -MINIMUM #6 AWB BONDING CONDUCTOR FOR LADDER RACK ARMORED MINIMUM #6 AWG BONDING CONDUCTOR FOR OPTICAL FIBER (BACKBONE) -----**EQUIPMENT** RACKS/CABINETS/FRAMES COMPRESSION TYPE TWO HOLE LUG CONNECTOR (TYPICAL) TGB TELECOMMUNICATIONS GROUNDING BUS BAR (TGB) INSULATED FROM SUPPORT AT MINIMUM 2" FROM WALL PROVIDE NAMEPLATE MINIMUM #6 AWG BONDING CONDUCTORS TO CABLE

BRACKET

- GROUNDING LUG

#6 AWG, UON)

INDEPENDENTLY GROUND EACH CONDUIT TO CABLE

- GROUND WIRE (MIN.

TRAY. (MIN. #6 AWG) —

GROUNDING LUG

- MOUNTING HARDWARE

(MAY VARY FROM

SHOWN)

— WIRE MESH STYLE BASKET CABLE TRAY

GROUND WIRE (MIN.

CABLE TRAY DIVIDER (AS REQUIRED)

#6 AWG, ÙON)

GROUNDING LUG

#6 AWG, UON)

GROUNDING LUG

GROUND WIRE (MIN.


WIRE (MIN. #6 AWG,


EMT CONDUIT TO

WORK AREA OUTLET -

ÙON)

PROVIDE ONE FOOT SERVICE LOOP OF

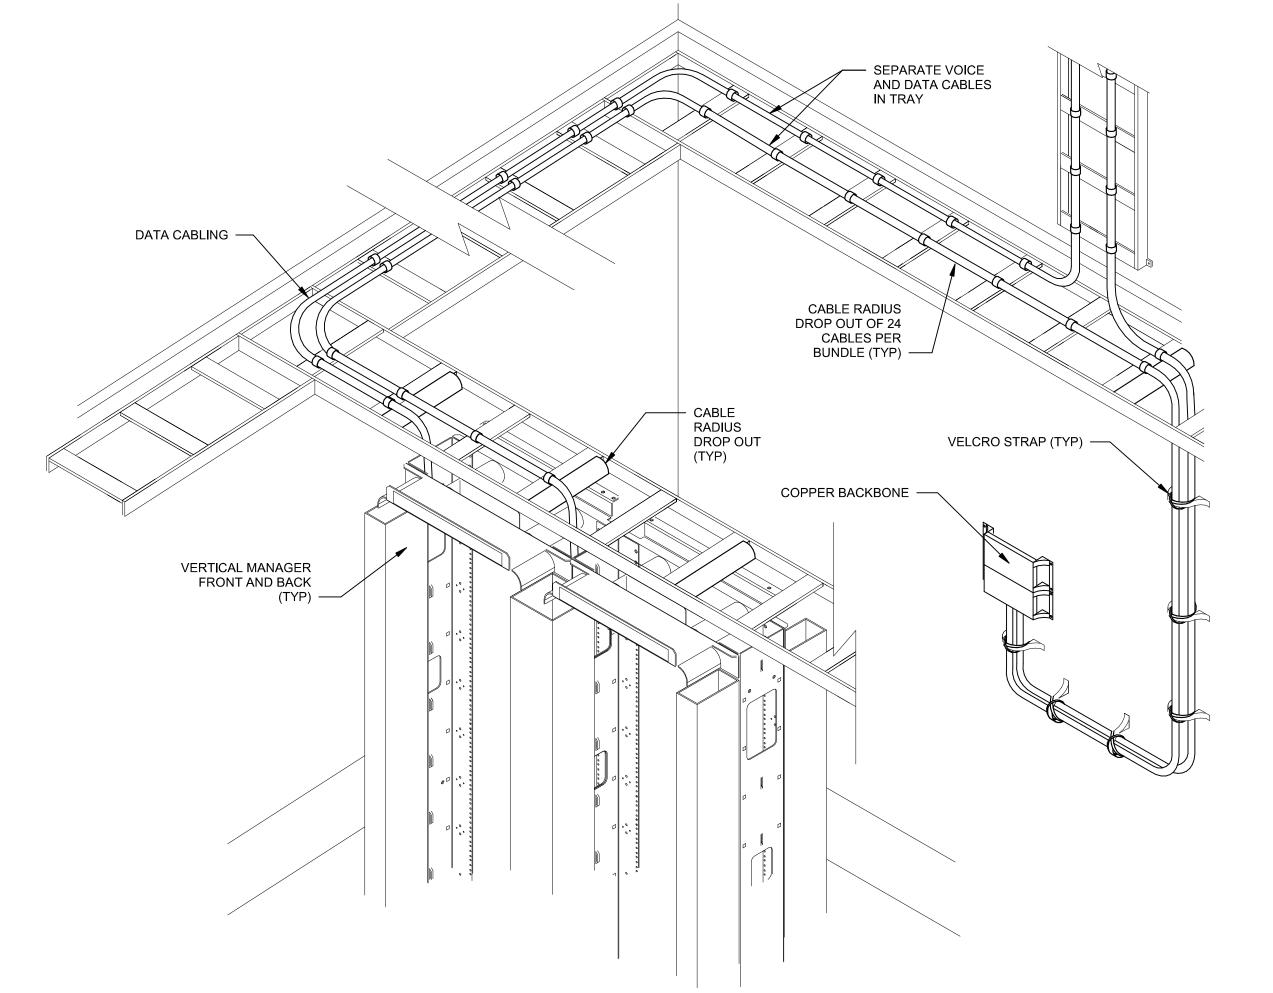

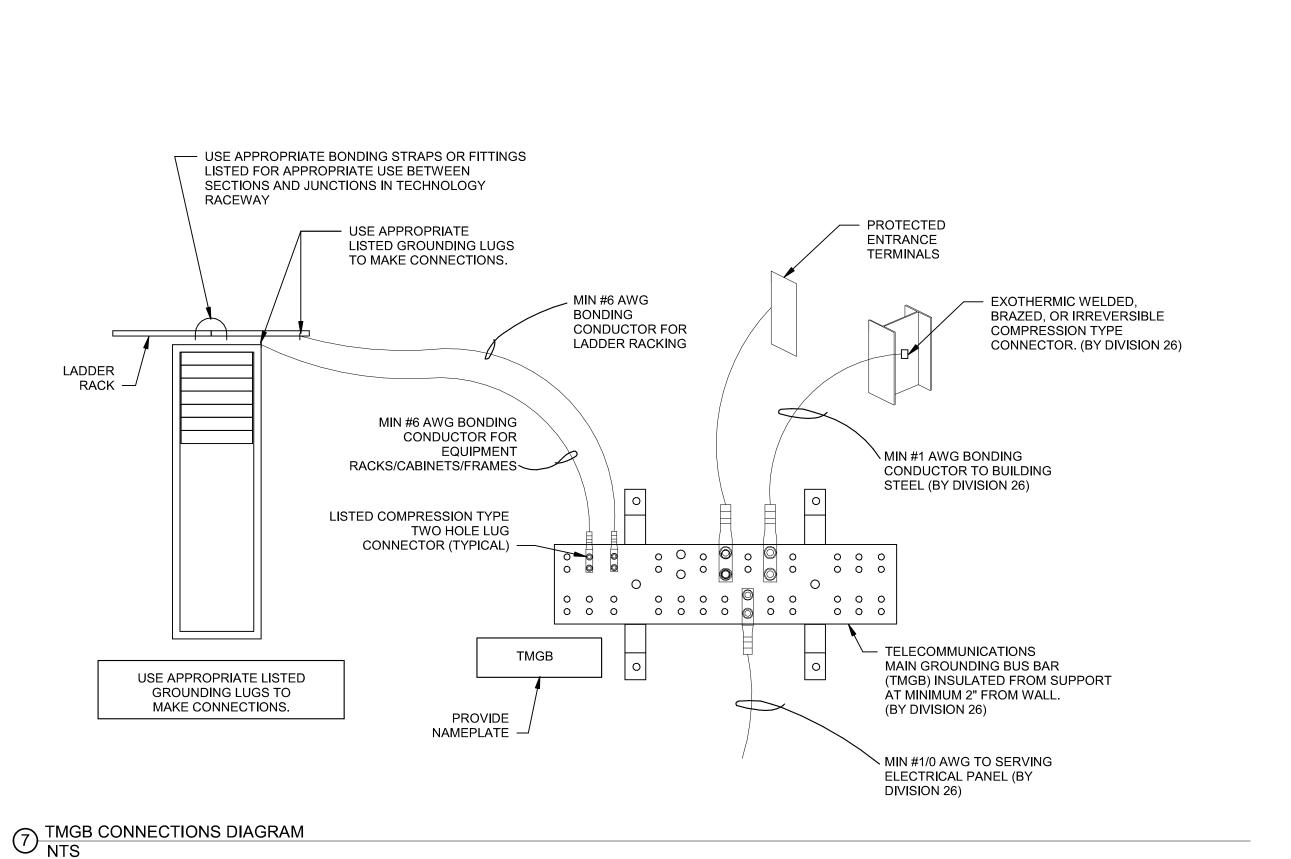

5 TELECOM ROOM TRAY ALIGNMENT, BEND RADIUS TREATMENT NTS

REVISIONS

TN6.1

