


Plan Scope/Notes:

- 1: Electrical**
- A. Add Outlet To Wall As Marked
 - B. Add Dedicated 20 AMP Circuit Outlet As Marked
 - C. Add GFCI Outlets As Marked
 - D. Add (1) Low Outlet- (1) Higher Outlet as Marked-24" & 72" Off Floor
- 2: Plumbing**
- A. New Plumbing Fixtures-Use existing Pipes and Drains in Current Location
 - B. Add Grease Interceptor To Sink In-LineDrain
 - C. Add New Stools To Bathroom-Use Existing Drain Locations
 - D. Add Mop Sink-Use existing Drain Locations

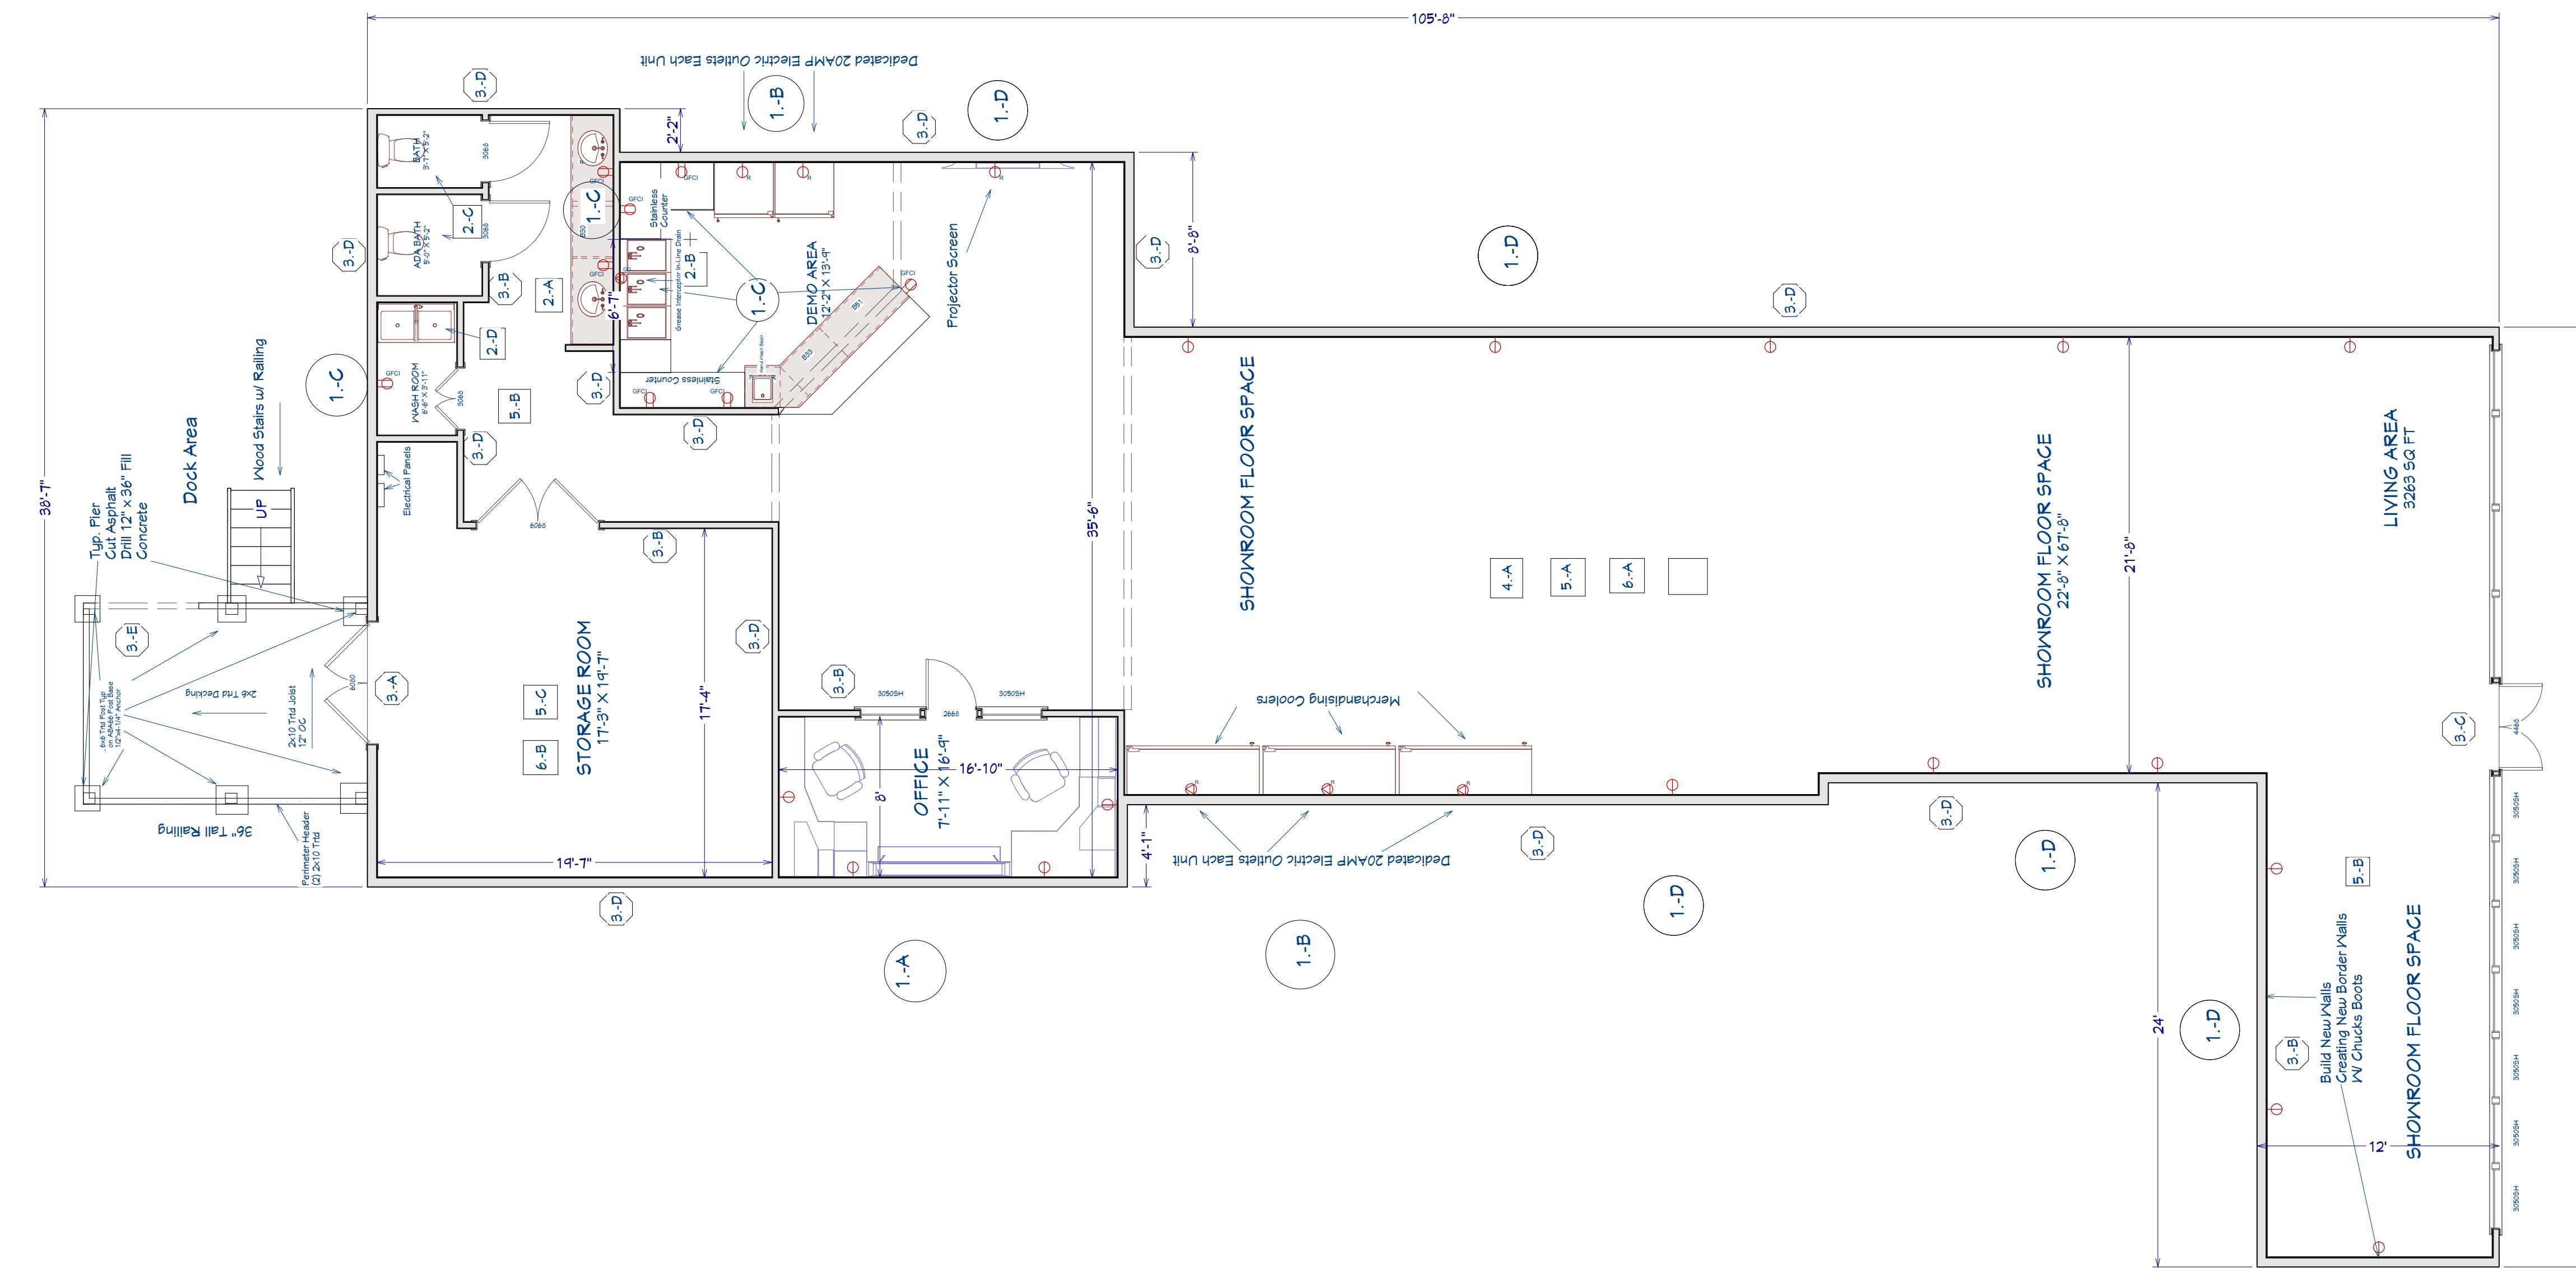

Working Plan View

DRAWINGS PROVIDED BY: OnPoint Home Design & Contracting LLC Archie, MO 64125	DATE: 12/16/2020	SCALE: 1:100	SHEET: 1
--	---------------------	-----------------	-------------

**American BBQ Store
340 SW Blue Pkwy
Lees Summit, MO, 64086**

NUMBER	DATE	REVISION	TABLE	REVISED BY	DESCRIPTION