


INTERIOR REMODEL

LEE'S SUMMIT KCUC UROLOGY & ONCOLOGY

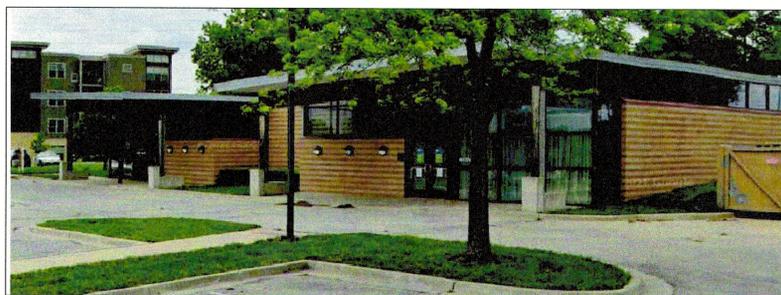

451 NW MURRAY ROAD
LEE'S SUMMIT, MISSOURI 64081
JACKSON COUNTY


ARCHITECTURAL DRAWING LEGEND

DETAIL NO. ##	ELEVATION BUBBLE	#	WINDOW TYPE. RE: A700	##	CEILING HEIGHT. RE: A-201
SHEET NO. ##		###	ROOM NUMBER	100.0'	ELEVATION DATUM
DETAIL NO. ##	DETAIL REFERENCE BUBBLE	#	SHEET NOTE	#	WALL TYPE. RE: A-1.0
SHEET NO. ##		#		#	DOOR NUMBER
#	REVISION NUMBER				

ARCHITECTURAL DRAWING ABBREVIATIONS

A/C	AIR CONDITIONING	EA	EACH EXPANSION JOINT	JB	JUNCTION BOX	REQ	REQUIRED
AB	ANCHOR BOLT	EJ	ELECTRIC/ELECTRICAL	JT	JOIST	RM	ROOM
AC	ACOUSTICAL	EL	ELEVATION	JST	JOINT	RO	ROUGH OPENING
ACT	ACCOUSTICAL TILE	EMERG	EMERGENCY	L	LENGTH	ROW	RIGHT OF WAY
AGG	ABOVE FINISHED	ENCL	ENCLOSURE	LAV	LAVATORY	RTU	ROOF TOP UNIT
AGG	AGGREGATE	ENT	ENTRANCE	LT	LIGHT	RV	ROOF VENT
ALT	ALTERNATE	EQ	ELECTRICAL PANEL	LVL	LEVEL	SCHED	SCHEDULE
ALUM	ALUMINUM	EQ	EQUAL EQUIPMENT	MAT	MATERIAL	SECT	SECTION
ANOD	ANODIZED	EQ	EQUAL EQUIPMENT	MAS	MASONRY	SE	SQUARE FEET
APPROX	APPROXIMATELY	EW	EACH WAY	MAX	MAXIMUM	SHT	SHEET
ARCH	ARCHITECTURAL	EXH	EXHAUST	MECH	MECHANICAL	SIM	SIMILAR
ASPH	ASPHALT	EXP	EXPANSION	MEMB	MEMBRANE	SPEC	SPECIFICATION
AVG	AVERAGE	EXT	EXTERIOR	MTL	METAL	SPK	SPEAKER
BD	BOARD	FD	FLOOR DRAIN	MFR	MANUFACTURER /	SQ	SQUARE
B.F.F.	BELOW FINISHED	FDN	FOUNDATION	MANUFACTURING	STD	STAINLESS STEEL	
BIT	BITUMINOUS	FFE	FINISHED FLOOR	MIN	MINIMUM	STD	STANDARD
BKR	BREAKER	FLR	FLOOR	MISC	MISCELLANEOUS	STL	STEEL
BULD	BUILDING	FLSH	FLASHING	MO	MASONRY OPENING	STRUC	STRUCTURAL
BM	BEAM	FLUR	FLOURESCENT	NIC	NOT IN CONTRACT	SUP	SUPPLY
BRG	BEARING	FMS	FACE OF STUD	NGM	NOMINAL	SUSP	SUSPEND
BTU	BRITISH THERMAL UNIT	F.R.	FIRE RATE / RESISTANT	NTS	NOT TO SCALE	TH	THERMOSTAT
CCT	CIRCUIT	FRP	FIBERGLASS	OA	OVERALL	THK	TEMPORARY
CEM	CEMENT	FRP	REINFORCED PLASTIC	OC	ON CENTER	THK	THICK
CFM	CUBIC FEET/MINUTE	FT	FOOT	OD	OUTSIDE DIAMETER	THRES	THRESHOLD
CJ	CONTROL JOINT	FTG	FOOTING	OFF	OFFICE	TYP	TYPICAL
CLG	CEILING	FUR	FURRING	OH	OVERHEAD	UC	UNDERCUT
CLR	CLEAR	OPNG	OPENING	OPNG	OPENS	UL	UNDERWRITER
CMU	CONCRETE MASONRY	OPP HND	OPPOSITE HAND	OPP HND	OPPOSITE HAND	UNO	UNLESS NOTED
CNDT	UNIT	GA	GALLON	P	POLE	UR	URINAL
CO	CLEAN OUT	GALV	GALVANIZED	PL	PLATE	UTIL	UTILITIES
COL	COLUMN	GEN	GENERAL	PLG	PLUMBING	V	VOLT
CONC	CONCRETE	GND	GROUND	PLYWD	PLYWOOD	VB	VAPOR BARRIER
COND	CONDENSATE	GRD	GRADE	PNL	PANEL	VERT	VERTICLE
CONN	CONNECTION	GWB	GYPSSUM WALL BOARD	PR	PAIR	VEST	VESTIBULE
CONSTR	CONSTRUCTION	GYP	GYPSSUM	PRFAB	PREFABRICATED	VOL	VOLUME
CONT	CONTINUOUS	HDR	HARDWARE	PSF	POUNDS/SQUARE FOOT	VTR	VENT THROUGH ROOF
CT	CERAMIC TILE	HGT	HEIGHT	PSI	POUNDS/SQUARE INCH	W	WITH
CS	COLD WATER	HORZ	HORIZONTAL	PT	PAINT	WC	WATER CLOSET
OW		HDWR	HARDWARE	FVC	POLYVINYL CHLORIDE	WD	WOOD
		HGT	HEIGHT	Q	QUARRY TILE	WDW	WINDOW
DBL	DOUBLE	HR	HOUR	R	RADIUS	WH	WATER HEATER
DEPT	DEPARTMENT	HRZ	HORIZONTAL	RIS	RISER	WP	WEATHER RESISTANT BARRIER
DIA	DIAMETER	HTR	HEATER	RRA	RETURN AIR	WRB	WEATHER RESISTANT BARRIER
DIM	DIMENSION	HTG	HEATING	RCT	RECEPTACLE	WSCOT	WANSICOT
DISC	DISCONNECT	HTR	HEATER	RD	ROOF DRAIN	WT	WEIGHT
DN	DOWN	HW	HOT WATER	REC	RECESSED	WWF	WELDED WIRE FABRIC
DR	DOOR	ID	INSIDE DIAMETER	REF	REFERENCE	YD	YARD
DS	DOWNSPOUT	IN	INCHES	REG	REGISTER		
DTL	DETAIL	INSUL	INSULATION	REIN	REINFORCING		
		INT	INTERIOR				

VICINITY MAP

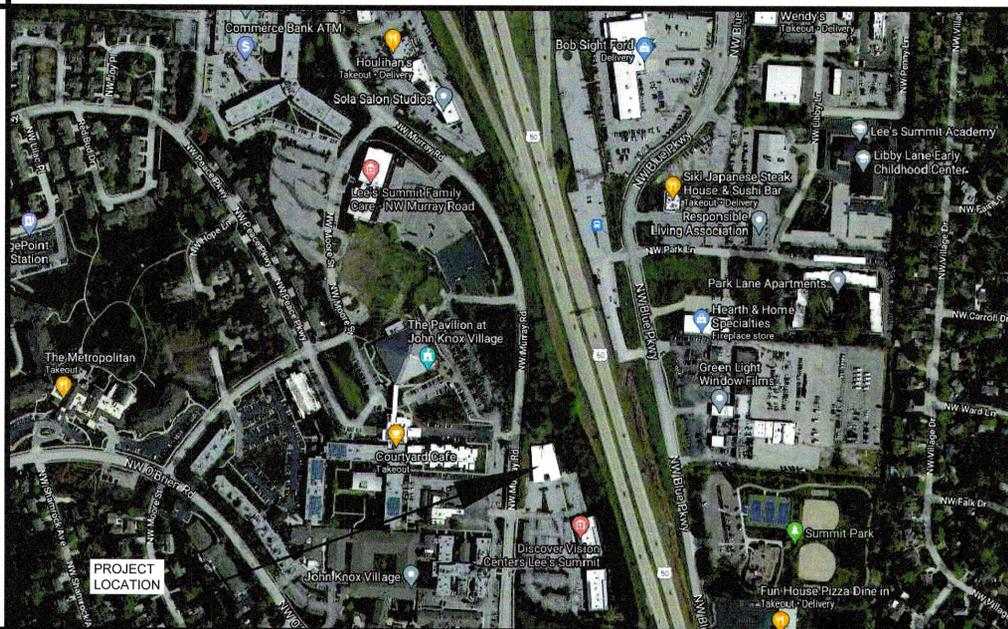

PROJECT TEAM

ARCHITECTURE

NOLTE ASSOCIATES, ARCHITECTS
9400 REEDS ROAD, SUITE 200
OVERLAND PARK, KS 66207
TEL.: (913) 322-2444 FAX.: (913) 322-6277

OWNER

KCUC
KCUC

PME

ARCHITECTURAL ENGINEERING CONSORTIUM

GREG GLADFELTER
11032 S. GREEN ROAD
OLATHE, KANSAS 66061
(816) 916-4675
GPG@AECONSORT.COM

DRAWING INDEX

G-001 COVER SHEET
G-101 CODE REVIEW

ARCHITECTURAL

AD-101 DEMOLITION PLAN
A-101 FIRST FLOOR PLAN
A-102 ENLARGED FLOOR PLANS
A-401 INTERIOR ELEVATIONS
A-402 INTERIOR ELEVATIONS
A-403 INTERIOR ELEVATIONS
A-404 INTERIOR ELEVATIONS
A-601 DOORS, DOOR SCHEDULES AND DETAILS
A-602 FINISH SCHEDULES

PME

MP-300 MECHANICAL PLUMBING DETAILS
P-100 PLUMBING PLAN
M-100 MECHANICAL FLOOR PLAN
E-100 POWER FLOOR PLAN
E-101 LIGHTING FLOOR PLAN
E-300 ELECTRICAL SCHEDULE AND NOTES



NOLTE & ASSOCIATES, P.A.
ARCHITECTS & PLANNERS
9400 REEDS ROAD, SUITE 200
OVERLAND PARK, KANSAS 66207
(913) 322-2444
FAX (913) 322-6277



Copyright © 2021

REMODEL LEE'S SUMMIT KCUC UROLOGY & ONCOLOGY

451 NW MURRAY ROAD
LEE'S SUMMIT, MISSOURI 64081
JACKSON COUNTY

DATE PRINTED:
Oct 13, 2021

DATE ISSUED:
10.13.2021

REVISIONS:

ARCHITECTURAL PROJECT NUMBER
2021027


COVER SHEET

SHEET NUMBER
G-001

PROJECT ISSUANCE

ISSUED FOR: _____ DATE ISSUED: _____
 PERMIT REVIEW _____
 CITY REVISIONS _____
 CITY REVISIONS _____
 CONSTRUCTION _____

Drawing Name: F:\2021\2021027 - Jayger - KCUC Lee's Summit\Production\04 - Construction Documents\2021\2021-AD-101 DEMO FLOOR PLAN.dwg Last Modified: Oct 08, 2021 - 10:28am Plotted on: Oct 13, 2021 - 9:54am by mwinslow

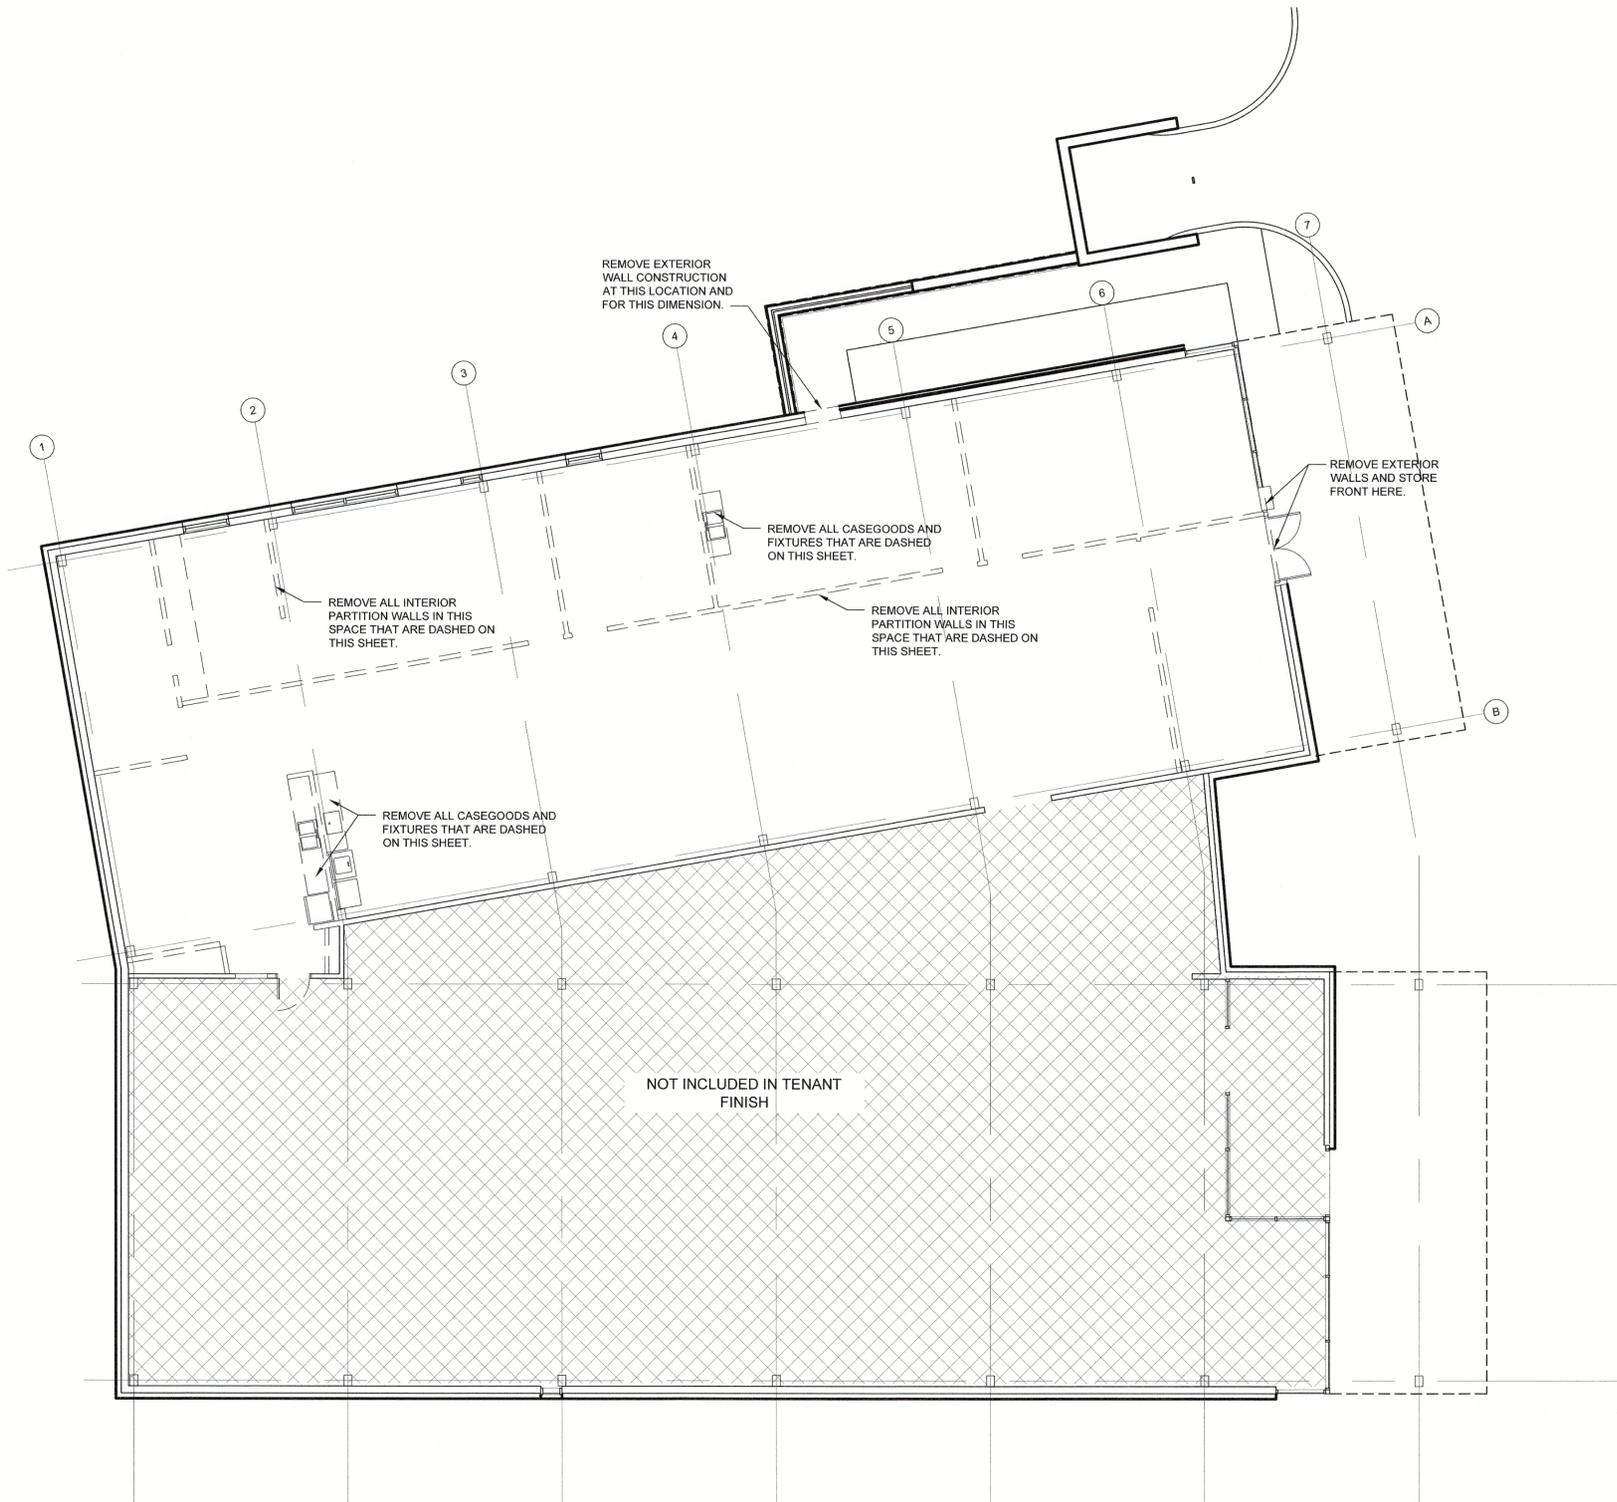

GENERAL DEMOLITION NOTES

1. SELECTIVE DEMOLITION TO BE PERFORMED CAREFULLY AND IN A MANNER TO PROTECT ADJACENT FINISHES TO BE PRESERVED.
2. COORDINATE ALL DEMOLITION/PHASING EFFORTS WITH THE ARCHITECT & OWNER'S REPRESENTATIVE PRIOR TO COMMENCING THE WORK.
3. COORDINATE ALL EXCESSIVE NOISE, VIBRATION & PRE-APPROVED SERVICE DISRUPTION WITH THE OWNER'S REPRESENTATIVE PRIOR TO COMMENCING THE WORK.
4. CONSTRUCT & MAINTAIN TEMPORARY PARTITIONS AS REQUIRED TO ISOLATE DEMOLITION WORK FROM GENERAL PUBLIC & TENANTS AS DEEMED NECESSARY FROM OWNER'S REPRESENTATIVE.
5. COORDINATE WITH OWNER'S REPRESENTATIVE TO MAINTAIN THE MEANS OF EGRESS & BUILDING SECURITY (IF APPLICABLE) DURING DEMOLITION/CONSTRUCTION WORK.
6. MAINTAIN SECURE, WEATHER-TIGHT ENCLOSURE WHERE WORK IS TO OCCUR ON THE EXTERIOR OF THE BUILDING (IF APPLICABLE) AS COORDINATED WITH OWNER'S REPRESENTATIVE.
7. VERIFY ALL EXISTING CONDITIONS, DIMENSIONS, ELEVATIONS AND NOTIFY ARCHITECT/ENGINEER WITH ANY DISCREPANCIES PRIOR TO COMMENCING DEMOLITION WORK.
8. REMOVE ALL DEMOLITION MATERIALS IN THEIR ENTIRETY FROM THE JOBSITE & LEGALLY DISPOSE OF MATERIALS UNLESS NOTED OTHERWISE. THE OWNER SHALL RESERVE THE RIGHT TO SALVAGE ANY MATERIALS.
9. PROVIDE PROTECTION FOR ALL EXISTING MATERIALS & EQUIPMENT FROM DAMAGE DUE TO ANY DEMOLITION WORK. REPAIR OR REPLACE ANY WALLS, FLOORS, CEILINGS, EQUIPMENT, ETC. DAMAGED DURING DEMOLITION WORK.
10. THE CONTRACTOR SHALL COORDINATE WITH THE ARCHITECT & OWNER'S REPRESENTATIVE ANY MATERIALS TO BE REUSED & WILL BE RESPONSIBLE FOR VERIFYING & MAINTAINING THE FUNCTIONAL & AESTHETIC INTEGRITY OF THE MATERIALS FOR REUSE.
11. REMOVE ELECTRICAL COMPONENTS SHOWN FOR DEMOLITION TO THE NEAREST J-BOX AND CAP OFF BEHIND FINISHED CONSTRUCTION AS REQUIRED.
12. REMOVE MECHANICAL COMPONENTS SHOWN FOR DEMOLITION AND CAP OFF BEHIND FINISHED CONSTRUCTION AS REQUIRED. PATCH, REPAIR & FINISH ADJACENT FINISHES AS REQUIRED.
13. REFER TO MECHANICAL, PLUMBING & ELECTRICAL DRAWINGS, NOTES & SPECIFICATIONS FOR FURTHER SEQUENCING & SCOPE OF WORK.
14. THE DEMOLITION PLAN IS PROVIDED TO DEFINE THE GENERAL SCOPE OF WORK. CONTRACTOR IS RESPONSIBLE FOR ALL DEMOLITION WORK NECESSARY TO PERFORM NEW CONSTRUCTION WORK REQUIREMENTS.
15. CONTRACTOR TO REFER TO STRUCTURAL DRAWINGS FOR ANY DEMOLITION WORK TO STRUCTURAL ELEMENTS. CONTRACTOR TO VERIFY EXISTING CONDITIONS TO INSURE NO DEMOLITION WILL ENDANGER STRUCTURAL INTEGRITY OF BUILDING. PROVIDE THE NECESSARY SHORING OF STRUCTURE AS REQUIRED TO MAINTAIN STRUCTURAL INTEGRITY OF BUILDING.
16. IF HAZARDOUS MATERIALS ARE ENCOUNTERED DURING DEMOLITION COMPLY WITH APPLICABLE REGULATIONS, LAWS & ORDINANCES CONCERNING REMOVAL, HANDLING & PROTECTION AGAINST EXPOSURE OF ENVIRONMENTAL POLLUTION.

1 FLOOR PLAN
SCALE: 1/8"=1'-0"



NOLTE & ASSOCIATES, P. A.
ARCHITECTS / PLANNERS
9400 REEDS ROAD, SUITE 200
OVERLAND PARK, KANSAS 66207
(913) 322-2444
FAX (913) 322-6277



Copyright © 2021

REMODEL
LEE'S SUMMIT
KCUC UROLOGY & ONCOLOGY
451 NW MURRAY ROAD
LEE'S SUMMIT, MISSOURI 64081
JACKSON COUNTY

This material is confidential, proprietary and owned solely by Nolte & Associates, P.A. By providing these documents, Nolte & Associates, P.A. assumes no responsibility for their accuracy, construction and planning or information contained therein. Do not modify, duplicate, reproduce, distribute or transfer this material without the express written permission of Nolte & Associates, P.A.

DATE PRINTED:
Oct 13, 2021

DATE ISSUED:
10.13.2021


REVISIONS:
▲
▲
▲
▲
▲

ARCHITECTURAL PROJECT NUMBER
2021027


DEMOLITION
FLOOR
PLAN

SHEET NUMBER


AD-101

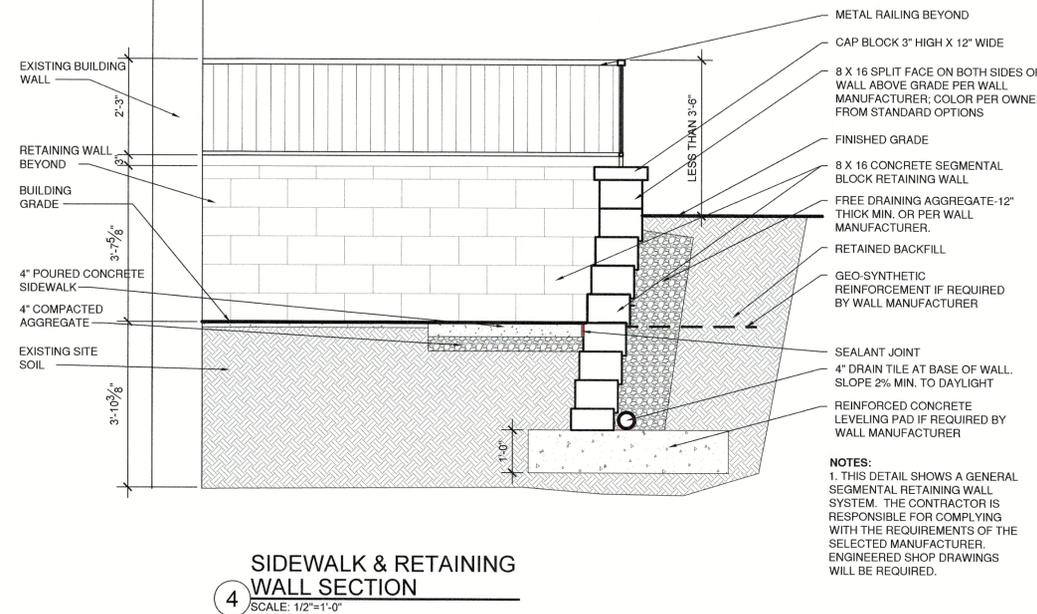


4 SIDEWALK & RETAINING WALL SECTION
SCALE: 1/2"=1'-0"

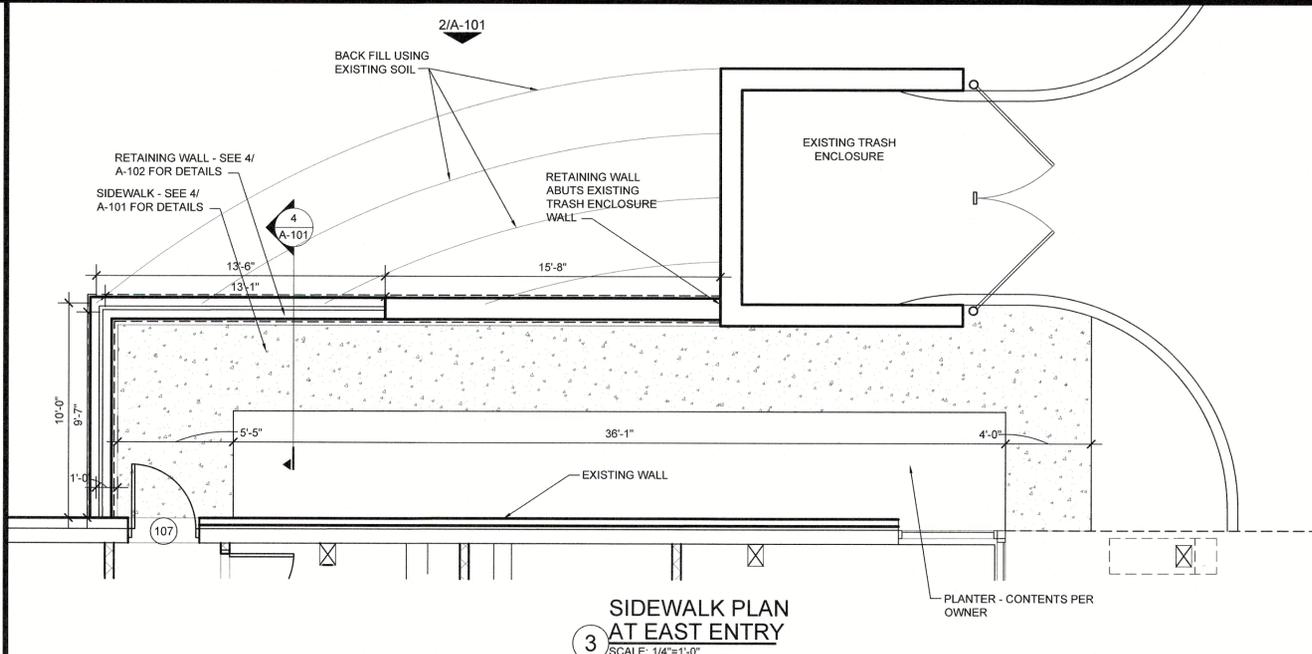

3 SIDEWALK PLAN AT EAST ENTRY
SCALE: 1/4"=1'-0"

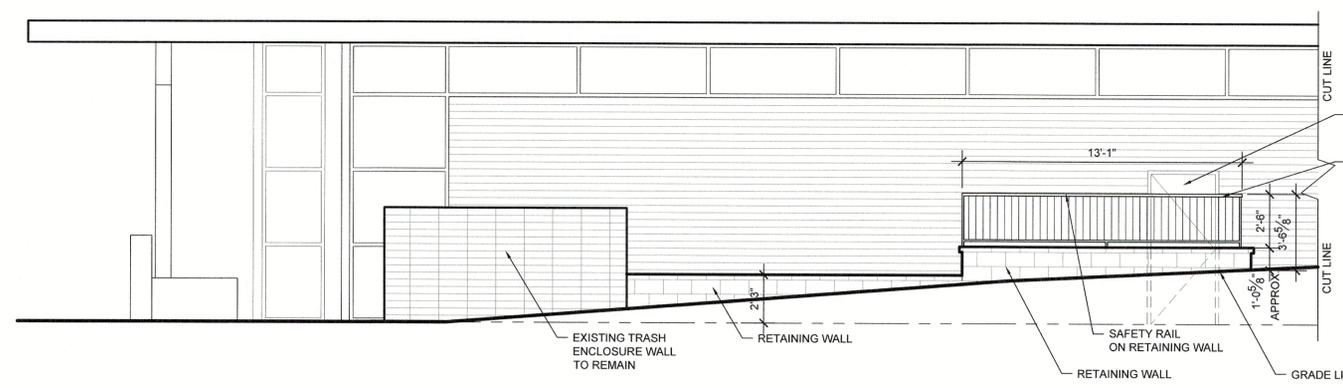

2 EXTERIOR EAST ELEVATION
SCALE: 1/4"=1'-0"

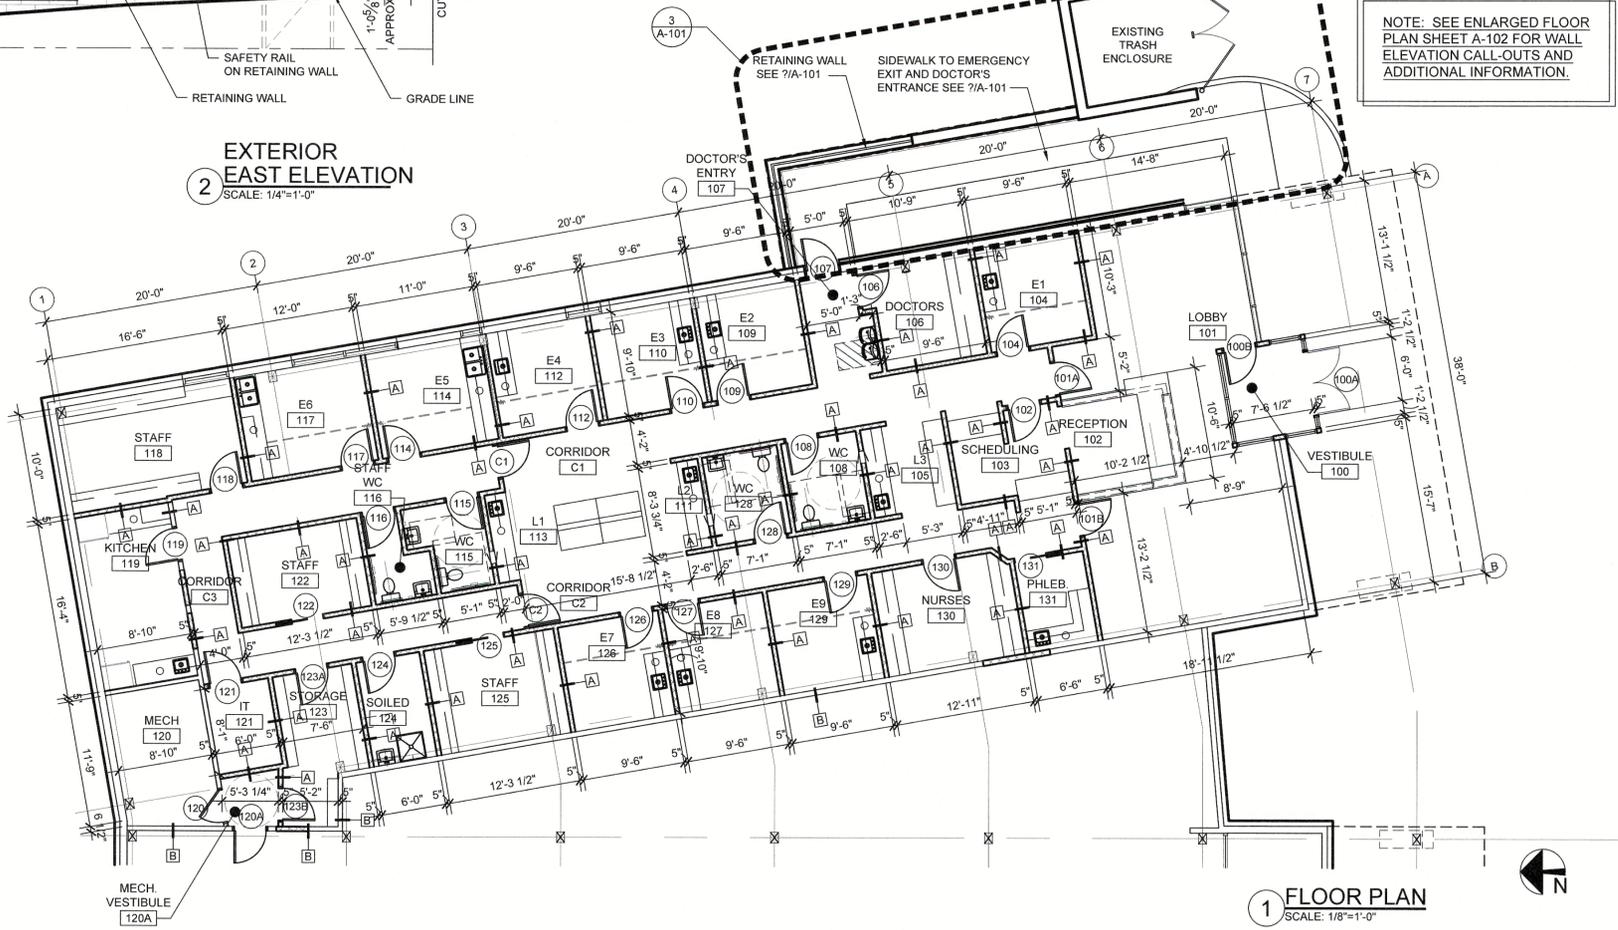

1 FLOOR PLAN
SCALE: 1/8"=1'-0"

GENERAL CONSTRUCTION NOTES

1. ALL NEW WORK TO BE PERFORMED AS SHOWN ON FLOOR PLAN.
2. OWNER TO SELECT FINISHES FROM STANDARD LINES AS PROVIDED AND INSTALLED BY CONTRACTOR.
3. WHERE EXISTING SURFACES ARE DISTURBED, THE CONTRACTOR SHALL PATCH AND MATCH TO ADJOINING EXISTING SURFACES THAT REMAIN DURING CONSTRUCTION.
4. DO NOT SCALE DRAWINGS.
5. ALL DIMENSIONS GIVEN ARE FROM EXISTING FINISH TO GYPSUM WALL BOARD AT NEW WALLS, EDGE OF NEW EQUIPMENT OR CENTER LINE OF NEW EQUIPMENT.
6. THERE SHALL BE NO LEVEL CHANGES (STEPS) GREATER THAN 1/2" WITHIN AN ACCESSIBLE ROUTE.
7. THE GENERAL CONTRACTOR SHALL PERFORM HIGH QUALITY PROFESSIONAL WORK IN ACCORDANCE WITH ACCEPTED NATIONAL INDUSTRY STANDARDS. JOIN MATERIALS TO UNIFORM, ACCURATE FITS SO THEY MEET WITH NEAT, STRAIGHT LINES, FREE OF SMEARS AND OVERLAPS.
8. WORK OF EACH TRADE SHALL MEET ALL NATIONAL STANDARDS PUBLISHED BY THAT TRADE.
9. GENERAL CONTRACTOR SHALL COORDINATE THEIR WORK WITH THOSE OF OTHER TRADES.
10. ALL WORK SHALL BE DONE IN STRICT ACCORDANCE WITH THE CURRENT BUILDING CODES AS ENFORCED BY THE LOCAL AUTHORITIES.
11. THE CONTRACTOR SHALL VERIFY LOCATION OF EXISTING UTILITIES AND SHALL BE RESPONSIBLE FOR PROTECTING THESE UTILITIES DURING THE EXECUTION OF THE WORK.
12. THE CONTRACTOR SHALL BE RESPONSIBLE FOR REPAIRING ALL DAMAGE CAUSED THROUGH OPERATIONS UNDER THIS PROJECT.
13. PROVIDE FIRE BLOCKING AND DRAFT STOPPING AS REQUIRED BY CODE.
14. THE CONTRACTOR SHALL PROTECT AND MAINTAIN THE INTEGRITY OF ALL FIRE RATED PARTITIONS AND ASSEMBLIES.

Drawing Name: F:\2021\2021027 - Jayger - KCUC Lee's Summit\Production\04 - Construction Documents\2021027 A-101 FLOOR PLAN.dwg Last Modified: Oct 12, 2021 - 2:12pm Plotted on: Oct 13, 2021 - 9:50am by mwinslow



NOLTE & ASSOCIATES, P.A.
ARCHITECTS / PLANNERS
8400 REEDS ROAD, SUITE 200
OVERLAND PARK, KANSAS 66207
(913) 322-2444
FAX (913) 322-8277



REMODEL
LEE'S SUMMIT
KCUC UROLOGY & ONCOLOGY
451 NW MURRAY ROAD
LEE'S SUMMIT, MISSOURI 64081
JACKSON COUNTY

DATE PRINTED:
Oct 13, 2021

DATE ISSUED:
10.13.2021


REVISIONS:

ARCHITECTURAL PROJECT NUMBER
2021027

FLOOR PLAN

SHEET NUMBER
A-101

Drawing Name: F:\2021\2021027 - Jayger - KCUC Lee's Summit\Production\4 - Construction Documents\2021027 A-102 ENLARGED FLOOR PLANS.dwg Last Modified: Oct 13, 2021 - 3:14pm Plotted on: Oct 13, 2021 - 9:55am by mwinslow

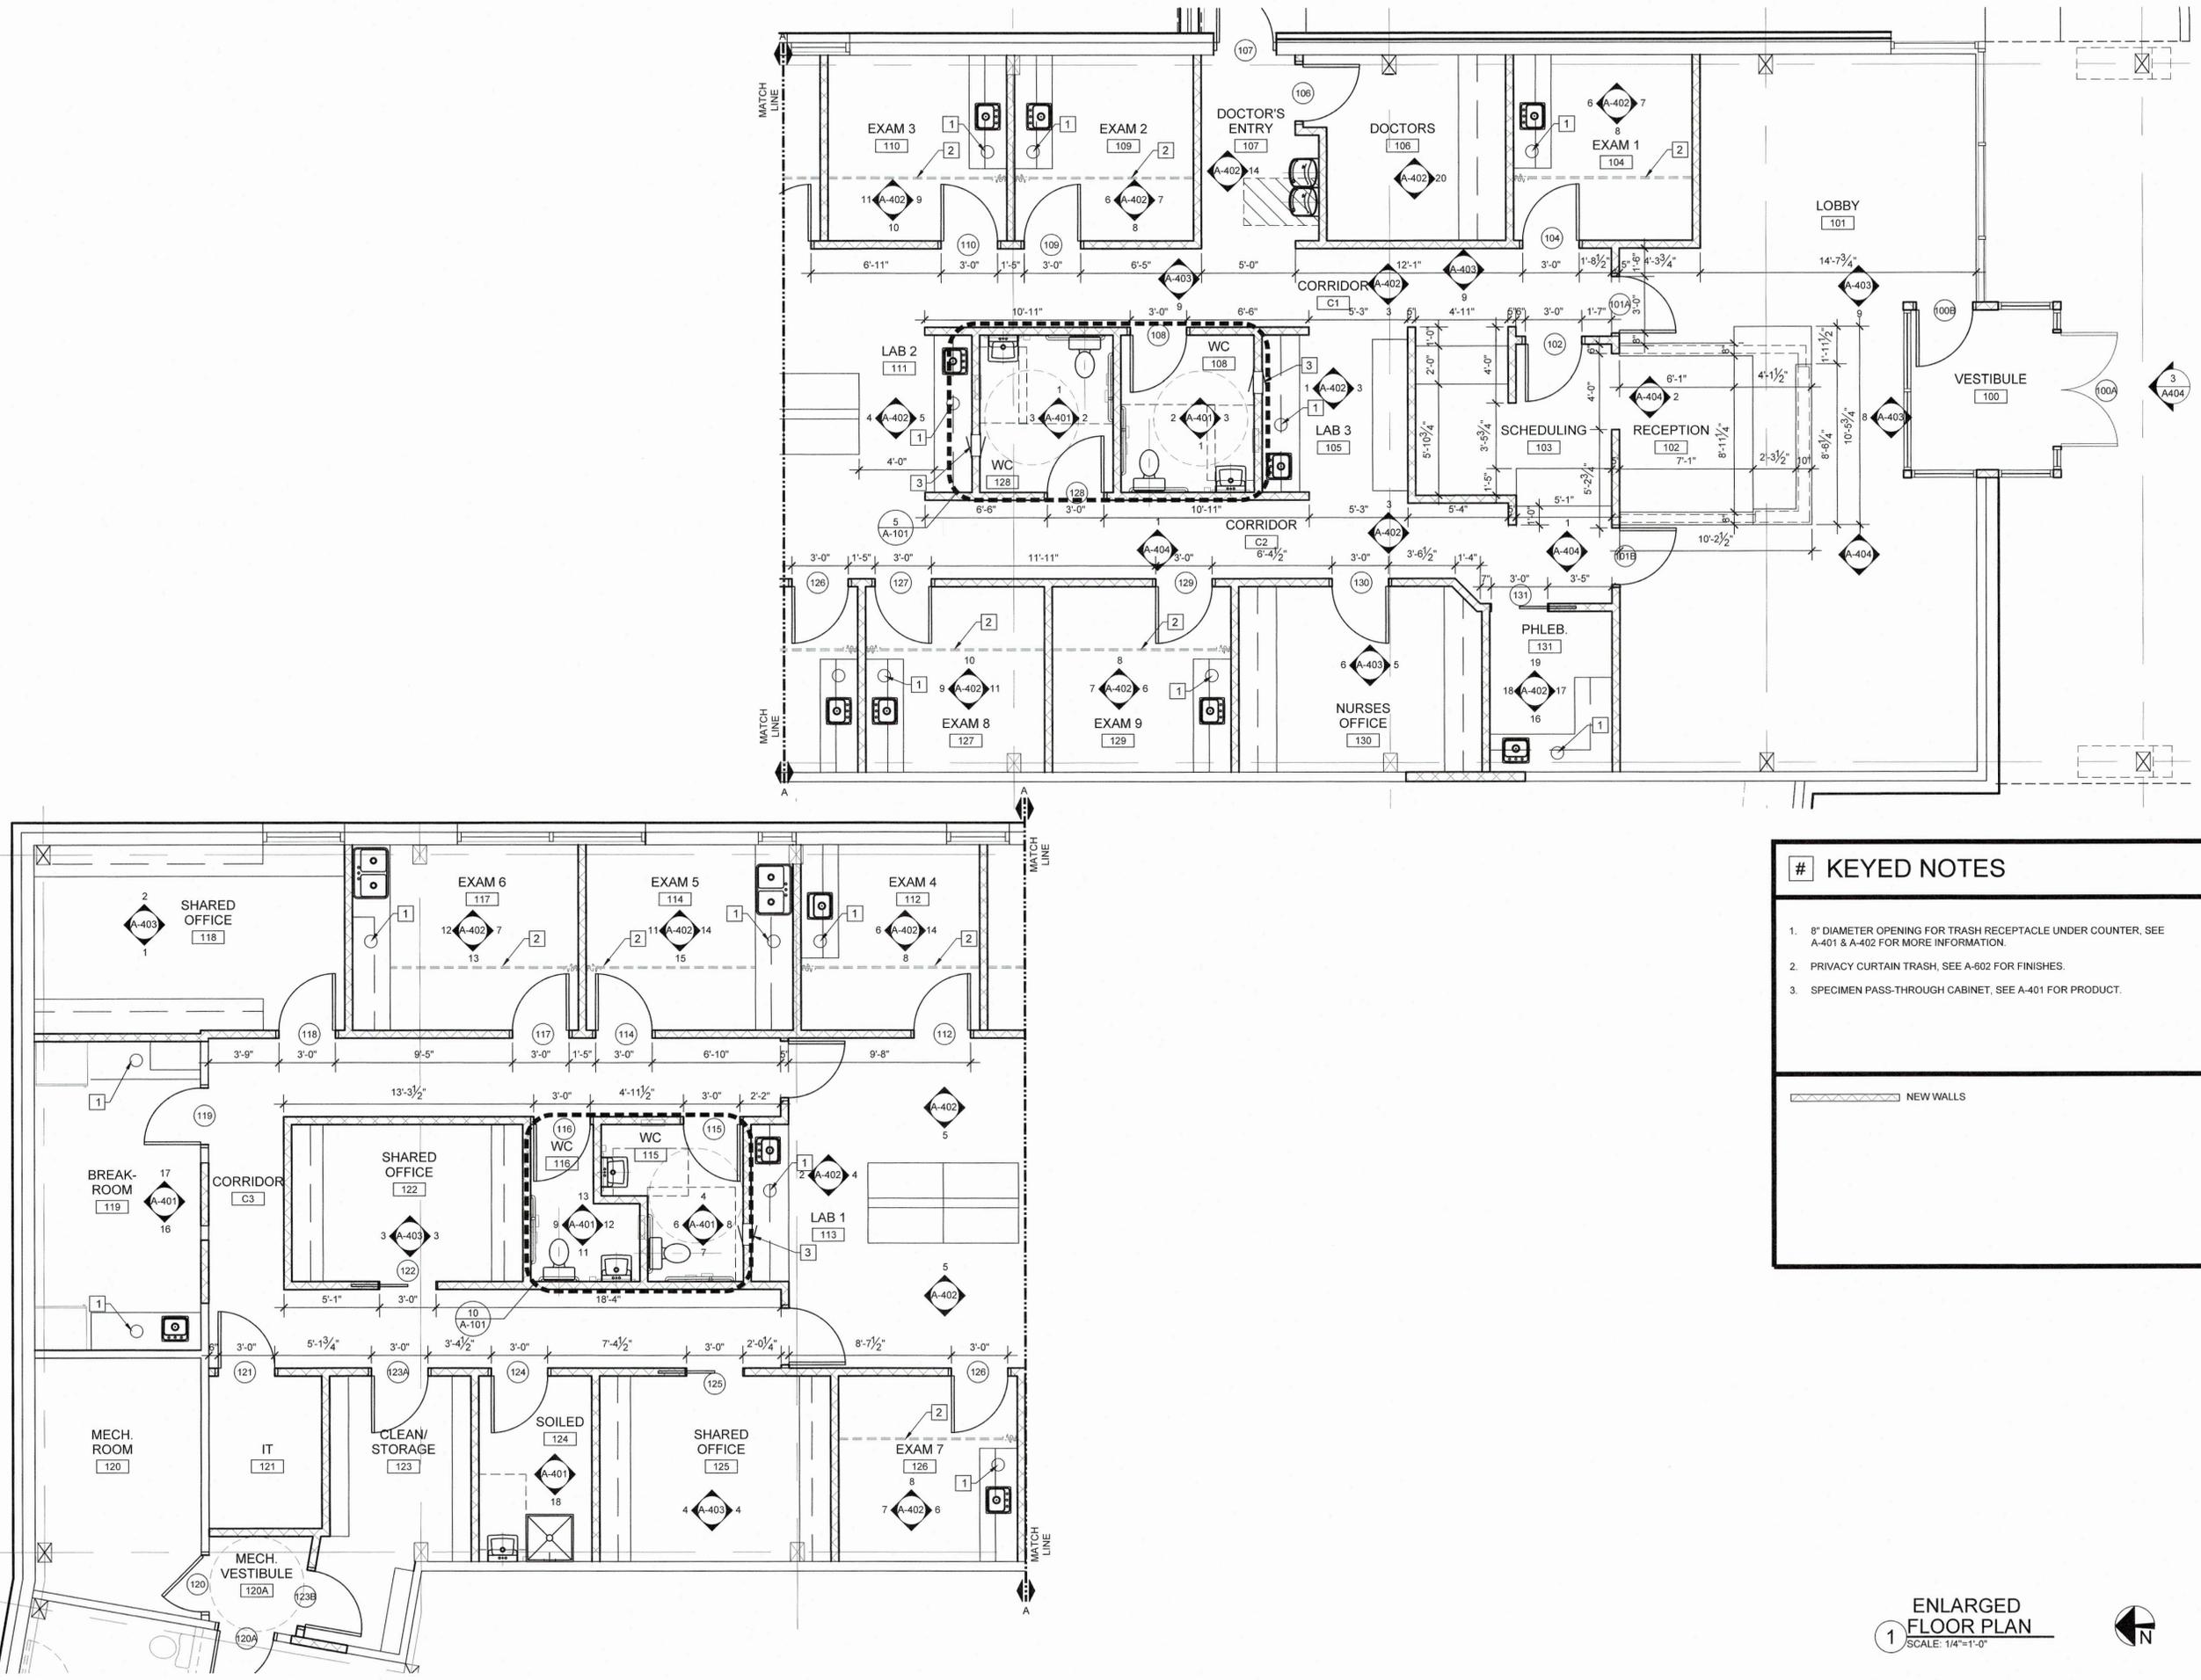

#	KEYED NOTES
1.	8" DIAMETER OPENING FOR TRASH RECEPTACLE UNDER COUNTER, SEE A-401 & A-402 FOR MORE INFORMATION.
2.	PRIVACY CURTAIN TRASH, SEE A-602 FOR FINISHES.
3.	SPECIMEN PASS-THROUGH CABINET, SEE A-401 FOR PRODUCT.

	NEW WALLS
--	-----------

ENLARGED
FLOOR PLAN
 SCALE: 1/4"=1'-0"



NOLTE & ASSOCIATES, P.A.
 ARCHITECTS / PLANNERS
 9400 REEDS ROAD, SUITE 200
 OVERLAND PARK, KANSAS 66207
 (913) 322-2444
 FAX (913) 322-6277



REMODEL
LEE'S SUMMIT
KCUC UROLOGY & ONCOLOGY
 451 NW MURRAY ROAD
 LEE'S SUMMIT, MISSOURI 64081
 JACKSON COUNTY

DATE PRINTED:
 Oct 13, 2021

DATE ISSUED:
 10.13.2021

REVISORS:

ARCHITECTURAL PROJECT NUMBER
 2021027

ENLARGED
 FLOOR
 PLANS

SHEET NUMBER
A-102


This material is confidential, proprietary and owned solely by Nolte & Associates, P.A. By providing these documents, Nolte & Associates, P.A. assumes no responsibility for their accuracy, construction and detailing of information contained herein. Do not modify, replicate, reproduce, distribute or transfer this material without the express written permission of Nolte & Associates, P.A.
 Copyright © 2021

RESTROOM GENERAL NOTES


1. PROVIDE F.R. WOOD BLOCKING IN WALLS AT ALL LOCATIONS AS NEEDED FOR MOUNTING.
2. COUNTERTOPS & BACKSPLASH TO BE SELECTED BY OWNER.
3. NOT USED.
4. ALL WORK TO COMPLY WITH ALL APPLICABLE NATIONAL, STATE & LOCAL BUILDING CODES.
5. THIS PROJECT SHALL COMPLY IN ALL AREAS WITH THE 2010 ADA STANDARDS FOR ACCESSIBLE DESIGN.
6. PROVIDE 1-1/2" CLEARANCE BETWEEN GRAB BARS AND ADJACENT WALLS.
7. HOT WATER & DRAIN PIPING UNDER LAVATORIES SHALL BE INSULATED TO PROTECT AGAINST ANY CONTACT.
8. GRAB BARS & TOILET SEATS SHALL WITHSTAND A LOAD OF NOT LESS THAN 250 LBS. APPLIED AT ANY POINT.
9. THE GENERAL CONTRACTOR IS RESPONSIBLE FOR CHECKING ALL CONTRACT DOCUMENTS, FIELD CONDITIONS AND DIMENSION FOR THEIR ACCURACY AND CONFIRMING THAT WORK IS BUILDABLE AS SHOWN BEFORE PROCEEDING WITH CONSTRUCTION. IF THERE ARE ANY QUESTIONS REGARDING THESE OR OTHER COORDINATION QUESTIONS, THE CONTRACTOR IS RESPONSIBLE FOR OBTAINING CLARIFICATION FROM THE ARCHITECT BEFORE PROCEEDING WITH THE WORK IN QUESTION OR ANY RELATED WORK.

NOTE: SEE A-602 FOR ABBREVIATIONS AND FINISH SCHEDULE


BOBRICK MODELS	
MODEL #	TOILET ACCESSORY SCHEDULE
B-211	(A) SURFACE MOUNTED LIQUID SOAP DISPENSER.
B-3942	(B) RECESSED PAPER TOWEL DISP / RECEPTACLE.
B-1652436	(C) 24" X 36" MIRROR.
B-6806X36	(D) 1-1/2" DIAMETER X 36" LONG PEENED GRAB BAR.
B-6806X42	(E) 1-1/2" DIAMETER X 42" LONG PEENED GRAB BAR.
B-4354	(F) SURFACE MOUNTED SANITARY NAPKIN DISPOSAL.
B-685	(G) SURFACE MOUNTED TOILET TISSUE DISPENSER.
B-6806X18	(H) 1-1/2" DIAMETER X 18" LONG PEENED GRAB BAR.
B-505	(I) RECESSED SPECIMEN PASS THROUGH CABINET.

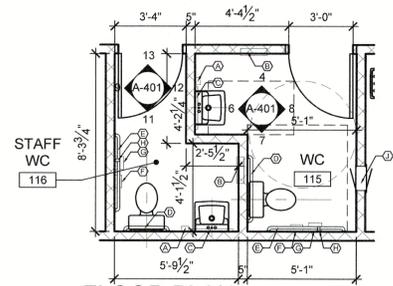

FLOOR PLAN WC 115 & 116
SCALE: 1/4" = 1'-0"

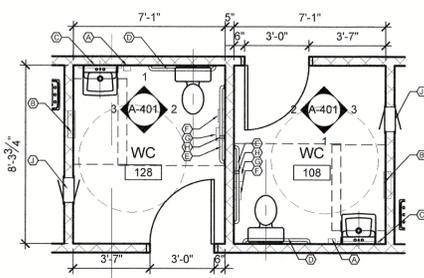

FLOOR PLAN WC 108 & 128
SCALE: 1/4" = 1'-0"

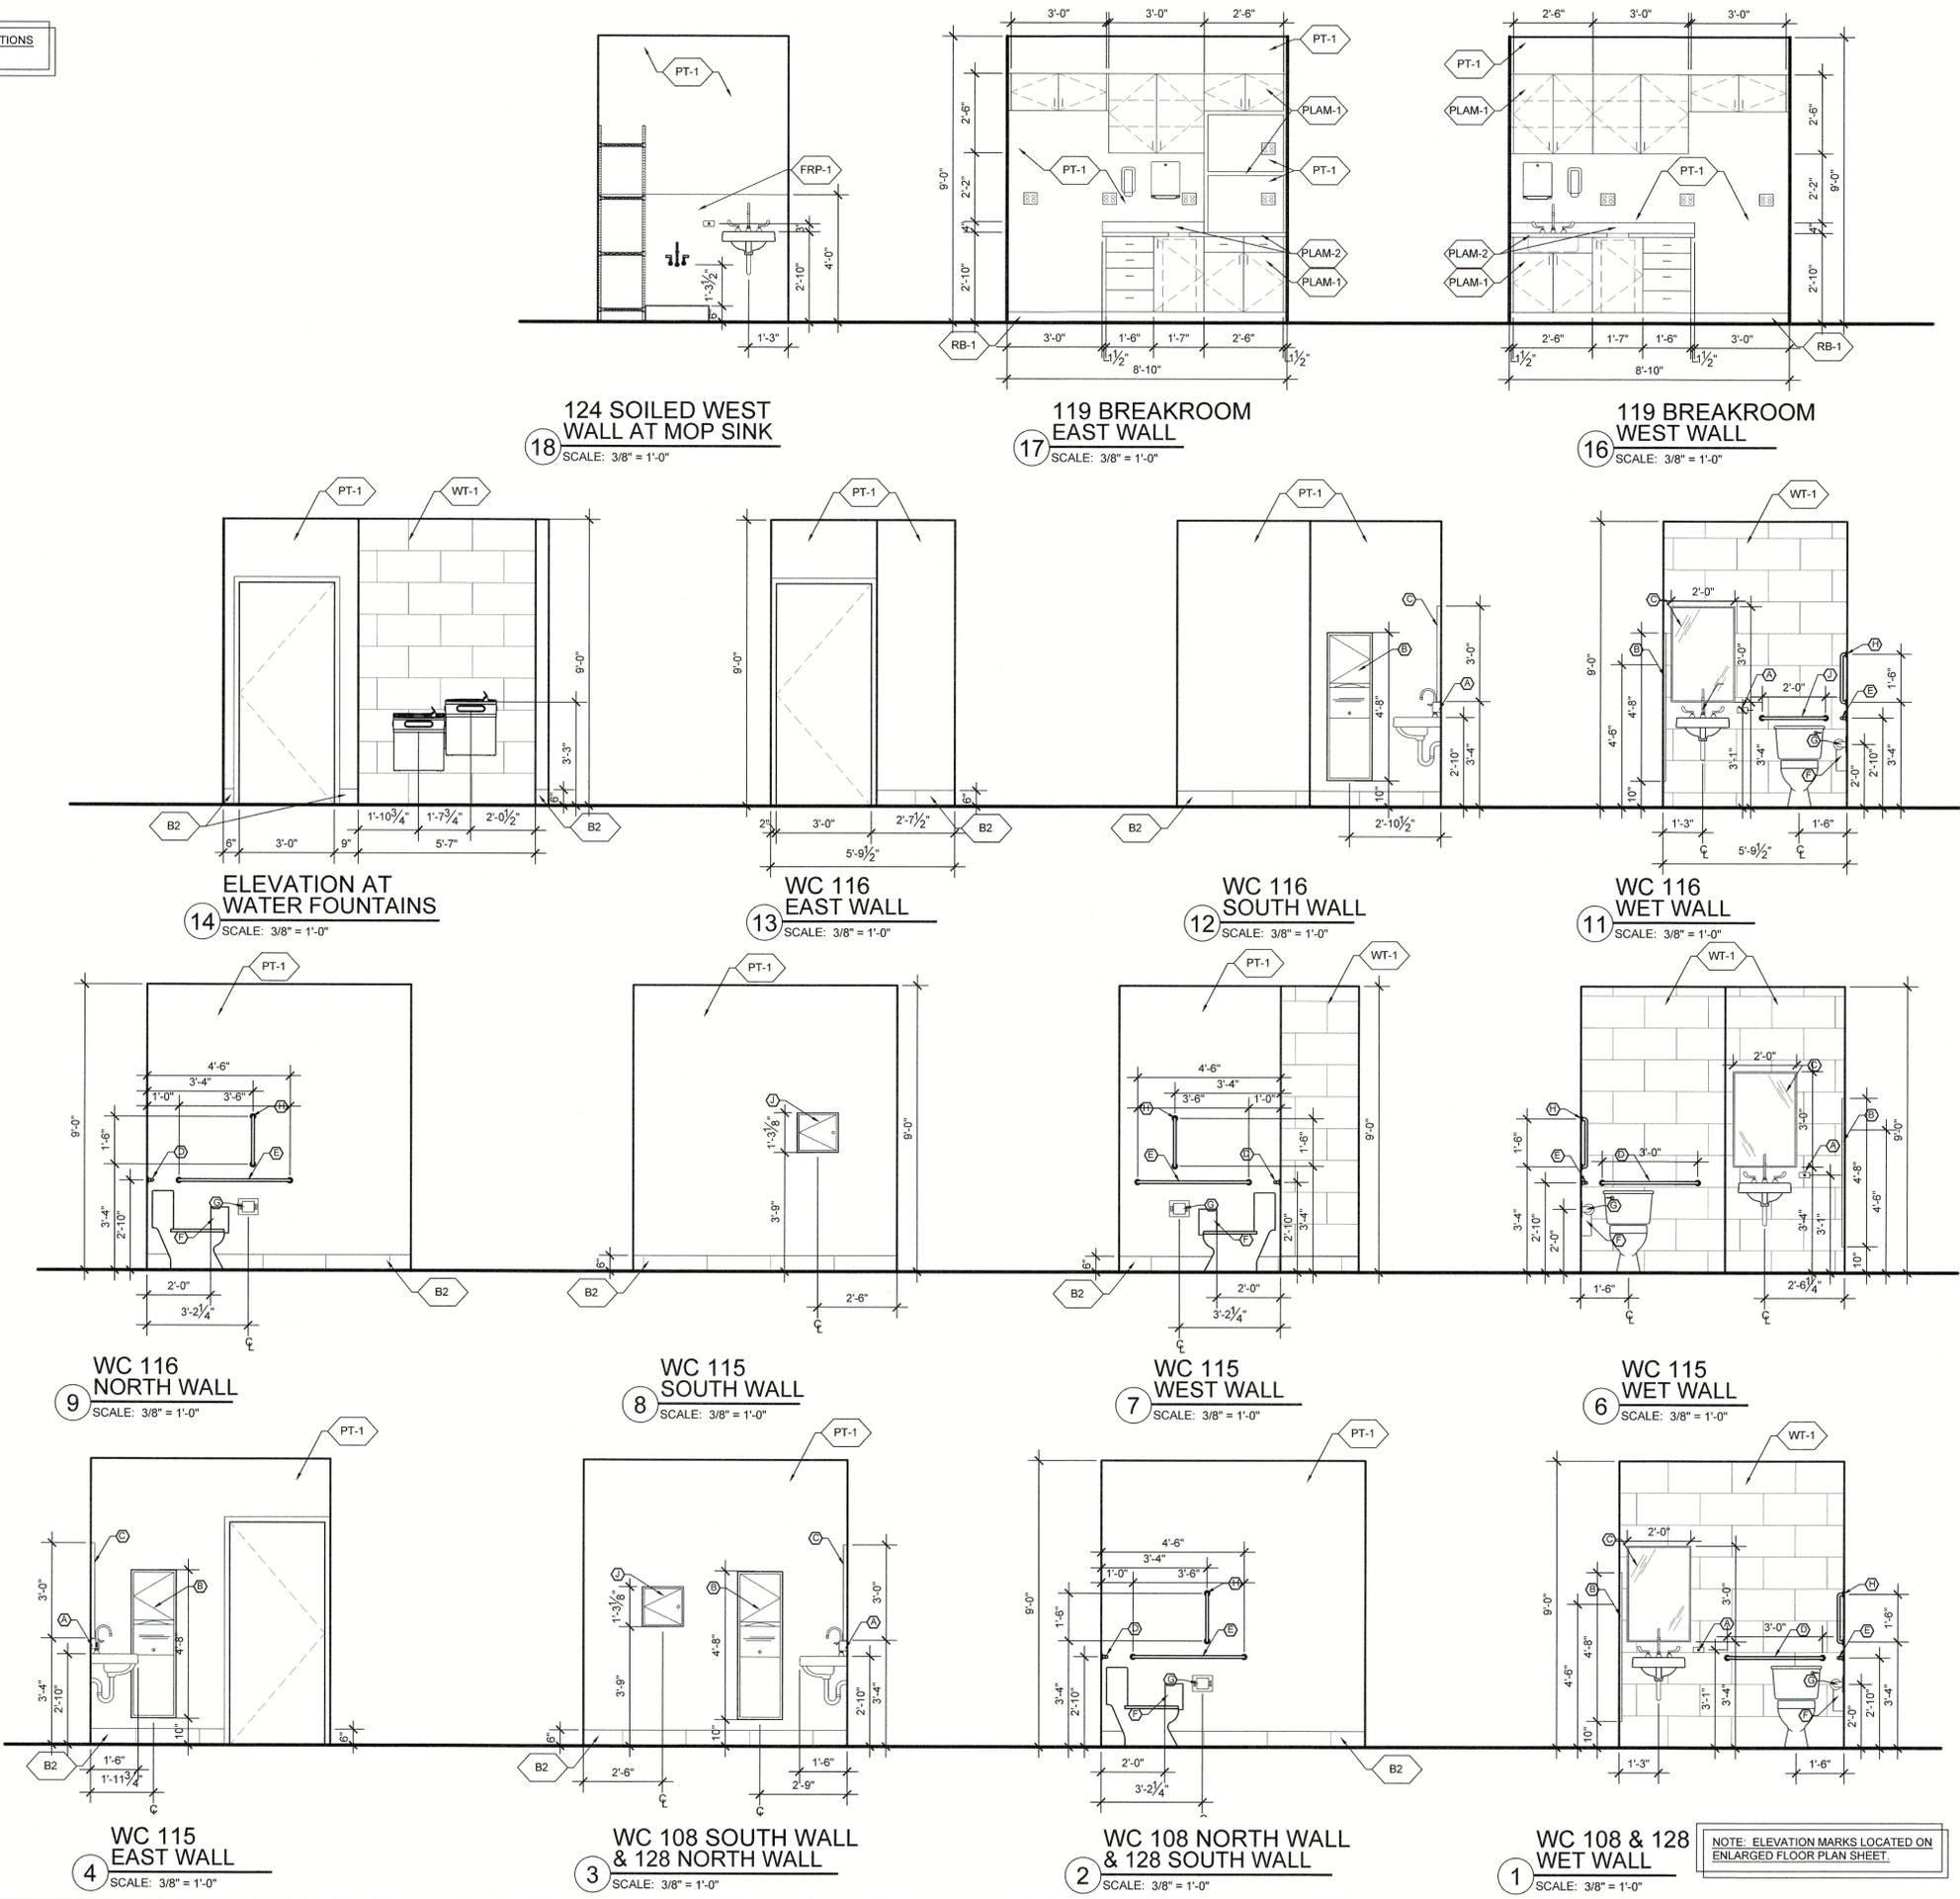

124 SOILED WEST WALL AT MOP SINK
SCALE: 3/8" = 1'-0"

119 BREAKROOM EAST WALL
SCALE: 3/8" = 1'-0"

119 BREAKROOM WEST WALL
SCALE: 3/8" = 1'-0"

ELEVATION AT WATER FOUNTAINS
SCALE: 3/8" = 1'-0"

WC 116 EAST WALL
SCALE: 3/8" = 1'-0"

WC 116 SOUTH WALL
SCALE: 3/8" = 1'-0"

WC 116 WET WALL
SCALE: 3/8" = 1'-0"

WC 116 NORTH WALL
SCALE: 3/8" = 1'-0"

WC 115 SOUTH WALL
SCALE: 3/8" = 1'-0"

WC 115 WEST WALL
SCALE: 3/8" = 1'-0"

WC 115 WET WALL
SCALE: 3/8" = 1'-0"

WC 115 EAST WALL
SCALE: 3/8" = 1'-0"

WC 108 SOUTH WALL & 128 NORTH WALL
SCALE: 3/8" = 1'-0"

WC 108 NORTH WALL & 128 SOUTH WALL
SCALE: 3/8" = 1'-0"

WC 108 & 128 WET WALL
SCALE: 3/8" = 1'-0"

NOTE: ELEVATION MARKS LOCATED ON ENLARGED FLOOR PLAN SHEET.



NOLTE & ASSOCIATES, P.A.
ARCHITECTS / PLANNERS
9400 REEDS ROAD, SUITE 200
OVERLAND PARK, KANSAS 66207
(913) 322-2444
FAX (913) 322-6277



REMODEL
LEE'S SUMMIT
KCUC UROLOGY & ONCOLOGY
451 NW MURRAY ROAD
LEE'S SUMMIT, MISSOURI 64081
JACKSON COUNTY

DATE PRINTED:
Oct 13, 2021

DATE ISSUED:
10.13.2021

REVISIONS:


ARCHITECTURAL PROJECT NUMBER
2021027

INTERIOR
ELEVATIONS


SHEET NUMBER
A-401

Drawing Name: F:\2021\2021027 - Jayger - KCUC Lee's Summit\Production\04 - Construction Documents\2021027 A-401 INT ELEVS.dwg Last Modified: Oct 08, 2021 - 10:06am by mwinslow


Drawing Name: F:\2021\2021\1027 - Joyger - KCUC Lee's Summit\Production\04 - Construction Documents\2021027 A-402 INT ELEVATIONS.dwg Last Modified: Oct 08, 2021 - 1:36pm Plotted on: Oct 13, 2021 - 10:04am by mwinislow

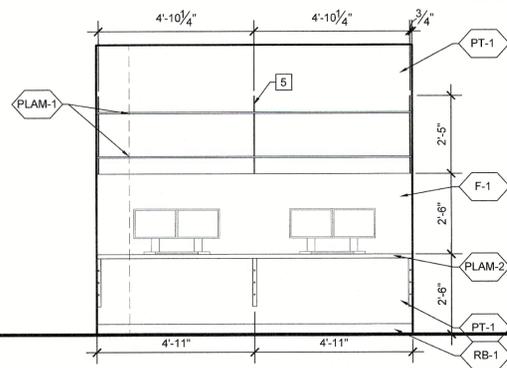


20 106 DOCTORS WORKSTATIONS
SCALE: 3/8" = 1'-0"

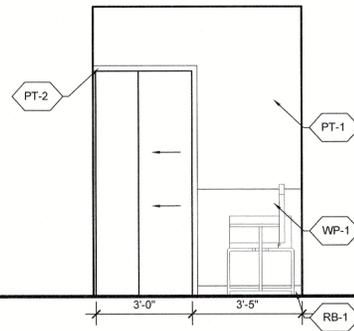


19 131 PHLEB. EAST WALL
SCALE: 3/8" = 1'-0"

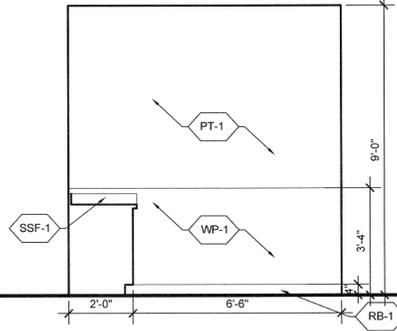


18 131 PHLEB. NORTH WALL
SCALE: 3/8" = 1'-0"

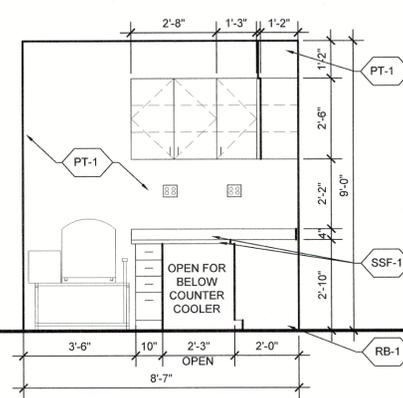


17 131 PHLEB. SOUTH WALL
SCALE: 3/8" = 1'-0"

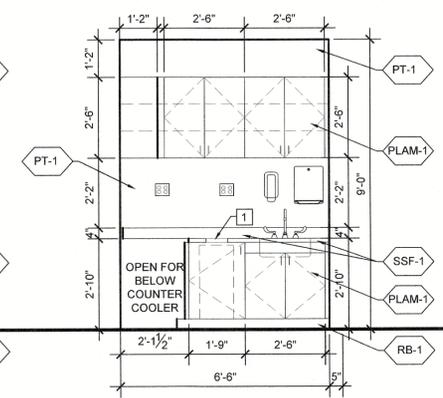


16 131 PHLEB. WEST WALL
SCALE: 3/8" = 1'-0"

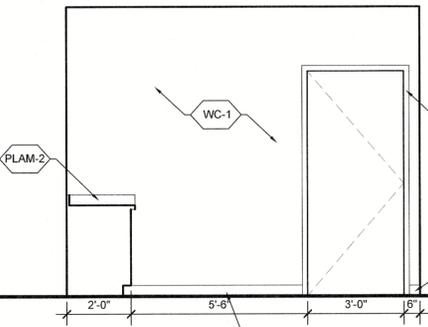


15 114 EXAM 5 ENTRANCE WALL
SCALE: 3/8" = 1'-0"

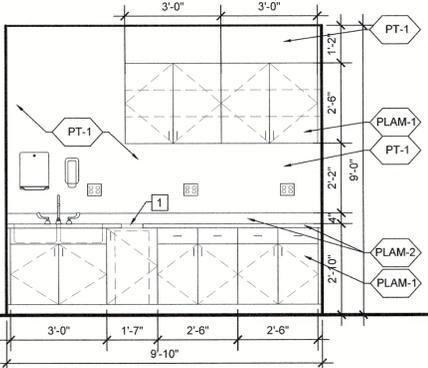


14 114 EXAM 5 CABINET WALL
SCALE: 3/8" = 1'-0"

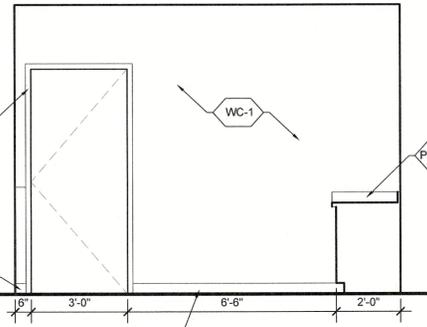


13 117 EXAM 6 ENTRANCE WALL
SCALE: 3/8" = 1'-0"

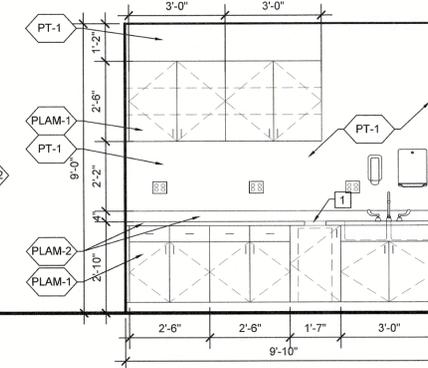


12 117 EXAM 6 CABINET WALL
SCALE: 3/8" = 1'-0"

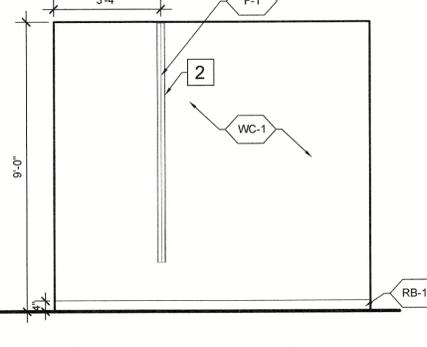


11 LEFT HAND EXAM CURTAIN WALL
SCALE: 3/8" = 1'-0"

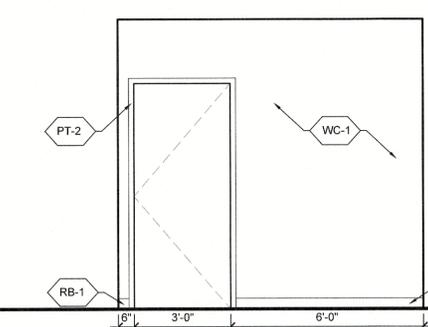


10 LEFT HAND EXAM ENTRANCE WALL
SCALE: 3/8" = 1'-0"

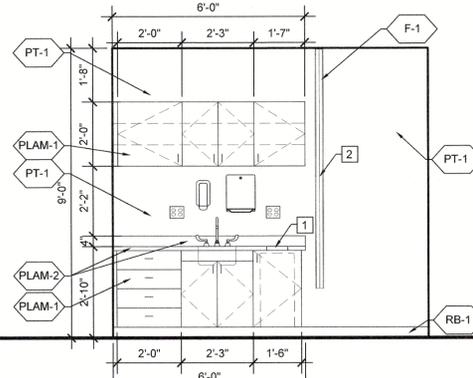


9 LEFT HAND EXAM COUNTER WALL
SCALE: 3/8" = 1'-0"

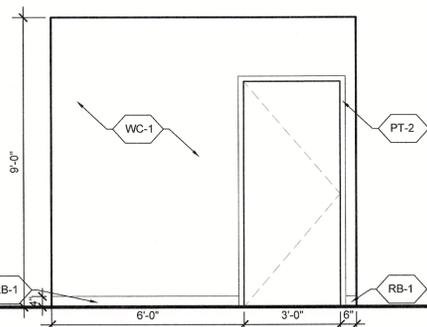


8 RIGHT HAND EXAM ENTRANCE WALL
SCALE: 3/8" = 1'-0"

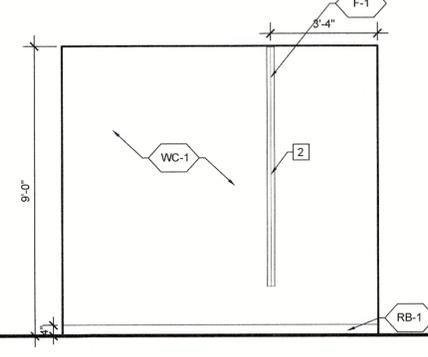


7 RIGHT HAND EXAM CURTAIN WALL
SCALE: 3/8" = 1'-0"

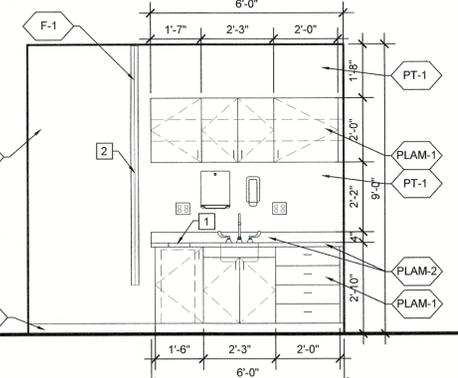


6 RIGHT HAND EXAM CABINET WALL
SCALE: 3/8" = 1'-0"

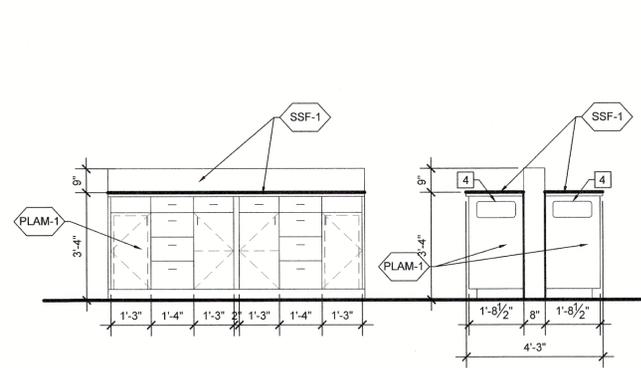


4 111 LAB 2 & 113 LAB 1 ISLAND ELEVATIONS
SCALE: 3/8" = 1'-0"

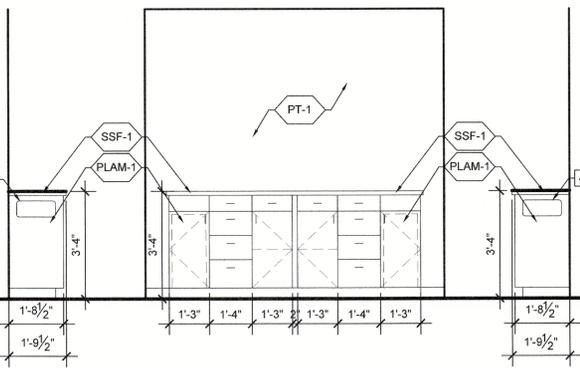

3 105 LAB 3 PC COUNTER WITH SIDE ELEVATIONS
SCALE: 3/8" = 1'-0"

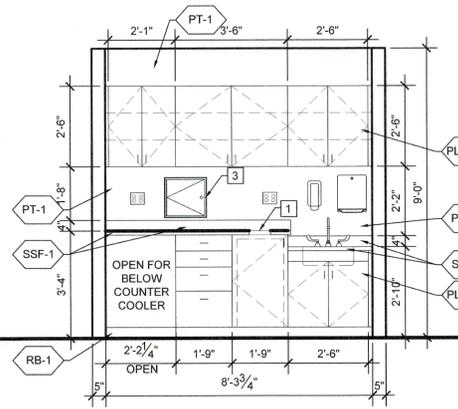

2 113 LAB 1 SINK COUNTER
SCALE: 3/8" = 1'-0"

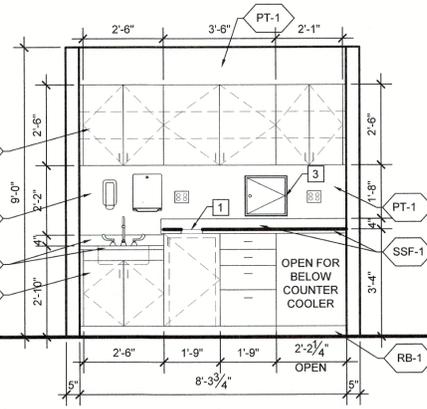

1 105 LAB 3 & 111 LAB 2 AT SINK COUNTER
SCALE: 3/8" = 1'-0"

GENERAL NOTES

- SEE A-602 FOR ABBREVIATIONS AND FINISH SCHEDULE.
- ELEVATIONS MARKS LOCATED ON ENLARGED FLOOR PLAN SHEET A-102.

KEYED NOTES

- 8" DIAMETER OPENING FOR UNDER COUNTER TRASH RECEPTACLE.
- PRIVACY CURTAIN, SEE A-602 FOR FINISHES.
- SPECIMEN PASS-THROUGH CABINET, SEE A-401 FOR PRODUCT.
- SIDE OPENING FOR TRASH RECEPTACLE.
- SHELVING TRACK.



NOLTE & ASSOCIATES, P.A.
ARCHITECTS / PLANNERS
6400 REEDS ROAD, SUITE 200
OVERLAND PARK, KANSAS 66207
(913) 322-2444
(913) 322-6277



REMODEL
LEE'S SUMMIT
KCUC UROLOGY & ONCOLOGY
451 NW MURRAY ROAD
LEE'S SUMMIT, MISSOURI 64081
JACKSON COUNTY

DATE PRINTED:
Oct 13, 2021

DATE ISSUED:
10.13.2021

REVISIONS:

ARCHITECTURAL PROJECT NUMBER
2021027

INTERIOR
ELEVATIONS

SHEET NUMBER
A-402



NOLTE & ASSOCIATES, P.A.
 ARCHITECTS / PLANNERS
 9400 REEDS ROAD, SUITE 200
 OVERLAND PARK, KANSAS 66207
 (913) 322-2444
 F.A.X. (913) 322-6277



Copyright © 2021

REMODEL
LEE'S SUMMIT
KCUC UROLOGY & ONCOLOGY
 451 NW MURRAY ROAD
 LEE'S SUMMIT, MISSOURI 64081
 JACKSON COUNTY

This material is confidential, proprietary and owned solely by Nolte & Associates, P.A. By providing these documents, Nolte & Associates, P.A. assumes no responsibility for their accuracy, construction and/or installation. Contractors are to verify all dimensions, materials, finishes, etc. prior to construction. No part of this material shall be reproduced without the express written permission of Nolte & Associates, P.A.

DATE PRINTED:
 Oct 13, 2021


DATE ISSUED:
 10.13.2021

REVISIONS:

ARCHITECTURAL PROJECT NUMBER
 2021027

INTERIOR
 ELEVATIONS

SHEET NUMBER
A-403

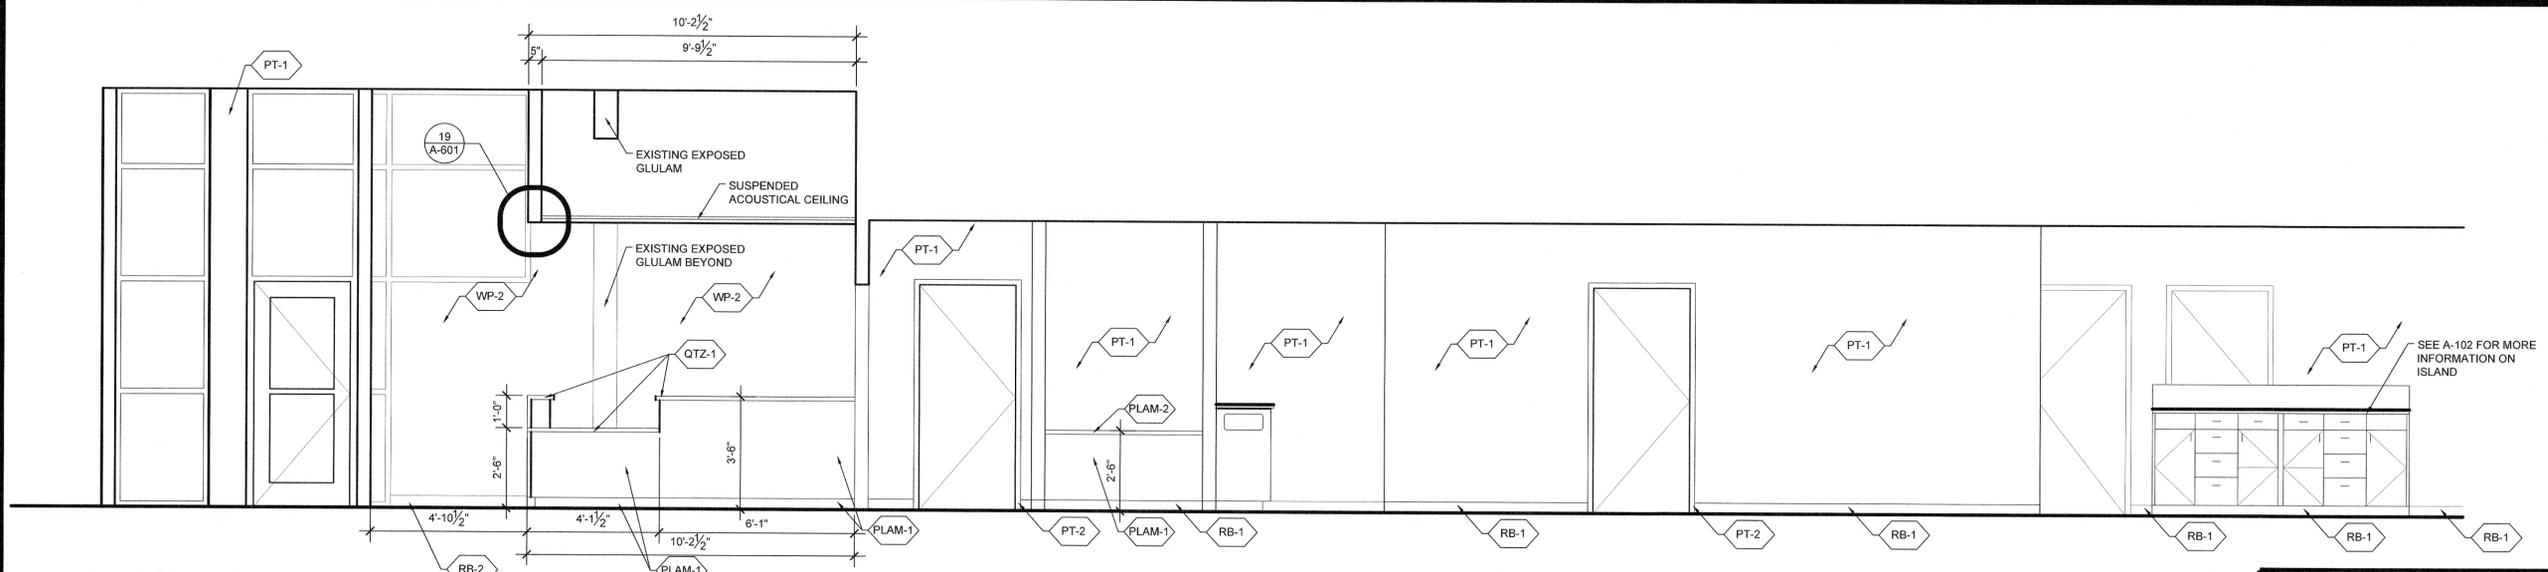


9 101 LOBBY WEST WALL WITH CORRIDOR 1
 SCALE: 3/8" = 1'-0"

GENERAL NOTES


- SEE A-602 FOR ABBREVIATIONS AND FINISH SCHEDULE.
- ELEVATIONS MARKS LOCATED ON ENLARGED FLOOR PLAN SHEET A-102.

KEYED NOTES


- 8" DIAMETER OPENING FOR UNDER COUNTER TRASH RECEPTACLE.
- PRIVACY CURTAIN, SEE A-602 FOR FINISHES.
- SPECIMEN PASS-THROUGH CABINET, SEE A-401 FOR PRODUCT.
- SIDE OPENING FOR TRASH RECEPTACLE.
- SHELVING TRACK.

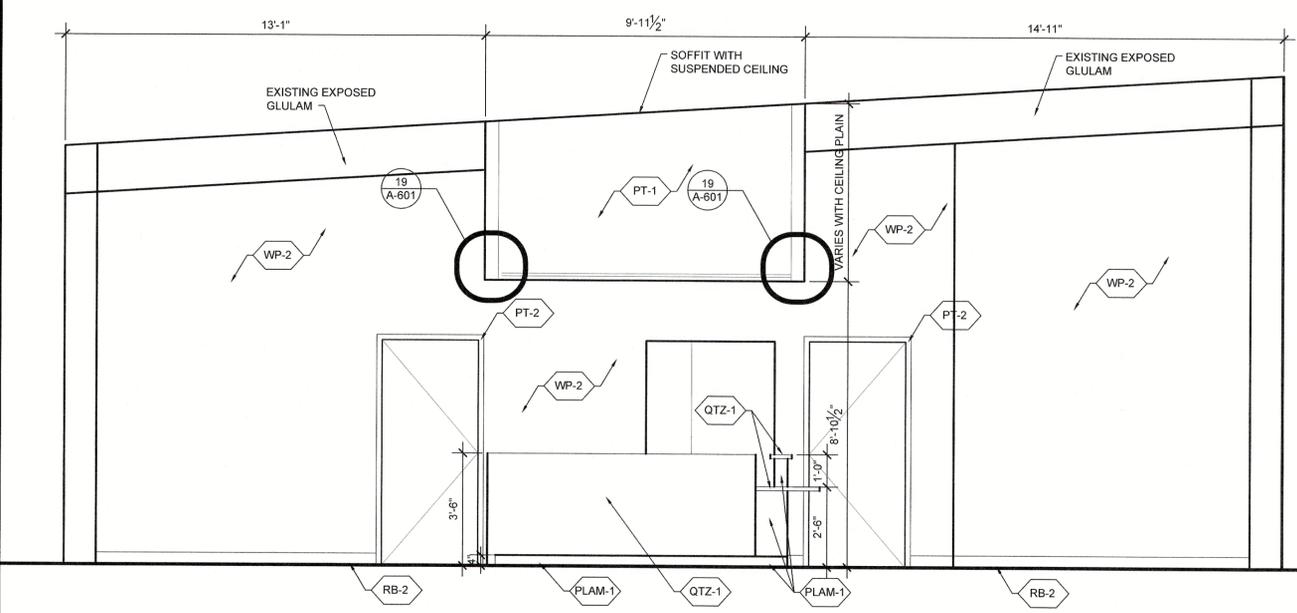


8 101 LOBBY AT FRONT
 102 RECEPTION COUNTER
 SCALE: 3/8" = 1'-0"

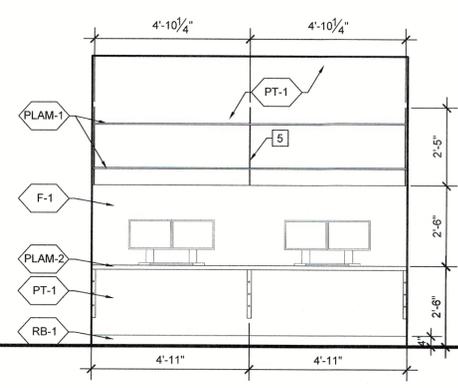


6 130 NURSES OFFICE NORTH WALL
 SCALE: 3/8" = 1'-0"

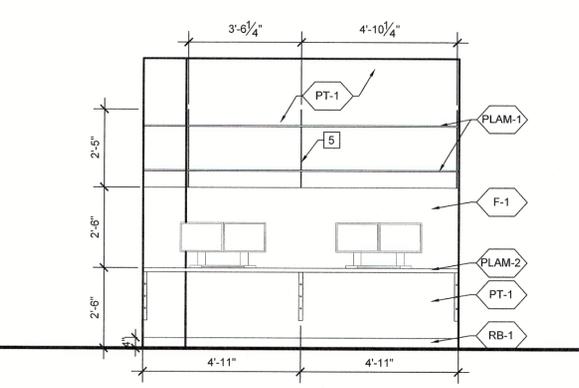


5 130 NURSES OFFICE SOUTH WALL
 SCALE: 3/8" = 1'-0"

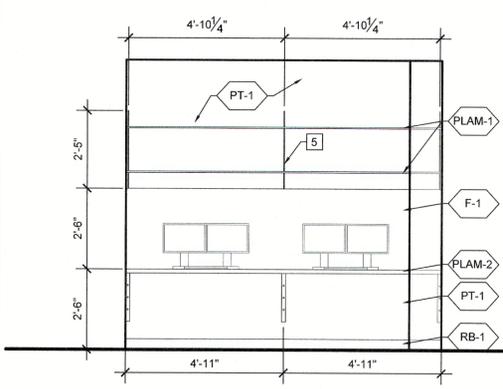


4 125 STAFF OFFICE NORTH & SOUTH WALLS
 SCALE: 3/8" = 1'-0"

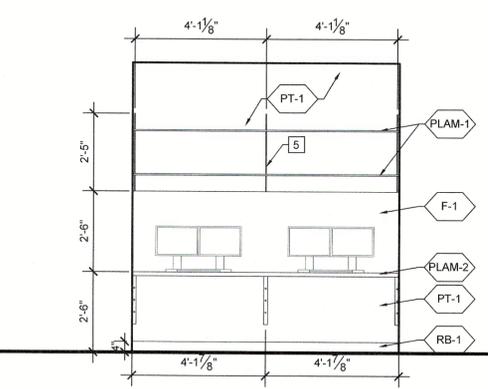

3 122 STAFF OFFICE NORTH & SOUTH WALLS
 SCALE: 3/8" = 1'-0"

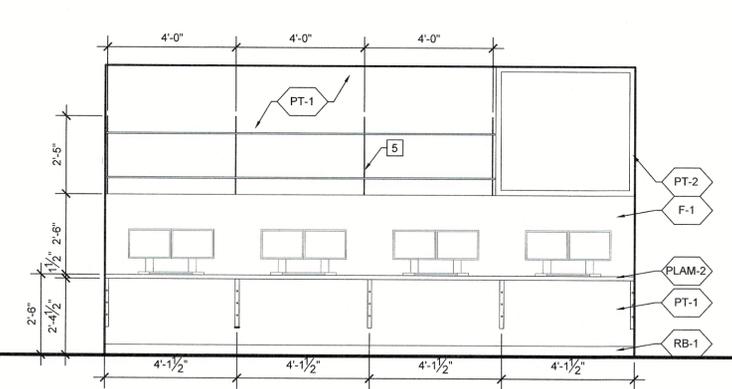


2 118 SHARED OFFICE EAST WALL
 SCALE: 3/8" = 1'-0"

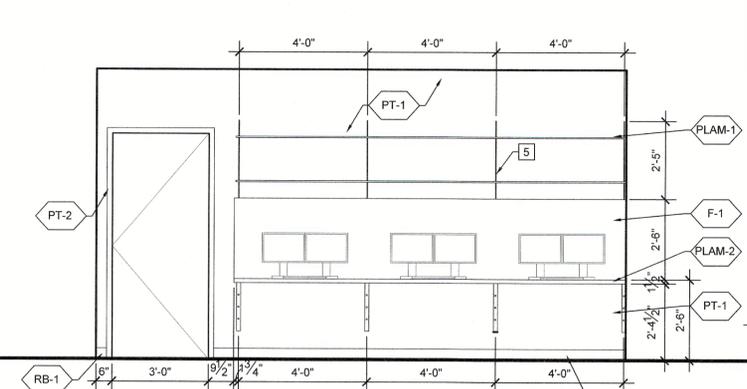


1 118 SHARED OFFICE WEST WALL
 SCALE: 3/8" = 1'-0"

Drawing Name: F:\2021\2021027 - Jagger - KCUC - Lee's Summit\Production\04 - Construction Documents\2021027 A-403 INT ELEV.dwg Last Modified: Oct 12, 2021 - 4:05pm Plotted on: Oct 13, 2021 - 10:07am by mwinslow


Drawing Name: F:\2021\2021027 - Jayger - KCUC Lee's Summit\Production\04 - Construction Documents\2021027 A-404 INT ELEV.dwg Last Modified: Oct 08, 2021 - 1:38pm Plotted on: Oct 13, 2021 - 10:18am by mwinslow

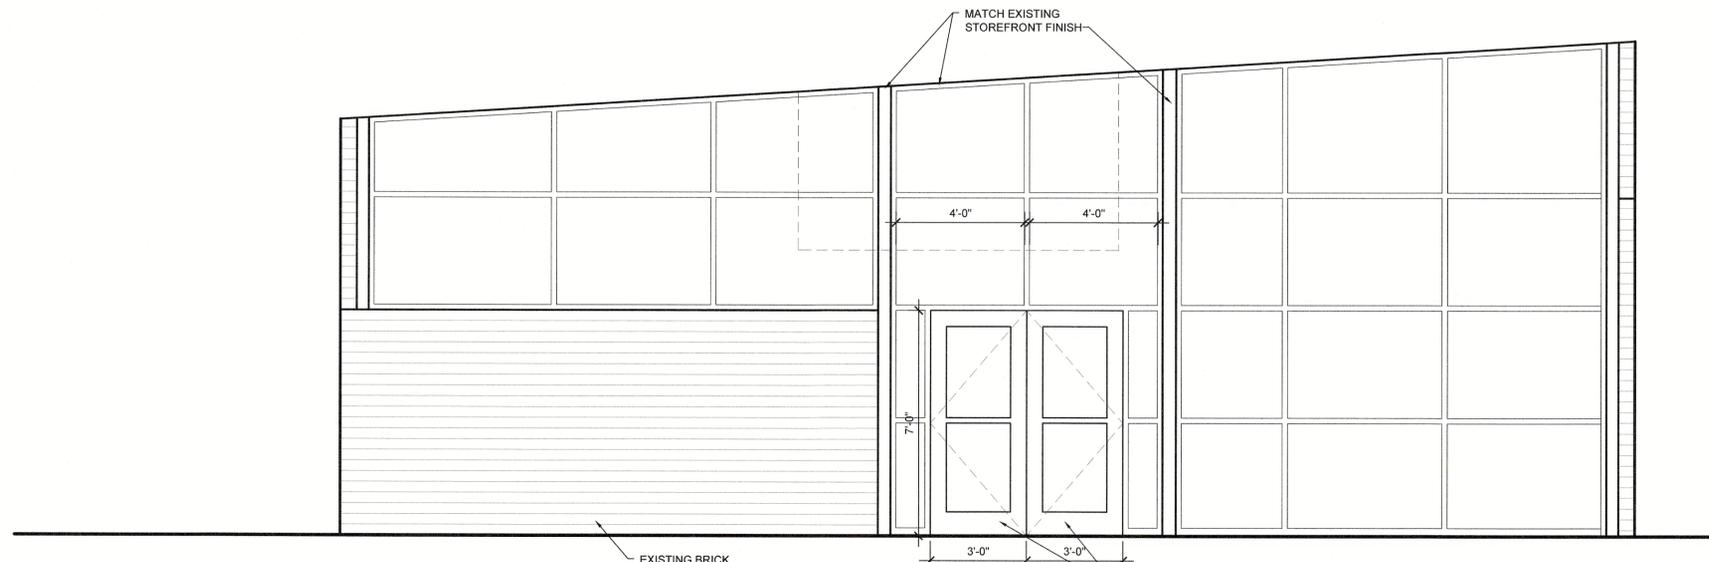

3 EXTERIOR NORTH FACADE ENTRY WITH VESTIBULE
SCALE: 3/8" = 1'-0"

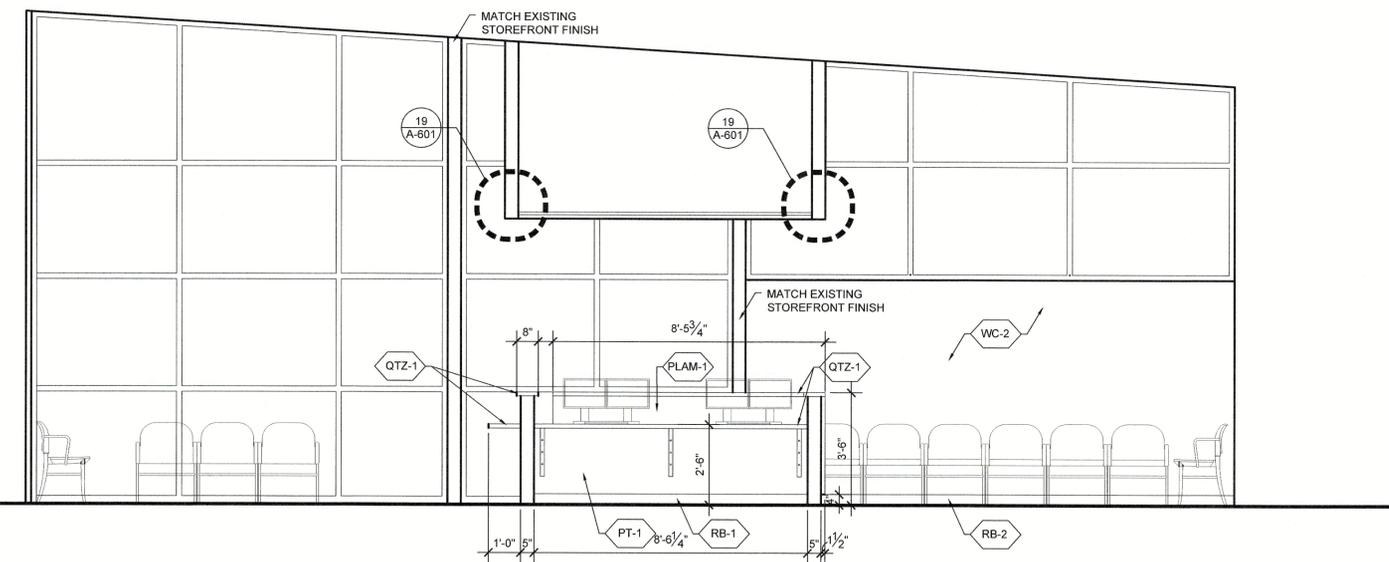

2 SOUTH ELEVATION LOBBY 101 & RECEPTION 102 COUNTER
SCALE: 3/8" = 1'-0"

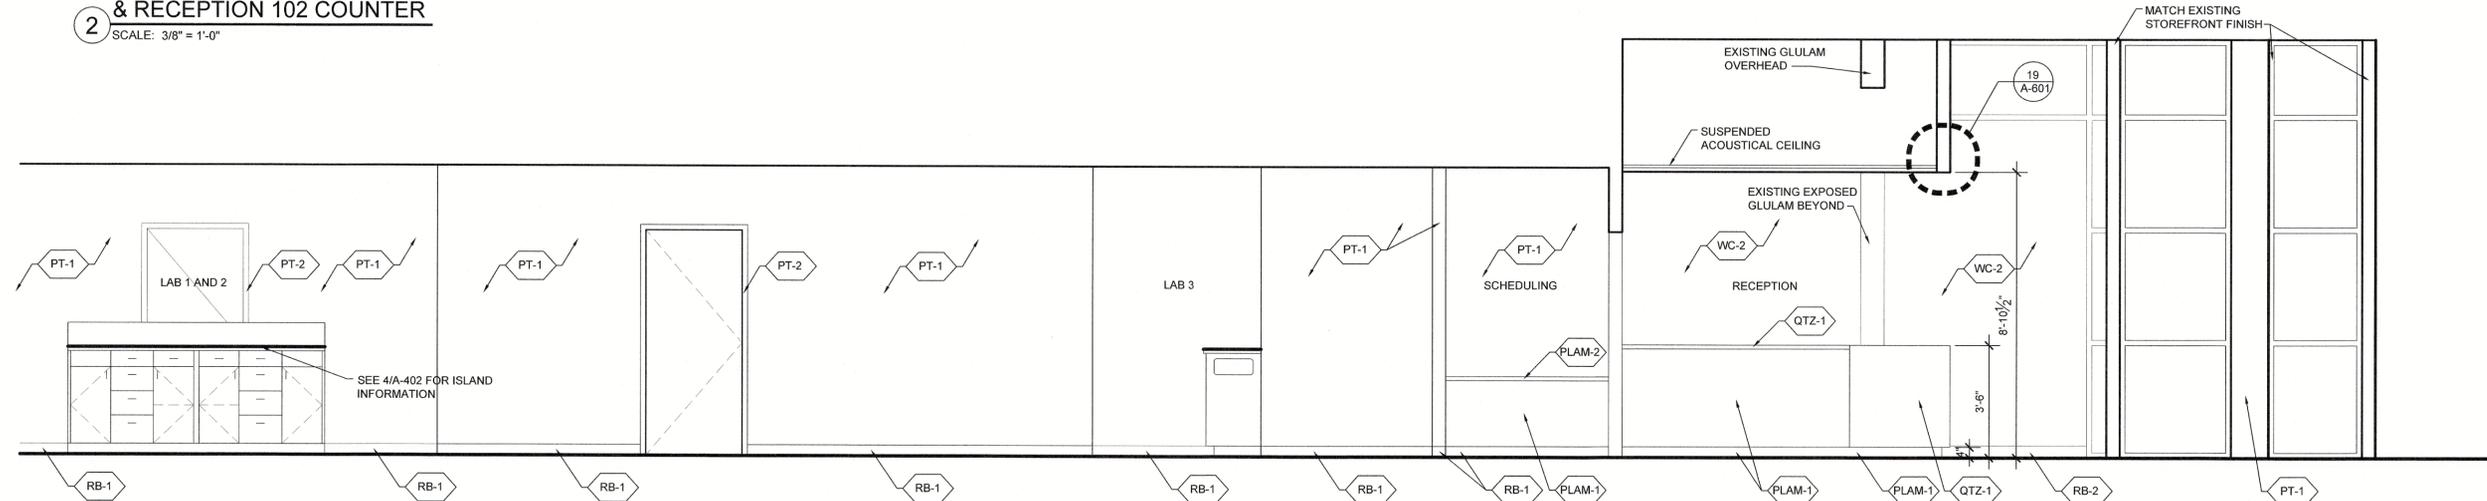

1 EAST ELEVATION LOBBY 101 AND CORRIDOR 2
SCALE: 3/8" = 1'-0"



NOLTE & ASSOCIATES, P.A.
ARCHITECTS / PLANNERS
9400 REEDS ROAD, SUITE 200
OVERLAND PARK, KANSAS 66207
(913) 322-2444
F.A.X. (913) 322-6277



Copyright © 2021

REMODEL
LEE'S SUMMIT
KCUC UROLOGY & ONCOLOGY
451 NW MURRAY ROAD
LEE'S SUMMIT, MISSOURI 64081
JACKSON COUNTY

This material is confidential, proprietary and owned solely by Nolte & Associates, P.A. By providing these documents, Nolte & Associates, P.A. assumes no responsibility for their accuracy, construction and detailing of information contained herein. Do not modify, duplicate, reproduce, disseminate or transfer this material without the express written permission of Nolte & Associates, P.A.

DATE PRINTED:
Oct 13, 2021

DATE ISSUED:
10.13.2021

REVISIONS:



ARCHITECTURAL PROJECT NUMBER
2021027

INTERIOR
ELEVATIONS



SHEET NUMBER
A-404

DOOR SCHEDULE


DOOR INFORMATION									FRAME INFORMATION				DETAILS				
DOOR	ROOM NUMBER	ROOM NAME	SIZE	MATERIAL	FINISH	TYPE	GLAZING	RATING	MATERIAL	FINISH	TYPE	RATING	HEAD	JAMB	SILL	HARDWARE	NOTES
100A	100	VESTIBULE	PR. 3'-0" X 7'-0"	ALUMINUM	MATCH EXISTING	4	TEMPERED	--	ALUMINUM	MATCH EXISTING	--	--	11.21/A-601	6.16/A-601	1/A-601	SET 1	NOTES
100B	100	VESTIBULE	3'-0" X 7'-0"	ALUMINUM	MATCH EXISTING	3	TEMPERED	--	ALUMINUM	MATCH EXISTING	--	--	7.12/A-601	2/A-601	1/A-601	SET 5	NOTES
101A	101	LOBBY	3'-0" X 7'-0"	SOLID CORE WOOD	STAINED	1	--	--	HOLLOW METAL	PAINTED	A	--	15/A-601	10/A-601	5/A-601	SET 3	NOTES
101B	101	LOBBY	3'-0" X 7'-0"	SOLID CORE WOOD	PAINTED	1	--	--	HOLLOW METAL	PAINTED	A	--	15/A-601	10/A-601	5/A-601	SET 3	NOTES
102	102	RECEPTION	3'-0" X 7'-0"	SOLID CORE WOOD	STAINED	1	--	--	HOLLOW METAL	PAINTED	A	--	15/A-601	10/A-601	5/A-601	SET 3	NOTES
104	104	EXAM 1	3'-6" X 7'-0"	SOLID CORE WOOD	STAINED	1	--	--	HOLLOW METAL	PAINTED	B	--	13/A-601	8/A-601	3/A-601	SET 3	NOTES
106	106	DOCTORS	3'-0" X 7'-0"	SOLID CORE WOOD	STAINED	1	--	--	HOLLOW METAL	PAINTED	A	--	15/A-601	10/A-601	5/A-601	SET 7	NOTES
107	119	DOCTORS ENTRY	3'-0" X 7'-0"	HOLLOW METAL	MATCH EXISTING	2	TEMPERED	--	ALUMINUM	MATCH EXISTING	A	--	15/A-601	10/A-601	5/A-601	SET 2	NOTES
108	108	WC	3'-0" X 7'-0"	SOLID CORE WOOD	STAINED	1	--	--	HOLLOW METAL	PAINTED	A	--	15/A-601	10/A-601	5/A-601	SET 6	NOTES
109	109	EXAM 2	3'-0" X 7'-0"	SOLID CORE WOOD	STAINED	1	--	--	HOLLOW METAL	PAINTED	A	--	11.21/A-601	6.16/A-601	1/A-601	SET 3	NOTES
110	110	EXAM 3	3'-0" X 7'-0"	SOLID CORE WOOD	STAINED	1	--	--	HOLLOW METAL	PAINTED	A	--	15/A-601	10/A-601	5/A-601	SET 3	NOTES
112	112	EXAM 4	3'-0" X 7'-0"	SOLID CORE WOOD	STAINED	1	--	--	HOLLOW METAL	PAINTED	A	--	15/A-601	10/A-601	5/A-601	SET 3	NOTES
C1	C1	CORRIDOR 1	3'-0" X 7'-0"	SOLID CORE WOOD	STAINED	1	--	--	HOLLOW METAL	PAINTED	A	--	15/A-601	10/A-601	5/A-601	SET 3	NOTES
114	114	EXAM 5	3'-0" X 7'-0"	SOLID CORE WOOD	STAINED	1	--	--	HOLLOW METAL	PAINTED	A	--	15/A-601	10/A-601	5/A-601	SET 3	NOTES
115	115	WC	3'-0" X 7'-0"	SOLID CORE WOOD	STAINED	1	--	--	HOLLOW METAL	PAINTED	A	--	15/A-601	10/A-601	5/A-601	SET 6	NOTES
116	116	STAFF WC	3'-0" X 7'-0"	SOLID CORE WOOD	STAINED	1	--	--	HOLLOW METAL	PAINTED	A	--	15/A-601	10/A-601	5/A-601	SET 6	NOTES
117	117	EXAM 6	3'-0" X 7'-0"	SOLID CORE WOOD	STAINED	1	--	--	HOLLOW METAL	PAINTED	A	--	15/A-601	10/A-601	5/A-601	SET 3	NOTES
118	118	SHARED STAFF	3'-0" X 7'-0"	SOLID CORE WOOD	STAINED	1	--	--	HOLLOW METAL	PAINTED	A	--	15/A-601	10/A-601	5/A-601	SET 3	NOTES
119	119	BREAKROOM	3'-0" X 7'-0"	SOLID CORE WOOD	STAINED	1	--	--	HOLLOW METAL	PAINTED	A	--	15/A-601	10/A-601	5/A-601	SET 3	NOTES
120	120	MECH	EXISTING	EXISTING	EXISTING	--	EXISTING	EXIST.	EXISTING	EXISTING	EXIST.	EXIST.	EXISTING	EXISTING	EXISTING	EXISTING	NOTES
120A	120A	MECH VESTIBULE	3'-0" X 7'-0"	SOLID CORE WOOD	STAINED	1	--	1 HOUR	HOLLOW METAL	PAINTED	A	EXIST.	15/A-601	10/A-601	5/A-601	SET 7	1 HOUR FIRE RATED DOOR
121	121	IT	3'-0" X 7'-0"	SOLID CORE WOOD	STAINED	1	--	--	HOLLOW METAL	PAINTED	A	--	15/A-601	10/A-601	5/A-601	SET 7	NOTES
122	122	STAFF (4)	3'-0" X 7'-0"	SOLID CORE WOOD	STAINED	1B	--	--	HOLLOW METAL	PAINTED	1B	--	15/A-601	10/A-601	5/A-601	SET 4	POCKET DOOR
123	123A	STORAGE	3'-0" X 7'-0"	SOLID CORE WOOD	STAINED	1	--	--	HOLLOW METAL	PAINTED	A	--	15/A-601	10/A-601	5/A-601	SET 7	NOTES
123	123B	STORAGE	3'-0" X 7'-0"	SOLID CORE WOOD	STAINED	1	--	--	HOLLOW METAL	PAINTED	A	--	15/A-601	10/A-601	5/A-601	SET 7	NOTES
124	124	SOILED	3'-0" X 7'-0"	SOLID CORE WOOD	STAINED	1	--	--	HOLLOW METAL	PAINTED	A	--	15/A-601	10/A-601	5/A-601	SET 3	NOTES
125	125	STAFF (4)	3'-0" X 7'-0"	SOLID CORE WOOD	STAINED	1B	--	--	HOLLOW METAL	PAINTED	1B	--	15/A-601	10/A-601	5/A-601	SET 4	POCKET DOOR
126	126	EXAM 7	3'-0" X 7'-0"	SOLID CORE WOOD	STAINED	1	--	--	HOLLOW METAL	PAINTED	A	--	15/A-601	10/A-601	5/A-601	SET 3	NOTES
127	127	EXAM 8	3'-0" X 7'-0"	SOLID CORE WOOD	STAINED	1	--	--	HOLLOW METAL	PAINTED	A	--	15/A-601	10/A-601	5/A-601	SET 3	NOTES
128	128	WC	3'-0" X 7'-0"	SOLID CORE WOOD	STAINED	1	--	--	HOLLOW METAL	PAINTED	A	--	15/A-601	10/A-601	5/A-601	SET 6	NOTES
129	129	EXAM 9	3'-0" X 7'-0"	SOLID CORE WOOD	STAINED	1	--	--	HOLLOW METAL	PAINTED	A	--	15/A-601	10/A-601	5/A-601	SET 3	NOTES
130	130	NURSES	3'-0" X 7'-0"	SOLID CORE WOOD	STAINED	1	--	--	HOLLOW METAL	PAINTED	A	--	15/A-601	10/A-601	5/A-601	SET 3	NOTES
131	131	PHLEBOTOMY	3'-0" X 7'-0"	SOLID CORE WOOD	STAINED	1B	--	--	HOLLOW METAL	PAINTED	1B	--	15/A-601	10/A-601	5/A-601	SET 4	POCKET DOOR

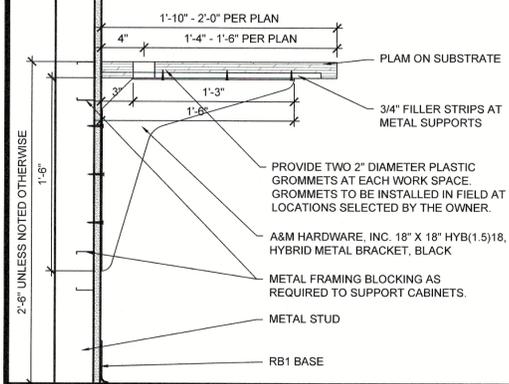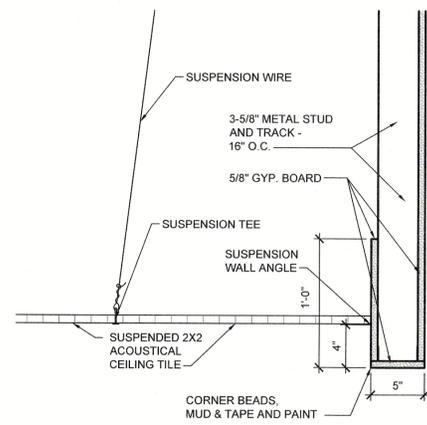


RECEPTION COUNTER SOFFIT
SCALE: 1/2"=1'-0"

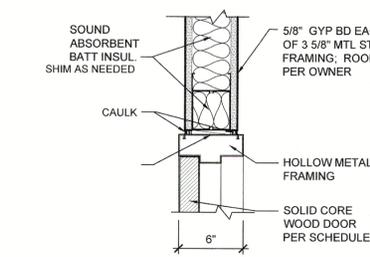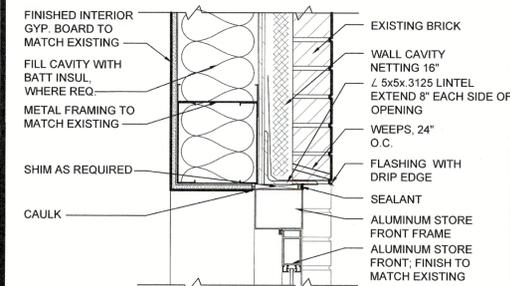



EXTERIOR EXIT DOOR HEAD
SCALE: 1/2"=1'-0"

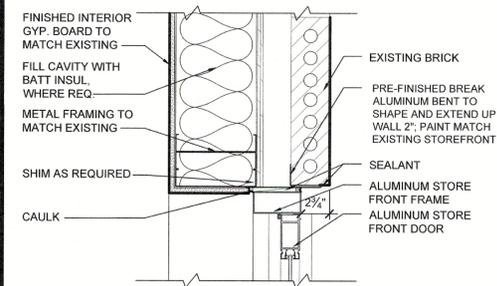


INTERIOR DOOR JAMB
SCALE: 1/2"=1'-0"

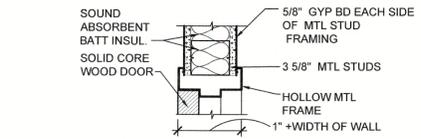

EXTERIOR EXIT DOOR JAMB
SCALE: 1/2"=1'-0"

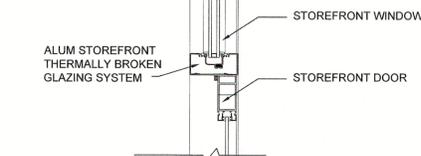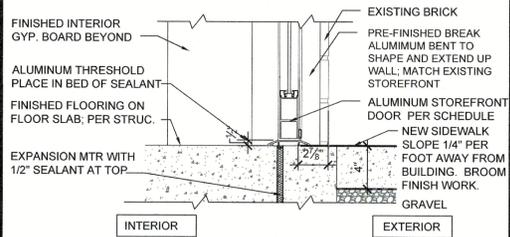

EXTERIOR EXIT DOOR THRESHOLD
SCALE: 1/2"=1'-0"

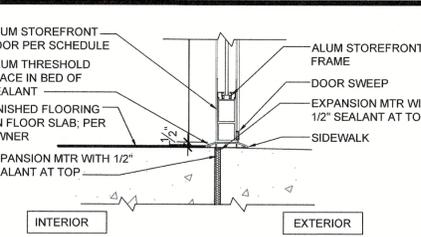


STOREFRONT THRESHOLD
SCALE: 1/2"=1'-0"

HARDWARE SCHEDULE

NOTE: HARDWARE SHOWN FOR REFERENCE ONLY. ALL HARDWARE BY DOOR SUPPLIER. ALL HARDWARE SET TO BE KEVD TO OWNER'S SYSTEM.

- SET 1: 3 PAIR HINGE/2 EA - HW HINGE (NRP), 1 EA - PANIC HDWR W/ CYLINDER TRIM, 1 EA CYLINDER (ACTIVE DOOR), 1 EA 90 DEG. OFFSET PULL, 2 EA CLOSER PA W/ STOP, 1 EA SURFACE BOLTS (INACTIVE DOOR), 2 EA DOOR SWEEP, 2 EA WEATHERSTRIP BY DOOR SUPPLIER, 1 EA THRESHOLD
- SET 2: 3 EA HW HINGE (NRP), 1 EA PANIC HDWR (NIGHT LATCH TRIM), 1 EA CYLINDER, 1 EA 90 DEG. OFFSET PULL, 1 EA CLOSER PA W/STOP, 1 EA KICK PLATE, 1 EA SURFACE BOLTS, 1 EA DOOR SWEEP, 1 EA THRESHOLD, 1 EA RAIN DRIP EACH TO HAVE.
- SET 3: 3 PAIR HINGE - HW HINGE, 1 EA - PASSAGE SET, 1 EA - DOOR STOP, 1 EA - KICK PLATE
- SET 4: 1 EA - PASSAGE POCKET SET
- SET 5: 3 PAIR HINGE - HW HINGE, 1 EA - PUSH/PULL, 1 EA - CLOSER, 1 EA - DOOR STOP, 1 EA - DOOR SILENCER, 1 EA - KICK PLATE
- SET 6: 3 PAIR HINGE - HW HINGE, 1 EA - PRIVACY LOCK, 1 EA - CLOSER, 1 EA - KICK PLATE, 1 EA - DOOR STOP, 1 EA - DOOR SILENCER
- SET 7: 3 PAIR HINGE - HW HINGE, 1 EA - ENTRY/OFFICE LOCK, 1 EA - CLOSER, 1 EA - KICK PLATE, 1 EA - DOOR SILENCER

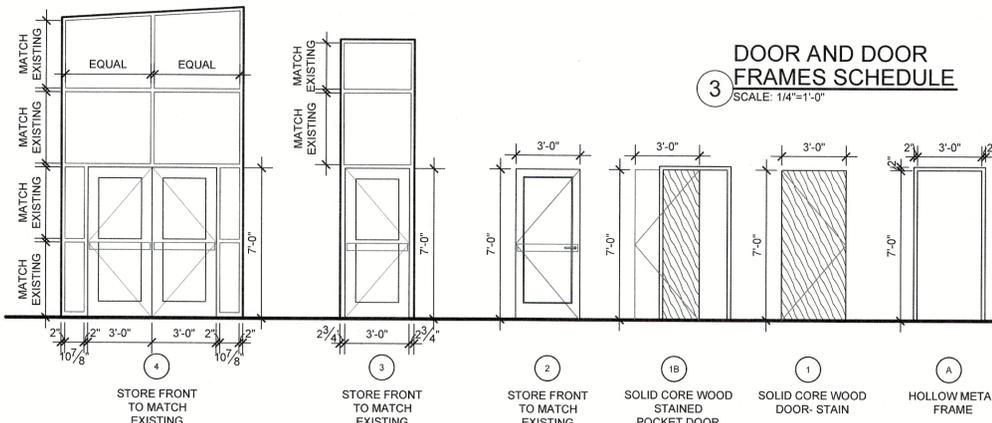

NOLTE & ASSOCIATES, P.A.
ARCHITECTS / PLANNERS
8400 REEDS ROAD, SUITE 200
OVERLAND PARK, MISSOURI 66207
TEL: (816) 322-9277
FAX: (816) 322-9277



REMODEL
LEE'S SUMMIT
KCUC UROLOGY & ONCOLOGY
451 NW MURRAY ROAD
LEE'S SUMMIT, MISSOURI 64081
JACKSON COUNTY

DATE PRINTED:
Oct 13, 2021

DATE ISSUED:
10.13.2021

REVISIONS:

ARCHITECTURAL PROJECT NUMBER
2021027

DOOR SCHEDULE AND DETAILS

SHEET NUMBER
A-601

Drawing Name: F:\2021\2021027 - Jayger - KCUC Lee's Summit\Production\04 - Construction Documents\2021027 A-601 Schedules.dwg Last Modified: Oct 13, 2021 - 6:08pm Plotted on: Oct 13, 2021 - 10:21am by mwinslow

FINISH SCHEDULE

ROOM NUMBER	ROOM NAME	FLOORING	FLOOR BASE	COUNTER TOPS	CABINETS	WALLS	NORTH	WEST	SOUTH	EAST	CEILING	FINISH	HEIGHT	NOTES
100	VESTIBULE	T-1	--	--	--	--	--	--	--	--	EXISTING	PT-3	OPEN	--
101	LOBBY/WAITING	CPT-1	RB-2	--	--	WC-2	WC-2	WC-2	--	--	EXISTING	PT-3	OPEN	--
102	RECEPTION	CPT-1	RB-2	QTZ-1*	PLAM-1	PT-1	PT-1	PT-1	PT-1	PT-1	ACT-1	WHITE	9'-0"	*SEE ELEV.
103	SCHEDULING	CPT-1	RB-2	--	PLAM-1	PT-1	PT-1	PT-1	PT-1	PT-1	ACT-1	WHITE	9'-0"	--
104	EXAM 1	LVT-1	RB-1	PLAM-2	PLAM-1	PT-1A	WC-1	WC-1	WC-1	WC-1	ACT-1	WHITE	9'-0"	--
105	LAB 3	LVT-1	RB-1	SSF-1	PLAM-1	PT-1A	WC-1	WC-1	WC-1	WC-1	ACT-1	WHITE	9'-0"	--
106	DOCTORS	CPT-1	RB-1	PLAM-2	--	PT-1	PT-1	PT-1	PT-1	PT-1	ACT-1	WHITE	9'-0"	--
107	DOCTOR'S ENTRY	T-1	B-2	--	--	PT-1	PT-1	PT-1	PT-1	PT-1/WT-1*	ACT-1	WHITE	9'-0"	*SEE ELEV.
108	WC	T-1	B-2	--	--	PT-1A	WT-1	PT-1A	PT-1A	PT-1A	ACT-1	WHITE	9'-0"	--
109	EXAM 2	LVT-1	RB-1	PLAM-2	PLAM-1	PT-1A	WC-1	WC-1	WC-1	WC-1	ACT-1	WHITE	9'-0"	--
110	EXAM 3	LVT-1	RB-1	PLAM-2	PLAM-1	WC-1	WC-1	WC-1	PT-1A	WC-1	ACT-1	WHITE	9'-0"	--
111	LAB 2	LVT-1	RB-1	SSF-1	PLAM-1	PT-1	PT-1	PT-1A	PT-1	PT-1	ACT-1	WHITE	9'-0"	--
112	EXAM 4	LVT-1	RB-1	PLAM-2	PLAM-1	PT-1A	WC-1	WC-1	WC-1	WC-1	ACT-1	WHITE	9'-0"	--
113	LAB 1	LVT-1	RB-1	SSF-1	PLAM-1	PT-1A	PT-1	PT-1	PT-1	PT-1	ACT-1	WHITE	9'-0"	--
C1	CORRIDOR 1	CPT-1	RB-1	--	--	PT-1	PT-1	PT-1	PT-1	PT-1	ACT-1	WHITE	9'-0"	--
114	EXAM 5	LVT-1	RB-1	PLAM-2	PLAM-1	WC-1	WC-1	PT-1A	WC-1	WC-1	ACT-1	WHITE	9'-0"	--
115	WC	T-1	B-2	--	--	WT-1	PT-1A	PT-1A	PT-1A	PT-1A	ACT-1	WHITE	9'-0"	--
116	STAFF WC	T-1	B-2	--	--	PT-1A	WT-1	PT-1A	PT-1A	PT-1A	ACT-1	WHITE	9'-0"	--
117	EXAM 6	LVT-1	RB-1	PLAM-2	PLAM-1	PT-1A	WC-1	WC-1	WC-1	WC-1	ACT-1	WHITE	9'-0"	--
118	STAFF (7)	CPT-1	B-2	PLAM-2	--	PT-1	PT-1	PT-1	PT-1	PT-1	ACT-1	WHITE	9'-0"	--
119	STAFF LOUNGE	LVT-1	RB-1	PLAM-2	PLAM-1	PT-1	PT-1	PT-1	PT-1	PT-1	ACT-1	WHITE	9'-0"	--
120	MECHANICAL	CONC	--	--	--	PT-1	PT-1	PT-1	PT-1	PT-1	OPEN	--	OPEN	--
121	IT	CONC	--	--	--	PT-1	PT-1	PT-1	PT-1	PT-1	OPEN	--	OPEN	--
122	STAFF (4)	CPT-1	RB-1	PLAM-2	--	PT-1	PT-1	PT-1	PT-1	PT-1	ACT-1	WHITE	9'-0"	--
123	STORAGE	LVT-1	RB-1	--	--	PT-1	PT-1	PT-1	PT-1	PT-1	ACT-1	WHITE	9'-0"	--
124	SOILED	LVT-1	RB-1	--	--	PT-1	PT-1A	WC-1	WC-1	WC-1	ACT-1	WHITE	9'-0"	--
125	STAFF (4)	CPT-1	RB-1	PLAM-2	--	PT-1	PT-1	PT-1	PT-1	PT-1	ACT-1	WHITE	9'-0"	--
C3	CORRIDOR 3	CPT-1	RB-1	--	--	PT-1	PT-1	PT-1	PT-1	PT-1	ACT-1	WHITE	9'-0"	--
126	EXAM 7	LVT-1	RB-1	PLAM-2	PLAM-1	WC-1	WC-1	PT-1A	WC-1	WC-1	ACT-1	WHITE	9'-0"	--
127	EXAM 8	LVT-1	RB-1	PLAM-2	PLAM-1	PT-1A	WC-1	WC-1	WC-1	WC-1	ACT-1	WHITE	9'-0"	--
128	WC	T-1	B-2	--	--	PT-1A	PT-1A	PT-1A	PT-1A	PT-1A	ACT-1	WHITE	9'-0"	--
129	EXAM 9	LVT-1	RB-1	PLAM-2	PLAM-1	WC-1	WC-1	PT-1A	WC-1	WC-1	ACT-1	WHITE	9'-0"	--
130	NURSES	CPT-1	RB-1	PLAM-2	--	PT-1	PT-1	PT-1	PT-1	PT-1	ACT-1	WHITE	9'-0"	--
131	PHLEBOTOMY	LVT-1	RB-1	PLAM-2	PLAM-1	WC-1	WC-1	PT-1A	WC-1	WC-1	ACT-1	WHITE	9'-0"	--
C2	CORRIDOR 2	CPT-1	RB-1	--	--	PT-1	PT-1	PT-1	PT-1	PT-1	ACT-1	WHITE	9'-0"	--

GENERAL ROOM FINISH NOTES

A	REFER TO FINISH PLAN AND INTERIOR ELEVATIONS FOR WALL FINISHES. ALL FINISH ABBREVIATIONS SHOWN ON THIS SHEET IN FINISH KEY.
B	ALL SOLID WOOD, WOOD VENEER AND PLASTIC LAMINATE GRAIN SHALL BE VERTICALLY ORIENTATED UNLESS OTHERWISE NOTED.
C	DOOR FRAMES, HOLLOW METAL WNDOW FRAMES TO BE PT-2, STOREFRONT FRAMES TO MATCH EXISTING.
D	ALL FACES AND UNDERSIDES OF SOFFITS AND HEADERS TO BE PT-1 UNLESS OTHERWISE NOTES.
E	WALL EXPANSION JOINTS TO BE PAINTED PT-1 UNLESS OTHERWISE NOTED.
F	ALL ELECTRICAL PANELS AND METAL GRILLS SHALL BE PAINTED TO MATCH ADJACENT WALL SURFACE UNLESS OTHERWISE NOTED.
G	ALL GROUT TO BE GR-1, MEIPEI 14 BISCUIT UNLESS OTHERWISE NOTED.
H	WHERE A WALL IS INDICATED TO HAVE PARTIAL OR FULL HEIGHT WALL PROTECTION, THE ENTIRE WALL IS TO BE PAINTED PRIOR TO WALL PROTECTION INSTALLATION.
I	EXTEND ALL FINISHES BENEATH, BEHIND, AROUND ALL CASEWORK, EQUIPMENT, SIGNAGE, ETC.
J	ALL EXAM, LAB AND BREAKROOM SINKS TO BE STAINLESS STEEL.
K	ALL FLOOR MATERIALS TRANSITIONS AT DOORS TO BE MADE AT CENTER OF DOOR IN CLOSED POSITION.
L	SEE FINISH KEY FOR ALL TRANSITION MATERIALS AND LOCATIONS.

FINISHING KEY

LABEL	TYPE	MANUFACTURER	STYLE	COLOR	SIZE/NOTES
CEILING					
HC1	HARD CEILING	GYP BOARD	FLAT	TBD	
OPEN	OPEN TO STRUCTURE ABOVE	MANUFACTURER	STYLE	TBD	
ACT-1	2 X 2 CEILING GRID	USG MARS ACOUSTICAL PANEL	CLIMAPLUS PERFORMANCE	WHITE	USG DONN BRAND DX/DXL 15/16" ACOUSTICAL SUSPENSION SYSTEM (WHITE)
WALLS					
PT-1	PAINT	SHERWIN WILLIAMS	EGGSHELL	SW6141 SOFTER TAN	FIELD PAINT
PT-1A	PAINT	SHERWIN WILLIAMS	EPOXY	SW6141 SOFTER TAN	FIELD PAINT
PT-2	PAINT	SHERWIN WILLIAMS	SEMI-GLOSS	SW7048 URBAN BRONZE	HOLLOW METAL DOOR AND WINDOW FRAMES
PT-3	PAINT	SHERWIN WILLIAMS	FLAT FINISH	SW7007 CEILING BRIGHT WHITE	CEILING PAINT
PT-4	PAINT	SHERWIN WILLIAMS	EGGSHELL	SW6236 GRAYS HARBOR	ACCENT PAINT
PT-4A	PAINT	SHERWIN WILLIAMS	EPOXY	SW6236 GRAYS HARBOR	ACCENT PAINT
PT-5	PAINT	SHERWIN WILLIAMS	EPOXY	SW7008 ALABASTER	LAB PAINT
WT-1	WALL TILE	DALTILE	COVE CREEK	WHITE, MATTE FINISH - 12 x 24	1/3 OFFSET INSTALLATION
FRP-1	WALL BOARD	PANOLAM SURFACE SYSTEMS	FIBERGLASS REINFORCED PLASTIC	WHITE	
WC-1	VINYL WALL COVERING	MDC	ESQUIRE COLLECTION	PAKHRA ASH MPK9418	EXAMS
WC-2	VINYL WALL COVERING	MDC	ESQUIRE COLLECTION	PAKHRA SLATE MPK9414	WAITING ROOM
WP-1	WALL PROTECTION	INPRO	RIGID SHEET	GALA 0380	EXAMS, USE MATCHING TRIMS
WP-2	WALL PROTECTION	INPRO	ELEMENTS PATTERNS	5E018 FIBER TERRA	TBD, USE MATCHING TRIMS
WALL TRIM					
WT-1	METAL WALL TRIM (CORNER EDGE)	SCHLUTER	ECK-K	BRUSHED STAINLESS STEEL	TO BE USED WITH WC-1 AND WC-2
WT-2	METAL WALL TRIM (TOP EDGE)	SCHLUTER	JOLLY	BRUSHED STAINLESS STEEL	TO BE USED AT TOP OF MT-1
COUNTERS & CABINETS					
PLAM-1	PLASTIC LAMINATE	NEVAMAR	W8294	CROWN CHERRY	USE MATCHING EDGE BANDING
PLAM-2	PLASTIC LAMINATE	NEVAMAR	EM6001	AGED ELEM.ENTS	USE MATCHING EDGE BANDING
SSF-1	SOLID SURFACE	LG HAUSYS	HI-MACS	GT914 MERINO	1/2" THICK, EASED EDGE
QTZ-1	QUARTZ	CAMBRIA	CLASSIC COLLECTION	DOVEDALE	3 CM THICK, SEACLIFF PROFILE, GLOSS FINISH
WALL BASE					
B-1	METAL COVE BASE	SCHULTER	DILEX-AHK	SATIN NICKEL ANODIZED ALUMINUM	TO BE USED WITH WT-1 AND T-1 ON TOILET WET WALL
B-2	PORCELAIN TILE BASE	DALTILE	COVE CREEK	CC10 GREY	CUT DOWN TO 6 X 24, TO BE USED ON NON-WET WALLS IN TOILETS, APPLY SCHLUTER TRIM TO FINISH
RB-1	RESILIENT BASE	JOHNSONITE	4" COVE - BASEWORKS THERMOSET (TX)	63 BURNT UMBER	
RB-2	RESILIENT BASE	JOHNSONITE	4-11/4" MILLWORK REVEAL	63 BURN UMBER	WAITING ROOM/MITER CORNERS
FLOORING					
CPT-1	CARPET	PATCRAFT	I0290 - THOUGHT MODULAR	00550 - UNDERSTANDING	MONOLITHIC INSTALLATION
LVT-1	LUXURY VINYL PLANK	ARMSTRONG	CLASSICS BUCKHEAD OAK	SAVANNAH TP101	ASHLAR INSTALLATION
T-1	PORCELAIN FLOOR TILE	DALTILE	COVE CREEK	CC10 GRAY	1/3 OFFSET INSTALLATION
T-2	PORCELAIN FLOOR TILE	VIRGINIA TILE	ATLAS CONCORDE - SIGN	WHITE, MATTE FINISH, 12" X 24"	1/3 OFFSET INSTALLATION
T-3	PORCELAIN FLOOR TILE	ERGON	ARCHITECT RESIN 639G5R	LONDON SMOKE, MATTE FINISH 12" X 24	1/3 OFFSET INSTALLATION
CONC	SEALED CONCRETE	--	--	--	--
GR-1	GROUT	MEIPEI	ULTRA COLOR PLUS MAX	14 BISCUIT	TO BE USED WITH ALL T-1, WT-1 AND TRIMS
FLOOR TRANSITIONS					
TR-1	RUBBER TRANSITION STRIP	JOHNSONITE	SLTC-XX-J	63 BURN UMBER	LVT TO CARPET
TR-2	METAL TRANSITION STRIP	SCHLUTER	SCHIENE	BRUSHED STAINLESS STEEL	CARPET TO FLOOR TILE
TR-3	METAL TRANSITION STRIP	SCHLUTER	RENO-U	BRUSHED STAINLESS STEEL	FLOOR TILE TO LVT
FABRICS					
F-1	PRIVACY CURTAIN	TBD	TBD	TBD	
F-2	TACK BOARD FABRIC	MAHARAM	MANNER 466177	005 HUSH	



NOLTE & ASSOCIATES, P.A.
ARCHITECTS / PLANNERS
6400 REEDS ROAD, SUITE 200
OVERLAND PARK, KANSAS 66207
913.322.2444
FAX: (913) 322-8277



REMODEL
LEE'S SUMMIT
KCUC UROLOGY & ONCOLOGY
451 NW MURRAY ROAD
LEE'S SUMMIT, MISSOURI 64081
JACKSON COUNTY

DATE PRINTED:
Oct 13, 2021

DATE ISSUED:
10.13.2021

REVISIONS:

ARCHITECTURAL PROJECT NUMBER
2021027

FINISH
SCHEDULES
AND DETAILS

SHEET NUMBER
A-602

Drawing Name: F:\2021\2021027 - Jayger - KCUC Lee's Summit\Production\04 - Construction Documents\2021027 A-602 Finishes.dwg Last Modified: Oct 08, 2021 - 4:50pm Plotted on: Oct 13, 2021 - 10:23am by mwinslow

MECHANICAL/PLUMBING SPECIFICATION

- INSTALLATION SHALL BE IN ACCORDANCE WITH THE 2018 INTERNATIONAL MECHANICAL, PLUMBING AND FUEL GAS CODES, NFPA 90A AND 101 AND ALL STATE AND LOCAL CODES, ORDINANCES AND REGULATIONS.
- PLANS AND SPECIFICATIONS SHALL TAKE PRECEDENCE OVER THE CODE WHERE CODE REQUIREMENTS ARE EXCEEDED.
- DRAWINGS ARE DIAGRAMMATIC AND ARE INTENDED TO INDICATE THE GENERAL DESIGN CONCEPT THEY DO NOT NECESSARILY INDICATE EACH AND EVERY FITTING OR FEATURE. THE CONTRACTOR SHALL PROVIDE ALL ITEMS NECESSARY FOR AN INSTALLATION THAT IS COMPLETE IN EVERY RESPECT.
- DRAWINGS SHOWING EXISTING CONDITIONS ARE BASED ON INFORMATION FURNISHED BY OTHERS. EXISTING BUILDING CONSTRUCTION & RECORD DRAWINGS AND LIMITED SITE OBSERVATIONS. THEY ARE INTENDED TO INDICATE DESIGN CONCEPTS ONLY AND ARE NOT GUARANTEED TO BE 100% ACCURATE OR ALL INCLUSIVE NOR DO THEY NECESSARILY SHOW EACH AND EVERY FITTING AND DEVICE NOR ARE THEY GUARANTEED TO SHOW EACH AND EVERY ITEM REQUIRING REMOVAL AND/OR RELOCATION. THE CONTRACTOR IS RESPONSIBLE FOR FIELD VERIFICATION OF ALL EXISTING CONDITIONS AND HOW THEY MAY AFFECT THE PROSECUTION OF THE WORK OF THIS CONTRACT.
- CONTRACTOR SHALL FULLY COOPERATE WITH THE GENERAL CONTRACTOR TO MAINTAIN THE SCHEDULE AND PHASING OF THE WORK. REFER TO ARCHITECTURAL AND DIVISION 1 SPECIFICATIONS.
- 'FURNISHED' SHALL MEAN CONTRACTOR SHALL SUPPLY THE INDICATED ITEM. 'INSTALLED' SHALL MEAN CONTRACTOR SHALL PROVIDE LABOR TO PLACE THE ITEM IN SERVICE. 'PROVIDED' SHALL MEAN CONTRACTOR SHALL FURNISH AND INSTALL THE ITEM.
- REFER TO ARCHITECTURAL AND STRUCTURAL DRAWINGS FOR DIMENSIONS. DO NOT SCALE MECHANICAL DRAWINGS. CONFORM TO ARCHITECTURAL AND STRUCTURAL REQUIREMENTS FOR EXACT PLACEMENT AND LOCATION OF EQUIPMENT AND FOR REQUIRED STRUCTURAL SUPPORT, BRACING AND REINFORCEMENT.
- REFER TO STRUCTURAL DRAWINGS FOR SPECIFIC REQUIREMENTS CONCERNING EQUIPMENT PAD CONSTRUCTION, STRUCTURAL SUPPORTS AND MOUNTINGS FOR MECHANICAL EQUIPMENT AND SUPPLEMENTAL STEEL.
- VERIFY ALL ACTUAL JOB CONDITIONS AND DETERMINE WHICH MAY AFFECT PROSECUTION OF THE WORK. COORDINATE WITH BUILDING STRUCTURE, EXISTING CONDITIONS AND ALL OTHER TRADES AS REQUIRED TO PROPERLY, NEATLY AND ORDERLY INSTALL ALL SYSTEMS WITHIN THE CONFINES OF THE SPACE AVAILABLE AND WITHOUT INTERFERENCES. ANY CONFLICTS SHALL BE BROUGHT TO THE ATTENTION OF THE ARCHITECT PRIOR TO THE PURCHASE OF EQUIPMENT AND COMMENCEMENT OF THE WORK. FAILURE TO DETERMINE ACTUAL CONDITIONS WILL NOT BE CONSIDERED GROUNDS FOR GRANTING ADDITIONAL COMPENSATION OR TIME.
- VERIFY EXACT LOCATION, SIZE, CONDITION AND SERVICE OF EXISTING DUCTWORK, PIPING AND EQUIPMENT. DETERMINE SUITABILITY OF USE, CAPACITY AND CONNECTION PRIOR TO MAKING NEW CONNECTIONS. NOTIFY A/E OF ANY OBSERVED OR SUSPECTED DEFICIENCY.
- VERIFY ALL EQUIPMENT TO BE INSTALLED (WHETHER FURNISHED BY THIS CONTRACTOR OR BY OTHERS), CONFIRM WITH VENDOR CONNECTION SIZES, TYPES AND LOCATION AND PROVIDE MATCHING DUCT AND/OR PIPING CONNECTIONS, SIZES AND TYPES AFTER EQUIPMENT PROCUREMENT. PROVIDE ALL FITTINGS AND ACCESSORIES FOR A COMPLETE CODE COMPLIANT WORKING INSTALLATION.
- COORDINATE EXACT LOCATIONS AND ORIENTATION OF EQUIPMENT WITH ARCHITECTURAL AND STRUCTURAL REQUIREMENTS. EQUIPMENT SHALL BE SCREENED IN ACCORDANCE WITH LOCAL JURISDICTION REQUIREMENTS AND AS SHOWN ON ARCHITECTURAL DRAWINGS.
- EQUIPMENT AND MATERIALS IDENTIFIED ON THESE DRAWINGS SHALL BE FURNISHED AS SPECIFIED EXCEPT THAT EQUIVALENT PRODUCTS BY ALTERNATE MANUFACTURERS THAT MEET ALL SPECIFICATION REQUIREMENTS MAY BE CONSIDERED. THE CONTRACTOR SHALL OBTAIN APPROVAL FROM THE A/E FOR ANY SUBSTITUTION. APPROPRIATE DOCUMENTATION PROVING THAT THE PRODUCT IS EQUAL TO THAT SPECIFIED MAY BE REQUESTED BY THE A/E. THE BURDEN OF PROOF THAT THE PRODUCT IS EQUIVALENT SHALL BE WHOLLY THE RESPONSIBILITY OF THE SUBMITTING CONTRACTOR. ALL EQUIPMENT SHALL BE PROVIDED WITH A 1-YEAR WARRANTY UNLESS OTHERWISE NOTED.
- DUCTWORK FABRICATION AND INSTALLATION SHALL BE IN ACCORDANCE WITH SMACNA STANDARDS.
- ALL DUCTWORK SHALL BE SHEET METAL, CONSTRUCTED TO SMACNA STANDARDS, MINIMUM OF 2" WG PRESSURE CLASS AND SEAL CLASS "B" MINIMUM. LONGITUDINAL AND TRANSVERSE JOINTS TO BE SEALED, EXCEPT AS OTHERWISE NOTED. ROUND AND FLEX DUCT CONNECTIONS SHALL BE MADE WITH SPIN COLLARS WITH EXTRACTORS AND VOLUME DAMPERS.
- DUCT SIZES SHOWN ARE CLEAR INSIDE DIMENSIONS. CONTRACTOR SHALL INCLUDE AN ALLOWANCE FOR 1" DUCT LINER IN LOW VELOCITY DUCTS WHERE APPLICABLE.
- DUCT RUNOUT SIZES NOT SHOWN SHALL BE THE SAME SIZE AS THE DIFFUSER NECK CONNECTION.
- MOUNT DIFFUSERS IN LOCATIONS AS SHOWN, COORDINATE WITH CEILING GRID, LIGHTING, SPRINKLERS AND OTHER CEILING MOUNTED DEVICES. LIGHTING AND SPRINKLER HEAD PLACEMENT SHALL TAKE PRECEDENCE. REFER TO ARCHITECTURAL REFLECTED CEILING PLAN WHERE APPLICABLE.
- CONTRACTOR SHALL INSURE THAT A PROPER RETURN AIR PATH EXISTS FROM EACH SPACE, WHERE NOT OTHERWISE INDICATED AND IN RETURN AIR PLENUM APPLICATIONS, PROVIDE FLANGED RETURN AIR OPENINGS ABOVE CEILING LEVEL, THRU WALLS TO STRUCTURE, SO THAT RETURN AIR VELOCITY AND PRESSURE DROP DOES NOT EXCEED 1000 FPM AND 0.065" WG/100' RESPECTIVELY.
- PROVIDE FLEXIBLE FABRIC CONNECTORS AT ALL DUCTWORK CONNECTIONS TO ROTATING EQUIPMENT. CONNECTORS EXPOSED TO SUNLIGHT SHALL BE MADE OF UV RESISTANT MATERIAL.
- ROUND OR OVAL EXPOSED DUCT SHALL BE SPIRAL DUCT, PAINT GRADE WHERE SCHEDULED BY ARCHITECT TO BE PAINTED.
- FLEX DUCT SHALL BE UL CLASS 1 AIR DUCT SUITABLE FOR +/- 2" WG PRESSURE WITH 1-1/2" FIBERGLASS INSULATION WITH AL SERVICE JACKET, 5" MAXIMUM LENGTH, ENDS BANDED IN PLACE AND TAPED WITH FOIL TAPE. ADEQUATELY SUPPORT FLEX DUCT TO PREVENT KINKS OR OBSTRUCTIONS. PROVIDE SHEET METAL ELBOW OR THERMAFLEX 'FLEXFLOW' ELBOW SUPPORT AT DIFFUSER CONNECTION.
- ALL MECHANICAL AND PLUMBING EQUIPMENT SHALL BE INSTALLED PER MANUFACTURER'S REQUIREMENTS AND PER LISTINGS. PROVIDE MANUFACTURER'S RECOMMENDED OPERATING AND SERVICE CLEARANCES FOR ALL EQUIPMENT. THE CONTRACTOR IS RESPONSIBLE FOR DIMENSIONS AND DIFFERING CLEARANCE REQUIREMENTS OF ACTUAL EQUIPMENT FURNISHED.
- SUPPORT ALL SUSPENDED EQUIPMENT, DUCTWORK AND PIPING INDEPENDENTLY, DIRECTLY FROM STRUCTURAL MEMBERS (NOT METAL DECK) IN ACCORDANCE WITH MANUFACTURER REQUIREMENTS AND INDUSTRY STANDARDS TO PREVENT SAGS AND DIPS. PROVIDE STRUTS AND PIPE CLAMPS ON 8' CENTERS AND SUPPORT ALL PIPING RISERS AT BASE OF RISER. THE USE OF RISER CLAMPS TO SUPPORT VERTICAL PIPING IS PROHIBITED.
- ALL WATER BEARING PIPING SHALL BE SLOPED FOR DRAINAGE WITH BALL DRAIN VALVES AT LOW POINTS.
- PROVIDE ACCESS PANELS TO PROVIDE ACCESS TO INACCESSIBLE VALVES, DAMPERS ANY ANY OTHER EQUIPMENT/DEVICES THAT REQUIRE ADJUSTMENT OR REPLACEMENT.
- DRAINAGE PIPING SHALL BE SLOPED IN ACCORDANCE WITH CODE, BUT NOT LESS THAN 1/8" PER FOOT FOR 3" AND LARGER PIPING AND 1/4" PER FOOT FOR 2-1/2" AND SMALLER PIPING. ALL INVERT ELEVATIONS SHALL BE COORDINATED WITH THE STRUCTURAL FOOTINGS.
- PROVIDE DIELECTRIC UNIONS AT ALL CONNECTIONS BETWEEN DISSIMILAR METALS.
- WHERE CHILLED CONDENSATE FROM INDOOR UNITS CANNOT BE POSITIVELY DRAINED, PROVIDE CONDENSATE PUMP ACCESSORY WITH THE EQUIPMENT.




- COORDINATE ALL UNDERGROUND PIPING WITH GRADE BEAMS, WALL FOOTINGS, COLUMN FOUNDATIONS AND OTHER STRUCTURAL CONDITIONS. COORDINATE FLOOR PENETRATIONS WITH STRUCTURAL DRAWINGS. SET SLEEVES IN FLOORS AND WALLS AND ATTACHMENTS FOR HANGERS AS CONSTRUCTION PROGRESSES. COORDINATE EXACT SIZE AND LOCATION OF ALL SLEEVES WITH STRUCTURAL ENGINEER. ALL PENETRATIONS SHALL BE SEALED AND HELD AS TIGHT TO COLUMNS OR WALLS AS POSSIBLE.
- CAULK AND SEAL ALL DUCT AND PIPING PENETRATIONS OF EXTERIOR OR DEMISING WALLS.
- THE CONTRACTOR SHALL TAKE CARE TO MAINTAIN THE INTEGRITY OF ALL FIRE RATED AND SOUND RATED ASSEMBLIES.
- ABOVE AND BELOW GROUND WASTE AND VENT PIPING SHALL BE SCHEDULE 40 PVC WITH SOLVENT CEMENT JOINTS, EXCEPT USE STANDARD WEIGHT NO-HUB CAST IRON IN AIR PLENUMS. VENT PIPING MAY BE SCHEDULE 40 GALVANIZED STEEL WITH SCREWED JOINTS. PAINT ALL EXTERIOR PIPING WITH UV RESISTANT PAINT.
- ABOVE GROUND WATER PIPING SHALL BE TYPE 'L' HARD COPPER WITH LEAD FREE SOLDER JOINTS.
- NATURAL GAS PIPING (ABOVE GROUND) SHALL BE SCHEDULE 40 BLACK STEEL WITH THREADED JOINTS. CONNECT USING JOINT COMPOUND SUITABLE FOR NATURAL GAS PIPING. ALL EXPOSED BLACK STEEL NATURAL GAS PIPING SHALL BE PROTECTED WITH A RUST INHIBITING COATING IN ACCORDANCE WITH THE PLUMBING CODE.
- SERVICE VALVES FOR WATER PIPING SYSTEMS UP THRU 2" SHALL BE 1/4 TURN, 150 LB. BALL VALVE WITH BRONZE CHROME PLATED BALL AND TFE SEATS, NIBCO S-585-70.
- DOMESTIC WATER PIPING SHALL BE INSULATED WITH 1" FIBERGLASS WITH ALL SERVICE JACKET OR COMPARABLE UNCELLULAR INSULATION WITH SMOKE/FLAME RATING OF 25/50. WHEN INSTALLED WITHIN A CHASE ALONG AN EXTERIOR WALL, THE INSULATION SHALL BE 1-1/2" FIBERGLASS AND THE PIPING SHALL BE LOCATED ON THE INTERIOR SIDE OF THE BUILDING WALL INSULATION.
- GAS SERVICE VALVES TO BE LUBRICATED PLUG COCKS, ROCKWELL 142 OR 143. CONNECTIONS TO EQUIPMENT SHALL HAVE SERVICE VALVES, 6" MINIMUM DIRT LEG AND UNION OR AT CONTRACTOR OPTION, UL LISTED APPLIANCE FLEXIBLE CONNECTORS MAY BE USED.
- PROVIDE PLUMBING FIXTURES AS SCHEDULED OR SELECTED BY OWNER WITH ALL REQUIRED TRIM AND ACCESSORIES FOR A COMPLETE WORKING AND CODE COMPLIANT INSTALLATION. PROVIDE STOP VALVES AND WATER HAMMER ARRESTORS, SIZED AS INDICATED OR PER MANUFACTURER FOR EACH FIXTURE OR EACH GROUP OF FIXTURES. REFER TO THE ARCHITECTURAL PLANS FOR EXACT LOCATION OF THE FIXTURES.
- MEET ALL REQUIREMENTS OF THE ADA FOR ALL FIXTURES REQUIRED TO BE HANDICAP ACCESSIBLE. INSULATE PIPING BENEATH HANDICAP FIXTURES PER ADA, HANDI-LAV-GARD SYSTEM OR EQUIVALENT.
- ALL POWER WIRING SHALL BE THE RESPONSIBILITY OF THE ELECTRICAL CONTRACTOR. DISCONNECT SWITCHES AND MOTOR STARTERS SHALL BE FURNISHED BY THE ELECTRICAL CONTRACTOR, EXCEPT WHERE SPECIFICALLY INDICATED TO BE FURNISHED BY THE MECHANICAL CONTRACTOR. COORDINATE REQUIRED POWER FOR EQUIPMENT WITH THE ELECTRICAL CONTRACTOR.
- ALL CONTROL DEVICES AND INTERLOCK WIRING SHALL THE RESPONSIBILITY OF THE MECHANICAL CONTRACTOR. CONTRACTOR SHALL FURNISH LOCKING GUARDS FOR DEVICES WHERE INDICATED AND WHERE REQUIRED TO PROTECT THEM FROM PHYSICAL DAMAGE. PROVIDE INSULATED SUBBASES WHERE SENSORS ARE INSTALLED ON 'COLD' OR EXTERIOR WALLS. MOUNT CONTROL DEVICES SUCH AS THERMOSTATS AND SENSORS AT 46" AFF.
- CONTRACTOR SHALL BE RESPONSIBLE FOR EQUIPMENT HANDLING AND TRANSPORT FOR ITEMS HE FURNISHES AND/OR INSTALLS. HE SHALL BE RESPONSIBLE FOR PROVIDING FOR ACCESS INTO SPACES WHERE WORK IS TO OCCUR.
- CONTRACTOR SHALL BE RESPONSIBLE FOR CUTTING, PATCHING, FLASHING AND REPAIR OF ROOFS, BUILDING STRUCTURE, COMPONENTS AND FINISHES ASSOCIATED WITH HIS WORK.
- CONTRACTOR IS RESPONSIBLE FOR ALL DAMAGES ASSOCIATED WITH CONSTRUCTION ACTIVITY. HE SHALL RESTORE REPAIRED OR REMODELED AREAS TO EXISTING CONDITIONS AND NEW CONSTRUCTION AREAS TO NEW CONDITION. ALL REPAIRS SHALL BE IN ACCORDANCE WITH THE APPLICABLE ARCHITECTURAL AND STRUCTURAL PROVISIONS. TO THE GREATEST EXTENT POSSIBLE, EXISTING BUILDING MATERIALS SHALL NOT BE DISTURBED.
- TEST AND CLEAN PIPING SYSTEMS PER INDUSTRY STANDARDS. PRESSURE TEST OF PRESSURE PIPING SHALL BE AT 1-1/2 TIMES THE ANTICIPATED OPERATING PRESSURE, BUT NOT LESS THAN 50 PSIG FOR 2 HOURS. NON-PRESSURIZED SYSTEMS SHALL BE TESTED WITH 10' WATER COLUMN ABOVE NORMAL OPERATING CONDITIONS OR 5 PSI FOR 2 HOURS. THERE SHALL BE NO MEASURABLE DROP DURING THE TEST PERIOD.
- TEST AND BALANCE ALL SYSTEMS PER NEBB STANDARDS. SUBMIT CERTIFIED REPORTS TO ARCHITECT FOR APPROVAL.

FIRE SPRINKLER SPECIFICATION NOTES

- ENTIRE BUILDING SHALL BE FIRE SPRINKLED IN ACCORDANCE WITH NFPA. CONTRACTOR SHALL PROVIDE SYSTEM HYDRAULIC CALCULATIONS AND COMPLETE SYSTEM LAYOUT IN ACCORDANCE WITH NFPA AND REQUIREMENTS INDICATED ON THE DRAWINGS AND/OR SPECIFICATIONS. SPRINKLER HEADS SHALL BE CHROME FINISHED PENDANT, SEMI-RECESSED OR ROUGH BRASS UPRIGHT IN UNFINISHED AREAS.
- ALL CONCEALED AREAS INCLUDING CANOPIES, OVERHANGS AND ATTICS SHALL HAVE FIRE SPRINKLER PROTECTION WITH A DRY PIPE OR ANTIFREEZE SYSTEM WHERE REQUIRED BY NFPA 13.
- ALL FIRE PROTECTION SYSTEM VALVES, FITTINGS AND OTHER COMPONENTS SHALL BE UL AND FM LISTED FOR FIRE SERVICE.
- UNDERGROUND FIRE PROTECTION PIPING SHALL BE CLASS 50 CEMENT LINED DUCTILE IRON WITH MECHANICAL COMPRESSION JOINTS.
- ABOVE GROUND FIRE PROTECTION PIPING SHALL BE SCHEDULE 40 BLACK STEEL, WELDED, ROLL OR CUT GROOVE OR SCREWED JOINTS. AT CONTRACTOR OPTION, SCHEDULE 10 ROLL GROOVE OR ALLED X PIPING MAY BE USED.
- WHERE PERMITTED, SPRINKLER PIPING UP THRU 3" SIZE MAY BE SCHEDULE 40 OR SCHEDULE 80 CPVC PIPING WITH SOLVENT CEMENT OR SCREWED JOINTS (WET SYSTEMS ONLY).



HVAC SYSTEM SAFETY CONTROLS

- DUCT SMOKE DETECTORS SHALL BE FURNISHED BY THE HVAC CONTRACTOR. SEE ELECTRICAL FOR INTEGRATION OF ALL SMOKE DETECTION AND SHUTDOWN OF EQUIPMENT. ALL HVAC EQUIPMENT IN EXCESS OF 2000 CFM SHALL BE EQUIPPED WITH SMOKE DETECTORS IN THE RETURN AIR STREAM OF THE UNIT. WHERE MULTIPLE HVAC UNIT FANS SHARE A COMMON RETURN AIR PLENUM (IN EXCESS OF 2,000 CFM COMBINED), ALL HVAC UNITS (INCLUDING VAV BOX FANS OR OTHER FANS ASSOCIATED WITH THE PLENUM) SHALL BE PROVIDED WITH A SMOKE DETECTOR. WHERE DUCT MOUNTED DETECTORS ARE SHOWN OR REQUIRED, USE DUCT INSERTION TUBE TYPE DETECTORS. IF FIRE ALARM SYSTEM IS INSTALLED, COORDINATE TYPE OF SMOKE DETECTOR WITH THE FIRE ALARM CONTRACTOR. IF A FIRE ALARM SYSTEM IS NOT PROVIDED, COORDINATE INSTALLATION OF A STROBE/HORN WITH THE ELECTRICAL CONTRACTOR TO NOTIFY OCCUPANTS OF THE SENSING OF SMOKE AT A SMOKE DETECTOR.

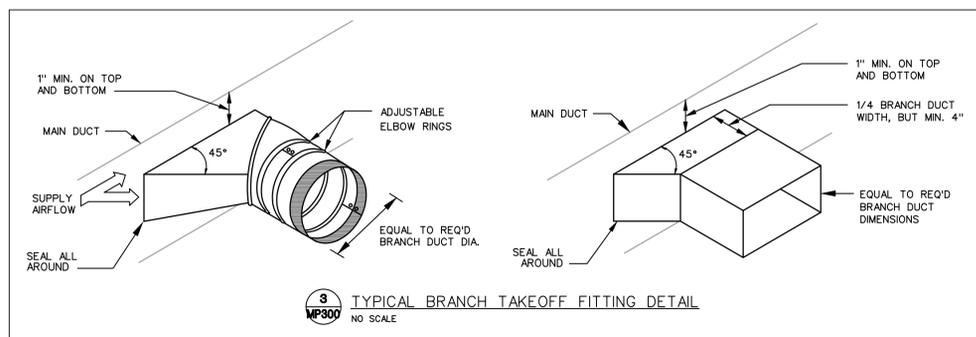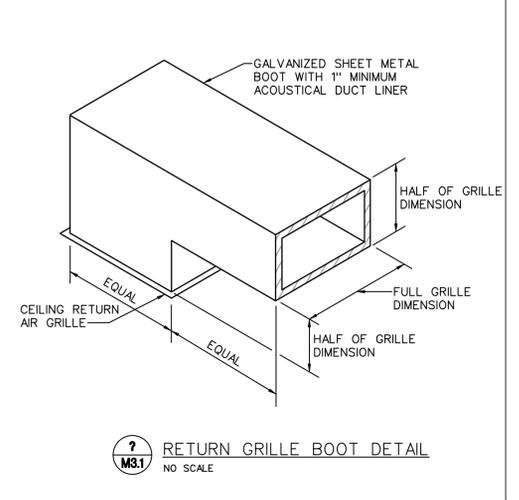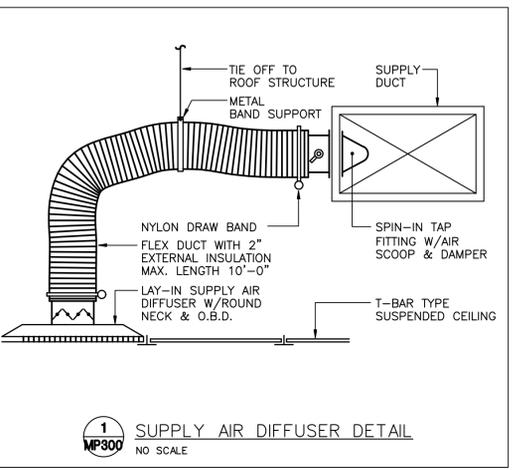

PLUMBING FIXTURE SCHEDULE

- INSTALL PLUMBING FIXTURES AND EQUIPMENT IN ACCORDANCE WITH MANUFACTURER'S INSTRUCTIONS. VERIFY ROUGH-IN REQUIREMENTS WITH MANUFACTURER'S DRAWINGS AND INSTALL PER MANUFACTURER'S RECOMMENDATIONS. PROVIDE WATER-CONSERVING FIXTURES AND APPURTENANCES IF/AS REQUIRED BY LOCAL AUTHORITIES. CONFIRM ALL LOCATIONS AND MOUNTING HEIGHTS WITH ARCHITECTURAL DRAWINGS AND/OR SPECIFICATIONS. CAULK FIXTURES TO WALLS/FLOORS. SET COUPLER MOUNTED SINKS AND LAVATORIES IN A BED OF CAULK. THE SPECIFIED PLUMBING FIXTURES, OR APPROVED EQUALS, SHALL BE USED UNLESS OTHERWISE NOTED OR INDICATED.
- WATER CLOSET (WC-1), TOTO #CST744S, VITREOUS CHINA, FLOOR-MOUNTED, ELONGATED BOWL, SIPHON JET ACTION, CLOSE-COUPLED TANK TYPE WATER CLOSET, 16-GPF, 14-5/8" HIGH, FULLY GLAZED BRASS AND MANUFACTURER'S BOLT CAPS, CHROME-PLATED BRASS TRIP LEVER AND 3/8" FLEXIBLE RISER WITH LOOSE KEY QUARTER TURN ANGLE STOP VALVE. PROVIDE TOTO #SC534 WHITE ELONGATED OPEN FRONT SEAT LESS COVER.
- WATER CLOSET (WC-1H), TOTO #CSC744SL.01, FLOOR-MOUNTED, CONSTRUCTED OF VITREOUS CHINA, MEETING ANSI A-117.1 AND ADA BARRIER-FREE REQUIREMENTS, 17" HIGH, 16-GALLON FLUSH, CLOSE-COUPLED TANK AND MANUFACTURER'S BOLT CAPS, CHROME-PLATED BRASS TRIP LEVER AND 3/8" FLEXIBLE RISER WITH LOOSE KEY QUARTER TURN ANGLE STOP VALVE, CHROME-PLATED BRASS TRIP LEVER AND MANUFACTURER'S BOLT CAPS. PROVIDE BENKE #527 WHITE ELONGATED OPEN FRONT SEAT LESS COVER, PERMA BUMPER.
- LAVATORY (LAV-1) TOTO #LT307.4 (20"x18"), WALL-HUNG TYPE, CONSTRUCTED OF VITREOUS CHINA. LAVATORY SHALL HAVE 4-INCH FAUCET CENTERS AND DRILLED FOR CONCEALED ARM CARRIER. PROVIDE 3/8-INCH FLEXIBLE RISER W/ANGLE SUPPLIES WITH LOOSE KEY STOPS, 1-1/4-INCH INLET 1-1/2-INCH OUTLET CHROME PLATED CAST BRASS "P" TRAP W/CLEANOUT PLUG AND ESCUTCHEON W/SET SCREW. PROVIDE DELTA #523-WFHDF HEAVY DUTY SINGLE LEVER FAUCET, 4-INCH CENTERS, VANDAL-RESISTANT 2.2 GPM AERATOR, PERFORATED GRID DRAIN (W/ 1-1/4" TAILPIECE) AND VANDAL-RESISTANT SINGLE LEVER HANDLE. PROVIDE WITH WADE CARRIER (TO MATCH WALL TYPE). SEE ARCHITECTURAL PLANS FOR MOUNTING DETAILS.
- LAVATORY (LAV-1H), TOTO #LT307.4 (20"x18"), WALL-HUNG TYPE, CONSTRUCTED OF VITREOUS CHINA, MEETING ANSI A-117.1 AND ADA BARRIER-FREE REQUIREMENTS. LAVATORY SHALL HAVE 4-INCH FAUCET CENTERS AND DRILLED FOR CONCEALED ARM CARRIER. PROVIDE 3/8-INCH FLEXIBLE RISER W/ANGLE SUPPLIES WITH LOOSE KEY STOPS, 1-1/4-INCH INLET 1-1/2-INCH OUTLET CHROME PLATED CAST BRASS "P" TRAP W/CLEANOUT PLUG AND ESCUTCHEON W/SET SCREW. PROVIDE DELTA #523-WFOGDF HEAVY DUTY SINGLE LEVER FAUCET, 4-INCH CENTERS, VANDAL-RESISTANT 2.2 GPM AERATOR, PERFORATED OFFSET GRID DRAIN (W/ 1-1/4" TAILPIECE) AND VANDAL-RESISTANT SINGLE LEVER HANDLE. PROVIDE WITH J.R. SMITH CARRIER (TO MATCH WALL TYPE). MOUNT AT ADA HEIGHT AND MAINTAIN CLEARANCES UNDER LAVATORY AS REQUIRED BY ADA REGULATIONS. INSULATE WASTE AND HOT WATER SUPPLY UNDER LAVATORY WITH UNDERSINK PROTECTIVE PIGE COVER, MOLDED, ANTIMICROBIAL, WITH FLUSH REUSABLE FASTENERS, TRUEBRO LAV GUARD.
- SINK (SK-1), JUST #SL-2217-A-GR, SINGLE COMPARTMENT, 18 GAUGE TYPE 304 STAINLESS STEEL, SELF RIMMING, UNDERSIDE FULLY UNDERCOATED WITH SOUND DAMPENING MATERIAL, 3 HOLE PUNCH, NOMINAL DIMENSIONS 22"x17"x7-1/2" DEEP. PROVIDE WITH DELTA COMMERCIAL #2772934 HEAVY DUTY DECKMOUNT SINK FAUCET, 6" RIGID/SWIVEL GOOSENECK SPOUT, 8" CENTERS, 2.0 GPM VANDAL-RESISTANT AERATOR, BASKET STRAINER DRAIN, 1-1/2" TAILPIECE, 3/8-INCH FLEXIBLE RISER W/ANGLE SUPPLIES WITH LOOSE KEY STOPS, 1-1/2-INCH INLET 2-INCH OUTLET CHROME PLATED CAST BRASS "P" TRAP W/CLEANOUT PLUG AND ESCUTCHEON W/SET SCREW AND 4" VANDAL-RESISTANT WRIST BLADE HANDLES.
- SINK (SK-2), JUST #DL-2133-A-GR, DOUBLE COMPARTMENT, 18 GAUGE TYPE 304 STAINLESS STEEL, SELF RIMMING, UNDERSIDE FULLY UNDERCOATED WITH SOUND DAMPENING MATERIAL, 4 HOLE PUNCH, NOMINAL DIMENSIONS OF 21"x33"x8" DEEP. PROVIDE WITH DELTA #400-WELHDF HEAVY DUTY SINGLE LEVER SINK FAUCET WITH SPRAYER, 8" LONG SWIVEL SPOUT, 8" CENTERS, 2.0 GPM VANDAL-RESISTANT AERATOR, JUST J-35 BASKET STRAINER DRAIN, 1-1/2" TAILPIECE, 3/8-INCH FLEXIBLE RISER W/ANGLE SUPPLIES WITH LOOSE KEY STOPS, 1-1/2-INCH INLET 2-INCH OUTLET CHROME PLATED CAST BRASS "P" TRAP W/CLEANOUT PLUG AND ESCUTCHEON W/SET SCREW. COORDINATE MOUNTING WITH CASEWORK. SEE ARCHITECTURAL PLANS.
- ELECTRIC WATER COOLER (EWC-1), OASIS #FBACSL, BI-LEVEL BARRIER FREE WITH STAINLESS STEEL TOP WITH SATIN FINISH, SANDSTONE POWDER COAT FINISH ON GALVANIZED STEEL CABINET, FRONT AND SIDE TOUCHPAD OPERATORS, FLEXIBLE BUBBLER GUARD, EXTERNAL STREAM HEIGHT ADJUSTMENT, 8 GPH @ 90°F AMBIENT. PROVIDE 3/8-INCH FLEXIBLE RISER W/ANGLE SUPPLIES WITH LOOSE KEY STOPS, AND 1-1/4-INCH INLET 1-1/2-INCH OUTLET CHROME-PLATED CAST BRASS "P" TRAP W/CLEANOUT PLUG AND ESCUTCHEON W/SET SCREW. MOUNT PER MANUFACTURER'S INSTRUCTIONS AND AS SHOWN ON THE ARCHITECTURAL PLANS.
- MOP SINK (MS-1), STERN WILLIAMS #SB-900, CONSTRUCTED OF TERRAZZO, 32" SQUARE BY 12" HIGH (COORDINATE SIZE WITH ARCHITECTURAL PLANS), CHROME-PLATED CAST BRASS DRAIN (CAST INTEGRAL) WITH STAINLESS STEEL CAP. PROVIDE WITH DELTA #28T2383 FAUCET WITH VACUUM BREAKER, LEVER HANDLES, 3/4" HOSE THREAD SPOUT WITH 48" LONG HOSE, WALL SPOUT, INTEGRAL STOPS AND ROUGH CHROME-PLATED FINISH.
- FLOOR DRAINS (FD-1), WADE #1100-G5-1-27, RATED FOR GENERAL LIGHT DUTY USE WITH CAST IRON BODY WITH FLANGE, SEEPAGE OPENINGS, INTEGRAL REVERSING CLAMPING COLLAR, TRAP PRIMER CONNECTION, 5" SQUARE NICKEL BRONZE ADJUSTIBLE STRAINER, SEDIMENT BUCKET AND HEEL PROOF GRATE, PROVIDE WITH SEPARATE DEEP SEAL "P" TRAP (SEE PLANS FOR SIZE).
- EQUIPMENT DRAINS (ED-1) WADE #1100-94 ADJUSTABLE CAST IRON FLOOR DRAIN WITH FLANGE, SEEPAGE OPENINGS, INTEGRAL CLAMPING COLLAR, EXTENSION ADAPTER INSTALLED ABOVE THE FLOOR ELEVATION APPROXIMATELY 3/4" TO PREVENT WATER ON THE FLOOR FROM ENTERING DRAIN AND 1/2" PLUGGED TRAP PRIMER CONNECTION. PROVIDE WITH SEPARATE DEEP SEAL "P" TRAP (SEE PLANS FOR SIZE).
- FINISHED FLOOR CLEANOUTS: (FFCO) WADE #6000-1-2-S CAST IRON FLOOR CLEANOUT WITH FLANGE, PLASTIC TAPERED PLUG AND SQUARE NICKEL BRONZE ADJUSTABLE TOP. PROVIDE WITH CARPET CLEANOUT MARKER WHEN CLEANOUT IS LOCATED BELOW CARPET. COORDINATE WITH ARCHITECTURAL PLANS.
- FINISHED WALL CLEANOUTS: (FWCO) WADE #8560, W/ 8304-85-6 CAST IRON CLEANOUT TEE WITH BRASS PLUG AND 6" ROUND STAINLESS STEEL ACCESS COVER. J.R. SMITH FIGURE 4530. PROVIDE DUGO CAST IRON WALL CLEANOUT TEE WITH COUNTERSUNK PLUG. DELETE COVER PLATE IF CLEANOUT IS IN EXPOSED LOCATION.
- ALL FIXTURES USED SPECIFICALLY FOR HANDWASHING PURPOSES (LAVATORIES, HAND SINKS, ETC.) SHALL BE PROVIDED WITH A TEMPERING VALVE TO TEMPER THE HOT WATER TO THE FIXTURE (MAXIMUM OF 105-DEGREES F).

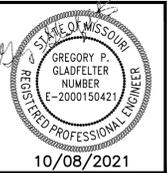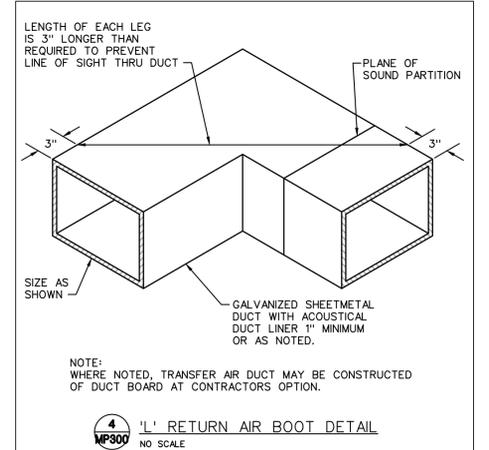

KC UC LS
451 NORTHWEST MURRAY RD
LEE'S SUMMIT, MO



JOB NO.:	212423G
DATE:	10/08/2021
REVISIONS:	
DESIGNED BY:	GEG
DRAWN BY:	GEG
CHECKED BY:	GEG
SHEET NO.:	

MP300

X:\AEC-PROJECTS\2021 PROJECTS\212423G_KCUC_LS\212423G_MP300_09-30-2021_24X36_JEE.DWG : 10/8/2021 12:06:59 PM : jeshinour

PLUMBING GENERAL NOTES

- A) ALL FIXTURES USED SPECIFICALLY FOR HANDWASHING PURPOSES (LAVATORIES, HAND SINKS, ETC.) SHALL BE PROVIDED WITH A TEMPERING VALVE TO TEMPER THE HOT WATER TO THE FIXTURE (MAXIMUM OF 105-DEGREES F).
- B) SEE "PLUMBING RISER DIAGRAMS", THIS SHEET, FOR PIPING NOT SHOWN ON THE PLANS.

PLUMBING PLAN NOTES ①:


1. 2" W DOWN, 1-1/2" V UP TO ABOVE CEILING OR OVER TO V FROM WATER CLOSET.
2. 4" S DOWN, 2" V OVER TO WALL AND UP ABOVE CEILING.
3. CONNECT NEW 4" S TO EXISTING 4" S. FIELD VERIFY EXACT LOCATION AND DIRECTION OF FLOW.
4. 2" W DOWN, 2" V OVER TO WALL AND UP TO ABOVE CEILING.
5. SEE "DOMESTIC WATER SCHEMATIC", THIS SHEET, FOR CONTINUATION.
6. EXTEND CW, HW AND HWR FROM EXISTING CW SERVICE AND EXISTING ELECTRIC WATER HEATER IN MECHANICAL ROOM.

PLUMBING SYMBOLS


- EXISTING TO REMAIN.
- NEW PIPING WORK.
- DOMESTIC COLD WATER (CW).
- DOMESTIC HOT WATER (HW).
- HOT WATER RECIRCULATION (HWR).
- V PLUMBING VENT ABOVE FLOOR (V).
- SAN SANITARY WASTE ABOVE FLOOR (W).
- SANITARY WASTE BELOW FLOOR (W).
- NG GAS (NATURAL) (NG).
- ELBOW DOWN.
- ELBOW UP.
- TEE DOWN.
- TEE UP.
- CAP.
- PIPE UNION.
- 1/4 TURN SHUT-OFF VALVE.
- CHECK VALVE.
- VTR VENT THRU ROOF (VTR).
- ETR EXISTING TO REMAIN.
- PLAN NOTE DESIGNATION.
- △ PLAN REVISION DESIGNATION.
- CONNECT TO EXISTING.
- ⊞ PLUMBING EQUIPMENT DESIGNATION - TOP PORTION IS EQUIPMENT (HW, RTU, ETC.), BOTTOM PORTION IS NO. OR LETTER (SEE APPROPRIATE SCHEDULE).




KC UC LS
451 NORTHWEST MURRAY RD
LEE'S SUMMIT, MO

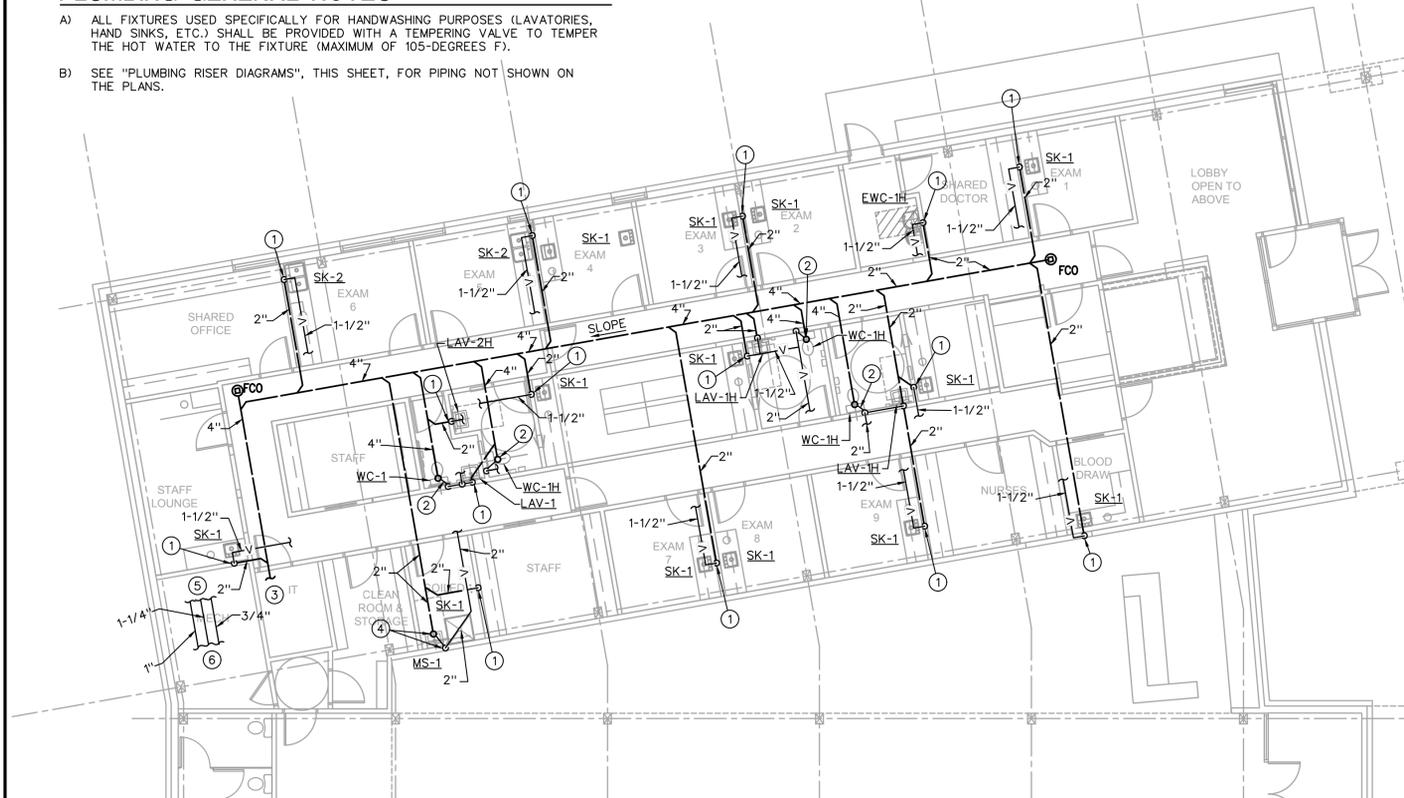

PLUMBING FLOOR PLAN
1/8" = 1'-0"

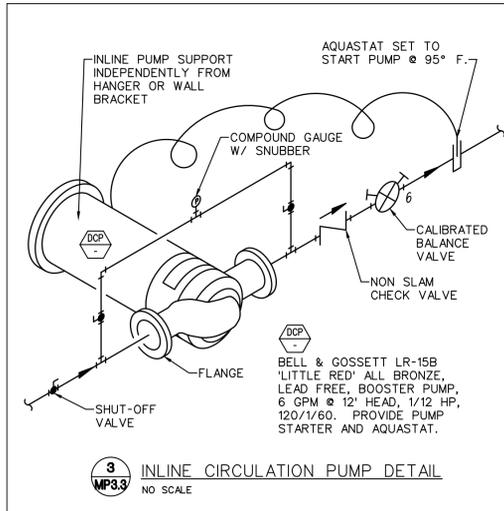


9 MP3.3 INLINE CIRCULATION PUMP DETAIL
NO SCALE

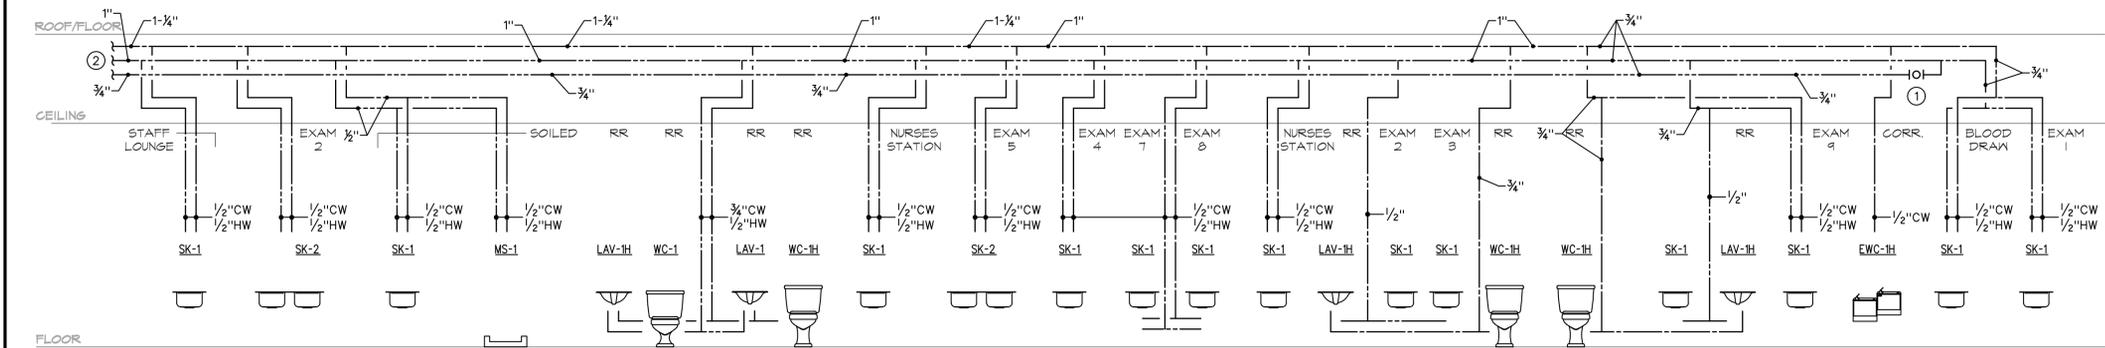

DOMESTIC WATER SCHEMATIC
NTS

RISER DIAGRAM NOTES


- ① HOT WATER RECIRCULATING SYSTEM BALANCE VALVE.
- ② SEE PLUMBING FLOOR PLAN FOR CONTINUATION.

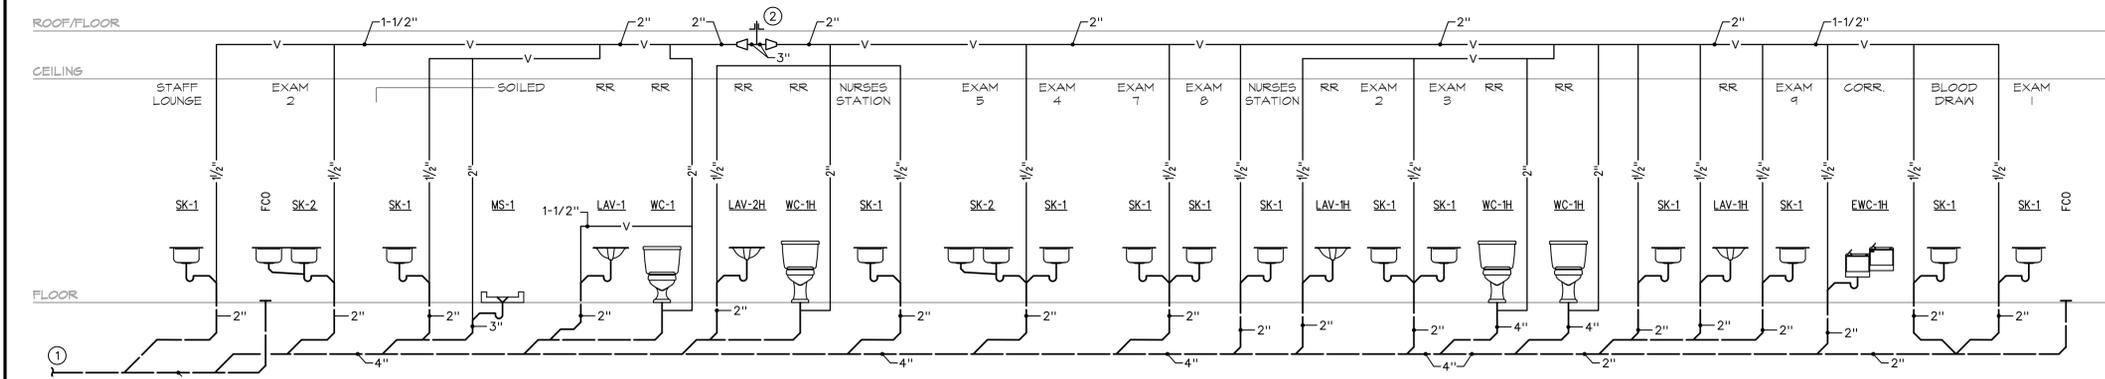

PLUMBING RISER
NTS

RISER DIAGRAM NOTES

- ① SEE PLUMBING PLAN FOR CONTINUATION.
- ② 3" V UP TO 3" VTR. REUSE EXISTING VTR IF ONE CURRENTLY EXISTS.

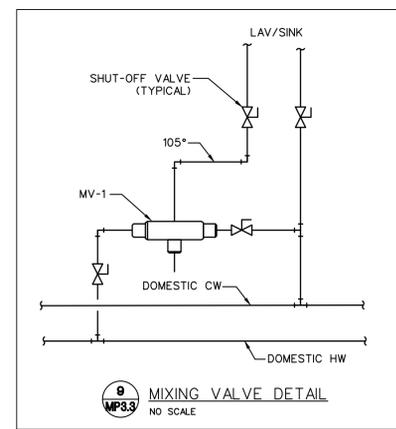

9 MP3.3 MIXING VALVE DETAIL
NO SCALE




JOB NO.:	212423G
DATE:	10/08/2021
REVISIONS:	
DESIGNED BY:	GEG
DRAWN BY:	GEG
CHECKED BY:	GEG
SHEET NO.	

P100

X:\AEC-PROJECTS\2021 PROJECTS\212423G_KCUC_LS\212423G_P100_10-06-2021_24X36_EED.DWG : 10/8/2021 12:07:06 PM : jeshmar

X:\AEC-PROJECTS\2021\PROJECTS\21243G_KCUC_LS_10-05-2021_24X36_JEE.DWG : 10/8/2021 12:08:12 PM : jeshnaur

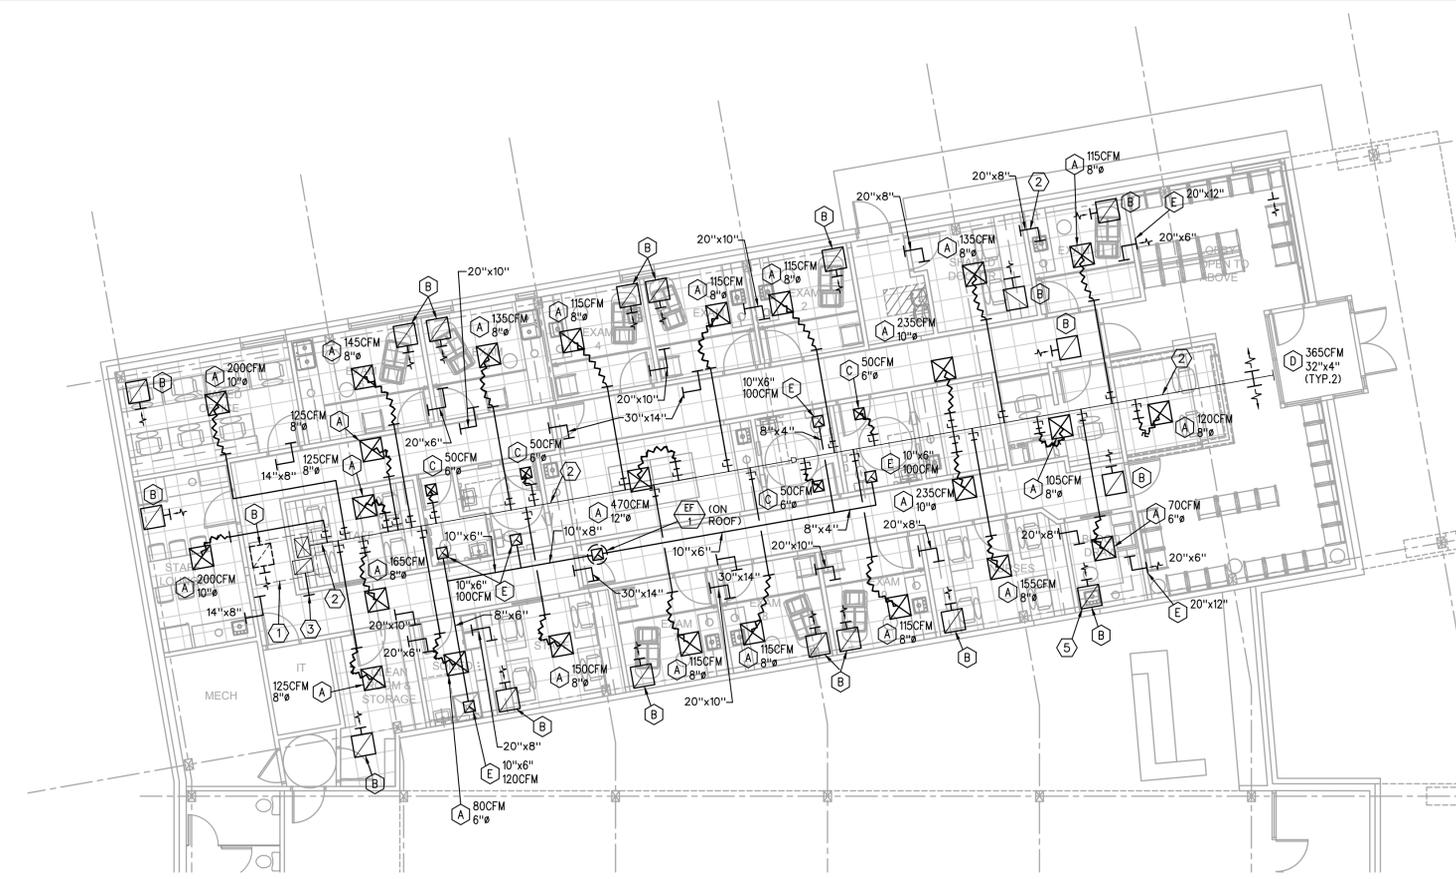

MECHANICAL FLOOR PLAN

1/8" = 1'-0"



MECHANICAL PLAN NOTES

- EXISTING 12.5 TON RTU ON ROOF (ESTIMATED SIZE). BALANCE MINIMUM OA TO 655 CFM.
- EXISTING FLAT OVAL DUCT SHALL REMAIN. REMOVE EXISTING SUPPLY REGISTERS AND SEAL DUCT AIRTIGHT. TAP DUCT AS SHOWN TO ACCOMMODATE NEW CONSTRUCTION.
- EXTEND EXISTING RA DUCT SO THAT INTAKE IS ABOVE CORRIDOR CEILING. RELOCATE EXISTING SMOKE DETECTOR IF NECESSARY.
- RA BOOT THRU WALL ABOVE CEILING (TYPICAL). SIZE AS INDICATED.
- SEE "RETURN GRILLE BOOT DETAIL", THIS SHEET FOR SOUND BOOT AT RETURN GRILLE (TYPICAL).

MECHANICAL GENERAL NOTES (RTU)

- COORDINATE LOCATION OF CEILING DIFFUSERS AND RETURN GRILLES WITH ARCHITECTURAL REFLECTED CEILING PLAN.
- CONTRACTOR SHALL INSURE THAT A PROPER RETURN AIR PATH EXISTS FROM EACH SPACE. WHERE NOT OTHERWISE INDICATED AND IN RETURN AIR PLENUM APPLICATIONS, PROVIDE FLANGED RETURN AIR OPENINGS ABOVE CEILING LEVEL, THRU WALLS TO STRUCTURE, SO THAT RETURN AIR VELOCITY AND PRESSURE DROP DOES NOT EXCEED 1000 FPM AND 0.065"WG/100' RESPECTIVELY.
- CONFIRM THAT NO COMBUSTIBLE MATERIALS ARE LOCATED IN CEILING RETURN AIR PLENUMS.
- TEMPERATURE CONTROL INCLUDES ALL CONTROL WIRING FOR COMPLETE OPERATION OF ROOFTOP UNITS BY MECHANICAL CONTRACTOR ACCORDING TO THE FOLLOWING SEQUENCE OF OPERATIONS:

RTU SEQUENCE OF CONTROL:

PROVIDE A WALL MOUNTED 7-DAY HEATING/COOLING THERMOSTAT FOR EACH ROOFTOP UNIT INSTALLED IN A LOCATION APPROVED BY THE OWNER. INSTALL TAMPERPROOF COVER.

DAY OPERATION - THE TIMECLOCK OR MANUAL OVERRIDE FUNCTION SHALL AUTOMATICALLY ACTIVATE THE SYSTEM TO THE "OCCUPIED" OR "DAY" MODE. THE SYSTEM SHALL HEAT OR COOL THE SPACE TO THE DESIRED SET POINTS (COOLING: 74°F AND HEATING: 70°F) THROUGH THE THERMOSTATS BUILT-IN DEADBAND. THE OUTSIDE AIR DAMPERS SHALL BE AT THEIR MINIMUM POSITION AND THE FAN SHALL MAINTAIN CONTINUOUS OPERATION.

NIGHT OPERATION - THE TIMECLOCK SHALL AUTOMATICALLY ACTIVATE THE SYSTEM TO THE "NIGHT/UNOCCUPIED" MODE. THE SYSTEM SHALL HEAT OR COOL THE SPACE TO THE DESIRED NIGHT SET POINTS (COOLING: 85°F AND HEATING: 60°F) THROUGH THE THERMOSTATS NIGHT/UNOCCUPIED SETPOINTS. THE OUTSIDE AIR DAMPERS SHALL BE CLOSED AND THE FAN SHALL CYCLE AS NEEDED TO MAINTAIN THE THERMOSTAT SETPOINTS.

ECONOMIZER OPERATION TO ENABLE FREE COOLING SHALL BE A FUNCTION OF THE RTU MANUFACTURER'S STANDARD CONTROLS.

DEHUMIDIFICATION OPERATION, IF PROVIDED, SHALL BE A FUNCTION OF THE RTU MANUFACTURER'S STANDARD CONTROLS. INSTALL HUMIDISTAT ARE RECOMMENDED BY MANUFACTURER.

SAFETY OPERATION - THE FIRE ALARM SYSTEM SHALL SHUTDOWN OPERATION OF RTU FAN UPON DETECTION OF SMOKE AT ANY SMOKE DETECTOR INSTALLED AT THIS FACILITY.

- EXISTING ROOFTOP UNIT (RTU) IS REPORTED TO BE 12.5 TONS CAPACITY AND SUPPLY AIR VOLUMES HAVE BEEN CALCULATED AT 400 CFM/TON. CONTRACTOR SHALL MAKE CHANGES AS REQUIRED IF THE TONNAGE IS NOT 12.5 TONS.


MECHANICAL SYMBOLS

- NEW SHEET METAL DUCTWORK & SIZE.
- NEW SHEET METAL DUCTWORK & SIZE.
- SUPPLY AIR DUCT OR OUTSIDE AIR INTAKE.
- RETURN AIR DUCT OR EXHAUST AIR DUCT.
- DIRECTION OF RETURN AIRFLOW.
- THERMOSTAT OR TEMPERATURE SENSOR.
- CONDENSATE DRAIN.
- ELBOW DOWN.
- ELBOW UP.
- SUPPLY AIR.
- OUTSIDE AIR.
- RETURN AIR.
- EXHAUST AIR.
- CONDENSING UNIT.
- EXHAUST FAN.
- ROOFTOP UNIT.
- PLAN NOTE DESIGNATION.
- PLAN REVISION DESIGNATION.
- CONNECT TO EXISTING.
- MECHANICAL EQUIPMENT DESIGNATION - TOP PORTION IS EQUIPMENT (RTU, EF, HP, ETC.), BOTTOM PORTION IS NO. OR LETTER (SEE APPROPRIATE SCHEDULE).

OUTSIDE AIR SUMMARY (SINGLE ZONE SYSTEMS) (NOTES 2 & 3)

SYSTEM	SPACE	AREA (SQUARE FEET)	CALCULATED OCCUPANT TOTAL (Pa)	VENTILATION RATE (CFM/PER) (Rp)	AREA OUTDOOR AIRFLOW IN BREATHING ZONE (Ra) CFM/SF	SPACE OUTDOOR AIRFLOW IN BREATHING ZONE Vbz=RpPz+RaAz CFM	ZONE AIR DISTRIBUTION EFFECTIVENESS (Ez) COOLING/HEATING (NOTE 1)	ZONE OUTDOOR AIRFLOW (Voz=Vbz/Ez) COOLING	ZONE OUTDOOR AIRFLOW (Voz=Vbz/Ez) HEATING	ZONE OUTDOOR AIR SETPOINT (CFM)	EXHAUST REQUIRED (CFM) (NOTE 5)	REMARKS
RTU-1 (12.5-TON)	Exam 1	93	1	5	0.06	10.58	1.0/0.8	10.58	13.23	14		
	Exam 2	93	1	5	0.06	10.58	1.0/0.8	10.58	13.23	14		
	Exam 3	93	1	5	0.06	10.58	1.0/0.8	10.58	13.23	14		
	Exam 4	93	1	5	0.06	10.58	1.0/0.8	10.58	13.23	14		
	Exam 5	108	1	5	0.06	11.48	1.0/0.8	11.48	14.35	15		
	Exam 6	117	1	5	0.06	12.02	1.0/0.8	12.02	15.03	16		
	Exam 7	93	1	5	0.06	10.58	1.0/0.8	10.58	13.23	14		
	Exam 8	93	1	5	0.06	10.58	1.0/0.8	10.58	13.23	14		
	Exam 9	93	1	5	0.06	10.58	1.0/0.8	10.58	13.23	14		
	Restroom #1	58									70	
	Restroom #2	58									70	
	Restroom #3	51									70	
	Restroom #4	37									70	
	RECEPTION	85	1	5	0.06	10.10	1.0/0.8	10.10	12.63	13		
	Waiting	553	28	5	0.06	173.18	1.0/0.8	173.18	216.48	217		
	Shared Doctor	110	1	5	0.06	11.60	1.0/0.8	11.60	14.60	15		
	Nurses	125	1	5	0.06	12.50	1.0/0.8	12.50	15.63	16		
	Shared Office	163	1	5	0.06	14.78	1.0/0.8	14.78	18.48	19		
	Staff Lounge	144	8	5	0.06	48.64	1.0/0.8	48.64	60.80	61		
	Back Corridor	330	0	5	0.06	19.80	1.0/0.8	19.80	24.75	25		
	Soiled	59	1	5	0.06	8.54	1.0/0.8	8.54	10.68	11	30	6
	Clean Room & Storage	98	0	0		11.76	1.0/0.8	11.76	14.70	15		
	Nurses Station	126	1	5	0.06	12.56	1.0/0.8	12.56	15.70	16		
	Blood Draw	55	1	5	0.06	8.30	1.0/0.8	8.30	10.38	11		
	Check-out	84	1	5	0.06	10.04	1.0/0.8	10.04	12.55	13		
	Front Corridor	850	0	5	0.06	51.00	1.0/0.8	51.00	63.75	64		
	Staff	120	1	5	0.06	12.20	1.0/0.8	12.20	15.25	16		
	Staff	102	1	5	0.06	11.12	1.0/0.8	11.12	13.90	14		
	TOTAL	4,084	55							655	310	

- ZONE AIR DISTRIBUTION EFFECTIVENESS (Ez) DETERMINED FROM TABLE 403.3.1.2 AND IS BASED ON AIR DISTRIBUTION CONFIGURATION IN ACCORDANCE WITH THE 2018 IMC.
- CALCULATION DONE IN ACCORDANCE WITH 2018 IMC, CHAPTER 4.
- VENTILATION AIR PROVIDED BY DIRECT CONNECTION TO THE OUTDOORS IN ACCORDANCE WITH SECTION 401, 2018 IMC.
- BATHROOM MINIMUM EXHAUST AIR PROVIDED AT MINIMUM 70 CFM PER FIXTURE IN ACCORDANCE WITH CHAPTER 4, 2018 IMC.
- SPACE EXHAUST REQUIRED AT THE INDICATED RATE.

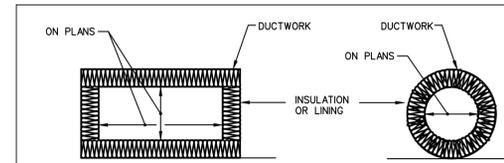

	DUCT INSULATION SCHEDULE						NOTES
	INTERNAL INSULATION			EXTERNAL INSULATION			
	1/2"	1"	OTHER	1"	2"	OTHER	
LOW VELOCITY DUCTS:							
RETURN DUCTS							1
SUPPLY DUCTS (RECT.)							
SUPPLY DUCTS (ROUND)							3,4
EXHAUST DUCTS							
OUTSIDE AIR DUCTS							2
RELIEF DUCTS							1
MEDIUM/HIGH VELOCITY DUCTS:							
ROUND SUPPLY							
FLAT OVAL SUPPLY							

- NOTES:
- INSULATION SHALL BE INSTALLED WHEN INDICATED OTHERWISE IN THE CONSTRUCTION DOCUMENTS. OTHERWISE, NO INSULATION IS REQUIRED.
 - INSULATION IS REQUIRED WITHIN 6'-0" OF TERMINATION POINT OF EXHAUST AIR. RECTANGULAR DUCTS SHALL BE LINED, ROUND DUCTS SHALL BE WRAPPED.
 - CONCEALED ROUND SUPPLY AIR DUCTS AND ROUND SUPPLY AIR DUCTS IN UNCONDITIONED SPACES SHALL BE INSULATED AS INDICATED AND SHALL INCLUDE A VAPOR BARRIER TO PREVENT CONDENSATION FROM FORMING ON COLD METAL SURFACES. NO INSULATION IS REQUIRED FOR ROUND SUPPLY AIR DUCT EXPOSED IN CONDITIONED SPACES UNLESS INDICATED OTHERWISE.
 - AT CONTRACTOR'S OPTION, GALVANIZED STEEL ROUND DOUBLE WALL DUCT MAY BE USED WHERE ROUND SUPPLY AIR DUCTS ARE REQUIRED TO BE INSULATED. DOUBLE WALL DUCT SHALL BE LINX LINDLAB SPIRO-SAFE SPIRAL LOCKSEAM DUCTWORK. SEE THE SPECIFICATIONS FOR ADDITIONAL REQUIREMENTS.
 - AT CONTRACTOR'S OPTION, ROUND DUCT LINER MAY BE USED WHERE ROUND SUPPLY AIR DUCTS ARE REQUIRED TO BE INSULATED. DUCT LINER SHALL BE JOHNS MANVILLE SPIROACUSTIC PLUS, OR APPROVED EQUAL, 1.5" THICK (R6.4). SEE THE SPECIFICATIONS FOR ADDITIONAL REQUIREMENTS.

5 INSULATED OR LINED DUCT DETAIL
NO SCALE



KC UC LS
451 NORTHWEST MURRAY RD
LEE'S SUMMIT, MO




JOB NO.: 212423G
DATE: 10/08/2021
REVISIONS:

DESIGNED BY: GEG
DRAWN BY: GEG
CHECKED BY: GEG
SHEET NO.

M100

Y:\AEC-PROJECTS\2021 PROJECTS\21243G_KCUC_LS\21243G_ET100_10-08-2021_24x36_SMB.DWG : 10/8/2021 4:23:37 PM : ablochburn

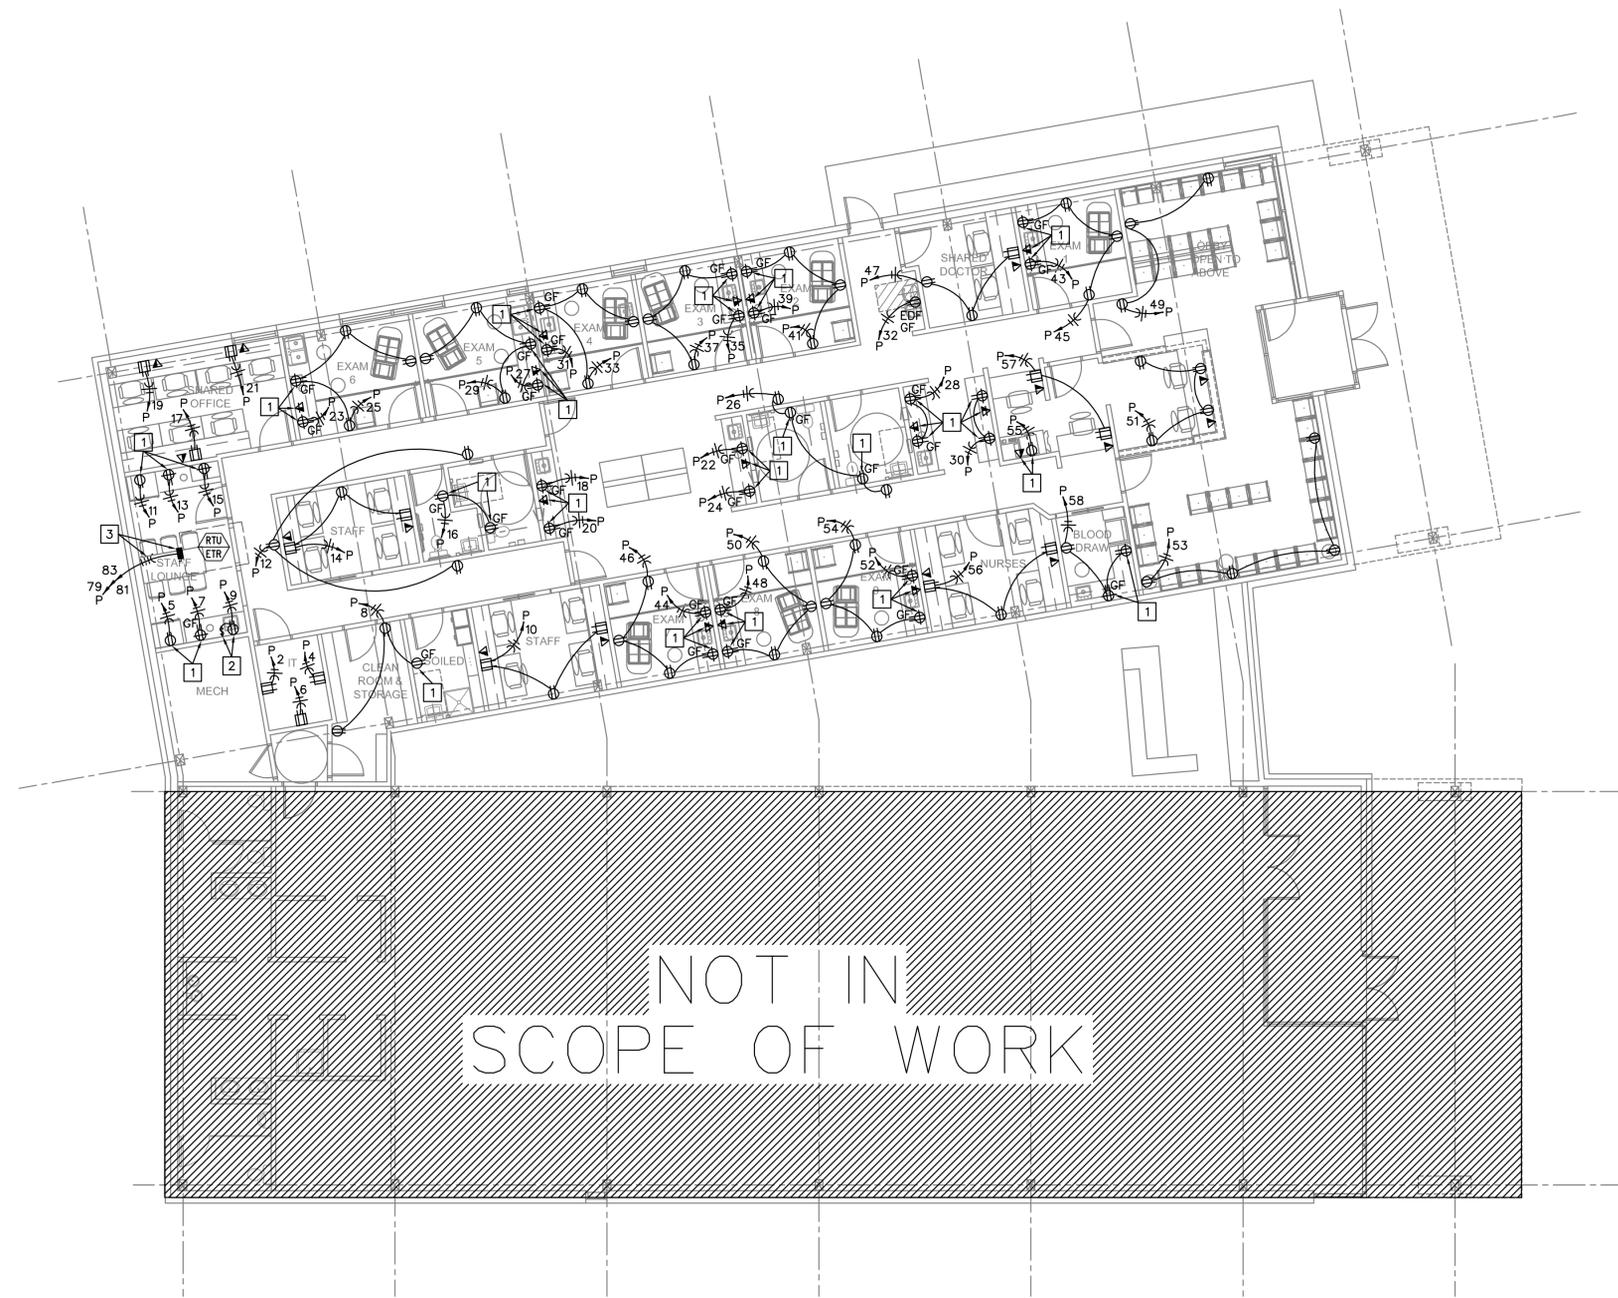

NOT IN SCOPE OF WORK


POWER PLAN
1/8" = 1'-0"
NORTH

POWER PLAN NOTES

1. INSTALL OUTLET BOX FOR WIRING DEVICE AT 48" AFF.
2. RECEPTACLE FOR DISPOSAL BELOW COUNTER AND SWITCH TO CONTROL RECEPTACLE ABOVE COUNTERTOP. INSTALL RECEPTACLE IN AN ACCESSIBLE MANNER.
3. EXISTING DISCONNECT, CONDUIT AND WIRING TO REMAIN.

ELECTRICAL GENERAL NOTES

- A) SEE ARCHITECTURAL REFLECTED CEILING PLANS FOR EXACT LOCATION OF LIGHT FIXTURES.
- B) COORDINATE NEMA RATING OF APPLIANCE PLUGS WITH THE EQUIPMENT SPECIFICATIONS.
- C) ALL RECEPTACLES WITHIN 6' OF WATER BEARING FIXTURES, EXTERIOR OUTLETS AND ALL OUTLETS IN KITCHEN AREAS SHALL BE GFI STYLE OR THE CIRCUIT SERVING THOSE DEVICES SHALL BE PROTECTED BY MEANS OF A GFI CIRCUIT BREAKER.
- D) OUTLET AND SWITCH BOXES INSTALLED IN RATED WALLS SHALL BE PROVIDED WITH UL LISTED PUTTY PADS TO PROTECT THE RATING OF THE WALL.
- E) CONNECT ALL NIGHT LIGHT, EXIT LIGHT AND EMERGENCY LIGHT FIXTURES TO UNSWITCHED HOT-LEG OF NEAREST 120V LIGHTING CIRCUIT IN SAME AREA.
- F) CONDUIT INSTALLED IN AREAS OF BUILDINGS OR PORTIONS OF BUILDINGS WHERE MEDICAL CARE IS PROVIDED SHALL BE MEDICAL GRADE CONDUIT AND THE INSTALLATION SHALL CONFORM WITH CHAPTER 517 OF THE NEC (HEALTH CARE FACILITIES).

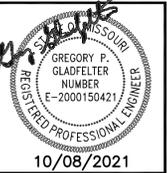

KC UC LS
451 NORTHWEST MURRAY RD
LEE'S SUMMIT, MO



JOB NO.:	212423G
DATE:	10/08/2021
REVISIONS:	
DESIGNED BY:	GEG
DRAWN BY:	GEG
CHECKED BY:	GEG
SHEET NO.	


E101



10/08/2021

LIGHTING PLAN NOTES

1. LIGHTING IN THIS AREA IS EXISTING TO REMAIN.

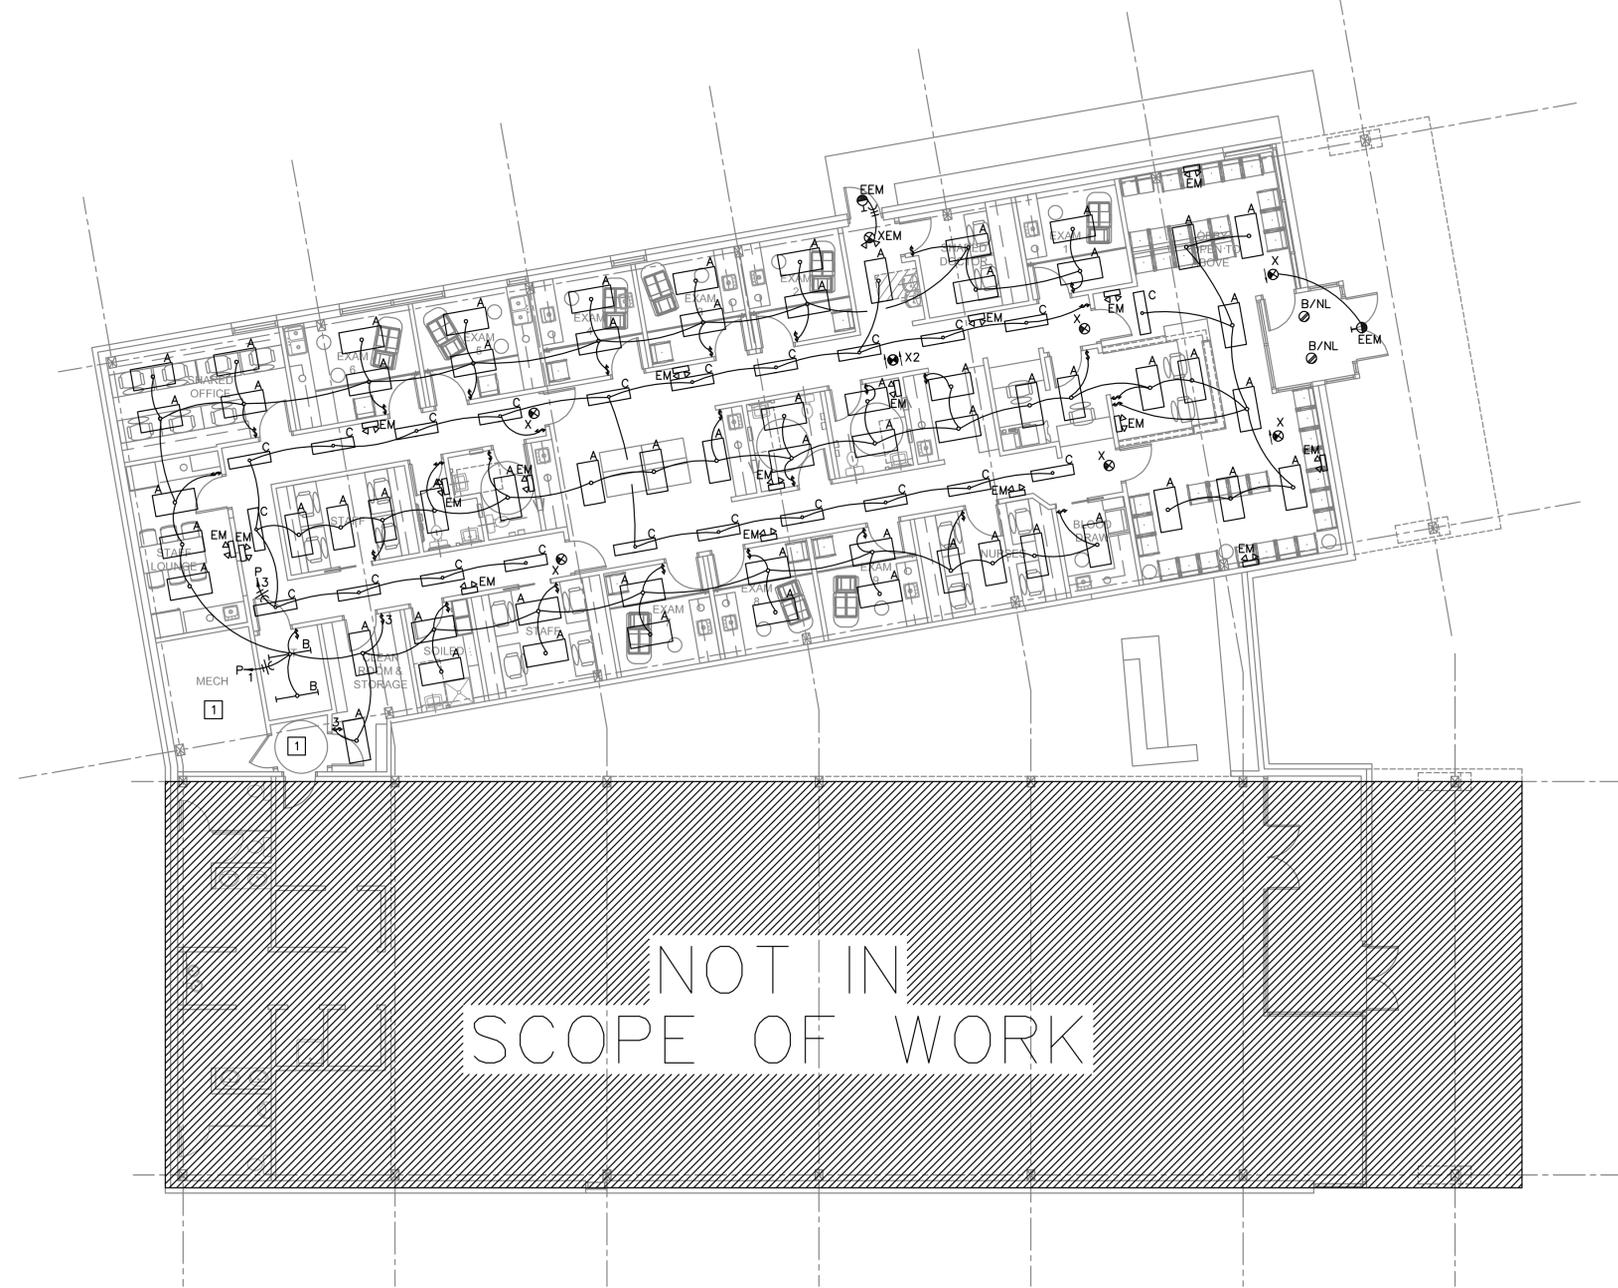

NOT IN
SCOPE OF WORK

ELECTRICAL GENERAL NOTES

- SEE ARCHITECTURAL REFLECTED CEILING PLANS FOR EXACT LOCATION OF LIGHT FIXTURES.
- COORDINATE NEMA RATING OF APPLIANCE PLUGS WITH THE EQUIPMENT SPECIFICATIONS.
- ALL RECEPTACLES WITHIN 6' OF WATER BEARING FIXTURES, EXTERIOR OUTLETS AND ALL OUTLETS IN KITCHEN AREAS SHALL BE GFI STYLE OR THE CIRCUIT SERVING THOSE DEVICES SHALL BE PROTECTED BY MEANS OF A GFI CIRCUIT BREAKER.
- OUTLET AND SWITCH BOXES INSTALLED IN RATED WALLS SHALL BE PROVIDED WITH UL LISTED PUTTY PADS TO PROTECT THE RATING OF THE WALL.
- CONNECT ALL NIGHT LIGHT, EXIT LIGHT AND EMERGENCY LIGHT FIXTURES TO UNSWITCHED HOT-LEG OF NEAREST 120V LIGHTING CIRCUIT IN SAME AREA.
- CONDUIT INSTALLED IN AREAS OF BUILDINGS OR PORTIONS OF BUILDINGS WHERE MEDICAL CARE IS PROVIDED SHALL BE MEDICAL GRADE CONDUIT AND THE INSTALLATION SHALL CONFORM WITH CHAPTER 517 OF THE NEC (HEALTH CARE FACILITIES).

LIGHTING PLAN
1/8" = 1'-0"
NORTH

Y:\AEC-PROJECTS\2021 PROJECTS\21243G_KCUC_LS\21243G_E101_10-08-2021_24X36_SWB.DWG : 10/8/2021 2:48:30 PM : sblackburn

KC UC LS
451 NORTHWEST MURRAY RD
LEE'S SUMMIT, MO



JOB NO.:	212423G
DATE:	10/08/2021
REVISIONS:	
DESIGNED BY:	GEG
DRAWN BY:	GEG
CHECKED BY:	GEG
SHEET NO.	

E101

Y:\AEC-PROJECTS\2021 PROJECTS\21243G_KCUC_LS\21243G_SWB.DWG : 10/8/2021 4:28:07 PM : sblackburn

PANEL P (EXISTING)		120/208 VOLTS		200 A. BUS		SERVICE ENTRANCE	
SECTION 1 OF 2		3 PHASE		200 A. MAIN BREAKER		FEED THRU LUGS	
CIRC. NO.		CIRCUIT DESCRIPTION		CIRC. BRKR. AMPS POLES		VA	
1	LIGHTS	20	1	958	A	2	4-PLEX REC - IT
3	LIGHTS	20	1	1568	B	4	4-PLEX REC - IT
5	REFRIGERATOR	20	1	800	C	6	4-PLEX REC - IT
7	GF RECEPTACLE	20	1	1250	A	8	RECEPTACLES
9	DISPOSAL	20	1	1350	B	10	RECEPTACLES
11	REFRIGERATOR	20	1	800	C	12	RECEPTACLES
13	GF RECEPTACLE	20	1	1000	A	14	RECEPTACLES
15	MICROWAVE	20	1	1500	B	16	GF RECEPTACLES
17	4-PLEX RECEPTACLE	20	1	1000	C	18	GF RECEPTACLES
19	4-PLEX RECEPTACLE	20	1	1000	A	20	GF RECEPTACLES
21	4-PLEX RECEPTACLE	20	1	1000	B	22	GF RECEPTACLES
23	GF RECEPTACLE	20	1	800	C	24	GF RECEPTACLES
25	RECEPTACLES	20	1	720	A	26	RECEPTACLES
27	GF RECEPTACLE	20	1	800	B	28	GF RECEPTACLES
29	RECEPTACLES	20	1	720	C	30	GF RECEPTACLES
31	GF RECEPTACLE	20	1	800	A	32	EDF
33	RECEPTACLES	20	1	720	B	34	SPARE
35	GF RECEPTACLE	20	1	800	C	36	SPARE
37	RECEPTACLES	20	1	720	A	38	SPARE
39	GF RECEPTACLE	20	1	800	B	40	SPARE
41	RECEPTACLES	20	1	720	C	42	SPARE

PANEL P (EXISTING)		120/208 VOLTS		200 A. BUS		SERVICE ENTRANCE	
SECTION 2 OF 2		3 PHASE		A. MAIN BREAKER		FEED THRU LUGS	
SECTION 2 OF 2		4 WIRE		MAIN LUGS ONLY		SUBFEED LUGS	
CIRC. NO.	CIRCUIT DESCRIPTION	CIRC. BRKR. AMPS POLES	VA	Ø	CIRCUIT DESCRIPTION	CIRC. BRKR. AMPS POLES	VA
43	GF RECEPTACLE	20 1	800	A	44	GF RECEPTACLE	20 1 800
45	RECEPTACLES	20 1	720	B	46	RECEPTACLES	20 1 720
47	RECEPTACLES	20 1	720	C	48	GF RECEPTACLE	20 1 800
49	RECEPTACLES	20 1	540	A	50	RECEPTACLES	20 1 720
51	RECEPTACLES	20 1	720	B	52	GF RECEPTACLE	20 1 800
53	RECEPTACLES	20 1	720	C	54	RECEPTACLES	20 1 720
55	PRINTER/COPIER	20 1	1500	A	56	RECEPTACLES	20 1 900
57	4-PLEX RECEPTACLES	20 1	1000	B	58	RECEPTACLES	20 1 720
59	SPARE	20 1	-	C	60	SPARE	20 1 -
61	SPARE	20 1	-	A	62	SPARE	20 1 -
63	SPARE	20 1	-	B	64	SPARE	20 1 -
65	SPARE	20 1	-	C	66	SPARE	20 1 -
67	SPARE	20 1	-	A	68	SPARE	20 1 -
69	SPARE	20 1	-	B	70	SPARE	20 1 -
71	SPARE	20 1	-	C	72	SPARE	20 1 -
73	SPACE	- -	-	A	74	SPACE	- - -
75	SPACE	- -	-	B	76	SPACE	- - -
77	SPACE	- -	-	C	78	SPACE	- - -
79			6720	A	80	SPACE	- - -
81	EXISTING RTU	80 3	6720	B	82	SPACE	- - -
83			6720	C	84	SPACE	- - -

SEE SECTION 1 FOR LOAD CALCULATIONS

TOTAL CONNECTED LOAD	64946 VA	DEMAND FACTORS:		NEUTRAL BUS	100 %
LIGHTS @ 125 %	3158 VA	RECEPTS @ 100 %	10000 VA	POWER FACTOR	100 %
RECEPTS @ 50 %	16130 VA	OTHER @ 100 %	20160 VA	DEMAND CURRENT	137.4 AMPS
TOTAL DEMAND LOAD	49448 VA				

TYPE	MANUFACTURER	LAMP	VOLTS WATTS
A	LITHONIA LTG #2VTL4 30L ADPT EZ1 LP835	LED	120 24
B	LITHONIA LTG #CSS L48 4000LM MVOLT 40K 80CRI	LED	120 35
C	LITHONIA LTG #VTL4 30L ADP EZ1 LP835 N80	LED	120 27
D	-	-	120 -
EM	EXITRONIX #LED90	(2) LED HEADS WITH UNIT	120 10
EEM	EXITRONIX #MLED	WEATHERPROOF LED REMOTE	6 8
X	EXITRONIX #VEX-U-BP-WB-WH-120-R	RED LED WITH UNIT	120 10
X2	EXITRONIX #VEX-U/2-BP-WB-WH-120-R	RED LED WITH UNIT	120 10
XEM	EXITRONIX #VLED-1-WH-EL90-R	RED LED AND (2) LED HEADS WITH UNIT	120 15


NOTES:
 1. TYPE 'X' AND/OR 'XEM' FIXTURES SHALL HAVE 12 WATTS OF REMOTE CAPACITY AND POWER TYPE 'EEM'.
 2. TYPE 'X2' SHALL BE DOUBLE FACE.

ELECTRICAL SYMBOLS

- BRANCH CIRCUIT CONCEALED IN CEILING OR WALL. ARROWS INDICATE HOMERUNS TO PANEL. ALL CONDUCTORS ARE #12 EXCEPT AS NOTED.
- CONDUIT RUN UNDERGROUND OR BENEATH FLOOR SLAB.
- GROUNDING CONDUCTOR #12 EXCEPT AS NOTED.
- WALL MOUNTED JUNCTION BOX.
- CEILING MOUNTED JUNCTION BOX.
- PANELBOARD (SURFACE MOUNTED).
- DISCONNECT SWITCH. SIZED AS NOTED.
- DISCONNECT SWITCH FURNISHED WITH EQUIPMENT.
- EXIT LIGHT - SINGLE FACE - ARROWS AS SHOWN.
- EXIT LIGHT - DOUBLE FACE - ARROWS AS SHOWN.
- COMBINATION EXIT/EMERGENCY LIGHT FIXTURE WITH (2) HEADS.
- CEILING OR WALL MOUNTED EMERGENCY LIGHTING UNIT WITH (2) HEADS.
- 2'x4' LIGHT FIXTURE.
- NIGHT LIGHT FIXTURE. FIXTURE SHALL BE ON 24/7.
- FLUORESCENT STRIP FIXTURE.
- CEILING LIGHT FIXTURE.
- WALL MOUNTED LIGHT FIXTURE.
- REMOTE WEATHERPROOF EMERGENCY LIGHT FIXTURE.
- SINGLE POLE SWITCH. +3'-10" AFF.
- THREE-WAY SWITCH +3'-10" AFF.
- FOUR-WAY SWITCH +3'-10" AFF.
- DUPLEX RECEPTACLE. +1'-6" AFF OR AS NOTED.
- DUPLEX RECEPTACLE INSTALLED ABOVE COUNTERTOP.
- DUPLEX RECEPTACLE WITH WEATHERPROOF PLATE. HEIGHT AS NOTED.
- DUPLEX RECEPTACLE W/GROUND FAULT PROTECTION. +1'-6" AFF OR AS NOTED.
- FOURPLEX RECEPTACLE. +1'-6" AFF OR AS NOTED.
- FOURPLEX RECEPTACLE INSTALLED ABOVE COUNTERTOP.
- COMBINATION VOICE/DATA OUTLET WITH 3/4" CONDUIT STUBBED UP OUT OF BOX TO ABOVE ACCESSIBLE CEILING. +1'-6" AFF OR AS NOTED.
- COMBINATION VOICE/DATA OUTLET WITH 3/4" CONDUIT STUBBED UP OUT OF BOX TO ABOVE ACCESSIBLE CEILING. INSTALLED ABOVE COUNTERTOP.
- TELEVISION OUTLET. +1'-6" AFF OR AS NOTED.
- HEIGHT TO CENTERLINE OF OUTLET BOX ABOVE FINISHED FLOOR.
- ROOF TOP UNIT AND NUMBER.
- ELECTRIC WATER HEATER AND NUMBER.
- EXHAUST FAN AND NUMBER.
- CONDENSING UNIT AND NUMBER.
- FURNACE AND NUMBER.
- ABOVE FINISH FLOOR.
- EXISTING TO REMAIN.
- EXISTING RELOCATED.
- ELECTRICAL CONTRACTOR.
- ELECTRIC DRINKING FOUNTAIN.
- NIGHT LIGHT. FIXTURE SHALL BE ON 24/7.

ELECTRICAL GENERAL NOTES

- A) CONTRACTOR SHALL COORDINATE INSTALLATION REQUIREMENTS AND SCHEDULING OF ALL WORK WITH ARCHITECT AND GENERAL CONTRACTOR.
- B) INSTALLATION SHALL COMPLY WITH LATEST EDITION OF N.E.C. AND LOCAL AUTHORITY HAVING JURISDICTION.
- C) CONTRACTOR SHALL BE LICENSED TO PERFORM WORK IN MUNICIPALITY WHERE PROJECT IS LOCATED.
- D) ALL WIRING SHALL BE INSTALLED IN CONDUIT. EMT CONDUIT WITH SET SCREW FITTINGS MAY BE UTILIZED WHERE PERMITTED BY CODE. MINIMUM CONDUIT SIZE SHALL BE 1/2".
- E) ALL WIRING SHALL BE COPPER WITH 600 VOLT INSULATION AND COLOR CODED, UNLESS NOTED OTHERWISE.
- F) CONTRACTOR SHALL OBTAIN AND PAY FOR ALL PERMIT AND INSPECTION FEES.
- G) MC CABLE MAY BE INSTALLED WHERE PERMITTED BY CODE. CONDUCTORS SHALL BE MINIMUM #12 GAUGE AND COPPER.
- H) INSTALL BLANK COVER PLATE ON ALL PULL BOXES AND JUNCTION BOXES.
- I) TYPEWRITTEN PANELBOARD DIRECTORY SHALL BE PROVIDED FOR PANELBOARD AND CORRECTLY FILLED OUT.
- J) CONTRACTOR SHALL COORDINATE INSTALLATION OF ELECTRICAL WORK WITH ALL OTHER TRADES INVOLVED WITH CONSTRUCTION OF PROJECT.
- K) ALL WIRING DEVICES SHALL BE RATED 20 AMP. OR AS NOTED ON DRAWINGS. COORDINATE LOCATION WITH ARCHITECT AND OWNER PRIOR TO ROUGH-IN.
- L) CONTRACTOR SHALL FIELD VERIFY EXACT ROUTING OF ALL CONDUITS TO NEW EQUIPMENT.
- M) FURNISH MATERIALS AND LABOR FOR A COMPLETE AND OPERATIONAL ELECTRICAL INSTALLATION.
- N) MATERIAL AND EQUIPMENT SHALL BE NEW AND SHALL BEAR THE 'UL' LABELS AS REQUIRED.
- O) CONTRACTOR SHALL COORDINATE INSTALLATION OF EQUIPMENT FURNISHED BY OTHERS.
- P) PVC (SCHEDULE 40) CONDUIT MAY BE USED FOR CONDUITS INSTALLED BELOW FINISHED GRADE OR CONCRETE FLOOR SLAB. PROVIDE WITH APPROVED FITTINGS.
- Q) DISCONNECT SWITCHES SHALL BE MANUFACTURED BY ITE/SIEMENS OR EQUAL. NEMA 1 FOR INDOOR INSTALLATION AND NEMA 3R FOR OUTDOOR INSTALLATION.
- R) ALL LIGHT FIXTURES AND DEVICES MOUNTED IN CEILING SHALL BE BRACED TO RESIST SEISMIC FORCES IN ACCORDANCE WITH IBC, NEC, AND LOCAL AUTHORITY HAVING JURISDICTION.
- S) VOICE/DATA AND THERMOSTAT OUTLET BOXES SHALL BE PROVIDED AND INSTALLED WITH 3/4" CONDUIT STUBBED UP OUT TOP OF BOX TO ABOVE ACCESSIBLE CEILING. PROVIDE BUSHING ON END OF CONDUIT.
- T) EMERGENCY AND EXIT LIGHT FIXTURES SHALL BE PROVIDED WITH BATTERY BACK-UP FOR MINIMUM OF (90) MINUTES. EMERGENCY AND EXIT LIGHT FIXTURES SHALL BE CONNECTED TO HOT LEG OF CIRCUIT, NOT SWITCHED.
- U) PANELBOARDS ARE EXISTING TO REMAIN. NEW CIRCUIT BREAKERS INSTALLED IN EXISTING PANELBOARDS SHALL MATCH PANELBOARD CONSTRUCTION AND AIC RATING. PANELS ARE MANUFACTURED BY ITE/SIEMENS, SQUARE 'D', G.E., OR CUTLER-HAMMER.

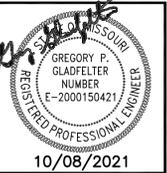

KC UC LS
 451 NORTHWEST MURRAY RD
 LEE'S SUMMIT, MO



JOB NO.:	212423G
DATE:	10/08/2021
REVISIONS:	
DESIGNED BY:	CEG
DRAWN BY:	CEG
CHECKED BY:	CEG
SHEET NO.	

E300