

ELECTRICAL SPECIFICATIONS

PART I - GENERAL

A. CONDITIONS
1. FURNISH AND INSTALL A COMPLETELY WIRED AND OPERATIONAL ELECTRICAL SYSTEM AS SHOWN ON THE DRAWINGS AND SPECIFIED HEREIN, INCLUDING BUT NOT LIMITED TO, THESE MAJOR ITEMS.
A. LIGHTING FIXTURES AS INDICATED AND SPECIFIED ON THE PLANS.
B. ELECTRICAL PANELS, SERVICE, CONDUIT, WIRING, ETC., FOR ALL OUTLETS AND EQUIPMENT.
C. TELEPHONE, TELEVISION, AND FIRE ALARM. OUTLETS AND CONDUIT AS INDICATED.

2. OBTAIN AND REVIEW ALL OTHER DRAWINGS INCLUDING REFLECTED CEILING PLAN, INTERIOR AND EXTERIOR ELEVATIONS, FURNITURE PLANS AND ALL MILL WORK DRAWINGS. COORDINATE INSTALLATION OF ALL ELECTRICAL DEVICES AND EQUIPMENT PRIOR TO ROUGH-IN.

3. OBTAIN SUBMITTAL AND SHOP DRAWINGS FROM OTHER TRADES AND EQUIPMENT TO COORDINATE INSTALLATION ACCORDINGLY.

4. INSTALLATION SHALL COMPLY WITH ALL CURRENT APPLICABLE CODES AND GOVERNING AGENCIES HAVING JURISDICTION.

5. FIRE ALARM SYSTEM, IF REQUIRED PER IBC, SHALL BE DESIGN-BUILD BY OWNER'S/GC'S FIRE ALARM CONTRACTOR. DESIGN SHALL BE IN ACCORDANCE WITH NFPA 72. FIRE ALARM CONTRACTOR SHALL SUBMIT STAMPED DRAWINGS TO AHI FOR REVIEW AND APPROVAL. FIRE ALARM CONTRACTOR IS RESPONSIBLE FOR TESTING AND VERIFYING THAT THE AUDIBILITY OF THE FIRE ALARM SYSTEM MEETS A MINIMUM OF 15 DBA ABOVE AMBIENT NOISE LEVELS. ADD HORNS WHERE REQUIRED TO MAINTAIN MINIMUM LEVELS.

6. PROVIDE FIRE STOP ON ALL PIPING THAT PENETRATES RATED WALLS. METHOD OF FIRE STOP SHALL MEET WALL RATING. REFER TO ARCHITECTURAL DRAWINGS FOR LOCATION OF FIRE RATED WALLS. THE CONTRACTOR SHALL PROVIDE FIRE RATED ENCLOSURES AROUND ALL ROUGH-IN BOXES, PANELS, ETC. THAT ARE LOCATED IN FIRE RATED WALLS AND SHALL FIRE CAULK ALL OPENINGS IN RATED ASSEMBLIES.

B. RELATED WORK BY OTHERS

1. THE ELECTRICAL CONTRACTOR SHALL PROVIDE CONDUIT, TRENCH, AND BACKFILL FOR ELECTRICAL SERVICE ENTRANCE FROM THE MAIN SERVICE TO UTILITY POINT OF ELECTRICAL SERVICE. ELECTRICAL CONTRACTOR SHALL COORDINATE THE INSTALLATION OF THE ELECTRICAL SERVICE ENTRANCE WITH SERVING UTILITY COMPANY.

2. THE ELECTRICAL CONTRACTOR SHALL PROVIDE CONDUIT, TRENCH, AND BACKFILL FOR PRIMARY PHONE AND CATV SERVICE FROM THE TELEPHONE TERMINAL BOARD OR CABINET TO THE PHONE COMPANY AND CATV COMPANY POINT OF SERVICE COORDINATE WITH LOCAL UTILITY COMPANIES.

C. CODES, REGULATIONS, AND STANDARDS

1. THE INSTALLATION SHALL COMPLY WITH APPLICABLE LOCAL AND STATE CODES AND ORDINANCES, WITH THE REGULATIONS OF THE LATEST EDITION OF THE NATIONAL ELECTRIC CODE AND WITH THE REQUIREMENTS OF THE POWER, TELEPHONE, AND CATV COMPANIES FURNISHING SERVICES TO THIS INSTALLATION.

2. THE LATEST EDITIONS OF THE FOLLOWING INDUSTRY STANDARDS, SPECIFICATIONS, AND CODES ARE MINIMUM REQUIREMENTS:

- THE NATIONAL ELECTRICAL MANUFACTURER'S ASSOCIATION STANDARDS.
- THE NATIONAL ELECTRICAL CODE, INCLUDING LOCAL AMENDMENTS.
- UNDERWRITER LABORATORIES INCORPORATED STANDARDS.
- AMERICAN NATIONAL STANDARDS INSTITUTE.
- INTERNATIONAL BUILDING CODE.

D. INSPECTION OF SITE

1. PRIOR TO SUBMITTING A BID FOR ELECTRICAL WORK, THE CONTRACTOR SHALL VISIT THE SITE OF THE PROPOSED CONSTRUCTION AND SHALL THOROUGHLY ACQUAINT HIMSELF WITH EXISTING UTILITIES, AND WORKING CONDITIONS TO BE ENCOUNTERED, ETC. ALLOWANCE WILL NOT BE MADE FOR NONCOMPLIANCE WITH THIS CONDITION AFTER BIDDING.

2. ELECTRICAL INSTALLATION SHALL MEET THE EXISTING CONDITIONS.

E. STORAGE AND HANDLING OF MATERIAL

1. DELIVER MATERIALS AND EQUIPMENT TO THE PROJECT IN THE MANUFACTURER'S ORIGINAL, UNOPENED, LABELED CONTAINERS. PROTECT AGAINST MOISTURE, TAMPERING, OR DAMAGE FROM IMPROPER HANDLING OR STORAGE. CONTRACTOR SHALL PROTECT AND BE RESPONSIBLE FOR ANY DAMAGE TO WORK OR MATERIALS UNTIL FINAL ACCEPTANCE BY THE OWNER AND SHALL MAKE GOOD WITHOUT COST TO THE OWNER, ANY DAMAGE OR LOSS THAT MAY OCCUR DURING THIS PERIOD.

2. ARRANGE FOR TIMELY DELIVERY OF MATERIALS AND EQUIPMENT TO THE JOB SITE IN ORDER TO MINIMIZE THE LENGTH OF TIME BETWEEN DELIVERY AND INSTALLATION.

3. COVER AND PROTECT ANY MATERIAL WHICH MAY BE AFFECTED BY THE WEATHER WHILE IN TRANSIT OR STORED AT THE PROJECT SITE. ANY MATERIAL FOUND DEFECTIVE OR NOT INSTALLED IN ACCORDANCE WITH THE CONTRACT DOCUMENTS MAY BE REJECTED BY THE ENGINEER.

F. CLEANUP

1. KEEP THE PREMISES FREE FROM ACCUMULATION OF WASTE MATERIALS, OR RUBBISH CAUSED BY EMPLOYEES OR WORK UNDER THIS DIVISION OF THE SPECIFICATIONS. AT THE COMPLETION OF THE WORK REMOVE ALL SURPLUS MATERIALS, TOOLS, ETC., AND LEAVE THE PREMISES BROOM-CLEAN.

G. EXCAVATION, CUTTING, AND FITTING

1. PERFORM ALL EXCAVATION AND BACK FILLING REQUIRED FOR WORK PERFORMED UNDER THIS DIVISION OF THE SPECIFICATIONS. USE EXCAVATED MATERIALS FOR BACKFILL UNLESS OFF SITE MATERIALS ARE DEMAILED NECESSARY.

2. PERFORM THE EXCAVATION, CUTTING, FITTING, REPAIRING, AND FINISHING OF THE WORK NECESSARY FOR THE INSTALLATION OF THE EQUIPMENT OF THIS SECTION. HOWEVER, NO CUTTING OF THE WORK OF OTHER TRADES OR OF ANY STRUCTURAL MEMBERS SHALL BE DONE WITHOUT THE CONSENT OF THE ARCHITECT.

H. DRAWINGS

1. THE DRAWINGS INDICATE THE GENERAL ARRANGEMENT AND LOCATIONS OF THE ELECTRICAL WORK DATA PRESENTED ON THESE DRAWINGS ARE AS ACCURATE AS PLANNING CAN DETERMINE, BUT FIELD VERIFICATION OF ALL DIMENSIONS, LOCATIONS, LEVELS, ETC., TO SUIT FIELD CONDITIONS IS REQUIRED. REVIEW ALL ARCHITECTURAL, STRUCTURAL, AND MECHANICAL DRAWINGS AND ADJUST ALL WORK TO MEET THE REQUIREMENTS OF CONDITIONS SHOWN. THE ARCHITECTURAL DRAWINGS SHALL TAKE PRECEDENCE OVER ALL OTHER DRAWINGS. DISCREPANCIES BETWEEN DIFFERENT PLANS, OR BETWEEN DRAWINGS AND SPECIFICATIONS, OR REGULATIONS AND CODES GOVERNING THE INSTALLATION SHALL BE BROUGHT TO THE ATTENTION OF THE ENGINEER IN WRITING BEFORE THE DATE OF BID OPENING. IF DISCREPANCIES ARE NOT REPORTED, THE CONTRACTOR SHALL BID THE GREATER QUANTITY OR BETTER QUALITY, AND APPROPRIATE ADJUSTMENTS WILL BE MADE AFTER CONTRACT AWARD. CONTRACTOR SHALL BE RESPONSIBLE TO FIELD MEASURE AND CONFIRM MOUNTING HEIGHTS AND LOCATION OF ELECTRICAL EQUIPMENT WITH RESPECT TO COUNTERS, RADIATION, ETC. DO NOT SCALE DISTANCES OFF THE ELECTRICAL DRAWINGS, USE ACTUAL BUILDING DIMENSIONS.

I. COOPERATION WITH OTHER CONTRACTORS

1. COOPERATE WITH THE OTHER TRADES SO THAT THE INSTALLATION OF THE ELECTRICAL OUTLETS AND EQUIPMENT WILL BE PROPERLY COORDINATED. CONDUIT, LIGHTING FIXTURES, AND OTHER EQUIPMENT LOCATIONS SHALL BE VERIFIED WITH OTHER TRADES TO AVOID CONFLICT WITH THE PIPING, DUCTWORK, STEEL, BEAMS, OR OTHER OBSTRUCTIONS.

2. CAREFULLY VERIFY THE LOCATIONS OF THE OUTLET BOXES AND DETERMINE THAT THEY HAVE NOT BEEN DISTURBED DURING THE INSTALLATION OF MATERIALS OF OTHER TRADES.

3. COORDINATE THE LOCATION OF THE TRENCHES AND CONDUITS FOR ELECTRICAL AND TELEPHONE UTILITY SERVICES WITH THE GENERAL CONTRACTOR.

4. COORDINATE HVAC AND PLUMBING EQUIPMENT CONNECTION REQUIREMENTS WITH HVAC AND PLUMBING CONTRACTORS.

J. RECORD DRAWINGS

1. THE ELECTRICAL CONTRACTOR SHALL MAINTAIN A SET OF DRAWINGS AT THE JOB SITE FOR THE EXCLUSIVE PURPOSE OF MAINTAINING A RECORD OF ALL WORK INSTALLED AND TO SHOW ANY DEVIATIONS FROM THE WORK INDICATED ON THE DRAWINGS.

2. AT THE COMPLETION OF THE PROJECT, ONE SET OF REPRODUCIBLE DRAWINGS, SHOWING ALL RECORD CONDITIONS, SHALL BE DELIVERED TO THE OWNER FOR ACCEPTANCE PRIOR TO FINAL PAYMENT.

PART II - PRODUCTS AND EXECUTION

A. MATERIALS

1. ALL MATERIALS SHALL BE NEW AND OF QUALITY AS SPECIFIED ON THE PLANS OR SPECIFICATIONS AND MUST CARRY THE UNDERWRITER'S LABORATORIES APPROVAL COVERING THE PURPOSE FOR WHICH THEY ARE USED, IN ADDITION TO MEETING ALL REQUIREMENTS OF THE CURRENT APPLICABLE CODES AND REGULATIONS.

B. SHOP DRAWINGS AND APPROVALS

1. THE ITEMS SPECIFIED HEREIN AND ON DRAWINGS ARE USED AS A STANDARD OF QUALITY. ANY MATERIALS OF EQUAL QUALITY AND AESTHETIC VALUE WILL BE GIVEN CONSIDERATION AS A SUBSTITUTE FOR THE MATERIALS SPECIFIED. NO APPROVAL WILL BE GIVEN TO A SPECIFIC CATALOG NUMBER, MODEL, OR TYPE OF EQUIPMENT, PRIOR TO BIDDING. AFTER BIDDING, THE DECISION OF THE ARCHITECT AND/OR ENGINEER DETERMINING EQUAL MATERIALS WILL BE FINAL.

2. THE CONTRACTOR SHALL SUBMIT SEVEN (7) IDENTICAL BOUND SETS OF SHOP DRAWINGS ON THE FOLLOWING ITEMS:

- LIGHTING FIXTURE CUTS AND PERFORMANCE DATA.
- OUTLINE DRAWINGS AND DATA SHEETS OF EACH PANELBOARD, LOAD CENTERS, AND DISTRIBUTION PANELS.
- OUTLINE DRAWINGS OF ALL SWITCH GEAR COMPONENTS.
- WIRING DEVICES AND COVERPLATES.
- ALL CIRCUIT BREAKERS INSTALLED IN PANELBOARDS, LOAD CENTERS, AND DISTRIBUTION PANELS.

3. SUBMIT ITEMS AT ONE TIME IN A NEAT AND ORDERLY MANNER WITHIN 15 DAYS OF AWARD OF CONTRACT. PARTIAL SUBMITTALS WILL NOT BE ACCEPTABLE.

C. SYSTEM GROUNDING

1. GROUNDING SHALL COMPLY WITH REQUIREMENTS OF ARTICLE 250. ALL EXPOSED NONCURRENT CARRYING METALLIC PARTS OF ELECTRICAL EQUIPMENT, METALLIC RACEWAY SYSTEMS, METALLIC CABLE ARMOR, GROUNDING CONDUCTOR OF NONMETALLIC SHEATHED CABLES, GROUNDING CONDUCTOR IN NONMETALLIC RACEWAYS, AND GROUNDED CONDUCTORS OF THE WIRING SYSTEM SHALL BE GROUNDED.

2. GROUNDING CONDUCTOR (NEUTRAL) OF THE WIRING SYSTEM SHALL BE CONNECTED TO THE SYSTEM GROUNDING CONDUCTOR AT A SINGLE PLACE IN EACH SYSTEM BY REMOVABLE BONDING JUMPERS, SIZED ACCORDING TO THE APPLICABLE PROVISIONS OF THE NATIONAL ELECTRICAL CODE. THE GROUNDED CONDUCTOR (NEUTRAL) TO THE GROUNDING CONDUCTOR CONNECTION SHALL BE LOCATED IN THE ENCLOSURE FOR THE SYSTEM'S OVERCURRENT PROTECTION OR WHERE OTHERWISE INDICATED ON THE PLANS OR SPECIFICATIONS.

3. A GROUND BUS SEPARATE FROM THE NEUTRAL BUS SHALL BE PROVIDED IN ALL DISTRIBUTION PANELS AND PANELBOARDS. PROPER TORQUE ON GROUND BUS SHALL BE VERIFIED, PER MANUFACTURER'S RECOMMENDATIONS, PRIOR TO ENERGIZING EQUIPMENT.

4. GROUNDING BUSES AND NEUTRAL BUSES IN ALL DISTRIBUTION PANELS, LOAD CENTERS, PANELBOARDS, AND THOSE PROVIDED IN ANY EQUIPMENT SHALL BE ISOLATED EXCEPT WHERE REQUIRED TO BE CONNECTED AS SPECIFIED ABOVE FOR THE SERVICE ENTRANCE.

5. WHEN INDICATED ON THE DRAWINGS, EQUIPMENT GROUNDING CONDUCTORS SHALL BE EXTENDED FROM THE GROUND BUS IN THE DISTRIBUTION EQUIPMENT TO THE RECEPTACLE, FIXTURE OR DEVICE LUGS WHERE THEY ARE PROVIDED. WHERE LUGS ARE NOT PROVIDED, EQUIPMENT GROUNDING CONDUCTORS SHALL BE CONNECTED TO EQUIPMENT ENCLOSURES. THE CONNECTIONS SHALL BE ARRANGED SUCH THAT REMOVAL OF THE RECEPTACLE, EQUIPMENT GROUND CONDUCTORS, OR GROUND JUMPERS FROM GROUND BUSING SHALL NOT AFFECT THE GROUND SYSTEM.

6. RACEWAYS MAY NOT BE USED AS A GROUNDING CONDUCTOR FOR POWER AND LIGHTING CIRCUITS. ALL CONDUIT SHALL HAVE SEPARATE CODE SIZED GREEN GROUND WIRE INSTALLED IN THE CONDUIT TO INSURE A CONTINUOUS GROUNDING PATH.

7. IN INACCESSIBLE LOCATIONS, MAKE CONNECTIONS BY EXOTHERMIC WELD PROCESS.

8. IN ACCESSIBLE LOCATIONS, CONNECTIONS SHALL BE MADE WITH BOLTED THROUGH, APPROVED SOLDERLESS BRONZE GROUNDING DEVICES.

D. WIRE

1. CONDUCTOR SIZES SHOWN ON THE DRAWINGS ARE BASED ON COPPER WIRE. UNLESS OTHERWISE SPECIFIED, ALL WIRE SHALL BE TYPE XHHW OR SE FOR FEEDERS OR BRANCH CIRCUITS LARGER THAN 4 AWG, TYPE THHN/THWN INSULATION FOR FEEDERS AND BRANCH CIRCUITS 4 AWG AND SMALLER. ALL BRANCH CIRCUIT WIRING SHALL BE COPPER.

2. ALUMINUM CONDUCTORS MAY BE UTILIZED FOR SERVICE ENTRANCE AND PANEL FEEDERS. CONDUCTORS SHALL BE ALUMINUM ALLOW AA-8000 SERIES.

3. THE WIRES SHALL BE MARKED WITH COLOR TO SIMPLIFY CIRCUIT IDENTIFICATION. UNLESS OTHERWISE REQUIRED BY LOCAL ORDINANCES GROUND WIRES SHALL BE GREEN, NEUTRAL WIRES SHALL BE 120V-WHITE, AND LIVE WIRES 208Y/120V AND 120/240 SHALL BE BLACK (PHASE A), RED (PHASE B), AND BLUE (PHASE C). CIRCUIT SHALL BE LABELED IN EACH J-BOX.

4. ALL CONDUCTORS SHALL BE RATED 600 VOLT.

5. SPLICES IN EXTERIOR PULL BOXES AND MANHOLES SHALL BE WEATHERPROOF USING "SCOTCHCAST" SPLICE KIT OR APPROVED EQUAL. SEAL ENDS OF CONDUITS AND DUCTS WITH "DUCTSEAL" OR APPROVED EQUAL.

6. PROVIDE SOLID CONDUCTOR FOR 12 AWG AND SMALLER.

7. NO WIRE SHALL BE INSTALLED IN THE CONDUIT SYSTEM UNTIL THE CONDUIT SYSTEM IS COMPLETE. USE MINERALGAC NO. 100 OR EQUIVALENT AS A LUBRICANT TO FACILITATE THE INSTALLATION OF THE CONDUCTORS IN THE CONDUIT SYSTEM.

8. MC CABLE WITH COPPER CONDUCTORS AND GROUND WIRE MAY BE USED WHERE PERMITTED.

E. CONDUIT

1. ALL WIRING SHALL BE INSTALLED IN LISTED METALLIC CONDUIT EXCEPT AS PERMITTED IN OTHER SECTIONS. RGS WITH A 20 MIL PVC COATING WILL BE USED WHEN IN CONTACT WITH EARTH. IMC MAY BE USED IN INDOOR LOCATIONS NOT IN CONTACT WITH THE EARTH. EMT MAY BE USED IN INDOOR LOCATIONS NOT IN CONTACT WITH EARTH, NOT IN CONCRETE SLABS OR WALLS AND NOT SUBJECT TO DAMAGE. PVC MAY BE USED IN OR BELOW CONCRETE AND DIRECT BURIED IN EARTH. FLEXIBLE STEEL CONDUIT SHALL BE USED FOR INDOOR FINAL CONNECTIONS TO EQUIPMENT IN LENGTHS NOT TO EXCEED 72". LIQUID-TIGHT FLEXIBLE STEEL CONDUIT SHALL BE FOR OUTDOOR FINAL CONNECTIONS TO EQUIPMENT NOT TO EXCEED 48".

2. WHERE CONDUIT ENTERS OUTLET BOXES, FIXTURES OR CABINETS, FIRMLY FASTEN WITH STEEL SET SCREW, COMPRESSION CONNECTORS, OR DOUBLE LOCKNUTS FOR GRC. ALL CONNECTIONS SHALL HAVE BUSHINGS OR INSULATED THROAT CONNECTORS. FIRMLY FASTEN CONDUIT TO THE BUILDING CONSTRUCTION. RUN EXPOSED CONDUIT PARALLEL TO THE BUILDING LINES, SUPPORTED BY APPROPRIATE HANGERS (UNISTRUT, T & B OR APPLTON, OR EQUAL).

3. COVER METALLIC CONDUIT IN CONTACT WITH EARTH WITH POLYETHYLENE TAPED SPIRAL WRAPPED, 1/2 LAPPED TO PROVIDE 20 MIL THICKNESS. TAPE SHALL BE SCOTCH NO. 50 TAPE. CONDUIT AND DUCTS NOT UNDER BUILDINGS AND FEEDER DUCTS SHALL BE INSTALLED PER N.E.C. 300-5. MAKE JOINTS WITH COMPOUND TO BE WATERTIGHT.

4. SCHEDULE 40 PVC CONDUIT SHALL BE PERMITTED UNDERGROUND WITH PROPER FITTINGS, ALL UL APPROVED AND CEMENTED JOINTS. PENETRATIONS THROUGH FLOOR SLABS AND BENDS GREATER THAN 22" SHALL BE WRAPPED RIGID GALVANIZED STEEL ELBOWS.

5. FITTINGS AND CONDUIT BODIES SHALL BE STEEL. DIECAST FITTINGS ARE NOT ACCEPTABLE.

6. CONDUIT SIZES SHALL BE AS REQUIRED BY CODE AND AS INDICATED OR SPECIFIED.

7. ALL EMPTY CONDUIT SYSTEMS SHALL HAVE A 200 LB. TEST NYLON PULL STRING TO FACILITATE INSTALLATION OF FUTURE WIRE.

8. WIRING, CONDUITS, AND OUTLETS SHALL BE CONCEALED WITH THE BUILDING STRUCTURE, EXCEPT THAT CERTAIN MOTOR AND LIGHTING FEEDER CONDUITS MAY BE RUN EXPOSED IN CERTAIN AREAS AS INDICATED ON THE DRAWINGS.

9. CONDUIT PENETRATION THROUGH ROOF SHALL HAVE ROOF FLASHING WITH CAULK TYPE COUNTER FLASHING SLEEVE. INSTALLATION SHALL BE WATERTIGHT.

10. CONDUITS SHALL BE ROUTED PARALLEL AND PERPENDICULAR TO THE STRUCTURE.

F. OUTLET, PULL, AND JUNCTION BOXES

1. ALL JUNCTION AND OUTLET BOXES CONCEALED IN WALLS SHALL BE STEEL.

2. BOXES INSTALLED IN POURED CEMENT FLOORS SHALL BE FLUSH TYPE CAST IRON OR STEEL WITH WATERTIGHT GASKETED COVERS. WHERE BOXES ARE INSTALLED IN FLOORS WITH TILE OR CARPET FLOOR COVERING, COVERS SHALL BE OF THE RECESSED TYPE TO ACCOMMODATE THE FLOOR COVERING.

3. BOXES INSTALLED FOR THE ALARM, COMPUTER, AND SECURITY SYSTEM SHALL BE PROVIDED WITH APPROPRIATE COVER PLATES.

4. BOXES FOR TELEPHONE, COMPUTER, T.V., FIRE ALARM, SECURITY, AND SIMILAR SYSTEMS SHALL BE MINIMUM 2-1/8" DEEP.

G. WIRING DEVICES (COMMERCIAL)

1. WALL SWITCHES SHALL BE SPECIFICATION GRADE AC SILENT TYPE SWITCHES, 20A 120/277 VOLT.

2. RECEPTACLES SHALL BE SPECIFICATION GRADE, DUPLEX TYPE, NEMA5-20R, 20 AMPERE, 120VOLT GROUNDED TYPE. SPECIAL APPLICATION RECEPTACLES SHALL BE INDICATED ON PLANS. MOUNT WITH THE GROUND DOWN.

3. DEVICE PLATES SHALL BE EQUAL TO SIERRA SMOOTH-LINE PLASTIC WALL PLATES. COLOR SHALL BE WHITE, UNLESS OTHERWISE NOTED.

4. RECEPTACLES IN OUTDOOR AND WET LOCATIONS SHALL BE INSTALLED WITH A HINGED OUTLET COVER/ENCLOSURE CLEARLY MARKED AND U.L. LISTED SUITABLE FOR WET LOCATIONS WHILE IN USE, EQUAL TO TAYMAC SPECIFICATION GRADE.

H. SERVICE ENTRANCE SECTION

1. THE SERVICE ENTRANCE EQUIPMENT SHALL BE AS INDICATED ON THE DRAWINGS. EQUIPMENT SHALL CARRY THE U.L. LABEL AND SHALL CONFORM TO THE POWER COMPANY REGULATIONS.

2. SERVICE ENTRANCE EQUIPMENT SHALL BE PROVIDED WITH A FULLY RATED COPPER OR ALUMINUM BUS. HORIZONTALLY TAPERED BUSING SHALL NOT BE ALLOWED.

J. PANEL BOARDS

1. CIRCUIT BREAKER TYPE AS INDICATED ON DRAWINGS. UNLESS INDICATED OTHERWISE, ALL PANELS SHALL HAVE PANEL HAVE PANEL BOARD TYPE CONSTRUCTION WITH BOLT-ON CIRCUIT BREAKERS FOR 3Ø PANELS.

2. MANUFACTURERS SHALL BE GENERAL ELECTRIC, SQUARE D, SIEMENS, CUTLER-HAMMER WITH VOLTAGE, SIZES, AND RATINGS AS INDICATED ON DRAWINGS.

3. THE CIRCUIT BREAKERS SHALL BE OPERABLE IN ANY POSITION AND BE REMOVABLE FROM THE FRONT OF THE PANEL BOARD WITHOUT DISTURBING THE ADJACENT UNITS. BRANCH BREAKERS SHALL BE OF SUCH DESIGN THAT COMBINATION OF SINGLE-POLE, DOUBLE-POLE, AND THREE-POLE BREAKERS CAN BE ASSEMBLED ON THE SAME PANEL. EACH BRANCH CIRCUIT SHALL BE CLEARLY NUMBERED. BRANCH AND MAIN TERMINALS SHALL BE SOLDERLESS TYPE. HANDLE TIES TO FORM MULTI-POLE BREAKERS NOT ACCEPTABLE.

L. LIGHTING FIXTURES

1. PROVIDE ALL LIGHTING FIXTURES, WIRED AND CONNECTED. THE DRAWINGS INDICATE THE FIXTURES FOR EACH LOCATION. PROVIDE LAMPS FOR ALL FIXTURES. THE LAMPS SHALL BE BY THE SAME MANUFACTURER. VERIFY CEILING CONSTRUCTION BEFORE ORDERING RECESSED UNITS. PROVIDE PLASTER FRAMES AND HANGERS AS REQUIRED. CEILING CONSTRUCTION, ARCHITECTURAL ACCESSORIES, VOLTAGE, AND BALLASTS TO MEET THE EXISTING CEILING CONDITION.

M. LIGHTING CONTROL

1. FURNISH AND INSTALL TIME SWITCHES, PHOTOCELLS, CONTRACTORS AND FULL LIGHTING CONTROL SYSTEMS AS REQUIRED FOR LIGHTING CONTROLS INDICATED ON THE DRAWINGS.

2. TIME SWITCHES SHALL BE EQUAL TO PARAGON, GENERAL ELECTRIC, TORK, OR INTERMATIC AND SHALL HAVE SIZE AND NUMBER OF POLES AS REQUIRED.

3. PHOTOCELLS SHALL BE EQUAL TO TORK OR INTERMATIC WITH VOLTAGE AS INDICATED.

N. TELEPHONE AND CABLE TELEVISION SYSTEMS

1. TELEPHONE WALL OUTLETS SHALL CONSIST OF STANDARD BOXES MOUNTED 18" ABOVE THE FLOOR UNLESS OTHERWISE INDICATED. PROVIDE A TERMINAL MOUNTING BOARD FOR THE INCOMING SERVICE CABLE.

2. CABLE TELEVISION OUTLETS SHALL CONSIST OF STANDARD BOXES MOUNTED 18" ABOVE THE FLOOR UNLESS OTHERWISE INDICATED. PROVIDE A TERMINAL MOUNTING BOARD FOR THE INCOMING SERVICE CABLE.

Q. GUARANTEE

1. GUARANTEE ALL MATERIAL FURNISHED AND ALL WORKMANSHIP PERFORMED FOR A PERIOD OF ONE YEAR FROM DATE OF FINAL ACCEPTANCE OF WORK. ANY DEFECTS DEVELOPING WITHIN THIS PERIOD, TRACEABLE TO MATERIAL FURNISHED AS A PART OF THIS SECTION OR WORKMANSHIP PERFORMED HEREUNDER, SHALL BE MADE GOOD AT NO EXPENSE TO THE OWNER.

SYMBOLS LEGEND

NOTE: THIS IS A MASTER LEGEND AND NOT ALL SYMBOLS, ETC. ARE NECESSARILY USED ON THE DRAWINGS.

LIGHTING FIXTURES - SYMBOL/LETTER INDICATES LIGHT FIXTURE AS INDICATED ON FIXTURE SCHEDULE

- LED FIXTURE (SEE LIGHTING FIXTURE SCHEDULE)
- FIXTURE WITH EMERGENCY BATTERY DRIVER UNIT TRACK LIGHT
- DOWNLIGHT FIXTURE WITH EMERGENCY BATTERY DRIVER UNIT
- WALL MOUNTED FIXTURE WITH EMERGENCY BATTERY DRIVER UNIT
- PENDANT MOUNTED FIXTURE WITH EMERGENCY BATTERY DRIVER UNIT
- DOWNLIGHT FIXTURE
- WALL MOUNTED FIXTURE
- PENDANT MOUNTED FIXTURE
- WALL WASHER
- SINGLE FACE EXIT SIGN - UNIVERSAL MOUNTED
- SINGLE FACE EXIT SIGN W/ DIRECTIONAL ARROWS - UNIVERSAL MTD
- DOUBLE FACE EXIT SIGN W/ DIRECTIONAL ARROWS - UNIVERSAL MTD
- DUAL HEADED EMERGENCY UNIT
- COMBO DUAL HEADED EMERGENCY AND EXIT SIGN UNIT

LIGHTING CONTROLS

- S SINGLE POLE SWITCH @ +48" UNLESS NOTED
- Sabc SWITCH BANK @ +48" UNLESS NOTED. LOWER CASE LETTER INDICATES FIXTURE CONTROLLED.
- S3 3-WAY SWITCH @ +48" UNLESS NOTED
- S4 4-WAY SWITCH @ +48" UNLESS NOTED
- Sd DIMMER SWITCH - SIZE AS REQUIRED @ +48" UNLESS NOTED
- Sm MANUAL MOTOR STARTER
- Sos WALL SWITCH WITH OCCUPANCY SENSOR. DIGITAL LOW VOLTAGE WALL SWITCH. SWITCH @ +48" UNLESS NOTED.
- SLV TWO BUTTON DIGITAL LOW VOLTAGE WALL SWITCH. PROVIDES ON/OFF/0-10V DIMMING. SWITCH @ +48" UNLESS NOTED. PROVIDE EXTRA CONTROL CABLES NEEDED TO FIXTURE CONTROLLED.
- Ⓢ LIGHTING CONTROLS CEILING MOUNT OCCUPANCY SENSOR
- Ⓢ LIGHTING CONTROLS POWER PACK
- Ⓢ PHOTOCELL
- Ⓢ TIMECLOCK

POWER DISTRIBUTION

- SWITCHBOARD, MOTOR CONTROL CENTER OR DISTRIBUTION BOARD
- 277/480V, 3 PHASE, 4 WIRE PANELBOARD, UNO
- 120/208V, 1 PHASE, 4 WIRE PANELBOARD, UNO
- 120/240V, 1 PHASE, 3 WIRE PANELBOARD, UNO
- TRANSFORMER

POWER DEVICES

- SPECIAL HEAVY DUTY RECEPTACLE - SIZE AS NOTED. @ +18" UNLESS NOTED
- 1/2 SWITCHED RECEPTACLE @ +18" UNLESS NOTED
- FIRE RATED POKE THRU WITH TYPE INDICATED
- FLUSH FLOOR BOX WITH TYPE INDICATED
- SINGLE RECEPTACLE @ +18" UNLESS NOTED
- DUPLEX RECEPTACLE @ +18" UNLESS NOTED
- DOUBLE DUPLEX RECEPTACLE @ +18" UNLESS NOTED
- DUPLEX RECEPTACLE INSTALLED ABOVE COUNTERTOP
- GFCI-RATED DUPLEX RECEPTACLE
- ARC FAULT RATED DUPLEX RECEPTACLE
- TAMPER RESISTANT RATED DUPLEX RECEPTACLE
- DUPLEX RECEPTACLE WITH WEATHERPROOF COVERPLATE @ 18" UNLESS NOTED
- JUNCTION BOX
- DISCONNECT SWITCH - SIZE AND TYPE NOTED
- COMBINATION FUSED STARTER DISCONNECT SWITCH FUSE SIZE AS INDICATED, STARTER SIZE "1"

AUXILIARY SYSTEMS

- MECHANICAL EQUIP. CONNECTION, SEE SCHED. ON MECH. PLAN
- TELEPHONE OUTLET @ +18" UNLESS NOTED
- DATA OUTLET @ +18" UNLESS NOTED
- COMBINATION TELEPHONE/DATA OUTLET @ +18" UNLESS NOTED
- TELEVISION OUTLET @ +60" UNLESS NOTED
- SMOKE DETECTOR
- HEAT DETECTOR
- DUCT SMOKE DETECTOR
- REMOTE TEST STATION WITH INDICATING LIGHT. MOUNT AT 48" AFF UNO.
- AUXILIARY SYSTEM TERMINAL CABINET

GENERAL

- CONDUIT RUN CONCEALED IN WALL OR ABOVE CEILING
- CONDUIT RUN BELOW FLOOR OR GRADE

PI-3,5,7 HOMERUN TO PANELBOARD, INFORMATION AT ARROWS ARE CIRCUIT NUMBERS AND PANELBOARD FOR TERMINATION. REFER TO ASSOCIATED NOTE FOR BRANCH CIRCUIT CONDUCTOR SIZES.

(E) OR ETR: DENOTES EXISTING ITEM/EQUIPMENT TO REMAIN

Architect:

MIDWEST ARCHITECTS
1120 NW EAGLE RIDGE BLVD
GRAIN VALLEY, MO 64029
t: (816) 229-8115

Client:

Ward Development
1120 NW Eagle Ridge Blvd.
Grain Valley, Missouri 64029
t: (816) 229-8115

Consultants:

Civil Engineering:

Quist Engineering, Inc.
821 NE Columbus St.
Lee's Summit, Missouri 64063
t: (816) 550-5675

Structural Engineering:

Structura Logica
18901 E. 299th Street
Harrisonville, MO 64701
t: (816) 872-4883

MEP Engineering:

JSC Engineers
1925 Central Street, Suite 201
Kansas City, MO 64108
t: (816) 272-5289

MO COA NO. 2012006786 / KS COA NO. E-2818

1925 CENTRAL STREET, SUITE 201

KANSAS CITY, MO 64108

phone: (816) 272-5289

email: jsmothers@jscengineers.com

Revisions to technical submissions which are not made or approved by the licensee are prohibited.

Seal:



Project Number: 22-215

Project Type: NEW CONSTRUCTION

Project Name and Address:

I-470 B&T CENTER, LOT 7

2701 NE McBaine Drive

Lee's Summit, Missouri 64064

Issue: Date:

Plan Review 09.30.22

Plan Review Revisions 11.17.22

Plan Review Revisions 01.02.23

Owner Comments 01.17.23


Owner Comments 02.14.23

Sheet Title:

ELECTRICAL SPECIFICATIONS AND SYMBOLS

E-001


CABLE RETAINER ASSEMBLY DETAIL

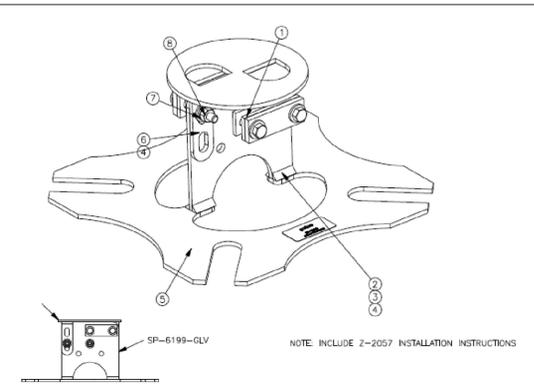

CABLE RETAINER ASSEMBLY FOR 6" FOUNDATION ANCHOR N.T.S.

ITEM	PART NUMBER	DESCRIPTION	QTY
1	SP-6199	WELDED, CABLE RETAINER ASSY FOR 6" FOUNDATION ANCHOR, STEEL	1
2	FS-1001-SS	NUT, HEX 5/16-18, STAINLESS, 304, WAXED	4
3	FS-4201-SS	WASHER, LOCK SPLIT, 5/16", STAINLESS	4
4	FS-4101-SS	WASHER, FLAT, 5/16" X .750" OD STAINLESS	8
5	D-3140	LABEL, 1" X 2" CABLE RETAINER	1
6	FS-2016-SS	BOLT, HEX HD TAP, 5/16-18 X 2-1/4", STAINLESS	4
7	SP-6199-3	BAR, CABLE RETAINER ASSEMBLY, STEEL	2
8	SP-6199-4	PAD, CABLE RETAINER, 3/16" THICK, 90 DURO, RED URETHANE	4


POLE-TO-BASE CONNECTION DETAIL

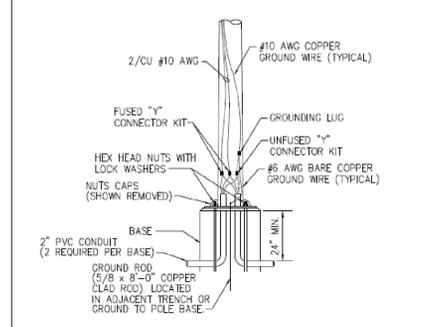


CAUTION: CONTRACTOR SHALL REFER TO UTILITY NOTE (ON PLAN) WHEN INSTALLING LIGHT PEDESTAL IN VICINITY OF UTILITIES.

POLE TO BASE CONNECTIONS NOT TO SCALE

FIXTURE POLE SPECIFICATION

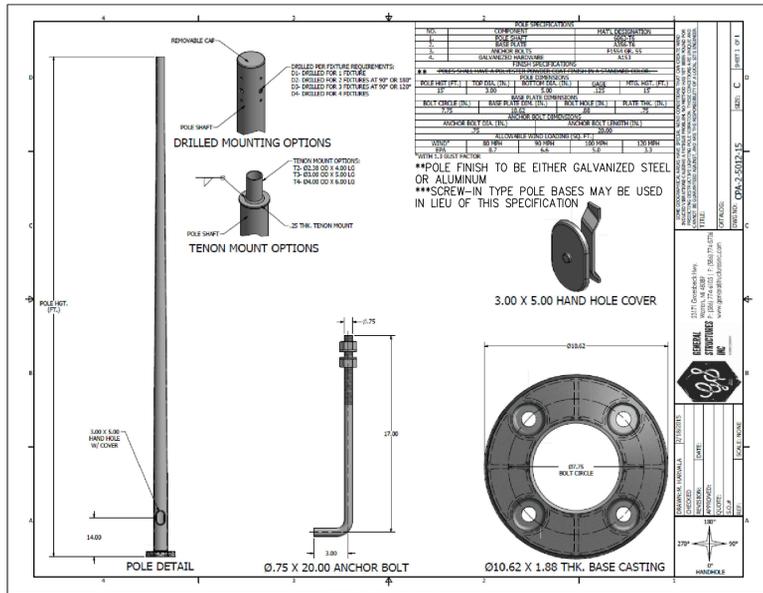


BREAK AWAY FUSE DETAILS

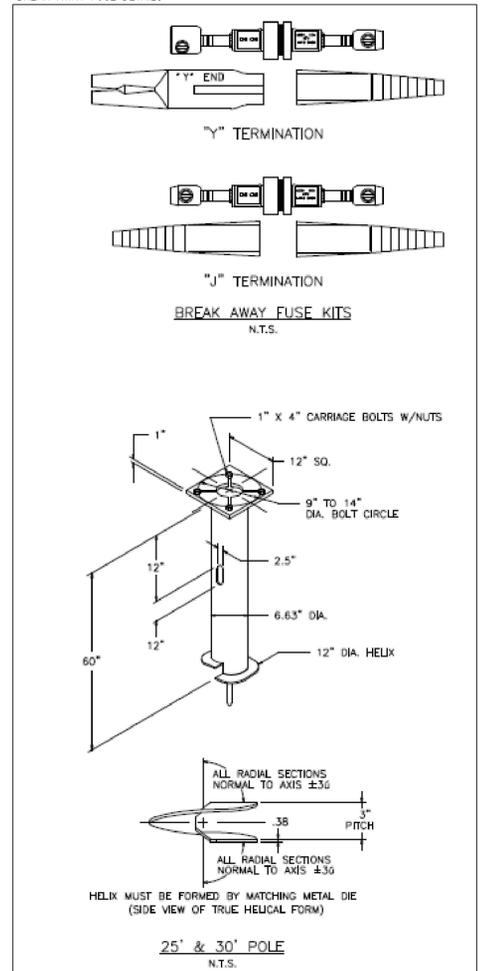


NOTES:
 1. FINISH: HOT DIP GALVANIZE PER ASTM-A153 (LATEST REVISION).
 2. BASEPLATE TO BE PERPENDICULAR TO SHAFT AXIS (±1%±250) AND HOLE CENTERLINE CONCENTRIC (±188) TO SHAFT AXIS.
 3. STENCIL MIN. 1/2 IN. LETTERS MANUFACTURER'S NUMBER AFTER GALVANIZING.
 4. PILOT POINT AND SHAFT AXES TO BE CONCENTRIC (±.125 FIM) AND IN LINE (±2%±250).
 5. FLAME CUT SLOT PERPENDICULAR TO THE BASEPLATE.
 6. PREHEAT, TUMBLEBLAST, HANDGRIND, AND CLEAN BASEPLATE, HELIX, AND PILOT POINT ON ALL WELDED AREAS.
 7. FLAMECUT IRREGULARITIES PERMISSIBLE: (1) VALLEYS NOT TO EXCEED 3/32 IN. BELOW NOMINAL SURFACE LEVEL. (2) PEAKS OR POSITIVE IRREGULARITIES NOT TO EXCEED 1/32 IN. ABOVE NOMINAL SURFACE LEVEL OR INTERSECTIONS OF NOMINAL SURFACES.
 8. MANUFACTURER TO HAVE IN EFFECT INDUSTRY RECOGNIZED WRITTEN QUALITY CONTROL FOR ALL MATERIALS AND MANUFACTURING PROCESSES.
 9. ALL MATERIAL IS TO BE NEW, UNUSED AND MILL TRACEABLE MEETING THE FOLLOWING SPECIFICATIONS:
 BASEPLATE: ASTM A36-(LATEST REVISION) HOT ROLLED STEEL PLATE, (CONFORM TO AASHTO TECH. BUL. #270)
 SHAFT: STEEL PIPE PILES, SEAMLESS OR STRAIGHT WELDED, GRADE-2 PER ASTM A252.
 ALT. MATERIAL: STEEL PIPE TYPE E OR S, GRADE-B PER ASTM A53.
 HELIX: ASTM A635 (LATEST REVISION) HOT ROLLED STEEL.
 PILOT POINT: ASTM A575 (LATEST REVISION) STEEL BAR.
 BOLTS: CARR BOLT PER ANSI B-18.2.1, SAE J429 GRADE-5.3
 10. BASEPLATE IS PERMANENTLY STAMPED WITH MANUFACTURER'S IDENTIFICATION "ABC" IN 1/2" LETTERS AND DATE CODE IN 1/4" LETTERS.


PEDESTAL WIRING DIAGRAM

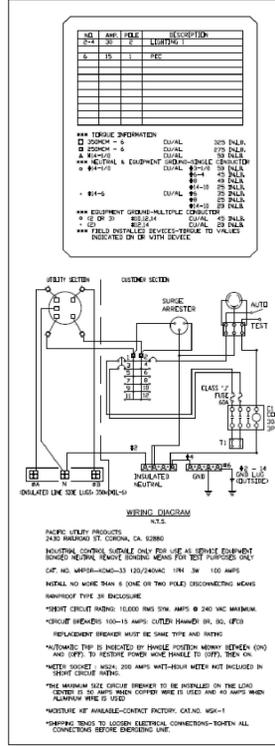


POLE BASE DETAIL - CONFIRM "A" DIMENSION WITH POLE MANUFACTURER

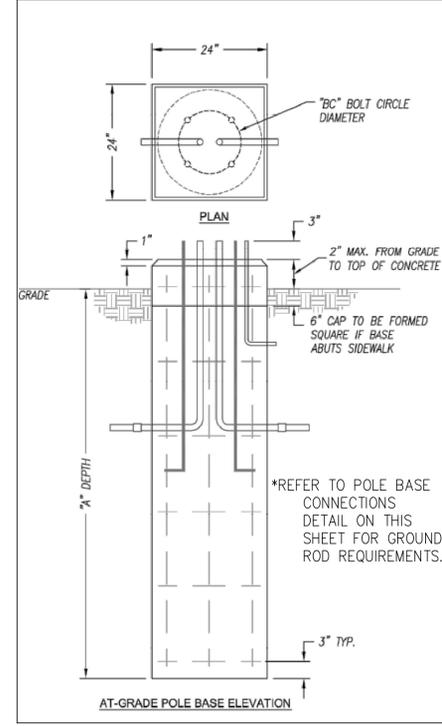

METER PEDESTAL DETAIL - PROVIDE WITH PHOTOCELL LOCATED ON METER PEDESTAL WITH SHIELD AND/OR TIME DELAY FUNCTION.

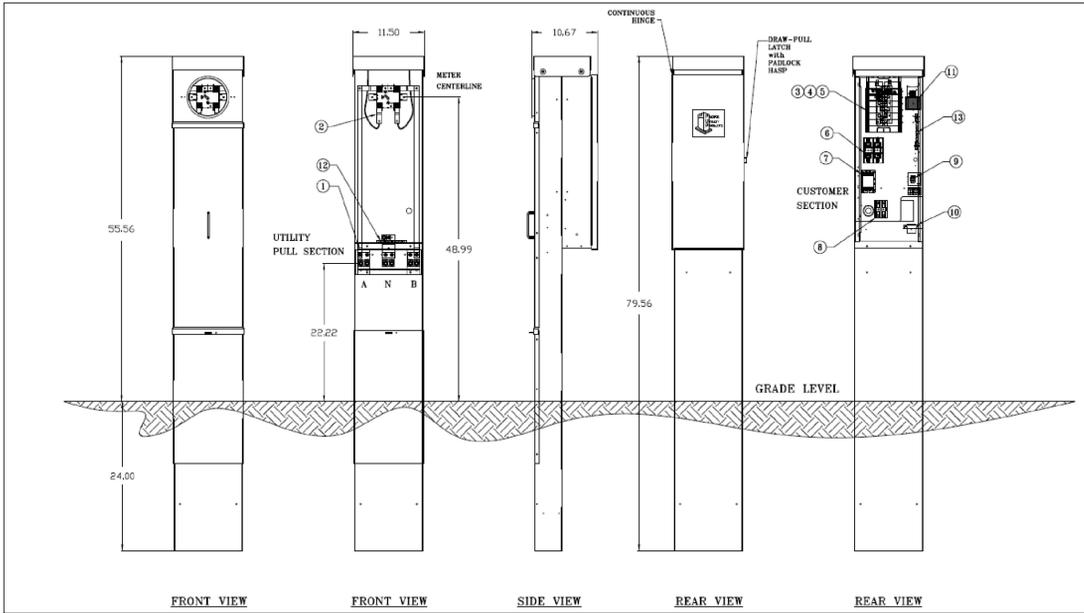

POWER PEDESTAL FOUNDATION DETAIL

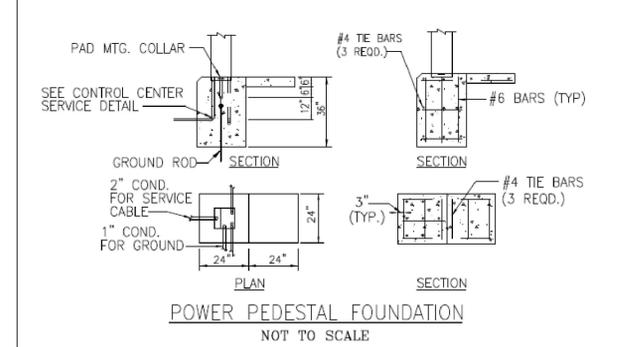

- 1) PROVIDE GROUND ROD(S) AS REQUIRED FOR MAXIMUM OF 25 OHMS RESISTANCE TO GROUND. EXOTHERMIC WELD ONE END OF NO. 6 AWG GROUND CONDUCTOR TO THE GROUND ROD(S) AND BRUSH ON 2 COATS OF AN INSULATING VARNISH TO THE WELDED AREAS.
- 2) CONCRETE SLAB TO PROVIDE SEMI-DRY WORKING AREA IN FRONT OF CONTROLLER CABINET.
- 3) SECONDARY POWER SERVICE (DIRECT BURY) THRU CONTRACTOR INSTALLED 2" CONDUIT AND ELBOW.

Architect:
 MIDWEST ARCHITECTS
 1120 NW EAGLE RIDGE BLVD
 GRAIN VALLEY, MO 64029
 t: (816) 229-8115

Client:
 Ward Development
 1120 NW Eagle Ridge Blvd.
 Grain Valley, Missouri 64029
 t: (816) 229-8115

Consultants:
 Civil Engineering:
 Quist Engineering, Inc.
 821 NE Columbus St.
 Lee's Summit, Missouri 64063
 t: (816) 550-5675

Structural Engineering:
 Structura Logica
 18901 E. 299th Street
 Harrisonville, MO 64701
 t: (816) 872-4883

MEP Engineering:
 JSC Engineers
 1925 Central Street, Suite 201
 Kansas City, MO 64108
 t: (816) 272-5289

MO COA NO. 2012006786 / KS COA NO. E-2818
 1925 CENTRAL STREET, SUITE 201
 KANSAS CITY, MO 64108
 phone: (816) 272-5289
 email: jsmothers@jscengineers.com


Revisions to technical submissions which are not made or approved by the licensee are prohibited.

Seal:

Project Number: 22-215
 Project Type: NEW CONSTRUCTION
 Project Name and Address:
I-470 B&T CENTER, LOT 7
 2701 NE McBaine Drive
 Lee's Summit, Missouri 64064

Issue: _____ Date: _____
 Plan Review _____ 09.30.22
 Plan Review Revisions _____ 11.17.22
 Plan Review Revisions _____ 01.02.23
 Owner Comments _____ 01.17.23
 Owner Comments _____ 02.14.23

Sheet Title:
 PHOTOMETRIC PLAN
E-003

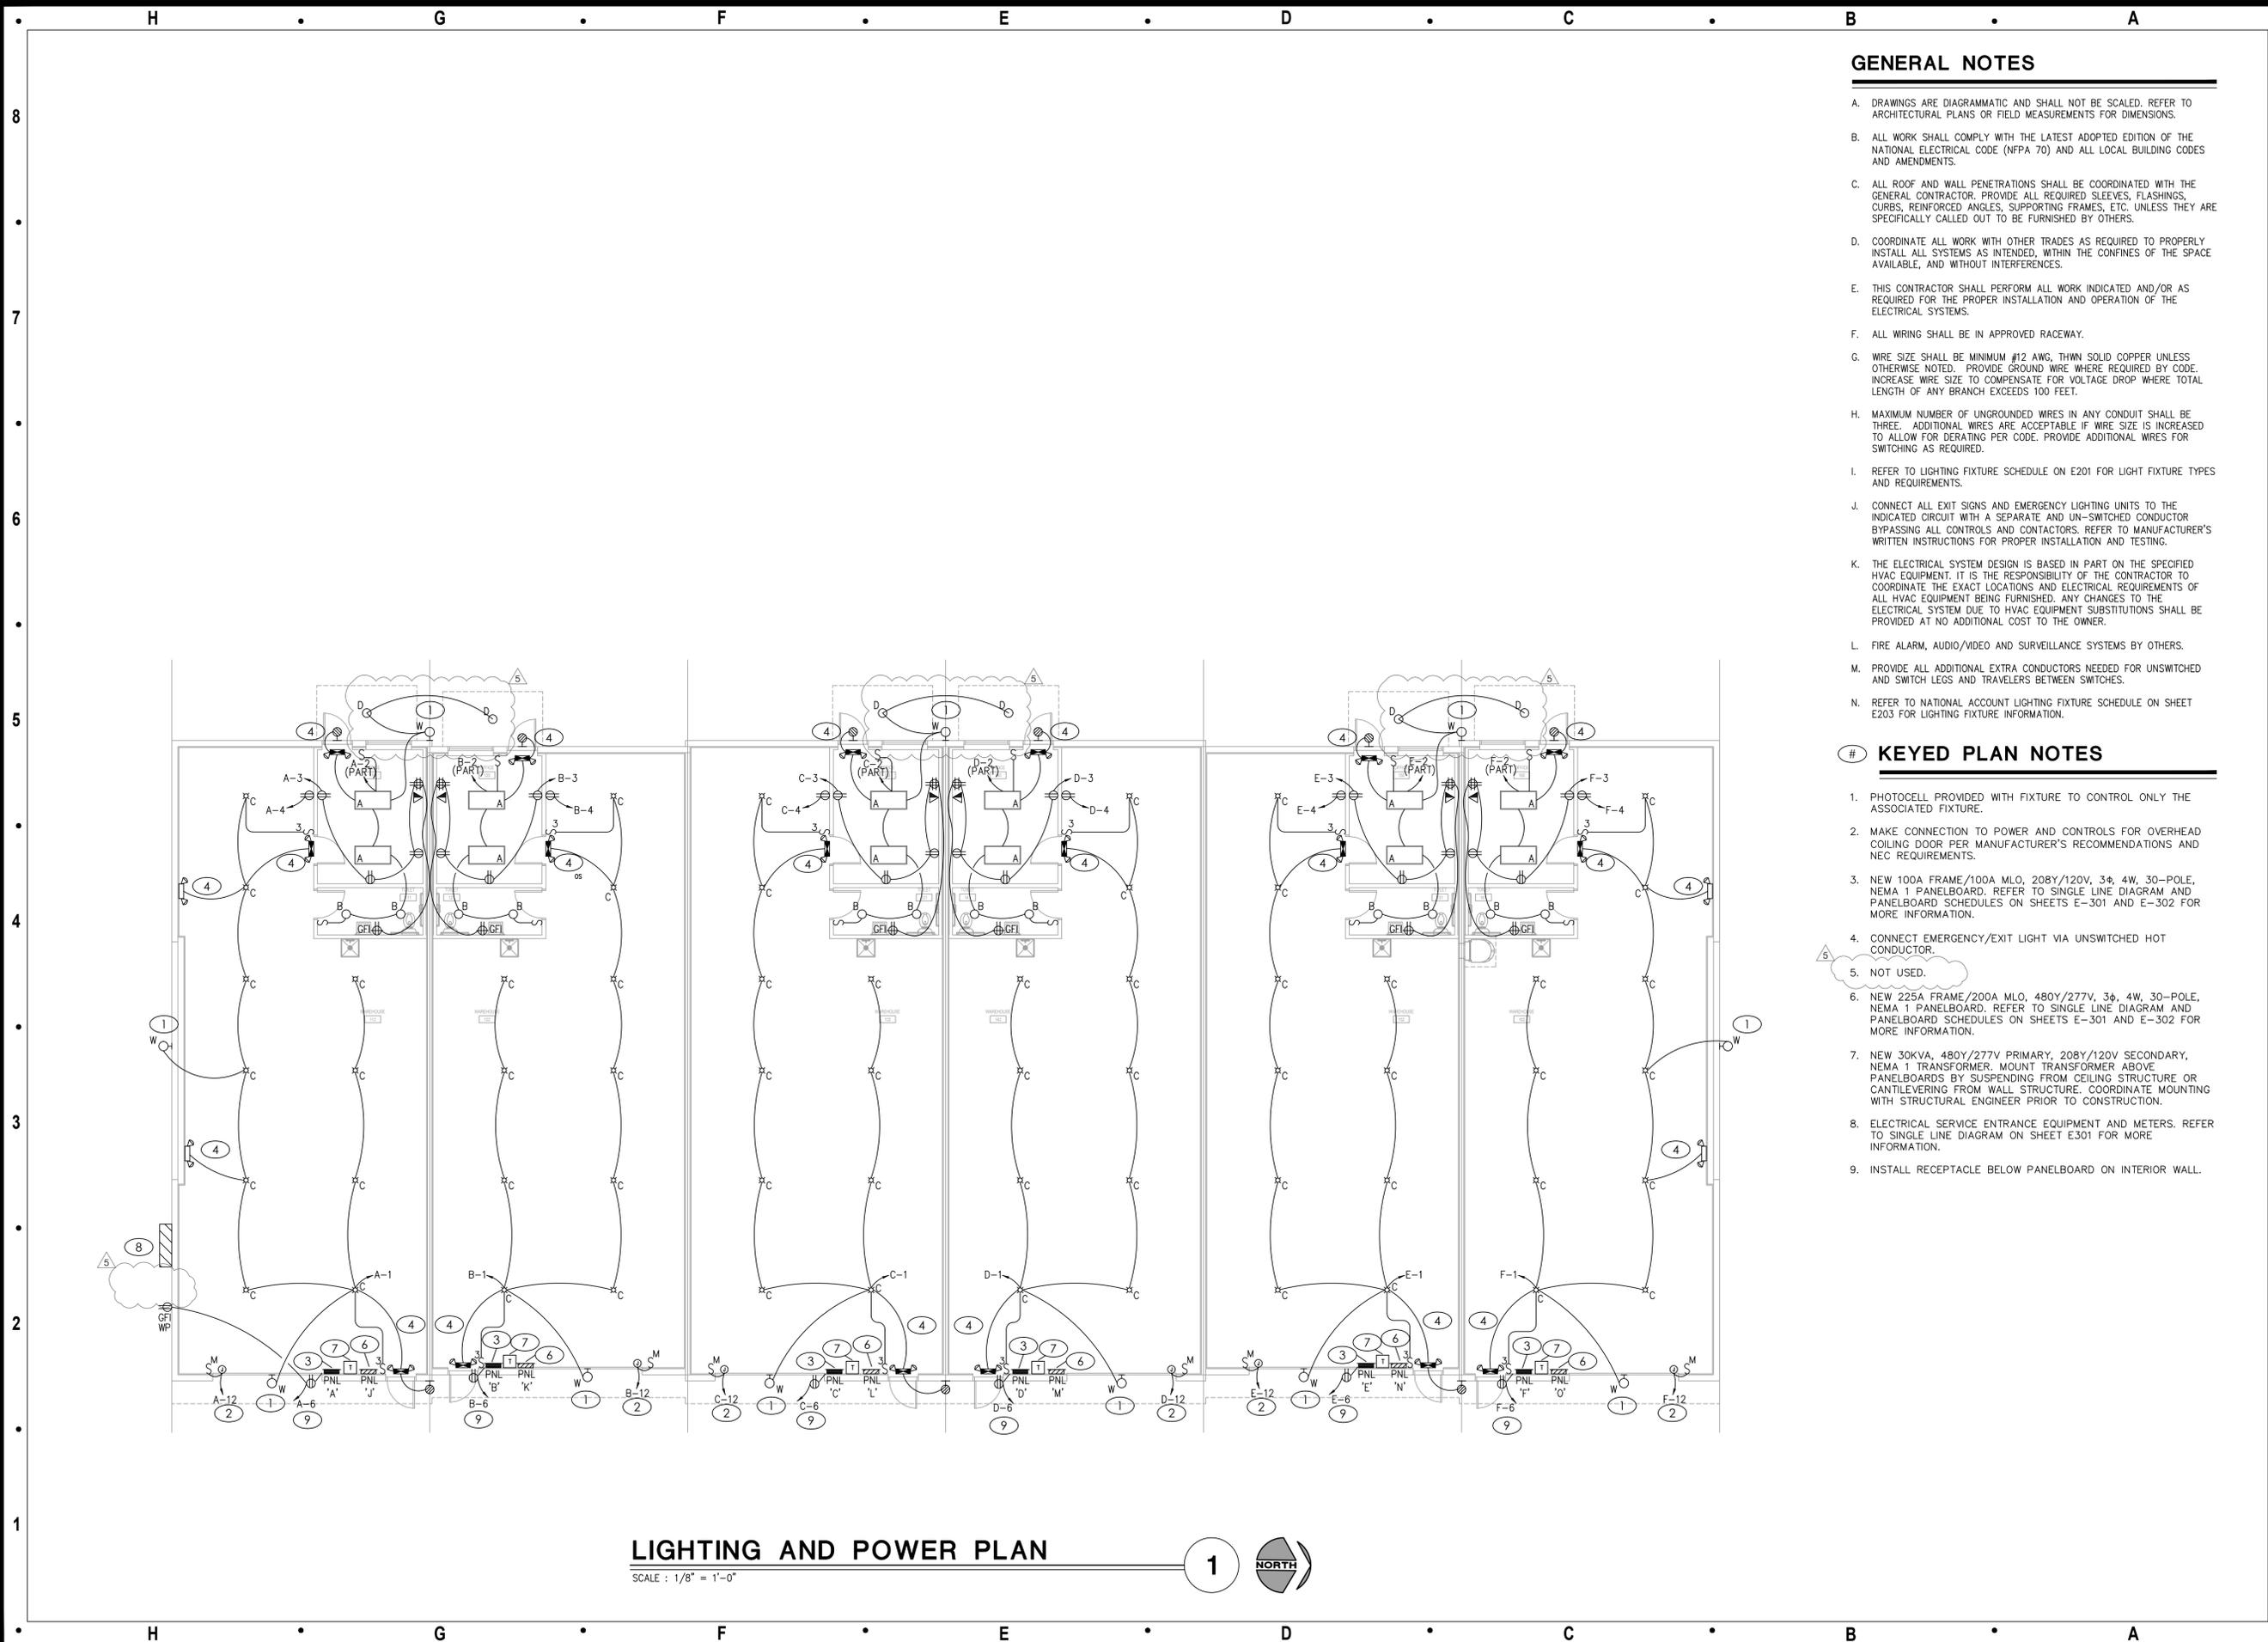

LIGHTING AND POWER PLAN

SCALE : 1/8" = 1'-0"



GENERAL NOTES

- A. DRAWINGS ARE DIAGRAMMATIC AND SHALL NOT BE SCALED. REFER TO ARCHITECTURAL PLANS OR FIELD MEASUREMENTS FOR DIMENSIONS.
- B. ALL WORK SHALL COMPLY WITH THE LATEST ADOPTED EDITION OF THE NATIONAL ELECTRICAL CODE (NFPA 70) AND ALL LOCAL BUILDING CODES AND AMENDMENTS.
- C. ALL ROOF AND WALL PENETRATIONS SHALL BE COORDINATED WITH THE GENERAL CONTRACTOR. PROVIDE ALL REQUIRED SLEEVES, FLASHINGS, CURBS, REINFORCED ANGLES, SUPPORTING FRAMES, ETC. UNLESS THEY ARE SPECIFICALLY CALLED OUT TO BE FURNISHED BY OTHERS.
- D. COORDINATE ALL WORK WITH OTHER TRADES AS REQUIRED TO PROPERLY INSTALL ALL SYSTEMS AS INTENDED, WITHIN THE CONFINES OF THE SPACE AVAILABLE, AND WITHOUT INTERFERENCES.
- E. THIS CONTRACTOR SHALL PERFORM ALL WORK INDICATED AND/OR AS REQUIRED FOR THE PROPER INSTALLATION AND OPERATION OF THE ELECTRICAL SYSTEMS.
- F. ALL WIRING SHALL BE IN APPROVED RACEWAY.
- G. WIRE SIZE SHALL BE MINIMUM #12 AWG, THWN SOLID COPPER UNLESS OTHERWISE NOTED. PROVIDE GROUND WIRE WHERE REQUIRED BY CODE. INCREASE WIRE SIZE TO COMPENSATE FOR VOLTAGE DROP WHERE TOTAL LENGTH OF ANY BRANCH EXCEEDS 100 FEET.
- H. MAXIMUM NUMBER OF UNGROUNDED WIRES IN ANY CONDUIT SHALL BE THREE. ADDITIONAL WIRES ARE ACCEPTABLE IF WIRE SIZE IS INCREASED TO ALLOW FOR DERATING PER CODE. PROVIDE ADDITIONAL WIRES FOR SWITCHING AS REQUIRED.
- I. REFER TO LIGHTING FIXTURE SCHEDULE ON E201 FOR LIGHT FIXTURE TYPES AND REQUIREMENTS.
- J. CONNECT ALL EXIT SIGNS AND EMERGENCY LIGHTING UNITS TO THE INDICATED CIRCUIT WITH A SEPARATE AND UN-SWITCHED CONDUCTOR BYPASSING ALL CONTROLS AND CONTACTORS. REFER TO MANUFACTURER'S WRITTEN INSTRUCTIONS FOR PROPER INSTALLATION AND TESTING.
- K. THE ELECTRICAL SYSTEM DESIGN IS BASED IN PART ON THE SPECIFIED HVAC EQUIPMENT. IT IS THE RESPONSIBILITY OF THE CONTRACTOR TO COORDINATE THE EXACT LOCATIONS AND ELECTRICAL REQUIREMENTS OF ALL HVAC EQUIPMENT BEING FURNISHED. ANY CHANGES TO THE ELECTRICAL SYSTEM DUE TO HVAC EQUIPMENT SUBSTITUTIONS SHALL BE PROVIDED AT NO ADDITIONAL COST TO THE OWNER.
- L. FIRE ALARM, AUDIO/VIDEO AND SURVEILLANCE SYSTEMS BY OTHERS.
- M. PROVIDE ALL ADDITIONAL EXTRA CONDUCTORS NEEDED FOR UNSWITCHED AND SWITCH LEGS AND TRAVELERS BETWEEN SWITCHES.
- N. REFER TO NATIONAL ACCOUNT LIGHTING FIXTURE SCHEDULE ON SHEET E203 FOR LIGHTING FIXTURE INFORMATION.

KEYED PLAN NOTES

- 1. PHOTOCELL PROVIDED WITH FIXTURE TO CONTROL ONLY THE ASSOCIATED FIXTURE.
- 2. MAKE CONNECTION TO POWER AND CONTROLS FOR OVERHEAD COILING DOOR PER MANUFACTURER'S RECOMMENDATIONS AND NEC REQUIREMENTS.
- 3. NEW 100A FRAME/100A MLO, 208Y/120V, 3φ, 4W, 30-POLE, NEMA 1 PANELBOARD. REFER TO SINGLE LINE DIAGRAM AND PANELBOARD SCHEDULES ON SHEETS E-301 AND E-302 FOR MORE INFORMATION.
- 4. CONNECT EMERGENCY/EXIT LIGHT VIA UNSWITCHED HOT CONDUCTOR.
- 5. NOT USED.
- 6. NEW 225A FRAME/200A MLO, 480Y/277V, 3φ, 4W, 30-POLE, NEMA 1 PANELBOARD. REFER TO SINGLE LINE DIAGRAM AND PANELBOARD SCHEDULES ON SHEETS E-301 AND E-302 FOR MORE INFORMATION.
- 7. NEW 30KVA, 480Y/277V PRIMARY, 208Y/120V SECONDARY, NEMA 1 TRANSFORMER. MOUNT TRANSFORMER ABOVE PANELBOARDS BY SUSPENDING FROM CEILING STRUCTURE OR CANTILEVERING FROM WALL STRUCTURE. COORDINATE MOUNTING WITH STRUCTURAL ENGINEER PRIOR TO CONSTRUCTION.
- 8. ELECTRICAL SERVICE ENTRANCE EQUIPMENT AND METERS. REFER TO SINGLE LINE DIAGRAM ON SHEET E301 FOR MORE INFORMATION.
- 9. INSTALL RECEPTACLE BELOW PANELBOARD ON INTERIOR WALL.

Architect:

MIDWEST ARCHITECTS
1120 NW EAGLE RIDGE BLVD
GRAIN VALLEY, MO 64029
t: (816) 229-8115

Client:

Ward Development
1120 NW Eagle Ridge Blvd.
Grain Valley, Missouri 64029
t: (816) 229-8115

Consultants:

Civil Engineering:
Quist Engineering, Inc.
821 NE Columbus St.
Lee's Summit, Missouri 64063
t: (816) 550-5675

Structural Engineering:
Structura Logica
18901 E. 299th Street
Harrisonville, MO 64701
t: (816) 872-4883

MEP Engineering:
JSC Engineers
1925 Central Street, Suite 201
Kansas City, MO 64108
t: (816) 272-5289

MO COA NO. 2012006786 / KS COA NO. E-2818
1925 CENTRAL STREET, SUITE 201
KANSAS CITY, MO 64108
phone: (816) 272-5289
email: jsmothers@jscengineers.com

Revisions to technical submissions which are not made or approved by the licensee are prohibited.

Seal:


Project Number: 22-215
Project Type: NEW CONSTRUCTION
Project Name and Address:

I-470 B&T CENTER, LOT 7
2701 NE McBaine Drive
Lee's Summit, Missouri 64064

Issue:	Date:
Plan Review	09.30.22
Plan Review Revisions	11.17.22
Plan Review Revisions	01.02.23
Owner Comments	01.17.23
Owner Comments	02.14.23

Sheet Title:

ELECTRICAL PLAN
E-101

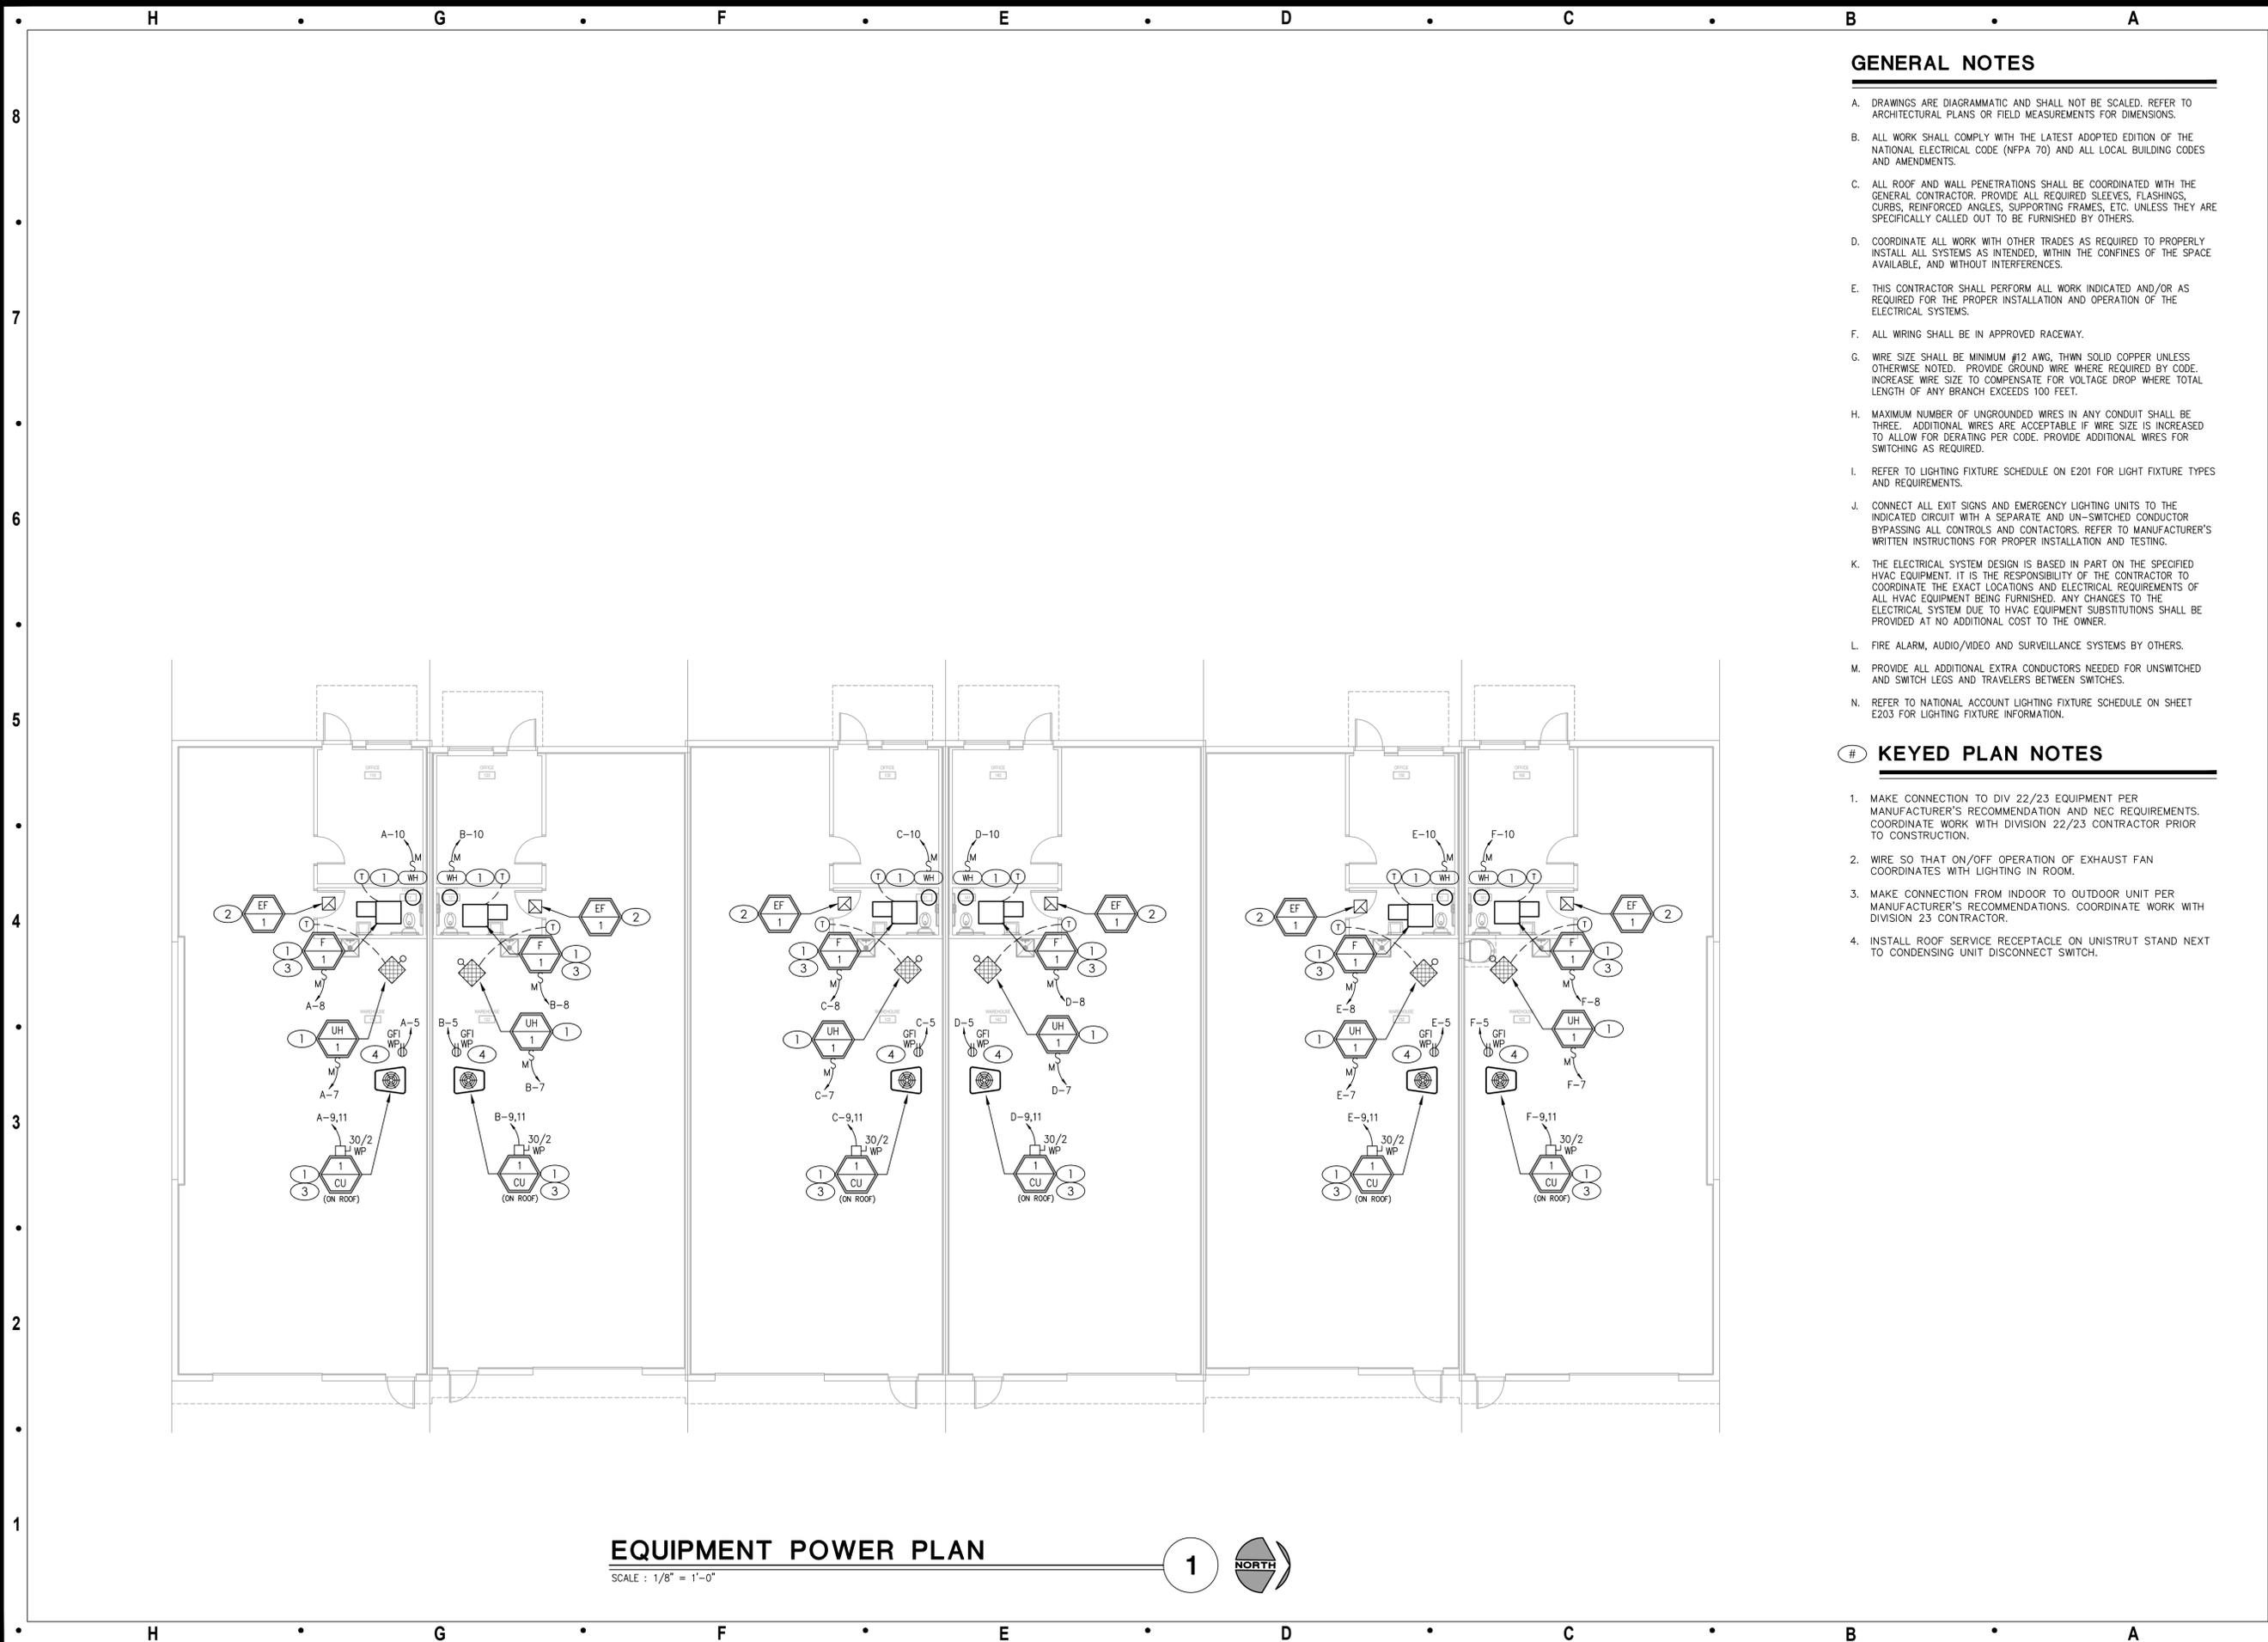

CONCRETE ENCASED ELECTRODE IN NEW CONCRETE FLOOR LOCATED WITHIN AND NEAR THE BOTTOM OF A CONCRETE FOUNDATION OR FOOTING THAT IS IN DIRECT CONTACT WITH THE EARTH

GROUNDING ELECTRODE SYSTEM DIAGRAM

SCALE : NO SCALE

2

Short-Circuit and Voltage Drop Calculations

Distances are for calculation purposes only and shall not be used for contractor takeoffs or bidding. Contractor shall notify Engineer of any field condition that results in a change of 10% or greater circuit distance.

The following calculations are based on the "Pottier-Hart" method where:

$ISC_{1\phi} = I_{SC} \times M \times 1.732 \times L \times I_{sc}$
 $ISC_{3\phi} = \text{short circuit current at fault point 1}$
 $ISC_{2\phi} = \text{short circuit current at fault point 2}$

$I_{sc} = \frac{V_p}{Z_{sc}}$
 $Z_{sc} = \sqrt{R^2 + X^2}$

$V_p = \text{Primary voltage}$
 $I_{sc} = \text{Secondary short circuit current}$
 $V_s = \text{Secondary voltage}$
 $L = \text{Length of circuit}$
 $C = \text{"C" factor from Busman table where "C" = 1 / impedance per linear foot}$

Feeder Types: * Non-Magnetic Conduit, M - Magnetic Conduit, FB - Feeder Busway, PB - Plug-in Busway, TX - Transformer

System Voltage: 480V/277V - 3 phase

Fault Point (FP)	Bus/Feeder Description	Source (Fault Point)	Phase	Source Impedance (Z)	Conduit Type	Material	Feeder Quantity/Parallel Sets and Bus Size	Conductor Size (AWG)	Busway Voltage (V)	Busway Length (L)	Circuit Voltage (V)	Load Power (kW)	Circuit Load (Amps)	Resistance (R)	Conductor Resistance (R)	Access (ft)	Type	Degree Rise	Transformer kVA	Primary/Secondary Voltage	Tap Setting	I	M	Fault Current (amp)	Voltage Drop (V)	Cumulative Voltage Drop (V)	Fault Point		
1	Utility Service Point	69100	NM	AL	1	250kcmil	12122	480	10	0.9	160	0.000096	0.000041	0.451027	1.028	0.35	23040	-0.54%	-0.54%	2			0.969	0.34	23560	-0.06%	0.59%	3	
2	TO SERVICE DISCONNECT	21562	M	AL	1	250kcmil	12122	480	10	0.9	160	0.000096	0.000052	0.451027	0.449	0.88	14877	-0.49%	-1.01%	4			0.578	0.63	13667	-0.52%	-1.12%	5	
3	TO FAN BD W	21562	M	AL	1	250kcmil	12122	480	10	0.9	160	0.000096	0.000052	0.451027	0.534	0.55	11754	-0.76%	-1.35%	6			0.983	0.51	10685	-0.87%	-1.47%	7	
4	TO FAN BD W	21562	M	AL	1	250kcmil	12122	480	10	0.9	160	0.000096	0.000052	0.451027	1.182	0.46	9952	-1.07%	-1.67%	8			1.284	0.44	9442	-1.18%	-1.78%	9	
5	TO FAN BD W	21562	M	AL	1	250kcmil	12122	480	10	0.9	160	0.000096	0.000052	0.451027	0.442	0.89	10372	-0.14%	-1.14%	11			0.467	0.71	9715	-0.14%	-1.28%	12	
6	TO FAN BD W	21562	M	AL	1	250kcmil	12122	480	10	0.9	160	0.000096	0.000052	0.451027	0.350	0.74	8708	-0.14%	-1.48%	13			0.327	0.76	8219	-0.14%	-1.60%	14	
7	TO FAN BD W	21562	M	AL	1	250kcmil	12122	480	10	0.9	160	0.000096	0.000052	0.451027	0.283	0.77	7621	-0.14%	-1.81%	15			0.281	0.78	7371	-0.14%	-1.89%	16	
8	TO FAN BD W	21562	M	AL	1	250kcmil	12122	480	10	0.9	160	0.000096	0.000052	0.451027	0.154	0.91	2703	-0.33%	-1.48%	17			0.103	0.91	2655	-0.33%	-1.59%	18	
9	TO FAN BD W	21562	M	AL	1	250kcmil	12122	480	10	0.9	160	0.000096	0.000052	0.451027	0.102	0.91	2448	-0.33%	-1.62%	19			0.101	0.91	2630	-0.33%	-1.64%	20	
10	TO FAN BD W	21562	M	AL	1	250kcmil	12122	480	10	0.9	160	0.000096	0.000052	0.451027	0.100	0.91	2599	-0.33%	-1.14%	21			0.098	0.91	2588	-0.33%	-1.23%	22	
11	TO FAN BD W	21562	M	AL	1	250kcmil	12122	480	10	0.9	160	0.000096	0.000052	0.451027	6.973	0.13	2885	-1.14%	-1.14%	23			6.969	0.13	2862	-1.06%	-1.24%	24	
12	TO FAN BD W	21562	M	AL	1	250kcmil	12122	480	10	0.9	160	0.000096	0.000052	0.451027	5.988	0.15	2917	-1.49%	-1.49%	25			5.988	0.15	2908	-1.60%	-1.60%	26	
13	TO FAN BD W	21562	M	AL	1	250kcmil	12122	480	10	0.9	160	0.000096	0.000052	0.451027	5.143	0.16	2955	-1.61%	-1.61%	27			5.143	0.16	2955	-1.61%	-1.61%	28	
14	TO FAN BD W	21562	M	AL	1	250kcmil	12122	480	10	0.9	160	0.000096	0.000052	0.451027	4.884	0.17	2843	-1.89%	-1.89%	29									

SC / VD CALCULATIONS


SCALE : NO SCALE

3

FEEDER NUMBER	CONDUIT AND CONDUCTOR SIZES
1	(1) 2-1/2" W / 4 #250KCM AL
2	(1) 2-1/2" W / 4 #250KCM AL & #4 AL GND
3	REMOVED FROM PROJECT
4	(1) 1" W / 4 #6 CU & #10 CU GND
5	(1) 1-1/4" W / 4 #3 CU & #8 CU GND

THE DESIGN PROFESSIONAL HAS PERFORMED ALL THE REQUIRED VOLTAGE DROP CALCULATIONS FOR ALL BRANCH CIRCUITS AND FEEDERS PER THE NATIONAL ELECTRICAL CODE, ARTICLE 210.19(A)(1) FPN NO. 4.

THE DESIGN PROFESSIONAL HAS PERFORMED ALL THE REQUIRED SHORT CIRCUIT CALCULATIONS AND THE AIC RATING INDICATED FOR EACH DEVICE IS ADEQUATE TO PROTECT THE EQUIPMENT AND THE ELECTRICAL SYSTEM.

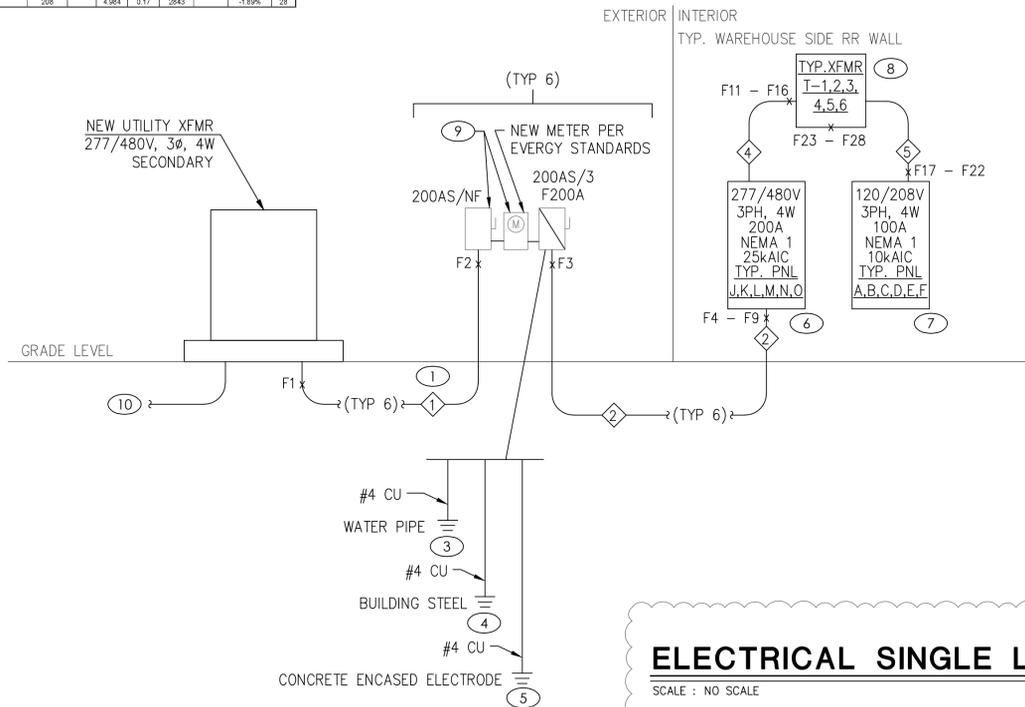

ELECTRICAL SINGLE LINE DIAGRAM

SCALE : NO SCALE

1

ELECTRICAL LIGHTING SCHEDULE

(OR EQUAL. VERIFY ALL SELECTIONS AND FINISHES WITH OWNER AND ARCHITECT PRIOR TO ORDERING).

FIXTURE TYPE	MANUFACTURER		VOLT AMPS	MOUNTING	LAMP TYPE	REMARKS	VOLT
	NAME	SERIES					
A	LITHONIA	EPANL	31	RECESSED/GRID	INCLUDED 4000K LED	LED 2'X4' FLAT PANEL - 4000LM OUTPUT HIGH EFFICIENCY	MVOLT
B	LITHONIA	WF6	14	RECESSED	INCLUDED 2700K LED	WAFFER-STYLE 6" LED DOWNLIGHT	MVOLT
C	LSI	RHB-LED-18L-UNV-DIM-40-BLK	147	SUSPENDED	INCLUDED 4000K LED	COMPACT HIGH-BAY LED WAREHOUSE FIXTURE - 18000 LUMEN OUTPUT	MVOLT
D	JUNO	J5F-7IN-10LM-40K-90CRI-MVOLT ZT-WH	13	SURFACE	INCLUDED 4000K LED	SUMFORM SURFACE MOUNT 7" LED DOWNLIGHT	MVOLT
W	LITHONIA	WDGE3	59	WALL	INCLUDED 4000K LED	EXTERIOR WALL PACK - P2 PACKAGE - PROVIDE WITH 'PE' PHOTOCCELL OPTION	MVOLT
L	LITHONIA	ELM2L-SDRT	5	SURFACE	INCLUDED LED	EMERGENCY EGRESS LIGHTING UNIT WITH 90 MIN. BATTERY PACK	120
E	LITHONIA	LHQM-LED-R-SD	5	SURFACE	INCLUDED LED	EMERGENCY EXIT EGRESS COMBO LIGHTING UNIT WITH RED FACE EXIT SIGN AND 90 MIN. BATTERY PACK	120
H	LITHONIA	ELA-B-T-QWP-L0309-SD	5	SURFACE	INCLUDED LED	OUTDOOR EMERGENCY REMOTE EGRESS LIGHTING UNIT	120

Architect:

MIDWEST ARCHITECTS
1120 NW EAGLE RIDGE BLVD
GRAIN VALLEY, MO 64029
t: (816) 229-8115

Client:

Ward Development
1120 NW Eagle Ridge Blvd.
Grain Valley, Missouri 64029
t: (816) 229-8115

Consultants:

Civil Engineering:
Cui Engineering, Inc.
821 NE Columbus St.
Lee's Summit, Missouri 64063
t: (816) 550-5675

Structural Engineering:

Structura Logica
18901 E. 299th Street
Harrisonville, MO 64701
t: (816) 872-4883

MEP Engineering:

JSC Engineers
1925 Central Street, Suite 201
Kansas City, MO 64108
t: (816) 272-5289

MO COA NO. 2012006786 / KS COA NO. E-2818

1925 CENTRAL STREET, SUITE 201

KANSAS CITY, MO 64108

phone: (816) 272-5289

email: jsmothers@jscengineers.com

Revisions to technical submissions which are not made or approved by the licensee are prohibited.

Seal:



KEYED SLD NOTES

- PROVIDE NEW CONDUIT AND CONDUCTORS TO UTILITY SOURCE. VERIFY EXACT LOCATION AND REQUIREMENTS WITH UTILITY PRIOR TO ROUGH-IN.
- REMOVED FROM PROJECT.
- PROVIDE NEW GROUND PER NEC 250.52(A)(1).
- PROVIDE NEW GROUND PER NEC 250.52(A)(2).
- PROVIDE NEW GROUND PER NEC 250.52(A)(3).
- NEW 120/208V PANELBOARD. SEE PANELBOARD SCHEDULES ON SHEET E-302 FOR MORE INFORMATION.
- NEW 277/480V PANELBOARD. SEE PANELBOARD SCHEDULES ON SHEET E-302 FOR MORE INFORMATION.
- NEW 277/480V PRIMARY, 208/120V SECONDARY, 30KVA, NEMA 1 RATED TRANSFORMER.
- MOUNT ON FREE-STANDING UNI-STRUT RACK. COORDINATE EXACT LOCATION WITH UTILITY PRIOR TO ROUGH-IN.
- ROUTE (1) 4" CONDUIT UNDERGROUND FOR PRIMARY CONDUCTOR ROUTING BY UTILITY. COORDINATE EXACT ROUTING WITH UTILITY PRIOR TO CONSTRUCTION.

Project Number: 22-215

Project Type: NEW CONSTRUCTION

Project Name and Address:

I-470 B&T CENTER, LOT 7

2701 NE McBaine Drive
Lee's Summit, Missouri 64064

Issue: Date:

Plan Review 09.30.22

Plan Review Revisions 11.17.22

Plan Review Revisions 3 01.02.23


Owner Comments 01.17.23

Owner Comments 02.14.23

Sheet Title:

ELECTRICAL SCHEDULES AND DIAGRAMS

E-301

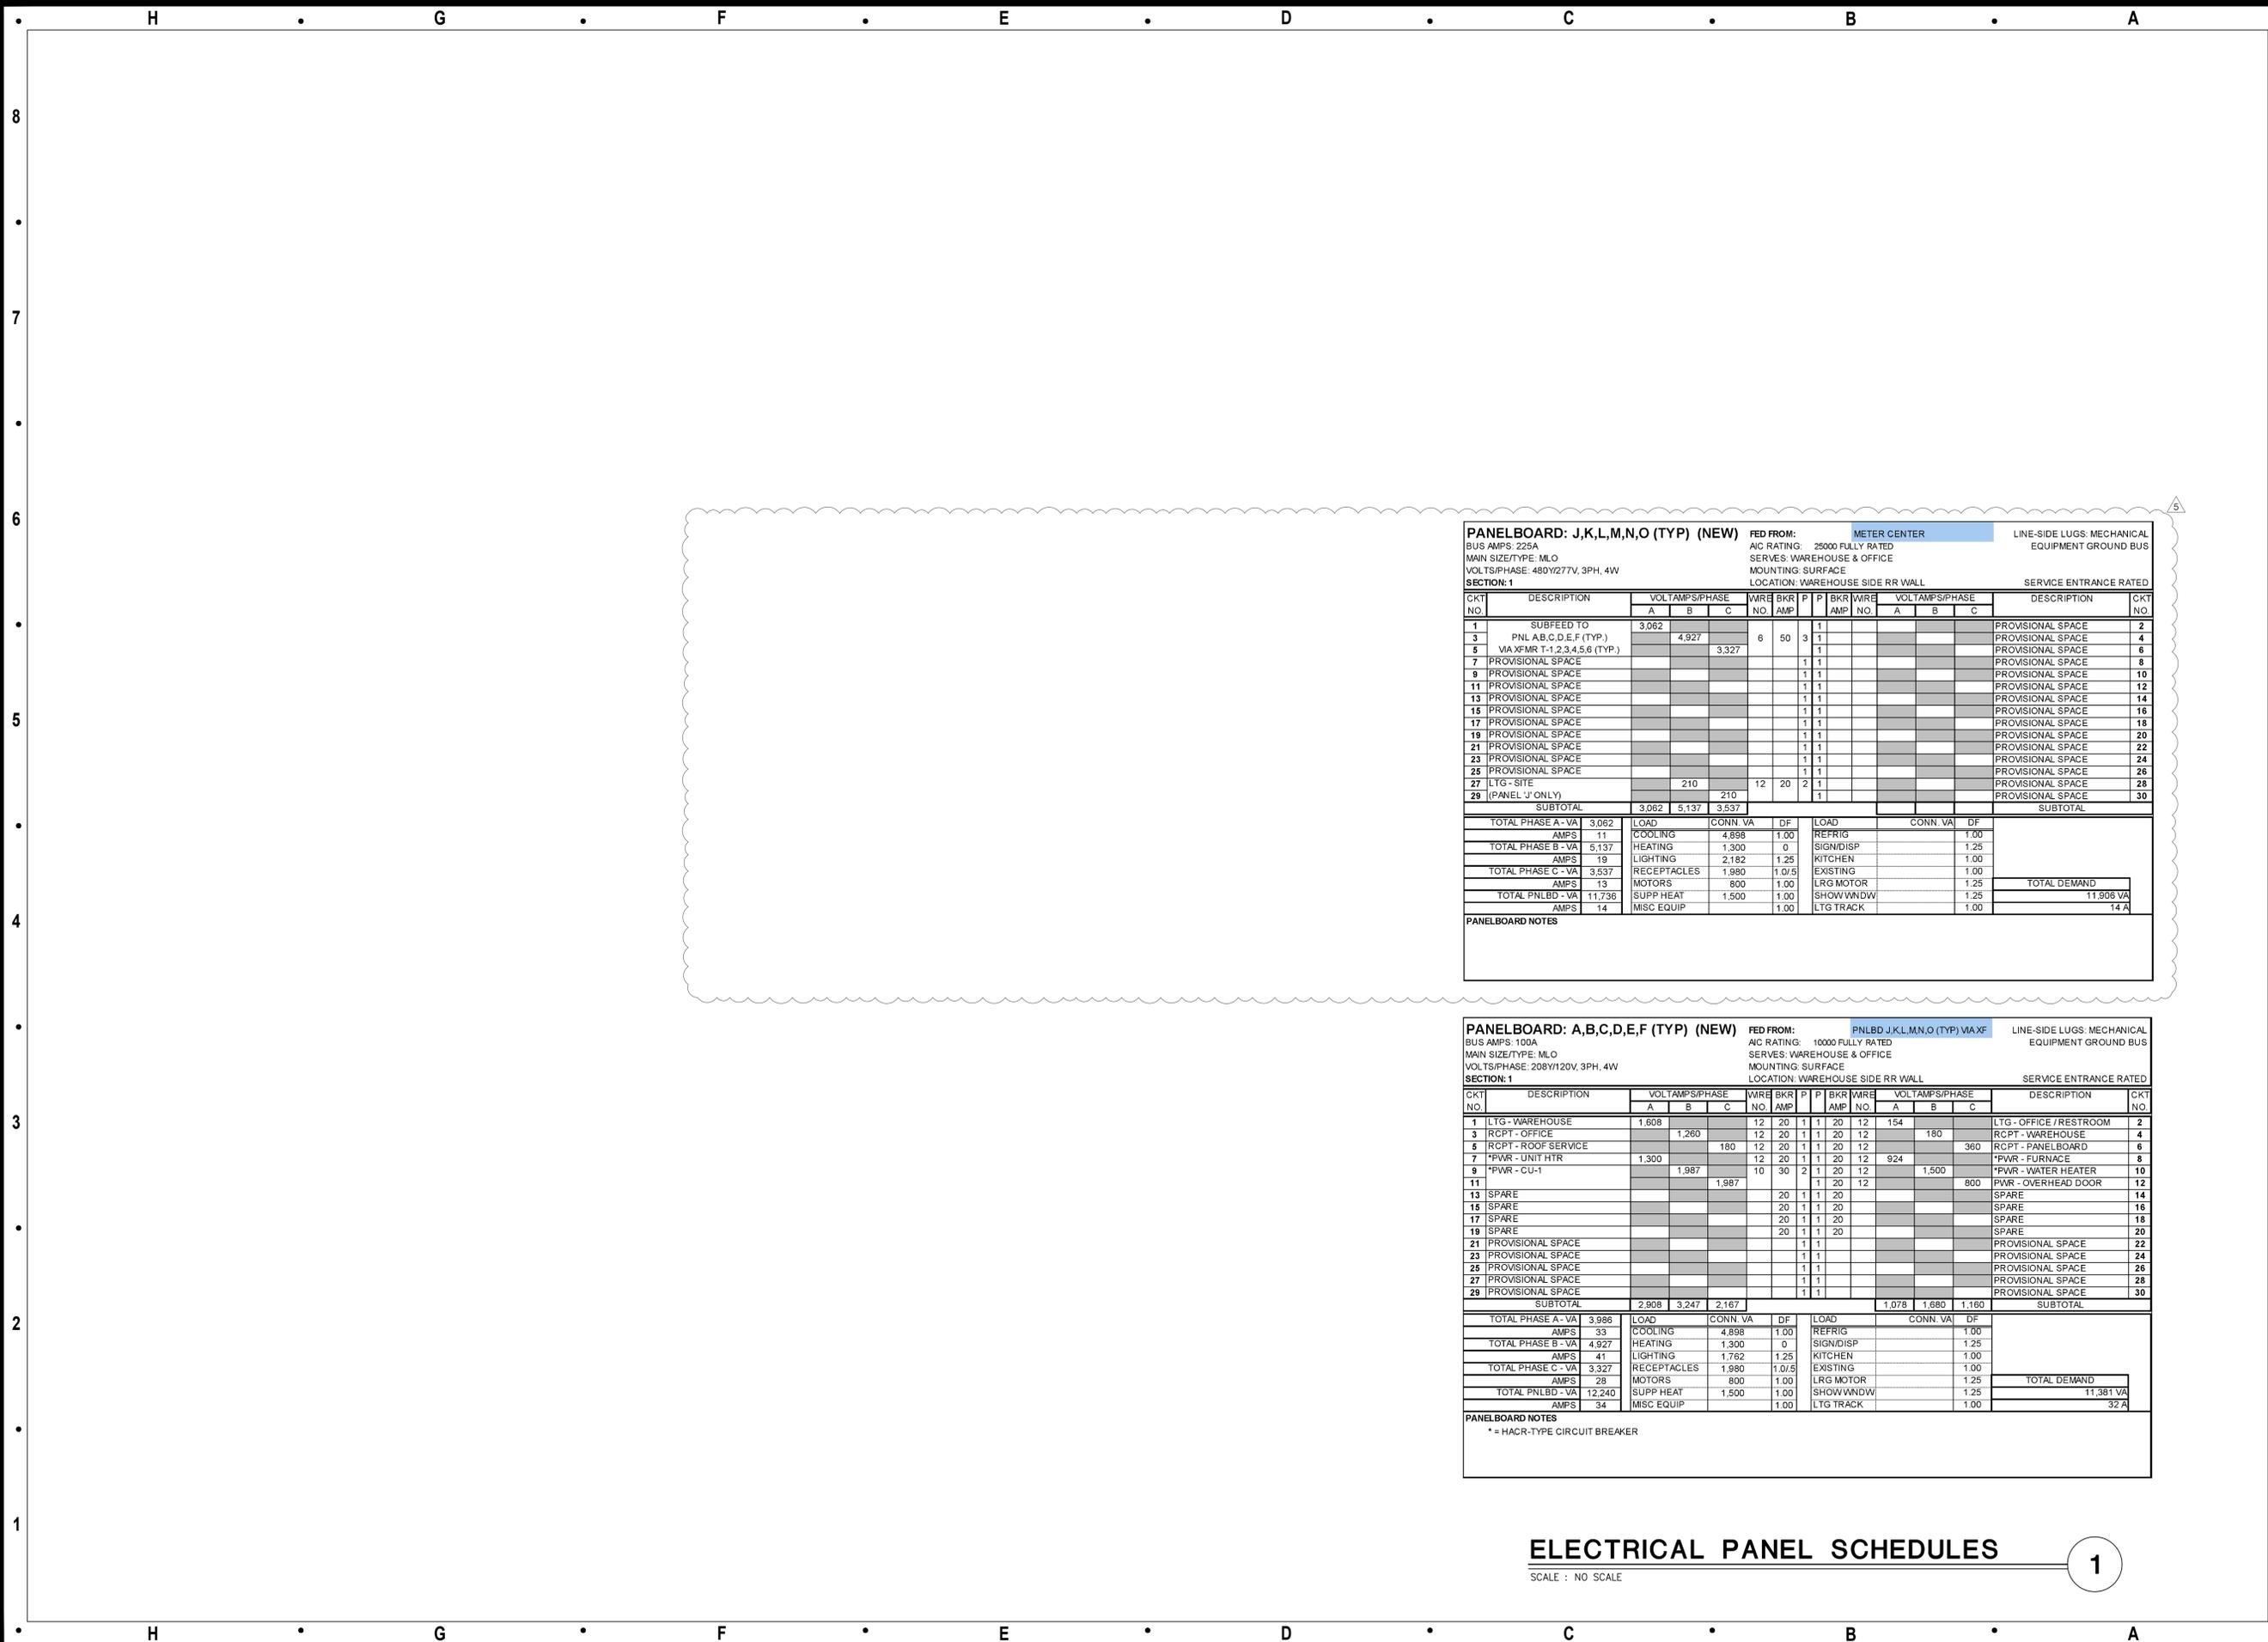

PANELBOARD: J,K,L,M,N,O (TYP) (NEW) FED FROM: METER CENTER LINE-SIDE LUGS: MECHANICAL
 BUS AMPS: 225A AIC RATING: 25000 FULLY RATED EQUIPMENT GROUND BUS
 MAIN SIZE/TYP: MLO SERVES: WAREHOUSE & OFFICE
 VOLTS/PHASE: 480Y/277V, 3PH, 4W MOUNTING: SURFACE
 LOCATION: WAREHOUSE SIDE RR WALL SERVICE ENTRANCE RATED

SECTION: 1

CKT NO.	DESCRIPTION	VOLTAMPS/PHASE			WIRE NO.	BKR AMP	P	BKR AMP	WIRE NO.	VOLTAMPS/PHASE			DESCRIPTION	CKT NO.
		A	B	C						A	B	C		
1	SUBFEED TO	3,062										PROVISIONAL SPACE	2	
3	PNL A,B,C,D,E,F (TYP.)		4,927		6	50	3	1				PROVISIONAL SPACE	4	
5	VA XFMR T-1,2,3,4,5,6 (TYP.)			3,327								PROVISIONAL SPACE	6	
7	PROVISIONAL SPACE											PROVISIONAL SPACE	8	
9	PROVISIONAL SPACE											PROVISIONAL SPACE	10	
11	PROVISIONAL SPACE											PROVISIONAL SPACE	12	
13	PROVISIONAL SPACE											PROVISIONAL SPACE	14	
15	PROVISIONAL SPACE											PROVISIONAL SPACE	16	
17	PROVISIONAL SPACE											PROVISIONAL SPACE	18	
19	PROVISIONAL SPACE											PROVISIONAL SPACE	20	
21	PROVISIONAL SPACE											PROVISIONAL SPACE	22	
23	PROVISIONAL SPACE											PROVISIONAL SPACE	24	
25	PROVISIONAL SPACE											PROVISIONAL SPACE	26	
27	LTG - SITE			210	12	20	2	1				PROVISIONAL SPACE	28	
29	[PANEL 'J' ONLY]			210				1				PROVISIONAL SPACE	30	
SUBTOTAL		3,062	5,137	3,537										
TOTAL PHASE A - VA		3,062												
AMPS		11												
TOTAL PHASE B - VA			4,927											
AMPS			19											
TOTAL PHASE C - VA				3,537										
AMPS				13										
TOTAL PNLBD - VA				11,736										
AMPS				14										
LOAD														
CONN VA														
DF														
LOAD														
CONN VA														
DF														
TOTAL DEMAND												11,906 VA		
												14 A		

PANELBOARD NOTES

PANELBOARD: A,B,C,D,E,F (TYP) (NEW) FED FROM: PNLBD J,K,L,M,N,O (TYP) VIA XF LINE-SIDE LUGS: MECHANICAL
 BUS AMPS: 100A AIC RATING: 10000 FULLY RATED EQUIPMENT GROUND BUS
 MAIN SIZE/TYP: MLO SERVES: WAREHOUSE & OFFICE
 VOLTS/PHASE: 208Y/120V, 3PH, 4W MOUNTING: SURFACE
 LOCATION: WAREHOUSE SIDE RR WALL SERVICE ENTRANCE RATED

SECTION: 1

CKT NO.	DESCRIPTION	VOLTAMPS/PHASE			WIRE NO.	BKR AMP	P	BKR AMP	WIRE NO.	VOLTAMPS/PHASE			DESCRIPTION	CKT NO.
		A	B	C						A	B	C		
1	LTG - WAREHOUSE	1,608			12	20	1	1	20	12	154	LTG - OFFICE / RESTROOM	2	
3	RCPT - OFFICE		1,260		12	20	1	1	20	12	180	RCPT - WAREHOUSE	4	
5	RCPT - ROOF SERVICE			180	12	20	1	1	20	12	360	RCPT - PANELBOARD	6	
7	*PWV - UNIT HTR	1,300			12	20	1	1	20	12	924	*PWV - FURNACE	8	
9	*PWV - CU-1		1,987		10	30	2	1	20	12	1,500	*PWV - WATER HEATER	10	
11									1	20	12	PWR - OVERHEAD DOOR	12	
13	SPARE				20	1	1	1	20			SPARE	14	
15	SPARE				20	1	1	1	20			SPARE	16	
17	SPARE				20	1	1	1	20			SPARE	18	
19	SPARE				20	1	1	1	20			SPARE	20	
21	PROVISIONAL SPACE								1	1		PROVISIONAL SPACE	22	
23	PROVISIONAL SPACE								1	1		PROVISIONAL SPACE	24	
25	PROVISIONAL SPACE								1	1		PROVISIONAL SPACE	26	
27	PROVISIONAL SPACE								1	1		PROVISIONAL SPACE	28	
29	PROVISIONAL SPACE								1	1		PROVISIONAL SPACE	30	
SUBTOTAL		2,908	3,247	2,167							1,078	1,680	1,160	
TOTAL PHASE A - VA		3,988												
AMPS		33												
TOTAL PHASE B - VA			4,927											
AMPS			41											
TOTAL PHASE C - VA				3,327										
AMPS				28										
TOTAL PNLBD - VA				12,240										
AMPS				34										
LOAD														
CONN VA														
DF														
LOAD														
CONN VA														
DF														
TOTAL DEMAND												11,381 VA		
												32 A		

PANELBOARD NOTES
 * = HACR-TYPE CIRCUIT BREAKER

ELECTRICAL PANEL SCHEDULES 1

SCALE : NO SCALE

Architect:
 MIDWEST ARCHITECTS
 1120 NW EAGLE RIDGE BLVD
 GRAIN VALLEY, MO 64029
 t: (816) 229-8115

Client:
 Ward Development
 1120 NW Eagle Ridge Blvd.
 Grain Valley, Missouri 64029
 t: (816) 229-8115

Consultants:
 Civil Engineering:
 Quist Engineering, Inc.
 821 NE Columbus St.
 Lee's Summit, Missouri 64063
 t: (816) 550-5675
 Structural Engineering:
 Structura Logica
 18901 E. 299th Street
 Harrisonville, MO 64701
 t: (816) 872-4883
 MEP Engineering:
 JSC Engineers
 1925 Central Street, Suite 201
 Kansas City, MO 64108
 t: (816) 272-5289

MO COA NO. 2012006786 / KS COA NO. E-2818
 1925 CENTRAL STREET, SUITE 201
 KANSAS CITY, MO 64108
 phone: (816) 272-5289
 email: jsmothers@jscengineers.com

Revisions to technical submissions which are not made or approved by the licensee are prohibited.

Seal:

 JUSTIN R. SMOTHERS
 NUMBER: PE-2012003556
 EXPIRES: 02-14-2023

Project Number: 22-215
 Project Type: NEW CONSTRUCTION
 Project Name and Address:
I-470 B&T CENTER, LOT 7
 2701 NE McBaine Drive
 Lee's Summit, Missouri 64064

Issue: _____ Date: _____
 Plan Review 09.30.22
 Plan Review Revisions 11.17.22
 Plan Review Revisions 3 01.02.23
 Owner Comments 4 01.17.23
 Owner Comments 5 02.14.23

Sheet Title:
 ELECTRICAL SCHEDULES
E-302