

FRONT & REAR ELEVATION NOTES

.12 TOP OF FOOTING DEPTH DETERMINED PER SITE. .71 CONCRETE WINDOW WELL FOR EGRESS WITH LADDER. PROVED SLEEVE THROUGH WALL FOR FOUNDATION

2.61 5/4"X8" TRIM. 1 1/2" ARCH ON GARAGE DOOR TRIM UNLESS NOTED OTHERWISE ON ELEVATION.

- 3.11 PANEL LAP SIDING WITH 5/4X6 TRIM AROUND DOORS, WINDOWS, AND CORNERS UNLESS NOTED OTHERWISE.
- 3.13 PANEL SIDING WITH 3/4X4 TRIM AROUND DOORS, WINDOWS, AND CORNERS UNLESS NOTED OTHERWISE. BOTTOM OF SIDING SHALL BE A MINIMUM OF 6" ABOVE GRADE.
- 3.15 BOARD AND BATTEN.
- 3.17 MANUFACTURED STONE VENEER.
- 3.38 6X6 CEDAR POST. 1X6 TRIM AT BASE. 1X4 TRIM AT
- 3.62 CEDAR SHUTTERS. ALL SHUTTERS TO BE 18" WIDE USING (3) 2X6 BOARDS. TRIM TO BE INSTALLED AROUND WINDOW PRIOR TO SHUTTER INSTALLATION.
- 3.66 DECORATIVE FALSE LOUVERED VENT WITH 1X6
- 4.11 MINIMUM ROOFING COMPOSITION- 30 YR COMPOSITE SHINGLES ON 15# FELT ON 1/2" OSB SHEATHING OR AS REQUIRED BY CODE.
- 4.31 BUILD CRICKET VALLEY AWAY FROM INTERSECTION FOR POSITIVE DRAINAGE.

CPG DBA

clover

120 SE 30TH ST. LEE'S SUMMIT, MO 64082 816-246-6700

COPYRIGHT 2020 HIS DRAWING HAS BEEN PREPARED BY CLOVER AN HIVE. OR UNDER THEIR DIRECT SUPERVISION AS AN NSTRUMENT OF SERVICE AND IS INTENDED FOR USE ONLY ON THIS PROJECT. ALL DRAWINGS SPECIFICATIONS, AND DESIGNS, INCLUDING THE VERALL LAYOUT, FORM, AND COMPOSITION C SPACES ARE PROTECTED BY COPYRIGHT REGISTERED O CPG. INC. ANY REPRODUCTION. USE. VITHOUT THE WRITTEN CONSENT FROM CPG, IN D/B/A SUMMIT HOMES EXCEPT AS REQUIRED FOR TRICTLY PROHIBITED.

ADDRESS:

A: 3743 SW CLAYTON PL B: 3745 SW CLAYTON PL

PROFESSIONAL SEAL

EVERSTEAD IS RESPONSIBLE FOR STRUCTURAL SPECIFICATIONS ONLY. ARCHITECTURAL PLANS

WERE PRODUCED BY OTHERS.

EVERSTEAD 3741 NE TROON DRIVE SUITE 200 LEE'S SUMMIT, MO 64064 816-399-4901

DIMENSIONAL LUMBER IS LABELED PER INDUSTRY STANDARD TERMINOLOGY. ACTUAL LUMBER SIZING IS EXPECTED TO VARY

WINDOW SIZES ARE WRITTEN IN FEET AND INCHES PER INDUSTRY STANDARDS. EX: 3050 SH = 3'-0" X 5'-0" SINGLE HUNG, 3066 FIX = 3'-0" X 6'-6" FIXED.

- A1. FRONT AND REAR ELEVATION
- A2. LEFT AND RIGHT ELEVATION
- A3. FOUNDATION LEVEL PLAN
- A4. MAIN LEVEL PLAN

FINISHED	PER UNIT	TOTAL
MAIN FLOOR	758	1516
UPPER LEVEL	1109	2218
FINISHED STAIRS TO LOWER LEVEL	0	0
TOTAL	1867	3734
UNFINISHED		
LOWER LEVEL - UNFINISHED	686	1372
PATIO	120	240
GARAGE	423	846

ENGINEER	TRUSS	I-JOIST
FVFRSTFAD	PREMIERE	N/A


REVISIONS	
DESCRIPTION	

ISSUE DATE: 6.7.23

DRAWN BY:

S. SCARBO

SHEET NUMBER:

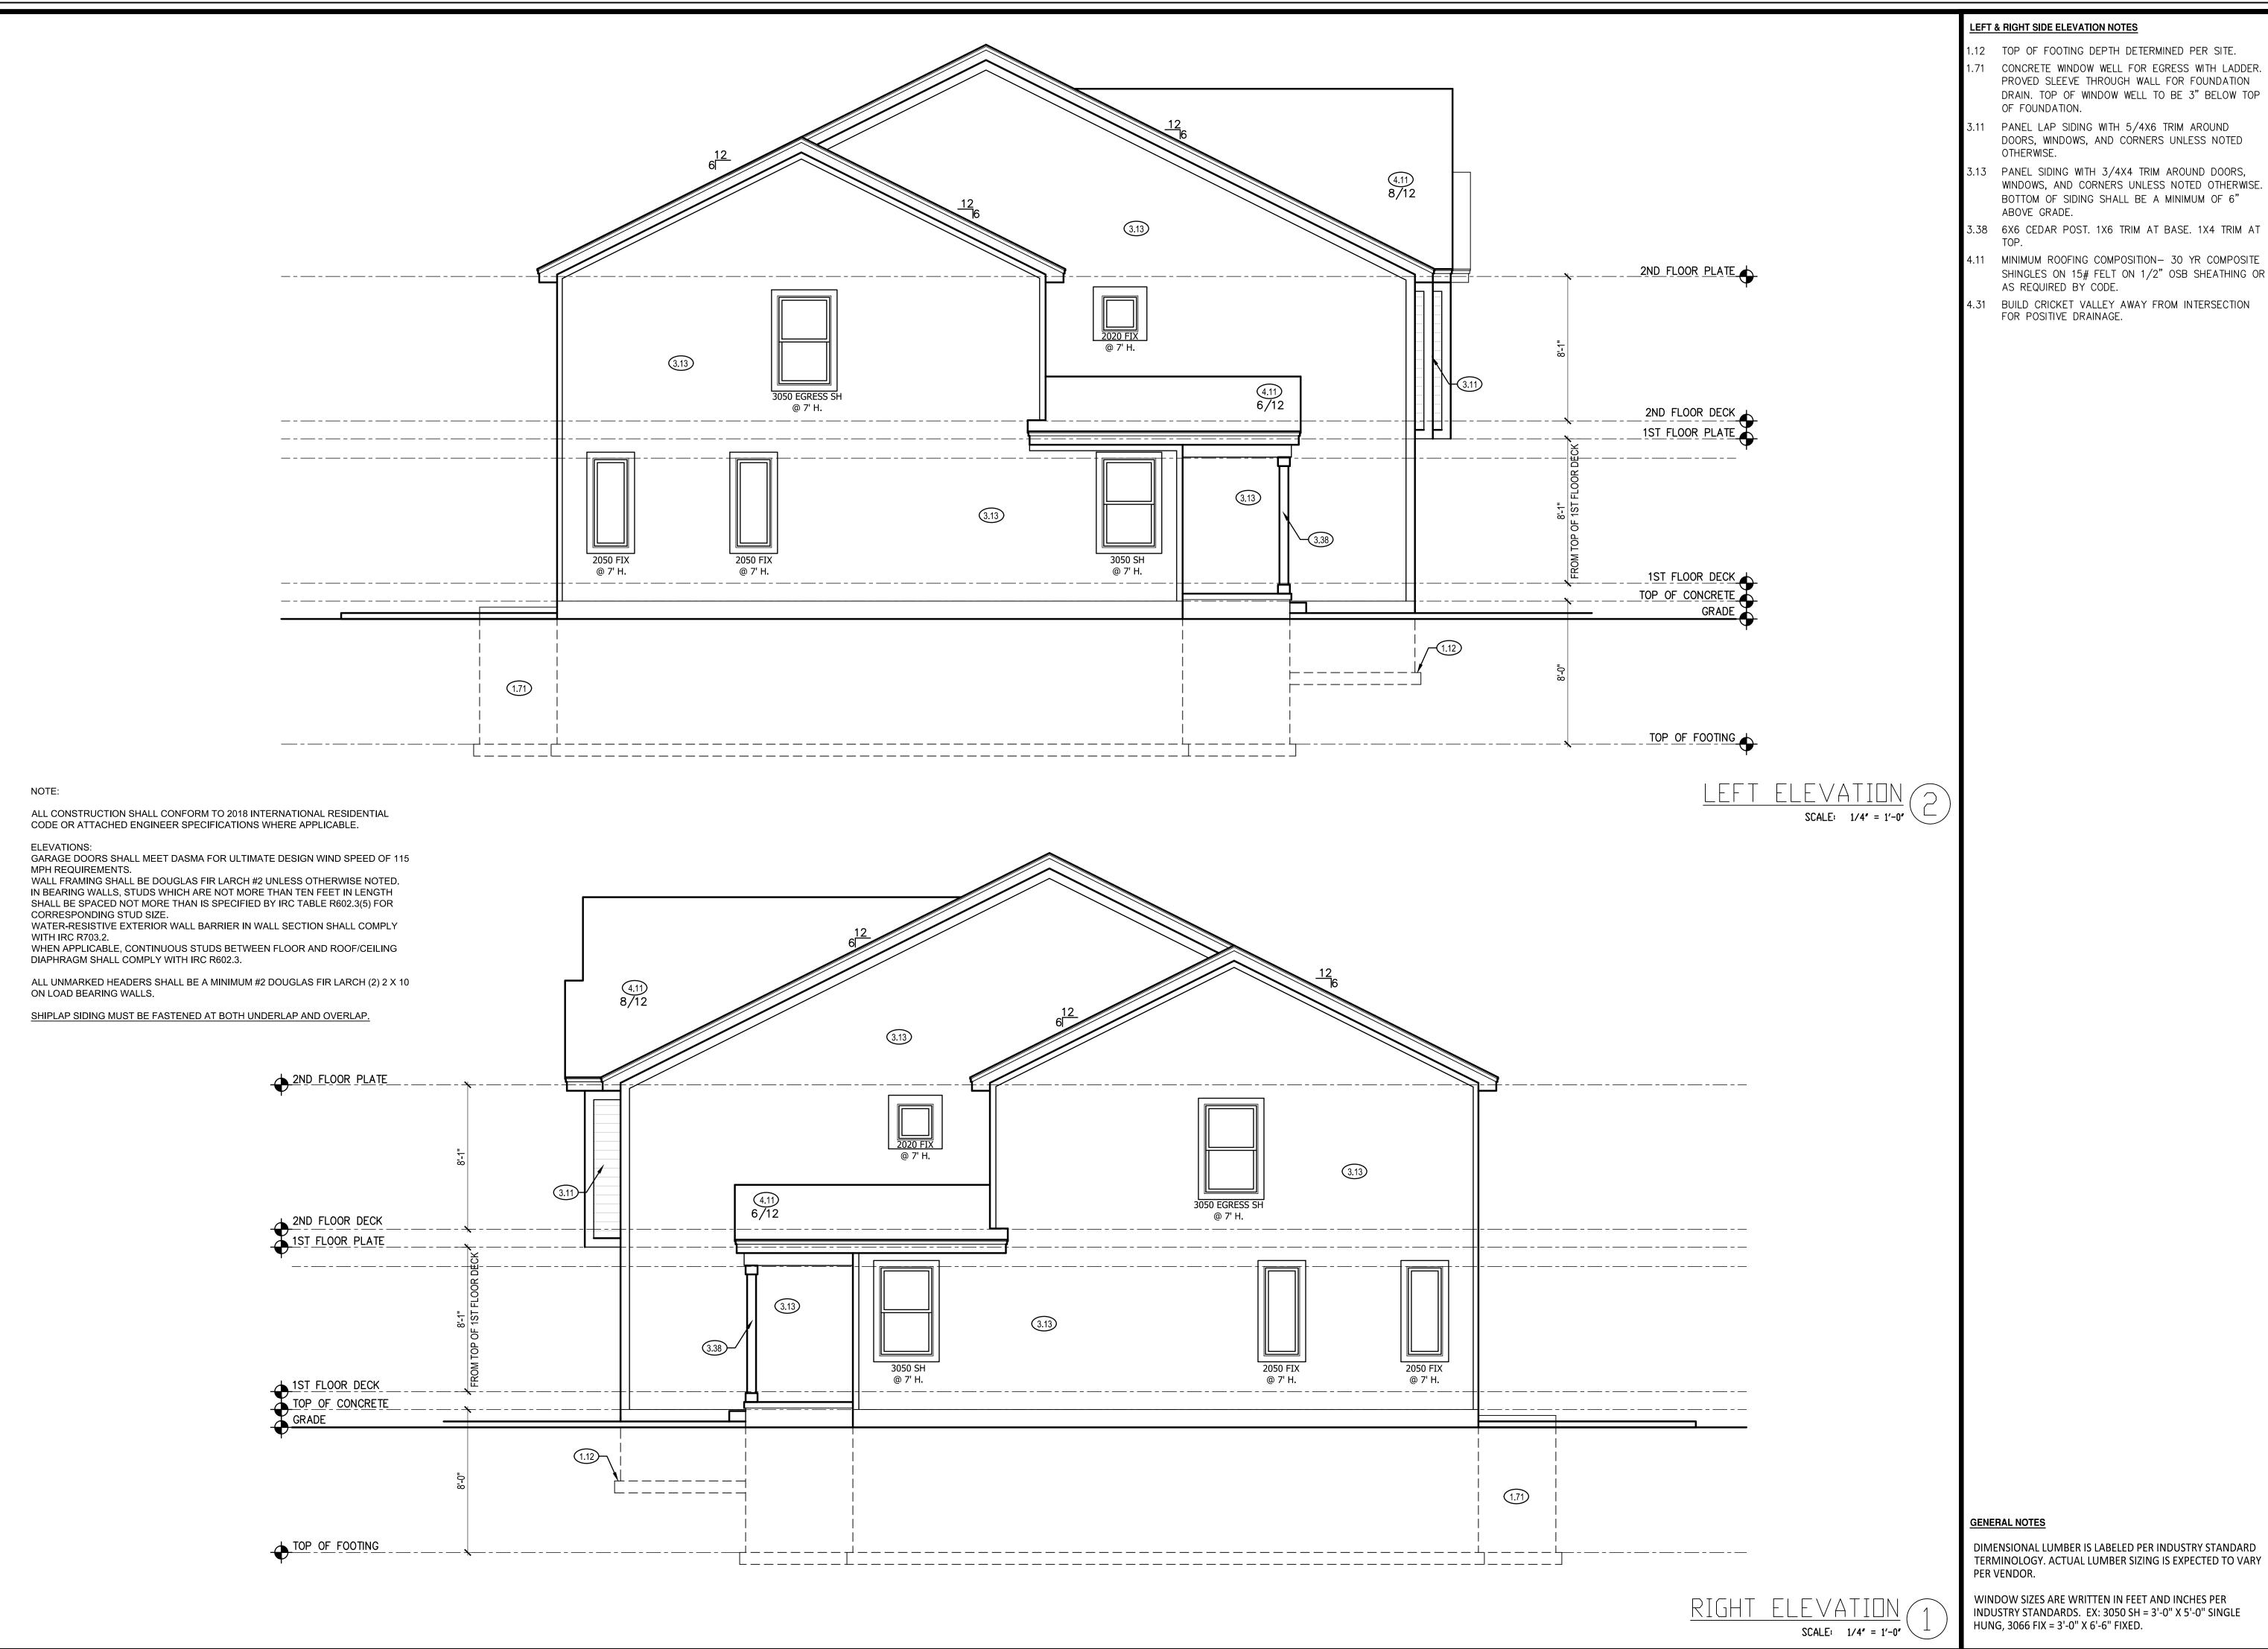

LEFT & RIGHT SIDE ELEVATION NOTES

- 1.12 TOP OF FOOTING DEPTH DETERMINED PER SITE.
- 1.71 CONCRETE WINDOW WELL FOR EGRESS WITH LADDER. PROVED SLEEVE THROUGH WALL FOR FOUNDATION DRAIN. TOP OF WINDOW WELL TO BE 3" BELOW TOP OF FOUNDATION.
- 3.11 PANEL LAP SIDING WITH 5/4X6 TRIM AROUND DOORS, WINDOWS, AND CORNERS UNLESS NOTED
- 3.13 PANEL SIDING WITH 3/4X4 TRIM AROUND DOORS, WINDOWS, AND CORNERS UNLESS NOTED OTHERWISE. BOTTOM OF SIDING SHALL BE A MINIMUM OF 6" ABOVE GRADE.
- 3.38 6X6 CEDAR POST. 1X6 TRIM AT BASE. 1X4 TRIM AT
- 4.11 MINIMUM ROOFING COMPOSITION— 30 YR COMPOSITE SHINGLES ON 15# FELT ON 1/2" OSB SHEATHING OR AS REQUIRED BY CODE.
- 4.31 BUILD CRICKET VALLEY AWAY FROM INTERSECTION FOR POSITIVE DRAINAGE.

CPG DBA

clover

120 SE 30TH ST. LEE'S SUMMIT, MO 64082 816-246-6700

IS DRAWING HAS BEEN PREPARED BY CLOVER AN HIVE, OR UNDER THEIR DIRECT SUPERVISION AS AN ISTRUMENT OF SERVICE AND IS INTENDED FOR USE NLY ON THIS PROJECT. ALL DRAWINGS SPECIFICATIONS, AND DESIGNS, INCLUDING TH PACES ARE PROTECTED BY COPYRIGHT REGISTERED CPG. INC. ANY REPRODUCTION. USE. C WITHOUT THE WRITTEN CONSENT FROM CPG, INC. D/B/A SUMMIT HOMES EXCEPT AS REQUIRED FOR FRICTLY PROHIBITED.

ADDRESS:

A: 3743 SW CLAYTON PL B: 3745 SW CLAYTON PL

PROFESSIONAL SEAL



EVERSTEAD IS RESPONSIBLE FOR STRUCTURAL SPECIFICATIONS ONLY. ARCHITECTURAL PLANS WERE PRODUCED BY OTHERS.

EVERSTEAD 3741 NE TROON DRIVE SUITE 200 LEE'S SUMMIT, MO 64064 816-399-4901

> DRAWN BY: S. SCARBO

ISSUE DATE: 6.7.23

SHEET NUMBER:

HUNG, 3066 FIX = 3'-0" X 6'-6" FIXED.

DIMENSIONS MEASURED FROM CENTERLINE OF PARTY WALL ASSEMBLY.

ALL CONSTRUCTION SHALL CONFORM TO 2018 INTERNATIONAL RESIDENTIAL CODE OR ATTACHED ENGINEER SPECIFICATIONS WHERE APPLICABLE.

FOUNDATION NOTES:

- ALL FOOTINGS MEET OR EXCEED MINIMUM FROST DEPTH OF 36".
 SOIL BEARING CAPACITY SHALL BE 1500 PSF.
- COMPRESSIVE STRENGTH OF CONCRETE F'C COMPRESSIVE STRENGTH
 SHALL BE AS SPECIFIED IN IRC TABLE R402.2. REQUIRED AIR ENTRAINMENT
- SHALL BE 5-7%.
 ALL FOUNDATION WALLS ENCLOSING BELOW GRADE SPACE SHALL BE DAMPPROOFED. DAMPPRROFING SHALL EXTEND FROM THE EDGE OF THE FOOTING TO THE FINISHED GRADE (R-406.1). METHOD OF DAMPPROOFING OR WATERPROOFING SHALL BE A MINIMUM 6-MIL THICK MOISTURE BARRIER OVER POROUS GRAVEL BASE UNDER BASEMENT FLOOR SLAB PER R405.2.2. LAP JOINTS SHALL BE A MINIMUM 6".
- FOUNDATION WALLS SHALL BE DAMPPROOFED PER IRC SECTION R406.
 FOUNDATION DRAINAGE WILL BE IN ACCORDANCE WITH WITH IRC SECTION
- R405.
 BASEMENT EGRESS OPENINGS SHALL BE IN ACCORDANCE WITH IRC SECTION
- R310.1
- ALL INTERIOR FOOTINGS OF LOAD BEARING WALLS AND COLUMNS SHALL BE ISOLATED FROM THE BASEMENT FLOOR SLAB.
- ALL ANCHOR BOLTS SHALL NOT BE SPACED MORE THAN 3' O.C. AND BE EMBEDDED INTO THE CONCRETE A MINIMUM OF 7".
- BACKFILL SHALL NOT BE PLACED AGAINST THE WALL UNTIL THE WALL HAS SUFFICIENT STRENGTH OR HAS BEEN SUFFICIENTLY BRACED TO PREVENT DAMAGE BY BACKFILL.
- IF BASEMENT SLAB ELEVATION IS ABOVE GRADE CONSULT ENGINEER.

DEAD MEN SPACING:

- ALL DEAD MEN SHALL BE SPACED NO MORE THAN 16' FROM EGRESS WELL, REAR GARAGE WALL, 24" RETURN ON FOUNDATION WALL OR ANOTHER DEAD MAN.
- DEAD MEN ARE NOT REQUIRED ON EXTERIOR GARAGE WALLS OR FOUNDATION WALLS THAT ARE 5' OR LESS.
- WALL TRANSITIONING FROM LESS THAN 5' TALL TO MORE THAN 5' TALL WITH STEP DOWNS: A DEAD MAN IS REQUIRED WITHIN 8' OF STEP DOWN (TRANSITIONING FROM LESS THAN 5' TALL TO MORE THAN 5' TALL WALL LOCATION) ON WALL 5' TALL OR MORE

ISOLATED FOOTINGS AND COLUMN PADS SCHEDULE 40 MINIMUM STEEL SYM PAD DEPTHREINFORCEMENT GRADE COLUMN, MIN SIZE 60 KSI STEEL FY = 35 KSIA\\ 30"×30" (5) #4 BAR E.W. 3" DIAMETER /B\| 36"×36"| (6) #4 BAR E.W. 3" DIAMETER /C\| 42"×42"| (7) #4 BAR E.W. 3" DIAMETER (8) #4 BAR E.W. 3" DIAMETER É\|54"×54"|1′−4" (9) #4 BAR E.W. 3" DIAMETER $F \setminus |60" \times 60" | 1' - 6" | (10) #4 BAR E.W.$ 3.5" DIAMETER NO COLUMN ANY SIZE FOOTING WITH AN (*) NEEDED


ISOLATED FOOTINGS AND COLUMN PADS

SYM	PIER DIAMETER	DEPTH	MINIMUM REINFORCEMENT GRADE 40 KSI STEEL
Ġ	12″	3′-0″	(4) VERTICAL #4
A	16″	3′-0″	(4) VERTICAL #4
\triangle	18″	3′-0″	(4) VERTICAL #4
k	24"	3′-0″	(4) VERTICAL #4
\triangle	28″	3'-0"	(4) VERTICAL #4

COLUMN AND PAD SIZES ARE FOR A MAXIMUM COLUMN HEIGHT OF 10'.

COLUMNS GREATER THAN 10' REQUIRE A SEPARATE ENGINEERED

DESIGN. FOOTINGS A-F SPACING OF 6" O.C. WITH 3" CLEAR COVER.

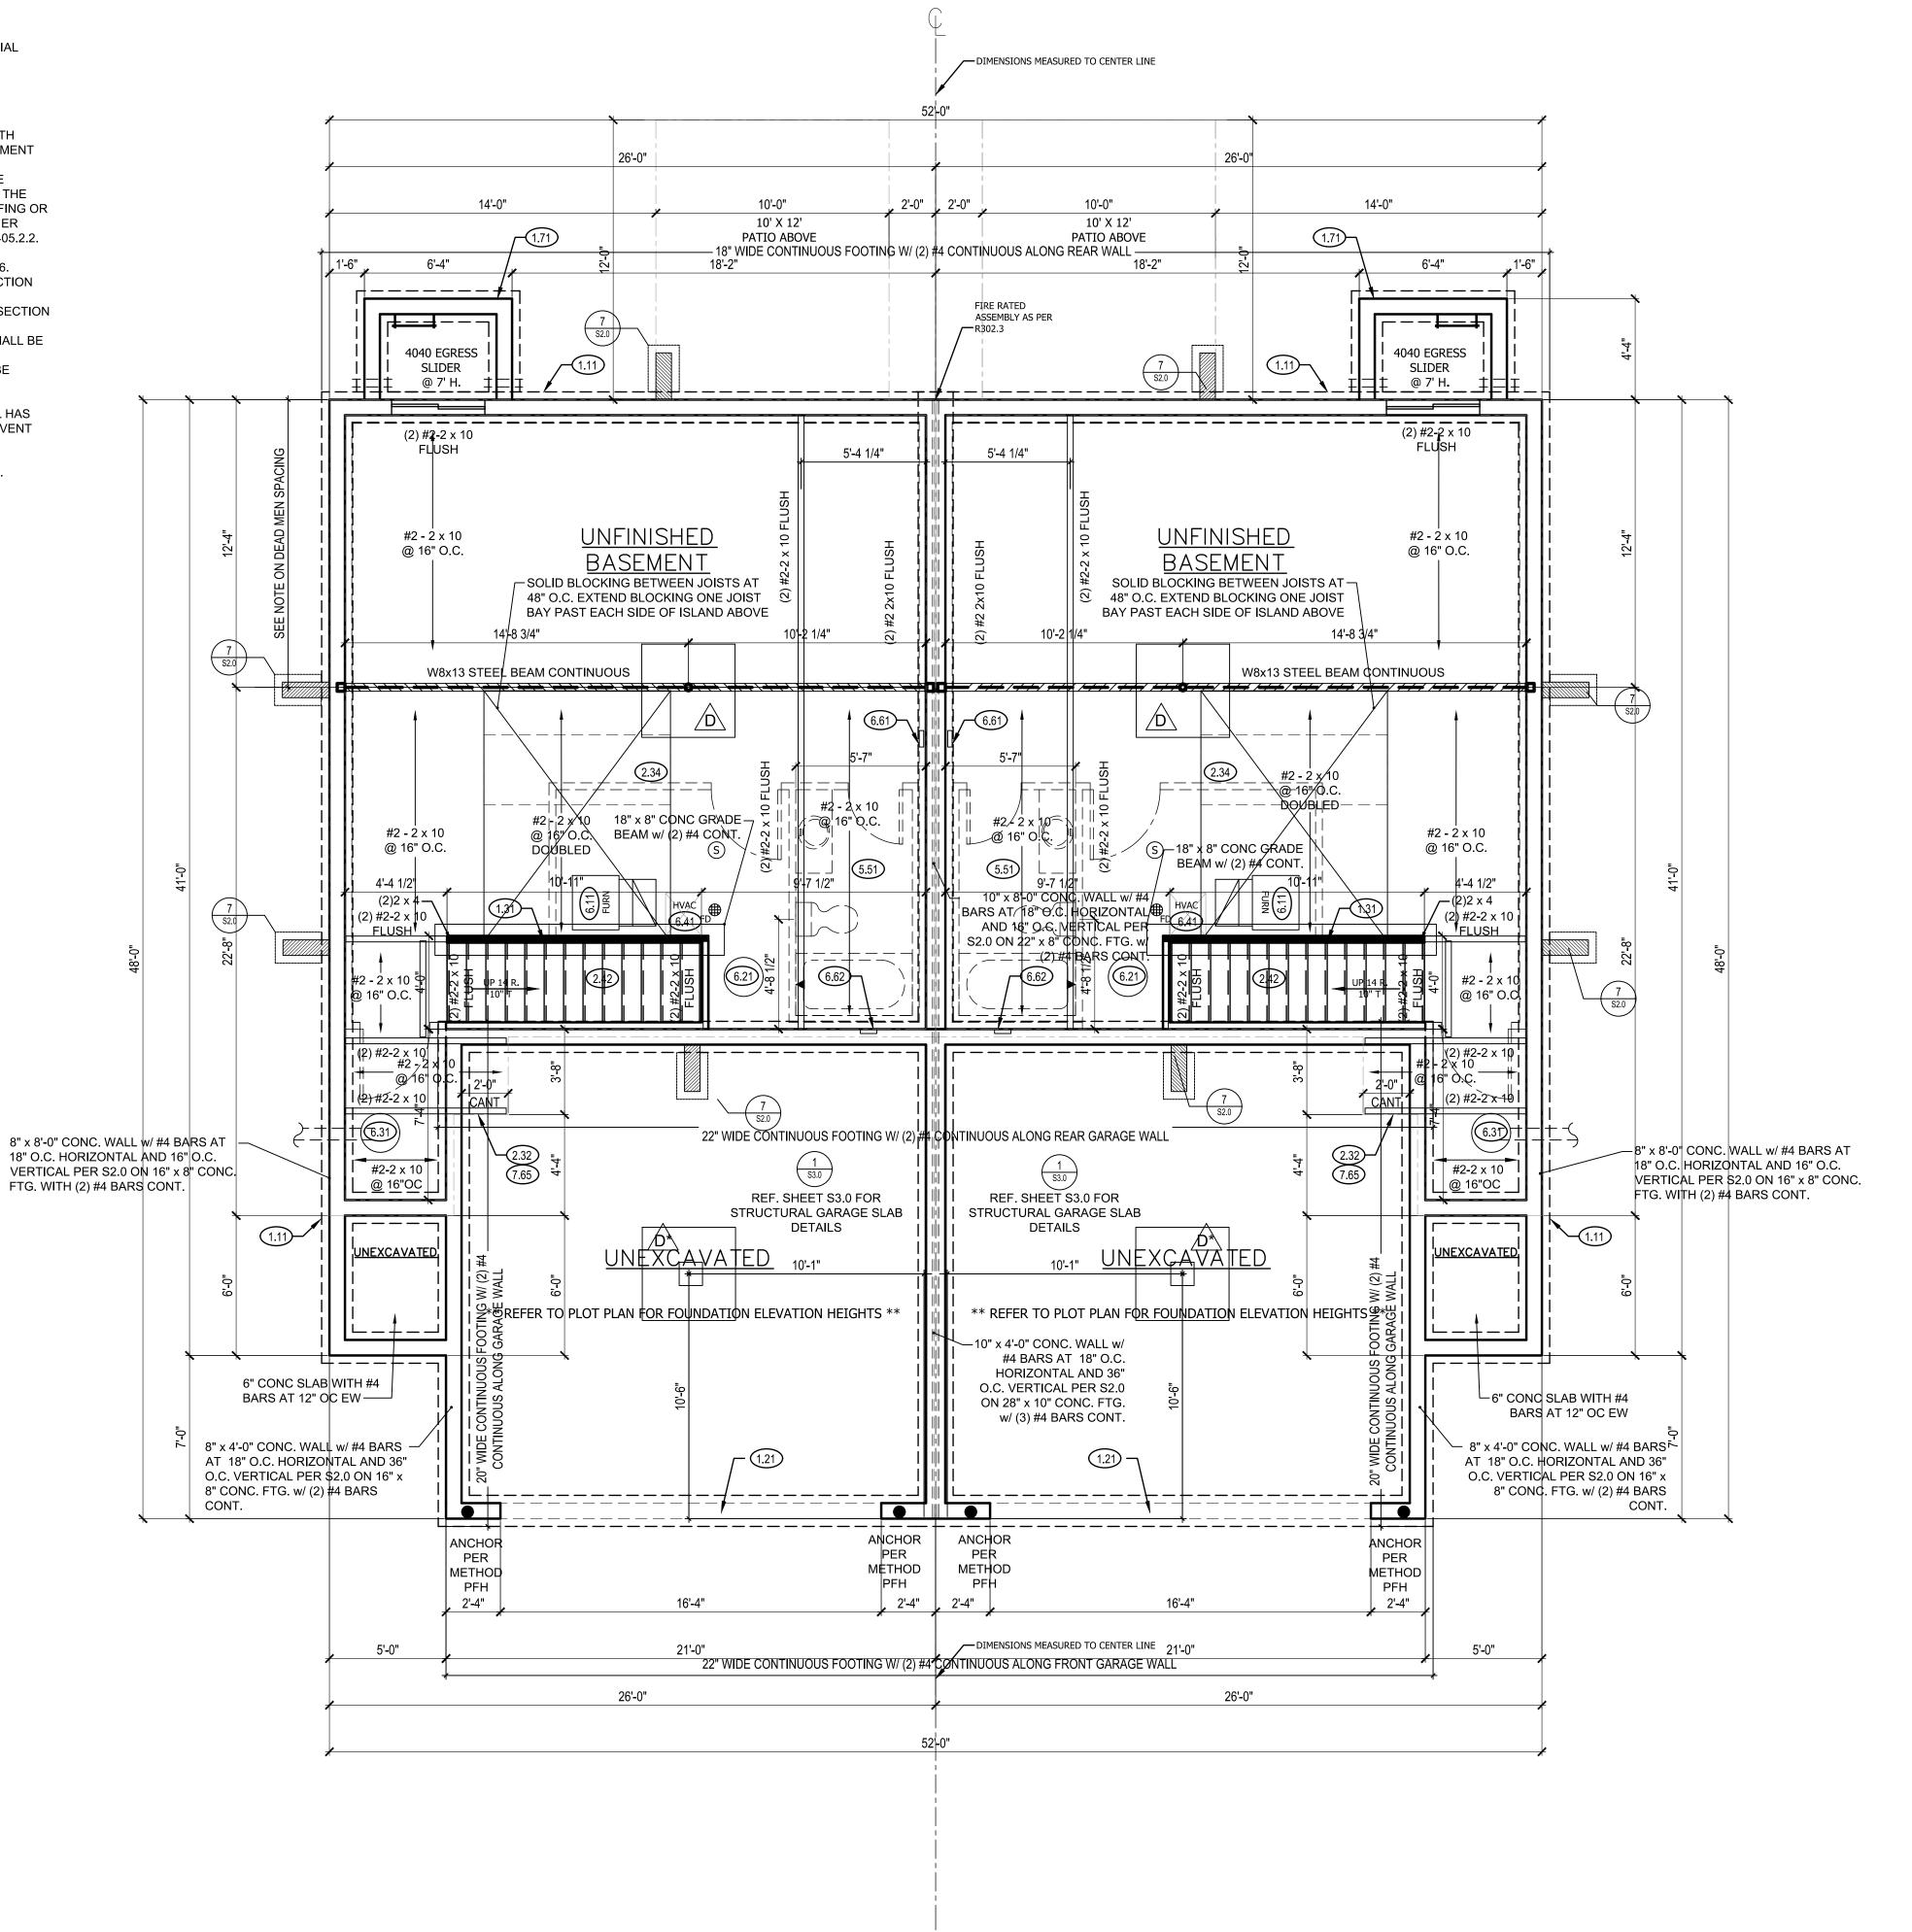

FOUNDATION PLAN NOTES

- 1.11 CONTINUOUS CONCRETE FOOTING
- .21 RECESS TOP OF FOUNDATION WALL
- 1.31 2X4 STUD WALL WITH TREATED SILL PLATE
- 1.71 CONCRETE WINDOW WELL FOR EGRESS WITH LADDER. PROVED SLEEVE THROUGH WALL FOR FOUNDATION DRAIN. TOP OF WINDOW WELL TO BE 3" BELOW TOP OF FOUNDATION.
- 2.32 INSULATE CANTILEVER AS REQUIRED PRIOR TO BLOCKING
- 2.34 PROVIDE ADDITIONAL BRACING FOR ISLAND ABOVE.
- 2.42 FIRE RATED SHEETROCK UNDER STAIRS
- 5.51 DRAIN LINE ONLY FOR FUTURE USE. LOCATION TO BE MARKED WITH REBAR AND CUT FLUSH TO FLOOR
- 6.11 DIRECT FURNACE. FUEL BURNING APPLIANCES SHALL BE DIRECT VENTED TO EXTERIOR FOR COMBUSTION
- 6.21 HOT WATER HEATER WITH THERMAL EXPANSION CONTROL DEVICE
- 6.31 SUMP PIT AND PUMP. PROVIDE ELECTRICAL GFCI PROTECTION. PROVIDE SLEEVE THROUGH FOOTING.
- 6.41 HVAC CHASE ABOVE
- 5.61 200 AMP ELECTRICAL PANEL. LOCATION TO BE DETERMINED ON SITE.
- 6.62 UFER GROUND— VERIFY LOCATION WITH PROJECT MANAGER.
- 7.65 LINE OF FLOOR ABOVE

CPG DBA

clover

& hive

120 SE 30TH ST. LEE'S SUMMIT, MO 64082 816-246-6700

COPYRIGHT 2020


THIS DRAWING HAS BEEN PREPARED BY CLOVER AND HIVE, OR UNDER THEIR DIRECT SUPERVISION AS AT INSTRUMENT OF SERVICE AND IS INTENDED FOR USI ONLY ON THIS PROJECT. ALL DRAWINGS SPECIFICATIONS, AND DESIGNS, INCLUDING THI OVERALL LAYOUT, FORM, AND COMPOSITION OF SPACES ARE PROTECTED BY COPYRIGHT REGISTERED TO CPG, INC. ANY REPRODUCTION, USE, OF DISCLOSURE OF THE INFORMATION CONTAINED HERBIT WITHOUT THE WRITTEN CONSENT FROM CPG, INC. D/B/A SUMMIT HOMES EXCEPT AS REQUIRED FOR STRICTLY PROHIBITED.

ADDRESS:

A: 3743 SW CLAYTON PL B: 3745 SW CLAYTON PL

OSAGE #49
TWIN HONEYDEW
FARMHOUSE

PROFESSIONAL SEAL:

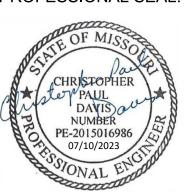

EVERSTEAD IS RESPONSIBLE FOI STRUCTURAL SPECIFICATIONS ONLY. ARCHITECTURAL PLANS WERE PRODUCED BY OTHERS.

EVERSTEAD 3741 NE TROON DRIVE SUITE 200 LEE'S SUMMIT, MO 64064 816-399-4901

> DRAWN BY: S. SCARBO

ISSUE DATE: 6.7.23

SHEET NUMBER:

AS NOTED FOR PLAN REVIE

GENERAL NOTES

BACK WATER VALVES REQUIRED ON ALL BASEMENT PLUMBING FIXTURES. PROVIDE MEANS OF CONTROLLING PRESSURE CAUSED BY THERMAL EXPANSION.

ALL SILLS & SLEEPERS SUPPORTED ON CONCRETE OR MASONRY SHALL BE OF DECAY-RESISTANT MATERIALS.

TERMINOLOGY. ACTUAL LUMBER SIZING IS EXPECTED TO VARY PER VENDOR.

DIMENSIONAL LUMBER IS LABELED PER INDUSTRY STANDARD

ALL INTERIOR NON-LOAD BEARING, NON-BRACED, NON-CABINET WALLS ARE ALLOWED AT 24" O.C.

SMOKE AND CARBON MONOXIDE DETECTORS SHOW ON PLANS ARE TO BE CONSIDERED RECOMMENDATIONS ONLY. FINAL PLACEMENT IS TO BE DETERMINED BY MUNICIPAL REQUIREMENTS.

DIMENSIONS MEASURED FROM CENTERLINE OF PARTY WALL ASSEMBLY. ALL CONSTRUCTION SHALL CONFORM TO 2018 INTERNATIONAL RESIDENTIAL CODE OR ATTACHED ENGINEER SPECIFICATIONS WHERE APPLICABLE. DIMENSIONS MEASURED TO CENTER LINE ALL UNMARKED HEADERS SHALL BE A MINIMUM #2 DOUGLAS FIR LARCH (2) 2 X 10 ON LOAD BEARING 2.51 3 STUDS BETWEEN WINDOW UNITS **DETAILS AND NOTES:** BASEMENT EGRESS WINDOWS ARE TO COMPLY WITH WINDOW FALL PROTECTION REQUIREMENTS TO COMPLY WITH SECTION R612.2. STAIRS SHALL COMPLY WITH IRC R311.7. THE MAXIMUM 2'-0" 2'-0" 10'-0" RISER HEIGHT OF STAIRWAYS SHALL NOT EXCEED 7-3/4" 10' X 12' 10' X 12' AND THE TREADS SHALL PROVIDE A MINIMUM TREAD PATIO PATIO DEPTH OF 10" (IRC 2018 R311.7.5.1). EVERIFY WITH CONTRACT VERIFY WITH CONTRACT SELF CLOSING DEVICES ARE REQUIRED FOR GARAGE TO DWELLING SEPARATION DOORS. STEEL COLUMNS WILL BE A MINIMUM OF SCHEDULE 40. 9'-4 3/4" 3'-4 1/2" 3'-4 1/2" 3'-4 1/2" 3'-4 1/2" ENERGY REQUIREMENTS SHALL CONFORM TO THE IRC 5.05 FIRE RATED CHAPTER 11. ASSEMBLY AS PER SECURITY SHALL CONFORM TO IRC R326/KCBRC. AN ACCESSIBLE CONNECTION POINT WILL BE PROVIDED END CONDITION #1 24"— -END CONDITION #1 24" TO A 20 FOOT CONCRETE ENCASED ELECTRODE RETURN PANEL @ 7' н. @ 7' н. (FOOTING REBAR) FOR THE ELECTRICAL SERVICE RETURN PANEL GROUNDING ELECTRODE CONDUCTOR (UFER GROUND). (2) #2-2 x 12 (2) #2-2 x 12 CARBON MONOXIDE DETECTORS WILL BE PROVIDED IN (2) #2-2 x 10 CONTINUOUS (2) #2-2 x 10 CONTINUOUS ACCORDANCE WITH IRC SECTION R315. THE BUILDING THERMAL ENVELOPE IS REQUIRED TO BE SEALED(2018 IRC SECTION N1102.4.1 AND TABLE • DUCTS, AIR HANDLERS, FILTER BOXES AND BUILDING GREAT <u>DINING</u> **DINING** GREA1 CAVITIES USED AS DUCTS SHALL BE SEALED (2018 IRC SECTION N1103.2.2) <u>ROOM</u> <u>ROOM</u> FLOOR PLANS: LEDGERS(FLOOR AND CEILING) SHALL BE IN #2 - 2 x 10 #2 - 2 x 10 ACCORDANCE WITH IRC 507. @ 16" O.C. @ 16" O.C. • ALL CANTILIEVERS SHALL HAVE AT LEAST A 3:1 BACK A MINIMUM OF DOUBLE JOIST UNDER EACH BEARING WALL IS REQUIRED. ALL WALLS UNDER 12' SHALL BE DOUGLAS FIR LARCH #2 2X4 STUDS AT 16" O.C. FULL HEIGHT CONTINUOUS (UNLESS OTHERWISE NOTED). ALL WALLS 12' AND OVER SHALL BE DOUGLAS FIR #2 (M-12) LUMBER 2x6 STUDS AT 16" O.C. FULL HEIGHT CONTINUOUS (UNLESS OTHERWISE NOTED). EXTERIOR WALL SHEATHING SHALL BE AS FOLLOWS: #2 - 2 x 10 @ 16" O.C<u>.</u> @ 16" O.C. 3" THICK OSB FOR METHODS: WSP, CS-WSP AND PFH #2 - 2 x 10 • $\frac{7}{16}$ " THICK OSB FOR METHOD CS-PF. @ 16" O.C. @ 16" O.C. <u>PANTRY</u> 8'-9 1/2" • SPECIFIED THICKNESS OF OSB SHALL BE INSTALLED UNDERNEATH LP LAP SIDING AND/OR ENGINEERED BRACED WALL PANELS. • LP PANEL SIDING - 7/16" GROOVED SHALL BE EQUIVALENT TO 3" THICK OSB. OSB MAY BE OMITTED UNDERNEATH 7/16" GROOVED PANEL SIDING IN AREAS REQUIRING 3" THICK OSB. ABOVE INSTALL FASTENERS AND NAILING PATTERN PER 2018 (2) #2-2 x 1 2) #2-2 x 10 IRC SECTION R602.10. GIRDER TRUSS BEARING: STUD PACK OF (4) 2 x 4 OR (4) 2 x 6 DOUGLAS FIR LARCH 7.71 3'-10" 2 (DEPENDING ON WALL THICKNESS) BELOW EACH EARING POINT OF EACH GIRDER TRUSS, UNLESS 5'-11" THERWISE NOTED. STUD PACKS SHALL BE CARRIED DOWN TO FOUNDATION OR LOAD SUPPORTING NOTE: 5/8" FIRE RATED GYP. BD PROVIDE 2X SOLID BLOCKING SUPPORT BELOW ALL ON GARAGE WALLS ADJACENT ON GARAGE WALLS ADJACENT POINT LOADS CONTINUOUS TO BEARING STRUCTURE @ 16" O.C. TO LIVING AREAS, CEILINGS, TO LIVING AREAS, CEILINGS, AND/OR FOUNDATION BELOW. BEAMS, AND WALLS. BEAMS, AND WALLS. (2) #2-2 x 10 30 x 68 **GARAGE** GARAGE LVL'S SHALL BE: BOISE CASCADE VERSA-LAM 3100 FB PROVIDE FULL BEARING FOR DOUBLE, TRIPLE JOISTS, LVL'S W12X14 STEEL BEAM UNIT (3) 2 x 4 — COVERED <u>COVERED</u> W12X14 STEEL BEAM ÙP TO 9' HT UP TO 9' HT UP TO 9' HT UP TO 9' HT ** REFER TO PLOT PLAN FOR FOUNDATION ELEVATION HEIGHTS ** ** REFER TO PLOT PLAN FOR FOUNDATION ELEVATION HEIGHTS ** <u>(2) #2-2 x 10</u> (2) #2-2 x 10 FULL HEIGHT CONTINUOUS 6 x 6 FULL HEIGHT CONTINUOUS 6 x 6 CEDAR POST ON SIMPSON ABU66 #2 - 2 x 10 CEDAR POST ON SIMPSON ABU66 #2 - 2 x 1 POST BASE, TYP #2 - 2 x 10 @ 16" O.C. @ 16" O.C. POST BASE, TYP @ 16" O.C. @ 16" O.0 **GENERAL NOTES** G.T. BEARIN (2) 13/4" x 18" LVL CONT FROM ABOV (2) 1¾" x 18" LVL CONT CORNER-TO-CORNER BWL 2 16' X 7 O.H.D. 16' X 7' O.H.D. 7.65 13'-8" 13'-8" 7'-4" 7'-4" 2'-6" 16'-0" 2'-6" 2'-6" 16'-0" 2'-6" BRACING METHODS EXTERIOR BRACING CS-WSP PER IRC R602.10 — DIMENSIONS MEASURED TO CENTER LINE 21'-0" EXTERIOR BRACING WSP PER IRC R602.10 (INCLUDES PARTIAL 21'-0" 5'-0" PANELS PER IRC R602.10.5.2) INTERIOR BRACING LIB PER IRC R602.10 26'-0" 26'-0" MINIMUM LIB LENGTH PER 2018 IRC TABLE R602.10.5: 55" - 8' TALL WALL HEIGHT 62" - 9' TALL WALL HEIGHT 69" - 10' TALL WALL HEIGHT EXTERIOR BRACING PFH (SEE DETAILS) PER IRC R602.10.5 BWL A **BWL B** BWL C INTERIOR LOAD BEARING WALL (EXTERIOR WALLS ARE ASSUMED LOAD BEARING) IRC TABLE N1102.1.2 (R402.1.2) INSULATION AND FENESTRATION REQUIREMENTS BY COMPONENT (PARTIAL) FLOOR BASEMENT SLAB R-VALUE CRAWL SPACE CEILING WOOD FRAME WALL WALL CLIMATE | FENESTRATION | SKYLIGHT *ENESTRATION | SKYLIGHT | FENESTRATION | CLILING U-FACTOR | FENESTRATION | R-VALUE R-VALUE | R-VALUE | WALL R-VALUE | & DEPTH R-VALUE SHGC ^{b, e} R-VALUE

.32

MARINE

20 OR 13+5

8/13 | 19

10/13

MAIN FLOOR PLAN NOTES

1.22 EXPOSED TOP OF FOUNDATION WALL.

2.32 INSULATE CANTILEVER AS REQUIRED PRIOR TO

2.41 CURB STAIR SYSTEM WITH OPEN HANDRAIL

2.45 STAIRS TO LOWER LEVEL UNFINISHED

3.38 6X6 CEDAR POST. 1X6 TRIM AT BASE. 1X4 TRIM AT

5.05 HOSE BIBB

7.65 LINE OF FLOOR ABOVE

7.71 20 MINUTE FIRE RATED SOLID CORE WITH

SELF-CLOSING HINGES

8.11 24" CABINET + 12" OVERHANG FLAT ISLAND. VERIFY LOCATION WITH PERSONAL BUILDER.

clover

CPG DBA

120 SE 30TH ST. LEE'S SUMMIT, MO 64082 816-246-6700

COPYRIGHT 2020 HIS DRAWING HAS BEEN PREPARED BY CLOVER AN HIVE. OR UNDER THEIR DIRECT SUPERVISION AS AN ISTRUMENT OF SERVICE AND IS INTENDED FOR USE DNLY ON THIS PROJECT. ALL DRAWINGS SPECIFICATIONS, AND DESIGNS, INCLUDING TH PACES ARE PROTECTED BY COPYRIGHT REGISTERED CPG. INC. ANY REPRODUCTION. USE. C VITHOUT THE WRITTEN CONSENT FROM CPG. INC D/B/A SUMMIT HOMES EXCEPT AS REQUIRED FOR TRICTLY PROHIBITED.

ADDRESS:

A: 3743 SW CLAYTON PL B: 3745 SW CLAYTON PL

PROFESSIONAL SEAL



EVERSTEAD IS RESPONSIBLE FOR STRUCTURAL SPECIFICATIONS ONLY. ARCHITECTURAL PLANS WERE PRODUCED BY OTHERS.

SCALE: 3/4" = 1'-0"

WINDOWS TO COMPLY WITH IRC R312.2 FOR FALL

ALL INTERIOR NON-LOAD BEARING, NON-BRACED, NON-CABINET WALLS ARE ALLOWED AT 24" O.C.

TRUSSES UNLESS NOTED OTHERWISE.

INSULATION SURROUND.

REQUIREMENTS.

ALL EXTERIOR WALLS, INTERIOR BEARING WALLS, AND

INTERIOR BRACED WALLS ARE AT 16" O.C. UNLESS NOTED

ROOF AND CEILING FRAMING ARE PRE-ENGINEERED WOOD

DIMENSIONAL LUMBER IS LABELED PER INDUSTRY STANDARD

HVAC DUCTWORK RUNNING THROUGH THE ATTIC SPACE

PROVIDE BLOCKING AT ALL CEILING JUMPS FOR INSULATION.

SMOKE AND CARBON MONOXIDE DETECTORS SHOW ON PLANS ARE TO BE CONSIDERED RECOMMENDATIONS ONLY. FINAL

2X6 EXTERIOR WALL OVER 12' SHALL BE DOUGLAS FIR #2.

PLACEMENT IS TO BE DETERMINED BY MUNICIPAL

SHALL BE HUNG FROM ABOVE TO ALLOW COMPLETE

TERMINOLOGY. ACTUAL LUMBER SIZING IS EXPECTED TO VARY

PROTECTION.

OTHERWISE.

EVERSTEAD 3741 NE TROON DRIVE SUITE 200 LEE'S SUMMIT, MO 64064 816-399-4901

> **DRAWN BY:** S. SCARBO

ISSUE DATE:

6.7.23

SHEET NUMBER:

WINDOW SIZES ARE WRITTEN IN FEET AND INCHES PER INDUSTRY STANDARDS. EX: 3050 SH = 3'-0" X 5'-0" SINGLE HUNG, 3066 FIX = 3'-0" X 6'-6" FIXED. SCALE: 1/4'' = 1'-0''

ALL CONSTRUCTION SHALL CONFORM TO 2018 INTERNATIONAL RESIDENTIAL CODE OR ATTACHED ENGINEER SPECIFICATIONS WHERE APPLICABLE. ALL UNMARKED HEADERS SHALL BE A MINIMUM #2 DOUGLAS FIR LARCH (2) 2 X 10 ON LOAD BEARING WALLS. DETAILS AND NOTES: BASEMENT EGRESS WINDOWS ARE TO COMPLY WITH IRC R310.2. WINDOW FALL PROTECTION REQUIREMENTS TO COMPLY WITH SECTION R612.2. STAIRS SHALL COMPLY WITH IRC R311.7. THE MAXIMUM RISER HEIGHT OF STAIRWAYS SHALL NOT EXCEED 7-3/4" 11'-8 1/2" AND THE TREADS SHALL PROVIDE A MINIMUM TREAD DEPTH OF 10" (IRC 2018 R311.7.5.1). SELF CLOSING DEVICES ARE REQUIRED FOR GARAGE 9'-6 1/2" TO DWELLING SEPARATION DOORS. STEEL COLUMNS WILL BE A MINIMUM OF SCHEDULE 40. ENERGY REQUIREMENTS SHALL CONFORM TO THE IRC SECURITY SHALL CONFORM TO IRC R326/KCBRC AN ACCESSIBLE CONNECTION POINT WILL BE PROVIDED TO A 20 FOOT CONCRETE ENCASED ELECTRODE (FOOTING REBAR) FOR THE ELECTRICAL SERVICE 3050 EGRESS SH 3050 EGRESS SH GROUNDING ELECTRODE CONDUCTOR (UFER GROUND). CARBON MONOXIDE DETECTORS WILL BE PROVIDED IN ACCORDANCE WITH IRC SECTION R315. (2) #2-2 x 10 (2) #2-2 x 10 THE BUILDING THERMAL ENVELOPE IS REQUIRED TO BE SEALED(2018 IRC SECTION N1102.4.1 AND TABLE N1102 4 1 1).

DUCTS, AIR HANDLERS, FILTER BOXES AND BUILDING

ALL CANTILIEVERS SHALL HAVE AT LEAST A 3:1 BACK

A MINIMUM OF DOUBLE JOIST UNDER EACH BEARING

ALL WALLS UNDER 12' SHALL BE DOUGLAS FIR LARCH #2 2X4 STUDS AT 16" O.C. FULL HEIGHT CONTINUOUS

ALL WALLS 12' AND OVER SHALL BE DOUGLAS FIR #2 (M-12) LUMBER 2x6 STUDS AT 16" O.C. FULL HEIGHT

EXTERIOR WALL SHEATHING SHALL BE AS FOLLOWS:

• 3" THICK OSB FOR METHODS: WSP, CS-WSP AND PFH

SPECIFIED THICKNESS OF OSB SHALL BE INSTALLED UNDERNEATH LP LAP SIDING AND/OR ENGINEERED

EQUIVALENT TO 3" THICK OSB. OSB MAY BE OMITTED UNDERNEATH 7/16" GROOVED PANEL SIDING IN AREAS

INSTALL FASTENERS AND NAILING PATTERN PER 2018

• STUD PACK OF (4) 2 x 4 OR (4) 2 x 6 DOUGLAS FIR LARCH (DEPENDING ON WALL THICKNESS) BELOW EACH BEARING POINT OF EACH GIRDER TRUSS, UNLESS OTHERWISE NOTED. STUD PACKS SHALL BE CARRIED DOWN TO FOUNDATION OR LOAD SUPPORTING

PROVIDE 2X SOLID BLOCKING SUPPORT BELOW ALL POINT LOADS CONTINUOUS TO BEARING STRUCTURE

BRACING METHODS

PANELS PER IRC R602.10.5.2)

55" - 8' TALL WALL HEIGHT

62" - 9' TALL WALL HEIGHT

69" - 10' TALL WALL HEIGHT

CLIMATE | FENESTRATION | SKYLIGHT

.32

U-FACTOR[®] U-FACTOR

ZONE

EXTERIOR BRACING CS-WSP PER IRC R602.10

INTERIOR BRACING LIB PER IRC R602.10

EXTERIOR BRACING PFH (SEE DETAILS) PER IRC R602.10.5

EXTERIOR BRACING WSP PER IRC R602.10 (INCLUDES PARTIAL

FENESTRATION | R-VALUE

SHGC b, e

WOOD FRAME WALL WALL

20 DR 13+5

FLOOR | BASEMENT® | SLAB®R-VALUE | CRAWL SPACE

10/13

R-VALUE

10/13

R-VALUE R-VALUE WALL R-VALUE & DEPTH

19

8/13

MINIMUM LIB LENGTH PER 2018 IRC TABLE R602.10.5:

LVL'S SHALL BE: BOISE CASCADE VERSA-LAM 3100 FB PROVIDE FULL BEARING FOR DOUBLE, TRIPLE JOISTS, LVL'S

LP PANEL SIDING - 7/16" GROOVED SHALL BE

CONTINUOUS (UNLESS OTHERWISE NOTED).

 $\frac{7}{6}$ " THICK OSB FOR METHOD CS-PF.

BRACED WALL PANELS.

REQUIRING $\frac{3}{8}$ " THICK OSB.

AND/OR FOUNDATION BELOW.

AND STEEL BEAMS.

IRC SECTION R602.10.

LEDGERS(FLOOR AND CEILING) SHALL BE IN

SECTION N1103.2.2)


WALL IS REQUIRED.

ACCORDANCE WITH IRC 507.

(UNLESS OTHERWISE NOTED).

CAVITIES USED AS DUCTS SHALL BE SEALED (2018 IRC

DIMENSIONS MEASURED FROM CENTERLINE OF PARTY WALL ASSEMBLY.

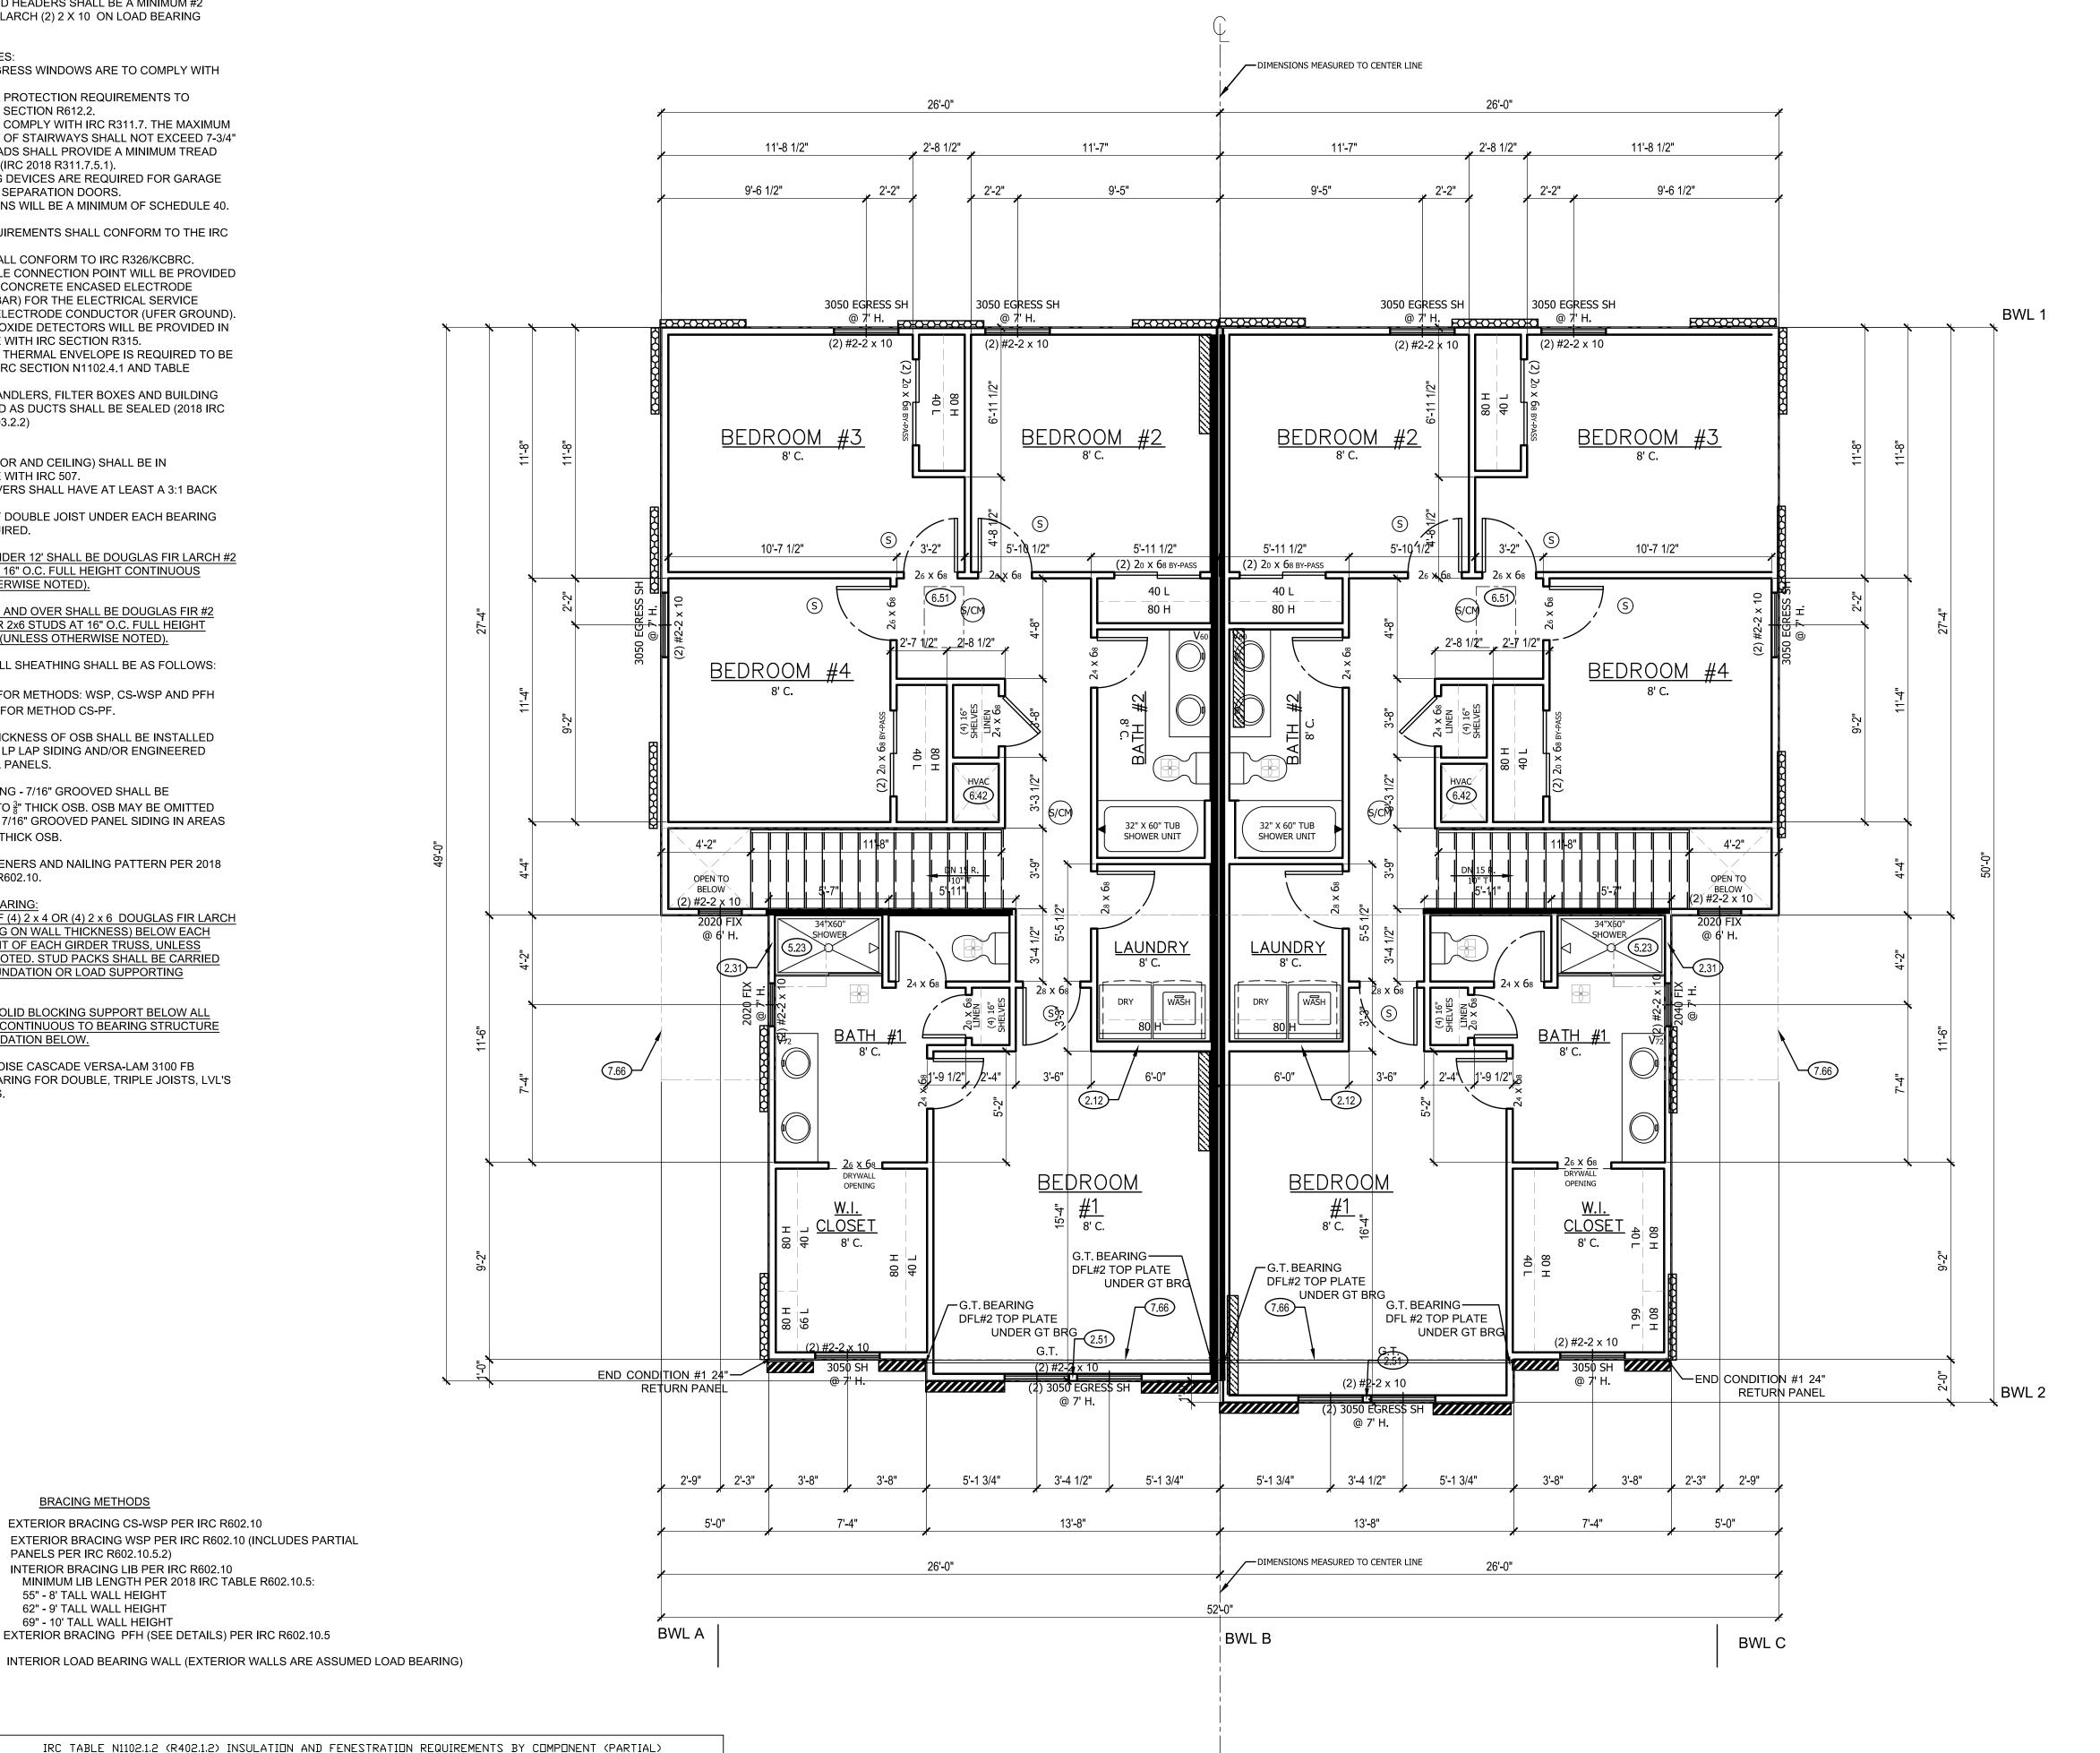

UPPER FLOOR PLAN NOTES

2.12 2X6 STUD WALL

2.31 SIX SIDED TUB ASSEMBLY INCLUDING THERMOPLY ON EXTERIOR WALL TO 2" ABOVE TOP OF TUB DECK OR TUB/SHOWER UNIT

5.23 FIBERGLASS SHOWER UNIT. SEE PRICE SUMMARY FOR DETAILS.

2.51 3 STUDS BETWEEN WINDOW UNITS

6.42 HVAC - BUMP TRUSSES AS NECESSARY FOR HVAC ACCESS.

6.51 1'-10"X3'-0" MINIMUM ATTIC ACCESS WITH 3/4" BACKER BOARD AND 2 LATCHES. BUMP TRUSSES FOR ATTIC ACCESS.

7.66 LINE OF FLOOR BELOW

clover

CPG DBA

120 SE 30TH ST. LEE'S SUMMIT, MO 64082 816-246-6700

COPYRIGHT 2020 HIS DRAWING HAS BEEN PREPARED BY CLOVER AN HIVE. OR UNDER THEIR DIRECT SUPERVISION AS AN NSTRUMENT OF SERVICE AND IS INTENDED FOR USE ONLY ON THIS PROJECT. ALL DRAWINGS SPECIFICATIONS, AND DESIGNS, INCLUDING THE SPACES ARE PROTECTED BY COPYRIGHT REGISTERED CPG. INC. ANY REPRODUCTION. USE. C VITHOUT THE WRITTEN CONSENT FROM CPG. INC D/B/A SUMMIT HOMES EXCEPT AS REQUIRED FOR TRICTLY PROHIBITED.

ADDRESS:

A: 3743 SW CLAYTON PL B: 3745 SW CLAYTON PL

PROFESSIONAL SEAL



EVERSTEAD IS RESPONSIBLE FOR STRUCTURAL SPECIFICATIONS ONLY. ARCHITECTURAL PLANS WERE PRODUCED BY OTHERS.

EVERSTEAD 3741 NE TROON DRIVE SUITE 200 LEE'S SUMMIT, MO 64064 816-399-4901

> DRAWN BY: S. SCARBO

ISSUE DATE:

6.7.23

SHEET NUMBER:

AS NOTED FOR PLAN REVI

07/24/2023

GENERAL NOTES

WINDOWS TO COMPLY WITH IRC R312.2 FOR FALL PROTECTION.

ALL EXTERIOR WALLS, INTERIOR BEARING WALLS, AND INTERIOR BRACED WALLS ARE AT 16" O.C. UNLESS NOTED OTHERWISE.

ALL INTERIOR NON-LOAD BEARING, NON-BRACED, NON-CABINET WALLS ARE ALLOWED AT 24" O.C.

ROOF AND CEILING FRAMING ARE PRE-ENGINEERED WOOD TRUSSES UNLESS NOTED OTHERWISE.

DIMENSIONAL LUMBER IS LABELED PER INDUSTRY STANDARD TERMINOLOGY. ACTUAL LUMBER SIZING IS EXPECTED TO VARY

HVAC DUCTWORK RUNNING THROUGH THE ATTIC SPACE SHALL BE HUNG FROM ABOVE TO ALLOW COMPLETE


PROVIDE BLOCKING AT ALL CEILING JUMPS FOR INSULATION.

2X6 EXTERIOR WALL OVER 12' SHALL BE DOUGLAS FIR #2.

INSULATION SURROUND.

SMOKE AND CARBON MONOXIDE DETECTORS SHOW ON PLANS ARE TO BE CONSIDERED RECOMMENDATIONS ONLY. FINAL PLACEMENT IS TO BE DETERMINED BY MUNICIPAL REQUIREMENTS.

WINDOW SIZES ARE WRITTEN IN FEET AND INCHES PER INDUSTRY STANDARDS. EX: 3050 SH = 3'-0" X 5'-0" SINGLE HUNG, 3066 FIX = 3'-0" X 6'-6" FIXED.

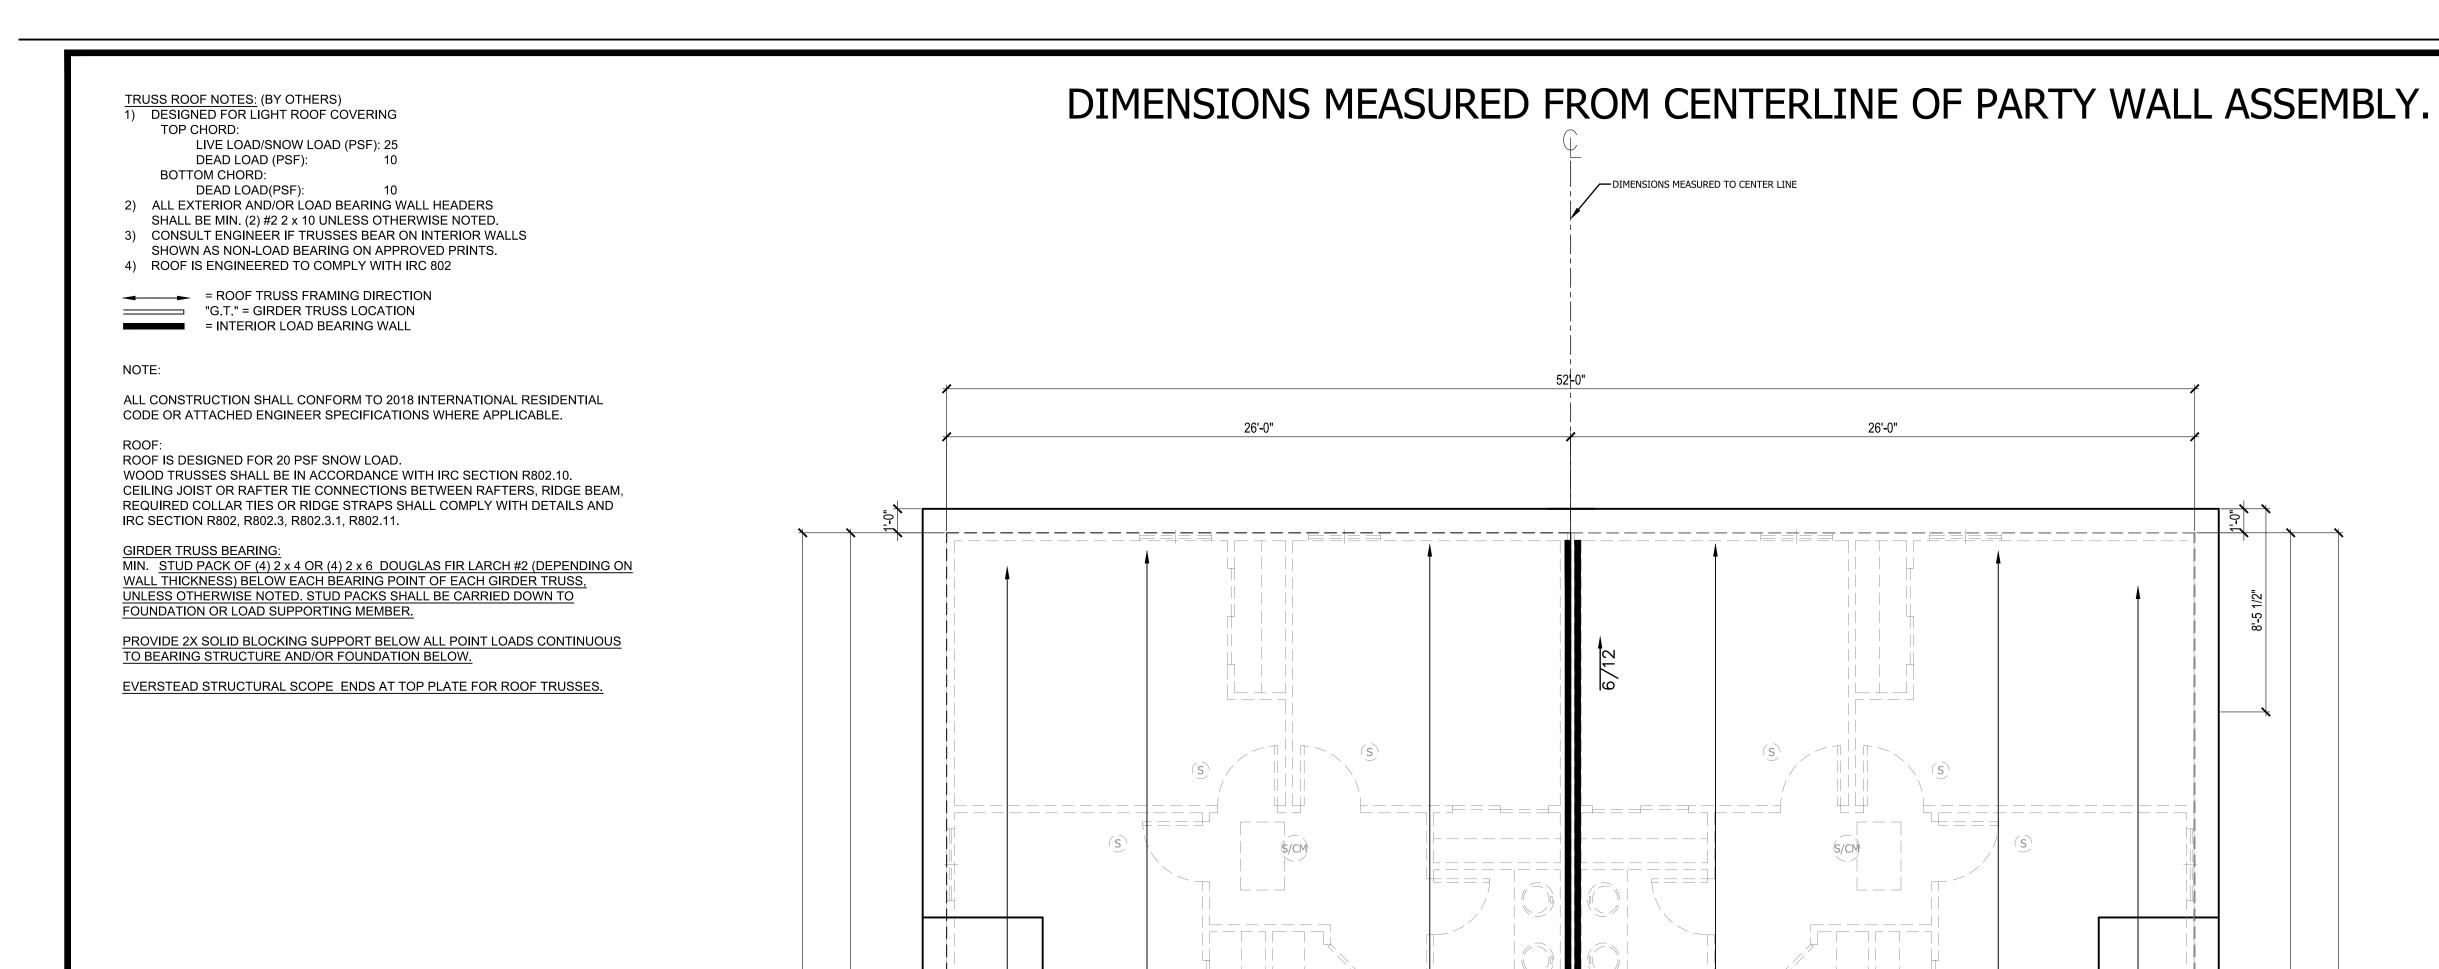

S/CM

====

GT. BEARING—— DFL#2 TOP PLATE

UNDER GT BRO

DFL#2 TOP PLATE

_8/12

UNDER GT BRG

∕−G.T. BEARING

DFL #2 TOP PLATE UNDER GT BRG

7'-4"

5'-0"

−Ø.T. BEARING

26'-0"

DFL#2 TOP PLATE

UNDER GT BRG

ROOF PLAN NOTES

- 4.11 MINIMUM ROOFING COMPOSITION- 30 YR COMPOSITE SHINGLES ON 15# FELT ON 1/2" OSB SHEATHING OR AS REQUIRED BY CODE.
- 4.31 BUILD CRICKET VALLEY AWAY FROM INTERSECTION FOR POSITIVE DRAINAGE.



120 SE 30TH ST. LEE'S SUMMIT, MO 64082


816-246-6700

COPYRIGHT 2020 THIS DRAWING HAS BEEN PREPARED BY CLOVER AND HIVE. OR UNDER THEIR DIRECT SUPERVISION AS AN INSTRUMENT OF SERVICE AND IS INTENDED FOR USE ONLY ON THIS PROJECT. ALL DRAWINGS SPECIFICATIONS, AND DESIGNS, INCLUDING THE OVERALL LAYOUT, FORM, AND COMPOSITION OF SPACES ARE PROTECTED BY COPYRIGHT REGISTERED TO CPG. INC. ANY REPRODUCTION. USE. DISCLOSURE OF THE INFORMATION CONTAINED HERE WITHOUT THE WRITTEN CONSENT FROM CPG. INC D/B/A SUMMIT HOMES EXCEPT AS REQUIRED FOR STRICTLY PROHIBITED.

ADDRESS:

A: 3743 SW CLAYTON PL B: 3745 SW CLAYTON PL

PROFESSIONAL SEAL

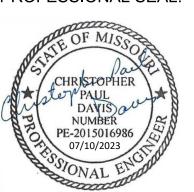

EVERSTEAD IS RESPONSIBLE FOR STRUCTURAL SPECIFICATIONS ONLY. ARCHITECTURAL PLANS WERE PRODUCED BY OTHERS.

EVERSTEAD 3741 NE TROON DRIVE SUITE 200 LEE'S SUMMIT, MO 64064 816-399-4901

> DRAWN BY: S. SCARBO

ISSUE DATE: 6.7.23

SHEET NUMBER:

PROVIDE BLOCKING AT ALL CEILING JUMPS FOR INSULATION.

PROVIDE FOAM INSULATION AT EXTERIOR WHERE MAIN LEVEL ROOF LINE MEETS UPPER LEVEL WALLS.

GENERAL NOTES

INTERSECTIONS.

NEAR TOP.

ROOF AND CEILING FRAMING ARE PRE-ENGINEERED ROOF

VENT EACH ENCLOSED ATTIC SPACE. NET AREA OPENING = 1/50TH OF VENTED AREA OR 1/300TH IF 580% OF VENTING

BUILD CRICKET VALLEY AWAY FROM INTERSECTION FOR

POSITIVE DRAINAGE. SEE FRAMING SPECIFICATIONS FOR

DIMENSIONAL LUMBER IS LABELED PER INDUSTRY STANDARD TERMINOLOGY. ACTUAL LUMBER SIZING IS EXPECTED TO VARY

HVAC DUCTWORK RUNNING THROUGH ATTIC SHALL BE HUNG FROM ABOVE TO ALLOW COMPLETE INSULATION SURROUND.

ASPHALT SHINGLES MIN 2/12. FLASH ALL PENETRATIONS AND

ASSEMBLY OPTIONS:

GYPSUM BOARD:

GYPSUM BOARD: ONE LAYER 1/2" THICK GYPSUM BOARD (USG SHEETROCK BRAND GYPSUM PANELS)

WOOD STUDS: 2x4 WOOD STUDS, 24" O.C.

INSULATION: MIN. 3" GLASS FIBER BATT INSULATION IN CAVITY

AIR SPACE: 3/4" AIR SPACE
STEEL STUDS: 2" H-STUD, 24" O.C.


GYPSUM BOARD: TWO LAYER 1" THICK BY NOM. 2' WIDE GYPSUM LINER PANELS FRICTION FIT (UL TYPE SLX)

AIR SPACE: 3/4" AIR SPACE

WOOD STUDS: 2x4 WOOD STUDS, 24" O.C.

INSULATION: MIN. 3" GLASS FIBER BATT INSULATION IN CAVITY

ONE LAYER 1/2" THICK GYPSUM BOARD (USG SHEETROCK BRAND GYPSUM PANELS)

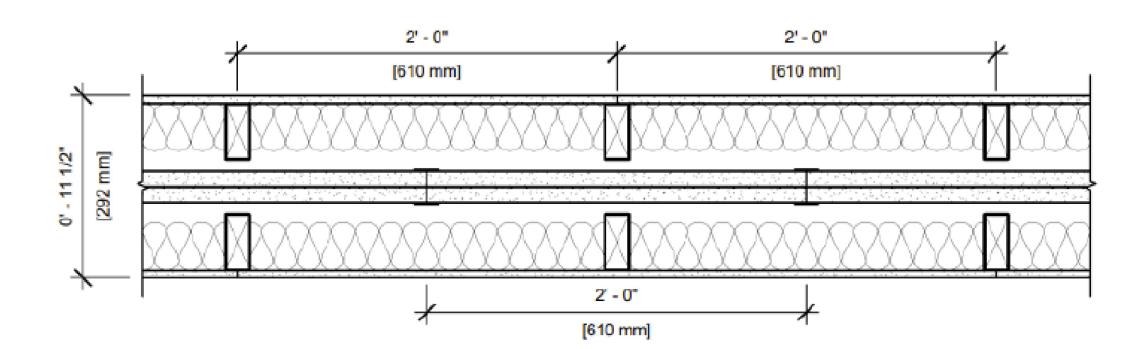


Intermediate Floor

two 2" USG

C-runners -

3/8" Type S

pan head screw -

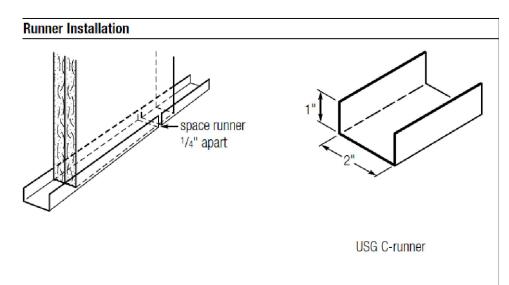

UL DESIGN NO. U336 B

FIRE RATING:


SOUND TEST:


SYSTEM THICKNESS:


2 HOUR

11 1/2"

RAL-TL88-350

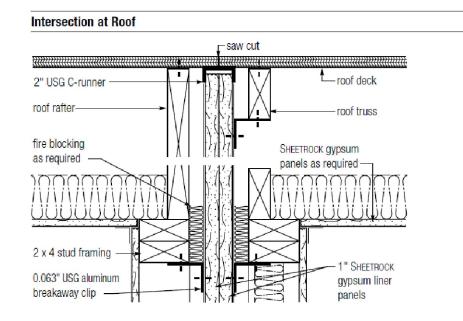


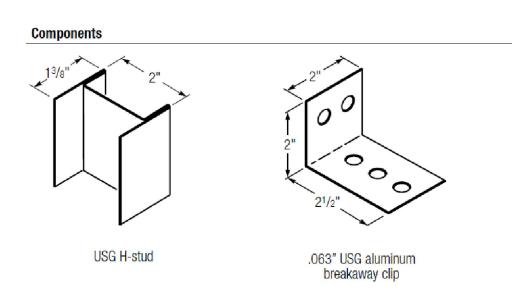


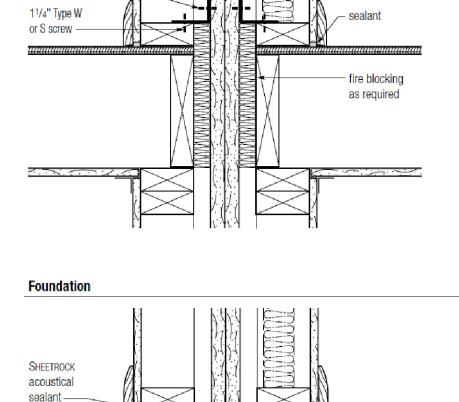



sound insulation

(optional)

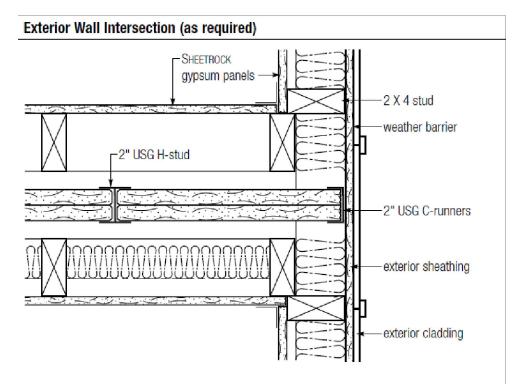

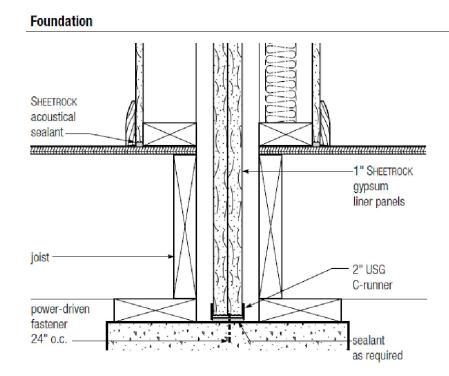

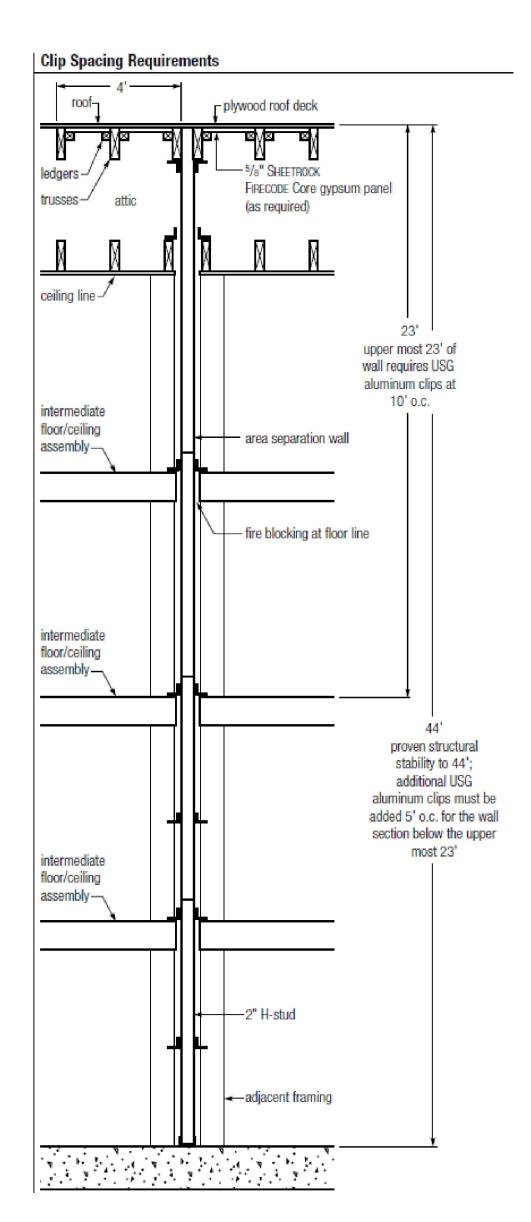

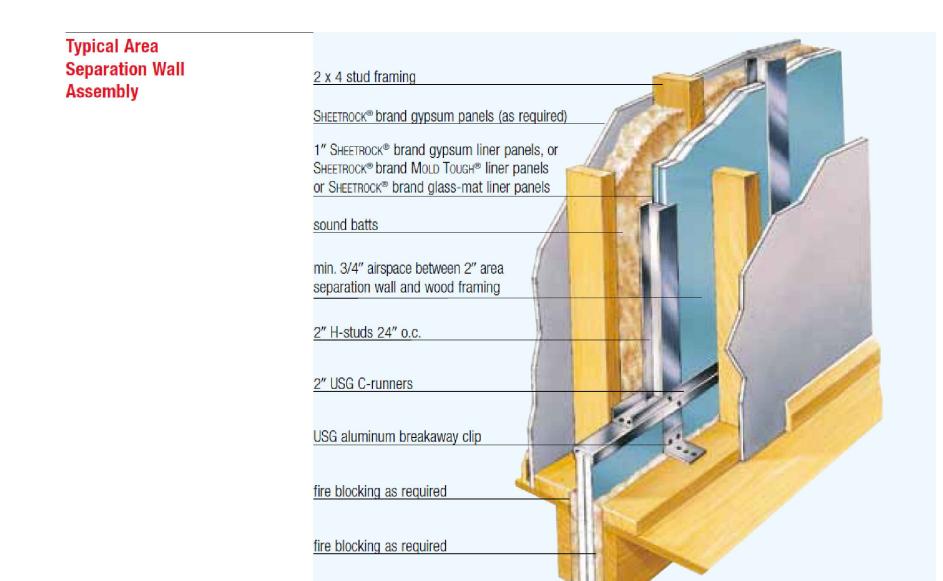

SG AREA SEPARATION WALL

GENERAL NOTES

ROOF AND CEILING FRAMING ARE PRE-ENGINEERED ROOF

ASPHALT SHINGLES MIN 2/12. FLASH ALL PENETRATIONS AND INTERSECTIONS.

VENT EACH ENCLOSED ATTIC SPACE. NET AREA OPENING = 1/50TH OF VENTED AREA OR 1/300TH IF 580% OF VENTING NEAR TOP.

BUILD CRICKET VALLEY AWAY FROM INTERSECTION FOR POSITIVE DRAINAGE. SEE FRAMING SPECIFICATIONS FOR

DIMENSIONAL LUMBER IS LABELED PER INDUSTRY STANDARD TERMINOLOGY. ACTUAL LUMBER SIZING IS EXPECTED TO VARY PER VENDOR.

HVAC DUCTWORK RUNNING THROUGH ATTIC SHALL BE HUNG FROM ABOVE TO ALLOW COMPLETE INSULATION SURROUND.

PROVIDE BLOCKING AT ALL CEILING JUMPS FOR INSULATION.

PROVIDE FOAM INSULATION AT EXTERIOR WHERE MAIN LEVEL ROOF LINE MEETS UPPER LEVEL WALLS.

120 SE 30TH ST.
LEE'S SUMMIT, MO 64082
816-246-6700

COPYRIGHT 2020

THIS DRAWING HAS BEEN PREPARED BY CLOVER AND HIVE, OR UNDER THEIR DIRECT SUPERVISION AS AN INSTRUMENT OF SERVICE AND IS INTENDED FOR USE ONLY ON THIS PROJECT. ALL DRAWINGS SPECIFICATIONS, AND DESIGNS, INCLUDING THE OVERALL LAYOUT, FORM, AND COMPOSITION OF SPACES ARE PROTECTED BY COPYRIGHT REGISTERED.


clover

INSTRUMENT OF SERVICE AND IS INTENDED FOR USE ONLY ON THIS PROJECT. ALL DRAWINGS, SPECIFICATIONS, AND DESIGNS, INCLUDING THE OVERALL LAYOUT, FORM, AND COMPOSITION OF SPACES ARE PROTECTED BY COPYRIGHT REGISTERED TO CPG, INC. ANY REPRODUCTION, USE, OR DISCLOSURE OF THE INFORMATION CONTAINED HEREIN WITHOUT THE WRITTEN CONSENT FROM CPG, INC. D/B/A SUMMIT HOMES EXCEPT AS REQUIRED FOR BIDDING AND CONSTRUCTION OF THIS PROJECT IS STRICTLY PROHIBITED.

ADDRESS:
A: 3743 SW CLAYTON PL
B: 3745 SW CLAYTON PL

OSAGE #49
TWIN HONEYDEW

PROFESSIONAL SEAL:

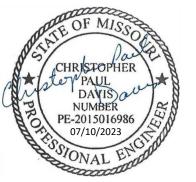

EVERSTEAD IS RESPONSIBLE FOR STRUCTURAL SPECIFICATIONS ONLY. ARCHITECTURAL PLANS WERE PRODUCED BY OTHERS.

EVERSTEAD 3741 NE TROON DRIVE SUITE 200 LEE'S SUMMIT, MO 64064 816-399-4901

> DRAWN BY: S. SCARBO

ISSUE DATE: 6.7.23

SHEET NUMBER:

RELEASE FOR CONSTRUCTION
AS NOTED FOR PLAN REVIEW
DEVELOPMENT SERVICES


UL/cUL SYSTEM NO. W-L-1406

METAL PIPE THROUGH GYPSUM WALL ASSEMBLY

F-RATING = 2-HR. T-RATING = 0-HR.

L-RATING AT AMBIENT = LESS THAN 1 CFM / SQ FT

L-RATING AT 400°F = LESS THAN 4 CFM / SQ FT

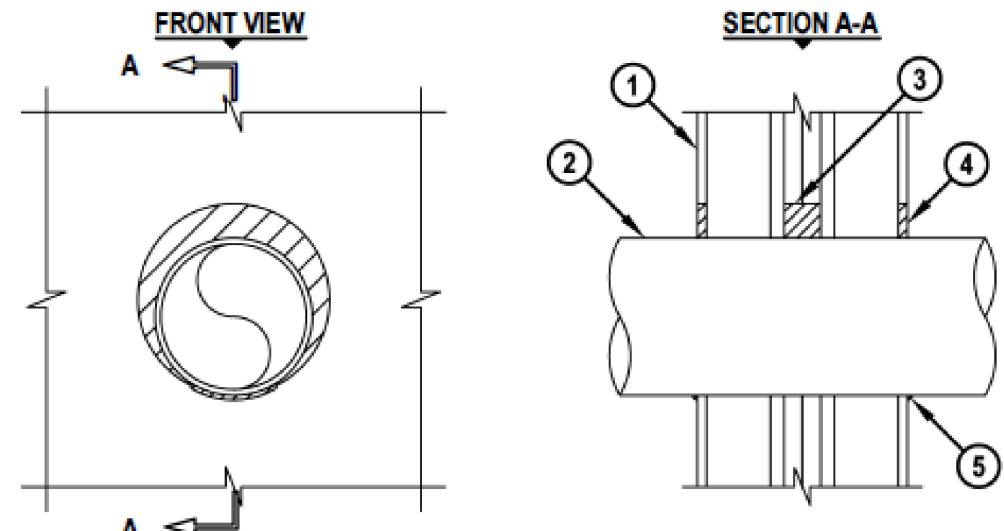

- 1. GYPSUM WALL ASSEMBLY (UL/cUL CLASSIFIED U300 SERIES) (2-HR. FIRE-RATING) CONSISTING OF THE FOLLOWING:
 - A. NOMINAL 2 x 4 STUDS SPACED MAXIMUM 24" OC.
 - B. STEEL "H" SHAPED STUDS SPACED MAXIMUM 24" OC.
 - C. TWO LAYERS 1" GYPSUM SHAFT LINER PANELS.
 - D. MINIMUM 1/2" THICK GYPSUM WALLBOARD.
- 2. PENETRATING ITEM TO BE ONE OF THE FOLLOWING:
- A. MAXIMUM 8" NOMINAL DIAMETER STEEL PIPE (SCHEDULE 5 OR HEAVIER).
- B. MAXIMUM 8" NOMINAL DIAMETER CAST OR DUCTILE IRON PIPE.
- C. MAXIMUM 4" NOMINAL DIAMETER COPPER PIPE OR TUBING.
- D. MAXIMUM 6" NOMINAL DIAMETER STEEL CONDUIT.
- E. MAXIMUM 4" NOMINAL DIAMETER EMT.
- 3. MINIMUM 2" DEPTH FS-ONE MAX OR FS-ONE INTUMESCENT FIRESTOP SEALANT APPLIED WITHIN GYPSUM SHAFT LINER PANELS.
- 4. MINIMUM 1/2" DEPTH FS-ONE MAX OR FS-ONE INTUMESCENT FIRESTOP SEALANT APPLIED FLUSH WITH OUTER SURFACES OF GYPSUM WALLBOARD.
- 5. MINIMUM 1/4" BEAD FS-ONE MAX OR FS-ONE INTUMESCENT FIRESTOP SEALANT APPLIED AT POINT OF CONTACT AT OUTER SURFACE OF GYPSUM WALLBOARD.


NOTES: 1. MAXIMUM DIAMETER OF OPENING = 10-1/2".

2. ANNULAR SPACE = MINIMUM 0", MAXIMUM 1-7/8".

UL SYSTEM NO. W-L-2472

PLASTIC PIPE THROUGH GYPSUM WALL ASSEMBLY

F-RATING = 2-HR. T-RATING = 2-HR.

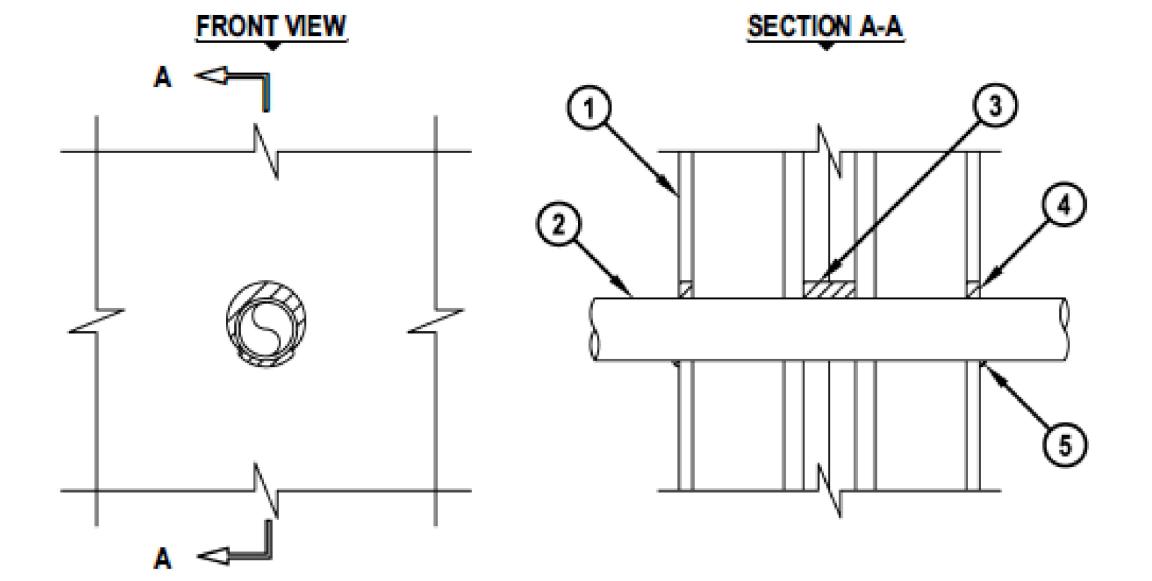

- 1. GYPSUM WALL ASSEMBLY (UL CLASSIFIED U300 SERIES) (2-HR. FIRE-RATING) CONSISTING OF THE FOLLOWING:
- A. NOMINAL 2 x 4 STUDS SPACED MAXIMUM 24" OC.
- B. STEEL "H" SHAPED STUDS SPACED MAXIMUM 24" OC.
- C. TWO LAYERS 1" GYPSUM SHAFT LINER PANELS.
- D. MINIMUM 1/2" THICK GYPSUM WALLBOARD.
- 2. PENETRATING ITEM TO BE ONE OF THE FOLLOWING: A. MAXIMUM 2" NOMINAL DIAMETER PVC PLASTIC PIPE (CELLULAR OR SOLID CORE).
 - B. MAXIMUM 2" NOMINAL DIAMETER CPVC PLASTIC PIPE (CLOSED PIPING SYSTEM ONLY).
 - C. MAXIMUM 2" NOMINAL DIAMETER RNC-PVC CONDUIT.
- 3. MINIMUM 2" DEPTH FS-ONE MAX OR FS-ONE INTUMESCENT FIRESTOP SEALANT APPLIED WITHIN GYPSUM SHAFT LINER PANELS.
- 4. MINIMUM 1/2" DEPTH FS-ONE MAX OR FS-ONE INTUMESCENT FIRESTOP SEALANT APPLIED FLUSH WITH OUTER SURFACES OF GYPSUM WALLBOARD.
- 5. MINIMUM 1/4" BEAD FS-ONE MAX OR FS-ONE INTUMESCENT FIRESTOP SEALANT APPLIED AT POINT OF CONTACT AT OUTER SURFACE OF GYPSUM WALLBOARD.

NOTES: 1. MAXIMUM DIAMETER OF OPENING = 3".

- 2. ANNULAR SPACE = MINIMUM 0", MAXIMUM 5/8".
- CLOSED OR VENTED PIPING SYSTEM (PVC, RNC = SCHEDULE 40; CPVC = SDR 13.5).

GENERAL NOTES

ROOF AND CEILING FRAMING ARE PRE-ENGINEERED ROOF

ASPHALT SHINGLES MIN 2/12. FLASH ALL PENETRATIONS AND

VENT EACH ENCLOSED ATTIC SPACE. NET AREA OPENING = 1/50TH OF VENTED AREA OR 1/300TH IF 580% OF VENTING

BUILD CRICKET VALLEY AWAY FROM INTERSECTION FOR POSITIVE DRAINAGE. SEE FRAMING SPECIFICATIONS FOR DETAILS.

DIMENSIONAL LUMBER IS LABELED PER INDUSTRY STANDARD TERMINOLOGY. ACTUAL LUMBER SIZING IS EXPECTED TO VARY

HVAC DUCTWORK RUNNING THROUGH ATTIC SHALL BE HUNG FROM ABOVE TO ALLOW COMPLETE INSULATION SURROUND.

PROVIDE BLOCKING AT ALL CEILING JUMPS FOR INSULATION

PROVIDE FOAM INSULATION AT EXTERIOR WHERE MAIN LEVEL ROOF LINE MEETS UPPER LEVEL WALLS.

HIVE. OR UNDER THEIR DIRECT SUPERVISION AS A SPECIFICATIONS. AND DESIGNS. INCLUDING D/B/A SUMMIT HOMES EXCEPT AS REQUIRED FO A: 3743 SW CLAYTON PL B: 3745 SW CLAYTON PL

CPG DBA

clover

120 SE 30TH ST LEE'S SUMMIT, MO 64082 816-246-6700

PROFESSIONAL SEAL



STRUCTURAL SPECIFICATIONS ONLY. ARCHITECTURAL PLANS WERE PRODUCED BY OTHERS.

EVERSTEAD 3741 NE TROON DRIVE SUITE 200 LEE'S SUMMIT, MO 64064 816-399-4901

> **DRAWN BY:** S. SCARBO

ISSUE DATE: 6.7.23

SHEET NUMBER:

AS NOTED FOR PLAN RE

GENERAL NOTES

PLANS SHALL COMPLY WITH THE 2018 INTERNATIONAL RESIDENTIAL CODE (IRC) WITH AMENDMENTS AS ADOPTED BY THE APPROPRIATE GOVERNING JURISDICTION. THE CONTRACTOR SHALL NOTIFY THE ENGINEER OF RECORD IF ANY CHANGES OR DEVIATIONS FROM THE PLAN ARE MADE DURING CONSTRUCTION. THE ENGINEER OF RECORD MAY REQUIRE REVISED DRAWING OR CALCULATIONS AT ITS DISCRETION.

IF DISCREPANCIES ARE IDENTIFIED THE MOST CONSERVATIVE SPECIFICATION SHALL APPLY.

<u>LOADING</u>

L	IGHT ROOF	10 PSF	
H	HEAVY ROOF	+10 PSF	(CONCRETE, SLATE, TILE
F	ROOF + CEILING (NO STORAGE)	15 PSF	
F	ROOF + CEILING (STORAGE)	20 PSF	
(CEILING JOISTS (STORAGE)	10 PSF	
E	EXTERIOR BACONIES / DECK	10 PSF	
I	NTERIOR FLOOR (MAIN FLOOR)	15 PSF	
	NTERIOR FLOOR (UPPER FLOORS)	10 PSF	
8	B" THICK MASONRY WALL	80 PSF	
6	S" THICK MASONRY WALL	85 PSF	
E	EXTERIOR LIGHT FRAMED WOOD WALLS	15 PSF	
I	NTERIOR LIGHT FRAMED WOOD WALLS	10 PSF*	
	*(INTERIOR WALLS	INCLUDED IN 1	5 PSF DEAD LOAD)

LIVE		
ROOF LIVE LOAD FLOOR LIVE LOAD GARAGE	20 PSF 40 PSF 50 PSF	(HABITABLE)
STORAGE GUARDRAII	20 PSF	(UN-INHABITABLE)
CONTINUOUS LINEAR MAXIMUM POINTLOAD	50 PLF 200 LBS	
SNOW		
GROUND SNOW LOAD	20 PSF	
WIND		
ULTIMATE DESIGN WIND SPEED VELOCITY	115 MPH	

SOIL AND SITE ASSUMPTIONS:

EXPOSURE CATEGORY

- . FOUNDATION DESIGN ASSUME A MINIMUM SOIL BEARING PRESSURE FOR THE SITE OF 1,500 PSF. CONTRACTOR TO VISUALLY INSPECT SITE OR PROVIDE GEOTECHNICAL INVESTIGATION TO VERIFY MINIMUM ACCEPTABLE SOIL CONDITIONS SW, SP, SM, SC, GM, AND GX AS DEFINED PER IRC TABLE R301.5. THE CONTRACTOR IS RESPONSIBLE FOR ANY SOIL CONDITION THAT DOES NOT MEET THE MINIMUM REQUIREMENTS AND CONTACTING THE ENGINEER OF RECORD.
- 2. PROVIDE A MINIMUM SOIL COVER OF $\underline{36}$ INCHES MEASURED FROM THE BOTTOM OF CONCRETE ON ALL FOUNDATIONS.
- ACCESSORY STRUCTURES WITH AN EAVE HEIGHT LESS THAN 10'-0" AND AN AREA LESS THAN 600 FT² MAT PROVIDE A MINIMUM SOIL COVER OF 12 INCHES MEASURED FROM THE BOTTOM OF CONCRETE.
- 4. SITE GRADING SHALL PROVIDE POSITIVE DRAINAGE AWAY FROM THE STRUCTURE AT A MINIMUM OF 0.5%.
- 5. LATERAL SOIL PRESSURES

 ACTIVE 30 PSF

 AT-REST 60 PSF

 PASSIVE 150 PSF

FOUNDATION NOTES:

FOUNDATION ANCHORAGE (IRC 403.1.6)

SILL PLATES SHALL BE BOLTED TO THE FOUNDATION WALL WITH A MINIMUM 1/2" DIAMETER ANCHOR BOLTS EMBEDDER AT LEAST 7" INTO THE CONCRETE. BOLTS SHALL BE SPACED NO GREATER THAN 6' 0.C. THERE SHALL BE A MINIMUM OF TWO BOLTS PER PLATE SECTION, WITH A BOLT PLACED WITHIN 12" AND NOT CLOSER THAN 7 BOLT DIAMETERS, OF THE END OF EACH PLATE SECTION. A PROPERLY SIZED NUT AND WASHER SHALL BE TIGHTENED ON EACH BOLT TO THE PLATE, (NOTE: 7" EMBEDMENT + 1-1/2" SILL PLATE + 3/4" FOR NUT AND WASHER EXCEEDS A 9" LONG BOLT.)

WALL BRACING METHODS PER IRC R602 MAY REQUIRE ADDITIONAL ANCHORAGE.

CONCRETE SLABS PLACED ON FILL MATERIAL WHICH EXCEEDS 24" OF COMPACTED GRANULATED MATERIAL (SAND OR GRAVEL) OR 8" OF EARTH:

THIS MAY OCCUR AT GARAGE FLOOR FILLS, OR OVER EXCAVATED AREAS UNDER FLOOR SLABS. THE DESIGN AND INSTALLATION DETAILS IN THIS DOCUMENT (WHERE APPLICABLE BASED ON SIZE AND SPACING LIMITATIONS) MAY BE USED IN LIEU OF PROVIDING A SEPARATE DESIGN. STRUCTURAL SLABS EXCEEDING THE SPANS AND CONDITIONS OF THE APPROVED DETAILS SHALL BE DESIGNED BY A PROFESSIONAL ENGINEER.

SLABS AT MAX 4' OVER-DIG ADJACENT TO FOUNDATION WALL:
WHERE SOIL IS EXCAVATED FOR A MAXIMUM DIMENSION OF 4' HORIZONTALLY ADJACENT TO A
FOUNDATION WALL, THE STANDARD OVER-DIG DETAIL MAY BE USED IN LIEU OF A COMPLETE
STRUCTURAL SLAB. SEE "TYPICAL FOOTING/FOUNDATION WALL/STANDARD SLAB AT MAX 4' OVER-DIG
DIAGRAM FOR DETAILS.

VAPOR RETARDER / BARRIER (IRC R506.2.3)

A 6 MIL POLYETHYLENE OR APPROVED VAPOR RETARDER WITH JOINTS LAPPED A MINIMUM OF 6" IS REQUIRED BETWEEN THE CONCRETE FLOOR SLAB AND THE BASE COURSE OR PREPARED SUBGRADE, (NOT REQUIRED FOR GARAGE SLABS OR DETACHED ACCESSORY BUILDINGS)

FOUNDATION AND LOT GRADING (IRC R401.3)

GRADES SHALL BE SLOPED AWAY FROM THE FOUNDATION A MINIMUM OF 6" IN THE FIRST 10'. ALTERNATE APPROACHES MAY BE APPROVED IF THE ALTERNATE DESIGN IS EQUIVALENT IN EFFECTIVENESS AND PERFORMANCE, AND PROVIDES FOR POSITIVE SITE DRAINAGE.

IRC R403.1.4

- THE BOTTOM OF ALL FOOTINGS SHALL EXTEND NOT LESS THAN 36" BELOW GRADE FOR FROST

 DROTTOTION
- FOOTINGS FOR FREESTANDING ACCESSORY STRUCTURES WITH AN AREA OF 600 SF OR LESS AND AN EAVE HEIGHT OF 10' OR LESS SHALL EXTEND BELOW GRADE A MINIMUM OF 12".

FOOTINGS:

EXTERIOR WALLS, BEARING WALLS, COLUMN AND PIERS SHALL BE SUPPORTED ON CONTINUOUS SOLID MASONRY OR CONCRETE FOOTINGS, OR APPROVED STRUCTURAL SYSTEM TO SAFELY SUPPORT THE IMPOSED LOADS AND SHALL BE SIZED AND REINFORCED IN ACCORDANCE WITH THIS STANDARD OR SHALL BE ENGINEERED DESIGN. FOOTINGS UNDER FOUNDATION WALLS SHALL BE CONTINUOUS AROUND THE STRUCTURE AND FROM ONE LEVEL TO THE NEXT. THE CONTINUOUS TRANSITIONS BETWEEN FOOTINGS AT DIFFERENT LEVELS ENCLOSING USABLE SPACE SHALL BE MADE BY APPROVED SOLID JUMPS OR SUPPORT SYSTEMS TO PROVIDE SAFE SUPPORT OF THE STRUCTURE. SEE "TYPICAL FOOTING/FOUNDATION WALLS/STANDARD SLAB AT MAXIMUM 4" OVER-DIG AND "FOOTING JUMP" DIAGRAMS FOR MORE DETAIL (PER KC, MO STANDARDS)

CONCRETE

- 1. ALL CONCRETE CONSTRUCTION SHOULD CONFORM TO ACI 318-11 AND THE 2018 INTERNATIONAL RESIDENTIAL CODE.
- 2. THE MINIMUM CONCRETE 28 DAY COMPRESSIVE STRENGTH SHALL BE AS SPECIFIED IN IRC TABLE B402.2
- 3. CONCRETE MIX TO UTILIZE A MAXIMUM WATER-CEMENT MATERIALS RATIO OF 0.45 FOR ALL APPLICATIONS. ALL CONCRETE TO HAVE MAXIMUM 0.10 PERCENT WATER SOLUBLE CHLORIDE CONTENT BY WEIGHT OF CEMENT. ADMIXTURES SHALL NOT CONTAIN ANY CHLORIDES.
- 4. CONCRETE POURED AGAINST AN EXISTING SURGACE SHOULD BE ROUGHENED TO A MINIMUM 1/4 INCH AMPLITUDE.
- 5. REBAR CLEAR DISTANCE SHALL BE AS FOLLOWS:

 -CAST AGAINST AND PERMANENT CONTACT WITH GROUND3 IN

 -EXPOSED TO WEATHER OR IN CONTACT WITH GROUND 2 IN

 NOT EXPOSED TO WEATHER OR GROUND 1.5 IN
- 6. CONCRETE MIX DESIGN SHALL BE 6% (±1%) AIR-ENTRAINED FOR GARAGE SLABS, FOOTINGS, WALLS, OR FLATWORK EXPOSED TO WEATHER.
- 7. SHORING AND RESHORING:
 -SHORING AND SUPPORTING FORMWORK SHALL NOT BE REMOVED FROM HORIZONTAL MEMBERS
 BEFORE CONCRETE STRENGTH REACHES 70% OF STRENGTH DETERMINED BY CYLINDERS OR 28

DAYS.
-SHORING MAY NOT BE REMOVED SOONER THAN RECOMMENDED BY ASTM 374-04 SECTION 3.7.2.3.

MINIMUM STANDARDS

CONCRETE SHALL BE 6% (\pm 1%) AIR-ENTRAINED FOR GARAGE SLABS AND FOR ALL LOCATION'S FOOTINGS, WALLS OR FLATWORK WHERE EXPOSED TO WEATHER. REBAR SHALL BE MINIMUM 60 KSI UNLESS NOTED OTHERWISE. REINFORCING BAR SHALL BE GRADE 60 MINIMUM.

CONCRETE REINFORCEMENT STEEL

- 1. REINFORCING STEEL SHALL CONFORM TO ASTM A615, GRADE 60.
- 2. SMOOTH BARS OR WELDED WIRE FABRIC SHALL CONFORM TO ASTM 185.
- 3. ALL REBAR LAP SPLICES SHALL BE CLASS B LAP SPLICES AS SHOWN ON THE LAP SPLICE SCHEDULE.
- 4. DEVELOPMENT LENGTH NOTED IS EQUAL TO 80% OF THE LENGTH NOTED IN THE LAP SPLICE SCHEDULE.
- 5. 90% HOOK SHOWN IN DRAWINGS SHALL BE STANDARD PER ACI 318-14 -STRAIGHT EXTENSION LENGTH = $12x\emptyset_{BAR}$ -BEND DIAMETER = $12X\emptyset_{RAR}$
- 6. LAP SPLICE SCHEDULE (SEE TABLE 1.1)
- 7. HOOKED DOWELS:
- 7. HOOKED DOWELS:
 7.1. HOOKED DOWELS FROM FOUNDATIONS TO WALL SHALL BE PROVIDED TO MATCH VERTICAL WALL
- REINFORCING AND EXTENDED TO 3" CLEAR FROM BOTTOM OF FOUNDATION
 7.2. HOOKED DOWELS MATCH SLAB REINFORCING FROM SLAB TO WALLS OR SLAB TO FOUNDATION
- 8. PROVIDE 2 #5 BARS AROUND PERIMETER OF ALL SUSPENDED SLABS
- 9. HORIZONTAL WALL REINFORCING SHALL TERMINATE AT THE END OF THE WALL WITH A STANDARD HOOK
- 10. TOP AND BOTTOM HORIZONTAL REINFORCING SHALL BE PLACED 1-1/2" TO 2" FROM THE TOP AND BOTTOM OF THE WALL

FOOTNOTES:

- 1. WALL HEIGHT IS MEASURED FROM THE TOP OF THE WALL TO THE TOP OF THE FLOOR SLAB.
- VERTICAL REINFORCEMENT FOR CONCRETE WALLS THAT ARE NOT FULL HEIGHT AND FOR REINFORCEMENT SPACED 24" O.C. MAY BE PLACED IN THE MIDDLE OF THE WALL. OTHER WALLS SHALL HAVE VERTICAL REINFORCEMENT PLACE AS FOLLOWS:
 - A. 8" WALL MINIMUM 5" FROM THE OUTSIDE FACE.
 B. 10" WALL MINIMUM 6-3/4" FROM THE OUTSIDE FACE.
- C. EXTEND BARS TO WITHIN 8" OF THE TOP OF THE WALL.
- 3. HORIZONTAL REINFORCEMENT:
 - A. ONE BAR SHALL BE PLACED WITHIN 12" OF THE TOP OF THE WALL.
 - B. OTHER BARS SHALL BE EQUALLY SPACED WITH SPACING NOT TO EXCEED 24" O.C.C. HORIZONTAL BARS SHOULD BE AS CLOSE TO THE TENSION FACE AS POSSIBLE (INTERIOR); AND BEHIND THE VERTICAL REINFORCEMENT (I.E. 2" TOWARD THE INSIDE).
 - D. SUPPLEMENTAL REINFORCEMENT AT CORNERS PLACE 1 #4 REBAR 48" LONG AT 45 DEGREE ANGLE AT CORNERS OF OPENINGS. PLACE REINFORCEMENT WITHIN 6" OF THE EDGE OF INSIDE CORNERS.
- 4. REINFORCEMENT SHALL BE LAPPED A MINIMUM 24" AT ENDS, SPLICES, AND AROUND CORNERS.
- 5. AT MASONRY LEDGES THE MINIMUM WALL THICKNESS SHALL BE 3-1/2". LEDGES SHALL NOT EXCEED A DEPTH OF MORE THAN 24" BELOW THE TOP OF THE WALL FOR WALL THICKNESS LESS THAN 4" PROVIDE #4 BARS AT MAXIMUM 24" O.C. TO WITHIN 8" OF THE TOP OF THE WALL.
- 6. STRAIGHT WALLS MORE THAN 5' TALL AND MORE THAN 16' LONG SHALL BE PROVIDED WITH EXTERIOR BRACED RETURN WALLS. WALL LENGTH SHALL BE MEASURED USING INSIDE THE SHORTEST DIMENSION BETWEEN INTERSECTING WALLS (SEE TYPICAL DEAD MAN SECTION).

TABLE 1.1

NORMAL WEIGHT CONCRETE LAP SPLICE SCHEDULE, IN						
BAR	TOP	BARS	OTHER	R BARS		
SIZE	CASE 1	CASE 2	CASE 1	CASE 2		
#3	28	42	22	32		
#4	37	56	29	43		
#5	47	70	36	54		
#6	56	84	43	64		

STEEL DECK - SUSPENDED SLABS

- 1. STEEL DECK QUALITY, FABRICATION, DELIVERY, INSTALLATION AND ATTACHMENT SHALL COMPLY WITH THE PROVISIONS OF THE STEEL DECK INSTITUTE, SDI.
- 2. STEEL ROOF DECK SHALL BE AS FOLLOWS UNLESS NOTED OTHERWISE ON CONSTRUCTION
- DRAWINGS:

 WIDE RIB CONFIGURATION
- 1.5" DEPTH
- 24GA DESIGN THICKNESS
- MAXIMUM SINGLE SPAN OF 4'-8" OR CONTINUOUS SPAN OF 5'-10"
 GALVANIZE PER ASTM A653 OR SHOP PRIME PER ASTM A1008
- GALVANIZE PER ASTM A653 OR SHOP PRIME PER ASTM A1006
 ATTACH STEEL ROOF DECK TO SUPPORTS WITH #12 TEK AT 18" O.C.
- ATTACH STEEL ROOF DECK SIDELAPS WITH #10 TEK OR CRIMP/BUTTON PUNCH AT 36" O.C. OR MID-SPAN, WHICHEVER IS SMALLER
- 3. CONTRACTOR AND/OR DECK MANUFACTURER SHALL FURNISH ALL NECESSARY DECK CLOSURE ACCESSORIES TO PROVIDE A FINISHED SURFACE FOR THE APPLICATION OF ROOF INSULATION AND ROOF COVERING
- 4. STEEL FLOOR DECK SHALL BE AS FOLLOWS UNLESS NOTED OTHERWISE ON CONSTRUCTION DRAWINGS:

STEEL DECK - SUSPENDED SLABS
STEEL DECK QUALITY, FABRICATION, DELIVERY, INSTALLATION AND ATTACHMENT SHALL COMPLY WITH THE PROVISIONS OF THE STEEL DECK INSTITUTE, SDI.

CONTRACTOR AND/OR DECK MANUFACTURER SHALL FURNISH ALL NECESSARY DECK CLOSURE ACCESSORIES TO PROVIDE A FINISHED SURFACE FOR THE APPLICATION OF ROOF INSULATION AND ROOF COVERING.

STEEL FLOOR DECK SHALL BE AS FOLLOWS UNLESS NOTED OTHERWISE ON CONSTRUCTION DRAWINGS:

- 2" COMPOSITE DECK WITH 6" TOTAL SLAB THICKNESS
 19GA DESIGN THICKNESS
- 19GA DESIGN THICKNESS
 MAXIMUM SINGLE SPAN DURING CONSTRUCTION OF 8', 2 SPAN OF 10'-1", OR 3 SPAN OF 10'-5".
- MAXIMUM SPAN SHALL NOT EXCEED 12.5'.
 PROVIDE W2.1xW2.1 WELDED WIRE MESH OR #4 @ 12" O.C. EACH WAY. PROVIDE 2" REBAR COVER MEASURED FROM TOP OF THE SLAB
- GALVANIZE PER ASTM A653
- MINIMUM BEARING LENGTH AT EDGE SUPPORTS IS 2"
- MINIMUM BEARING LENGTH AT INTERIOR SUPPORTS IS 4"
 ATTACH STEEL COMPOSITE FLOOR DECK TO SUPPORTS WITH 5/8" ARC PUDDLE WELDS AT 12"
 O.C. MECHANICAL FASTENERS EITHER POWDER ACTUATED, PNEUMATICALLY DRIVEN, OR
- SCREWS MAY BE USED IN LIEU OF WELDING PROVIDED THEY ARE APPROVED.

 ATTACH STEEL ROOF DECK SIDELAPS WITH #10 TEK OR CRIMP/BUTTON PUNCH AT 36" O.C. OR MID SPAN WHICHEVER IS SMALLED.

MID-SPAN, WHICHEVER IS SMALLER.
CONTRACTOR AND/OR DECK MANUFACTURER SHALL FURNISH ALL NECESSARY POUR STOPS, COLUMN CLOSURES, END PLATES, AND COVER PLATES AS NEEDED.

STRUCTURAL STEEL

- 1. STEEL DESIGN, FABRICATION, AND ERECTION SHALL CONFORM WITH AMERICAN INSTITUTE OF STEEL CONSTRUCTION.
- 2. STEEL GRADE AND SPECIFICATION SHALL BE AS FOLLOWS:

 HOLLOW STRUCTURAL SECTIONS:

 CHANNELS, PLATES AND ANGLES:

 WIDE FLANGES:

 ASTM A500 (Fy = 46 KSI)

 ASTM A36 (Fy = 36 KSI)

 ASTM A992 (Fy = 50 KSI)
- ANCHOR RODS:

3. BOLTS SHALL CONFORM TO ASTM A307

COLUMNS:

- 4. WELDING SHALL CONFORM TO THE AWS CODES FOR BUILDING CONSTRUCTION. WELDING SHALL BE PERFORMED IN ACCORDANCE TO WELDING PROCEDURE SPECIFICATION (WPS) AS REQUIRED IN AWS D1.1 THE WPS VARIABLES SHALL BE WITHIN THE PARAMETERS ESTABLISHED BY THE FILLER-METAL MANUFACTURER.
- 5. WELDS SHALL USE E70XX ELECTRODES AND A MINIMUM OR 3/16" SIZE UNLESS NOTED OTHERWISE.
- 6. ALL WELDS SPECIFIED AS FIELD WELDS MAY BE SHOP WELDED AT THE CONTRACTOR'S OPTION IF ERECTION CAN STILL BE EXECUTED.

ENERGY REQUIREMENTS:

- 1. LIGHTING FIXTURES PENETRATING THE THERMAL ENVELOPE SHALL BE IC-RATED, LEAKAGE RATED, AND SEALED TO THE GYPSUM WALLBOARD AS REQUIRED PER IRC N1102.4.4.
- 2. PROGRAMMABLE THERMOSTATS SHALL BE INSTALLED AS REQUIRED PER N1103.1.1.
- 3. AIR HANDLERS SHALL BE RATED FOR MAXIMUM 2% AIR LEAKAGE RATE PER N1103.3.2.1.
- 4. BUILDING FRAMING CAVITIES SHALL NOT BE USED AS DUCTS OR PLENUMS.
- 5. HOT WATER PIPES SHALL BE INSULATED AS REQUIRED PER N1103.4.
- 6. ALL EXHAUST FANS SHALL TERMINATE TO THE BUILDING EXTERIOR AS REQUIRED PER IRC M1504.3.
- 7. MAKEUP AIR SYSTEMS SHALL BE INSTALLED FOR KITCHEN EXHAUST HOODS THAT EXCEED 400 CFM AS REQUIRED PER M1503.6.
- 8. AN AIR HANDLING SYSTEM SHALL NOT SERVE BOTH THE LIVING SPACE AND THE GARAGE PER M1601.6 ENERGY CONSERVATION.

GARAGES:

- 1. THE GARAGE FLOOR SHALL SLOPE TOWARDS THE GARAGE DOORWAYS.
- 2. DOORS BETWEEN THE GARAGE AND THE DWELLING MINIMUM 1-3/8" SOLID CORE OR HONEY COMBED STEEL DOOR OR 20 MINUTE FIRE RATED.
- 3. THE GARAGE SHALL BE SEPARATED FROM THE DWELLING AND IT'S ATTIC AREAS BY A MINIMUM 5/8" GYPSUM BOARD APPLIED TO THE GARAGE SIDE WHERE A FLOOR/CEILING SPACE IS PROVIDED
- 4. THE GARAGE COLUMNS AND BEAMS SUPPORTING THE SEPARATION SHALL ALSO BE PROTECTED WITH 5/8" GYPSUM BOARD OR EQUIVALENT. WHERE HABITABLE SPACE OCCURS ABOVE THE GARAGE THE FLOOR CEILING ASSEMBLY SHALL BE PROTECTED WITH A MINIMUM PS TYPE "X" GYPSUM BOARD ON THE GARAGE CEILING.
- 5. GARAGE DOOR AND FRAME THE "H" FRAME FOR THE ATTACHMENT OF THE TRACK AND COUNTER BALANCE SHALL CONSIST OF THE FOLLOWING 2x6 VERTICAL JAMBS RUNNING FROM THE FLOOR TO CEILING, ATTACHED WITH 1-3/4"x0.120" NAILS AT 7" O.C. STAGGERED WITH (7) 3-1/4"x0.120" NAILS THROUGH THE JAMB INTO THE HEADER. A MINIMUM OF 2x8 HEADER FOR ATTACHMENT OF COUNTER BALANCE SYSTEM.
- 6. SELF CLOSING DEVICES SHALL BE INSTALLED FOR GARAGE AND/OR DWELLING SEPARATION DOORS
- 7. GARAGE VEHICLE DOORS AND FRAMES SHALL BE DESIGNED AND INSTALLED TO MEET THE 90 MPH WIND LOAD REQUIREMENTS OF DASMA 108 AND ASTM E330-96 (IRC 301.2.1).

STAIRWAYS:

ASTM A53 GR. B (Fy= 35 KSI)

ASTM F1554 (Fy = 36 KSI)

- 1. STAIRWAYS SHALL PROVIDE A MAXIMUM 7-3/4" RISE AND A MINIMUM 10" RUN.
- PROVIDE GUARD RAILS BETWEEN 36" GUARD RAILS ON THE OPEN SIDES OF RAISED FLOORS, PORCHES AND BALCONIES; MINIMUM 34" GUARD RAILS ON THE OPEN SIDES OF STAIRWAYS LOCATED MORE THAN 30" ABOVE THE FLOOR OR GRADE BELOW.
- 3. GUARD RAIL ENCLOSURES SHALL HAVE INTERMEDIATE RAILS OF ORNAMENTAL PATTERNS THAT DO NOT ALLOW PASSAGE OF A SPHERE 4" IN DIAMETER.
- 4. EACH STAIRWAY OF THREE OR MORE RISERS SHALL PROVIDE A CONTINUOUS HANDRAIL ON AT LEAST ONE SIDE BETWEEN 34" AND 38" ABOVE THE NOSING OF THE TREADS.
- 5. HANDRAILS SHALL HAVE A CIRCULAR CROSS SECTION OF 1-1/4" TO 2-5/8" OR OTHER APPROVED GRASPABLE SHAPE PER IRC R311.5.6.
- 6. MINIMUM 6'-8" OF HEADROOM CLEARANCE IS REQUIRED IN STAIRWAYS.
- 7. ENCLOSED ACCESSIBLE SPACE UNDER STAIRWAYS SHALL HAVE WALLS AND THE UNDERSIDE OF THE STAIR AND LANDING PROTECTED WITH 1/2" GYPSUM BOARD ON ENCLOSURE SIDE PER IRC R311.2.2.

GLAZING

- 1. GLAZING IN HAZARDOUS LOCATIONS AS IDENTIFIED IN IRC R308.4 SHALL BE OF APPROVED SAFETY GLAZING MATERIALS; GLASS IN STORM DOORS; INDIVIDUAL FIXED OR OPENABLE PANELS ADJACENT TO A DOOR WHERE THE NEAREST VERTICAL EDGE IS WITHIN A 24" ARCH OF THE DOOR IN A CLOSED POSITION AND WHOSE BOTTOM EDGE IS WITHIN 60" OF THE FLOOR; WALLS ENCLOSING STAIRWAYS AND LANDINGS WHERE THE GLAZING IS WITHIN 60" OF THE TOP OR BOTTOM OF THE STAIR; ENCLOSURES FOR SPAS, TUBS, SHOWERS, AND WHIRLPOOLS; GLAZING IN FIXED OR OPENABLE PANELS EXCEEDING 8 SF AND WHOSE BOTTOM EDGE IS LESS THAN 18" ABOVE THE FLOOR OR WALKING SURFACE WITHIN 36".
- 2. WINDOW FALL PROTECTION SHALL BE PROVIDED IN ACCORDANCE WITH R312.2.

EMERGENCY EGRESS AND RESCUE

- 1. PROVIDE ONE WINDOW FROM EACH BEDROOM THAT HAS A MINIMUM OPENABLE AREA OF 5.7 SF WITH A MINIMUM OPENABLE HEIGHT OF 24" AND WIDTH OF 21"
- 2. BASEMENT EGRESS TO MEET THE REQUIREMENTS OF IRC R310.
- 3. PROVIDE SMOKE ALARMS IN EACH SLEEPING ROOM, OUTSIDE OF EACH SLEEPING AREA AND ON EACH FLOOR INCLUDING BASEMENTS. ALARMS SHALL BE INTERCONNECTED IN SUCH A MANNER THAT THE ACTUATION OF ONE ALARM WILL ACTIVATE ALL OF THE ALARMS IN THE DWELLING.
- 4. CARBON MONOXIDE DETECTORS SHALL BE INSTALLED AS REQUIRED PER R315.

FRAMING NOTES:

- 1. ALL LUMBER SIZES ARE DOUGLAS FIR-LARCH #2 UNLESS OTHERWISE NOTED.
- 2. ALL UNMARKED HEADERS SHALL BE A MINIMUM #2 DOUGLAS FIR LARCH (2) 2x10 ON LOAD BEARING WALLS
- 3. ALL HEADER/BEAMS TO BEAR ON A MINIMUM OF (2) 2x4 POSTS UNLESS NOTED OTHERWISE.
- 4. DOUBLE JOIST UNDER INTERIOR NON-LOAD BEARING WALLS.

ATTACHED TO) SHALL BE OF DECAY RESISTANT MATERIAL.

- 5. CANTILEVERS, OVER BEAMS, AND DOOR JAMBS SHALL BE BLOCKED
- 6. ANY WOOD MEMBERS IN CONTACT WITH CONCRETE OR MASONRY (OR THE FURRING THEY ARE
- 7. INTERIOR NON LOAD BEARING WALLS SHALL BE ISOLATED FROM THE FLOOR FRAMING ABOVE UNLESS THE INTERIOR NON LOAD BEARING WALL RESTS DIRECTLY ON A FOOTING.
- 8. LVL STRENGTH SHALL BE VERSA-LAM 3100 Fb UNLESS NOTED OTHERWISE.

EVERSTEAD ENGINEERING & DESIGN

EVERSTEAD
WWW.EVERSTEAD.COM
3741 NE TROON DR
SUITE 200
LEES SUMMIT, MO 64064
(816) 399-4901



GENERAL NOT

SHEET #

GN1.0

ITEM	DESCRIPTION OF BUILDING	NI IMBED AND TYPE OF EASTENED	SPACING AND LOCATION
ı⊏IVI	ELEMENTS	NUMBER AND TYPE OF FASTENER	SPACING AND LOCATION
		ROOF 4-8D BOX (2-1/2"x0.113") OR	
1	BLOCKING BETWEEN CEILING JOISTS OR RAFTERS TO TOP PLATE	3-8D COMMON (2-1/2" x 0.131"); OR 3-10D BOX (3" x 0.128"); OR 3-3" x 0.131" NAILS	TOE NAIL
2	CEILING JOSTS TO TOP PLATE	4-8D BOX (2-1/2"x0.113") OR 3-8D COMMON (2-1/2" x 0.131"); OR 3-10D BOX (3" x 0.128"); OR 3-3" x 0.131" NAILS	PER JOIST, TOE NAIL
3	CEILING JOISTS NOT ATTACHED TO PARALLEL RAFTER LAPS OVER PARTITIONS	4-10D BOX (3" X 0.128"); OR 3-16D COMMON (3-1/2" X 0.162"); OR 4-3" X 0.131" NAILS	FACE NAIL
4	CEILING JOIST ATTACHED TO PARALLEL RAFTER (HEEL JOINT)	TABLE R802.5.2	FACE NAIL
5	COLLAR TIE TO RAFTER, FACE NAIL OR 1-1/4"x20 GAGE RIDGE STRAP TO RAFTER	4-10D BOX (3" X 0.128"); OR 3-10D COMMON (3" X 0.148"); OR 4-3" X 0.131" NAILS	FACE NAIL EACH RAFTER
6	RAFTER OR ROOF TRUSS TO PLATE	3-16d BOX NAILS (3-1/2"x0.135") OR 3-10d COMMON NAILS (3"x0.148"); OR 4-10D BOX (3" X .128"); OR 4-3" X 0.131" NAILS	2 TOE NAILS ON ONE SIDE AND 1 TOE NAIL ON OPPOSITE SIDE OF EACH RAFTER OR TRUSS
7	ROOF RAFTERS TO RIDGE, VALLEY	4-16D (3-1/2"x0.135"); OR 3-10D COMMON (3" X 0.148"); OR 4-10D BOX (3" X 0.128"); OR 4-3" X0.131" NAILS	TOE NAIL
7	OR HIP RAFTERS OR ROOF RAFTER TO MINIMUM 2" RIDGE BEAM	3-16d BOX NAILS (3-1/2"x0.135") OR 2-16D COMMON NAILS (3-1/2"x0.162"); OR 3-10D BOX (3" X .128"); OR 3-3" X 0.131" NAILS	END NAIL
		WALL	
8	STUD TO STUD (NOT AT BRACED	16D COMMON (3-1/2" X 0.162")	24" O.C. FACE NAIL
σ	WALL PANELS)	10d BOX (3"x0.128"); OR 3" X 0.131" NAILS	16" O.C. FACE NAIL
9	STUD TO STUD AND ABUTTING STUDS AT INTERSECTING WALL CORNERS (AT BRACED WALL	16D BOX (3-1/2"x0.135"); OR 3" X 0.131" NAILS	12" O.C. FACE NAIL
	PANELS)	16D COMMON (3-1/2" X 0.162")	16" O.C. FACE NAIL
10	BUILT-UP HEADER (2" TO 2"	16D COMMON (3-1/2"x0.162")	16" O.C. ALONG EACH EDGE FACE NAIL
	HEADER WITH ½" SPACER)	16D BOX (3-1/2" X 0.135)	12" ALONG EACH EDGE FACE NAIL
11	CONTINUOUS HEADER TO STUD	5-8D BOX (2-1/2" X 0.113"); OR 4-8D COMMON (2-1/2" X 0.131"); OR 4-10D BOX (3" X 0.128")	TOENAIL
		16D COMMON (3-1/2" X 0.162")	16" O.C. FACE NAIL
12	TOP PLATE TO TOP PLATE	10d BOX (3"x0.128"); OR 3" X 0.131" NAILS	12" O.C. FACE NAIL
13	DOUBLE TOP PLATE SPLICE	8-16D COMMON(3-1/2" X 0.162"); OR 12-16D BOX (3-1/2" X 0.135"); OR 12-10D BOX (3" X 0.128"); OR 12-3" X 0.131" NAILS	FACE NAIL ON EACH SIDE OF END JOINT (MINIMUM 24" LAP SPLICE LENGTH EACH SIDE OF END JOINT)
	BOTTOM PLATE TO JOIST, RIM	16D COMMON (3-1/2" X 0.162")	16" O.C. FACE NAIL
14	JOIST, BAND JOIST OR BLOCKING (NOT AT BRACED WALL PANELS)	16D BOX (3-1/2"x0.135"); OR 3" X 0.131" NAILS	12" O.C. FACE NAIL
15	BOTTOM PLATE TO JOIST, RIM JOIST, BAND JOIST BLOCKING (AT BRACED WALL PANELS)	3-16d BOX NAILS (3-1/2"x0.135") OR 2-16D COMMON (3-1/2"x0.162"); OR 4-3" X 0.131" NAILS	3 EACH 16" O.C. FACE NAIL 2 EACH 16" O.C. FACE NAIL 4 EACH 16" O.C. FACE NAIL
16	TOP OR BOTTOM PLATE TO STUD	4-8D BOX (2-1/2"x0.113") OR 3-16D BOX (3-1/2" x 0.135"); OR 4-8D COMMON (2-1/2" X 0.131"); OR 4-10D BOX (3" x 0.128"); OR 4-3" x 0.131" NAILS	TOE NAIL
		3-16D BOX (3-1/2" x 0.135"); OR 2-16D COMMON (3-1/2" X 0.162"); OR 3-10D BOX (3" x 0.128"); OR 3-3" x 0.131" NAILS	END NAIL
17	TOP PLATES, LAPS AT CORNERS AND INTERSECTIONS	3-10D BOX (3" X 0.128"); OR 2-16D COMMON (3-1/2" X 0.162"); OR 3-3" X 0.131" NAILS	FACE NAIL
18	1" BRACE TO EACH STUD AND PLATE	3-8D BOX (2-1/2" X 0.113"); OR 2-8D COMMON (2-1/2" X 0.131"); OR 2-10D BOX (3" X 0.128"); OR 2 STAPLES 1-3/4"	FACE NAIL
19	1"x6" SHEATHING TO EACH BEARING	3-8D BOX (2-1/2" X 0.113"); OR 2-8D COMMON (2-1/2" X 0.131"); OR 2-10D BOX (3" X 0.128"); OR 2 STAPLES, 1" CROWN, 16 GA, 1-3/4" LONG	FACE NAIL
20	1"x8" AND WIDER SHEATHING TO EACH BEARING	3-8D BOX (2-1/2" X 0.113"); OR 3-8D COMMON (2-1/2" X 0.131"); OR 3-10D BOX (3" X 0.128"); OR 3 STAPLES, 1" CROWN, 16 GA, 1-3/4" LONG WIDER THAN 1" X 8" 4-8D BOX (2-1/2" X 0.113"); OR 3-8D COMMON (2-1/2" X 0.131"); OR 3-10D BOX (3" X 0.128"); OR	FACE NAIL

	2018 IF	RC TABLE R602.3(1) (SEE IRC FOR FOOTI	NOTES)	
		FLOOR		
21	JOST TO SILL, TOP PLATE OR GIRDER	4-8D BOX (2-1/2" X 0.113"); OR 3-8D COMMON (2-1/2" X 0.131"); OR 3-10D BOX (3" X 0.128"); OR 3-3" X 0.131" NAILS	TOE	NAIL
	RIM JOIST, BAND JOIST OR	8d BOX (2-1/2"x0.113")	4" O.C. TOE NAIL	
22	BLOCKING TO SILL OR TOP PLATE (ROOF APPLICATIONS ALSO)	8D COMMON (2-1/2" X 0.131"); OR 10D BOX (3" X 0.128"); OR 3" X 0.131" NAILS	6" O.C. TOE NAIL	
23	1"x6" SUBFLOOR OR LESS TO EACH JOIST	3-8D BOX (2-1/2" X 0.113"); OR 2-8D COMMON (2-1/2" X 0.131"); OR 3-10D BOX (3" X 0.128"); OR 2 STAPLES, 1" CROWN, 16 GA, 1-3/4" LONG	FACE NAIL	
		FLOOR		
24	2" SUBFLOOR TO JOIST OR GIRDER	3-16D BOX (3-1/2" X 0.135"); OR 2-16D COMMON (3-1/2"x0.162")	BLIND AND	FACE NAIL
25	2" PLANKS (PLANK & BEAM - FLOOR & ROOF)	3-16D BOX (3-1/2" X 0.135"); OR 2-16D COMMON (3-1/2"x0.162")	AT EACH BEAR	ING, FACE NAIL
26	BAND OR RIM JOIST TO JOIST	3-16D COMMON (3-1/2" X 0.162"); OR 4-10 BOX (3" X 0.128"); OR 4-3" X 0.131" NAILS ; OR 4-3" X 14 GA. STAPLES, ⁷ / ₁₆ " CROWN	END	NAIL
		20D COMMON (4" X 0.192"); OR	NAIL EACH LAYER AS F TOP END AND BOTTOM	
27	BUILT-UP GIRDERS AND BEAMS, 2" LUMBER LAYERS	10D BOX (3" X 0.128"); OR 3" X 0.131" NAILS	24" O.C. FACE NAIL AT TOP AND BOTTOM STAGGERED ON OPPOSITE SIDES FACE NAIL AT ENDS AND AT EACH SPLICE	
		AND: 2-20D COMMON (4" X 0.192"); OR 3-10D BOX (3" X 0.128"); OR 3-3" X 0.131" NAILS		
28	LEDGER STRIP SUPPORTING JOISTS OR RAFTERS	4-16D BOX (3-1/2" X 0.135"); OR 3-16D COMMON (3-1/2" X 0.162"); OR 4-10D BOX (3" X 0.128"); OR 4-3" X 0.131" NAILS	AT EACH JOIST OR RAFTER, FACE NAIL	
29	BRIDGING OR BLOCKING TO JOIST	2-10D BOX (3" X 0.128"); OR 2-8D COMMON (2-1/2" X 0.131"; OR 2-3" X 0.131") NAILS	EACH END, TOE NAIL	
	DESCRIPTION OF BUILDING		SPACING OF FASTENERS	
ITEM	ELEMENTS	NUMBER AND TYPE OF FASTENER	EDGES (IN)	INTERMEDIATE SUPPORTS (IN)
30	3/8" - 1/2"	6d COMMON (2"x0.113") NAILS (SUBFLOOR, WALL) 8d COMMON (2-1/2"x0.131") NAIL (ROOF); OR RSRS-01 (2-38" X 0.113") NAIL (ROOF)	6	12
31	19/32"-1"	8d COMMON NAIL (2-1/2"x0.131"); OR RSRS-01 (2-3/8" X 0.113") NAIL (ROOF)	6	12
32	1-1/8" - 1-1.4"	10d COMMON (3"x0.148") NAIL OR 8D (2-1/2"x0.131") DEFORMED NAIL	6	12
		OTHER WALL SHEATHING		
33	1/2" STRUCTURAL CELLULOSIC FIBERBOARD SHEATHING	1-1/2" GALVANIZED ROOFING NAIL, 7/16" HEAD DIAMETER, OR 1-1/4" LONG 16 GA. STAPLE WITH ⁷ / ₁₆ " OR 1" CROWN	3	6
34	25/32" STRUCTURAL CELLULOSTIC FIBERBOARD SHEATHING	1-3/4" GALVANIZED ROOFING NAIL, 7/16" HEAD DIAMETER, OR 1-1/2" LONG 16 GA STAPLE WITH $\frac{7}{16}$ " OR 1" CROWN	3 6	
35	1/2" GYPSUM SHEATHING	1-1/2" GALVANIZED ROOFING NAIL; STAPLE GALVANIZED, 1-1/2" LONG; 1-1/4" SCREWS, TYPE "W" OR "S"	7 7	
36	5/8" GYPSUM SHEATHING	1-3/4" GALVANIZED ROOFING NAIL; STAPLE GALVANIZED, 1-5/8" LONG; 1-5/8" SCREWS, TYPE "W" OR "S"	7	7
	WOOD STRUCTURA	AL PANELS, COMBINATION SUBFLOOR U	NDERLAYMENT TO FE	RAMING
37	3/4" AND LESS	6D DEFORMED (2"x0.120") NAIL OR 8D COMMON (2-1/2"x0.131") NAIL	6	12
38	7/8" - 1"	8D COMMON (2-1/2"x0.131") NAIL OR 8D DEFORMED (2-1/2"x0.120") NAIL	6	12
39	1-1/8" - 1-1/4"	10D COMMON (3"x0.148") NAIL OR 8D DEFORMED (2-1/2"x0.120") NAIL	6	12


TABLE R507.2.1 PLACEMENT OF LAG SCREWS AND BOLTS IN DECK LEDGERS AND BAND JOISTS					
MINIMUM END AND EDGE DISTANCES AND SPACING BETWEEN ROWS (INCHES)					
	TOP EDGE	BOTTOM EDGE	ENDS	ROW SPACING	
LEDGER	2	1/4	2	1-5/8	
BAND JOIST	3/4	2	2	1-5/8	

MINIMUM WALL STUD FRAMING NOMINAL SIZE AND GRADE	MAXIMUM PONY WALL HEIGHT (FEET)	MAXIMUM TOTAL WALL HEIGHT (FEET)	MAXIMUM OPENING WIDTH (FEET)	TENSION STRAP CAPACITY REQUIRED (POUNDS) FOR 90 MPH EXPOSURE B
	0	10	18	1,000
			9	1,000
	1	10	16	1,000
			18	1,000
			9	1,200
	2	10	16	1,000
2x4 NO 2 GRADE			18	2,025
	2	12	9	2,400
			16	1,200
			18	3,200
		12	9	3,200
	4		16	2,350
			18	DR
			9	1,000
	2	12	16	2,050
2x6 STUD			18	2,450
GRADE			9	1,500
	4	12	16	3,150
			18	3,675

MINIMUM LENGTH OF BRACED WALL PANELS TABLE R602.10.5 (PARTIAL)						
		MINIM	IUM LENGTH (INCHES)		
M	ETHOD		WALL HEIGHT	Ī		
		8 FEET	9 FEET	10 FEET		
	SUPPORTING ROOF ONLY	16	16	16		
PFH	SUPPORTING ONE STORY AND ROOF	24	24	24		
	PFG	24	27	30		
(CS-PF	16	18	20		
CS-WSP	ADJACENT CLEAR OPENING HEIGHT (INCHES)					
	LESS THAN OR EQUAL TO 64	24	27	30		

BRA	THICKNESS		
METHODS,	MINIMUM	CONNECT	ION CRITEIA
MATERIAL	THICKNESS	FASTENERS	SPACING
WSP - WOOD		SHEATHING PER	
STRUCTURAL PANEL	3/8	SHEATHING PER TABLE R602.3(1)	
CS-WSP CONTINUOUSLY		SHEATHING PER	
SHEATHED WOOD STRUCTURAL PANEL	3/8	SHEATHING PER TABLE R602.3(1)	
PFH - PORTAL FRAME WITH HOLD DOWNS	3/8		
PFG - PORTAL FRAME AT GARAGE	3/8	1	
LIB	APPROVED METAL STRAPS AT 45 TO 60	COMMON NAILS	AND TOP AND
LET-IN-BRACING	ANGLES FOR MAX 16" STUD	PER	
GB-GYPSUM	1/2	SCREWS PER TABLE R602.3(1) FOR EXTERIOR	WALL PANEL LOCATIONS: 7"
BOARD	112	SCREWS PER	TOP AND BOTTOM

	ENGINEERED LUMBER MINIMUM DESIGN REQUIREMENTS												
		fb (PSI)	E (PSI)	Fv (PSI									
	VERSA-LAM LVL	3100	2.0x106	285									
	DOUGLAS FIR-LARCH #2	900	1.6x106	180									

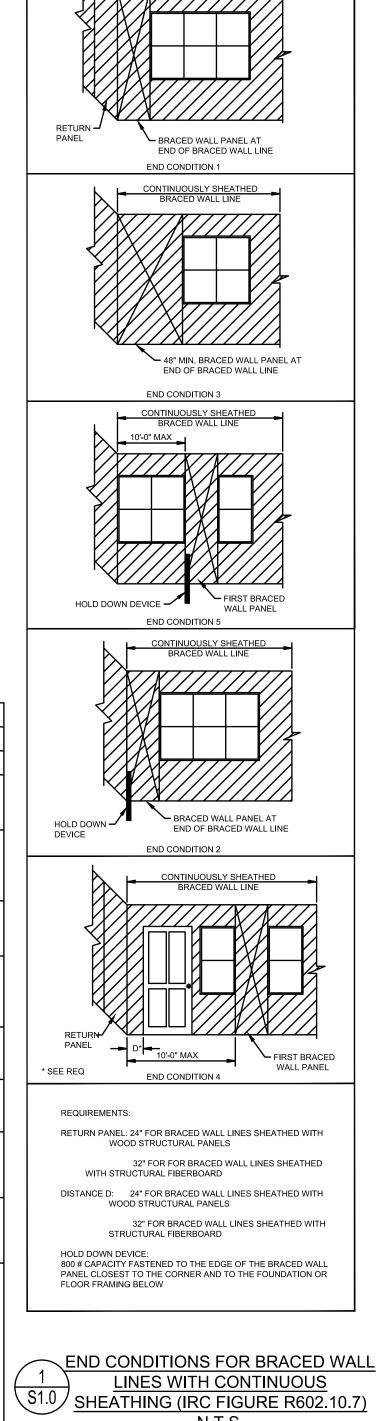





=AMING


SHEET#


07/24/2023


TABLE R507/2 FASTENER SPACING FOR A SOUTHERN PINE OR HEM-FIR DECK LEDGER 2" NOMINAL SOLID SAWN SPRUCE-PINE-FIR BAND JOIST (DECK LIVE LOAD = 40PSF, DECK DEAD LOAD = 10 PSF)

JOIST SPAN	6' AND LESS	6'1 TO 8'	8'1 TO 10'	10'1 TO 12'	TO 12' 12'1 TO 14' 14'1 TO		16'1 TO 18'			
CONNECTION DETAILS			ON CENTER SPACING OF FASTENERS							
1/2" DIAMETER LAG SCREW WITH 15/32" MAX SHEATHING	30	23	18	15	13	11	10			
1/2" DIAMETER BOLT WITH 15/32" MAX SHEATHING	36	36	34	29	24	21	19			
1/2" DIAMETER BOLT WITH 15/32" MAX SHEATHING AND 1/2" STACKED WASHERS	36	36	29	24	21	18	16			

REQUIREMENTS FOR WOOD STRUCTURAL PANEL WALL SHEATHING USED TO RESIST WIND PRESSURES IRC TABLE 602.3(3) (PARTIAL)										
MINIMU	M NAIL	MINIMUM WOOD STRUCTURAL	MINIMUM NOMINAL PANEL	ALPANEL MAX WALL STUD		L SPACING	ULTIMATE DESIGN WIND SPEED, V ULT (MPH)			
SIZE PENETRATI		PANEL SPAN RATING	THICKNESS (IN)	SPACING -	EDGES (IN O.C.)	FIELD (IN O.C.)	В			
6d COMMON 1.5		24/0	3/8	16	6	12	140			
8d COMMON	1.75	24/16	7/16	16	6	12	170 140			
	1.75	24/10	//10	24	6	12				

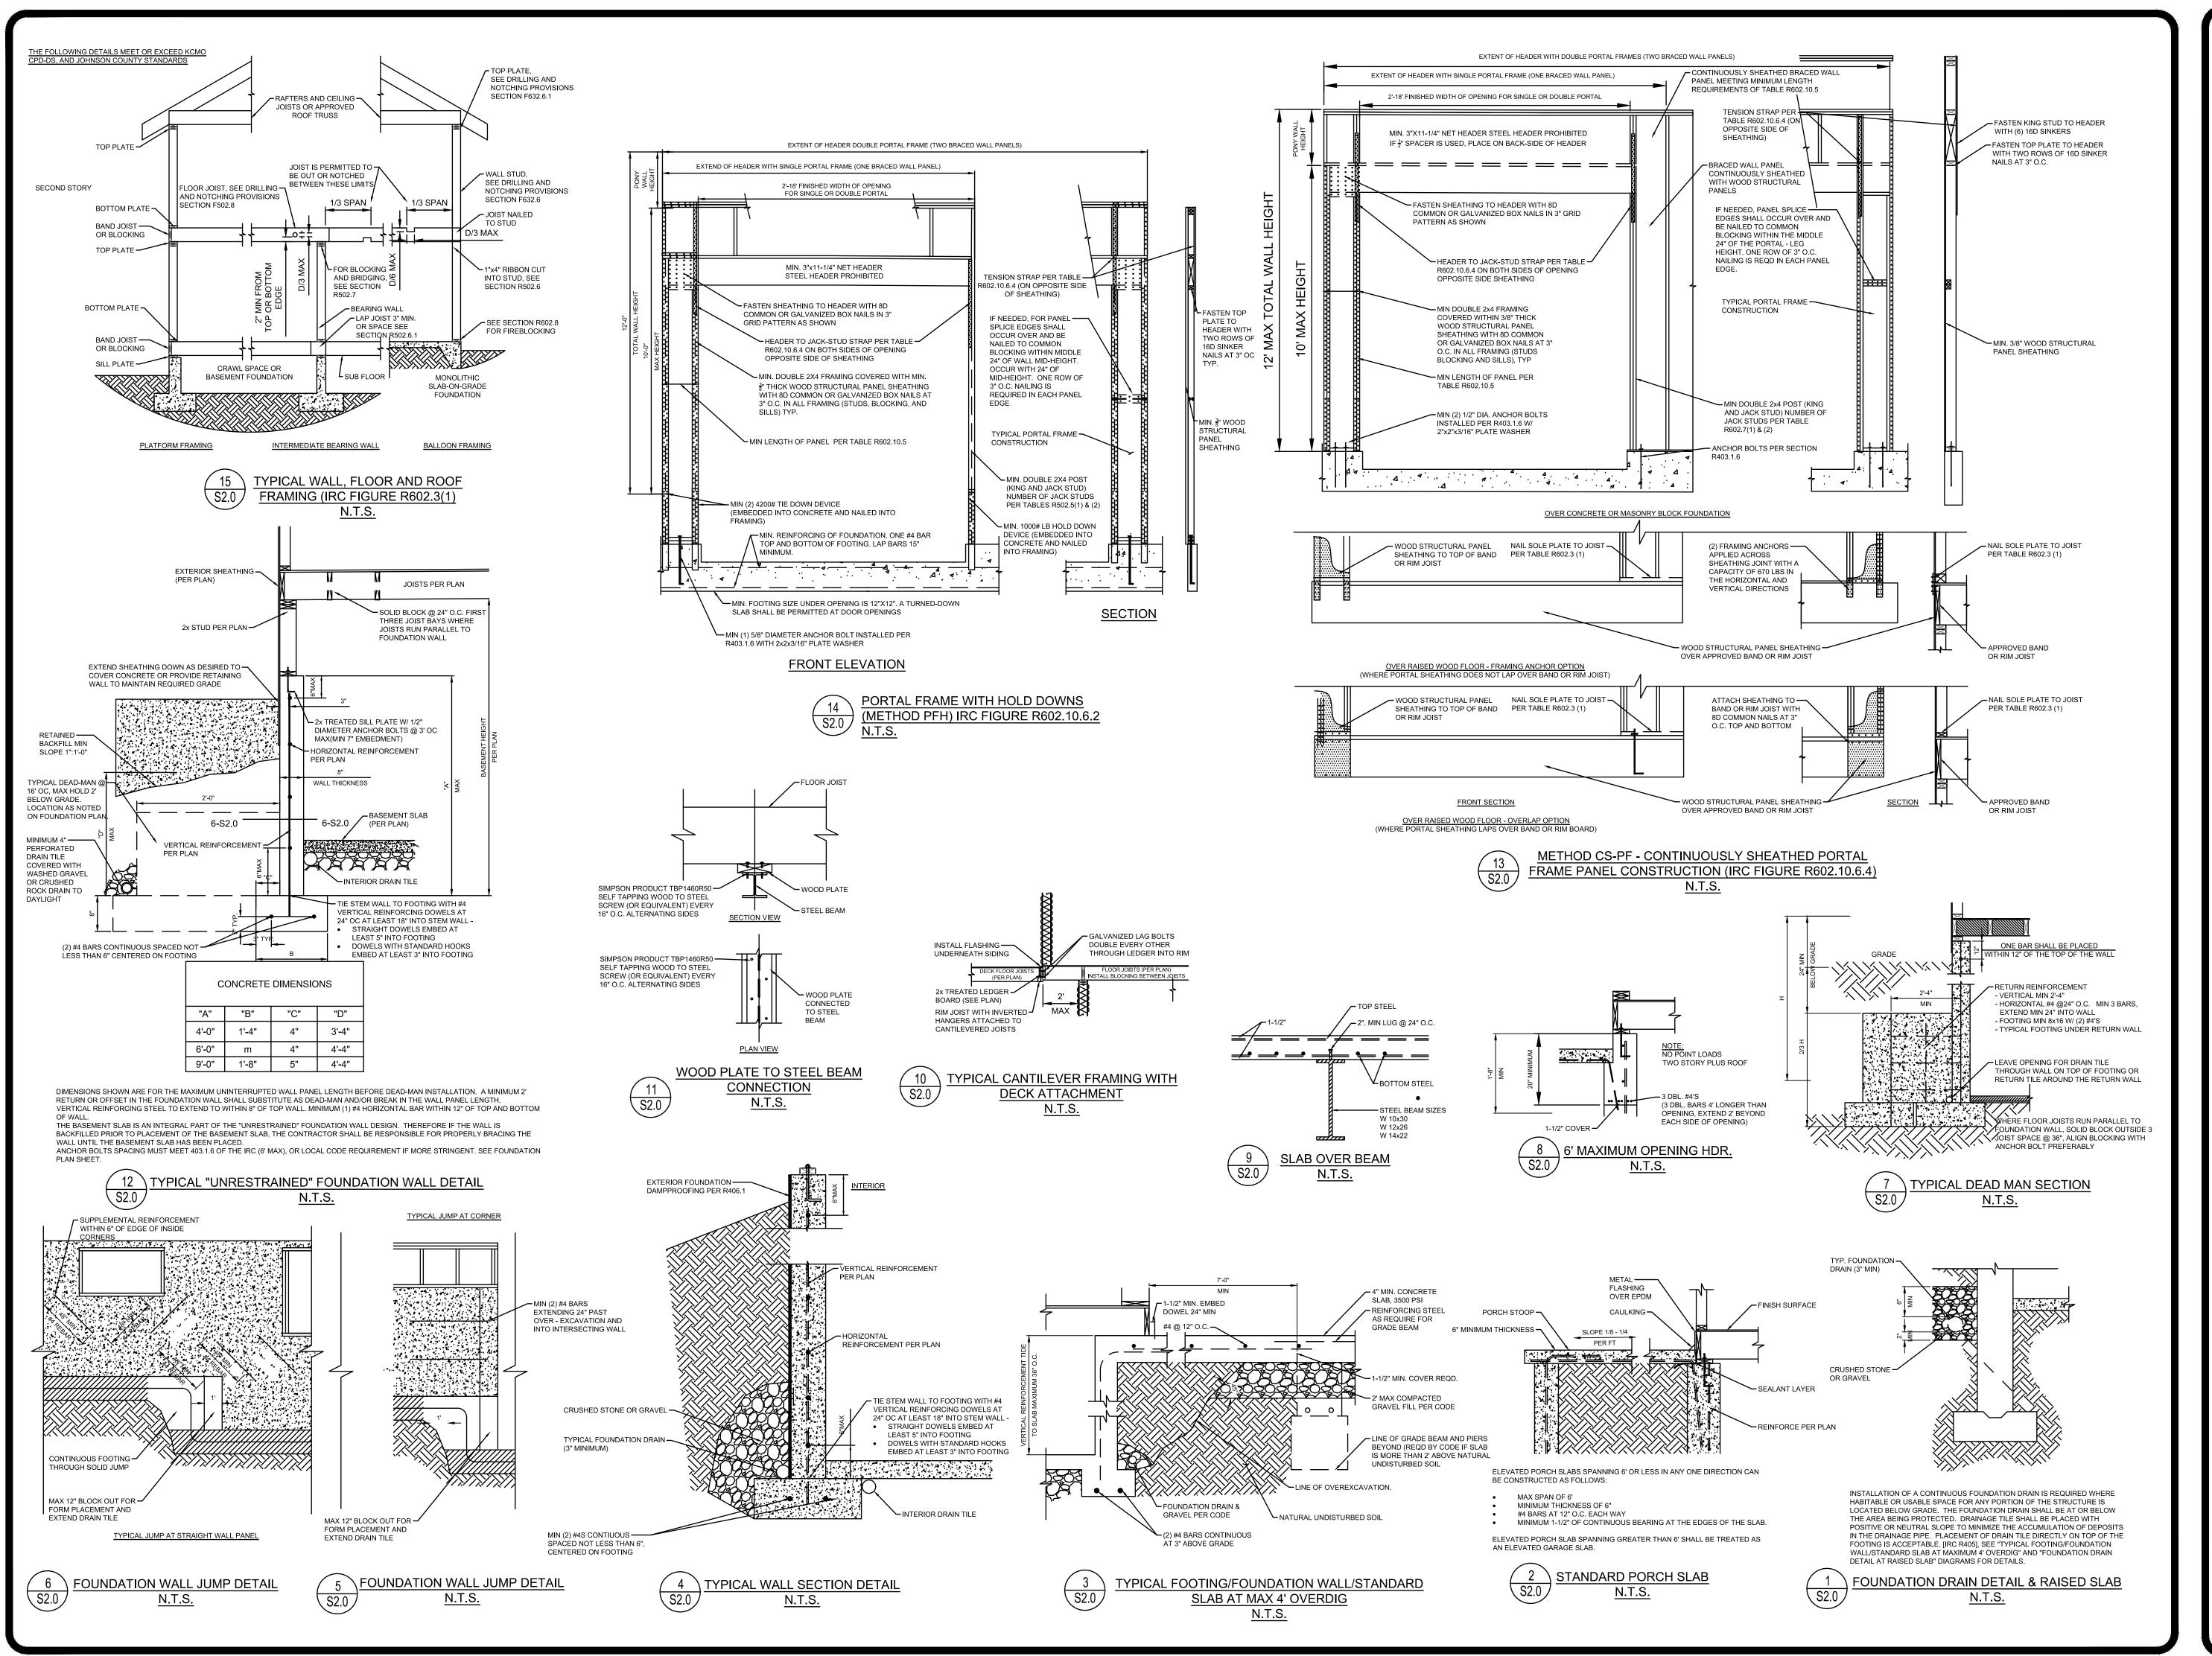

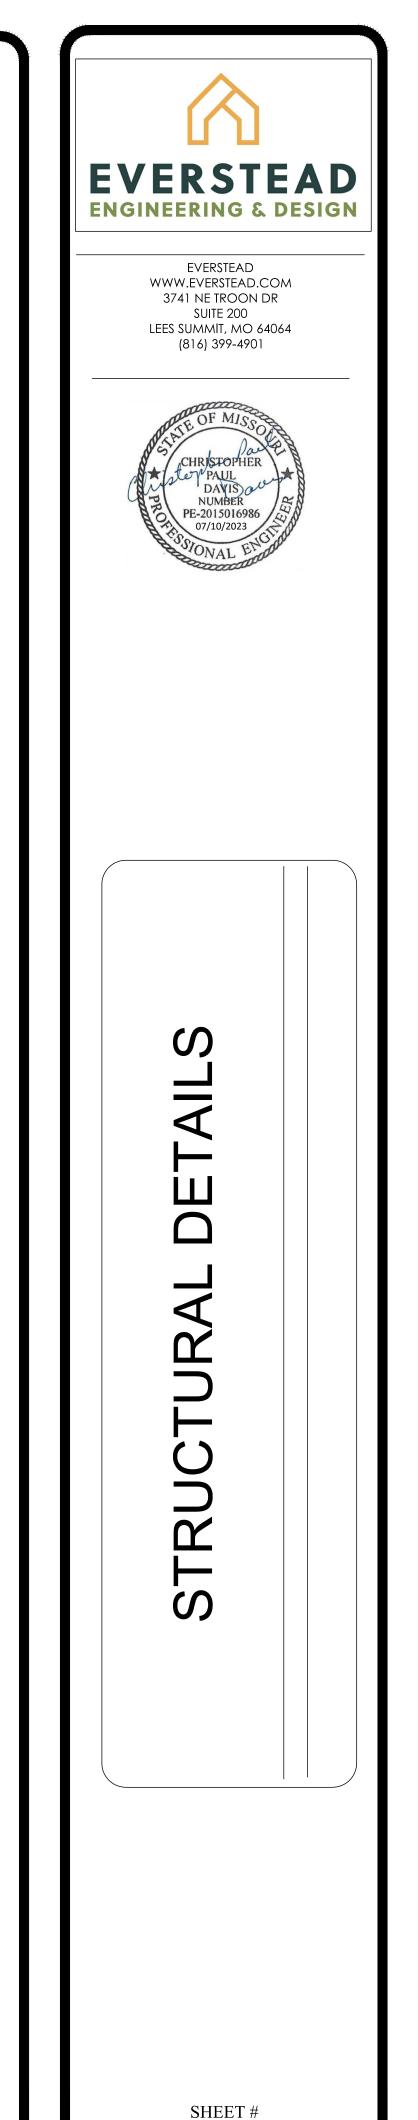

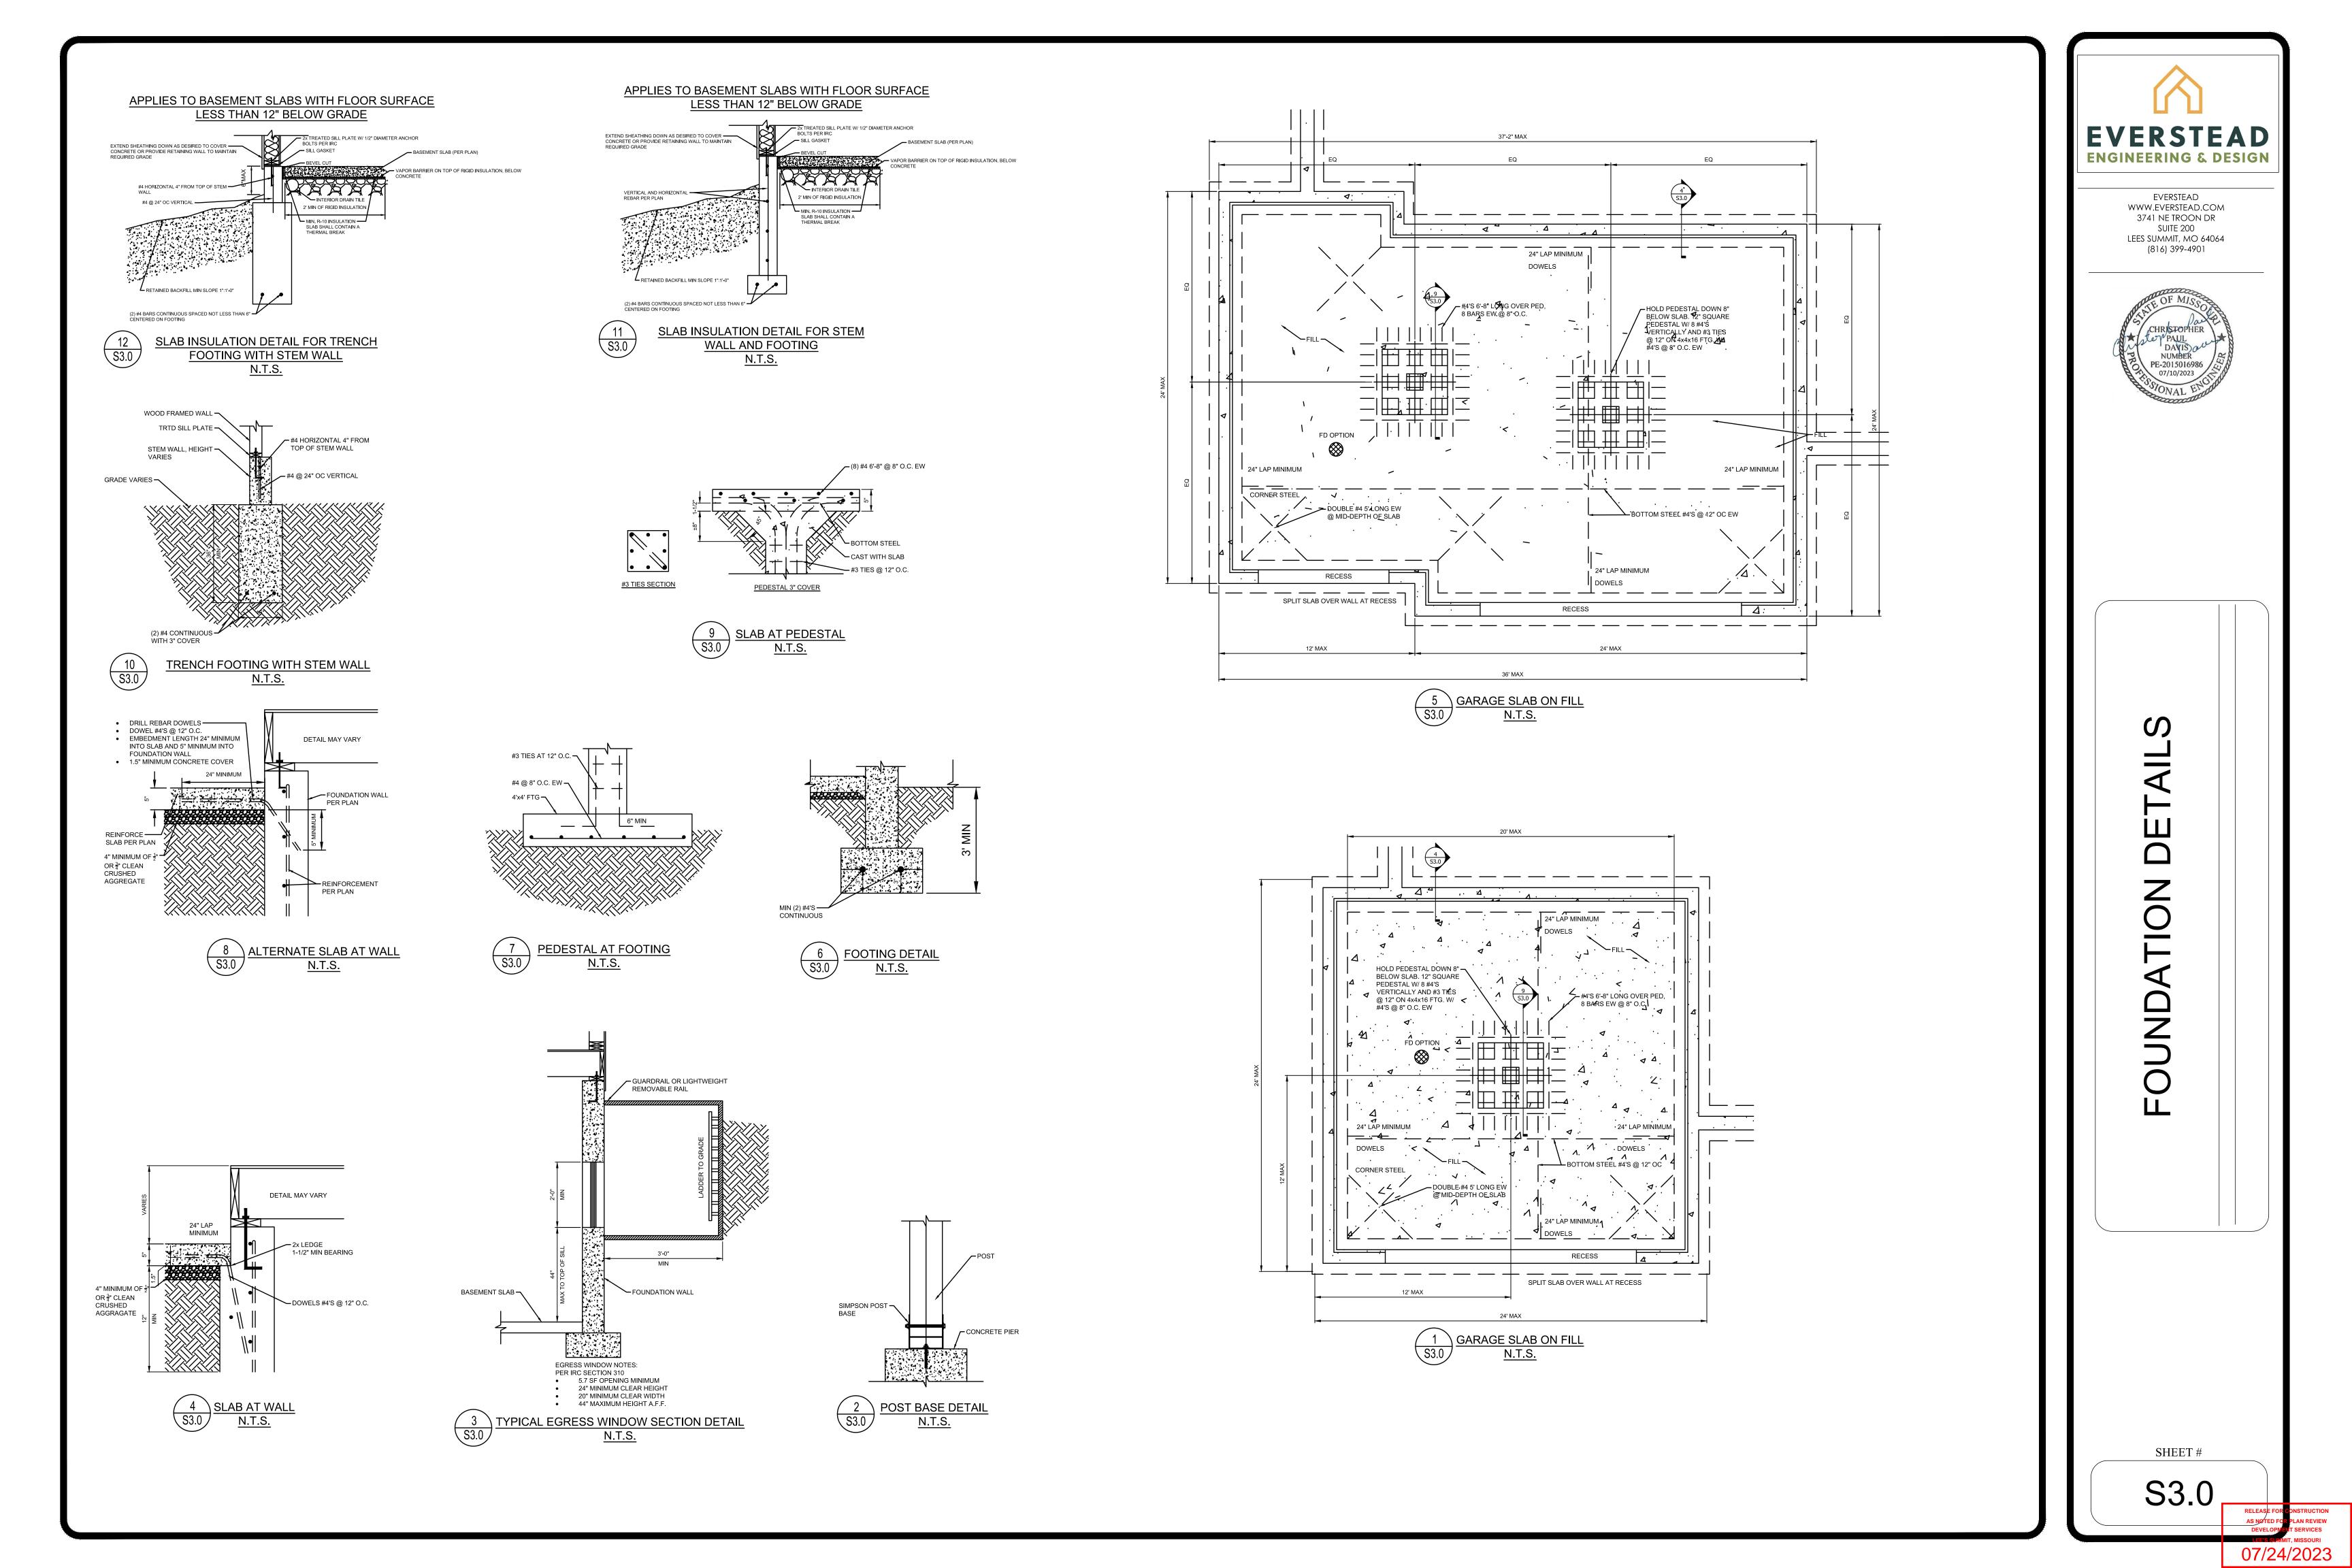

HELIX REQUIREMENTS:

- FOUNDATION WALL SHALL NOT EXCEED 9' HEIGHT.
- DEAD MAN SHALL BE A MAXIMUM 3'8" FROM TOP OF FOUNDATION WALL ELSE HELIX NOT PERMITTED.

ALL CONCRETE SHALL BE REINFORCED WITH HELIX MICRO REBAR ALONG WITH ANY ADDITIONAL REBAR AS NOTED:

- 9.0 LB/CUBIC YARD DOSAGE OF HELIX 5-25.
- VERIFY DOSAGE AT FORM INSPECTION.
 SEE MIXING PEOLIDEMENTS ON THIS PAGE
- SEE MIXING REQUIREMENTS ON THIS PAGE.
- MINIMUM 3000 PSI FOOTING COMPRESSIVE STRENGTH.
 MINIMUM 3000 PSI WALL COMPRESSIVE CONCRETE STRENGTH.
- AIR ENTRAINED BETWEEN 5-7% OF CONCRETE VOLUME.
- GRADE 60 REINFORCING STEEL UNLESS OTHERWISE NOTED.
 LAP SPLICES 24" MINIMUM.
- ASSUMED 1500 PSF SOIL BEARING.
- WALL SHALL BE BACK-FILLED WITH CLEAN, LEAN CLAY, OR BETTER, LOW VOLUME CHANGE MATERIAL. ON-SITE MATERIAL MAY BE USED IF DEEMED ACCEPTABLE BY THE GEOTECHNICAL ENGINEER.


HELIX ALTERNATE DESIGN NOT VALID IF ANY ONE OF THE FOLLOWING CONDITIONS ARE MET:

- NON-UNIFORM FOOTING SUPPORT (IE. CAST IN PLACE PIERS, PUSH PILES).
- DAYLIGHT WALLS EXCEEDING 6' TALL FOR A LENGTH GREATER THAN 6'.


HELIX DOSING INSTRUCTIONS:

MIXING SHOULD BE DONE ACCORDANCE WITH ASTM C94 AND THE MIXING INSTRUCTIONS BELOW. THE DOSAGES OF HELIX ADDED TO THE MIX SHOULD BE NOTED ON THE BATCH DOCUMENTATION IN ACCORDANCE WITH UNIFORM EVALUATION SERVICE ER 279 SECTION 5.15. VERIFIED USING PROCEDURE IN ER 279 APPENDIX A.


A SLUMP OF 125 MM OR 5" OR HIGHER WILL FACILITATE STRIKE OFF. A SLUMP OF LESS THAN 4" IS NOT RECOMMENDED AS THIS WILL PREVENT SURFACE SEGREGATION OF THE CEMENT AND FINES FROM THE AGGREGATE AND HELIX. SLUMP SHOULD BE MEASURED ON THE INITIAL LOAD AND ADJUSTMENTS MADE WITH A WATER REDUCER OR PLASTICIZER (NOT WATER).

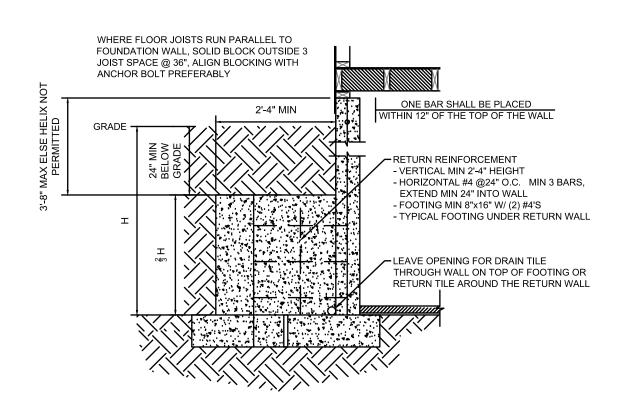




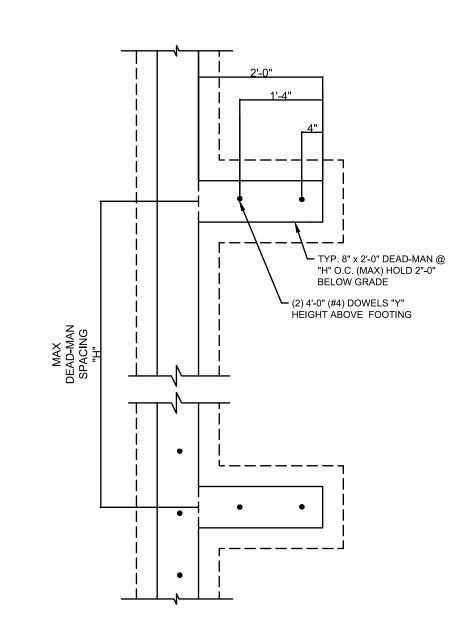

3 TYPICAL DEAD MAN SECTION N.T.S.

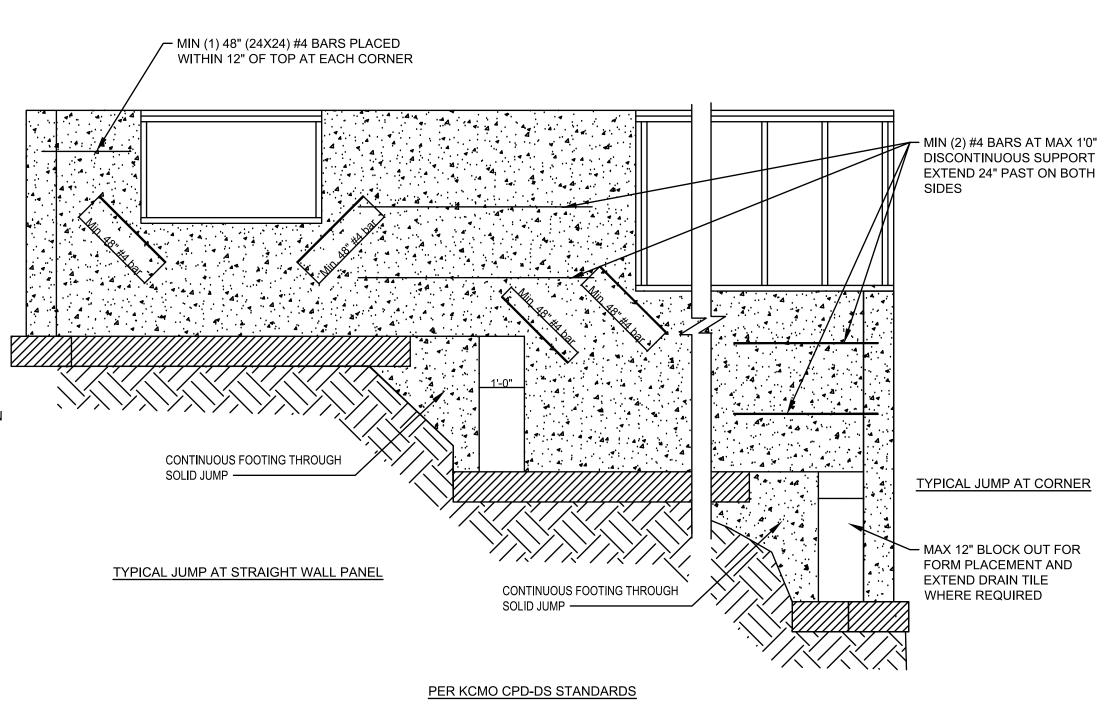



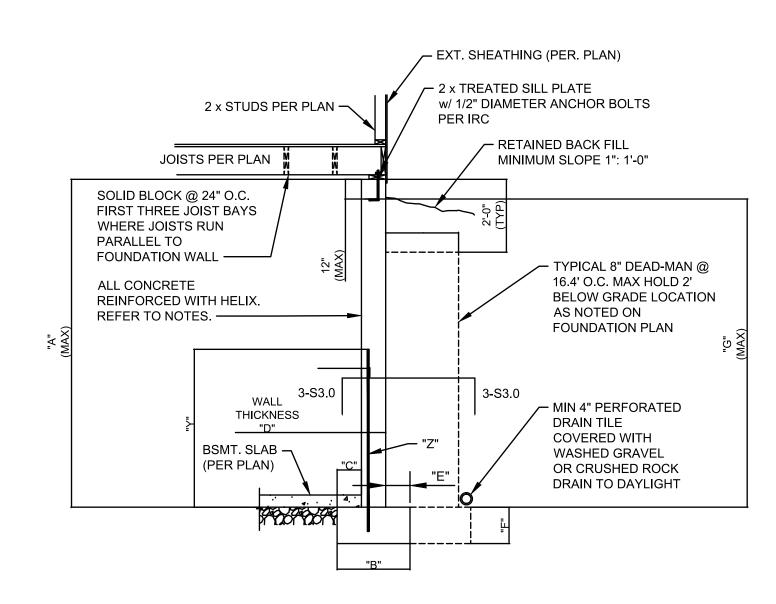


			CON	CRETE	DIMENS	SIONS	HEIGHT ABOVE FOOTING	REINFORCINGBARS (GRADE 60)	HELIX DOSAGE.
"A"	"B"	"C"	"D"	"E"	"F"	"G"	"Y"	"Z"	,,,,,
8'-0"	1'-4"	4"	8"	4"	8"	7'-6"	2'-6"	4 BARS AT 24" O.C.	9.0 LB/CUBIC YARD
9'-0"	1'-4"	4"	8"	4"	8"	8'-6"	2'-6"	4 BARS AT 24" O.C.	9.0 LB/CUBIC YARD

DIMENSIONS SHOWN IS FOR THE MAXIMUM UNINTERRUPTED WALL PANEL LENGTH BEFORE DEAD-MAN SHALL BE INSTALLED. A MINIMUM 2' RETURN OFFSET IN THE FOUNDATION WALL SHALL SUBSTITUTE AS DEAD-MAN AND/OR BREAK IN THE WALL PANEL LENGTH.
WALL WILL NOT ACHIEVE FULL STRENGTH UNTIL FIRST FLOOR DECK AND BASEMENT SLAB HAVE BEEN PLACED.



	HELIX DOSAGE					
Al	LL STRI	9 LB/CU FT				
		ISOLA	ΛTΕ	ED FOOTINGS AND	COLUMN PAD	S
SYM	PIER PAD SIZE	DEPTH	MIM	NIMUM REINFORCEMENT GRADE 60 KSI STEEL	SCHEDULE 40 STEEL COLUMN, MIN FY = 35 KSI	HELIX DOSAGE
A	30"x30"	1'-0"		(5) #4 BAR E.W.	3" DIAMETER	12.5 LB/CU FT
B	36"x36"	1'-0"		(6) #4 BAR E.W.	3" DIAMETER	12.5 LB/CU FT
<u>⟨</u> c∖	42"x42"	1'-2"		(7) #4 BAR E.W.	3" DIAMETER	12.5 LB/CU FT
\triangle	48"x48"	1'-4"		(8) #4 BAR E.W.	3" DIAMETER	12.5 LB/CU FT
	48"x48"	1'-4"		(8) #4 BAR E.W.	N/A	12.5 LB/CU FT
Æ	54"x54"	1'-4"		(9) #4 BAR E.W.	3.5" DIAMETER	12.5 LB/CU FT
F	60"x60"	1'-6"		(10) #4 BAR E.W.	3.5" DIAMETER	12.5 LB/CU FT
SYM	PIER DIAMETE	DEF	TH	MINIMUM REINFORCE GRADE 60 KSI STE	HELIX DOSAGE	
G	12" 3'-0'		0"	(4) VERTICA	AL #4	12.5 LB/CU FT
A	16" 3'-0		0"	(4) VERTICA	AL #4	12.5 LB/CU FT
	18" 3'		0"	(4) VERTICA	AL #4	12.5 LB/CU FT
K	24" 3'-		0"	(4) VERTICA	12.5 LB/CU FT	
	28"	3'-	0"	(4) VERTICAL #4 12.5 LB/CU		12.5 LB/CU FT

COLUMN AND PAD SIZES ARE FOR A MAXIMUM COLUMN HEIGHT OF 10'.
COLUMNS GREATER THAN 10' REQUIRE A SEPARATE ENGINEERED
DESIGN. FOOTINGS A-F SPACING OF 6" O.C. WITH 3" CLEAR COVER.

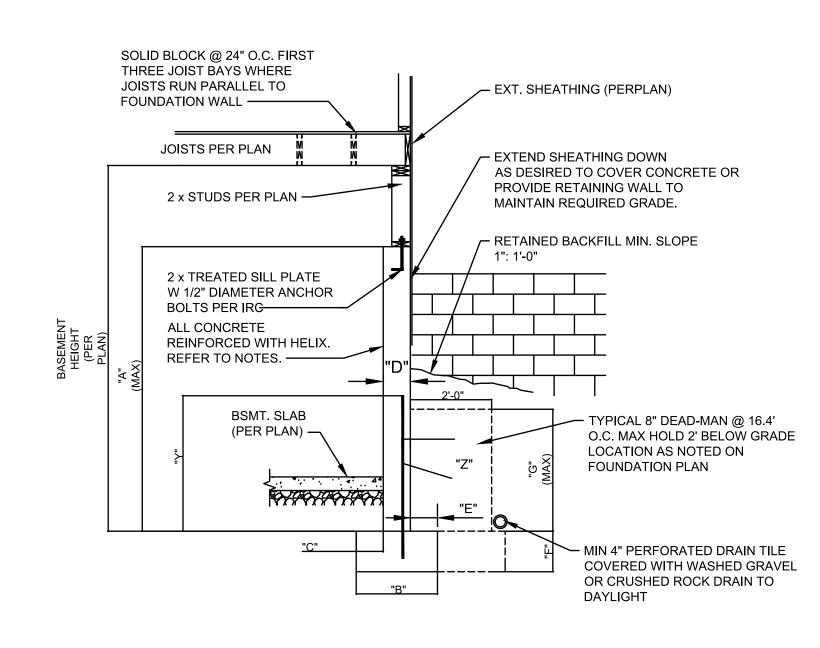


			CONCR	ETE DIN	MENSION	IS	HEIGHT ABOVE FOOTING	REINFORCINGBARS (GRADE 60)	HELIX DOSAGE.
"A"	"A" "B" "C" "D" "E" "F" "G"					"G"	"Y"	"Z"	THEE IN BOOK OF.
4'-0"	1'-4"	4"	8"	4"	8"	3'-4"	2'-6"	4 BARS AT 24" O.C.	9.0 LB/CUBIC YARD
6'-0"	1'-4"	4"	8"	4"	8"	4'-4"	2'-6"	4 BARS AT 24" O.C.	9.0 LB/CUBIC YARD

DIMENSIONS SHOWN IS FOR THE MAXIMUM UNINTERRUPTED WALL PANEL LENGTH BEFORE DEAD-MAN SHALL BE INSTALLED. A MINIMUM 2' RETURN OFFSET IN THE FOUNDATION WALL SHALL SUBSTITUTE AS DEAD-MAN AND/OR BREAK IN THE WALL PANEL LENGTH. THE BASEMENT SLAB IS AN INTEGRAL PART OF THE "UNRESTRAINED" FOUNDATION WALL DESIGN. THEREFORE, IF THE WALL IS BACKFILLED PRIOR TO PLACEMENT OF THE BASEMENT SLAB, THE CONTRACTOR SHALL BE RESPONSIBLE FOR PROPERLY BRACING THE WALL UNTIL THE BASEMENT SLAB HAS BEEN PLACED.



TYPICAL "UNRESTRAINED" FOUNDATION
WALL DETAIL

N.T.S

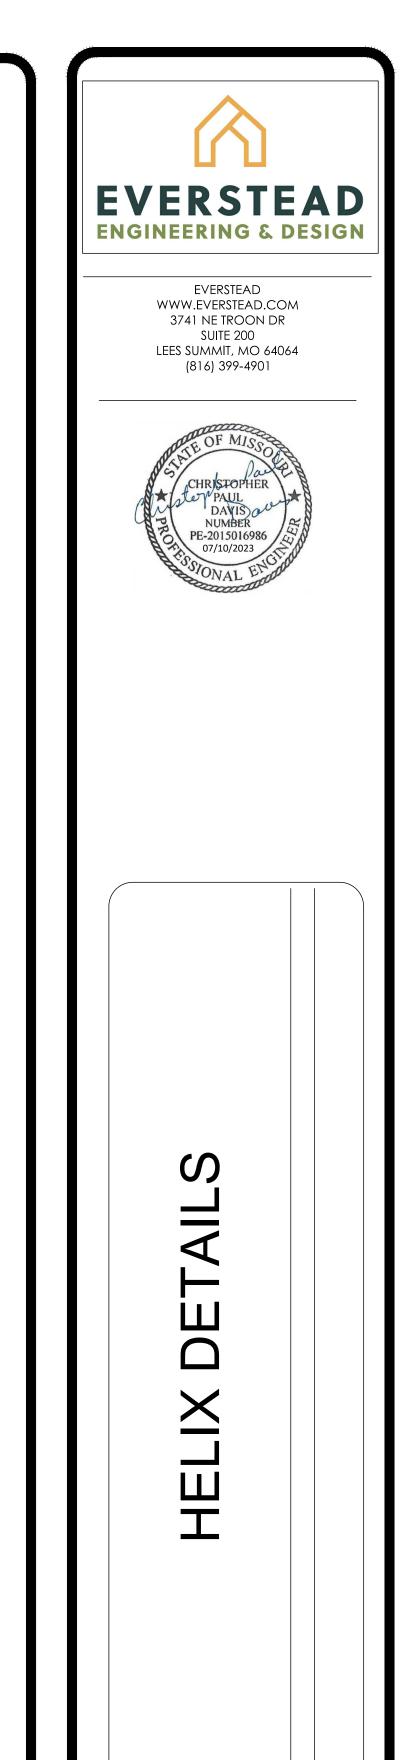

SHEET#

AS NOTED FOR PLAN REVIEW DEVELOPMENT SERVICES

LEFTS SUMMIT, MISSOURI

07/24/2023