


EXTERIOR LIGHT FIXTURE SCHEDULE										
MARK	DESCRIPTION	MFGR	MODEL	MOUNTING	FINISH	LAMPS	NOTES			
Α	Bollard	Architectural Area Lighting	SPB-SPB-COP-BL	surface	black	1000 Lumen 3000K 15W LED	1			
В	Pole	Architectural Area Lighting	SP1-DBL-Y5-32LED-4K-550-COP-BL-SAP1	surface	black	1000 Lumen 3000K 15W LED	1, 2			
С	Wall Sconce	Architectural Area Lighting	SP1-DBL-Y5-32LED-4K-550-COP-BL-AWM1	wall	black	600 Lumen 3000K 15W LED	1			

## NOTE:

1 CONFIRM COLOR WITH ARCHITECT

2 PROVIDE WITH 16' POLE

STATISTICS (fc)							
Description	Avg	Max	Min				
Drive	1.3	19.8	0				

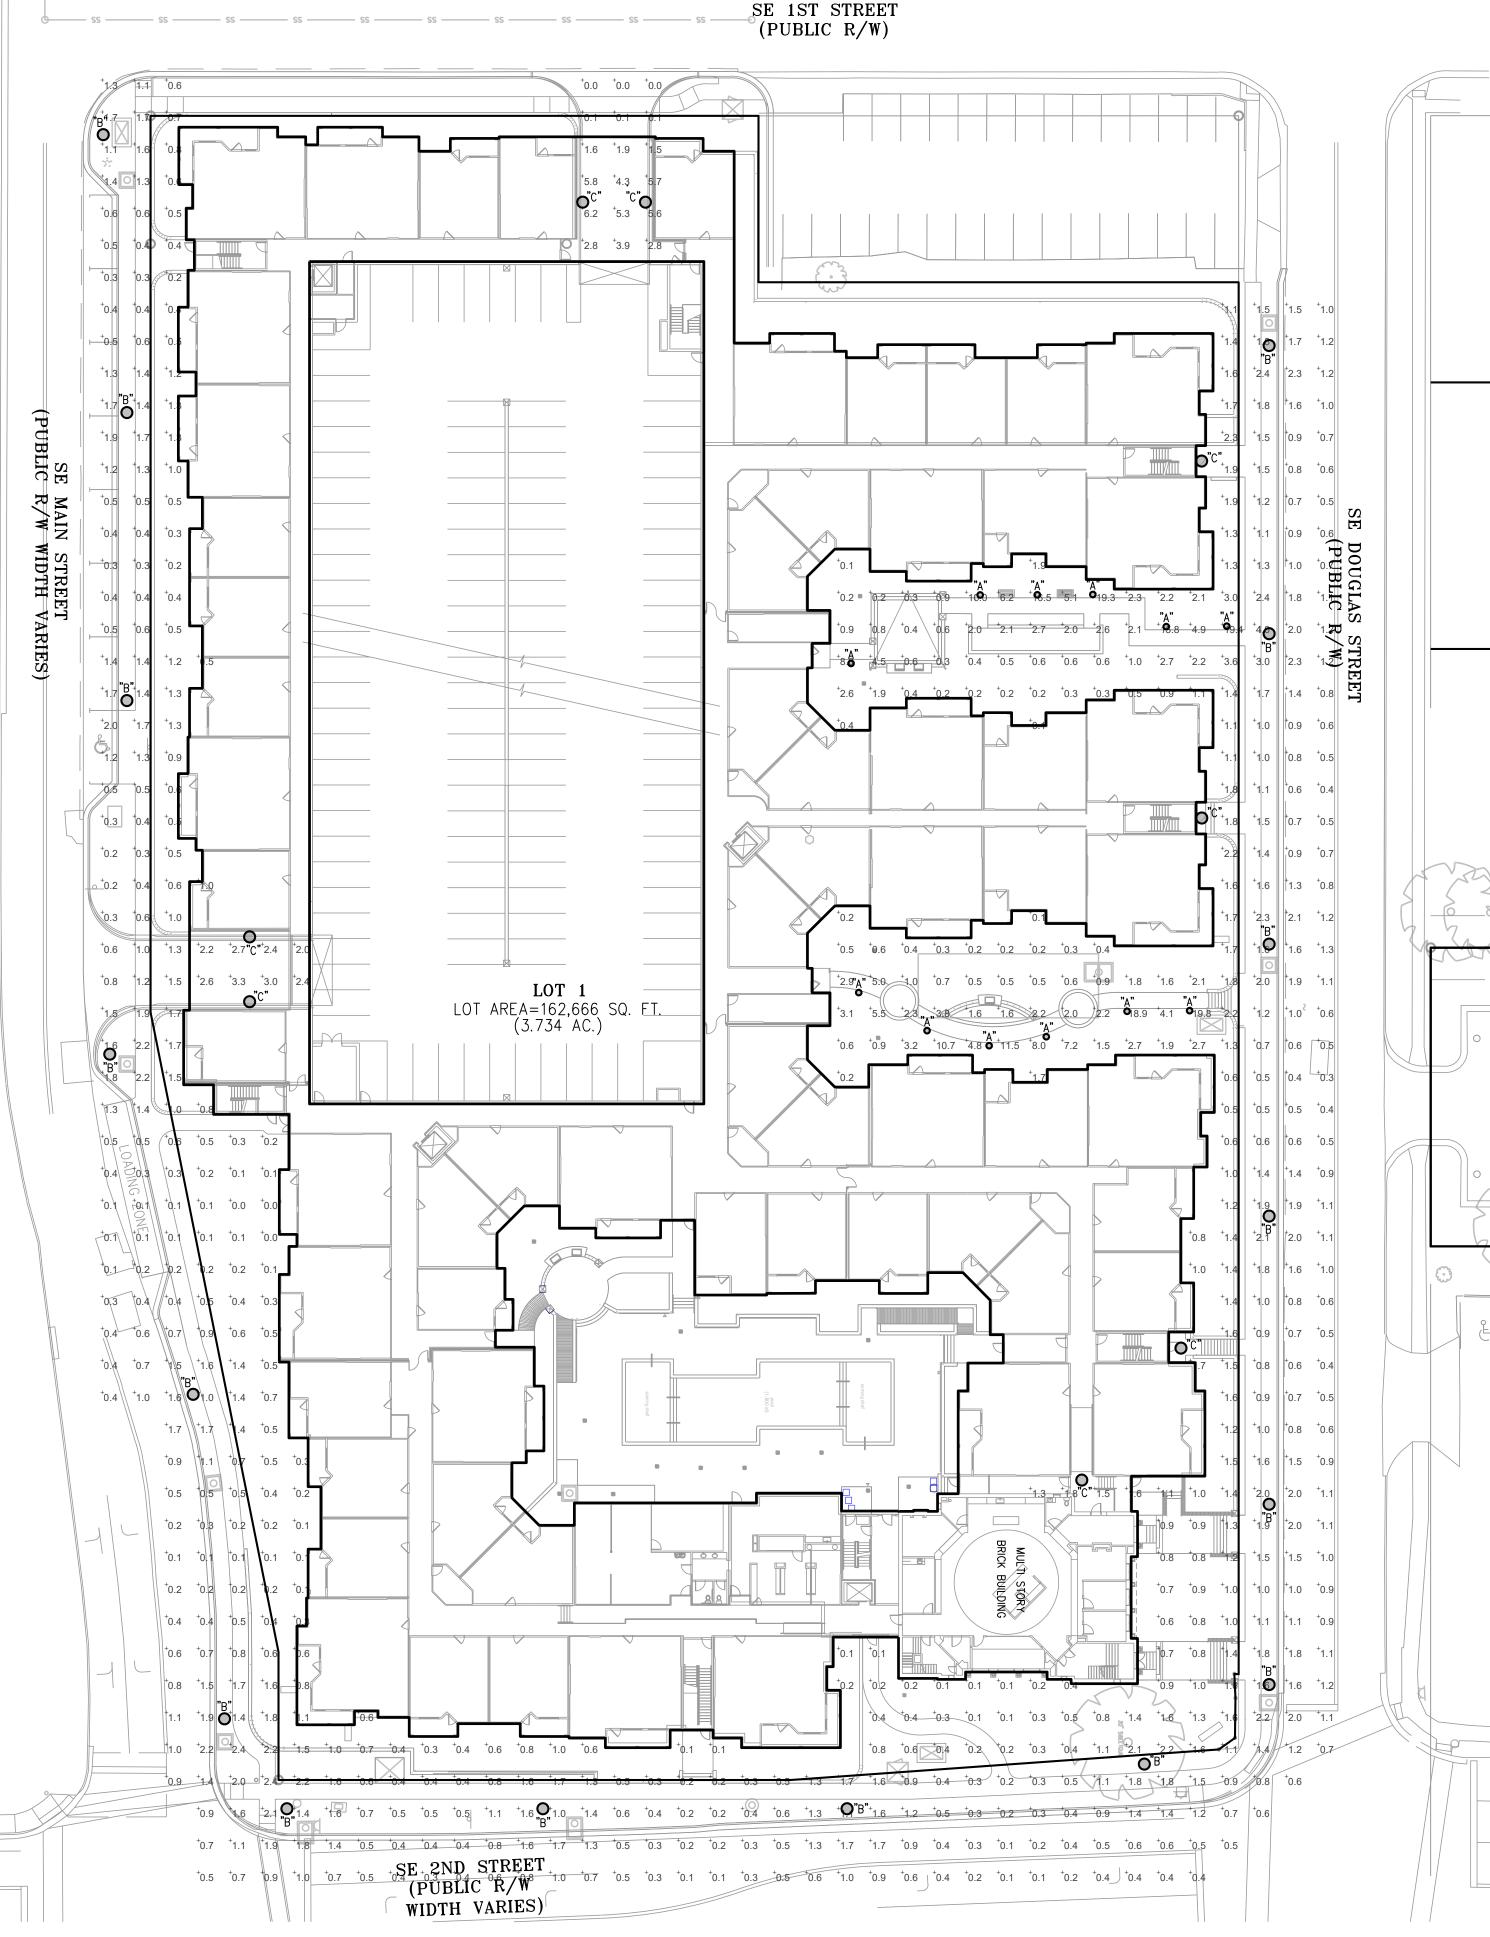

SITE PHOTOMETRIC PLAN

1"=30'-0"



Planning · Architecture Landscape Architecture

SGN+A, Inc.

315 West Ponce de Leon Avenue Suite 755 Decatur, Georgia 30030

Tel: 404.373.7370 www.sgnplusa.com





Revisions:

Date: Description:

Construction

Downtown Lee's Summit Apartments

Documents

A Residential Development by



This drawing as an instrument of services, is and shall remain the property of SGN+A and shall not be reproduced, published or used in any way without permission of SGN+A, Inc.

Sheet Title:

SITE PHOTOMETRIC PLAN

Date: 30 January 2020

Sheet Number:

E0.1