

B:\M 360\113-20102-00_Lee's Summit Middle School #4\13-20102-00_Lee's Summit Middle School 4_ARCH_2020.rvt
5/8/2020 2:21:03 PM

LEE'S SUMMIT MIDDLE SCHOOL #4

PRELIMINARY DEVELOPMENT PLAN

1001 SE BAILEY ROAD
LEE'S SUMMIT, MO 64081

INDEX OF DRAWINGS

05/08/2020

PRELIMINARY DEVELOPMENT PLAN DRAWING LIST

A0.0 COVER SHEET

CIVIL

1000 GENERAL LAYOUT PLAN
1001 SITE PLAN
1002 SITE PLAN
1003 SITE PLAN
1004 OVERALL GRADING PLAN
1005 OVERALL GRADING PLAN
1006 UTILITY PLAN
1007 UTILITY PLAN

LANDSCAPE

L1.0 OVERALL LAYOUT PLAN
L1.1 ENLARGED LAYOUT PLAN
L1.2 ENLARGED LAYOUT PLAN
L1.3 ENLARGED LAYOUT PLAN
L2.0 OVERALL LANDSCAPE PLAN
L2.1 ENLARGED LANDSCAPE PLAN
L2.2 ENLARGED LANDSCAPE PLAN
L2.3 ENLARGED LANDSCAPE PLAN

ARCHITECTURAL

A5.01 EXTERIOR ELEVATIONS
A5.02 EXTERIOR ELEVATIONS

ELECTRICAL

E01.00 SITE LIGHTING PHOTOMETRIC PLAN
E01.01 SITE LIGHTING PHOTOMETRIC PLAN
E01.02 SITE LIGHTING PHOTOMETRIC PLAN
E01.03 SITE LIGHTING FIXTURE CUTSHEETS
E01.04 SITE LIGHTING FIXTURE CUTSHEETS

VICINITY MAP:



LEGAL DESCRIPTION:

Surveyor's Recommended Property Description:

All that part of Northeast Quarter of Section 16, Township 47 North, Range 31 West, in the City of Lee's Summit, Jackson County, Missouri, as described by Timothy Blair Wiswell, Missouri Professional Licensed Surveyor, PLS-2009000067, and being more particularly described as follows:

COMMENCING at the Northwest corner of the Northeast Quarter, of said Section 16-T47N-R31W; thence South 02 degrees 20 minutes 19 seconds West, along the West line of said Northeast Quarter, a distance of 20.00 feet, to a point on the South Right-of-Way line of Bailey Road as now established, said point also being the Northeast corner of Lot 164 of Newberry Second Plat, Lots 1-65, 163 and 164, a subdivision in the City of Lee's Summit, Jackson County, Missouri; thence South 88 degrees 07 minutes 48 seconds East, on the South Right-of-Way line of said Bailey Road, a distance of 1,350.00 feet, to a point; thence South 35 degrees 20 minutes 58 seconds West, departing the South Right-of-Way line of said Bailey Road, a distance of 517.08 feet, to a point; thence South 07 degrees 56 minutes 53 seconds West, a distance of 320.18 feet, to a point; thence South 12 degrees 12 minutes 42 seconds West, a distance of 1,168.07 feet, to a point; thence South 27 degrees 41 minutes 50 seconds West, a distance of 480.35 feet, to a point on a line that is 300.00 feet North of and parallel to the South line of said Northeast Quarter; thence North 88 degrees 04 minutes 43 seconds West, on said parallel line, a distance of 630.96 feet, to a point on the West line of said Northeast Quarter, said point also being on the East line of Newberry Fourth Plat, a subdivision in the City of Lee's Summit, Jackson County, Missouri; thence North 02 degrees 20 minutes 19 seconds East, on the West line of said Northeast Quarter, and on the East line of said Newberry Fourth Plat, and on the East line of Newberry Third Plat, a subdivision in the City of Lee's Summit, Jackson County, Missouri, and on the East line of said Newberry Second Plat, Lots 1-65, 163 and 164, a distance of 2,330.63 feet, to the POINT OF BEGINNING, containing 2,250,248 square feet or 51.6586 acres, more or less.

DESIGN TEAM:

OWNER:

LEE'S SUMMIT R-7 SCHOOL DISTRICT
502 SE TRANSPORT DRIVE
LEE'S SUMMIT, MO 64083
816.986.3415

ARCHITECT OF RECORD:

DLR GROUP
7290 WEST 133RD ST
OVERLAND PARK, KS 66213
913.897.7811

CIVIL ENGINEER:

OLSSON
7301 WEST 133RD ST
OVERLAND PARK, KS 66213
913.381.1170

LANDSCAPE ARCHITECT:

DLR GROUP
7290 WEST 133RD ST
OVERLAND PARK, KS 66213
913.897.7811

M.E.P. ENGINEER:

HENDERSON ENGINEERS
8435 LENEXA DRIVE SUITE 300
LENEXA, KS 66214
913.742.5000

STRUCTURAL ENGINEER:

DLR GROUP
7290 WEST 133RD ST
OVERLAND PARK, KS 66213
913.897.7811

CONSTRUCTION MANAGER:

MCCOWNGORDON CONSTRUCTION
422 ADMIRAL BOULEVARD
KANSAS CITY, MO 64106
816.877.0690

LEE'S SUMMIT MIDDLE SCHOOL #4

LEE'S SUMMIT R-7 SCHOOL DISTRICT

1001 SE BAILEY ROAD
LEE'S SUMMIT, MO 64081

PRELIMINARY
DEVELOPMENT PLAN


Issue Date
REVISIONS

13-20102-00

COVER SHEET


A0.0

DWG: F:\2020\0001-0500\020-0103\40-design\AutoCAD\preliminary plans\Sheets\GNVC\GEN01_0200103.dwg USER: sjallard
DATE: May 08, 2020 11:17am XREFS: C:\BASE_0200103 C:\BASE_0200103 C:\BLK_0200103

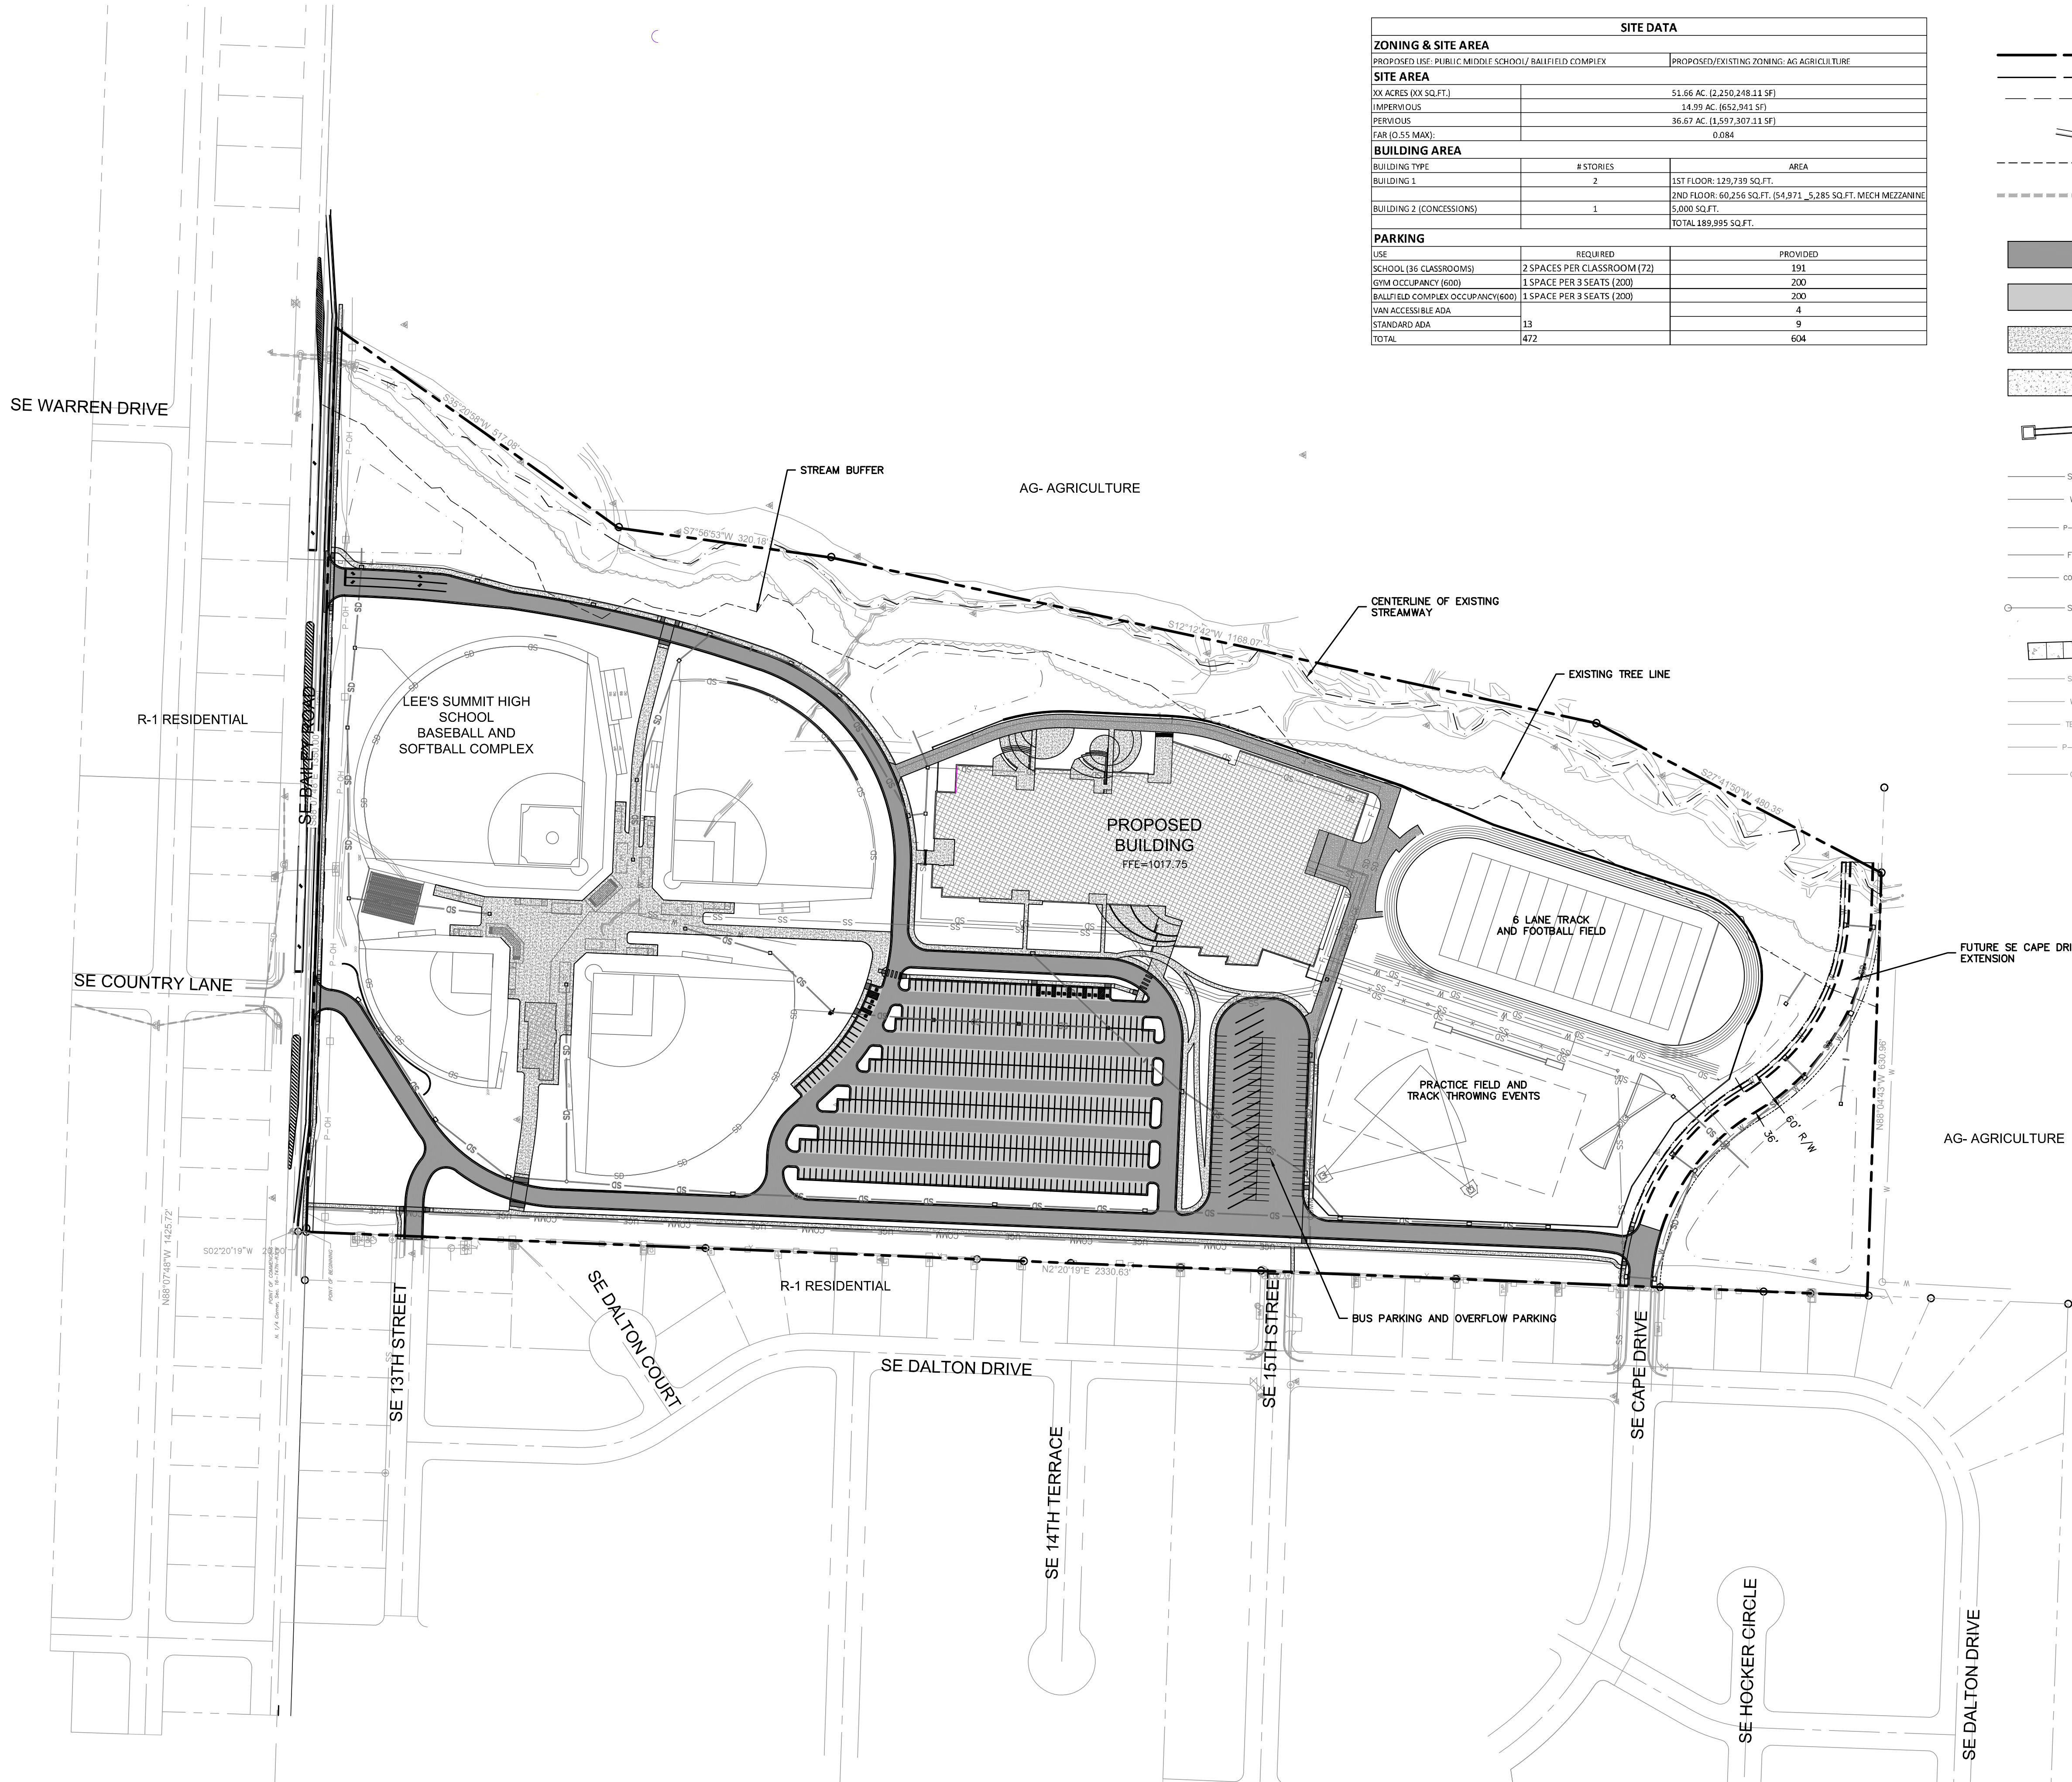


SITE DATA		
ZONING & SITE AREA		
PROPOSED USE: PUBLIC MIDDLE SCHOOL/ BALLFIELD COMPLEX		PROPOSED/EXISTING ZONING: AG AGRICULTURE
SITE AREA		
XX ACRES (XX SQ.FT.)		51.66 AC. (2,250,248.11 SF)
IMPERVIOUS		14.99 AC. (652,941 SF)
PERVIOUS		36.67 AC. (1,597,307.11 SF)
FAR (0.55 MAX):		0.084
BUILDING AREA		
BUILDING TYPE	# STORIES	AREA
BUILDING 1	2	1ST FLOOR: 129,739 SQ.FT.
BUILDING 2 (CONCESSIONS)	1	2ND FLOOR: 60,256 SQ.FT. (54,971 _ 5,285 SQ.FT. MECH MEZZANINE
		5,000 SQ.FT.
		TOTAL 189,995 SQ.FT.
PARKING		
USE	REQUIRED	PROVIDED
SCHOOL (36 CLASSROOMS)	2 SPACES PER CLASSROOM (72)	191
GYM OCCUPANCY (600)	1 SPACE PER 3 SEATS (200)	200
BALLFIELD COMPLEX OCCUPANCY(600)	1 SPACE PER 3 SEATS (200)	200
VAN ACCESSIBLE ADA		4
STANDARD ADA	13	9
TOTAL	472	604

LEGEND	
	PROPERTY LINE
	LOT LINE
	UTILITY EASEMENT
	CONSTRUCT CONCRETE CURB & GUTTER
	SAWCUT PAVEMENT FULL DEPTH
	ADA PATH — SIDEWALKS NOT DELINEATED AS ADA PATHS WILL NOT BE ADA COMPLIANT.
	HEAVY DUTY ASPHALT PAVEMENT
	STANDARD DUTY ASPHALT PAVEMENT
	HEAVY DUTY CONCRETE PAVEMENT
	CONCRETE PAVEMENT
	STORM SEWER
	SANITARY SERVICE LINE
	WATER SERVICE LINE
	UNDERGROUND POWER SERVICE LINE
	FIRE PROTECTION LINE
	COMMUNICATIONS SERVICE LINE
	LANDSCAPE/ROOF DRAIN
	ADA CONCRETE SIDEWALK AND RAMP
	EXISTING SANITARY SEWER MAIN
	EXISTING WATER MAIN
	EXISTING COMMUNICATIONS LINE
	EXISTING ELECTRIC LINE
	EXISTING GAS MAIN

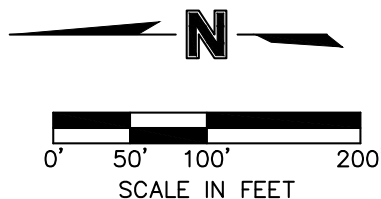


DWG: F:\2020\0001-0500\020-0103-40-Design\AutoCAD\preliminary plans\Sheets\GNVC-SIT01_0200103.dwg USER: ellard
DATE: May 08, 2020 11:18am XREFS: C:\BASE_0200103 C:\PBASE_0200103 C:\JTBKX_0200103 C:\PSURF_0200103

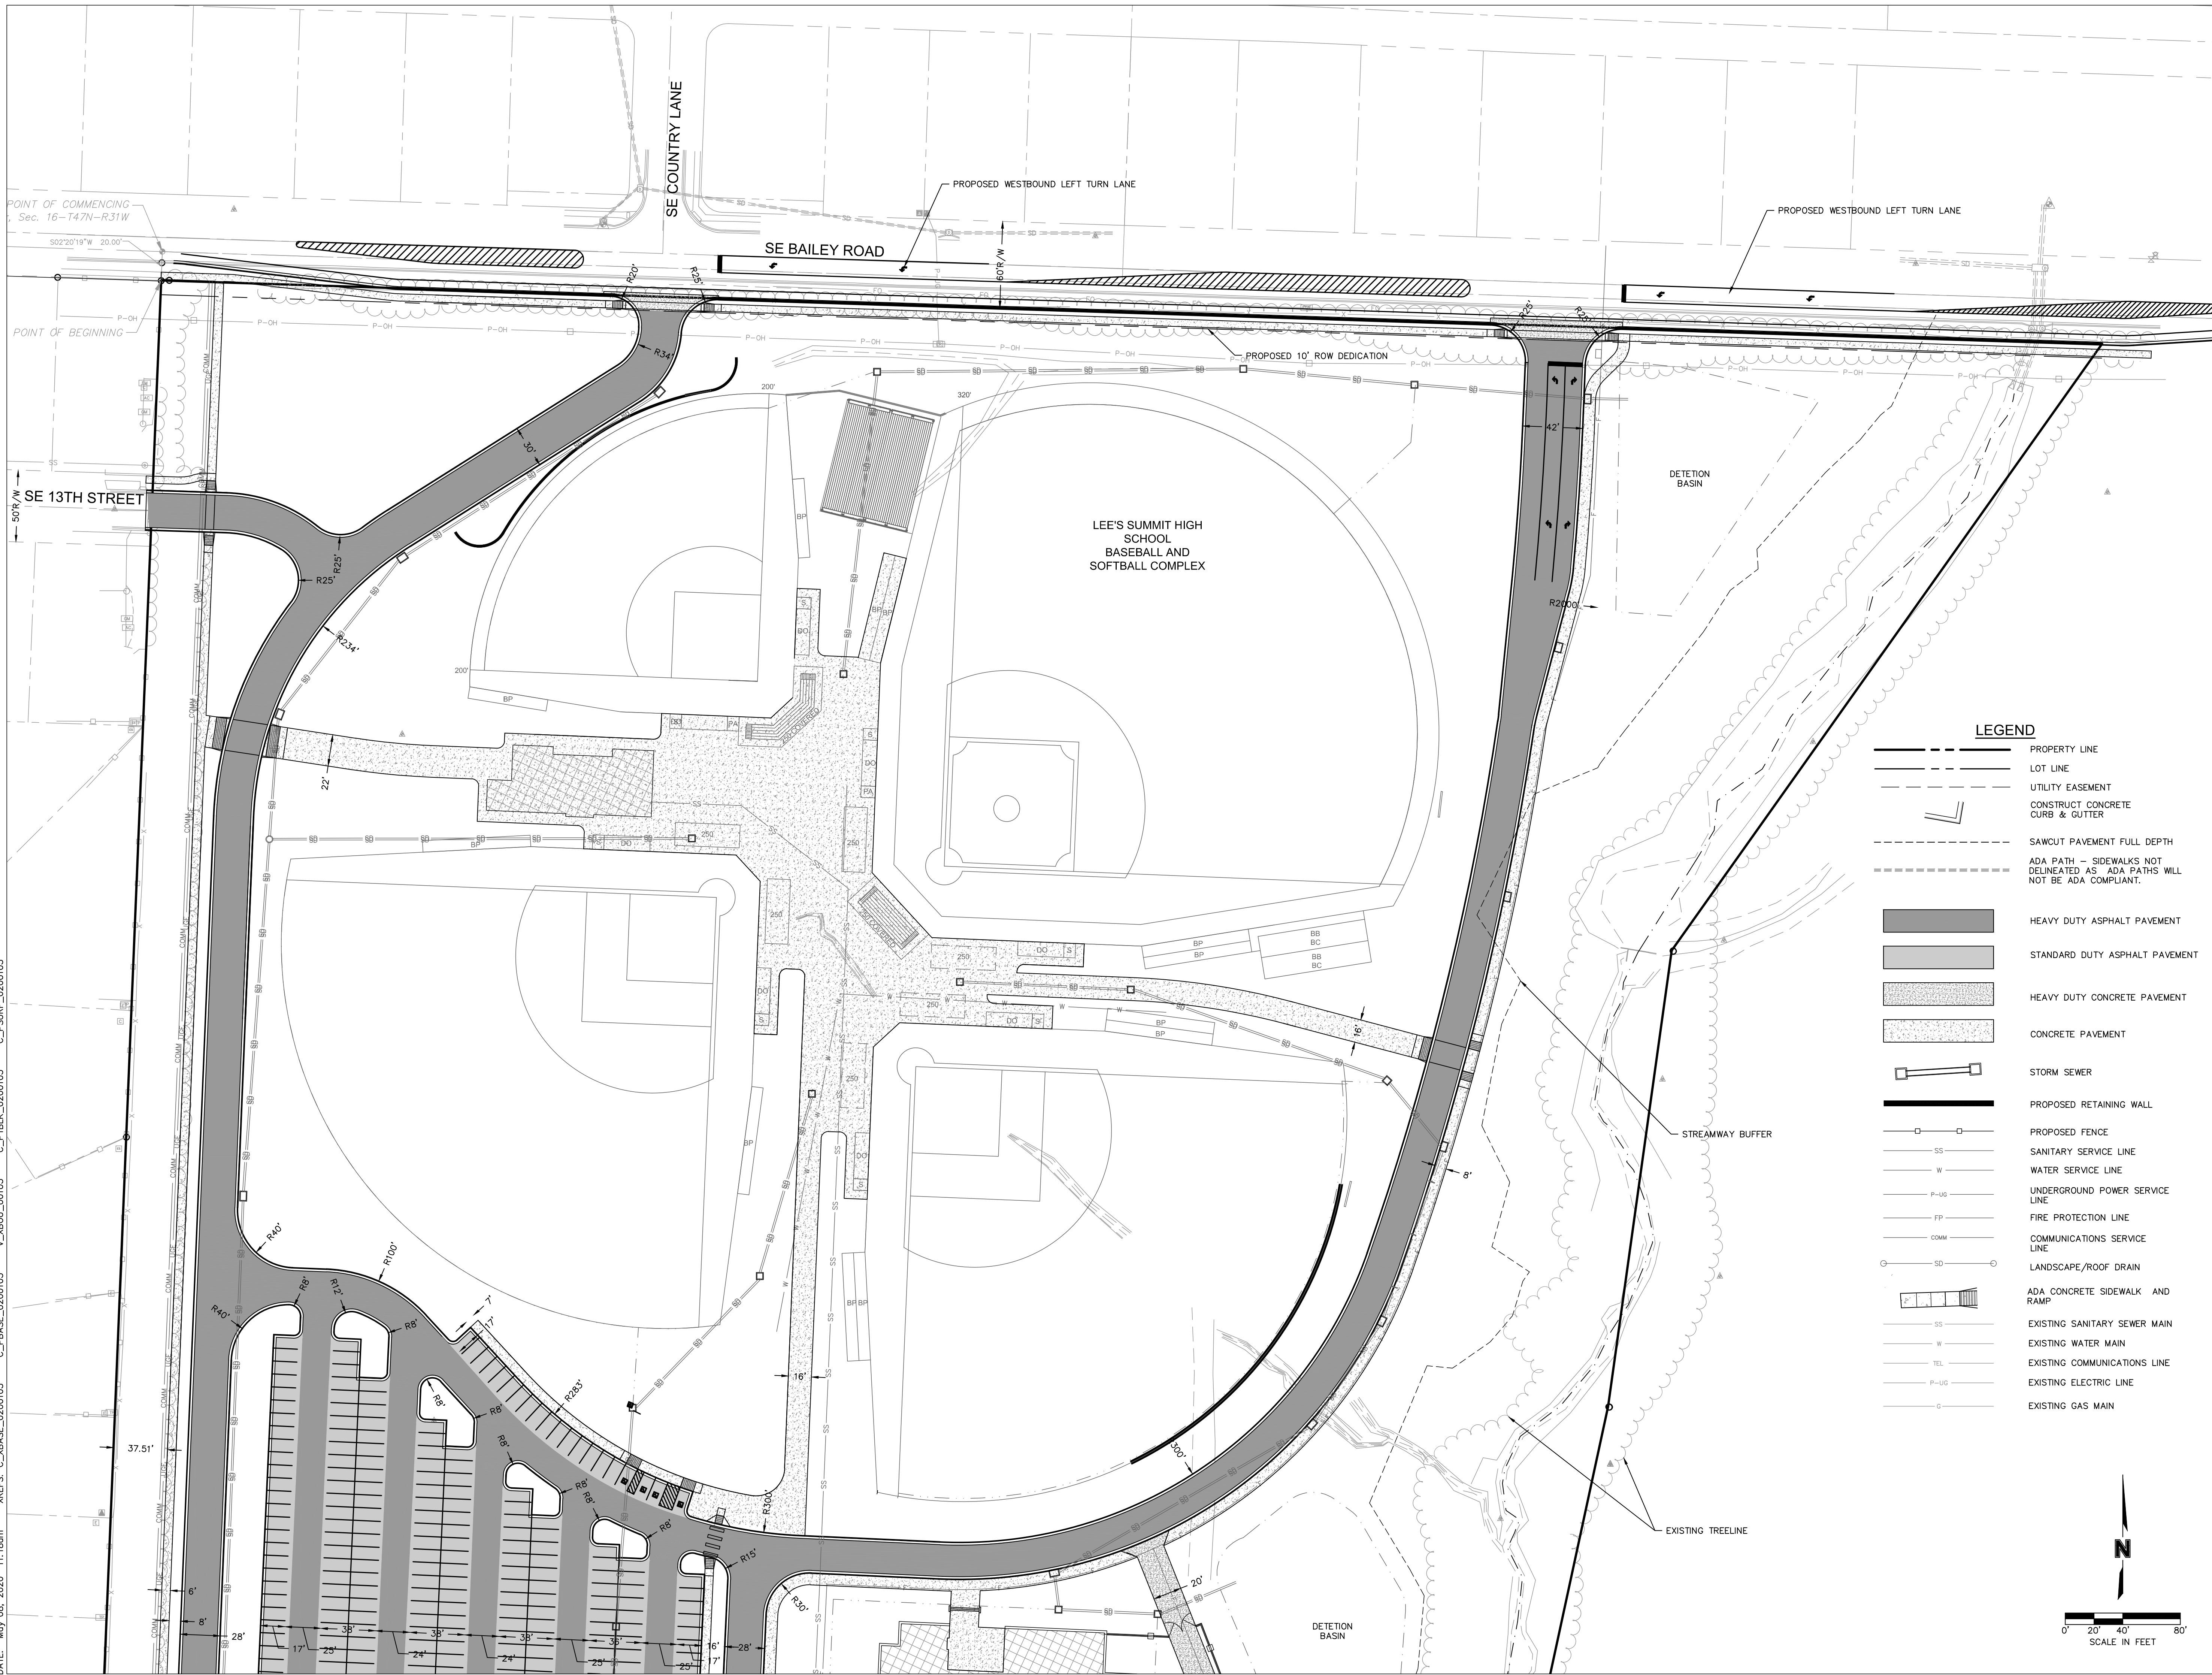

LEGEND

- PROPERTY LINE
- LOT LINE
- UTILITY EASEMENT
- CONSTRUCT CONCRETE CURB & GUTTER
- SAWCUT PAVEMENT FULL DEPTH
- ADA PATH - SIDEWALKS NOT DELINEATED AS ADA PATHS WILL NOT BE ADA COMPLIANT.
- HEAVY DUTY ASPHALT PAVEMENT
- STANDARD DUTY ASPHALT PAVEMENT
- HEAVY DUTY CONCRETE PAVEMENT
- CONCRETE PAVEMENT
- STORM SEWER
- PROPOSED RETAINING WALL
- PROPOSED FENCE
- SANITARY SERVICE LINE
- WATER SERVICE LINE
- UNDERGROUND POWER SERVICE LINE
- FIRE PROTECTION LINE
- COMMUNICATIONS SERVICE LINE
- LANDSCAPE/ROOF DRAIN
- ADA CONCRETE SIDEWALK AND RAMP
- EXISTING SANITARY SEWER MAIN
- EXISTING WATER MAIN
- EXISTING COMMUNICATIONS LINE
- EXISTING ELECTRIC LINE
- EXISTING GAS MAIN

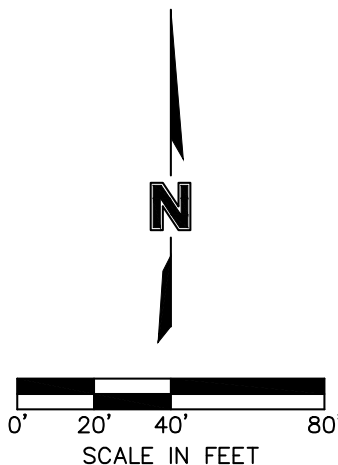


LEE'S SUMMIT MIDDLE SCHOOL #4

PRELIMINARY
DEVELOPMENT
PLAN
Issue Date 05.08.20
REVISIONS


13-20102-00
SITE PLAN

1001

DWG: F:\2020\0001-0500\020-0103\40-design\AutoCAD\preliminary plans\Sheets\GNVC-SIT01_0200103.dwg USER: ellard
DATE: May 08, 2020 11:18am XREFS: C_XBASE_0200103 C_PBASE_0200103 C_PTLBLK_0200103 C_PSURF_0200103

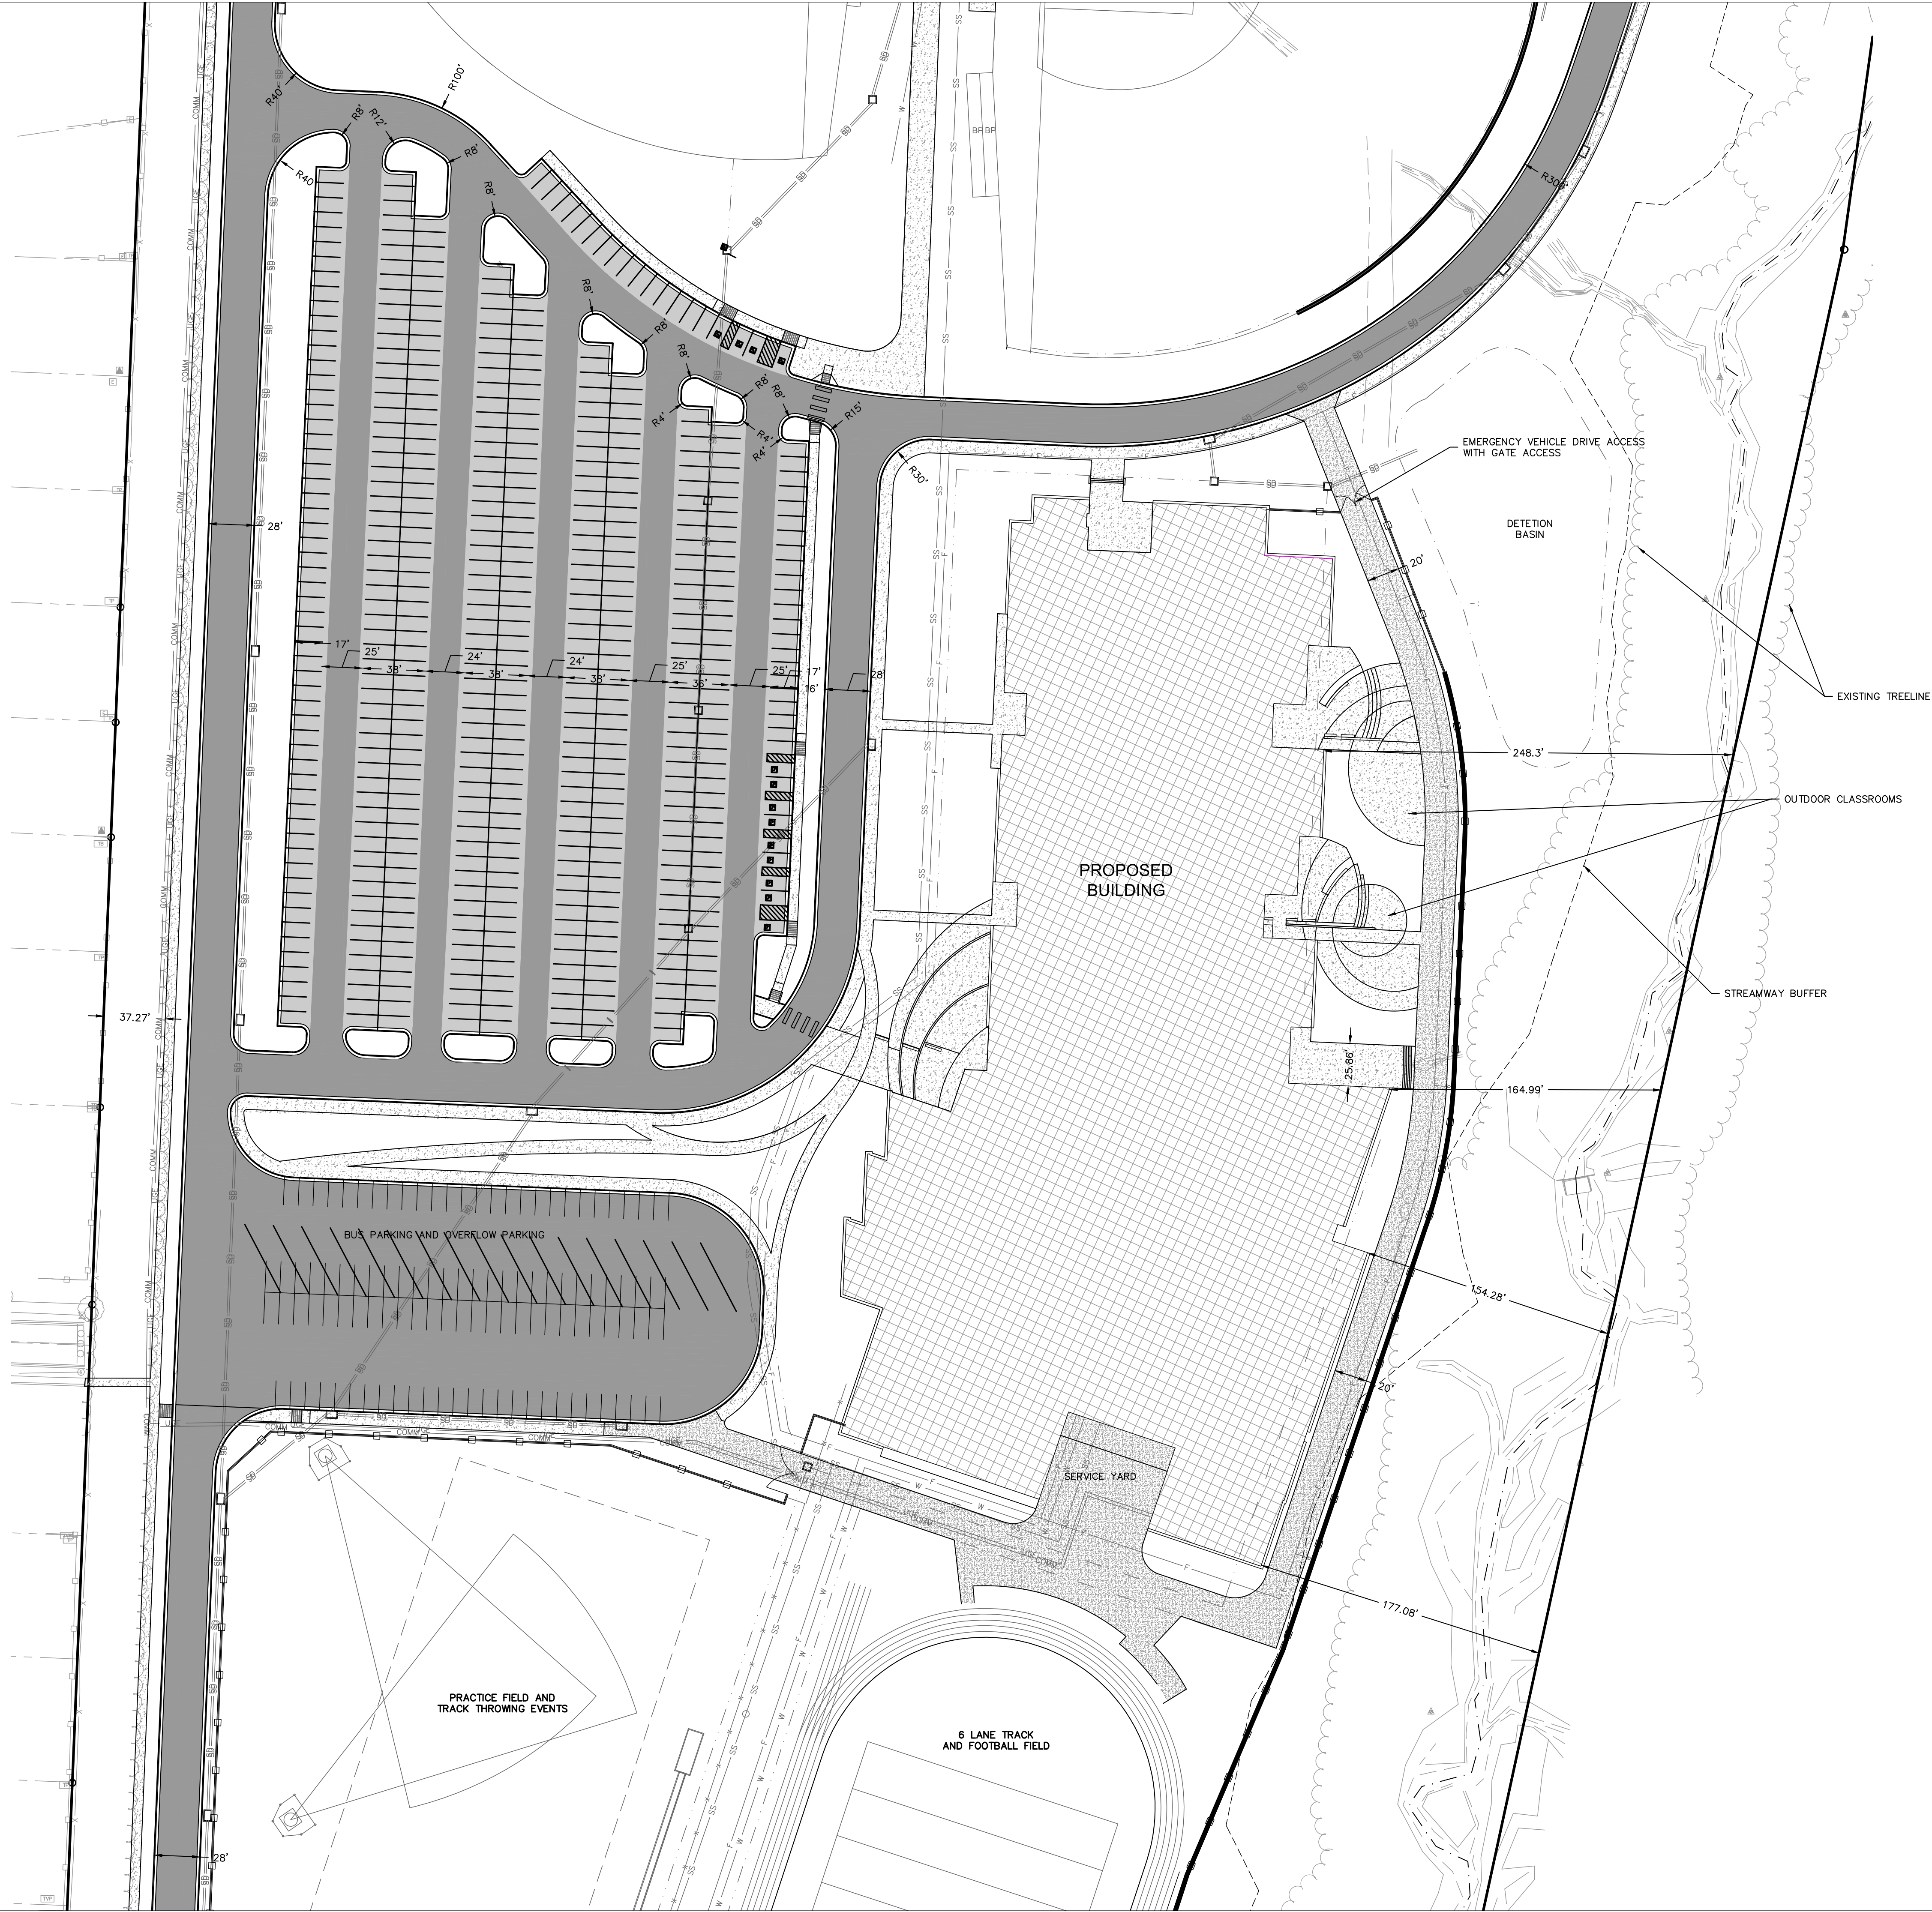

- LEGEND**
- PROPERTY LINE
 - LOT LINE
 - UTILITY EASEMENT
 - CONSTRUCT CONCRETE CURB & GUTTER
 - SAWCUT PAVEMENT FULL DEPTH
 - ADA PATH - SIDEWALKS NOT DELINEATED AS ADA PATHS WILL NOT BE ADA COMPLIANT.
 - HEAVY DUTY ASPHALT PAVEMENT
 - STANDARD DUTY ASPHALT PAVEMENT
 - HEAVY DUTY CONCRETE PAVEMENT
 - CONCRETE PAVEMENT
 - STORM SEWER
 - PROPOSED RETAINING WALL
 - PROPOSED FENCE
 - SANITARY SERVICE LINE
 - WATER SERVICE LINE
 - UNDERGROUND POWER SERVICE LINE
 - FIRE PROTECTION LINE
 - COMMUNICATIONS SERVICE LINE
 - LANDSCAPE/ROOF DRAIN
 - ADA CONCRETE SIDEWALK AND RAMP
 - EXISTING SANITARY SEWER MAIN
 - EXISTING WATER MAIN
 - EXISTING COMMUNICATIONS LINE
 - EXISTING ELECTRIC LINE
 - EXISTING GAS MAIN

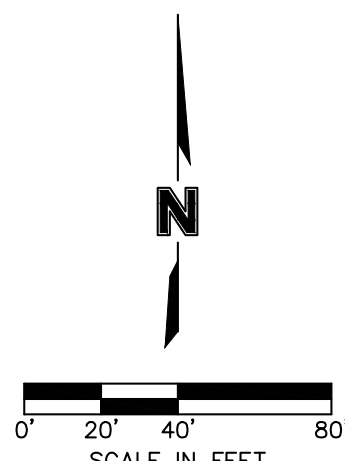

LEE'S SUMMIT MIDDLE SCHOOL #4

PRELIMINARY
DEVELOPMENT
PLAN
Issue Date 05.08.20
REVISIONS

13-20102-00
SITE PLAN

1002




olsson

7301 West 134th Street, Suite 200
Overland Park, KS 66213-4750
TEL 913.381.1170
www.olson.com

Lee's Summit, MO


DWG: F:\2020\0001-0500\020-0103\40-design\AutoCAD\preliminary plans\Sheets\GNVC-SIT01_0200103.dwg
DATE: May 08, 2020 11:19am
XREFS: C_XBASE_0200103 C_PBASE_0200103 C_PTBK_0200103 C_PSURF_0200103

USER: ellard

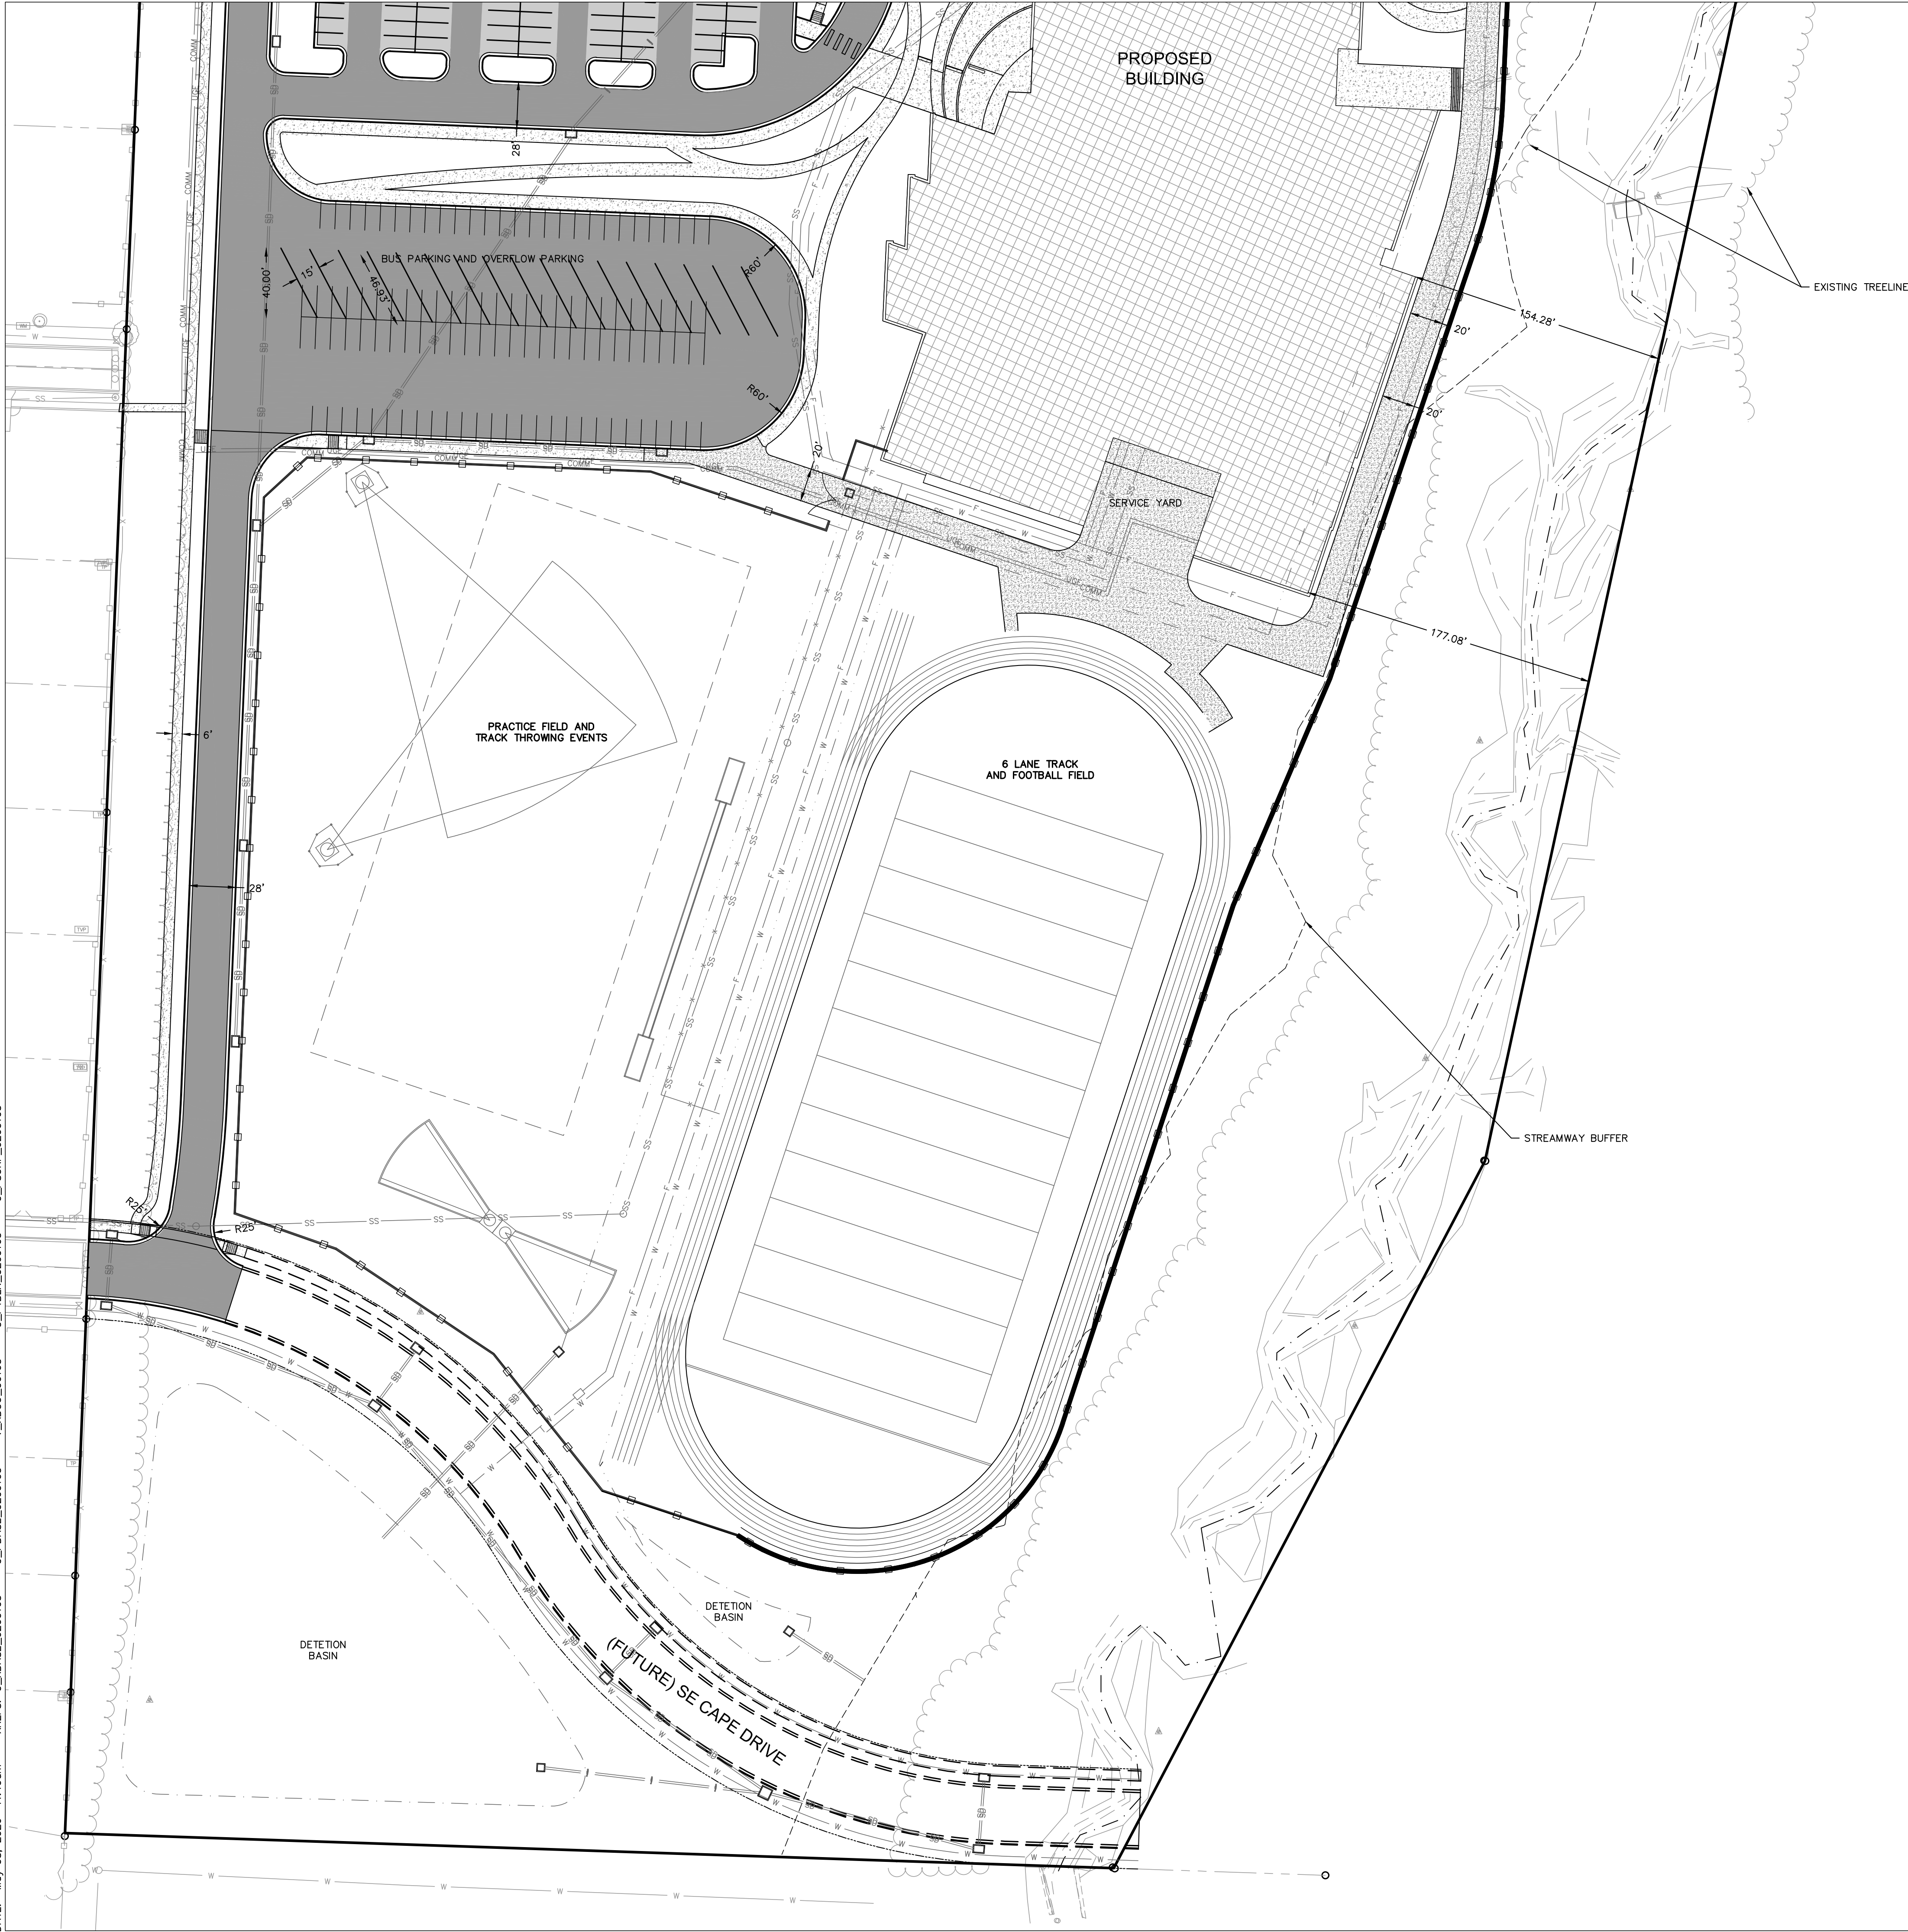

LEGEND

- PROPERTY LINE
- LOT LINE
- UTILITY EASEMENT
- CONSTRUCT CONCRETE CURB & GUTTER
- SAWCUT PAVEMENT FULL DEPTH
- ADA PATH - SIDEWALKS NOT DELINEATED AS ADA PATHS WILL NOT BE ADA COMPLIANT.
- HEAVY DUTY ASPHALT PAVEMENT
- STANDARD DUTY ASPHALT PAVEMENT
- HEAVY DUTY CONCRETE PAVEMENT
- CONCRETE PAVEMENT
- STORM SEWER
- PROPOSED RETAINING WALL
- PROPOSED FENCE
- SANITARY SERVICE LINE
- WATER SERVICE LINE
- UNDERGROUND POWER SERVICE LINE
- FIRE PROTECTION LINE
- COMMUNICATIONS SERVICE LINE
- LANDSCAPE/ROOF DRAIN
- ADA CONCRETE SIDEWALK AND RAMP
- EXISTING SANITARY SEWER MAIN
- EXISTING WATER MAIN
- EXISTING COMMUNICATIONS LINE
- EXISTING ELECTRIC LINE
- EXISTING GAS MAIN

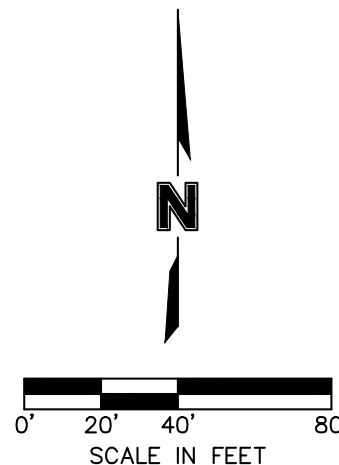

LEE'S SUMMIT MIDDLE SCHOOL #4

PRELIMINARY
DEVELOPMENT
PLAN
Issue Date 05.08.20
REVISIONS

13-20102-00
SITE PLAN

1003

olsson

7301 West 134th Street, Suite 200
Overland Park, KS 66213-4750
TEL 913.381.1170
www.olsen.com

DLR Group
© DLR Group

DWG: F:\2020\0001-0500\020-0103_40-Design\AutoCAD\preliminary plans\Sheets\GNVC\ C_GPD6D_0200103.dwg USER: sgillard
DATE: May 08, 2020 11:20am XREFS: C_XBASE_0200103 C_PBASE_0200103 C_PBLK_0200103 C_PSURF_0200103



LEGEND

- PROPERTY LINE
- EXISTING GRADE CONTOUR
- FINISHED GRADE CONTOUR
- RIDGE LINE
- VALLEY LINE
- RAMP
- CONCRETE CURB & GUTTER TYPE "B"
- CONCRETE CURB & GUTTER TYPE "B-DRY"
- CONCRETE CURB TYPE "C" MODIFIED

LEE'S SUMMIT MIDDLE SCHOOL #4

PRELIMINARY
DEVELOPMENT
PLAN
Issue Date 05.08.20
REVISIONS

13-20102-00

OVERALL GRADING
PLAN

1004

olsson

Lee's Summit, MO

7301 West 134th Street, Suite 200
Overland Park, KS 66213-4750
TEL 913.381.1770
www.olsson.com

DLR Group
© DLR Group

DWG: F:\2020\0001-0500\020-0103\40--design\AutoCAD\preliminary plans\Sheets\GNVC\G_RPD6D_0200103.dwg USER: sdillard
DATE: May 08, 2020 11:21am XREFS: C:\BASE_0200103 C:\BASE_0200103 C:\PTBLX_0200103 C:\PSURF_0200103



LEGEND


	PROPERTY LINE
	EXISTING GRADE CONTOUR
	FINISHED GRADE CONTOUR
	RIDGE LINE
	VALLEY LINE
	RAMP
	CONCRETE CURB & GUTTER TYPE "B"
	CONCRETE CURB & GUTTER TYPE "B-DRY"
	CONCRETE CURB TYPE "C" MODIFIED

LEE'S SUMMIT MIDDLE SCHOOL #4


PRELIMINARY
DEVELOPMENT
PLAN
Issue Date 05.08.20
REVISIONS

13-20102-00
OVERALL GRADING
PLAN

DWG: F:\2020\0001-0500\020-0103\40-design\AutoCAD\preliminary plans\Sheets\GNVC-JTL01_0200103.dwg USER: sjillard
DATE: May 08, 2020 11:22am XREFS: C_XBASE_0200103 C_PBASE_0200103 C_PBLK_0200103

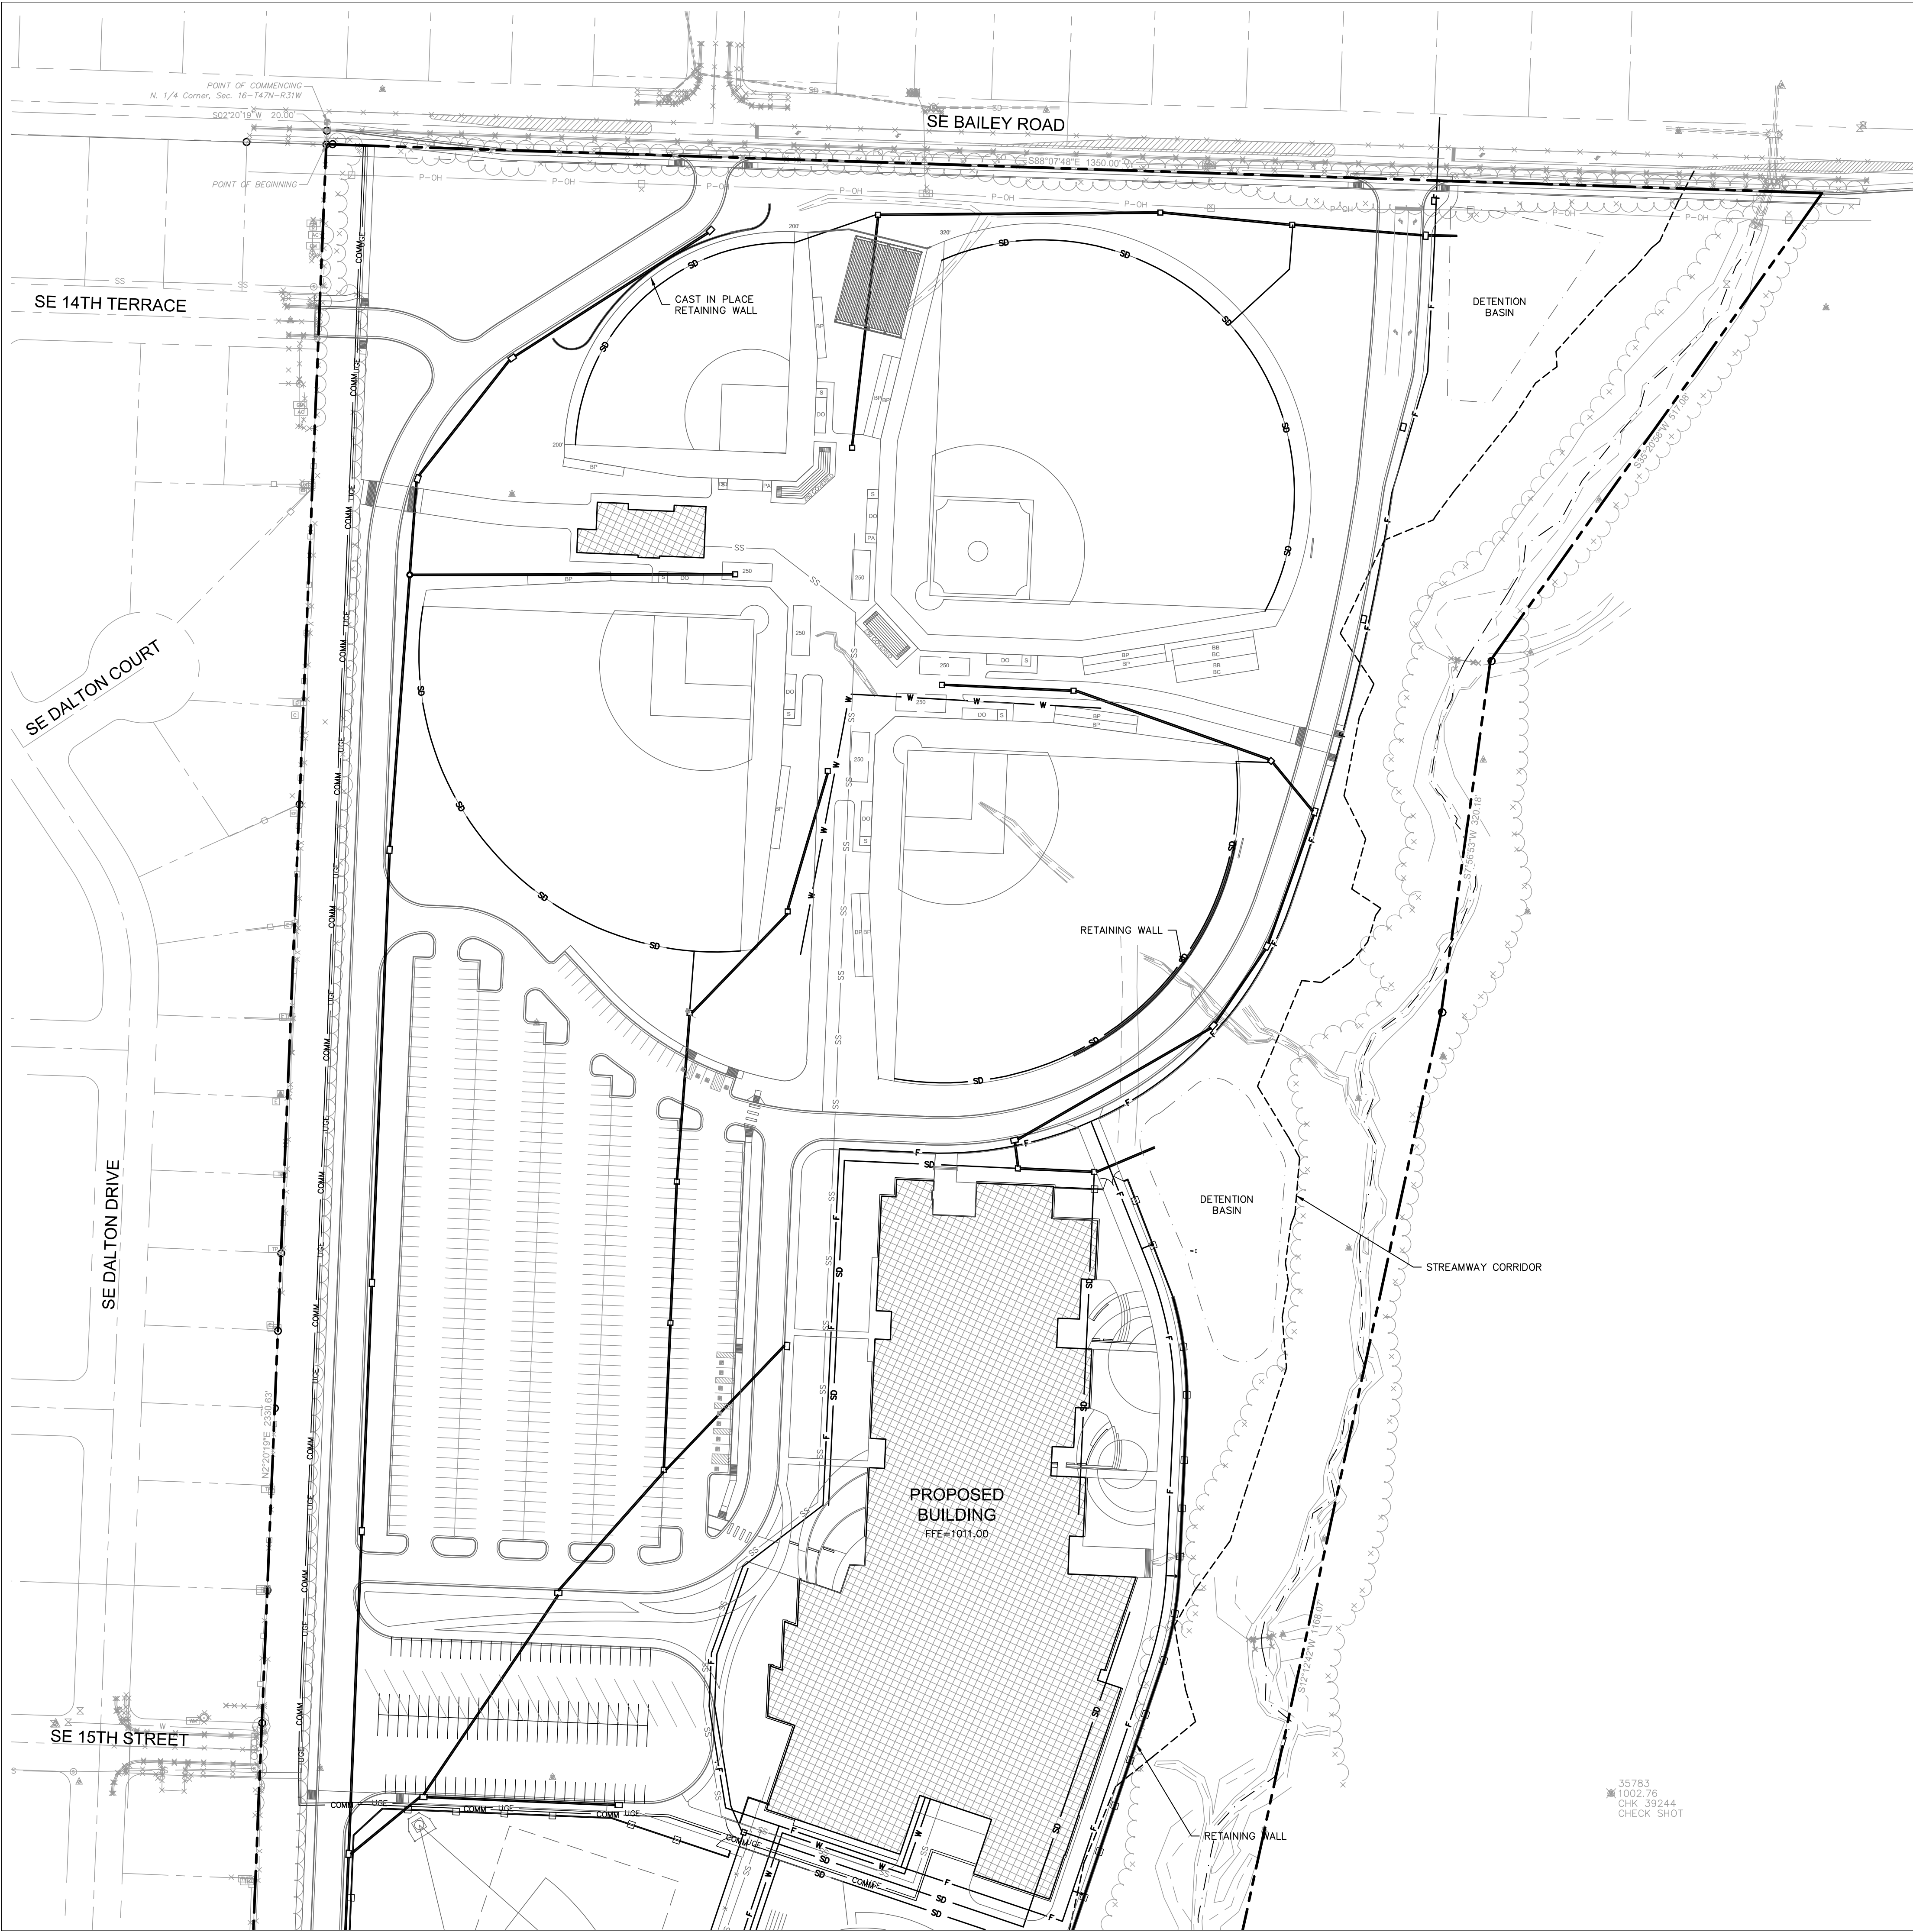

35783
1002.76
CHK 39244
CHECK SHOT

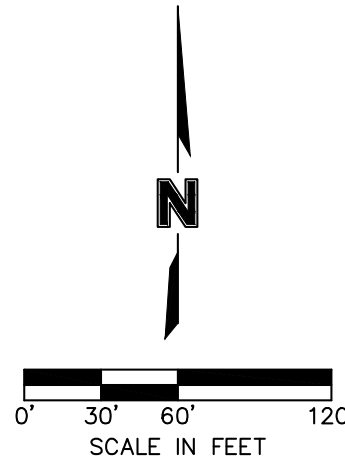

LEGEND	
	PROPERTY LINE
	LOT LINE
	UTILITY EASEMENT
	STORM SEWER
	SANITARY SERVICE LINE
	WATER SERVICE LINE
	UNDERGROUND POWER SERVICE LINE
	FIRE PROTECTION LINE
	COMMUNICATIONS SERVICE LINE
	TRENCH/LANDSCAPE/ROOF DRAIN
	EXISTING SANITARY SEWER MAIN
	EXISTING WATER MAIN
	EXISTING COMMUNICATIONS LINE
	EXISTING ELECTRIC LINE
	EXISTING GAS MAIN

LEE'S SUMMIT MIDDLE SCHOOL #4

PRELIMINARY
DEVELOPMENT
PLAN
Issue Date 05.08.20
REVISIONS

13-20102-00
UTILITY PLAN

1006


olsson

7301 West 134th Street, Suite 200
Overland Park, KS 66213-4750
TEL 913.381.1170
www.olsen.com

Lee's Summit, MO

DLR Group
© DLR Group

DWG: F:\2020\0001-0500\020-0103-40--design\AutoCAD\preliminary plans\Sheets\GNVC\JTL01_0200103.dwg USER: sjillard
DATE: May 08, 2020 11:23am XREFS: C:\BASE_0200103 C:\PBLK_0200103

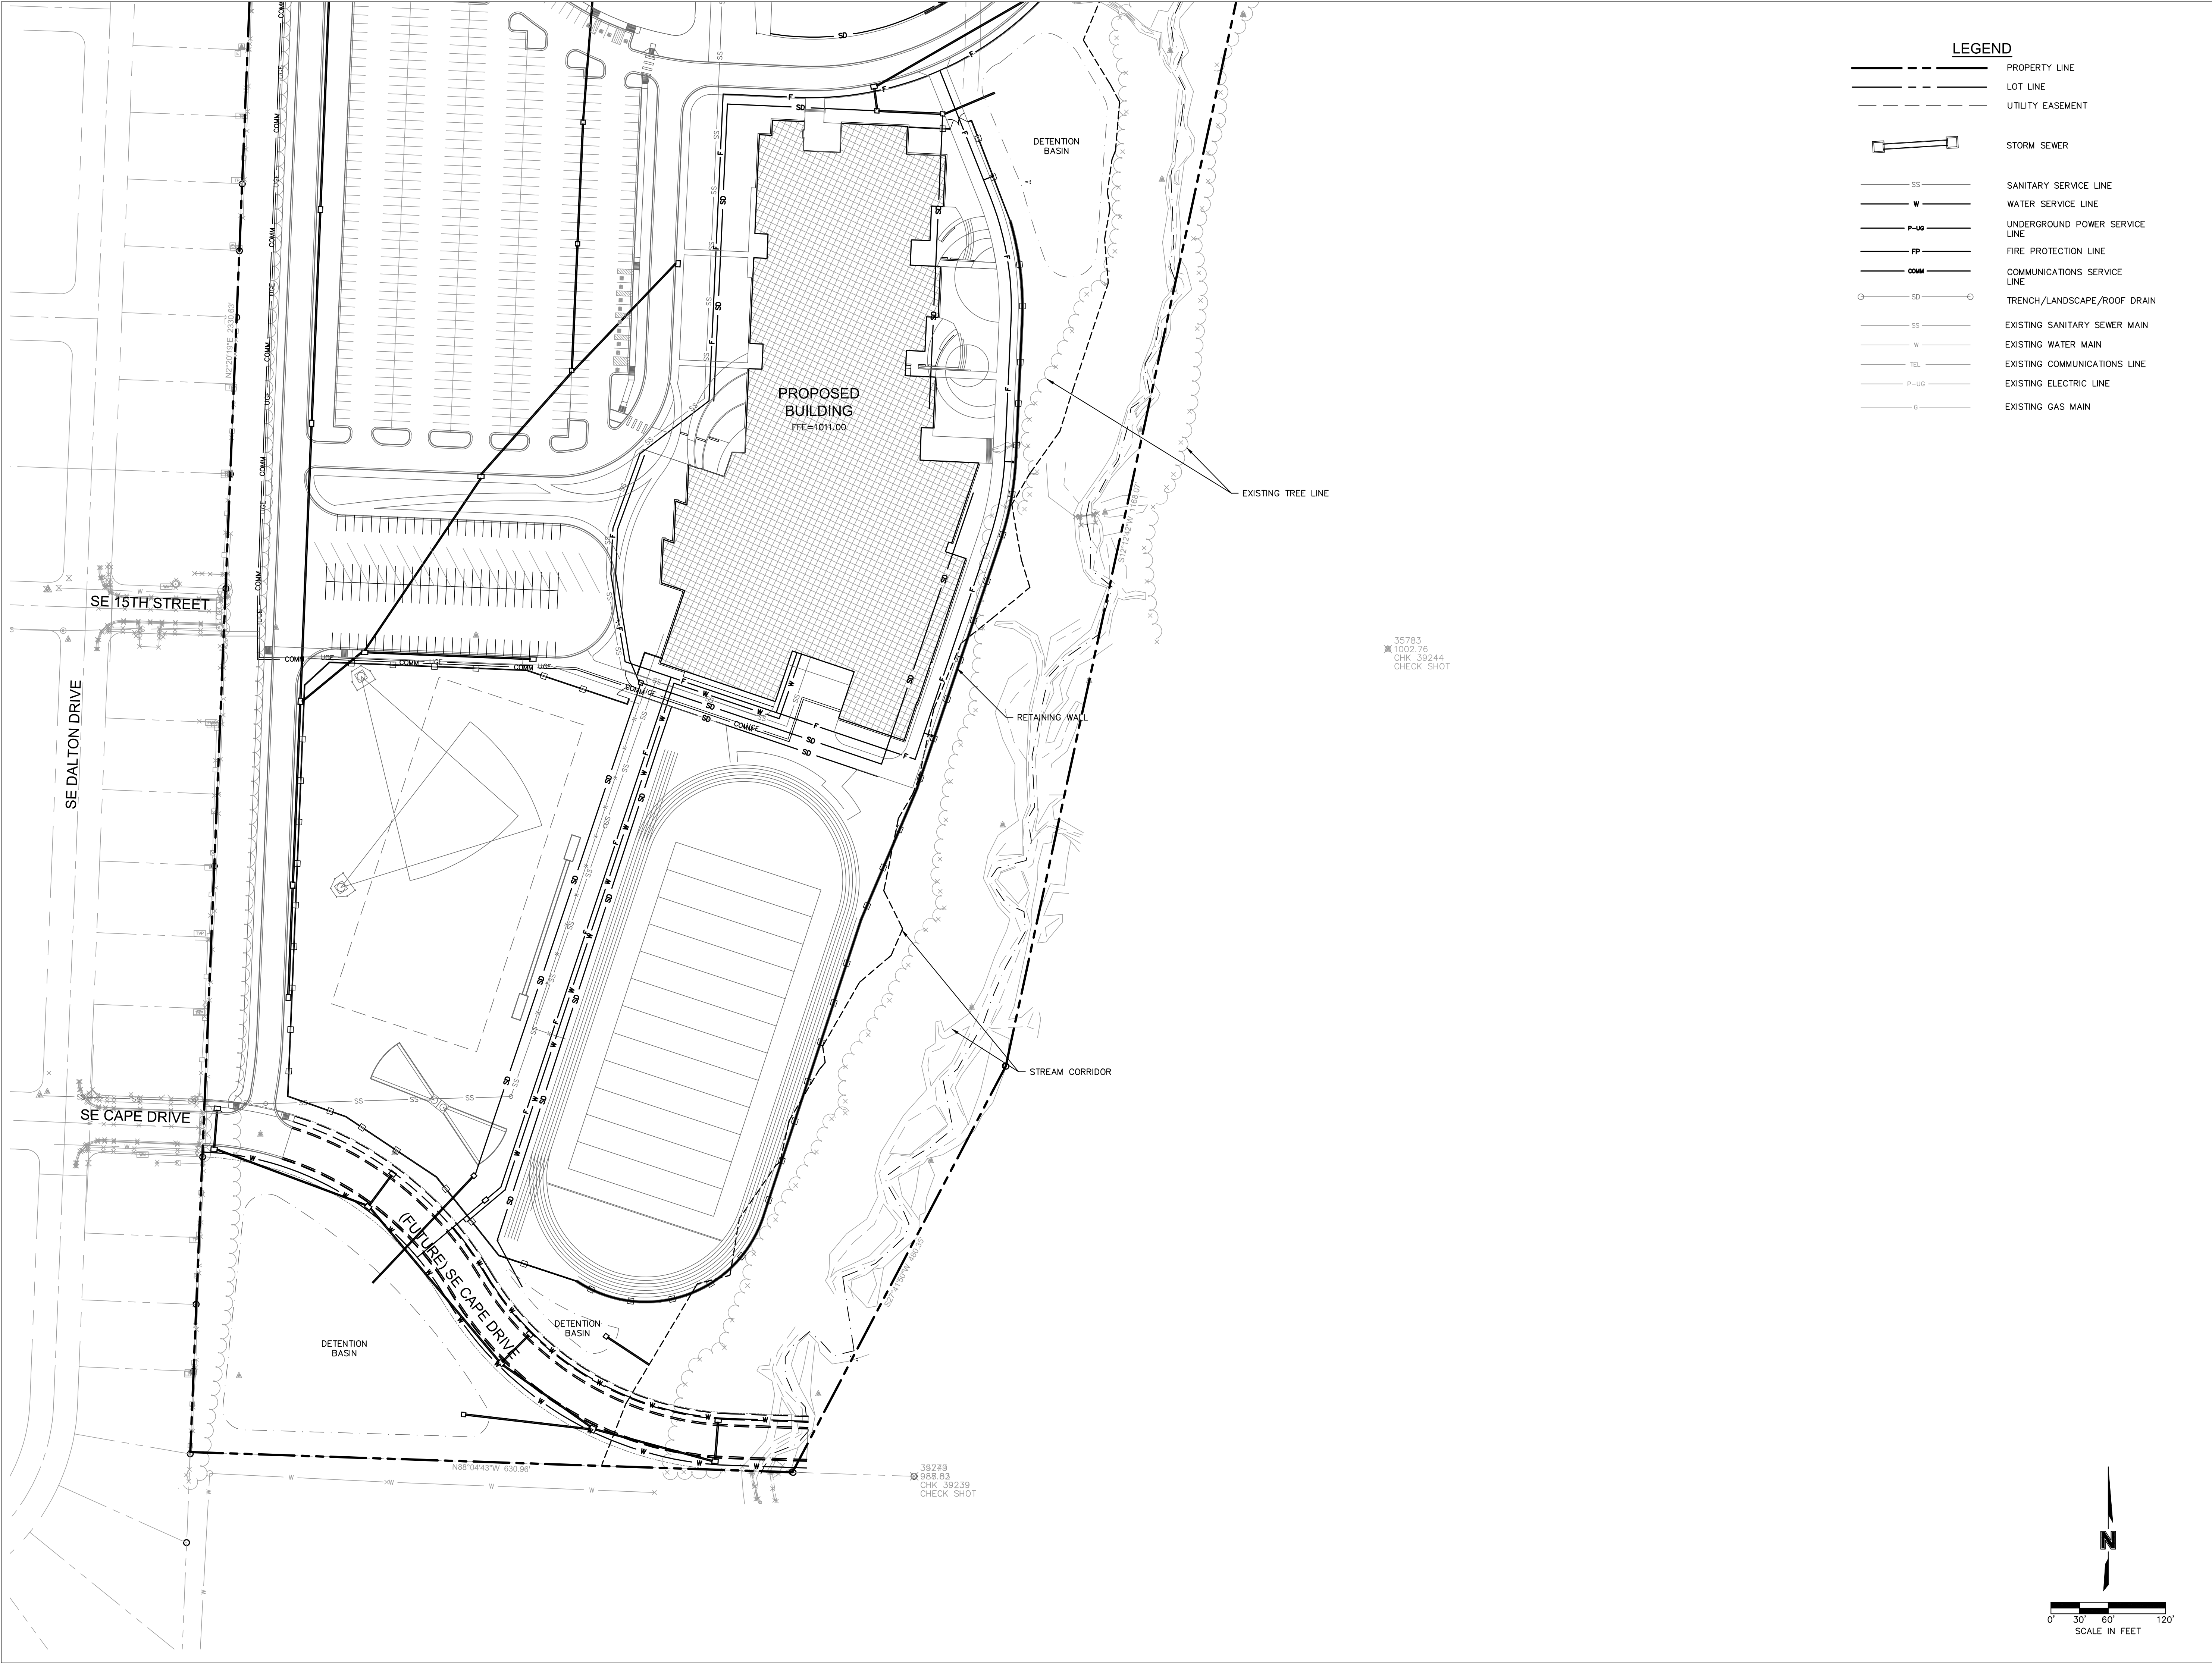

LEGEND

- PROPERTY LINE
- LOT LINE
- UTILITY EASEMENT
- STORM SEWER
- SANITARY SERVICE LINE
- WATER SERVICE LINE
- UNDERGROUND POWER SERVICE LINE
- FP
- COMM
- COMMUNICATIONS SERVICE LINE
- TRENCH/LANDSCAPE/ROOF DRAIN
- EXISTING SANITARY SEWER MAIN
- EXISTING WATER MAIN
- EXISTING COMMUNICATIONS LINE
- EXISTING ELECTRIC LINE
- EXISTING GAS MAIN

LEE'S SUMMIT MIDDLE SCHOOL #4

PRELIMINARY
DEVELOPMENT
PLAN
Issue Date 05.08.20
REVISIONS

13-20102-00
UTILITY PLAN


1007

olsson

Lee's Summit, MO

7301 West 134th Street, Suite 200
Overland Park, KS 66213-4750
TEL 913.381.1170
www.olsson.com

DLR Group
© DLR Group

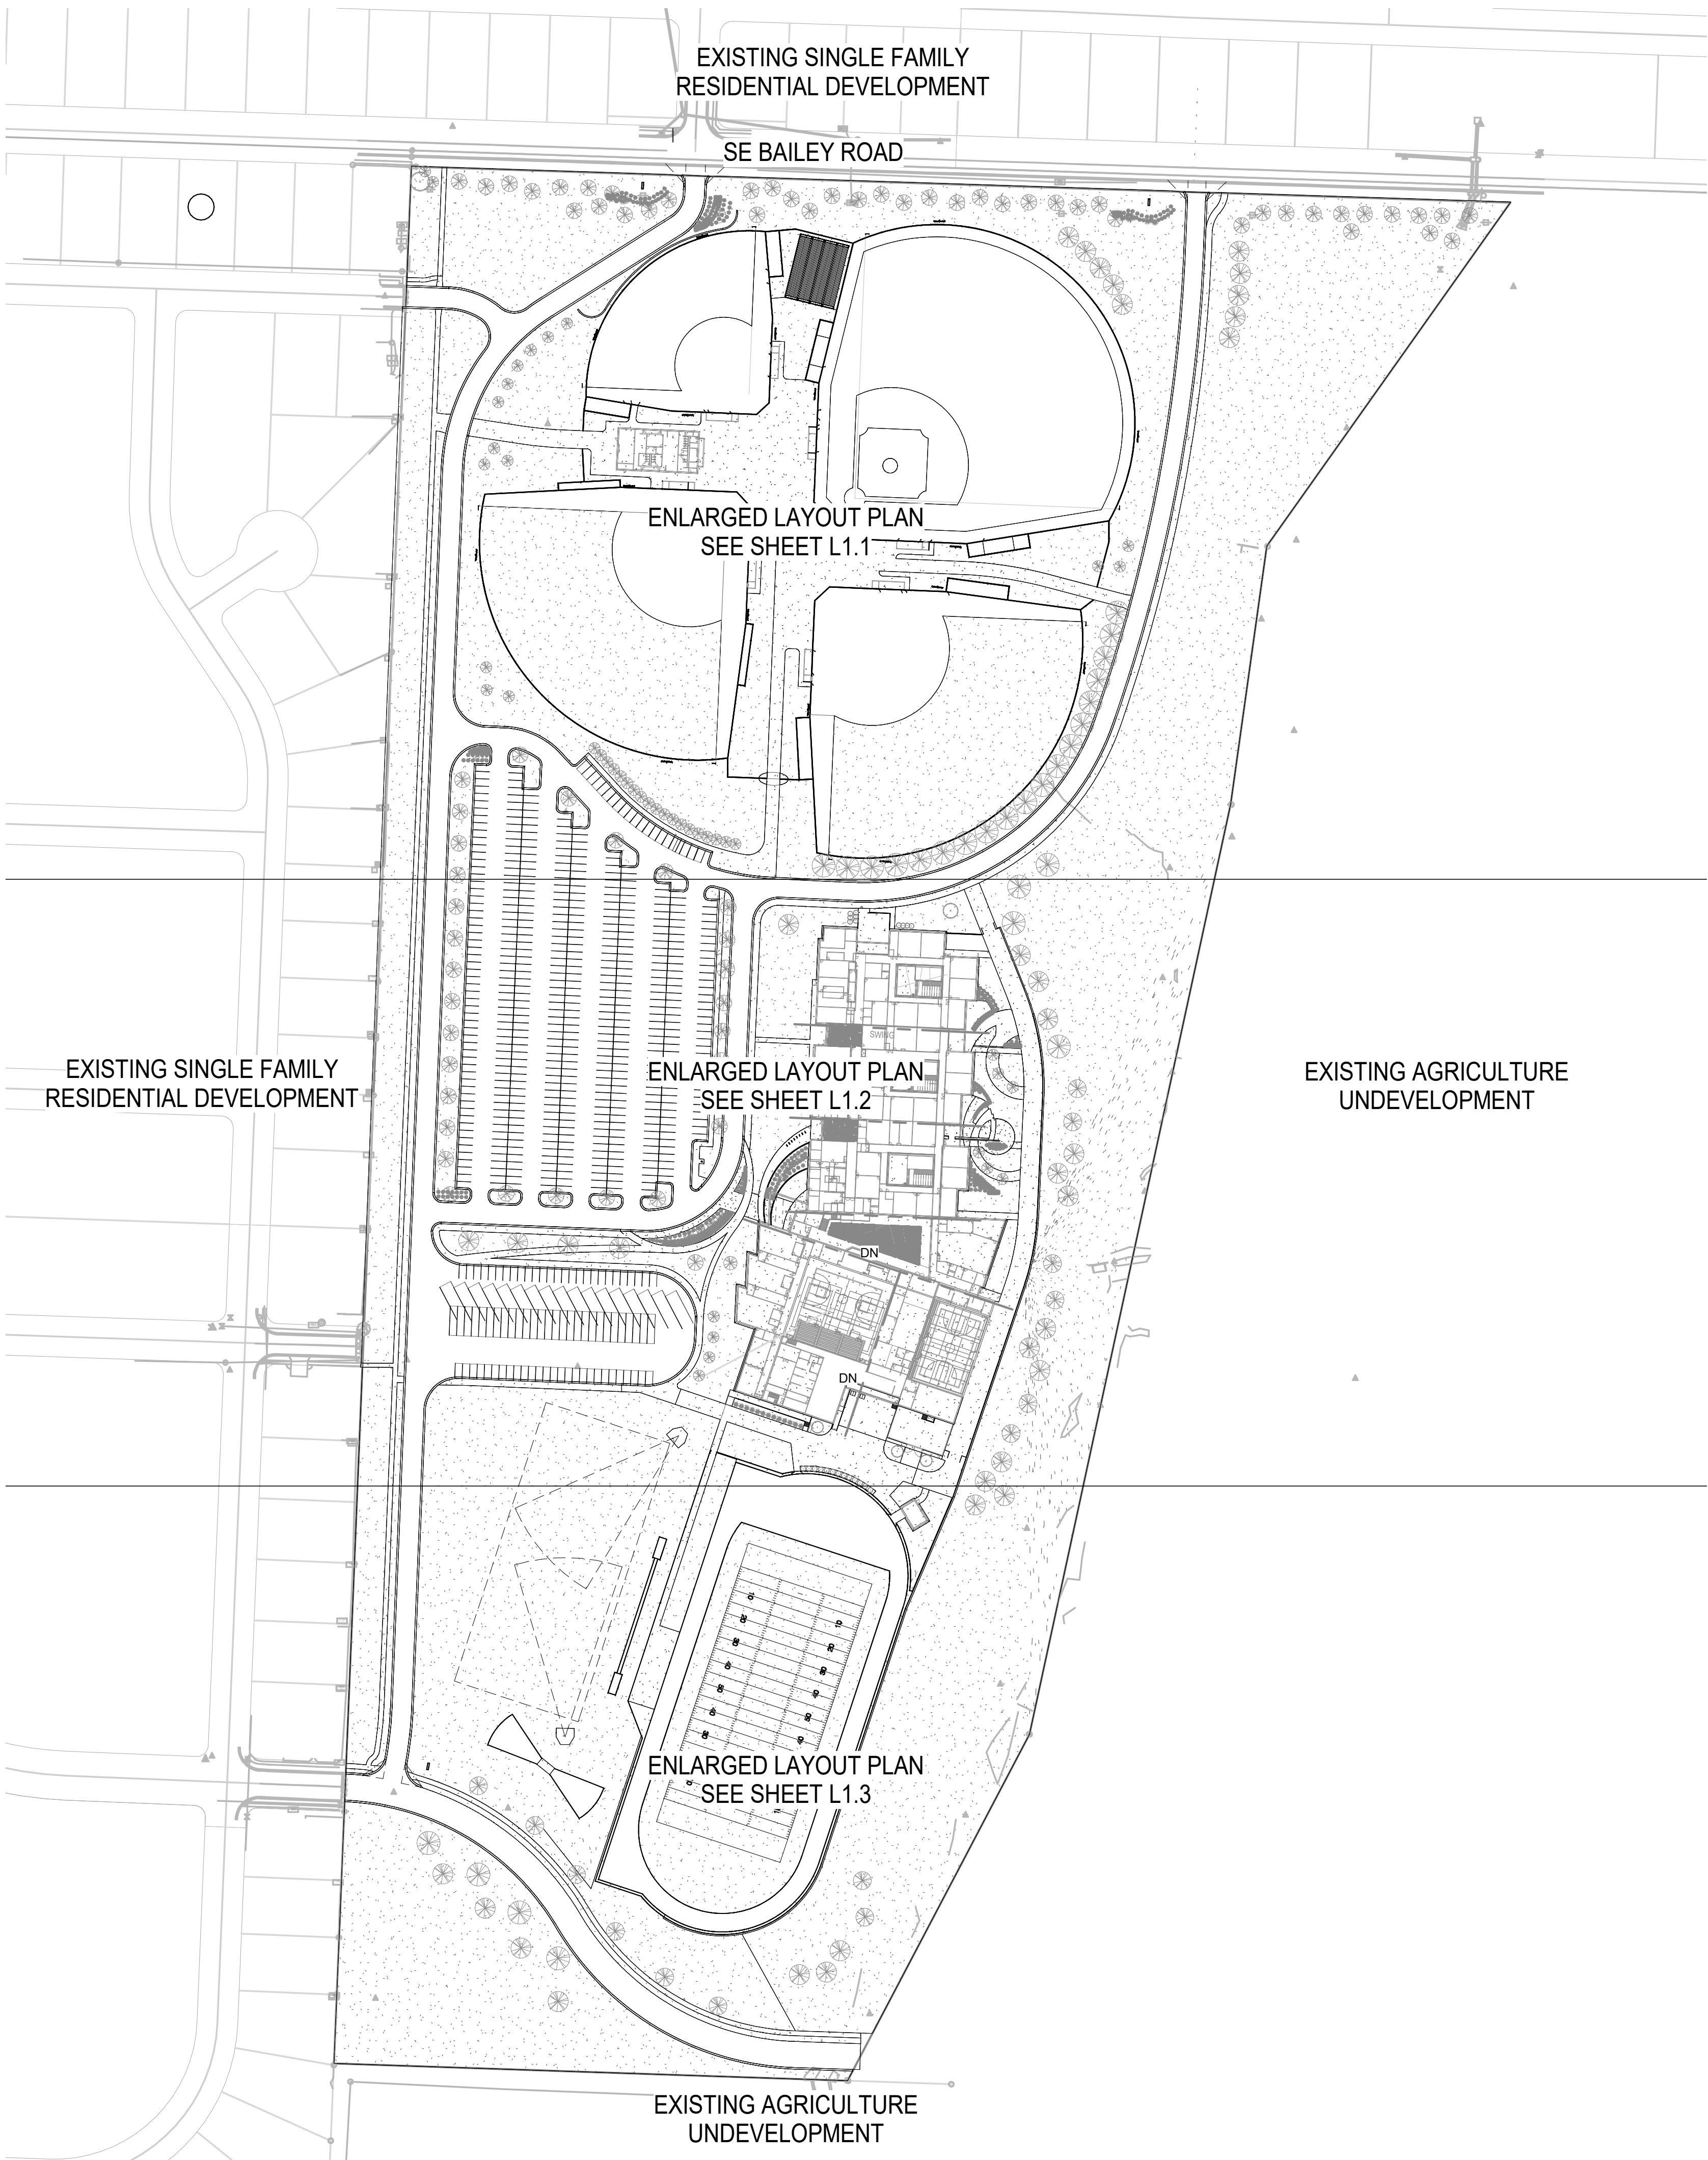


1 Overall Layout Plan
L1.0 SCALE: 1" = 120'-0"

B:\M 360\113-20102-00 Lee's Summit Middle School #4\113-20102-00_Lee's Summit Middle School 4_LS_2020.rvt
15/7/2020 6:15:04 PM


1
L1.1

2 - Ballfield Layout

SCALE: 1" = 40'-0"

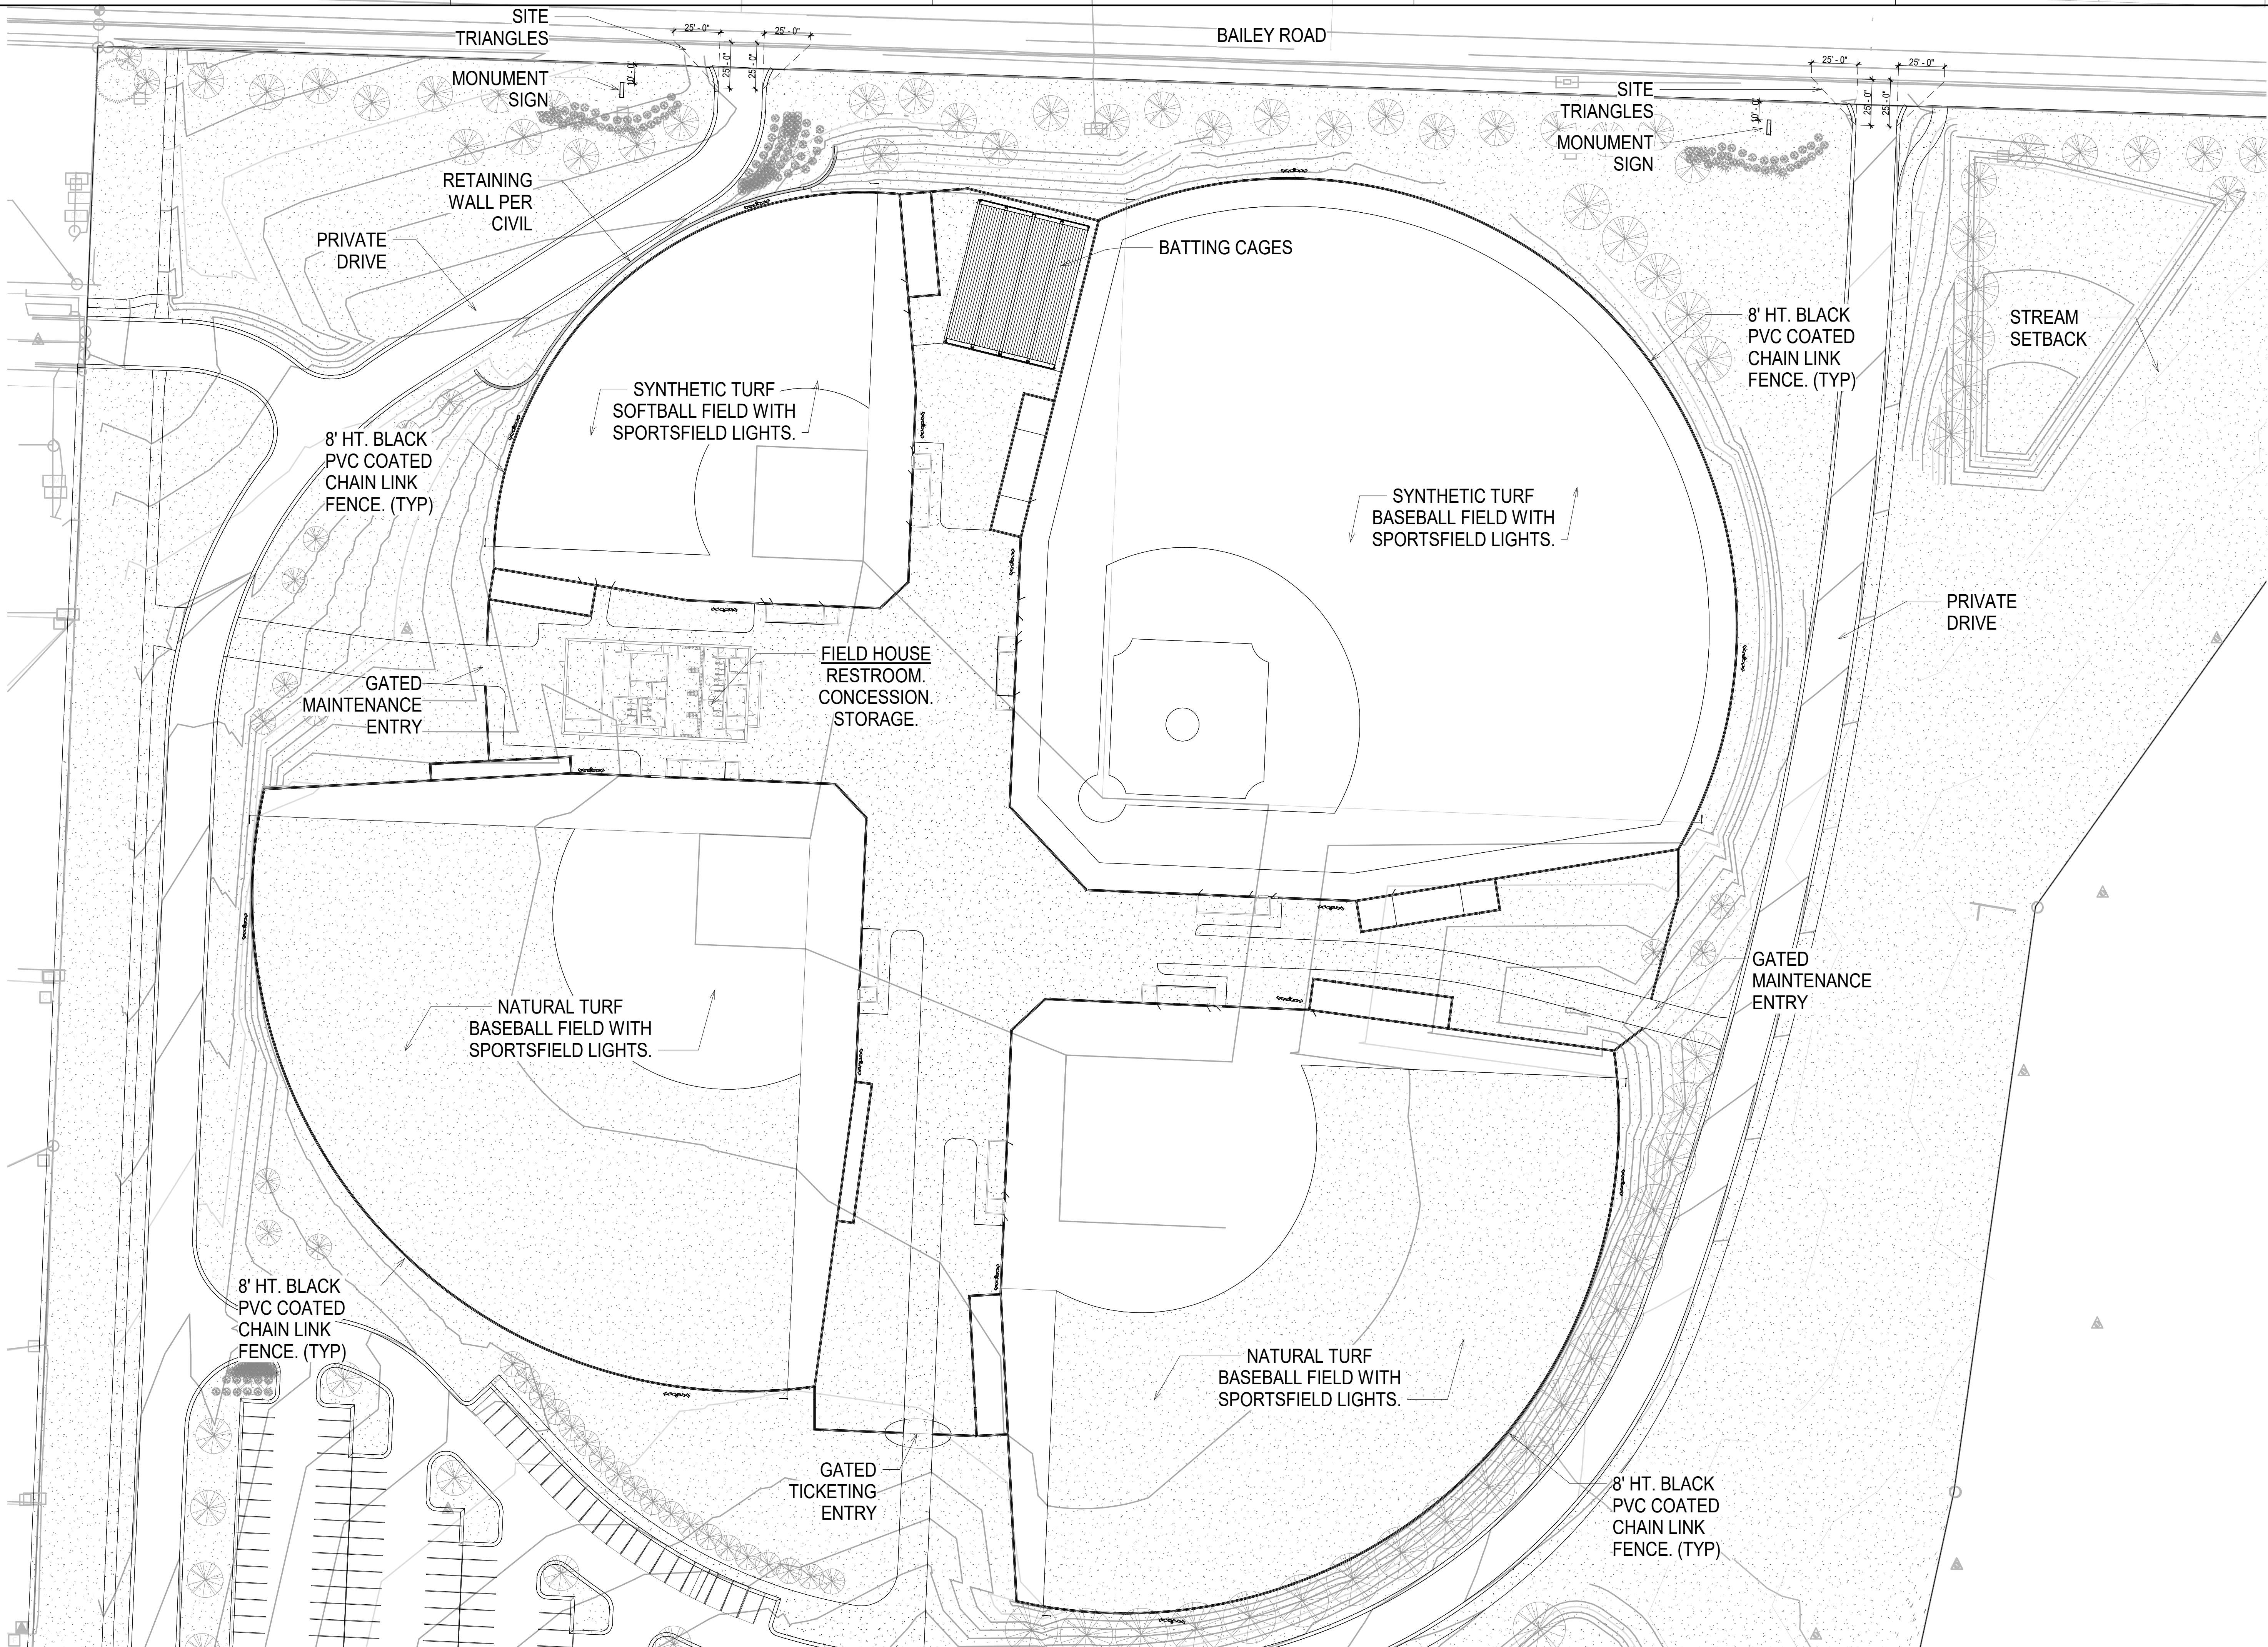


B:\M 360\113-20102-00 Lee's Summit Middle School #4\13-20102-00_Lee's Summit Middle School 4_LS_2020.rvt
5/7/2020 6:16:17 PM

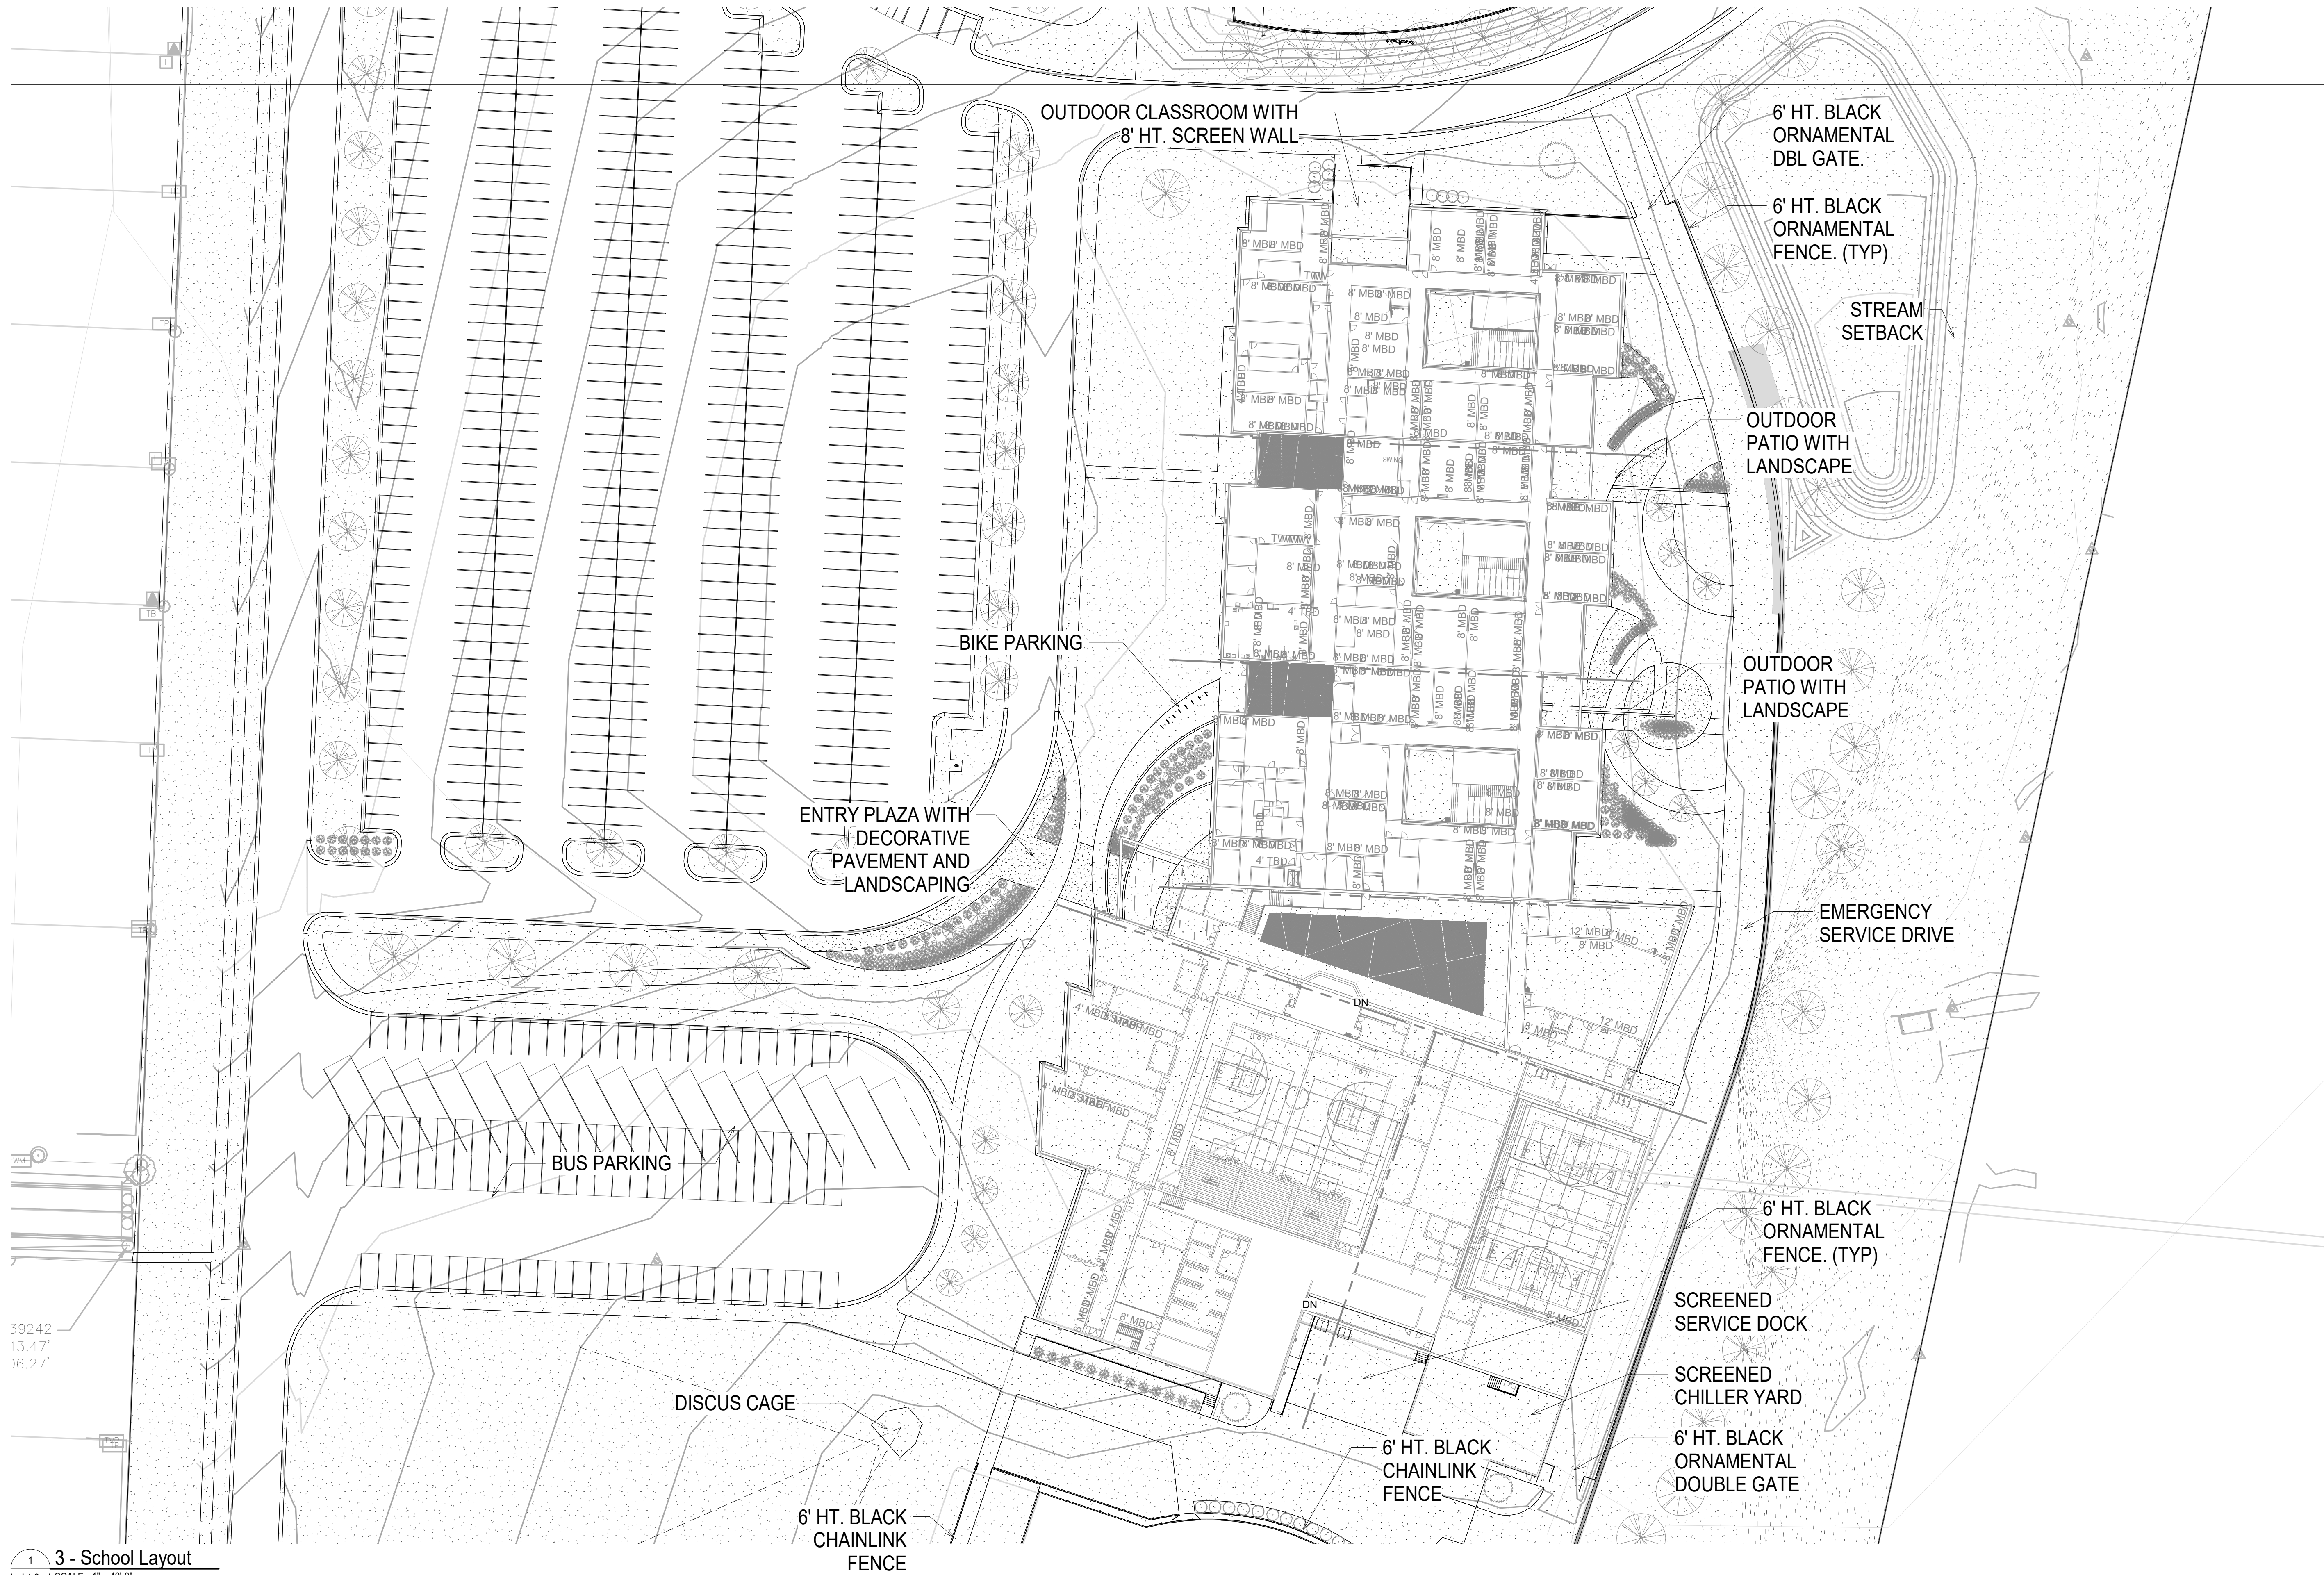

1 3 - School Layout
L1.2 SCALE: 1" = 40'-0"

B:\M 360\113-20102-00 Lee's Summit Middle School #4\13-20102-00_Lee's Summit Middle School 4_L13_2020.rvt
5/7/2020 6:16:22 PM

6" PVC=1006.27'

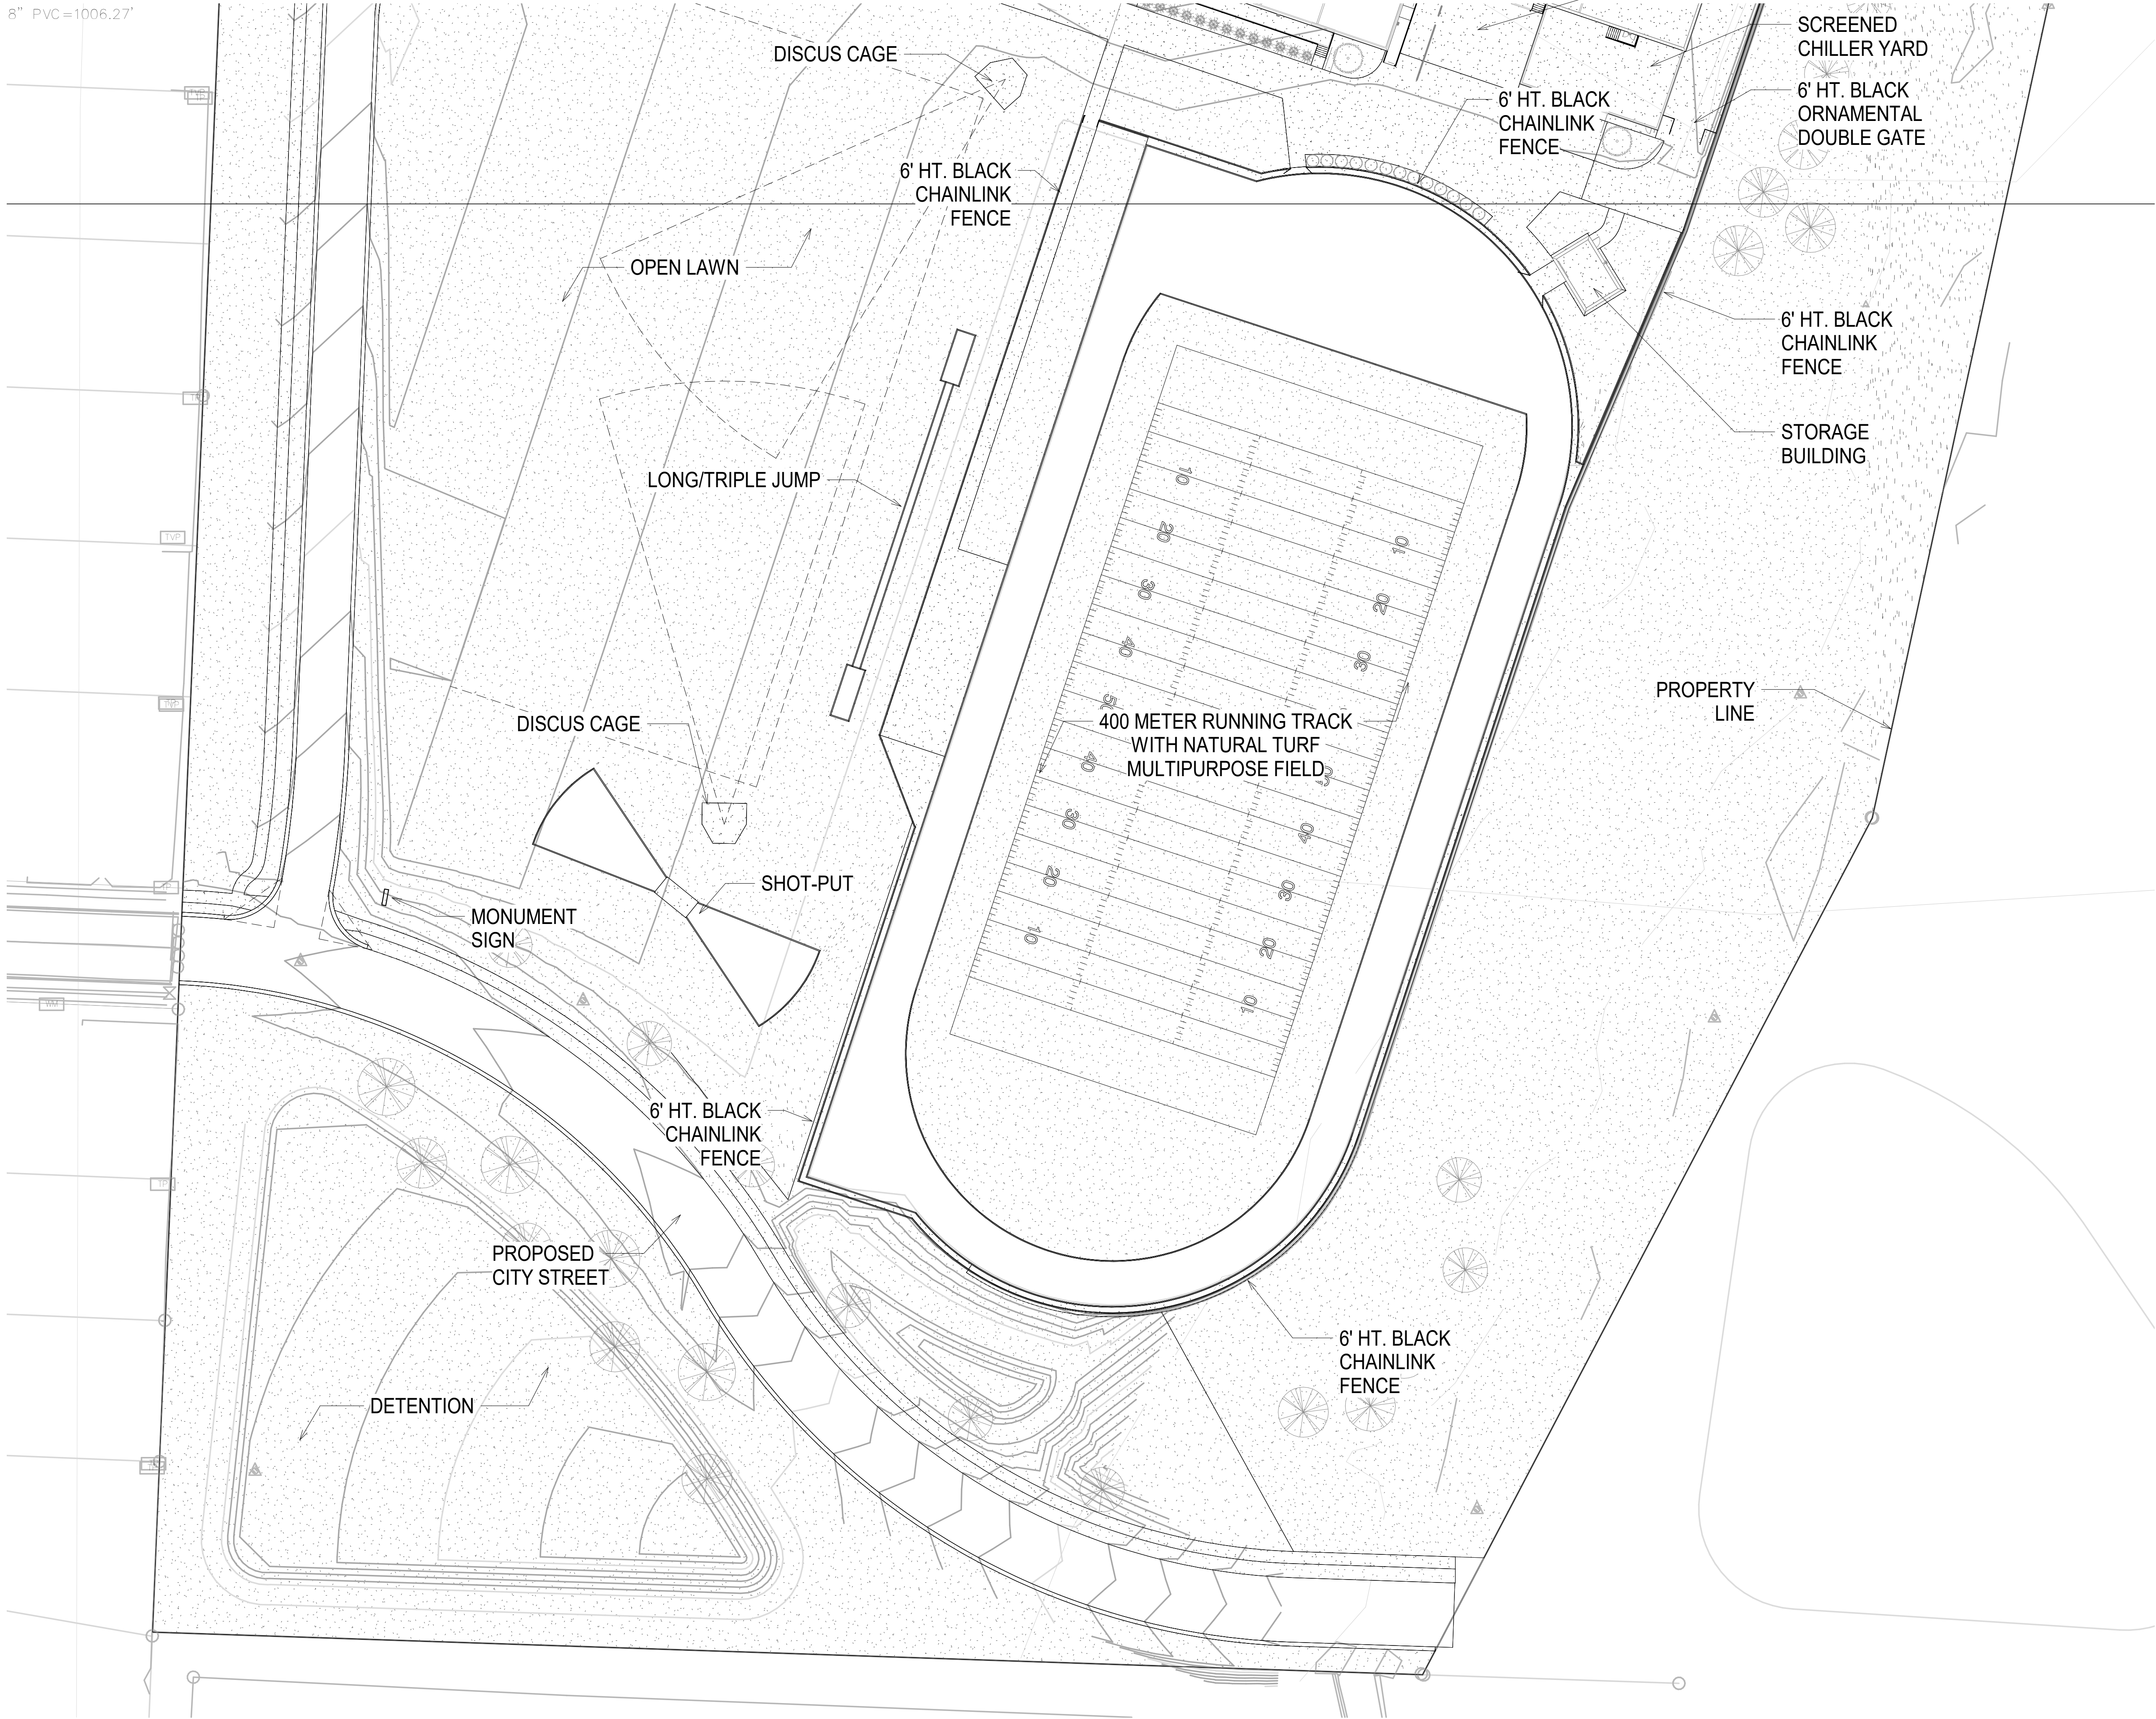

1 4 - Track
L1.3 SCALE: 1" = 40'-0"

Project Status
Issue Date
REVISIONS

13-20102
ENLARGED
LAYOUT PLAN

L1.3

Lee's Summit Middle School #4

Lee's Summit, MO, TBD


Project
Logo

Consultant Logo

NOT FOR
CONSTRUCTION

DLR Group
© DLR Group

B:\M 360\113-20102-00 Lee's Summit Middle School #4\113-20102-00_Lee's Summit Middle School 4_LS_2020.rvt
15/8/2020 10:19:39 AM

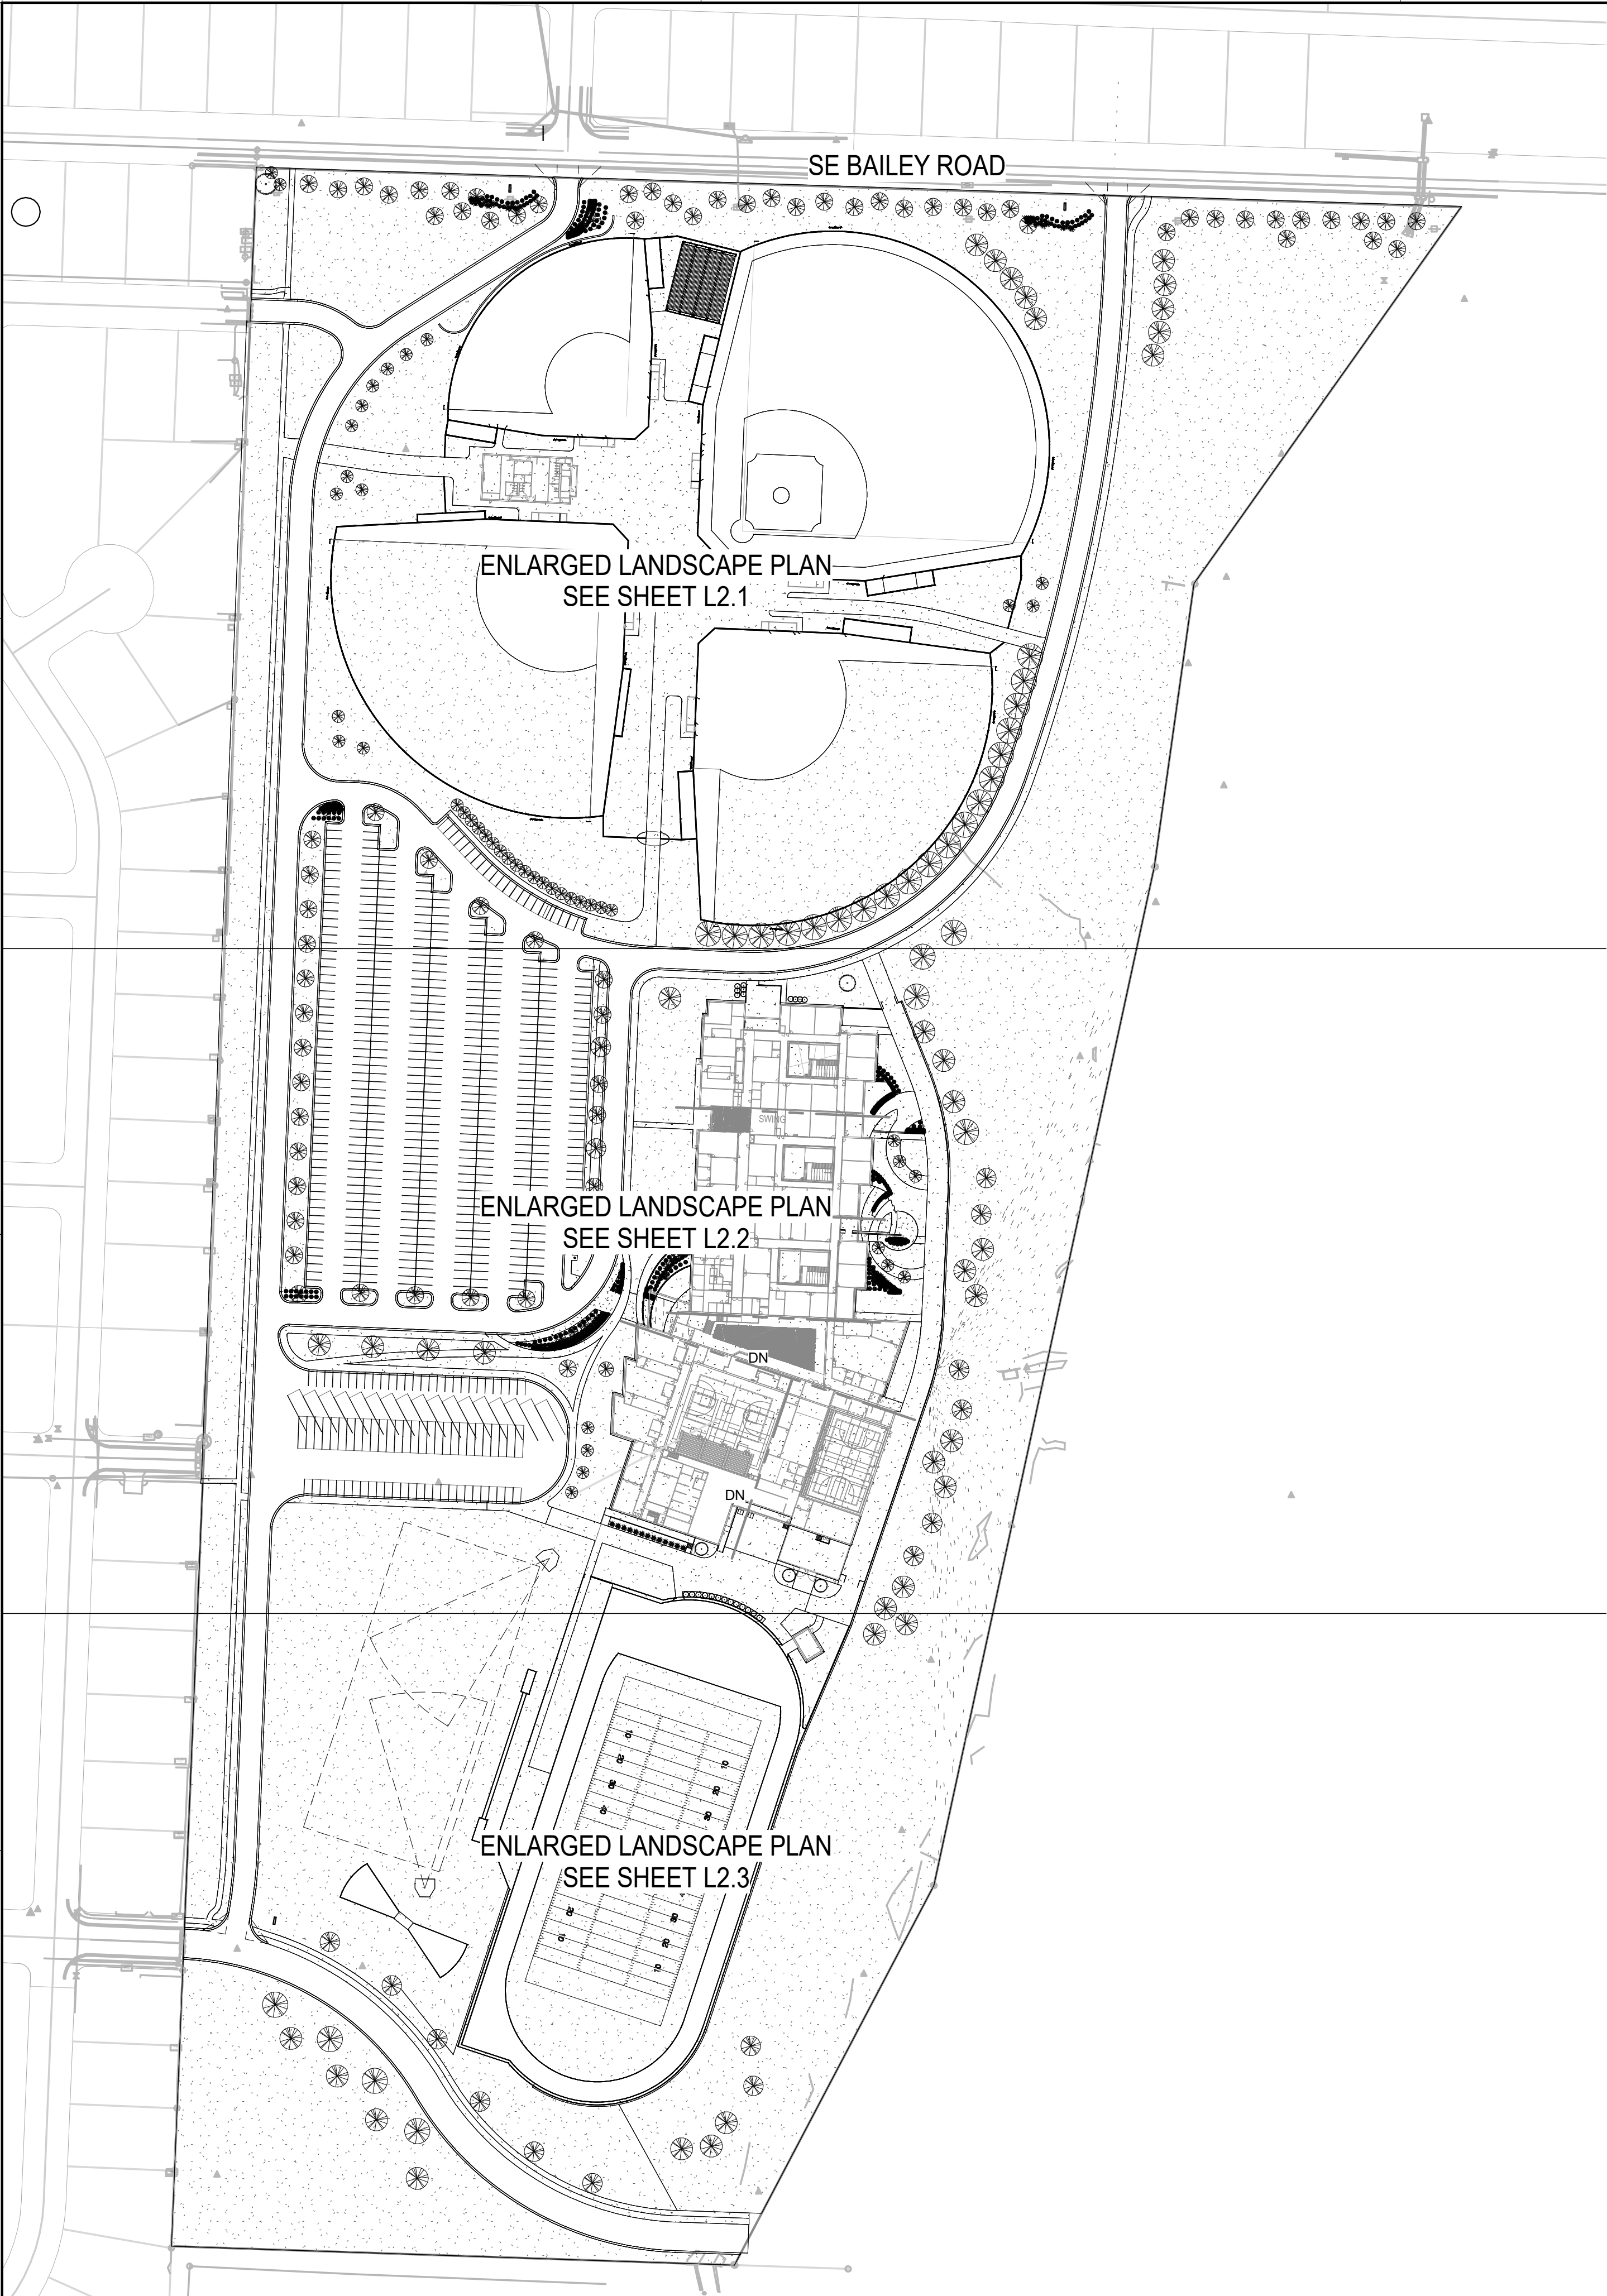

1 Overall Landscape Plan
L2.0 SCALE: 1" = 120'-0"

Planting Schedule					
Plant ID	Count	Botanical Name	Common Name	Cont.	Size

DECIDUOUS TREES

AS	39	Acer saccharum 'Autumn Splendor'	Autumn Splendor Sugar Maple	B&B	8'-10' HT.
BH	8	Betula nigra 'Heritage'	Heritage River Birch	B&B	8'-10' HT.
CA	35	Carpinus caroliniana 'Autumn Fire'	Autumn Fire American Hornbeam	B&B	8'-10' HT.
CP	16	Celtis occidentalis 'Prairie Pride'	Prairie Pride Hackberry	B&B	8'-10' HT.
QB	5	Quercus bicolor	Swamp White Oak	B&B	8'-10' HT.
QC	19	Quercus bicolor 'Bonnie and Mike' TM	Beacon Oak	B&B	8'-10' HT.
TS	30	Taxodium distichum 'Shawnee Brave' TM	Bald Cypress	B&B	8'-10' HT.

EVERGREEN SHRUBS

JO	102	Juniperus virginiana 'Grey Owl'	Eastern Redcedar	3 GAL	
----	-----	---------------------------------	------------------	-------	--

EVERGREEN TREES

JB	10	Juniperus chinensis 'Blue Heaven'	Blue Heaven Juniper	B&B	5-6'
JA	13	Juniperus virginiana 'Keteleeri'	Blue Arrow Juniper	6'-7' HT.	B&B
PF	4	Picea pungens 'Fat Albert'	Colorado Spruce		
PS	1	Pinus strobus	White Pine	B&B	8'-10' HT.

GRASSES

CK	146	Calamagrostis x acutiflora 'Karl Foerster'	Feather Reed Grass	1 GAL.	
----	-----	--	--------------------	--------	--

Grasses

BB	48	Bouteloua gracilis 'Blonde Ambition'	Blue Grama	1 GAL.	
CL	83	Chasmanthium latifolium	Wood Oats	1 GAL.	

ORNAMENTAL TREES

AA	9	Amelanchier arborea 'Autumn Brilliance'	Downy Serviceberry	B&B	8'-10' HT.
MG	1	Magnolia virginiana 'Green Shadow'	Green Shadow Magnolia	B&B	8'-10' HT.
MP	19	Malus x 'Jefspire' TM	Purple Spire Columnar Crabapple	B&B	8'-10' HT.
MS	25	Malus x 'Spring Snow'	Spring Snow Crabapple	B&B	8'-10' HT.

PERENNIAL

CB	4	Coreopsis x 'Berry Chiffon'	Berry Chiffon Tickseed	1 GAL.	
SM	71	Salvia x sylvestris 'May Night'	May Night Sage	1 GAL.	

SHRUBS

AI	12	Aronia melanocarpa 'Low Scape Mound'	Red Chokeberry	3 GAL	
CH	83	Callicarpa x 'NCCX2' TM	Pearl Glam Beauty Berry	3 GAL	
FB	34	Fothergilla gardenii 'Blue Mist'	Blue Mist Fothergilla	3 GAL	
HA	16	Hydrangea quercifolia 'Amethyst'	Amethyst Oakleaf Hydrangea	3 GAL	
HS	22	Hydrangea quercifolia 'Sike's Dwarf'	Sike's Dwarf Oakleaf Hydrangea	3 GAL	
RG	19	Rhus aromatica 'Gro-Low'	Gro-Low Fragrant Sumac	3 GAL	

PLANTING REQUIREMENTS

SEC. 8.790 - LANDSCAPING-MIN. REQUIREMENTS

STREET FRONTAGE:

ONE TREE SHALL BE PLANTED FOR EACH 30 FEET OF STREET FRONTAGE. MIN. 20' WIDE LANDSCAPE STRIP SHALL BE PROVIDED ALONG THE LENGTH OF ANY STREET FRONTAGE

ONE SHRUB SHALL BE PROVIDED FOR EACH 20' OF STREET FRONTAGE

STREET FRONTAGE PLANTING PROVIDED:

1350 LINEAR FEET OF STREET FRONTAGE / 30' = 45 TREES
1350 LINEAR FEET OF STREET FRONTAGE / 20' = 68 SHRUBS

47 DECIDUOUS TREES PROVIDED
93 SHRUBS PROVIDED

SEC. 8.810 - PARKING LOT LANDSCAPING AND TREES

A LANDSCAPING ISLAND SHALL BE LOCATED AT THE END OF EVERY PARKING BAY BETWEEN THE LAST PARKING SPACE AND ADJACENT TRAVEL AISLE OR DRIVEWAY NO LESS THAN 9' WIDE & 1/2 THE LENGTH OF THE ADJACENT PARKING.

TOTAL
513 PARKING STALLS (Does not include bus & overflow)
6 PARKING BAYS = 6 LANDSCAPING ISLANDS REQUIRED

SEC. 8.900-REQUIRED TYPICAL IMPACT SCREENS

EXISTING DENSE TREE PLANTINGS TO REMAIN & PROVIDE REQUIRED SCREENING

SEC. 8.790.B.1 OPEN YARD SHRUB REQ'T.

MINIMUM OF 2 SHRUBS PER 5,000 SQUARE FEET OF TOTAL LOT AREA REQUIRED

TOTAL LOT AREA: 117,130 SF / 5,000 SF = 23.5 x 2 (SHRUBS/5,000 SF) = 47 TOTAL SHRUBS REQUIRED

TOTAL SHRUBS PROVIDED: 129

SEC. 8.810.A. PARKING LOT LANDSCAPE ISLANDS

LANDSCAPE ISLANDS, STRIPS OR OTHER PLANTING AREAS SHALL BE LOCATED WITHIN THE PARKING LOT AND SHALL CONSTITUTE AT LEAST 5% OF THE ENTIRE AREA DEVOTED TO PARKING SPACES

ENTIRE PARKING AREA: 266,995 SF

LANDSCAPE AREA WITHIN PARKING AREA: 38,450 SF

38,450 SF / 266,995 SF = 14.4% TOTAL PARKING AREA DESIGNATED FOR PLANTING

LANDSCAPE NOTES:

1. THE CONTRACTOR WILL DETERMINE THE EXACT LOCATION OF ALL EXISTING UTILITIES AND STRUCTURES BEFORE COMMENCING WORK. THE CONTRACTOR WILL CONDUCT HIS WORK SO AS TO PREVENT INTERRUPTION OF SERVICE OR DAMAGE TO THEM. THE CONTRACTOR AGREES TO BE FULLY RESPONSIBLE FOR ANY AND ALL DAMAGE WHICH MIGHT BE OCCASIONED BY THE CONTRACTOR'S FAILURE TO LOCATE AND PRESERVE ANY AND ALL EXISTING UTILITIES AND STRUCTURES.

2. CONTRACTOR SHALL VERIFY LOCATION OF ALL UTILITIES BEFORE STARTING ANY WORK.

3. EXISTING UNDERGROUND (UG) UTILITIES AND DRAINAGE STRUCTURES HAVE BEEN PLOTTED FROM AVAILABLE INFORMATION AND THEREFORE, THEIR LOCATIONS MUST BE CONSIDERED APPROXIMATE ONLY. IT IS THE RESPONSIBILITY OF THE INDIVIDUAL CONTRACTORS TO NOTIFY THE UTILITY COMPANIES TO LOCATE UTILITIES BEFORE ACTUAL CONSTRUCTION.

4. THE CONTRACTOR WILL SHOW PROOF OF PROCUREMENT, SOURCES, QUANTITIES AND VARIETIES FOR ALL SHRUBS, PERENNIALS, ORNAMENTAL GRASSES, AND ANNUALS.

5. SUBSTITUTIONS WILL BE ALLOWED ONCE THE CONTRACTOR HAS EXHAUSTED ALL SOURCES FOR THE SPECIFIED MATERIAL, AND HAS PROVEN THAT THE SPECIFIED MATERIAL IS NOT AVAILABLE. THE CONTRACTOR MUST PROVIDE NAME AND VARIETY OF SUBSTITUTION IN THE SUBSTITUTION REQUEST FORM TO THE LANDSCAPE ARCHITECT FOR APPROVAL PRIOR TO TAGGING OR PLANTING. SUBSTITUTIONS WILL BE NEAREST EQUIVALENT SIZE OF VARIETY OF PLANT HAVING SAME ESSENTIAL CHARACTERISTICS.

6. SIZE AND QUALITY OF PLANT MATERIAL WILL CONFORM TO AMERICAN STANDARDS FOR NURSERY STOCK, ANSI 280-1992, OR MOST RECENT EDITION.

7. ALL PLANT MATERIAL WILL BE NURSERY GROWN, SOUND, HEALTHY, VIGOROUS AND FREE FROM INSECTS, DISEASE AND INJURIES, WITH HABIT OF GROWTH THAT IS NORMAL FOR THE SPECIES. SIZES WILL BE EQUAL TO OR EXCEEDING SIZES INDICATED ON THE PLANT LIST. THE CONTRACTOR WILL SUPPLY PLANTS IN QUANTITY AS SHOWN ON THE DRAWINGS.

8. THE CONTRACTOR WILL BE RESPONSIBLE FOR ENSURING POSITIVE SURFACE DRAINAGE IS PROVIDED IN ALL PLANTING AND TURF AREAS. ALL GRADE SURFACES WILL BE FINISHED TO UNIFORM GRADES AND SLOPED IN SUCH A MANNER TO BE FREE OF DEPRESSIONS THAT CAUSE AREAS OF STANDING WATER. THE CONTRACTOR WILL REPORT ANY CONFLICTS WITH THIS REQUIREMENT TO THE LANDSCAPE ARCHITECT/OWNER FOR RESOLUTION PRIOR TO FINAL OPERATIONS.

9. THE CONTRACTOR WILL REPORT SUB-SURFACE SOIL OR DRAINAGE ISSUES TO THE LANDSCAPE ARCHITECT.

10. CONTRACTOR SHALL STAKE PLANT LOCATIONS IN THE FIELD AND HAVE APPROVAL BY THE LANDSCAPE ARCHITECT BEFORE PLANT PITS ARE EXCAVATED AND BEFORE PROCEEDING WITH INSTALLATION.

11. TREES, SHRUBS & GROUND COVERS SHALL BE LAID OUT IN A UNIFORM AND CONSISTENT PATTERN.

12. CONTRACTOR TO PLACE MULCH AROUND ALL TREES AND IN ALL PLANTING BEDS UNLESS OTHERWISE NOTED, TO A DEPTH OF 3" OR AS DESCRIBED IN THE SPECIFICATIONS. ALL PLANTING BEDS TO BE SEPARATED FROM LAWN AREAS WITH SPECIFIED EDGING OR CONCRETE CURB EDGE PER DRAWINGS.

13. ELEVATION OF TOP OF MULCH SHALL BE 1/2" MIN. BELOW ANY ADJACENT PAVEMENT OR 2" min. BELOW FINISHED FLOOR ELEVATION.

14. ALL SHRUB BEDS SHALL BE MULCHED WITH SPECIFIED ORGANIC OR DECORATIVE AGGREGATE MULCH AND SEPARATED FROM LAWN AREAS WITH SPECIFIED EDGING OR CONCRETE CURB EDGE PER DRAWINGS.

15. CONTRACTOR SHALL FINE GRADE AND SEED ALL AREAS DISTURBED DURING CONSTRUCTION AND ESTABLISH NEW LAWN AREA, NOT DESIGNATED FOR SOO, NATIVE MEADOW, OR PLANTING BEDS. CONTRACTOR TO SEED ALL AREAS WITHIN CONTRACT LIMITS NOT COVERED BY PAVING, BUILDINGS, OR PLANTING BEDS UNLESS OTHERWISE NOTED.

16. CONTRACTOR SHALL BE RESPONSIBLE FOR CALCULATING ACTUAL AREAS OF SEED AND QUANTITIES REQUIRED FOR COVERAGE.

17. ALL PLANT MATERIALS DELIVERED TO THE SITE FOR APPROVAL AND INSTALLATION SHALL BE IDENTIFIED AND TAGGED. TO ENSURE THE PLANTS PROVIDED ARE AS SPECIFIED. PLANTS SHALL BE APPROVED BY THE LANDSCAPE ARCHITECT PRIOR TO INSTALLATION.

18. ALL TREES SHALL BE CALLIPERED AND UNDERSIZED TREES SHALL BE REJECTED.

19. PLANT QUANTITIES ARE PROVIDED FOR CONTRACTOR CONVENIENCE ONLY. PROVIDE AND INSTALL ALL PLANTS SHOWN ON THE PLANTING PLANS.


20. SPACING OF ALL PLANTINGS TO BE AS SHOWN ON PLANS.

21. ALL LANDSCAPE AREAS AND PLAYING FIELD AREAS TO HAVE A MINIMUM OF 6" TOPSOIL.


22. ALL TURF AREAS TO HAVE 4" MINIMUM OF IMPORTED TOPSOIL - SEE SPECS FOR SOIL AMENDMENTS.

23. PROVIDE, INSTALL, AND INCORPORATE SOIL AMENDMENTS PER RECOMMENDATIONS PER THE SOILS REPORT.

B:\360\113-20102-00 Lee's Summit Middle School #4\113-20102-00_Lee's Summit Middle School 4_LS_2020.rvt
15/7/2020 6:17:43 PM

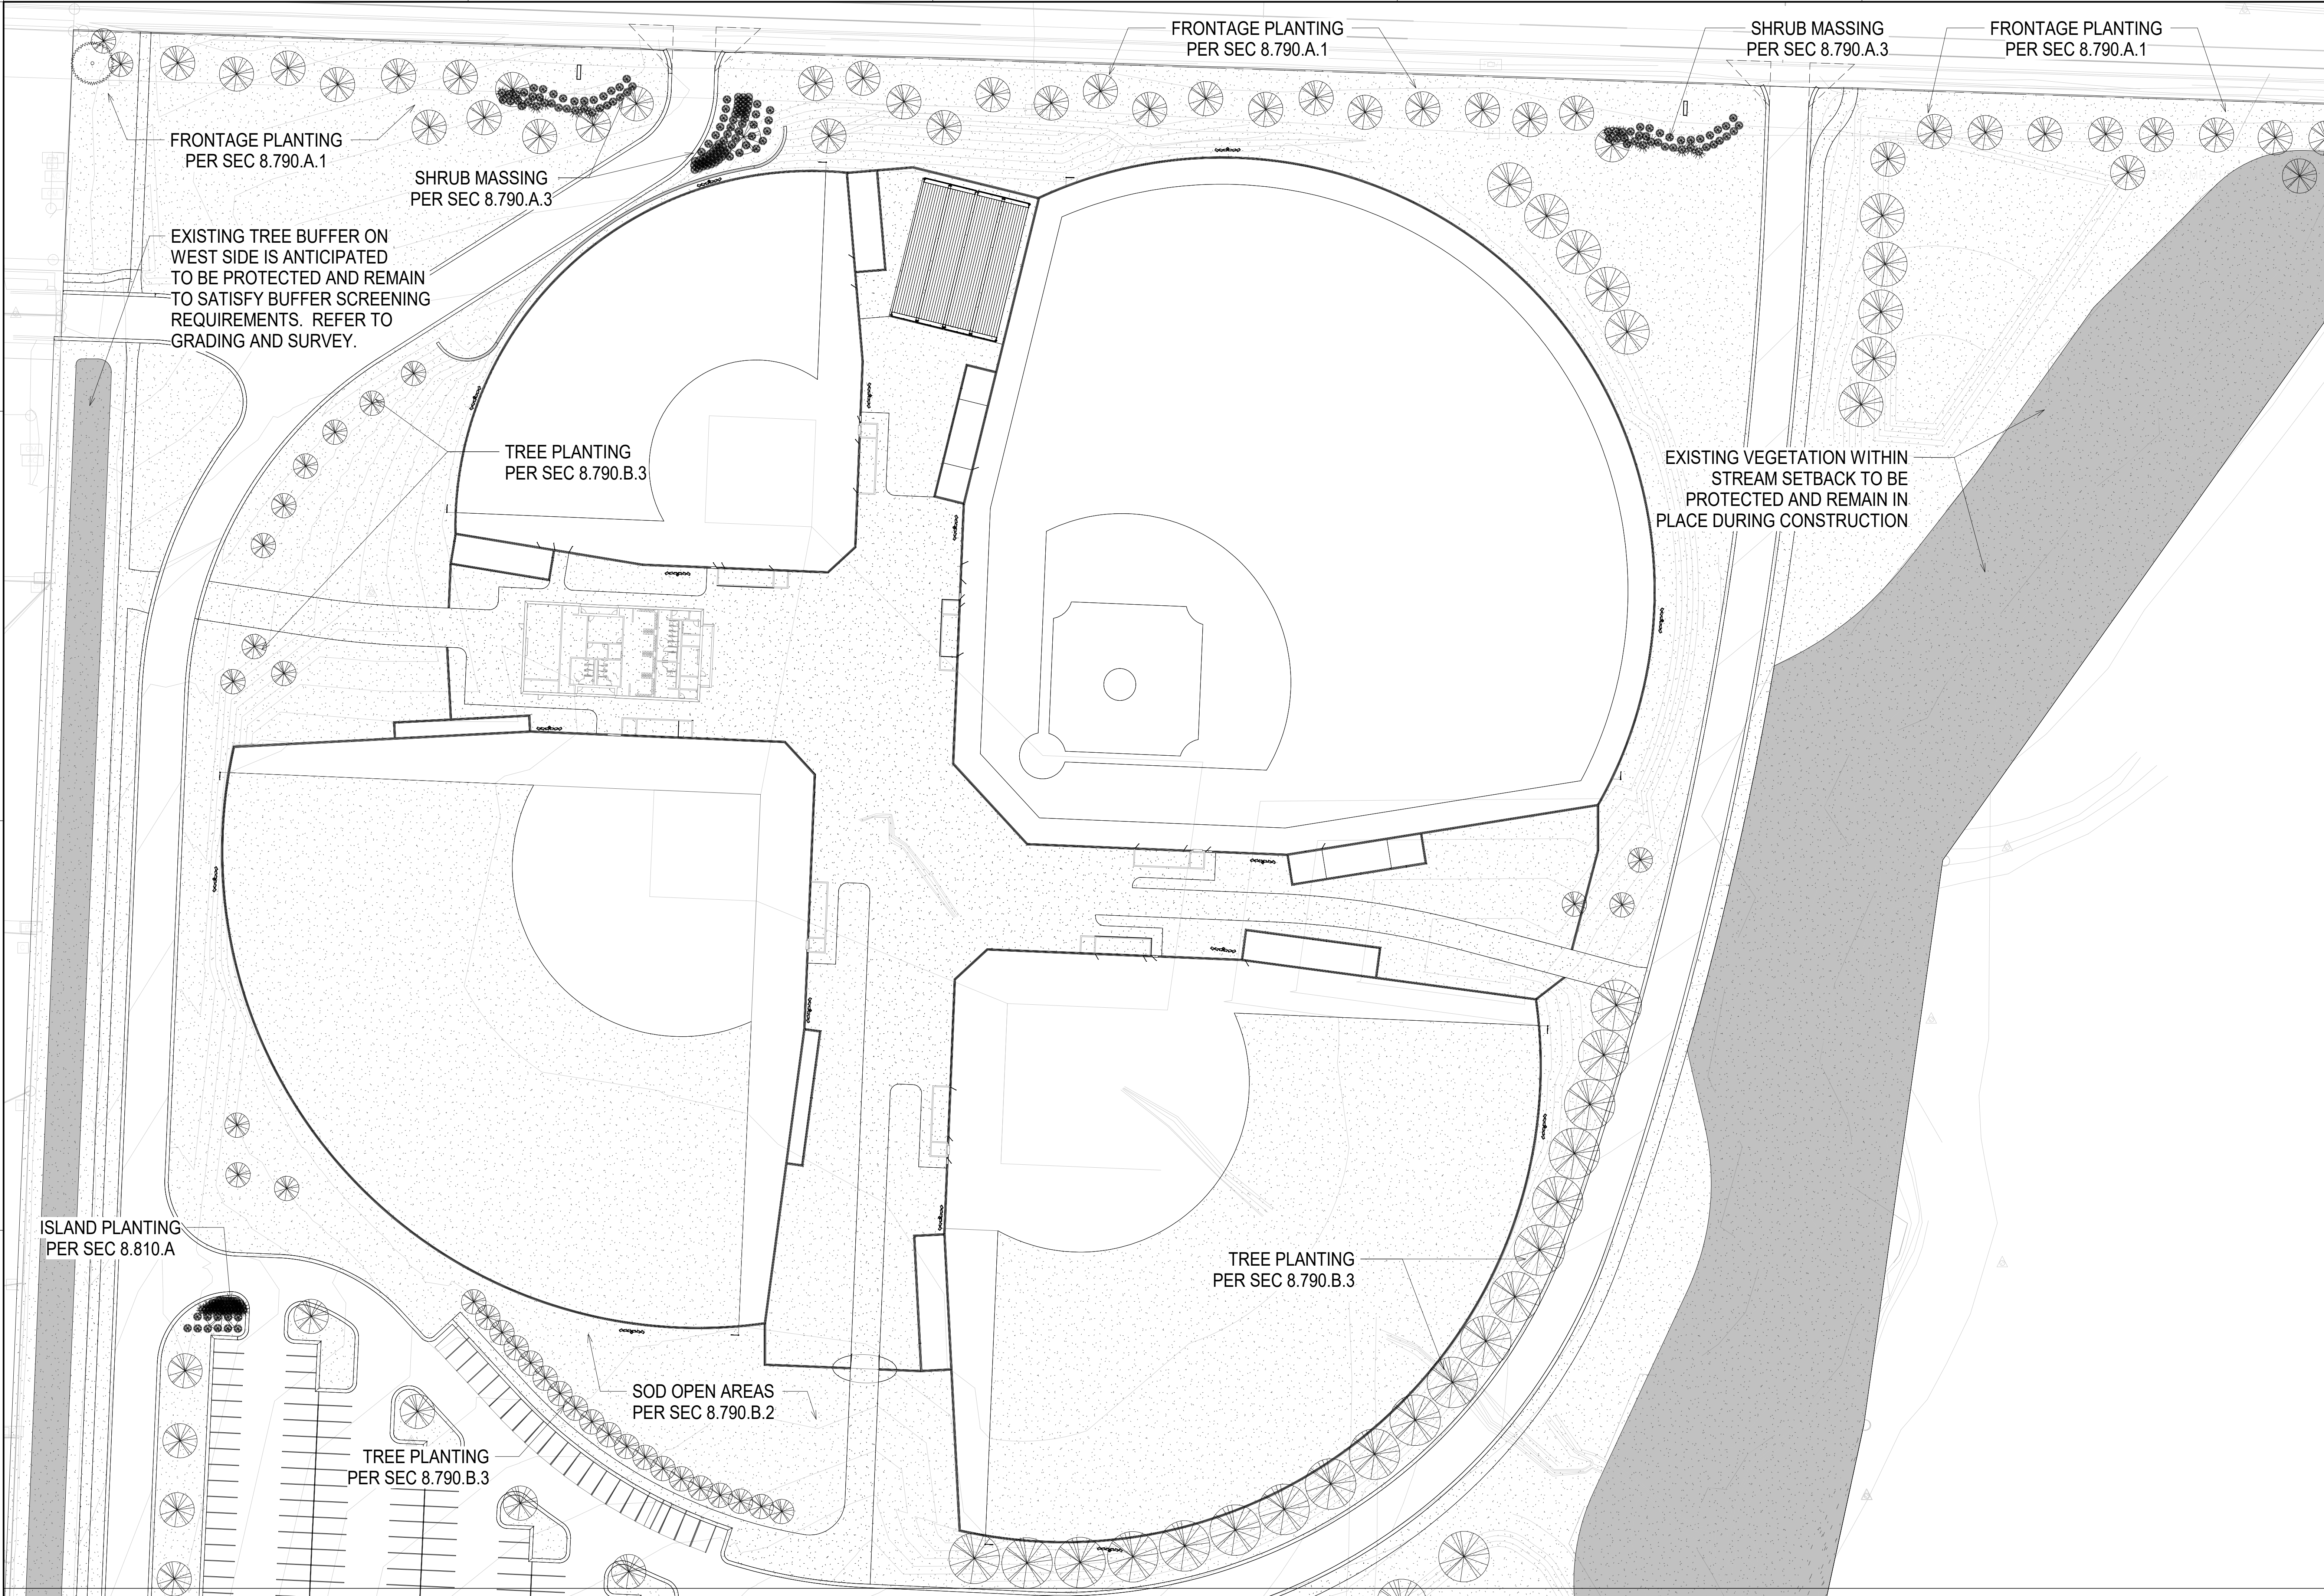


B:\M 360\113-20102-00 Lee's Summit Middle School #4\13-20102-00_Lee's Summit Middle School 4_LS_2020.rvt
5/7/2020 6:21:10 PM

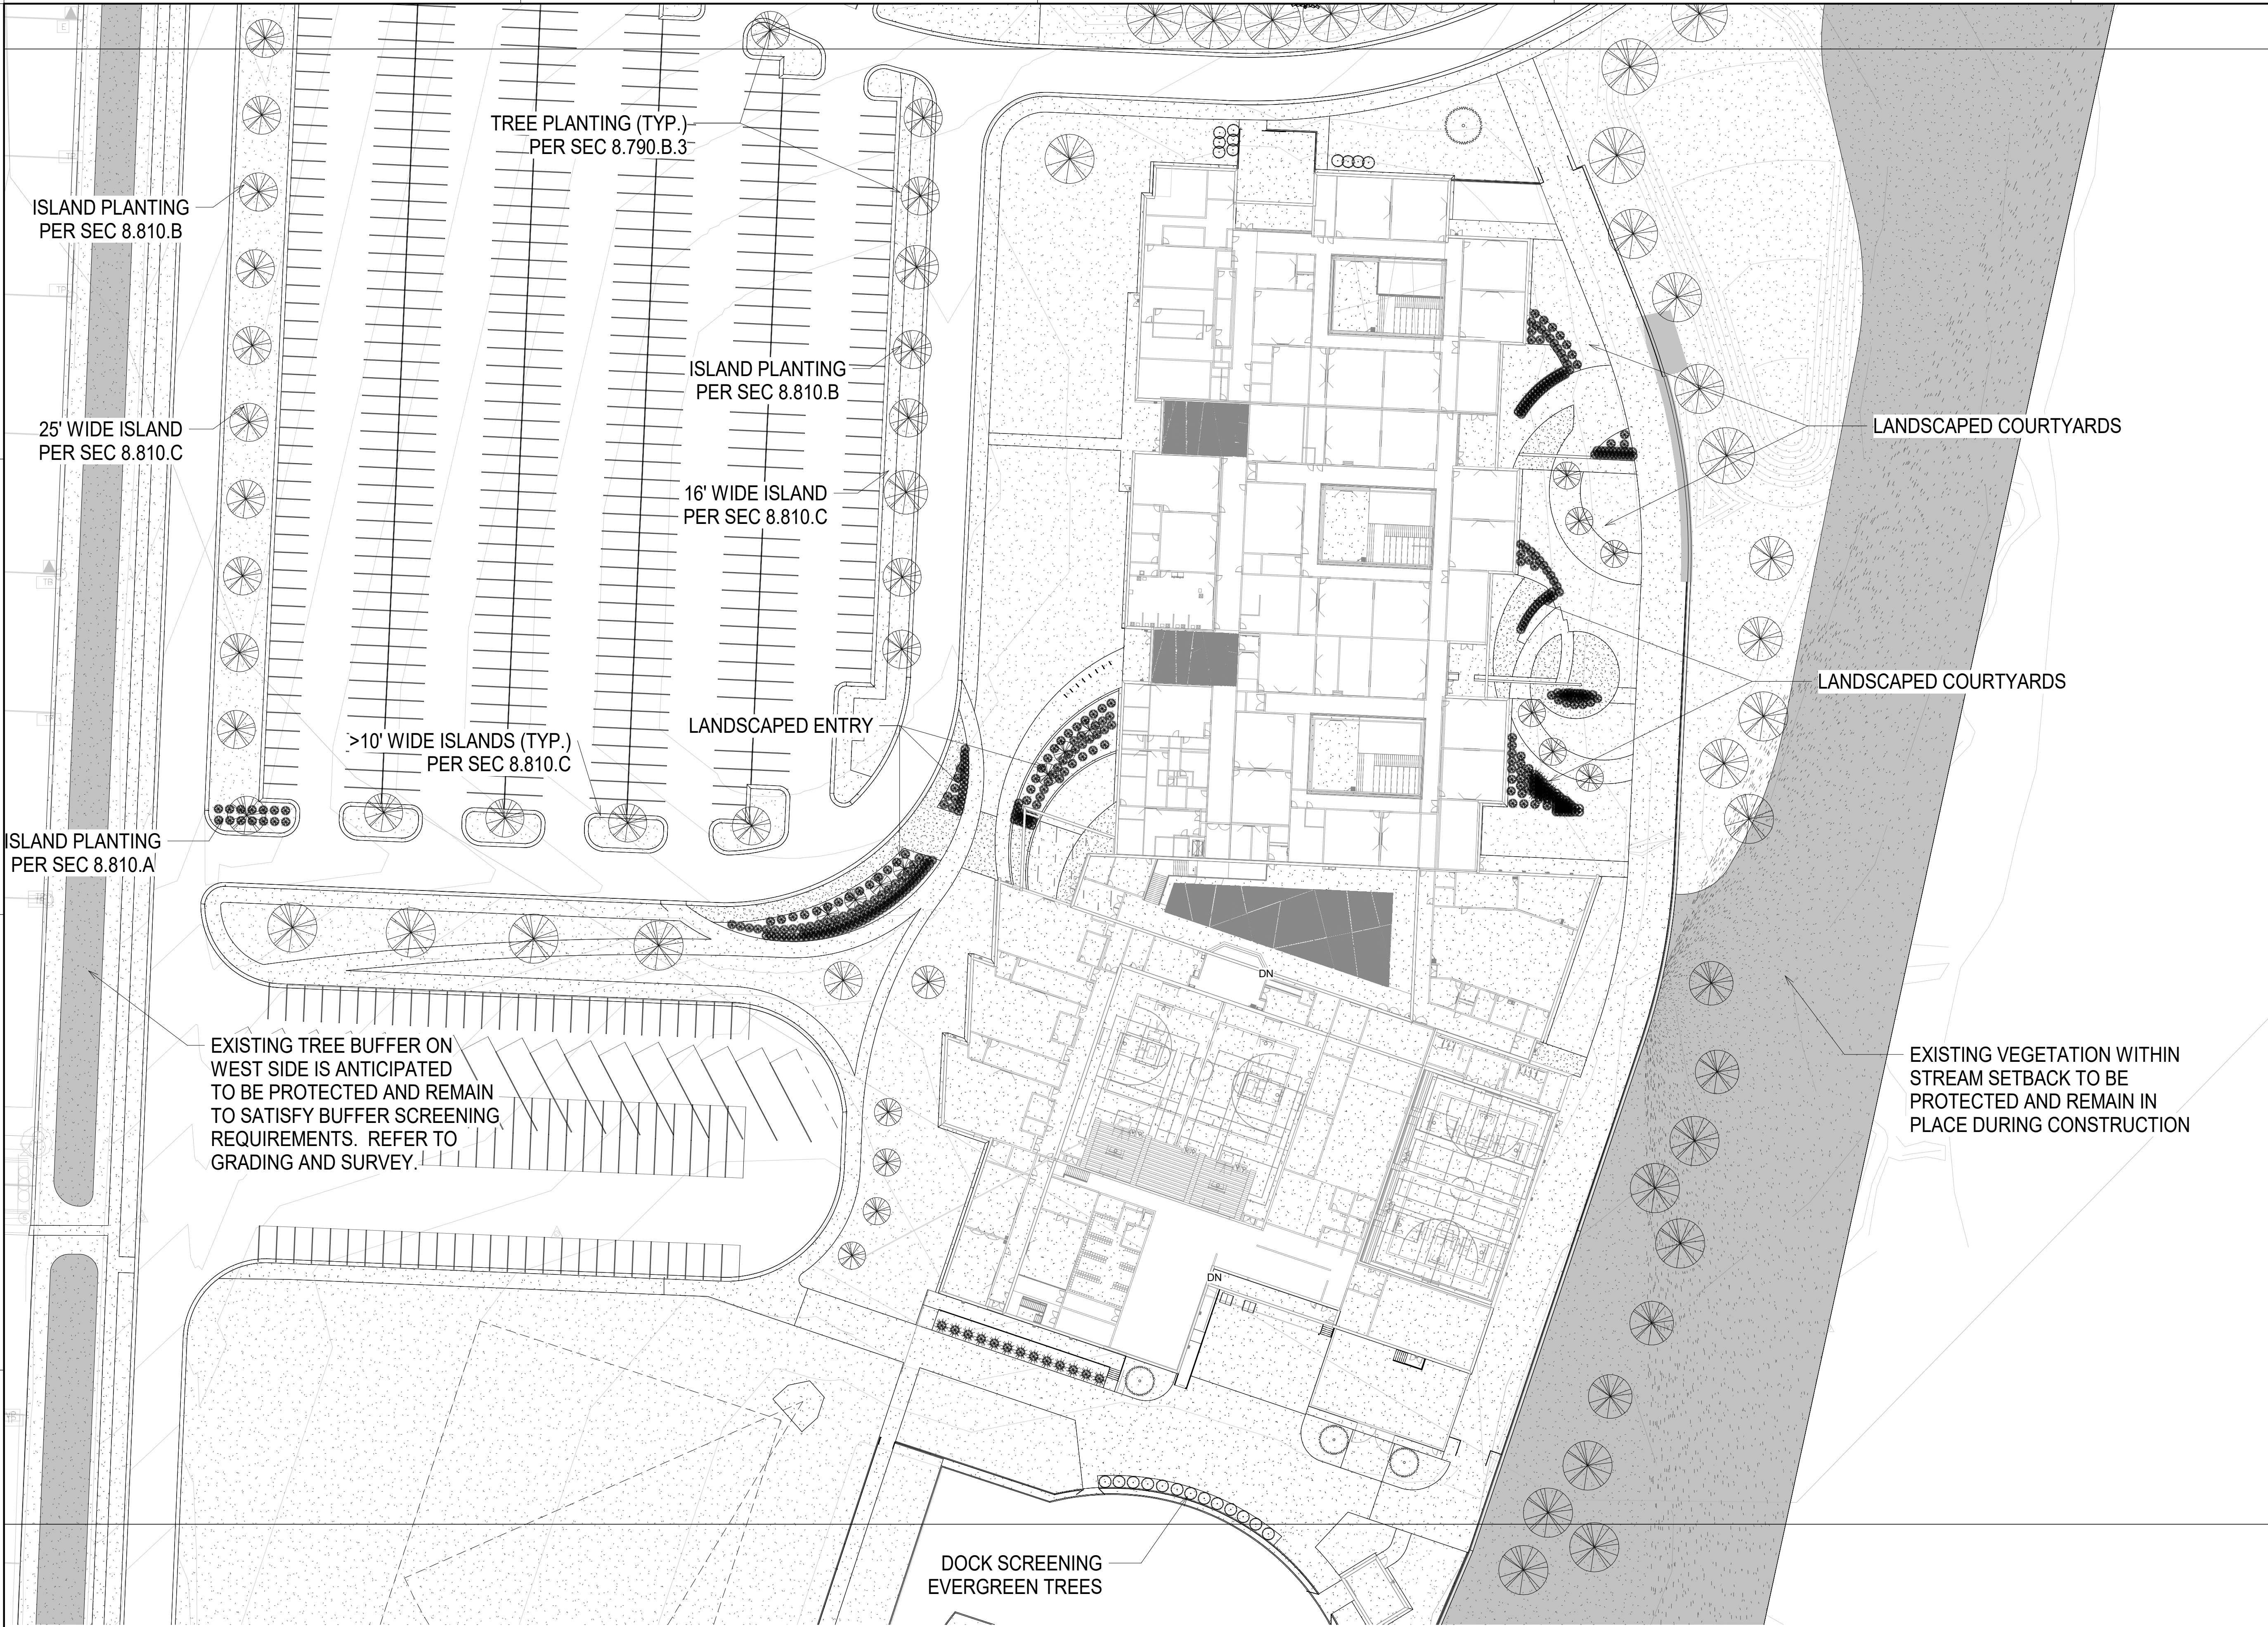

1 School Landscape Plan
L22 SCALE: 1" = 40'-0"

B:\M 360\113-20102-00 Lee's Summit Middle School #4\13-20102-00_Lee's Summit Middle School 4_LS_2020.rvt
5/7/2020 6:21:23 PM

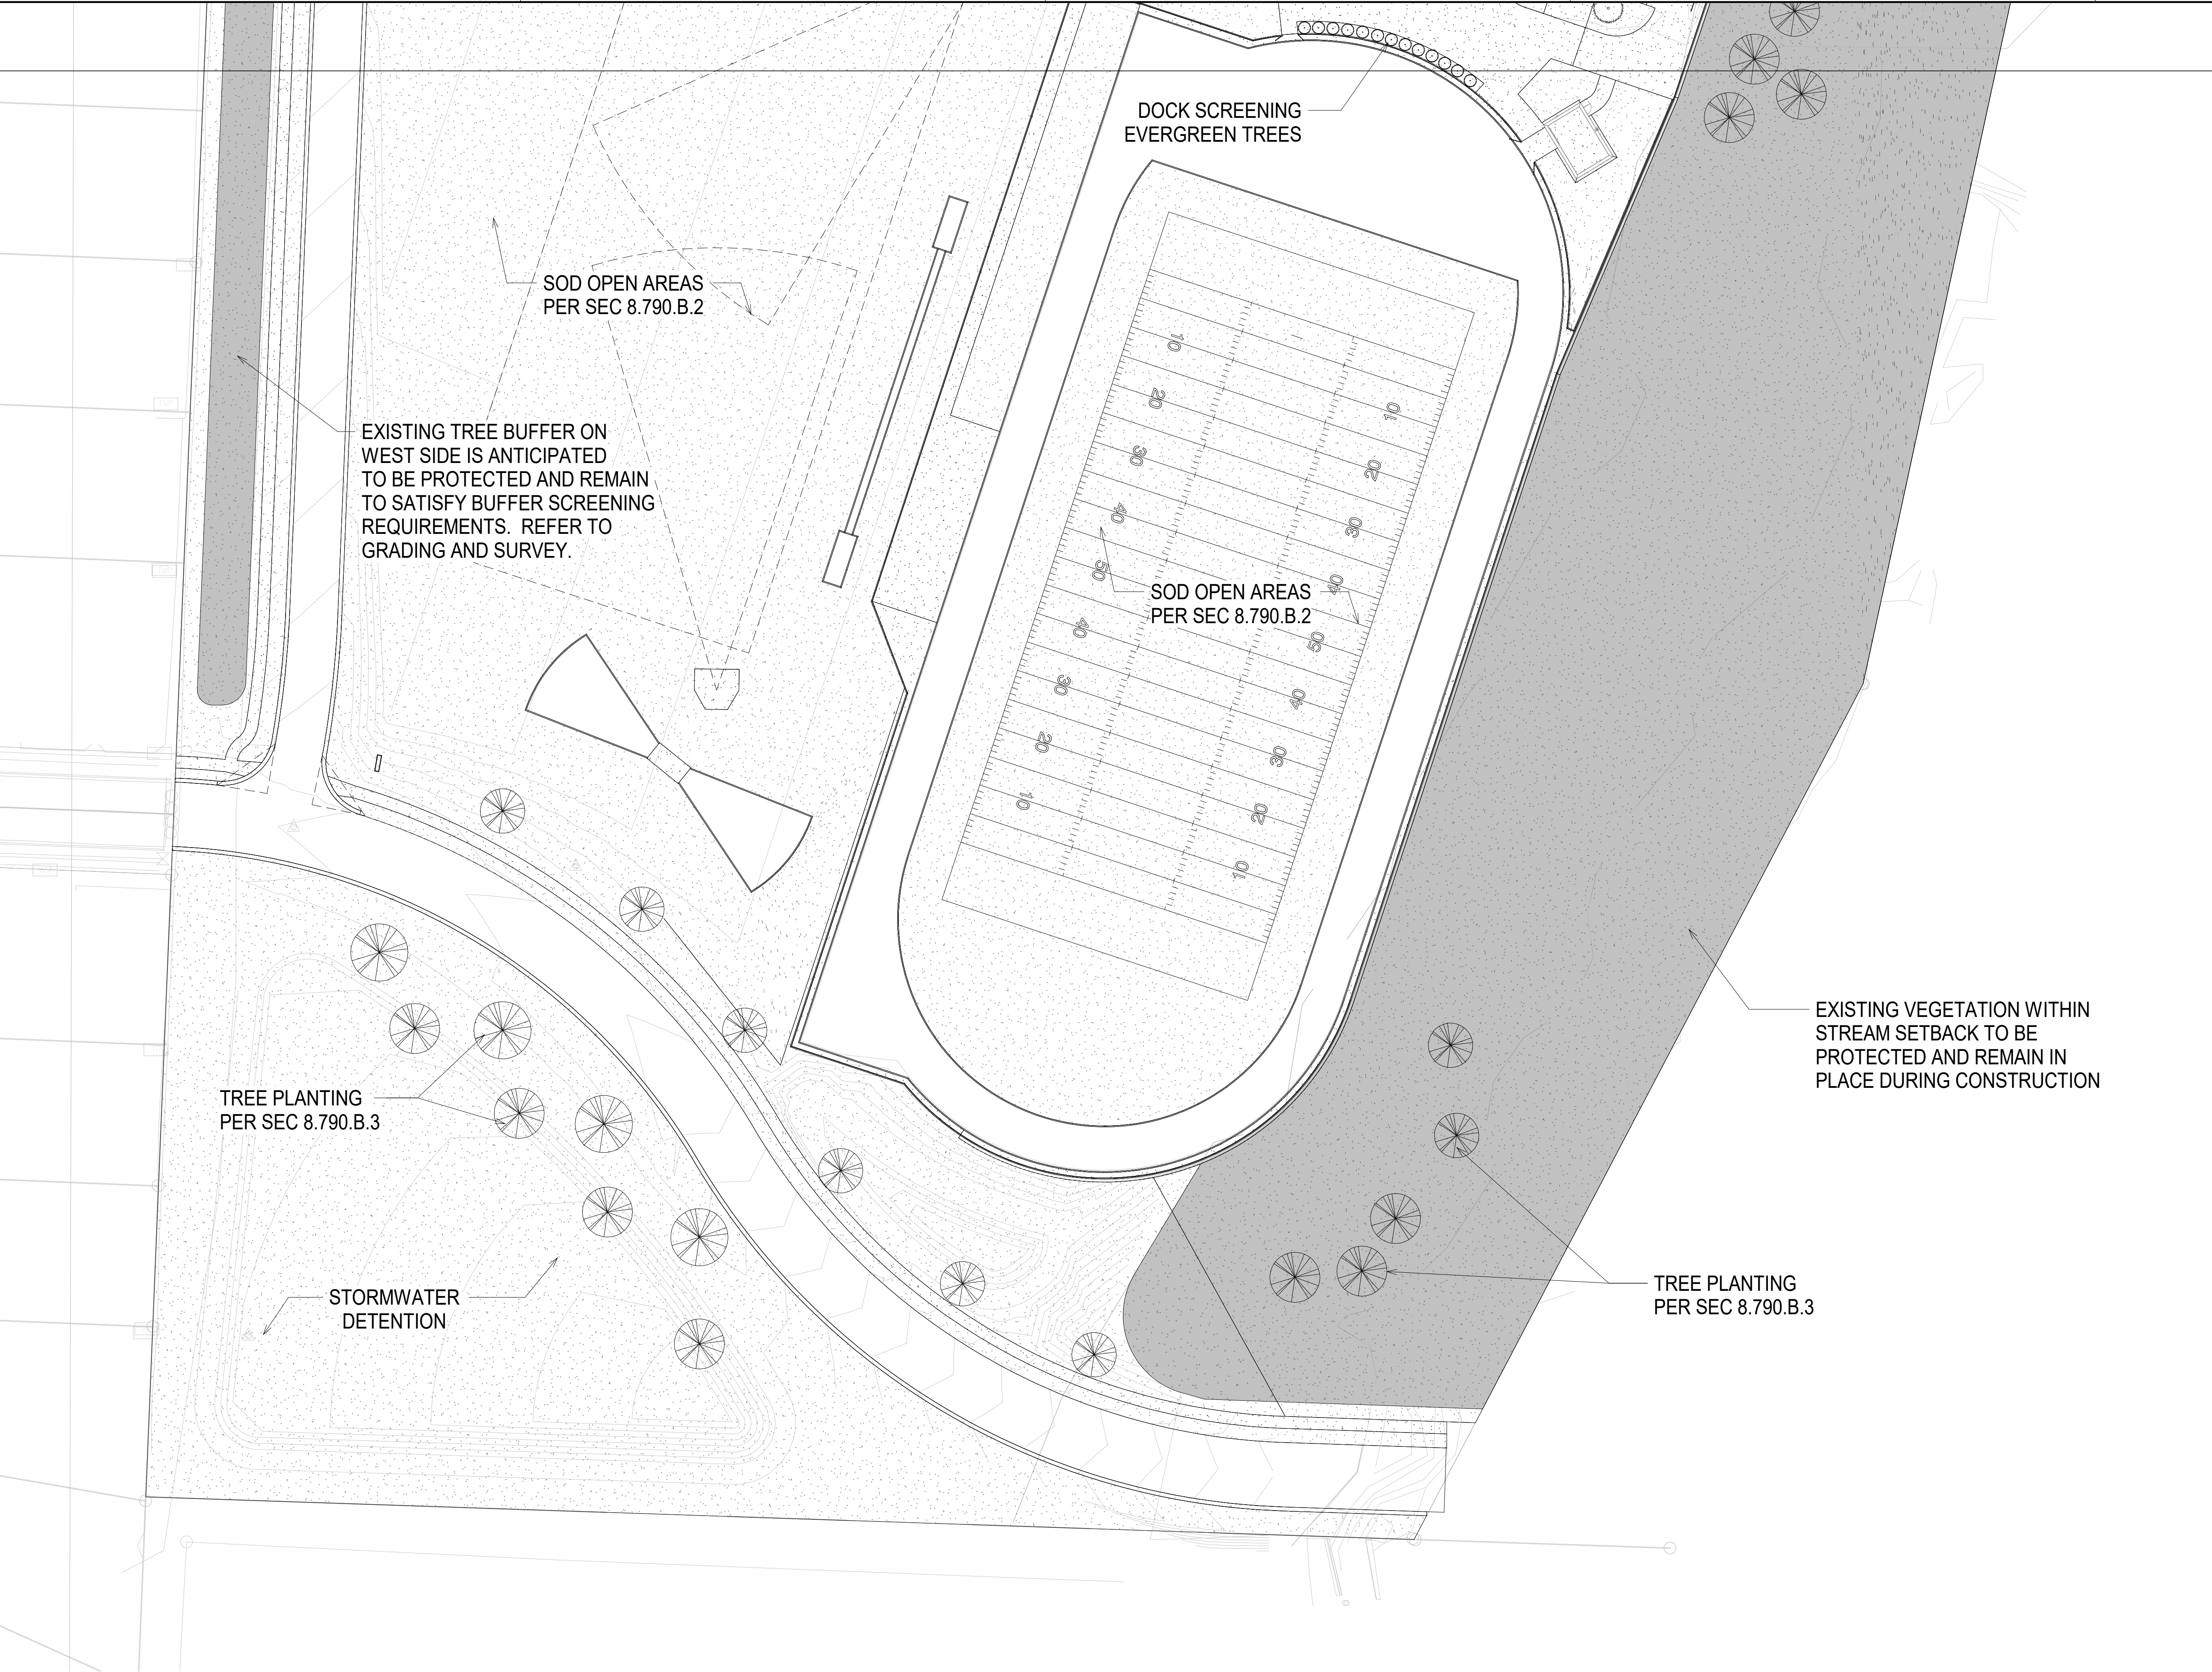

1 Enlarged Track Landscape
L2.3 SCALE: 1" = 40'-0"

Project Status
Issue Date
REVISIONS

13-20102
ENLARGED
LANDSCAPE PLAN

L2.3

Lee's Summit Middle School #4

Lee's Summit, MO, TBD


Project
Logo

Consultant Logo


NOT FOR
CONSTRUCTION

DLR Group
© DLR Group


B:\M 360\113-20102-00 Lee's Summit Middle School #4\13-20102-00_Lee's Summit Middle School 4_ARCH_2020.rvt
5/8/2020 10:20:11 AM

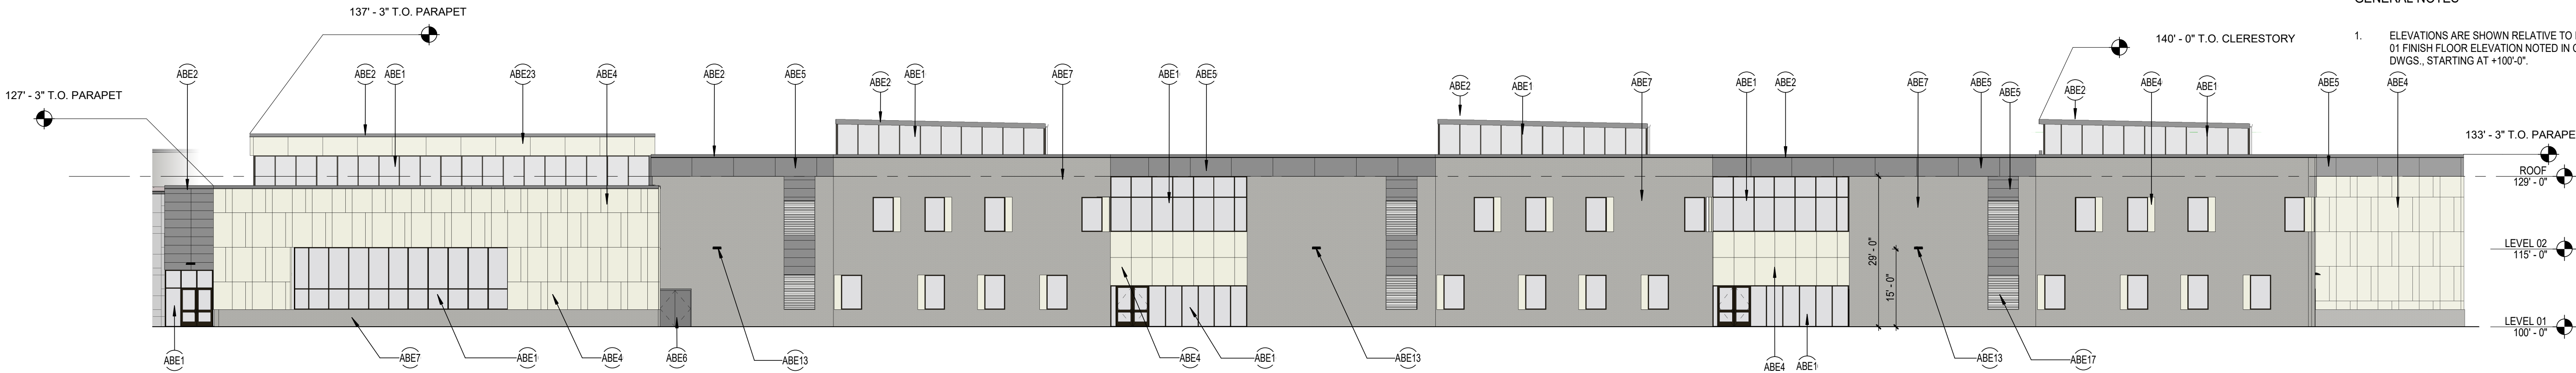

11 EAST ELEVATION-ACADEMICS
A5.01 SCALE: 1/16" = 1'-0"

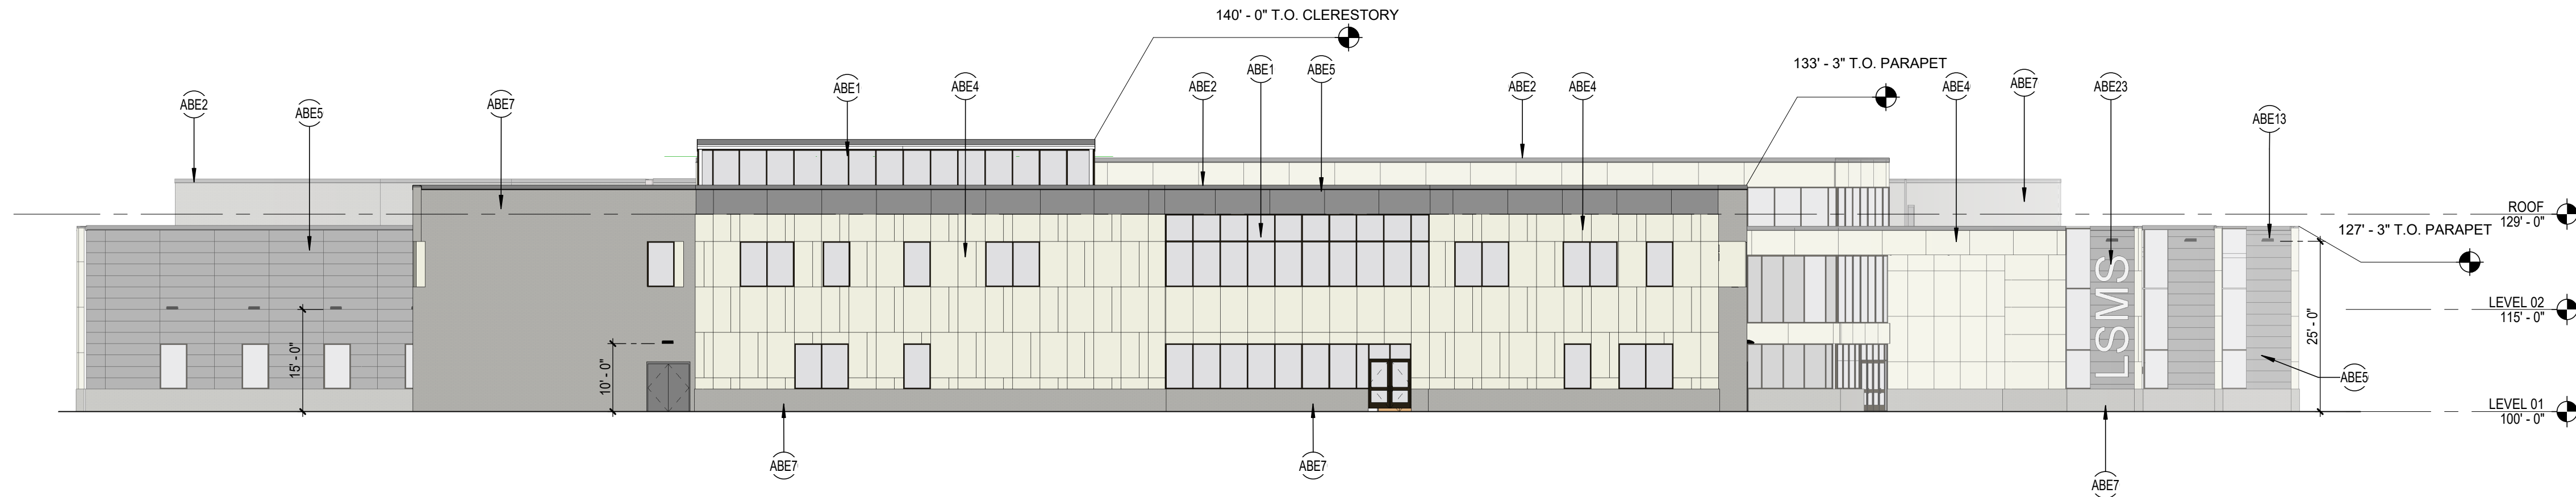

31 NORTH ELEVATION-ACADEMICS
A5.01 SCALE: 1/16" = 1'-0"

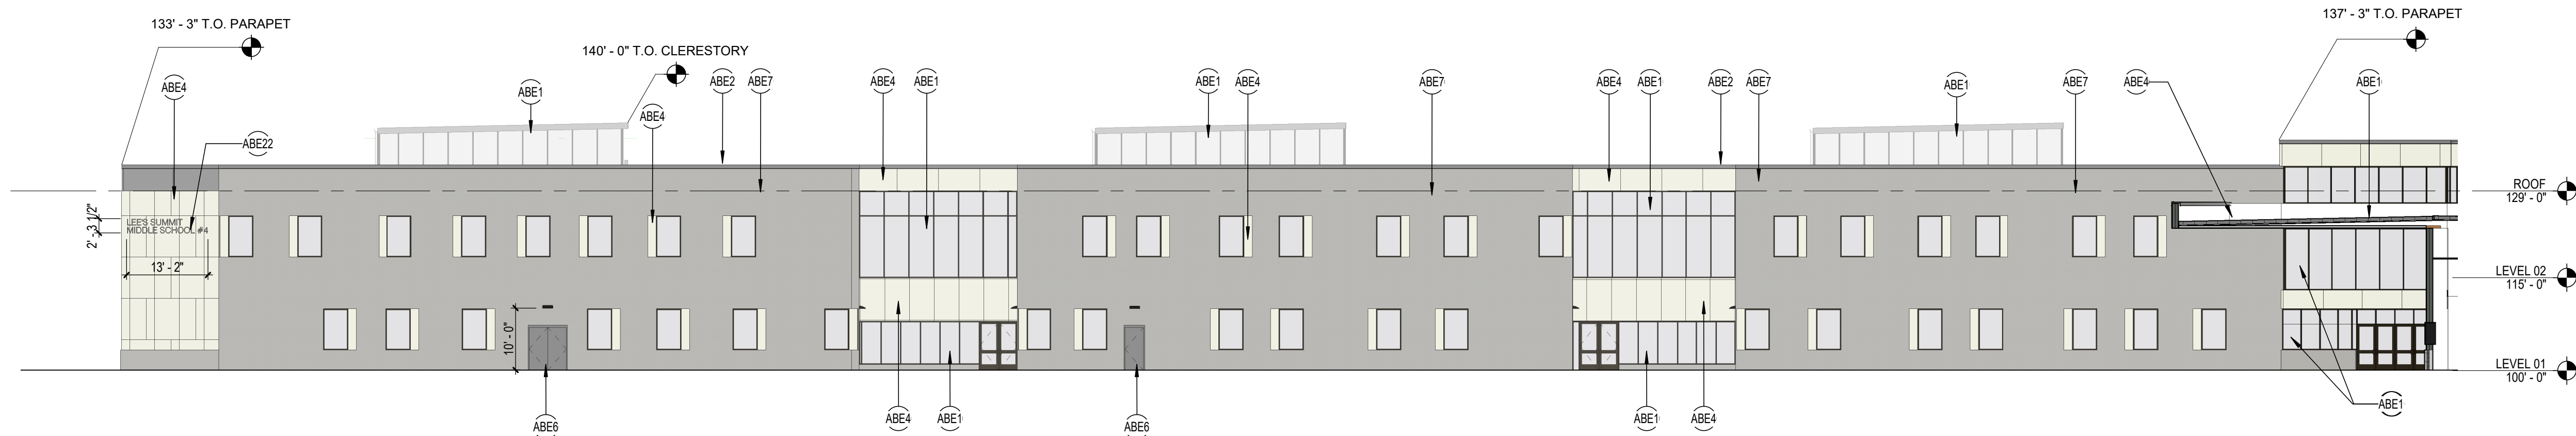

51 WEST ELEVATION-ACADEMICS-MAIN ENTRY
A5.01 SCALE: 1/16" = 1'-0"


KEYNOTE LEGEND

ABE1	ALUMINUM STOREFRONT SYSTEM (DARK BRONZE) WITH CLEAR GLAZING
ABE2	PREFINISHED METAL COPING
ABE4	CEMENTITIOUS WALL PANEL (CP-1) AMERICAN FIBER CEMENT S-282 SATURN, OR EQ.
ABE5	CEMENTITIOUS WALL PANEL (CP-2) AMERICAN FIBER CEMENT S-330 MERCURY, OR EQ.
ABE6	HOLLOW METAL DOOR AND FRAME
ABE7	FACE BRICK (FB-1) MODULAR, ACME MARBLE GRAY VELOUR PEP166, OR EQ.
ABE13	BUILDING MOUNTED LIGHT FIXTURE, RE: ELEC.
ABE17	ALUMINUM WALL LOUVER, RE: MECH.
ABE22	ALUMINUM DIMENSIONAL LETTER SIGNAGE
ABE23	EXTERIOR WALL GRAPHIC APPLIED TO FACE OF PANEL


GENERAL NOTES

- ELEVATIONS ARE SHOWN RELATIVE TO LEVEL 01 FINISH FLOOR ELEVATION NOTED IN CIVIL DWGS., STARTING AT +100'-0".


B:\M 360\113-20102-00_Lee's Summit Middle School #4\13-20102-00_Lee's Summit Middle School 4_ARCH_2020.rvt
5/7/2020 2:16:41 PM

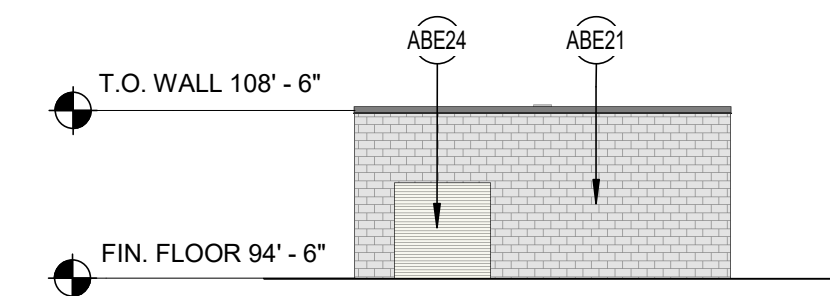


11 ATHLETIC STORAGE SW
A5.02 SCALE: 1/16" = 1'-0"

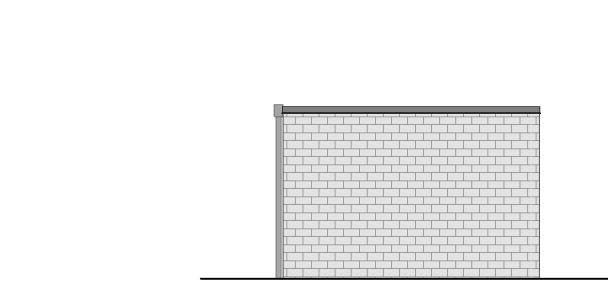


12 ATHLETIC STORAGE NW & SE
A5.02 SCALE: 1/16" = 1'-0"

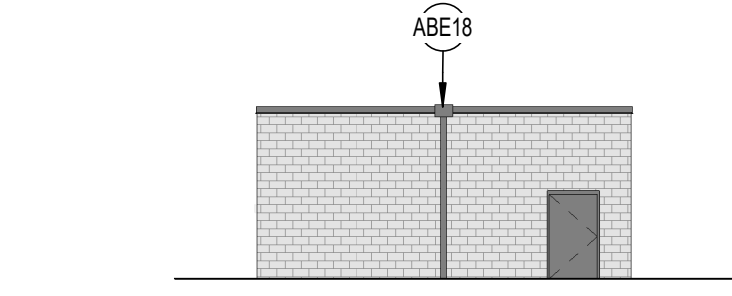


13 ATHLETIC STORAGE NE
A5.02 SCALE: 1/16" = 1'-0"

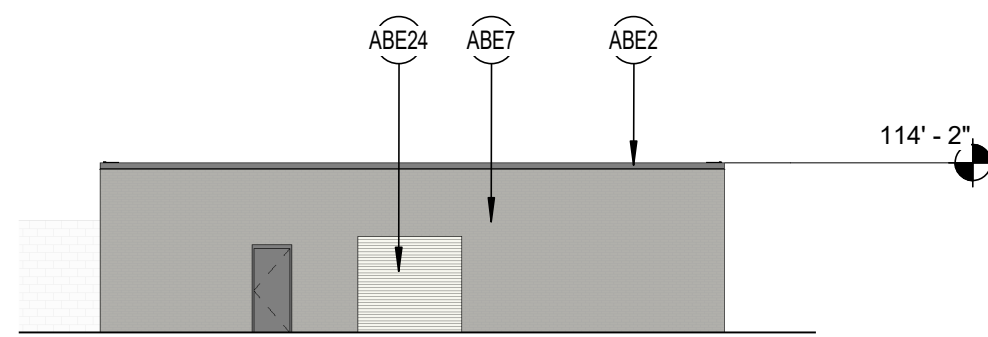


21 ATHLETIC BUILDING WEST
A5.02 SCALE: 1/16" = 1'-0"

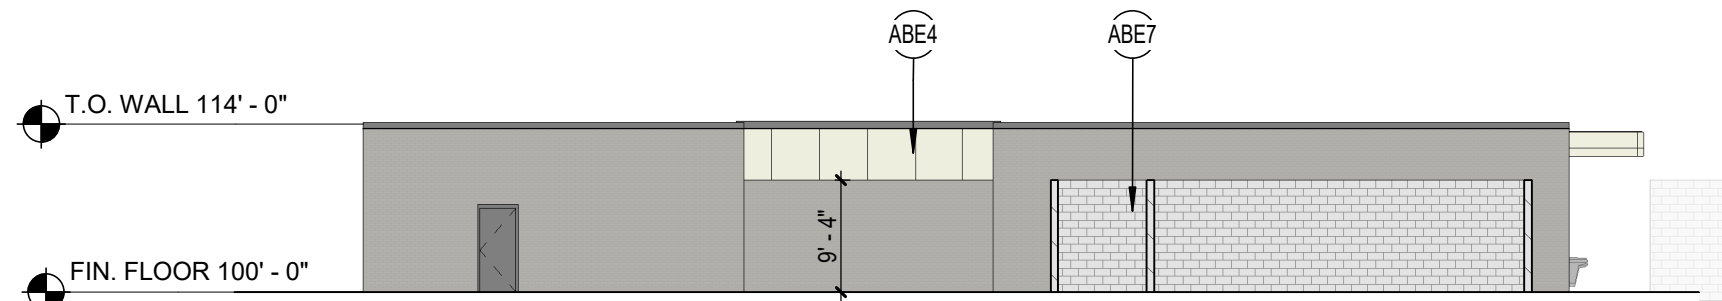


31 ATHLETIC BUILDING SOUTH
A5.02 SCALE: 1/16" = 1'-0"

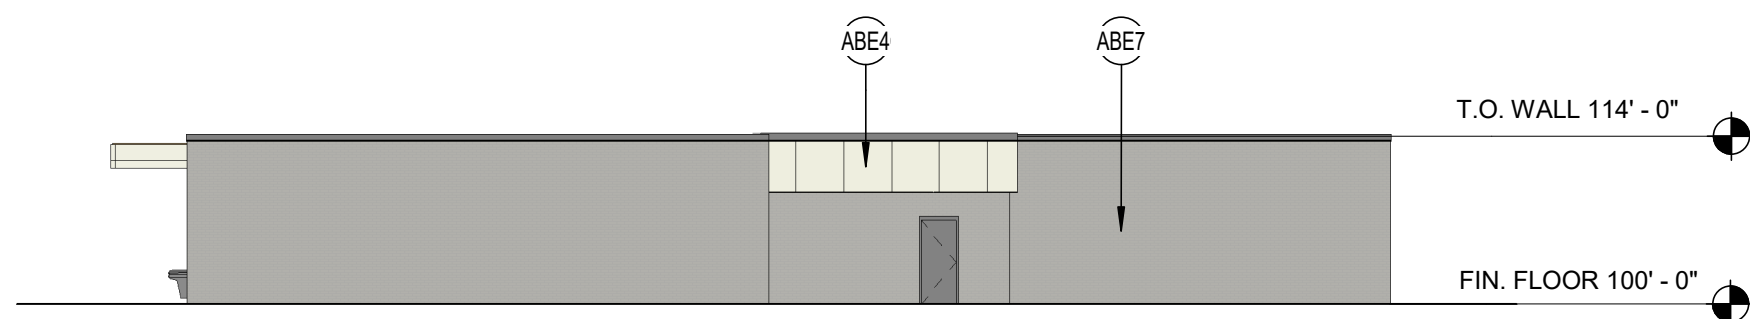


41 ATHLETIC BUILDING NORTH
A5.02 SCALE: 1/16" = 1'-0"

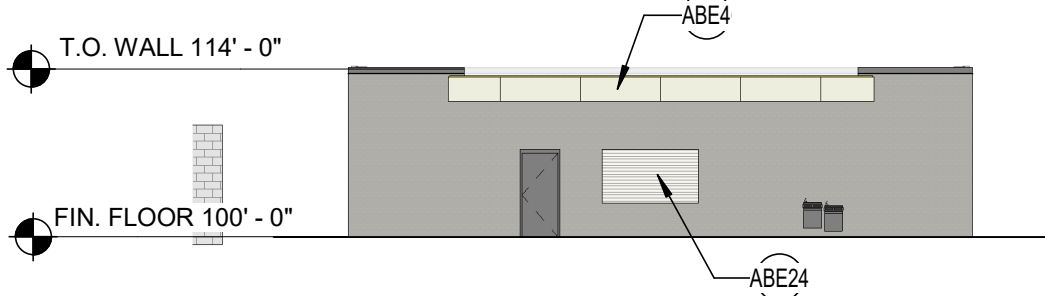


51 ATHLETIC BUILDING EAST
A5.02 SCALE: 1/16" = 1'-0"

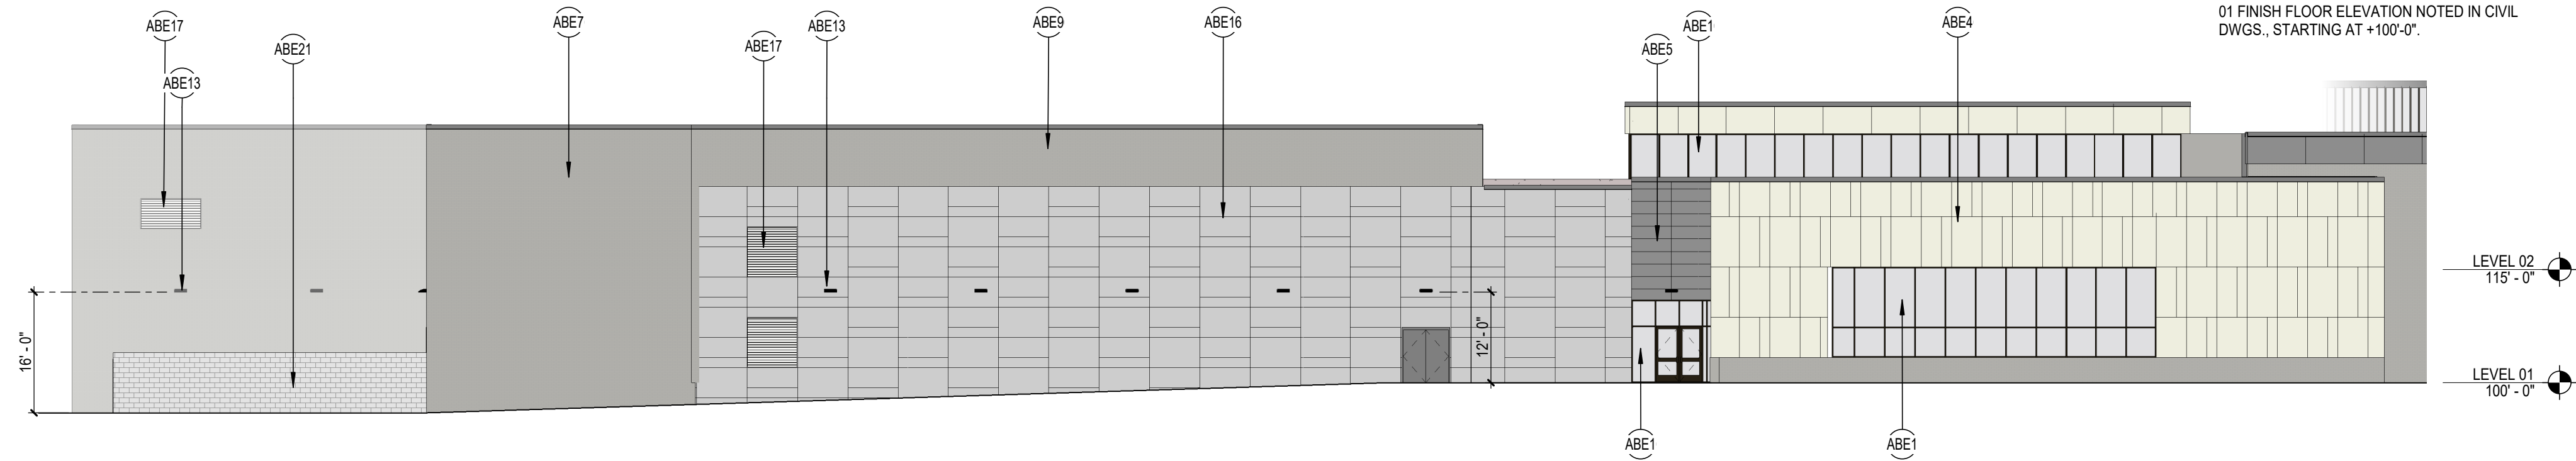

23 EAST ELEVATION-ATHLETICS-MEDIA CENTER
A5.02 SCALE: 1/16" = 1'-0"

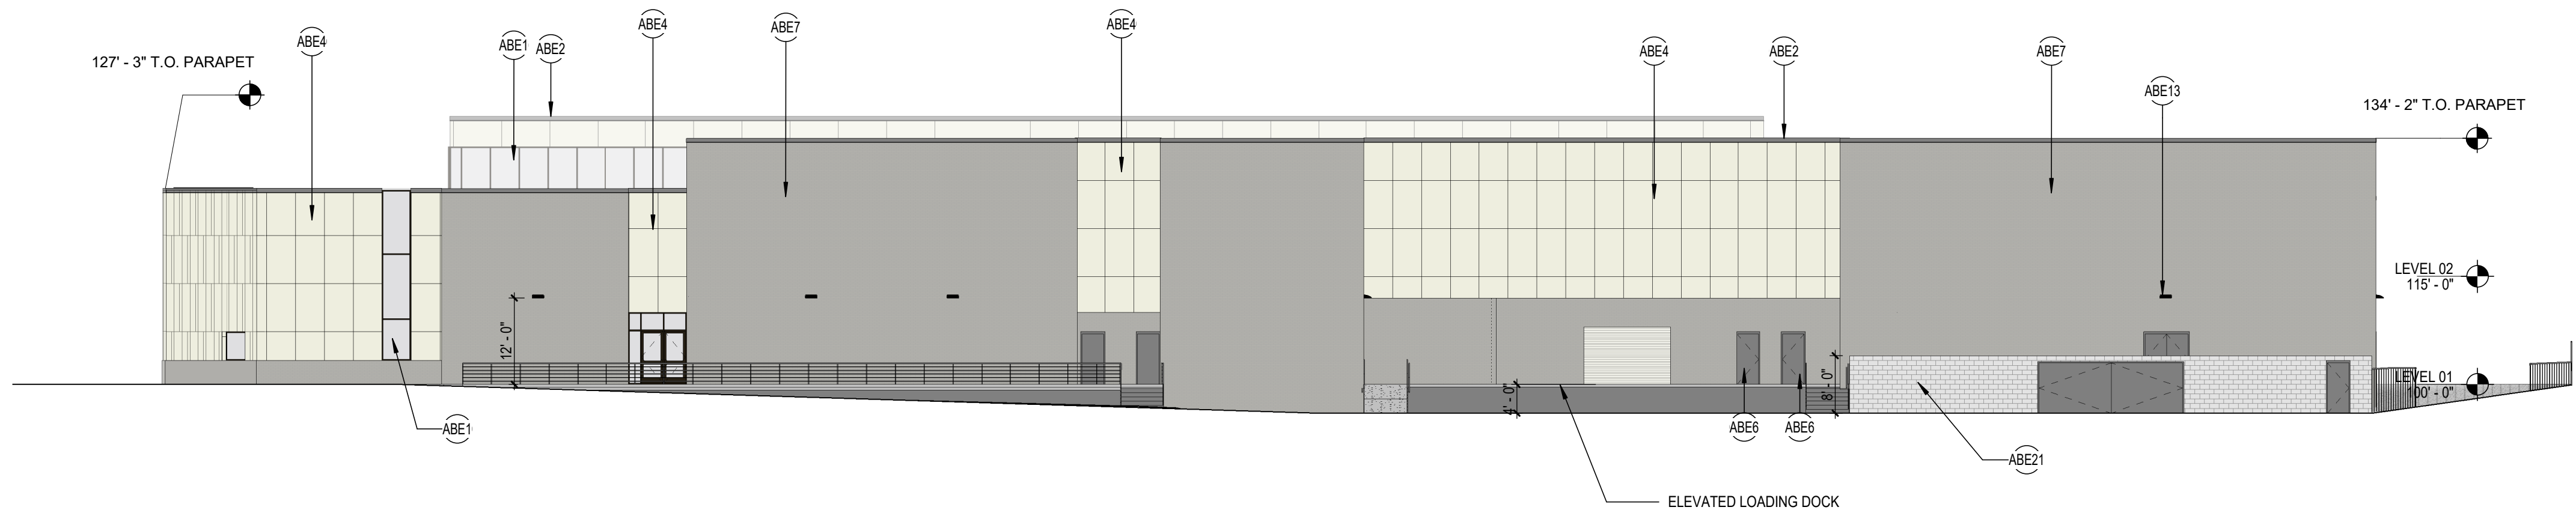

33 SOUTH ELEVATION-ATHLETICS-LOADING DOCK
A5.02 SCALE: 1/16" = 1'-0"

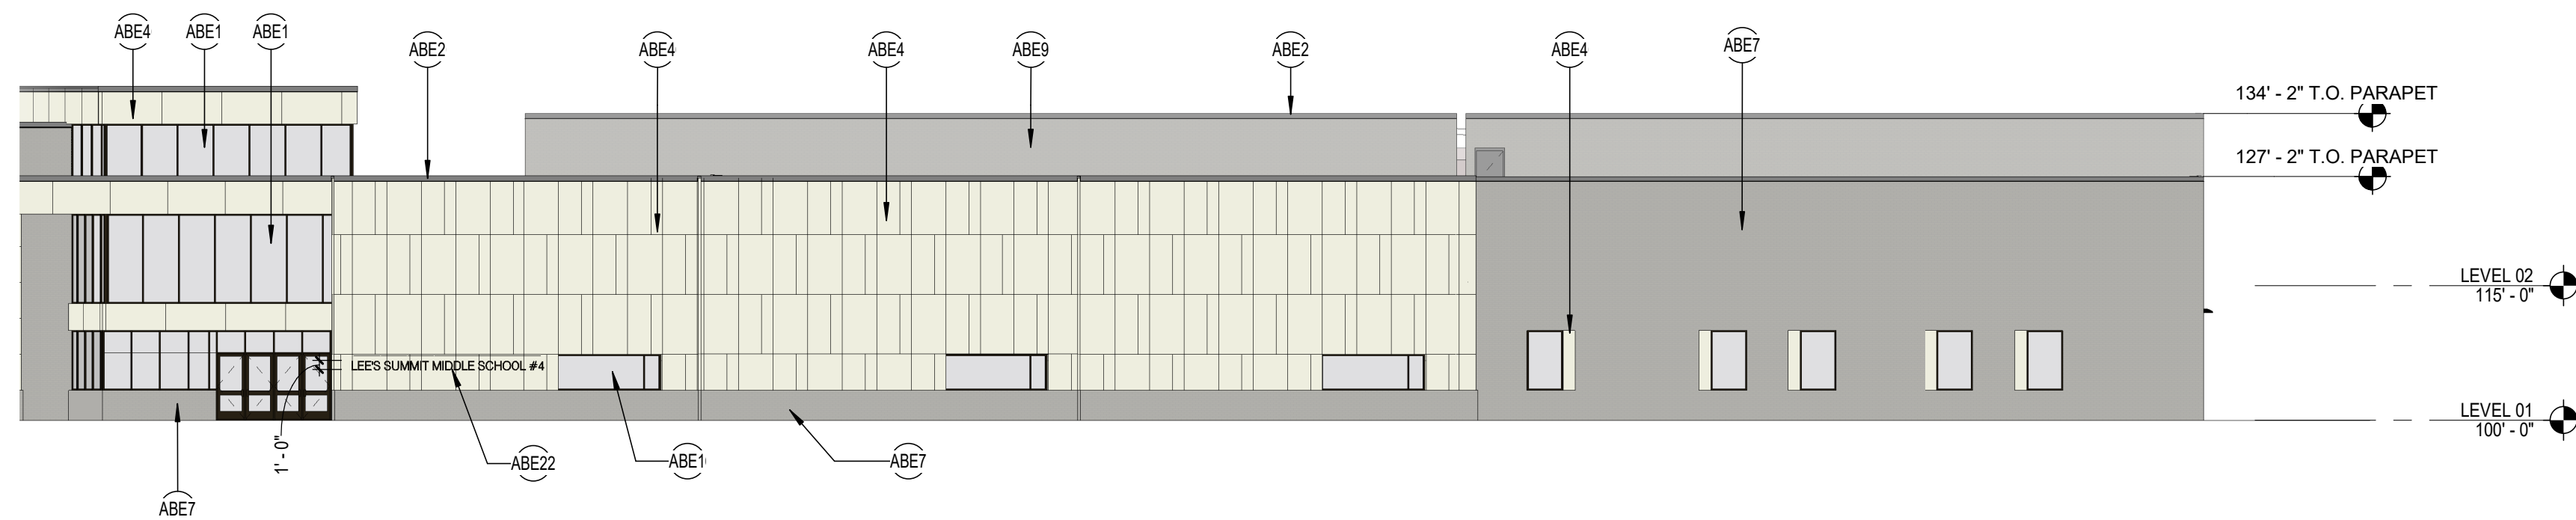

53 WEST ELEVATION-FINE ARTS-ATHLETICS
A5.02 SCALE: 1/16" = 1'-0"

KEYNOTE LEGEND

ABE1	ALUMINUM STOREFRONT SYSTEM (DARK BRONZE) WITH CLEAR GLAZING
ABE2	PREFINISHED METAL COPING.
ABE4	CEMENTITIOUS WALL PANEL (CP-1) AMERICAN FIBER CEMENT S-282 SATURN, OR EQ.
ABE5	CEMENTITIOUS WALL PANEL (CP-2) AMERICAN FIBER CEMENT S-030 MERCURY, OR EQ.
ABE6	HOLLOW METAL DOOR AND FRAME.
ABE7	FACE BRICK (FB-1) MODULAR, ACME MARBLE GRAY VELOUR PEP166, OR EQ.
ABE9	THIN BRICK (TB-1) OVER PRECAST. THIN BRICK TO MATCH FB-1
ABE13	BUILDING MOUNTED LIGHT FIXTURE, RE: ELEC.
ABE16	EXTERIOR PRECAST WALL PANEL (EP-1) WITH TEXTURED FINISH
ABE17	ALUMINUM WALL LOUVER, RE: MECH.
ABE18	CONDUCTOR HEAD WITH DOWNSPOUT W/ BOOT TO STORM
ABE21	GROUND FACE MASONRY BLOCK
ABE22	ALUMINUM DIMENSIONAL LETTER SIGNAGE
ABE24	OVERHEAD COILING DOOR

GENERAL NOTES

- ELEVATIONS ARE SHOWN RELATIVE TO LEVEL 01 FINISH FLOOR ELEVATION NOTED IN CIVIL DWGS., STARTING AT +100'-0".

1. REFER TO E01.01 FOR SITE PHOTOMETRIC GENERAL NOTES.
2. REFER TO E01.01 FOR PHOTOMETRIC CALCULATIONS SUMMARIES



CURTIS A. OLDS
LICENSE # PE-2018036640

HENDERSON
ENGINEERS

8345 LENEKA DRIVE, SUITE 300
LENEKA, KS 66214
TEL 913.742.5000 FAX 913.742.5001

WWW.HENDERSONENGINEERS.COM

1950005054
MO. CORPORATE NO. E-558D
EXPIRES 12/31/2020

LEE'S SUMMIT MIDDLE SCHOOL #4
LEE'S SUMMIT R-7 SCHOOL DISTRICT
Lee's Summit, MO. TBD

PDP SUBMITTAL


05/08/2020

REVISIONS

13-20102-00


**SITE LIGHTING
PHOTOMETRIC
PLAN**

E01.00

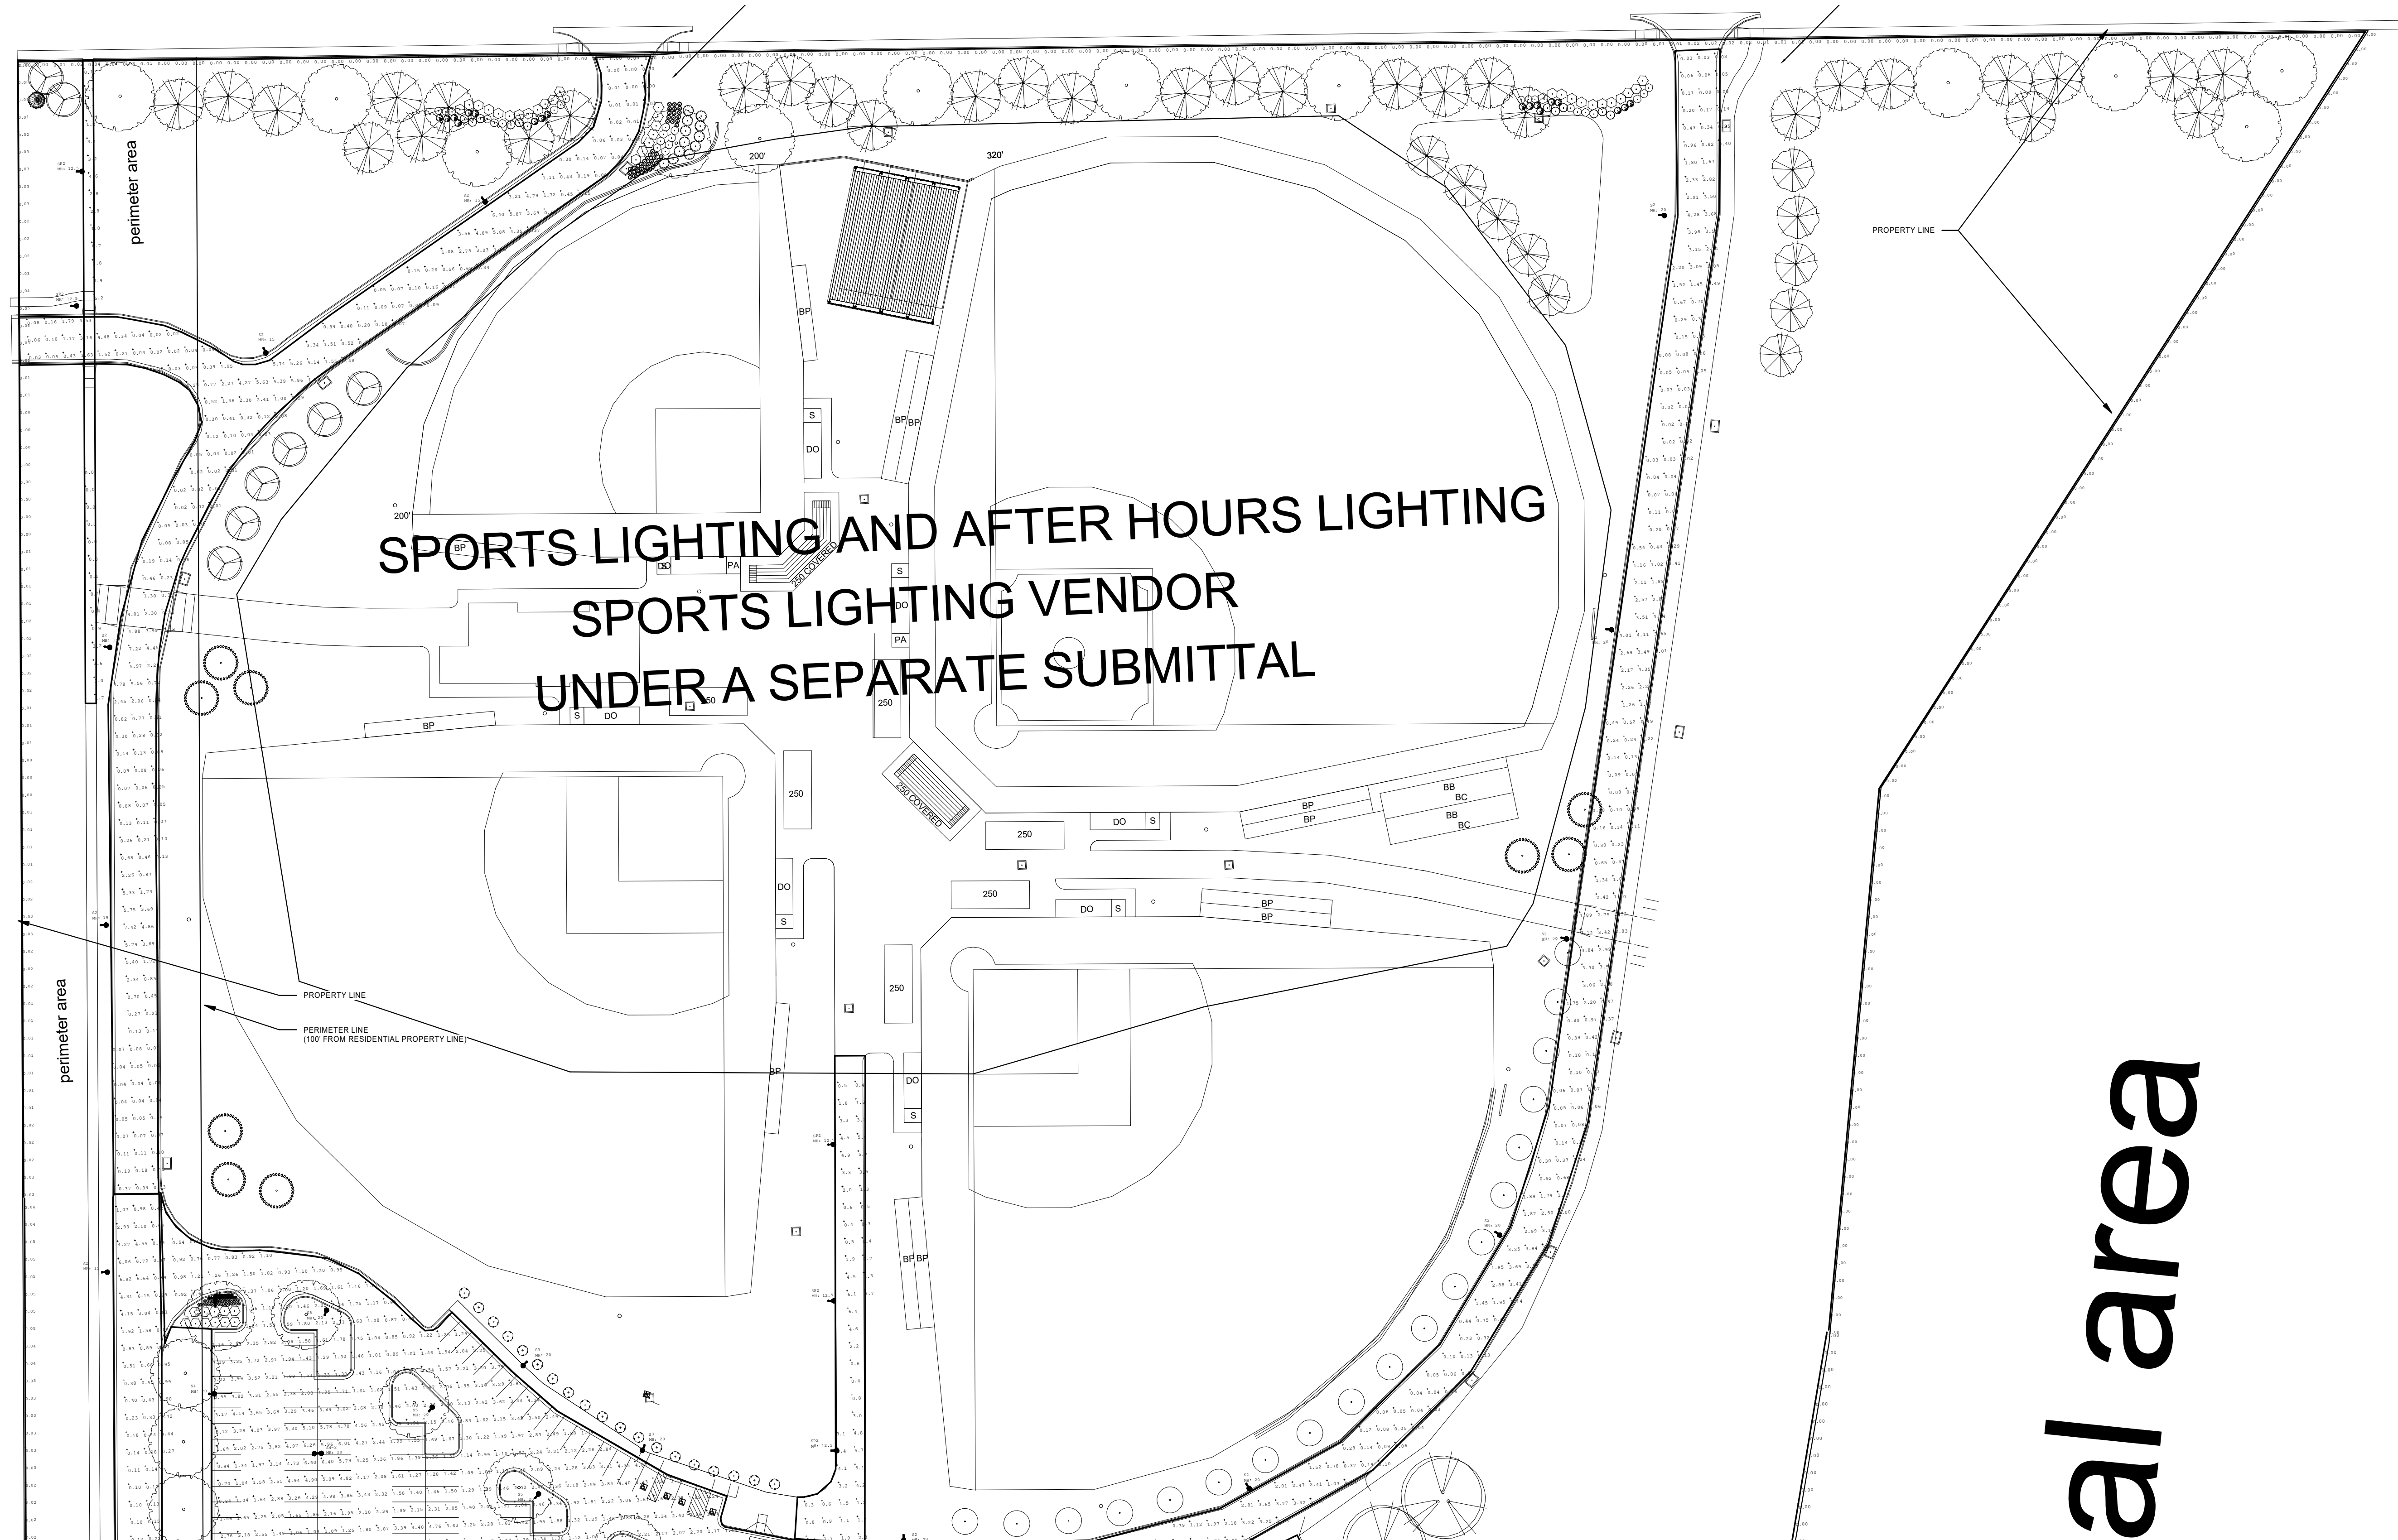

① PHOTOMETRIC SITE PLAN - AREA 1
1" = 50'-0"

CURTIS A. OLDS

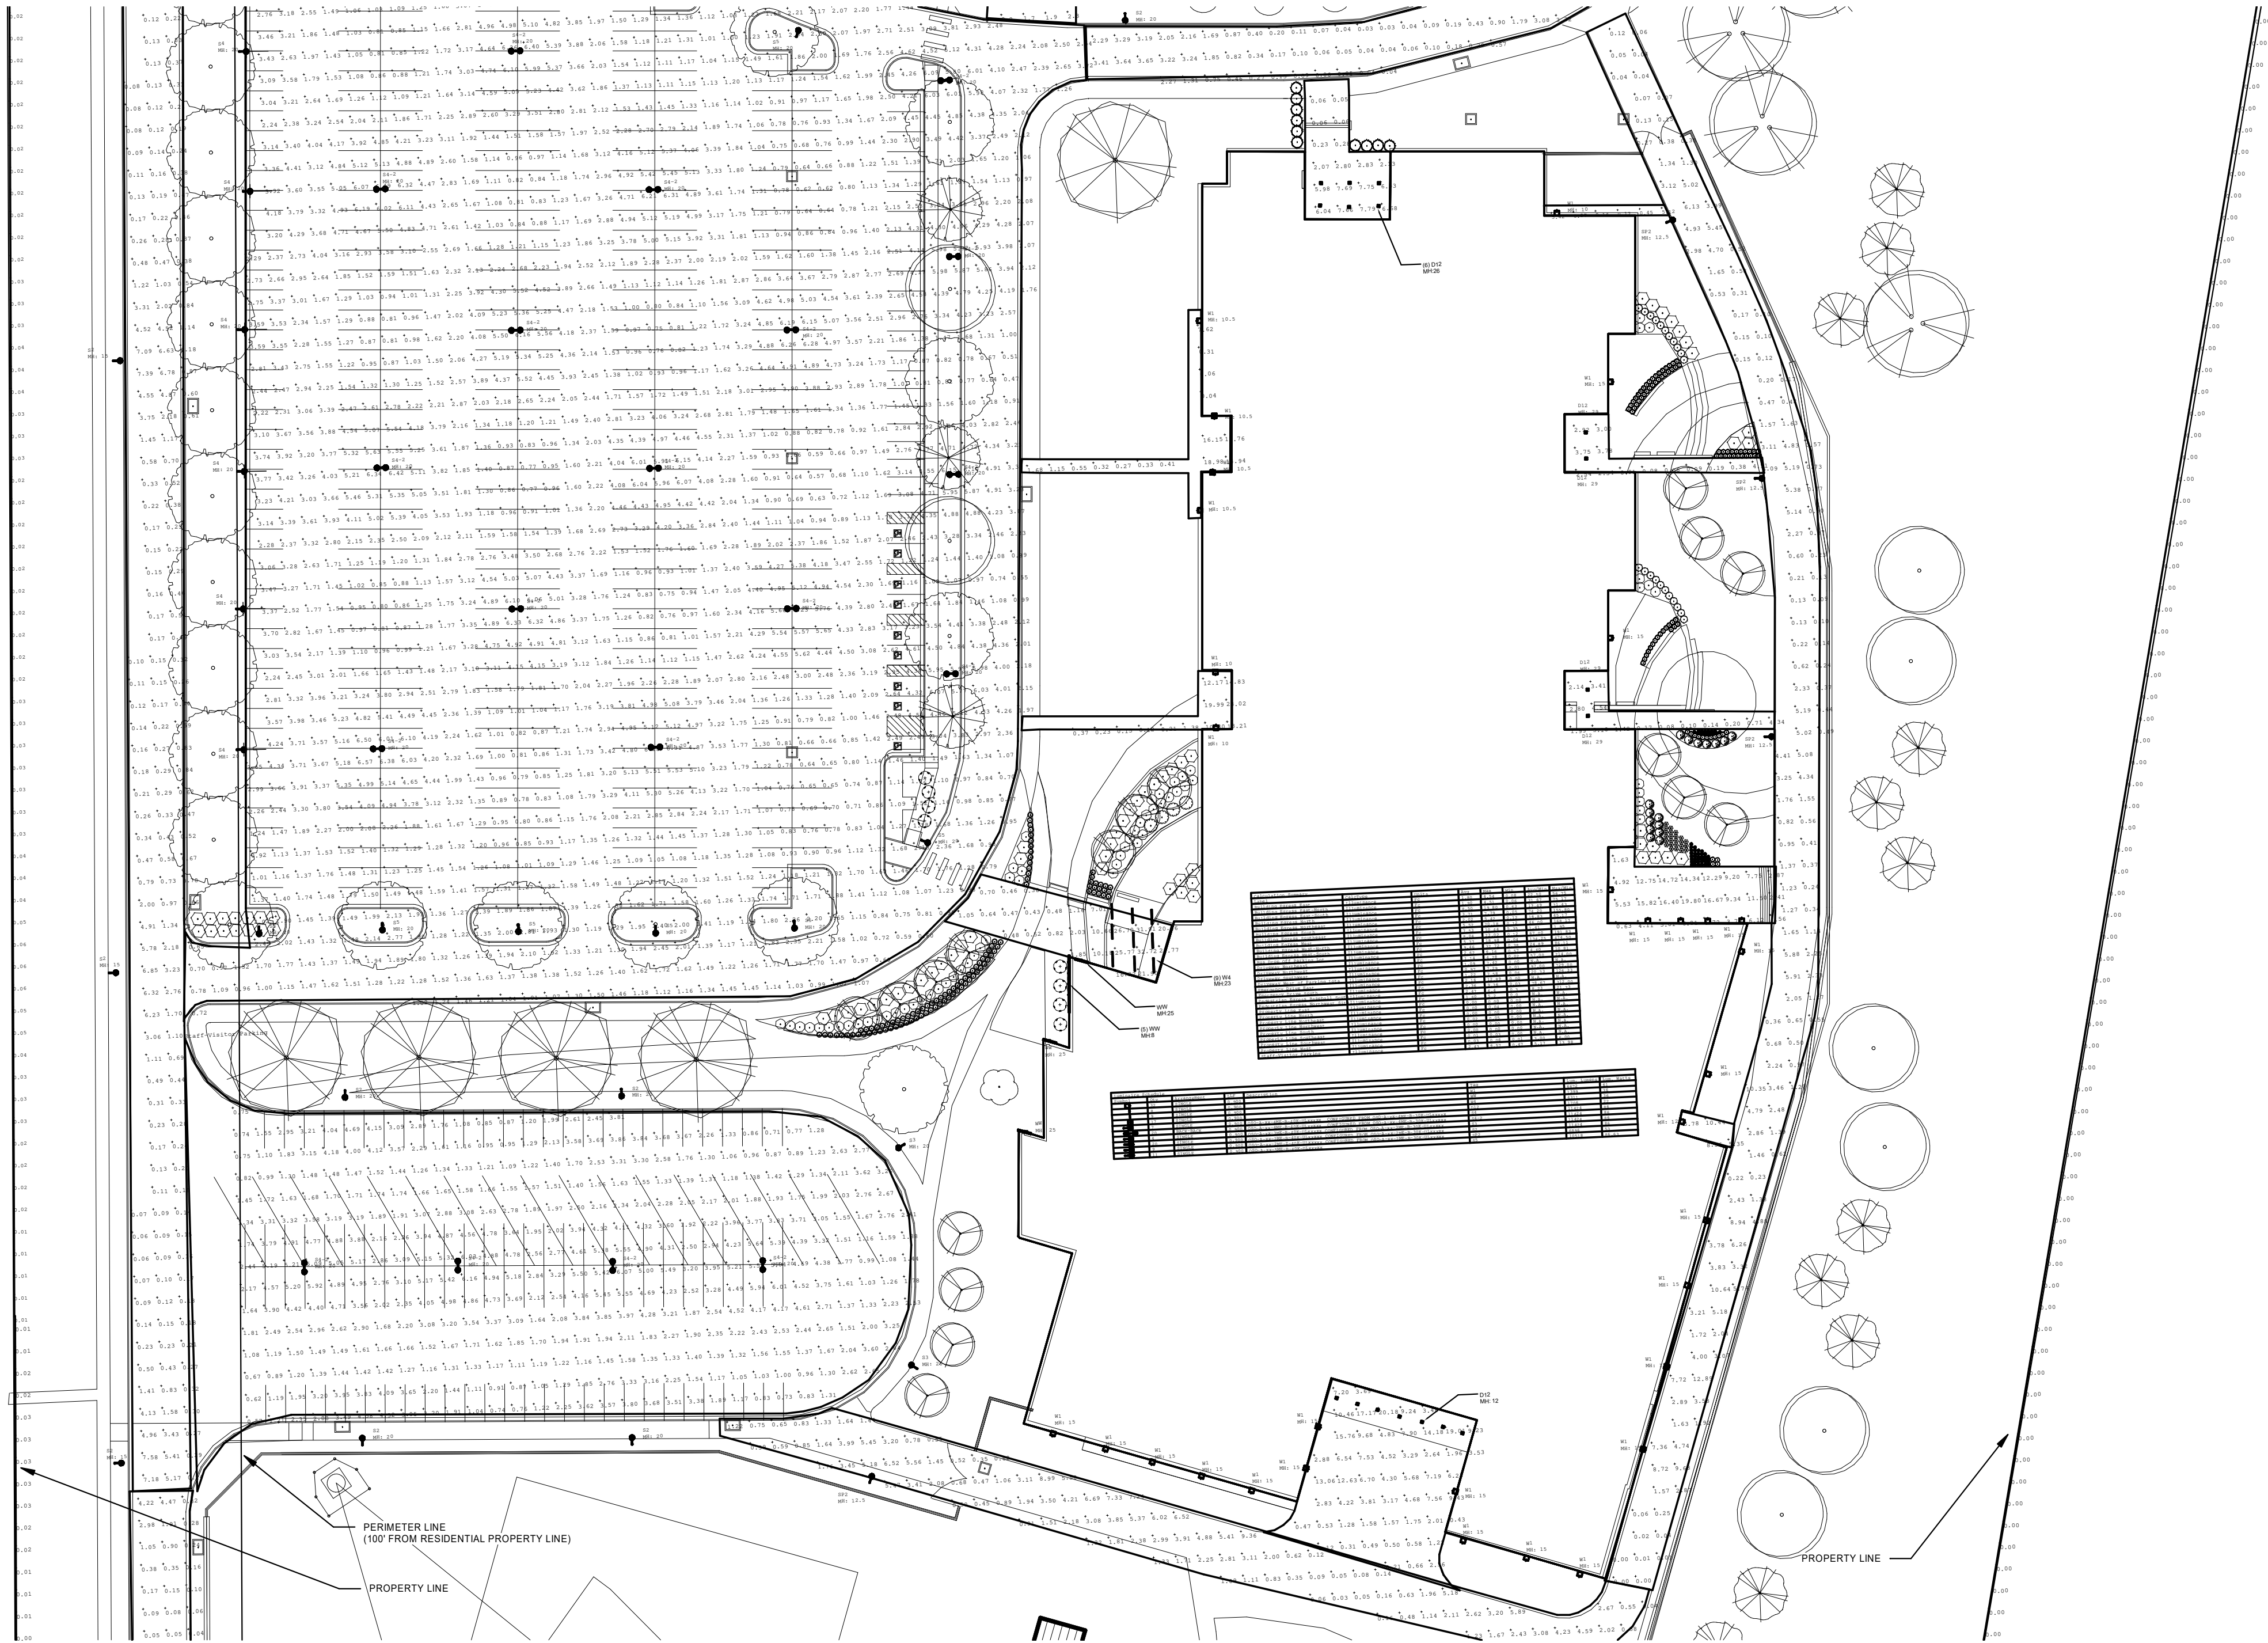

1 PHOTOMETRIC SITE PLAN - AREA 2
1" = 50'-0"

SITE PHOTOMETRIC GENERAL NOTES:

1. DISCLAIMER: THE LOCATION AND SELECTION OF THE EXISTING SITE LIGHTING FIXTURES ARE OUTSIDE OF THE SCOPE OF WORK. THE USE OF THE SEAL AND SIGNATURE ON THIS SHEET APPLIES TO SCOPE OF SERVICES ONLY.
 - A. LIGHTING PATTERN USED FOR LUMINAIRES REPRESENTS ILLUMINATION LEVELS CALCULATED FROM LABORATORY DATA TAKEN UNDER CONTROLLED CONDITIONS IN ACCORDANCE WITH ILLUMINATING ENGINEERING SOCIETY APPROVED METHODS. ACTUAL PERFORMANCE OF ANY LUMINAIRE MAY VARY DUE TO VARIATION IN VOLTAGE, TOLERANCE IN LAMPS AND OTHER VARIABLE FIELD AND EQUIPMENT CONDITIONS.
 - B. SOFTWARE USED FOR PHOTOMETRIC CALCULATIONS: AGI32 - V19.3
2. THE NEW SITE LIGHTING FOR THE NEW PARKING AREAS IS DESIGNED TO MEET THE FOLLOWING CRITERIA EXCEPT WHERE LIMITED BY SITE CONSTRAINTS AND LOCAL REQUIREMENTS:
 - A. AVG MAINTAINED HORIZONTAL ILLUMINATION LEVEL AT FINISHED GRADE NO LESS THAN 2 FC AT THE FRONT PARKING AREAS.
 - B. AVG MAINTAINED HORIZONTAL ILLUMINATION LEVEL AT FINISHED GRADE NO LESS THAN 2 FC AT THE REAR PAVED AREAS AND DRIVE AISLES.
 - C. MAXIMIN RATIO FOR EACH NEW PARKING AREA SHALL BE LESS THAN 10:1.
 - D. MAXIMUM HORIZONTAL ILLUMINATION LEVEL OF 1 FC AT FINISHED GRADE AT ALL RESIDENTIAL PROPERTY LINES.
 - E. MAXIMUM VERTICAL ILLUMINATION LEVEL OF 1 FC AT 6'-0" ABOVE FINISHED GRADE AT ALL RESIDENTIAL PROPERTY LINES.
 - F. PHOTOMETRIC CALCULATION GRID SHALL NOT EXCEED A 10' X 10' SPACING.
 - G. THE TOTAL LIGHT LOSS FACTOR USED FOR THE CALCULATIONS SHALL BE .9 OF INITIAL LUMEN OUTPUT FOR LED SOURCES AND .9 FOR EXISTING SOURCES SOURCES, UNLESS NOTED OTHERWISE.
 - H. MAXIMUM POLE MOUNTED LUMINAIRE MOUNTING HEIGHT (INCLUDING POLE AND BASE) OF 20' ABOVE FINISHED GRADE (A.F.G.) OUTSIDE PERIMETER AREA. INSIDE PERIMETER AREA MAX HEIGHT OF POLE MOUNTED LUMINAIRES IS 15' A.F.G. MAXIMUM HEIGHT OF PEDESTIAN POLE FIXTURES IS 12.5' A.F.G. MAXIMUM HEIGHT OF BUILDING MOUNTED AREA TYPE LIGHT FIXTURES IS 15' A.F.G.
 - I. MOUNTING HEIGHTS UNITS ON SITE PLANS ARE LISTED IN FEET AND ARE NOTED FOR EACH INDIVIDUAL FIXTURE. (MH: XX)



THIS DOCUMENT IS RELEASED FOR THE PURPOSE OF PRELIMINARY SUBMITTAL CURTIS A. OLDS LICENSE # PE-2018036640 IT IS NOT TO BE USED FOR CONSTRUCTION PURPOSES

CURTIS A. OLDS LICENSE # PE-2018036640


HENDERSON ENGINEERS
8345 LEE SUMMIT DRIVE 300
LEENEA, MO 64624
TEL 913.742.5000 FAX 913.742.5001
WWW.HENDERSONENGINEERS.COM
1507005064
MO CORPORATE NO. E-5560
EXPIRES 12/31/2020

LEE'S SUMMIT MIDDLE SCHOOL #4
LEE'S SUMMIT R-7 SCHOOL DISTRICT
Lee's Summit, MO, TED

PDP SUBMITTAL
05/08/2020
REVISIONS

13-20102-00
SITE LIGHTING
PHOTOMETRIC
PLAN

E01.01

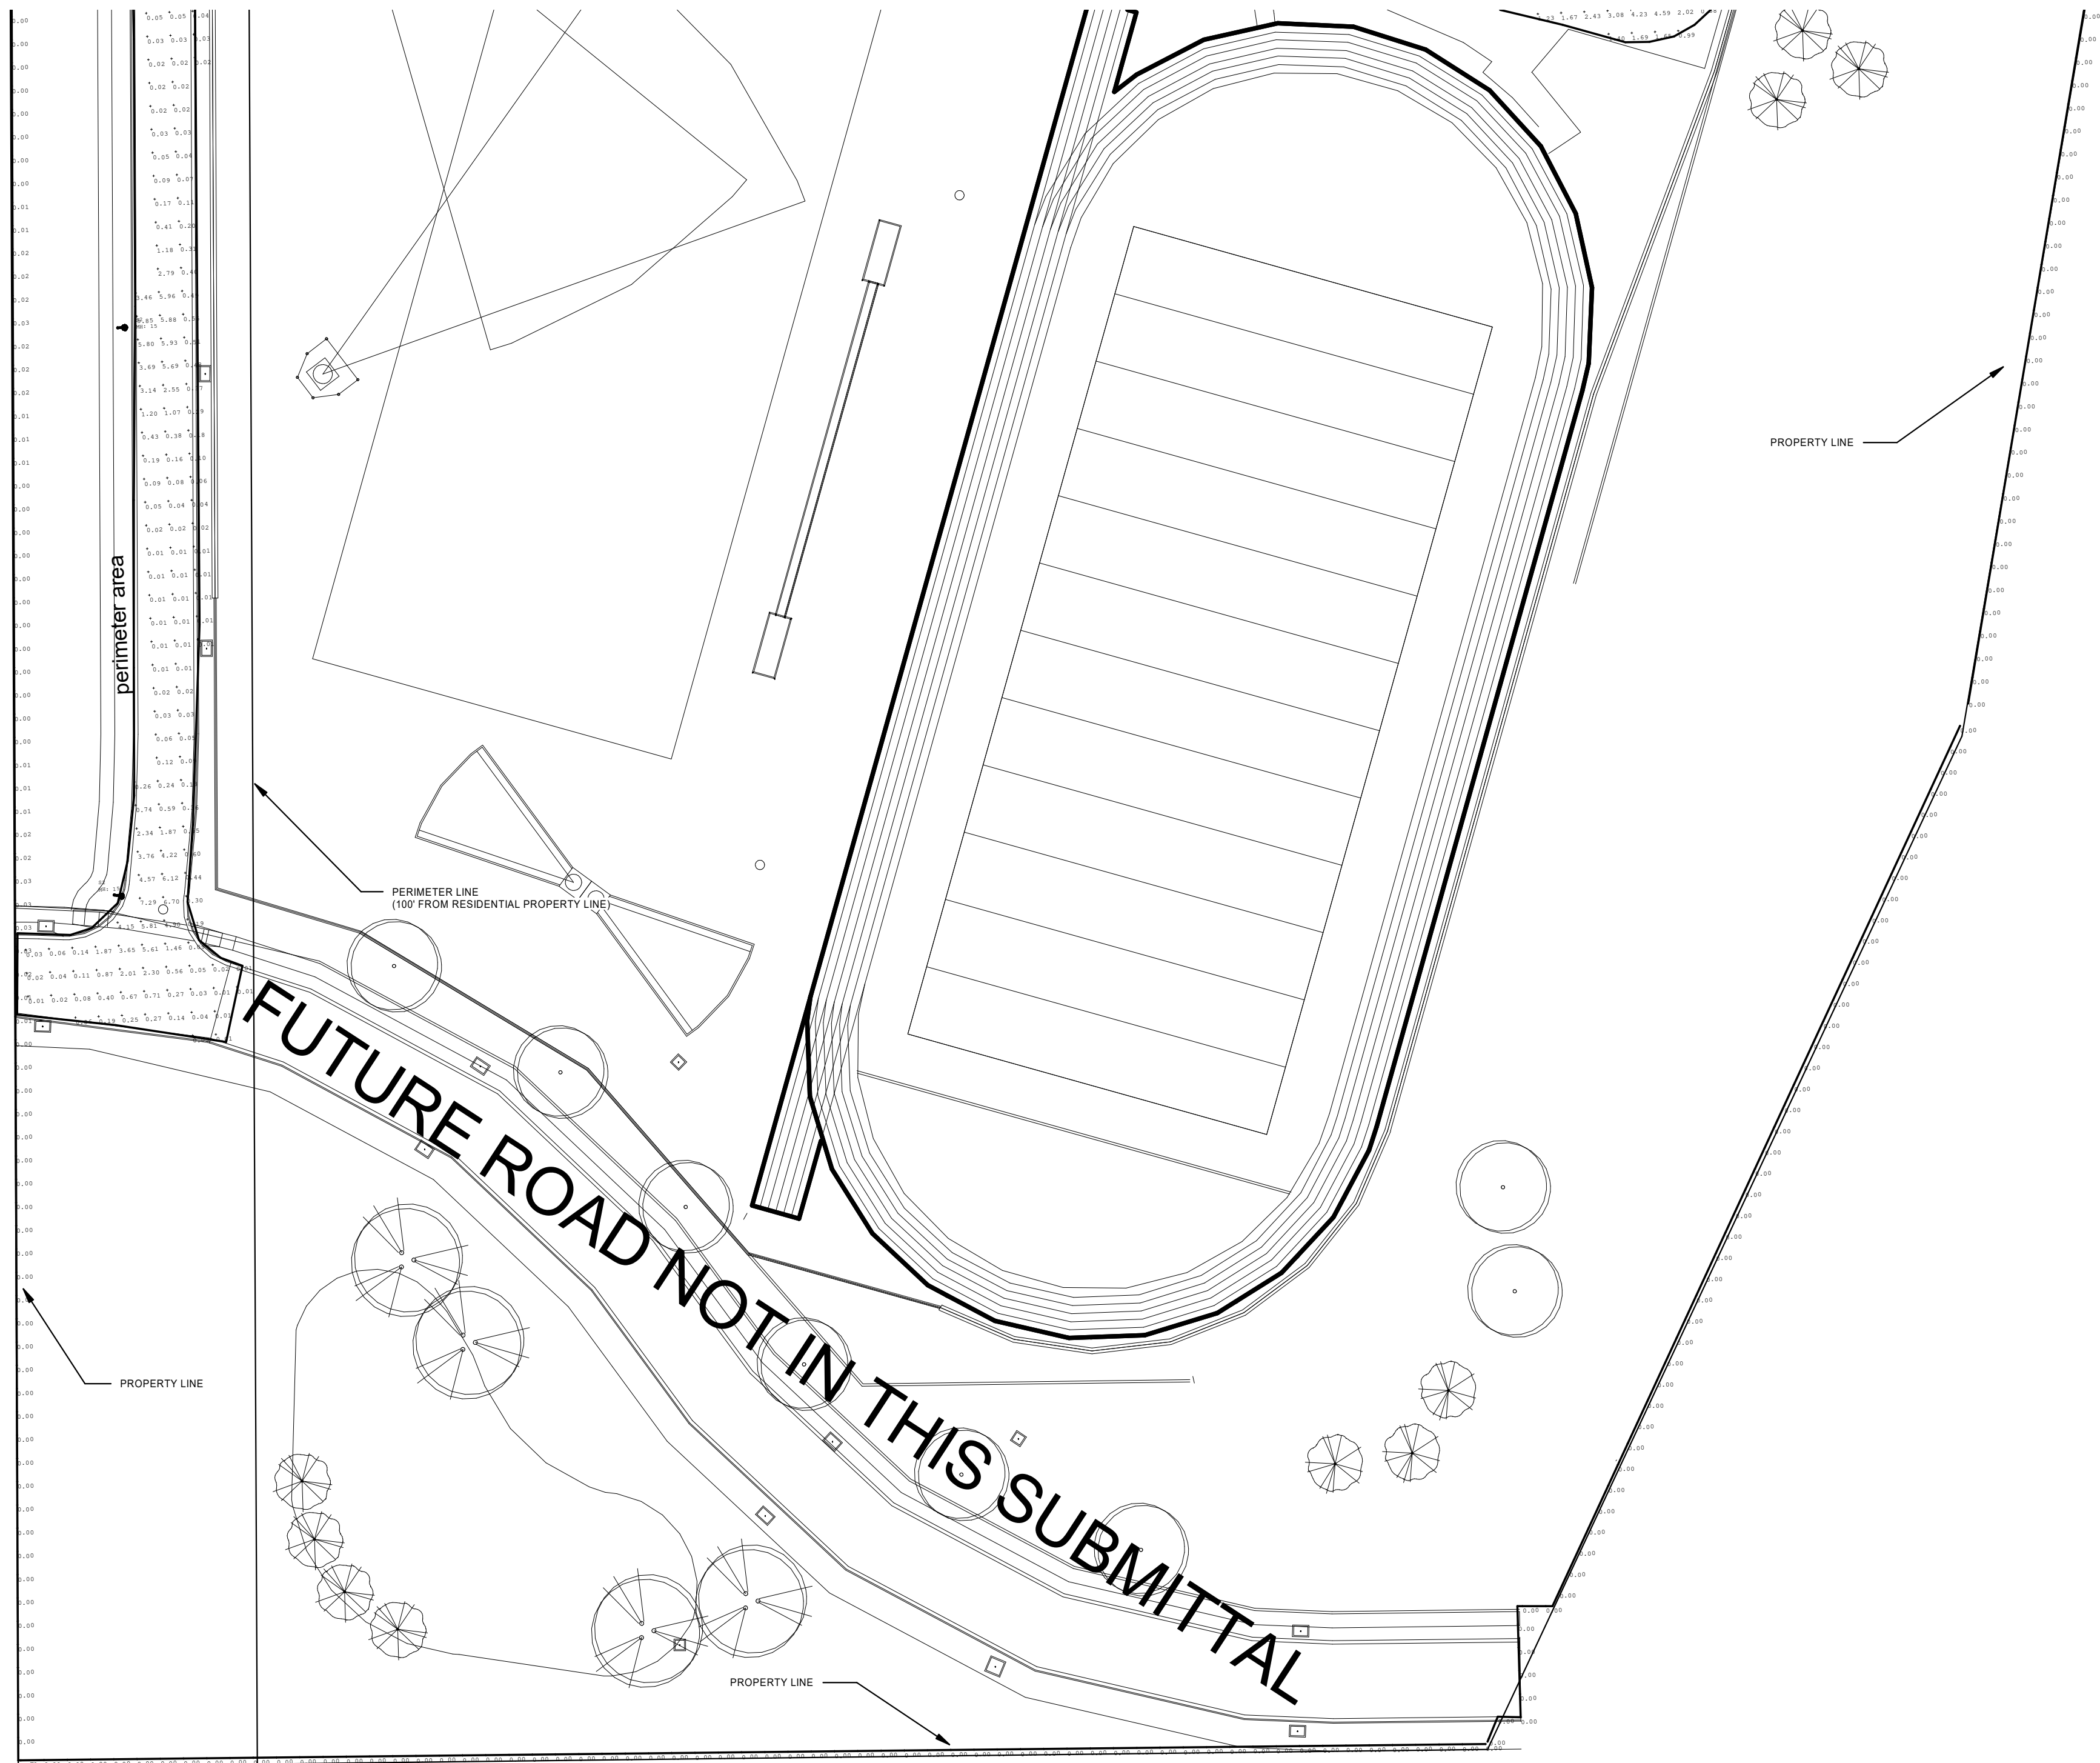

① PHOTOMETRIC SITE PLAN - AREA 3
1" = 50'-0"

SITE PHOTOMETRIC GENERAL NOTES:

1. REFER TO E01.01 FOR SITE PHOTOMETRIC GENERAL NOTES.
2. REFER TO E01.01 FOR PHOTOMETRIC CALCULATIONS SUMMARIES

THIS DOCUMENT IS RELEASED
FOR THE PURPOSE OF
PRELIMINARY SUBMITTAL
CURTIS A. OLDS
LICENSE # PE-2018036640
IT IS NOT TO BE USED FOR
CONSTRUCTION
PURPOSES

CURTIS A. OLDS
LICENSE # PE-2018036640

HENDERSON
ENGINEERS
8345 LEE ROAD, SUITE 300
LEES SUMMIT, MO 64084
TEL 913.742.5000 FAX 913.742.5001
WWW.HENDERSONENGINEERS.COM
1907005054
MO CORPORATE NO. E-556D
EXPIRES 12/31/2020

LEE'S SUMMIT MIDDLE SCHOOL #4

LEE'S SUMMIT R-7 SCHOOL DISTRICT

Lee's Summit, MO, TED

PDP SUBMITTAL

05/08/2020

REVISIONS

13-20102-00


SITE LIGHTING
PHOTOMETRIC
PLAN

E01.02

BEGA

WW - PHOTOMETRIC SUMMARY

Photometric Filename: 44419.IES
TEST: BE_44419
TEST LAB: BEGA
DATE: 3/6/2017
LUMINAIRE: 44 419
LAMP: 30.4W LED

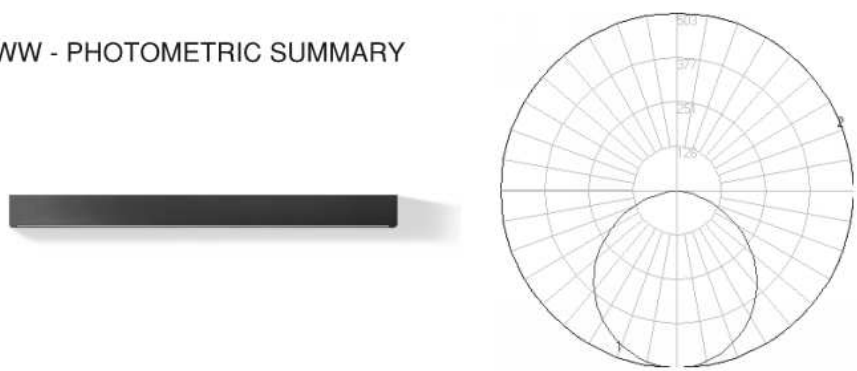


Characteristics
IES Classification
Longitudinal Classification
Lumens Per Lamp
Total Lamp Lumens
Luminaire Lumens
Downward Total Efficiency
Total Luminaire Efficiency
Luminaire Efficacy Rating (LER)
Total Luminaire Watts
Ballast Factor
Upward Waste Light Ratio
Max. Cd (180H, 0V)
Max. Cd (<90 Vert.)
Max. Cd (At 90 Deg. Vert.)
Max. Cd (80 to <80 Deg. Vert.)
Cutoff Classification (deprecated)

Type VS
Very Short
N.A. (absolute)
N.A. (absolute)
1399
N.A.
N.A.
39
36
1.00
N.A.
502.5 (180H, 0V)
502.5 (180H, 0V)
4 (0.0%lum)
42.7 (3.0%lum)
N.A. (absolute)

Lum. Classification System (LCS)

LCS Zone	Lumens	%Lamp	%lum
FL (0-30)	153.6	N.A.	13.8
FM (30-60)	360.5	N.A.	25.8
FH (60-80)	122.0	N.A.	8.7
FVH (80-90)	6.0	N.A.	0.4
BL (0-30)	195.7	N.A.	14.0
BM (30-60)	375.2	N.A.	26.8
BH (60-80)	136.7	N.A.	9.8
BVH (80-90)	8.9	N.A.	0.6
UL (90-100)	0.0	N.A.	0.0
UL (100-180)	0.0	N.A.	0.0
Total	1398.6	N.A.	100.0

BUG Rating B1-U0-G0

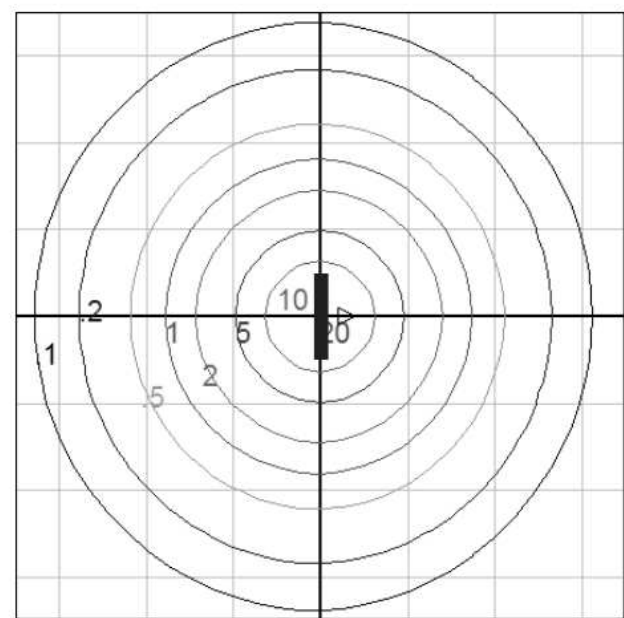

Wall mount - isofotocandle diagram on floor
Mounting Height = 5 ft. Grid Spacing = 5 ft.

In the interest of product improvement, BEGA reserves the right to make technical changes without notice.

BEGA 1000 Bega Way, Carpinteria, CA 93013 (805)684-0533 Fax (805)666-9474 www.bega-us.com © Copyright BEGA-US 2018

BEGA

LED wall luminaire - light output on one side

Application
The LED wall mounted luminaire has light output on one side. Arranged individually or in groups, this is a great design element for a host of lighting applications. For downlight applications only.

Materials
Luminaire housing constructed of die-cast and extruded marine grade, copper free (≤0.3% copper content) A360.0 aluminum alloy
Malle safety glass
High temperature silicone gasket
Mechanically captive stainless steel fasteners



NTNL listed to North American Standards, suitable for wet locations
Protection class IP65
Weight: 25.2 lbs

Electrical
Operating voltage 120-277VAC
Minimum start temperature -30°C
LED module wattage 30.4W
System wattage 36W
Controllability 0-10V dimmable
Color rendering index Ra > 90
Luminaire lumens 1399 lumens (3000K)
Lifetime at Ta = 15°C 229,000 h (L70)
Lifetime at Ta = 45°C 229,000 h (L70)

LED color temperature
E-4000K - Product number + **K4**
E-3500K - Product number + **K35**
E-3000K - Product number + **K3**
E-2700K - Product number + **K27**

BEGA can supply you with suitable LED replacement modules for up to 20 years after the purchase of LED luminaires - see website for details

Finish
All BEGA standard finishes are matte, textured polyester powder coat with minimum 3 mil thickness.
Available colors: Black (BLK) White (WHT) RAL: Silver (SLV) CUS:

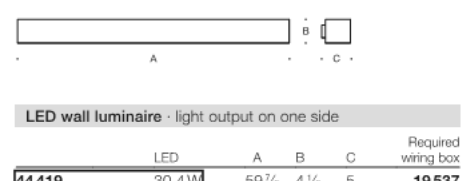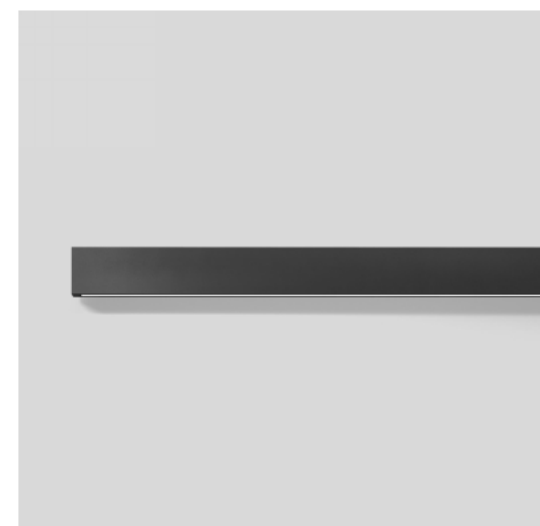

LED wall luminaire - light output on one side

LED A B C 30.4W 59% 4% 5 19507

BEGA 1000 Bega Way, Carpinteria, CA 93013 (805)684-0533 info@bega-us.com



Due to the dynamic nature of lighting products and the associated technologies, luminaire data on this sheet is subject to change at the discretion of BEGA North America. For the most current technical data, please refer to bega-us.com. Updated 06/16/18

4 WW - Linear Wall Wash NTS

BEGA

W4 - PHOTOMETRIC SUMMARY

Photometric Filename: 24304.ies
TEST: BE_24304
TEST LAB: BEGA
DATE: 4/12/2017
LUMINAIRE: 24 304
LAMP: 32W LED

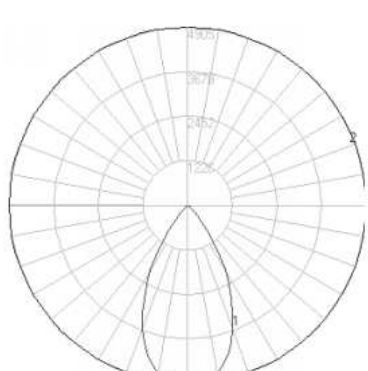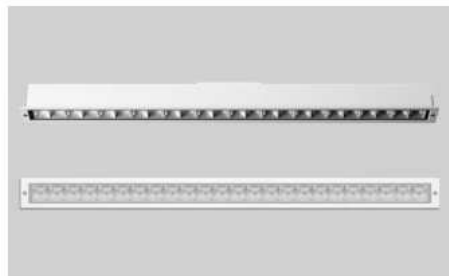


Characteristics

NEMA Type
Maximum Candela
Maximum Candela Angle
Horizontal Beam Angle (50%)
Vertical Beam Angle (50%)
Horizontal Field Angle (10%)
Vertical Field Angle (10%)
Lumens Per Lamp
Total Lamp Lumens
Beam Lumens
Beam Efficiency
Field Lumens
Field Efficiency
Spill Lumens
Luminaire Lumens
Total Efficiency
Total Luminaire Watts

5 H x 5 V
4904.5
0 H 0 V
55.0
54.9
82.7
81.2
N.A. (absolute)
N.A. (absolute)
2733
N.A.
4114
N.A.
208
4323
N.A.
36

Zonal Lumen Summary

Zone	Lumens
0-10	459.20
10-20	1196.15
20-30	1335.01
30-40	926.38
40-50	305.56
50-60	60.05
60-70	20.73
70-80	7.41
80-90	0.67
90-100	0.00
100-110	0.00
110-120	0.00
120-130	0.00
130-140	0.00
140-150	0.00
150-160	0.00
160-170	0.00
170-180	0.00

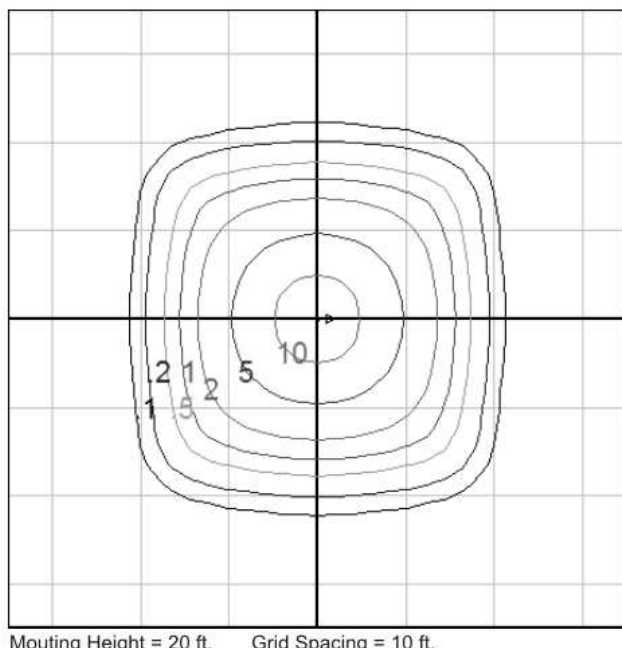

In the interest of product improvement, BEGA reserves the right to make technical changes without notice.

BEGA 1000 Bega Way, Carpinteria, CA 93013 (805)684-0533 Fax (805)666-9474 www.bega-us.com © Copyright BEGA-US 2018

1/4/2018

BEGA

LED recessed ceiling luminaires - Vortex optics - Symmetric wide

Application
Linear LED recessed ceiling luminaires with symmetric wide light distribution. The patent pending "vortex reflector" rotates a parabolic reflector around the vertical axis to form a complex vortex shape. The vortex balances maximum efficiency with optimal glare control while eliminating shadows and artifacts in a uniquely rectangular shape.

Materials
Luminaire housing and trim constructed of die-cast marine grade, copper free (≤0.3% copper content) A360.0 aluminum alloy
Clear safety glass
Reflector surface made of pure anodized aluminum
Silicone applied robotically to casting, plasma treated for increased adhesion

High temperature silicone gasket
Mechanically captive stainless steel fasteners
Stainless steel screw clamps



NTNL listed to North American Standards, suitable for wet locations
Protection class IP 65
Weight: 10.0 lbs

Electrical
Operating voltage 120-277VAC
Minimum start temperature -20°C
LED module wattage 32.0W
System wattage 36.0W
Controllability 0-10V dimming down to 0.1%
Color rendering index Ra > 90
Luminaire lumens 3,920 lumens (3000K)
Lifetime at Ta = 15°C >500,000 h (L70)
Lifetime at Ta = 45°C 87,000 h (L70)

LED color temperature
E-4000K - Product number + **K4**
E-3500K - Product number + **K35**
E-3000K - Product number + **K3**
E-2700K - Product number + **K27**

BEGA can supply you with suitable LED replacement modules for up to 20 years after the purchase of LED luminaires - see website for details

Finish
All BEGA standard finishes are matte, textured polyester powder coat with minimum 3 mil thickness.
Available colors: Black (BLK) White (WHT) RAL: Silver (SLV) CUS:

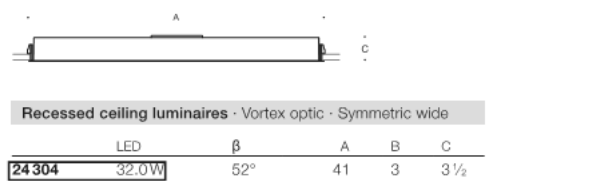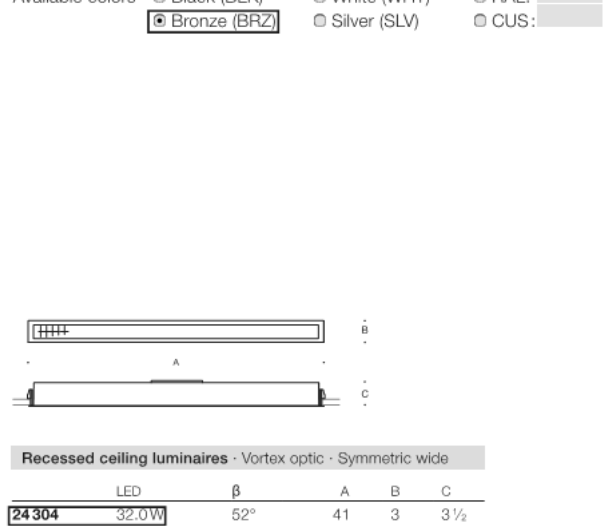

Recessed ceiling luminaires - Vortex optic - Symmetric wide

LED A B C 32W 82% 4% 3 2% 1

BEGA 1000 Bega Way, Carpinteria, CA 93013 (805)684-0533 info@bega-us.com


Due to the dynamic nature of lighting products and the associated technologies, luminaire data on this sheet is subject to change at the discretion of BEGA North America. For the most current technical data, please refer to bega-us.com. Updated 06/16/18

3 W4 - Linear Recessed NTS

BEGA

W1 - PHOTOMETRIC SUMMARY

Photometric Filename: 24816.ies
TEST: BE_24816
TEST LAB: BEGA
DATE: 11/30/2016
LUMINAIRE: 24 816
LAMP: 55.3W LED

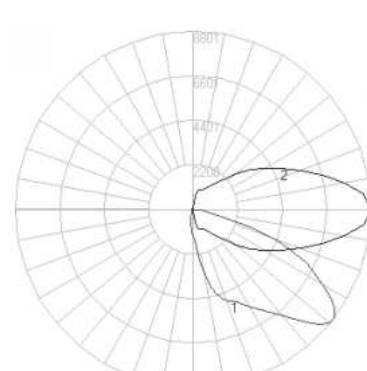

Characteristics


IES Classification
Longitudinal Classification
Lumens Per Lamp
Total Lamp Lumens
Luminaire Lumens
Downward Total Efficiency
Total Luminaire Efficiency
Luminaire Efficacy Rating (LER)
Total Luminaire Watts
Ballast Factor
Upward Waste Light Ratio
Max. Cd (180H, 0V)
Max. Cd (<90 Vert.)
Max. Cd (At 90 Deg. Vert.)
Max. Cd (80 to <80 Deg. Vert.)
Cutoff Classification (deprecated)

Type III
Very Short
N.A. (absolute)
N.A. (absolute)
8672
N.A.
109
61
1.00
N.A.
8801 (0H, 52.5V)
8801 (0H, 52.5V)
2.4 (0.0%lum)
551.2 (8.3%lum)
N.A. (absolute)

Lum. Classification System (LCS)

LCS Zone	Lumens	%Lamp	%lum
FL (0-30)	1181.6	N.A.	17.7
FM (30-60)	3467.0	N.A.	52.0
FH (60-80)	1690.9	N.A.	25.3
FVH (80-90)	39.4	N.A.	0.6
BL (0-30)	203.0	N.A.	3.0
BM (30-60)	72.8	N.A.	1.1
BH (60-80)	14.8	N.A.	0.2
BVH (80-90)	2.4	N.A.	0.0
UL (90-100)	0.0	N.A.	0.0
UL (100-180)	0.0	N.A.	0.0
Total	6672.0	N.A.	100.0

BUG Rating B1-U0-G1

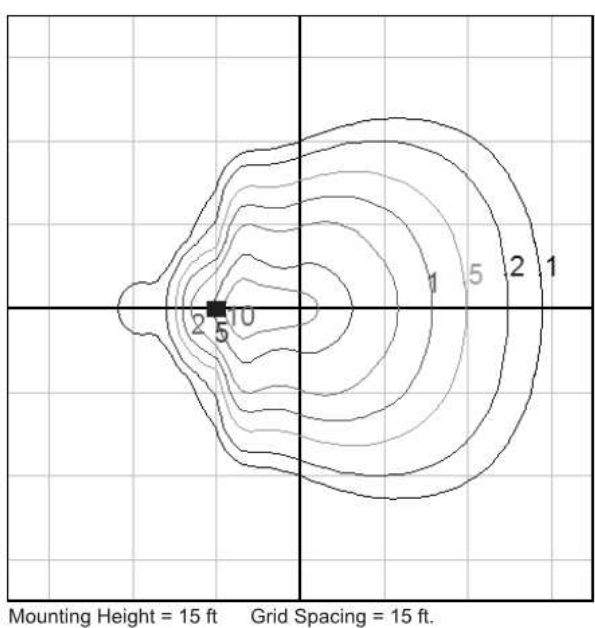

In the interest of product improvement, BEGA reserves the right to make technical changes without notice.

BEGA 1000 Bega Way, Carpinteria, CA 93013 (805)684-0533 Fax (805)666-9474 www.bega-us.com © Copyright BEGA-US 2018

2/7/2018

BEGA

LED wall luminaire - surface washer

Application
LED wall luminaire with asymmetrical light distribution designed for illuminating horizontal surfaces from vertical mounting surfaces.

Materials
Luminaire housing and faceplate constructed of die-cast marine grade, copper free (≤0.3% copper content) A360.0 aluminum alloy
Clear safety glass
Reflector made of pure anodized aluminum
Silicone applied robotically to casting, plasma treated for increased adhesion



High temperature silicone gasket
Mechanically captive stainless steel fasteners
NTNL listed to North American Standards, suitable for wet locations
Protection class IP65
Weight: 11.5 lbs

Electrical
Operating voltage 120-277VAC
Minimum start temperature -20°C
LED module wattage 55.3W
System wattage 61.0W
Controllability 0-10V dimmable
Color rendering index Ra > 90
Luminaire lumens 6,674 lumens (4000K)
Lifetime at Ta = 15°C 229,000 h (L70)
Lifetime at Ta = 35°C 73,000 h (L70)

LED color temperature
E-4000K - Product number + **K4**
E-3500K - Product number + **K35**
E-3000K - Product number + **K3**
E-2700K - Product number + **K27**

BEGA can supply you with suitable LED replacement modules for up to 20 years after the purchase of LED luminaires - see website for details

Finish
All BEGA standard finishes are matte, textured polyester powder coat with minimum 3 mil thickness.
Available colors: Black (BLK) White (WHT) RAL: Silver (SLV) CUS:

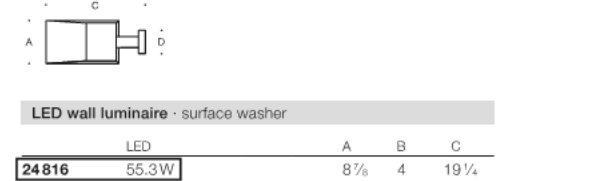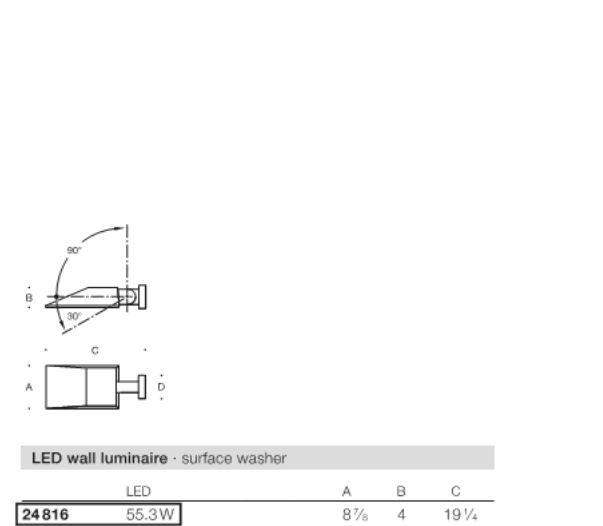

LED wall luminaire - surface washer

LED A B C 55.3W 8% 4% 19%

BEGA 1000 Bega Way, Carpinteria, CA 93013 (805)684-0533 info@bega-us.com


Due to the dynamic nature of lighting products and the associated technologies, luminaire data on this sheet is subject to change at the discretion of BEGA North America. For the most current technical data, please refer to bega-us.com. Updated 06/16/18

2 W1 - Wall Sconce NTS

BEGA

D12 - PHOTOMETRIC SUMMARY

Photometric Filename: 24806.IES
TEST: LI_24806
TEST LAB: BEGA
DATE: 3/14/2016
LUMINAIRE: 24 806
LAMP: 17.8W LED

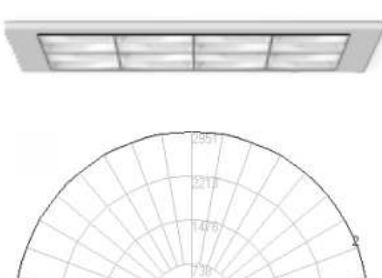


Characteristics

Lumens Per Lamp
Total Lamp Lumens
Luminaire Lumens
Total Luminaire Efficiency
Luminaire Efficacy Rating (LER)
Total Luminaire Watts
Ballast Factor
CIE Type
Spacing Criterion (0-180)
Spacing Criterion (90-270)
Basic Luminaire Shape
Luminous Length (0-180)
Luminous Width (90-270)
Luminous Height

N.A. (absolute)
N.A. (absolute)
1706
N.A.
78
22
1.00
Direct
0.66
0.66
Rectangular
0.36 ft
0.36 ft
0.00 ft

Zonal Lumen Summary

Zone	Lumens
0-10	256.02
10-20	546.17
20-30	535.46
30-40	287.10
40-50	51.70
50-60	16.97
60-70	8.17
70-80	3.78
80-90	0.54
90-100	0.00
100-110	0.00
110-120	0.00
120-130	0.00
130-140	0.00
140-150	0.00
150-160	0.00
160-170	0.00
170-180	0.00

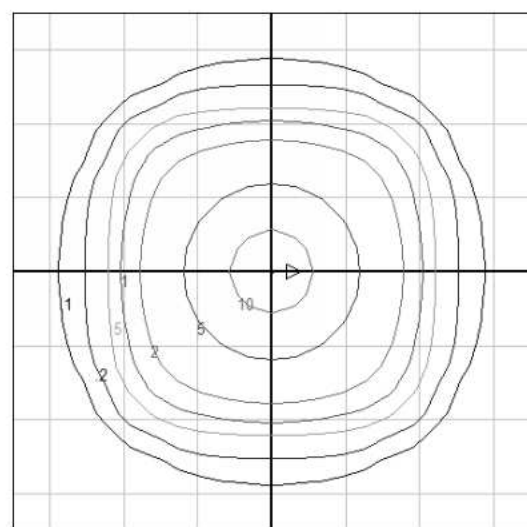

In the interest of product improvement, BEGA reserves the right to make technical changes without notice.

BEGA 1000 Bega Way, Carpinteria, CA 93013 (805)684-0533 Fax (805)666-9474 www.bega-us.com © Copyright BEGA-US 2017

1/12/2017

BEGA

LED recessed ceiling downlight - vortex reflector - wide beam

Application
LED recessed ceiling luminaire with symmetric wide beam light distribution. The patent pending "vortex reflector" rotates a parabolic reflector around the vertical axis to form a complex vortex shape. This vortex balances maximum efficiency with optimal glare control while eliminating shadows and artifacts in a uniquely sharp square distribution.

Materials
Luminaire housing and faceplate constructed of die-cast marine grade, copper free (≤0.3% copper content) A360.0 aluminum alloy
Clear safety glass
Reflector surface made of pure anodized aluminum
Silicone applied robotically to casting, plasma treated for increased adhesion

High temperature silicone gasket
Mechanically captive stainless steel fasteners
Stainless steel screw clamps



Galvanized steel rough in ceiling can with through wiring box
NTNL listed to North American Standards, suitable for wet locations
Protection class IP65
Weight: 1.8 lbs

Electrical
Operating voltage 120-277VAC
Minimum start temperature -20°C
LED module wattage 17.8W
System wattage 22W
Controllability 0-10V dimmable
Color rendering index Ra > 65
Luminaire lumens 1706 lumens (3000K)
Lifetime at Ta = 15°C 172,000 h (L70)
Lifetime at Ta = 30°C 73,000 h (L70)

LED color temperature
E-4000K - Product number + **K4**
E-3500K - Product number + **K35**
E-3000K - Product number + **K3**
E-2700K - Product number + **K27**

BEGA can supply you with suitable LED replacement modules for up to 20 years after the purchase of LED luminaires - see website for details

Finish
All BEGA standard finishes are matte, textured polyester powder coat with minimum 3 mil thickness.
Available colors: Black (BLK) White (WHT) RAL: Silver (SLV) CUS:

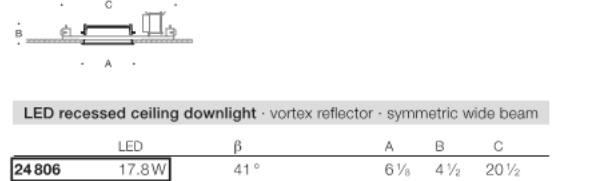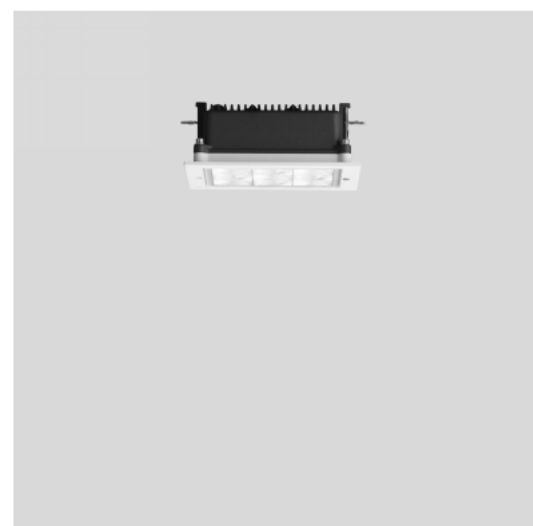

LED recessed ceiling downlight - vortex reflector - symmetric wide beam

LED A B C 17.8W 41% 4% 4% 20%

BEGA 1000 Bega Way, Carpinteria, CA 93013 (805)684-0533 info@bega-us.com

Due to the dynamic nature of lighting products and the associated technologies, luminaire data on this sheet is subject to change at the discretion of BEGA North America. For the most current technical data, please refer to bega-us.com. Updated 07/11/18

1 D12 - Square Downlight NTS

DLR Group
© DLR Group
© DLR Group, Inc., a Masco corporation.
ALL RIGHTS RESERVED
Masco's State Certificate of Authority #00039

THIS DOCUMENT IS RELEASED
FOR THE PURPOSE OF
PRELIMINARY SUBMITTAL
CURTIS A. OLDS
LICENSE # PE-2018036640
IT IS NOT TO BE USED FOR
CONSTRUCTION
PURPOSES

CURTIS A. OLDS
LICENSE # PE-2018036640

HENDERSON
ENGINEERS
8345 LEE SUMMIT DRIVE
LEE, MO 64624
TEL 913.742.5000 FAX 913.742.5001
WWW.HENDERSONENGINEERS.COM
195000564
MO CORPORATE NO. E-5580
EXPIRES 12/31/2020

LEE'S SUMMIT MIDDLE SCHOOL #4
LEE'S SUMMIT R-7 SCHOOL DISTRICT
Lee's Summit, MO, TED

PDP SUBMITTAL

05/08/2020

REVISIONS

13-20102-00

SITE LIGHTING
FIXTURE
CUTSHEETS

E01.03

TYPE S* POLE LIGHTS - 15' HEIGHT LEE'S SUMMIT PERIMETER ZONE, 20'
HEIGHT OUTSIDE OF PERMETER ZONE

OSQ Series

OSQ™ LED Area/Flood Luminaire featuring Cree TrueWhite® Technology - Medium

Product Description

The OSQ™ Area/Flood luminaire blends extreme optical control, advanced thermal management and modern, clean aesthetics. Built to last, the housing is rugged cast aluminum with an integral, weatherlight LED driver compartment. Versatile mounting configurations offer simple installation. Its slim, low profile design minimizes wind load requirements and blends seamlessly into the site providing even, quality illumination. The 'B' input power designator is a suitable upgrade for HID applications up to 250 Watt, and the 'K' input power designator is a suitable upgrade for HID applications up to 400 Watt.

Applications: Parking lots, walkways, campuses, car dealerships, office complexes, tunnels, underpasses, and internal roadways.

Performance Summary

Utilizes Cree TrueWhite® Technology on 5000K Luminaires

NanoOptic® Precision Delivery Grid™ optic

Assembled in the U.S.A. of U.S. and imported parts

Initial Delivered Lumens: Up to 17,291

Efficacy: Up to 136 LPW

CRB: Minimum 70 CRI (3000K, 4000K & 5700K), 90 CRI (5000K)

CCT: 3000K, 4000K, 5000K, 5700K

Limited Warranty*: 10 years on luminaires; 10 years on Colorfast DeltaGuard® finish; up to 5 years for Synapse® accessories; 1 year on luminaire accessories

*See <http://www.creeled.com/usa/usa> for warranty terms. The Synapse accessories, normal Synapse spec sheets for details on warranty terms.

Ordering Information

Fully assembled luminaire is composed of two components that must be ordered separately.

Example: Mount OSQ-B-AA20V - Luminaire OSQ-A-NA-2HC-S-10R-GL-2P

Mount Luminaire must be ordered separately*

OSQ

OSQ-B-AA

OSQ-B-AA20V

OSQ-B-AA20V

US: usa@henderon.com (800) 234-4800

Canada: canada@henderon.com (800) 473-1234

CREE LIGHTING

SP2 - Site Pedestrian Pole - 12.5' MAX

OSQ Series

OSQ™ LED Area/Flood Luminaire featuring Cree TrueWhite® Technology - Medium

Product Description

The OSQ™ Area/Flood luminaire blends extreme optical control, advanced thermal management and modern, clean aesthetics. Built to last, the housing is rugged cast aluminum with an integral, weatherlight LED driver compartment. Versatile mounting configurations offer simple installation. Its slim, low profile design minimizes wind load requirements and blends seamlessly into the site providing even, quality illumination. The 'B' input power designator is a suitable upgrade for HID applications up to 250 Watt, and the 'K' input power designator is a suitable upgrade for HID applications up to 400 Watt.

Applications: Parking lots, walkways, campuses, car dealerships, office complexes, tunnels, underpasses, and internal roadways.

Performance Summary

Utilizes Cree TrueWhite® Technology on 5000K Luminaires

NanoOptic® Precision Delivery Grid™ optic

Assembled in the U.S.A. of U.S. and imported parts

Initial Delivered Lumens: Up to 17,291

Efficacy: Up to 136 LPW

CRB: Minimum 70 CRI (3000K, 4000K & 5700K), 90 CRI (5000K)

CCT: 3000K, 4000K, 5000K, 5700K

Limited Warranty*: 10 years on luminaires; 10 years on Colorfast DeltaGuard® finish; up to 5 years for Synapse® accessories; 1 year on luminaire accessories

*See <http://www.creeled.com/usa/usa> for warranty terms. The Synapse accessories, normal Synapse spec sheets for details on warranty terms.

Ordering Information

Fully assembled luminaire is composed of two components that must be ordered separately.

Example: Mount OSQ-B-AA20V - Luminaire OSQ-A-NA-2HC-S-10R-GL-2P

Mount Luminaire must be ordered separately*

OSQ

OSQ-B-AA

OSQ-B-AA20V

OSQ-B-AA20V

US: usa@henderon.com (800) 234-4800

Canada: canada@henderon.com (800) 473-1234

CREE LIGHTING