FINAL DEVELOPMENT PLAN

LEE'S SUMMIT FLEX SPACE 60 SE THOMPSON DR.

PROJECT TEAM

OWNER: CAPITAL BUILDERS 1507 NE WALL ST. LEE'S SUMMIT, MO. 64086 CONTACT: MATT HENDRICKSON EMAIL: MATT@CAPITALBUILDERSKC.COM TEL: (816) 609-8633

CIVIL ENGINEER: KIMLEY-HORN AND ASSOCIATES, INC. 805 PENNSYLVANIA AVE. SUITE 150, KANSAS CITY, MO 64105 CONTACT: PATRICK JOYCE, P.E. TEL: (785) 550-8994 EMAIL: PATRICK.JOYCE@KIMLEY-HORN.COM

ARCHITECT SIXTWENTYONE 1705 SUMMIT ST. KANSAS CITY, MO 64108 CONTACT: JACOB LITTRELL, RA, LEED AP BD+C TEL: (816) 694-1369

LANDSCAPE: LANDWORKS STUDIO 102 S CHERRY ST. OLATHE, KS 66061 CONTACT: ERICA FLAD, PLA, LEED GA TEL: (913) 780-6707 EMAIL: ERICA@LANDWORKSSTUDIO.COM

EMAIL: JACOB@SIXTWENTYONE.COM

UTILITY AND GOVERNING AGENCY CONTACTS

SANITARY & WATER: CITY OF LEE'S SUMMIT 1200 SE HAMBLEN RD. LEE'S SUMMIT, MO 64081 TEL: (816) 969-1900

MICHAEL PARK

EVERGY:

DOUG DAVIN

220 SE GREEN ST.

TEL: (8160 969-1800

1300 SE HAMBLEN RD.

TEL: (816) 347-4320

LEE'S SUMMIT, MO 64081

LEE'S SUMMIT, MO 64063

220 SE GREEN ST. LEE'S SUMMIT, MISSOURI 64063 TEL: (816) 969-1800 STREETS: CITY OF LEE'S SUMMIT **RONALD GIPFERT**

> KANSAS CITY, MO 64106 TEL: (816) 275-1550 MISSOURI GAS ENERGY: RICHARD FROCK

3025 SW CLOVER DR.

TEL: (816) 472-3489

LEE'S SUMMIT, MO 64082

STORMWATER:

CITY OF LEE'S SUMMIT

PUBLIC WORKS

500 E 8TH ST.

CITY OF LEE'S SUMMIT, JACKSON COUNTY, MISSOURI NW $\frac{1}{4}$, SECTION S17, TOWNSHIP 47N, RANGE 31W **GENERAL NOTES:**

1. THE CONSTRUCTION COVERED BY THESE PLANS SHALL CONFORM TO ALL APPLICABLE STANDARDS AND SPECIFICATIONS OF THE PUBLIC WORKS DEPARTMENT OF THE CITY OF LEE'S SUMMIT, MISSOURI, IN ALL USAGE AND ALL SUPPLEMENTS THERE TO.

2. CONTRACTOR IS RESPONSIBLE FOR ALL PERMITS, BONDS, AND INSURANCE REQUIRED BY THE CITY

5. THE UTILITY LOCATIONS SHOWN ON THESE PLANS ARE TAKEN FROM UTILITY COMPANY RECORDS AND ARE APPROXIMATE ONLY. THEY DO NOT CONSTITUTE ACTUAL FIELD LOCATIONS. THE CONTRACTOR SHALL VERIFY THE LOCATION AND DEPTH OF ALL UTILITIES PRIOR TO CONSTRUCTION.

6. THE DEVELOPER/OWNER SHALL CONTROL EROSION AND SILTATION DURING ALL PHASES OF CONSTRUCTION, AND SHALL KEEP THE STREETS CLEAN OF MUD AND DEBRIS

7. ALL EXCESS MATERIAL SHALL BE REMOVED LEGALLY FROM SITE AND DISPOSED OF OFF SITE

8. TRAFFIC CONTROL AND MAINTENANCE OF TRAFFIC DURING CONSTRUCTION SHALL BE THE RESPONSIBILITY OF THE CONTRACTOR AND SHALL BE IN ACCORDANCE WITH THE REQUIREMENTS OF THE PUBLIC WORKS DEPARTMENT AND MUTCD.

CONTRACTOR'S EXPENSE.

10. ANY EXISTING OR NEW STORM SEWER INLETS IN USE DURING DEMOLITION, GRADING OR CONSTRUCTION SHALL HAVE INLET PROTECTION AS SPECIFIED

HISTORIC INFORMATION

THIS STRUCTURE IS NOT LISTED IN THE NATIONAL REGISTER OF HISTORIC PLACES.

THIS SITE IS NOT LOCATED IN A LOCAL HISTORIC DISTRICT PER THE MISSOURI DEPARTMENT OF NATURAL RESOURCES HISTORIC DISTRICTS AND SITES DATABASE, ACCESSED JUNE 27, 2023.

FEMA INFORMATION

THIS SITE IS LOCATED WITHIN ZONE X PER FEMA FIRM MAPS 29095C0438G: EFFECTIVE DATE JANUARY 20, 2017. NO LETTERS OF MAP AMENDMENT OR REVISION ARE BEING PROPOSED.

LEGAL DESCRIPTION

LOT 3A, DECKER STREET MINOR PLAT, LOTS 2A AND 3A, A SUBDIVISION IN LEE'S SUMMIT, JACKSON COUNTY, MISSOURI, ACCORDING TO THE PLAT RECORDED AUGUST 6, 2021.

WATERSHED

THIS SITE IS LOCATED WITHIN THE BIG CREEK WATERSHED

PROJECT SPECIFICATIONS

THE SPECIFICATIONS FOR THIS PROJECT SHALL BE THE FOLLOWING: THE CITY OF LEE'S SUMMIT, MISSOURI

KANSAS CITY METRO APWA

THE STANDARD SPECIFICATIONS THROUGH AND INCLUDING THE LATEST AMENDMENTS SHALL BE PART OF THESE PROJECT DRAWINGS AND SPECIFICATION AND ARE INCORPORATED HEREIN BY REFERENCE. THE MORE STRINGENT OF THESE STANDARD SPECIFICATIONS AND THOSE PREPARED BY THE ENGINEERING PREPARING THESE PLANS SHALL GOVERN.

OIL AND GAS WELL NOTES

NO ABANDONED OIL OR GAS WELLS HAVE BEEN IDENTIFIED WITHIN THE PROPERTY LIMITS OF THE PROPOSED CONSTRUCITON ACTIVITIES, PER THE MISSOURI DEPARTMENT OF NATURAL RESOURCES (MDNR) PERMITTED OIL AND GAS DATABASE, ACCESSED JUNE 27, 2023.

APPROXIMATE TOTAL ACREAGE: 2.13 AC LIMITS OF DISTURBANCE: 1.81 AC



	Sheet List Table
Sheet Number	Sheet Title
C001	COVER SHEET
C002	EXISTING CONDITIONS
C003	SITE PLAN
C004	GRADING PLAN
C005	ADA RAMPS
C006	UTILITY & STORMWATER PLAN
C007	STORMWATER PLAN & PROFILE
C008	STORMWATER PLAN & PROFILE
C009	DETAILS
C010	DETAILS
C011	DETAILS
C012	DETAILS
C013	ADS DETAILS
L001	LANDSCAPE PLAN
A101	FLOOR PLANS
A201	ELEVATIONS - BUILDING A
A202	ELEVATIONS - BUILDING B
M101	MECHANICAL FLOOR PLANS
E001	SITE PHOTOMETRICS

Horn


ORIGINAL ISSUE: 2/22/2024

KHA PROJECT NO.

268442000


SHEET NUMBER


C001

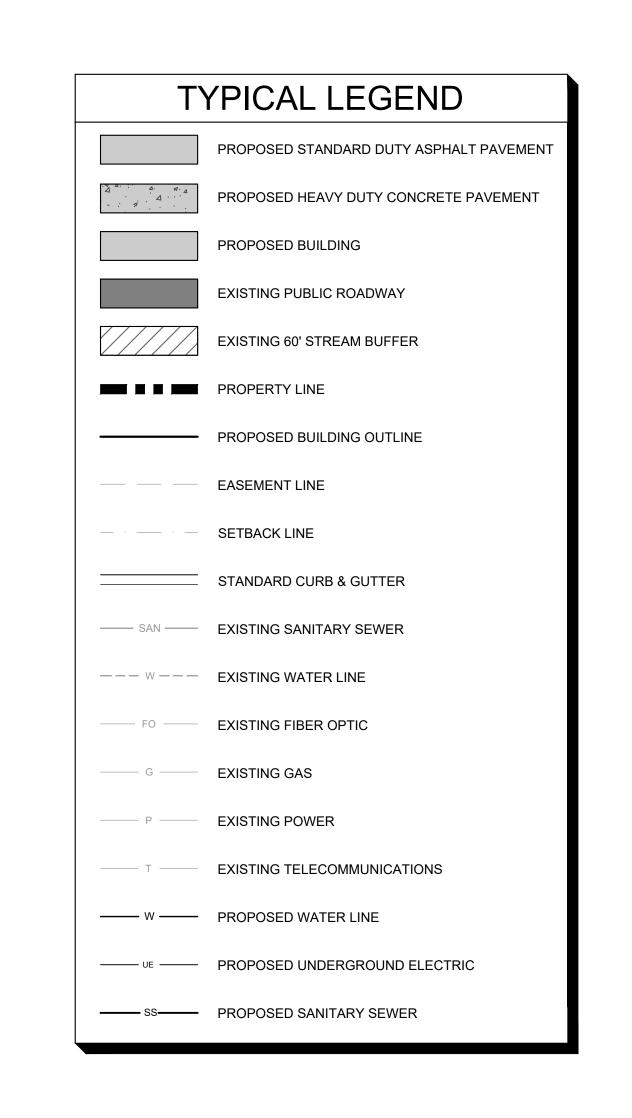





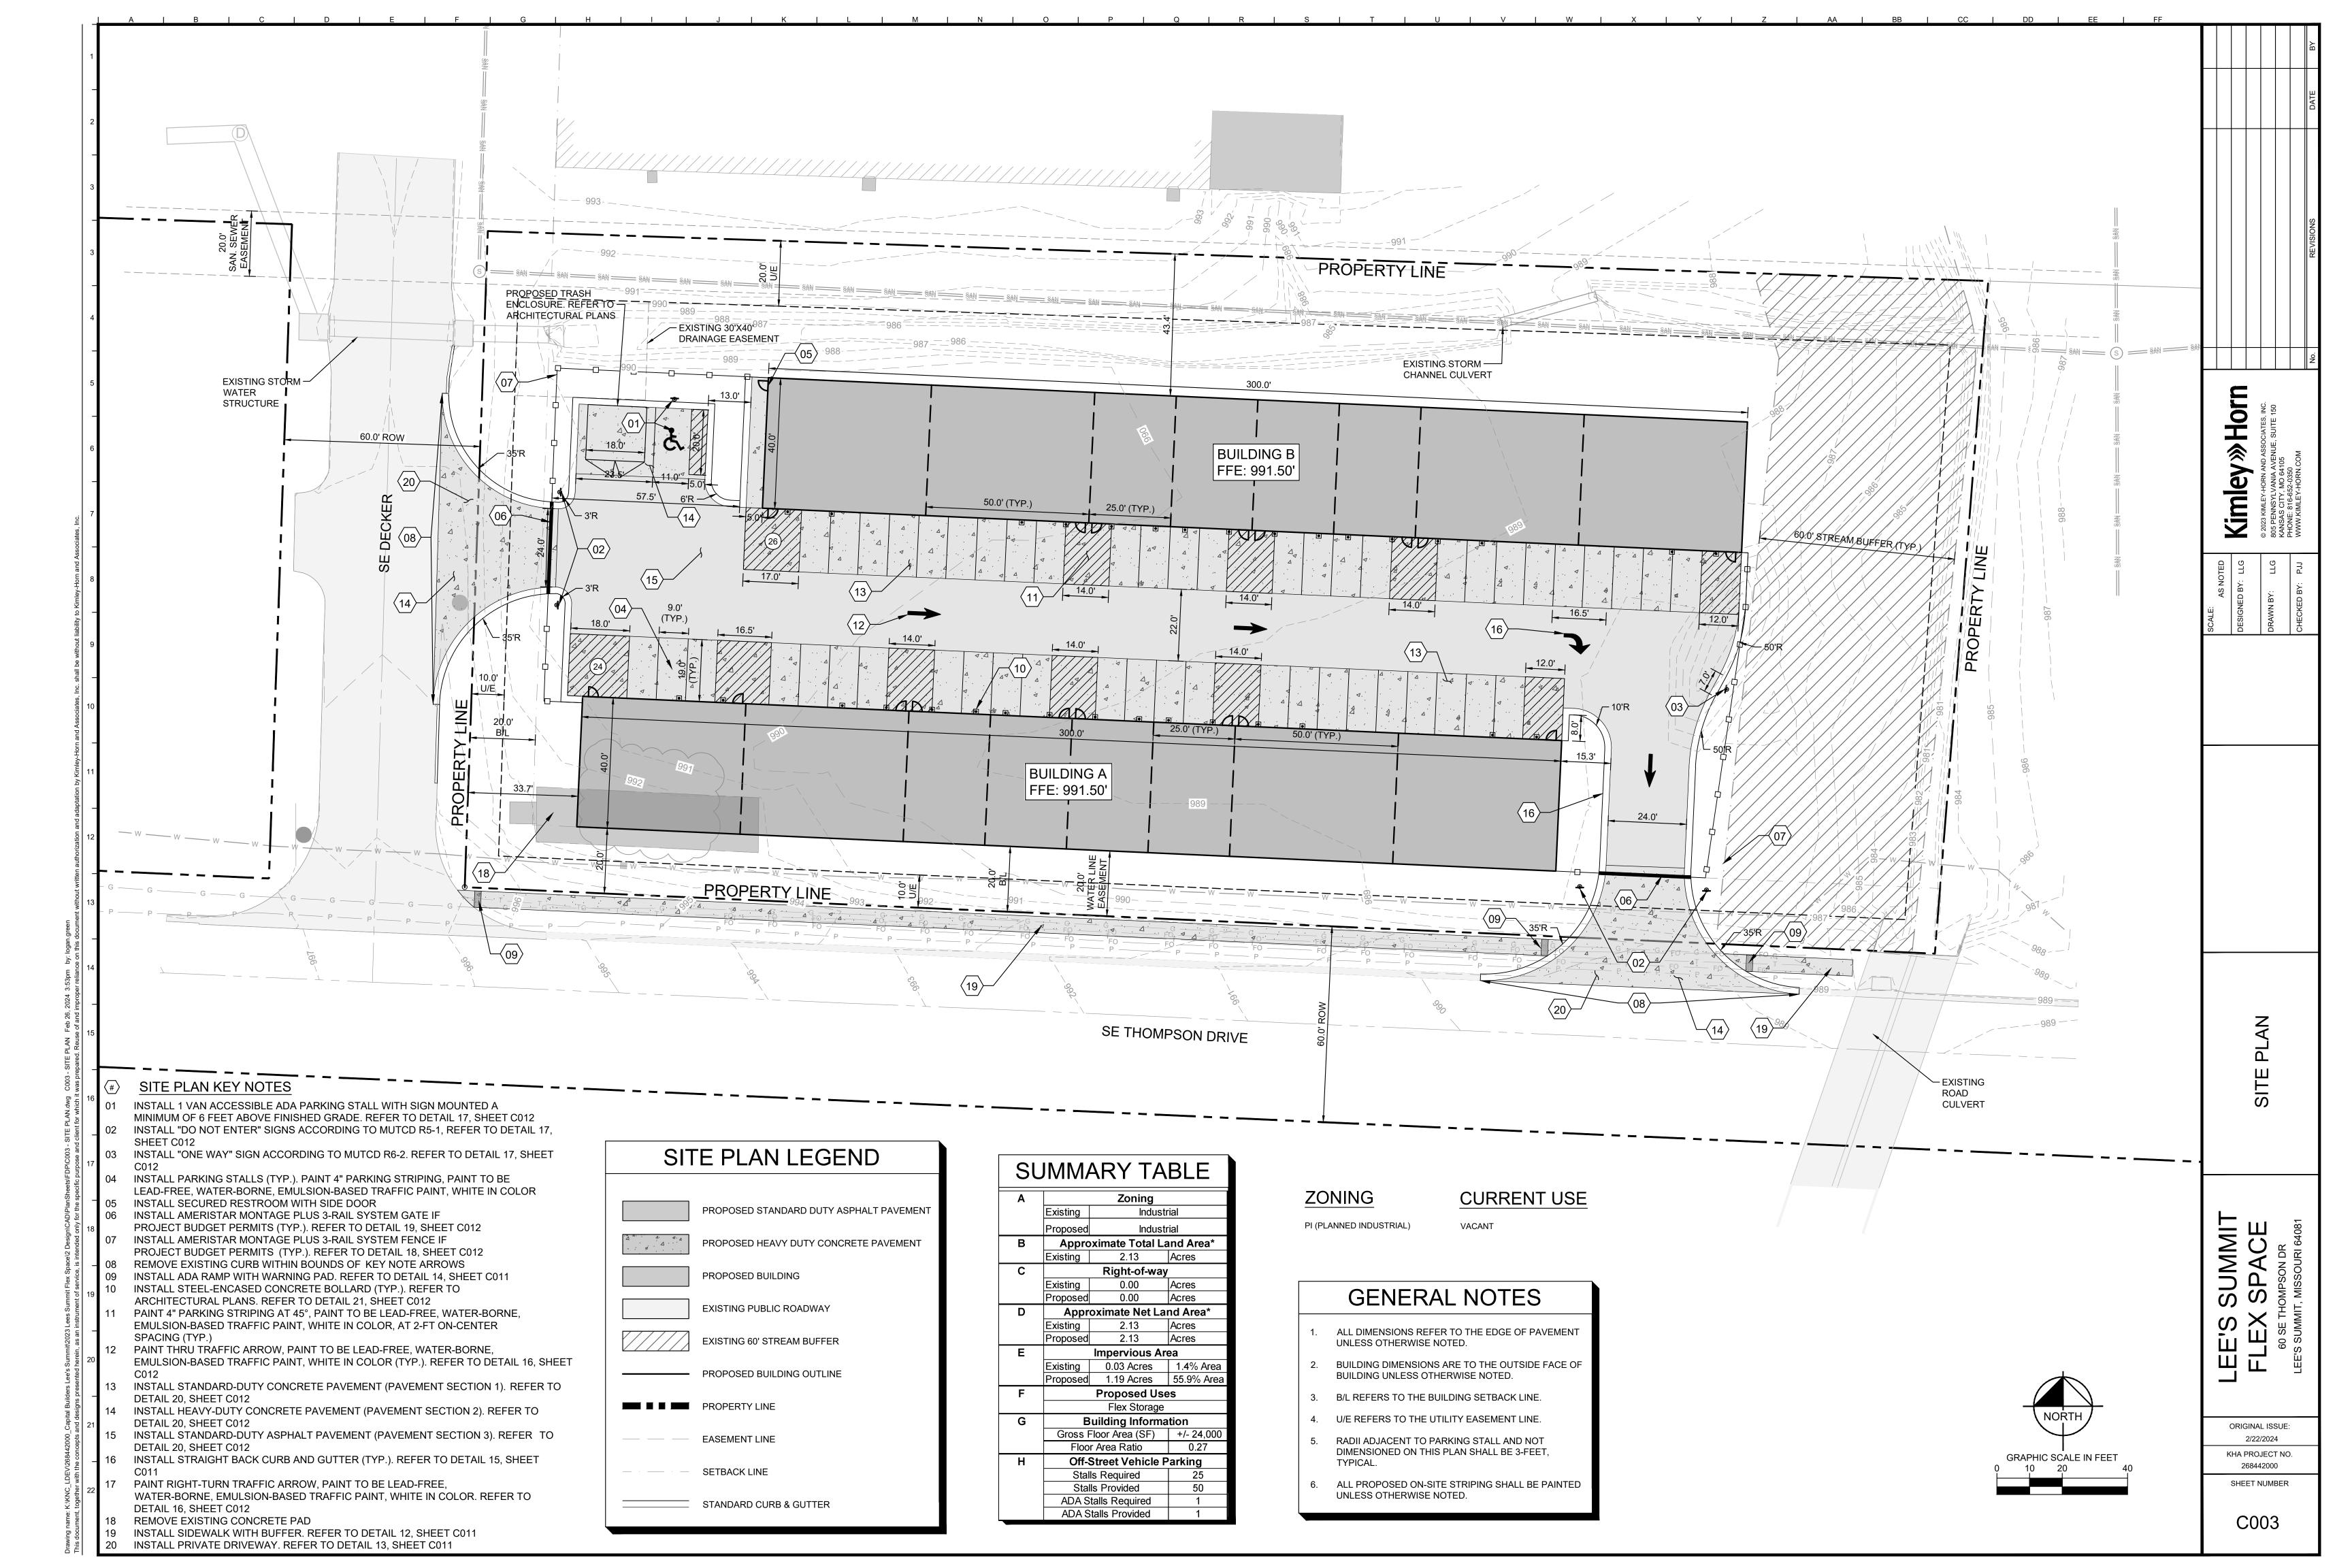

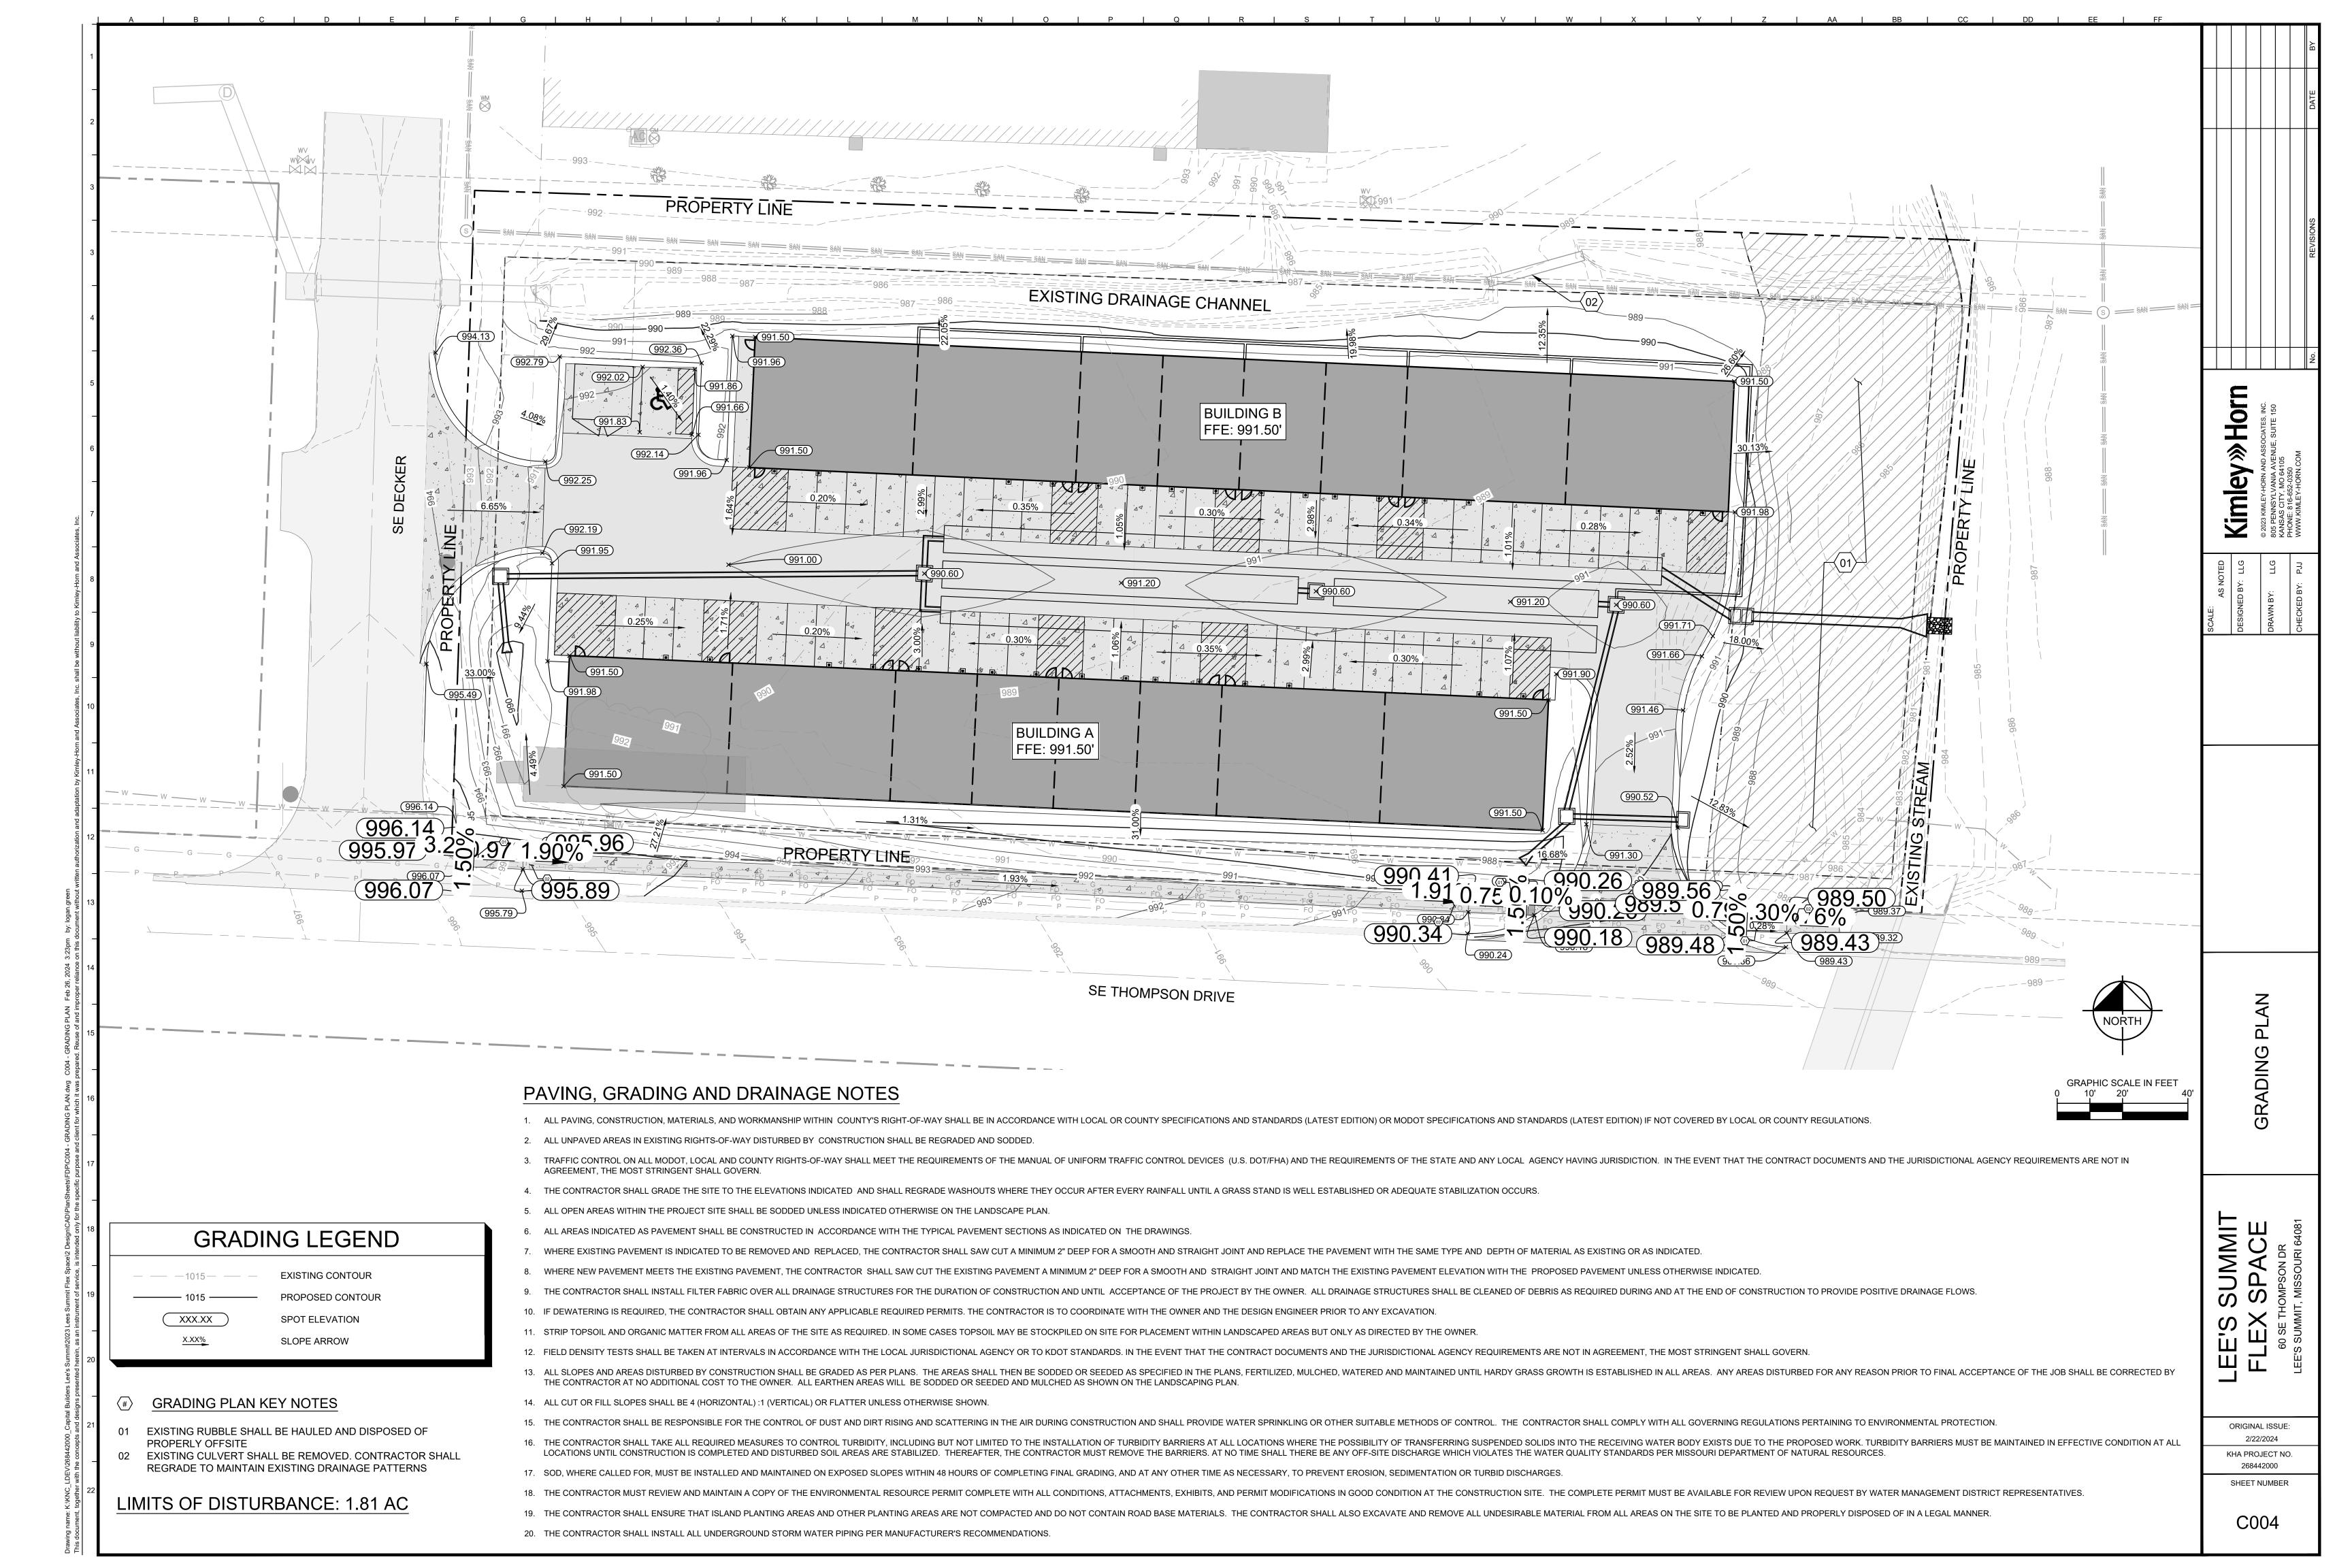

ADA RAMP 1 ADA RAMP 2 ADA WARNING PAD-990.41 996.14 990.26 ADA WARNING PAD -995.961.91% 995.97 0.10% 0.75% 0.97% 1.90% 990.26 SIDEWALK-TRANSITION ZONE (02) -SIDEWALK TRANSITION ZONE 990.34 990.18 996.07 995.89 ADA RAMP -ADA RAMP ADA RAMP 3


Kimley » Horn

ORIGINAL ISSUE:

2/22/2024 KHA PROJECT NO.


268442000 SHEET NUMBER


C005

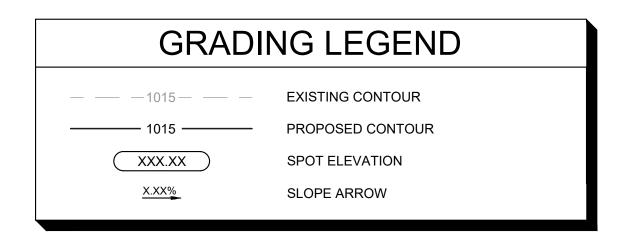


GRADING PLAN KEY NOTES

01 INSTALL ADA SIDEWALK RAMP WITH WARNING PAD. REFER TO DETAIL 14, SHEET C011 02 INSTALL SIDEWALK WITH BUFFER. REFER TO DETAIL 12, SHEET C011

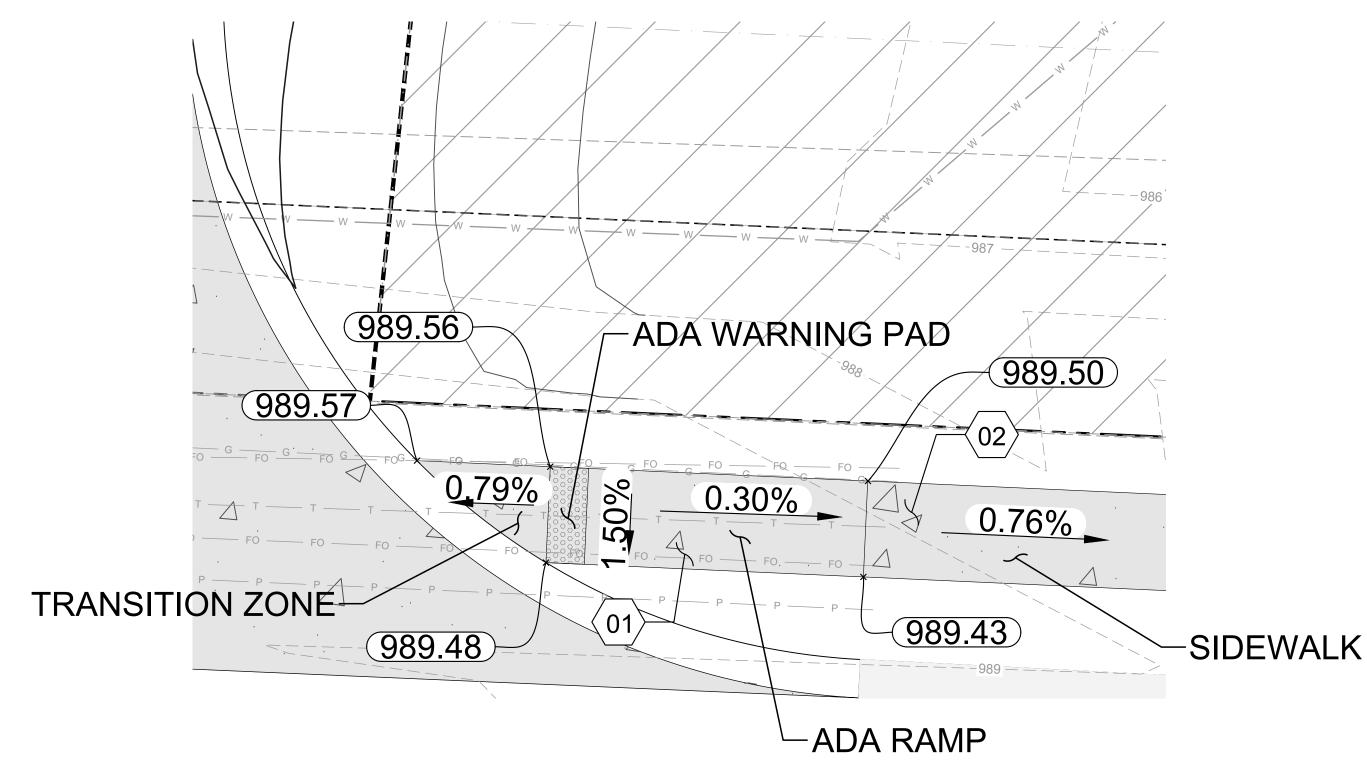

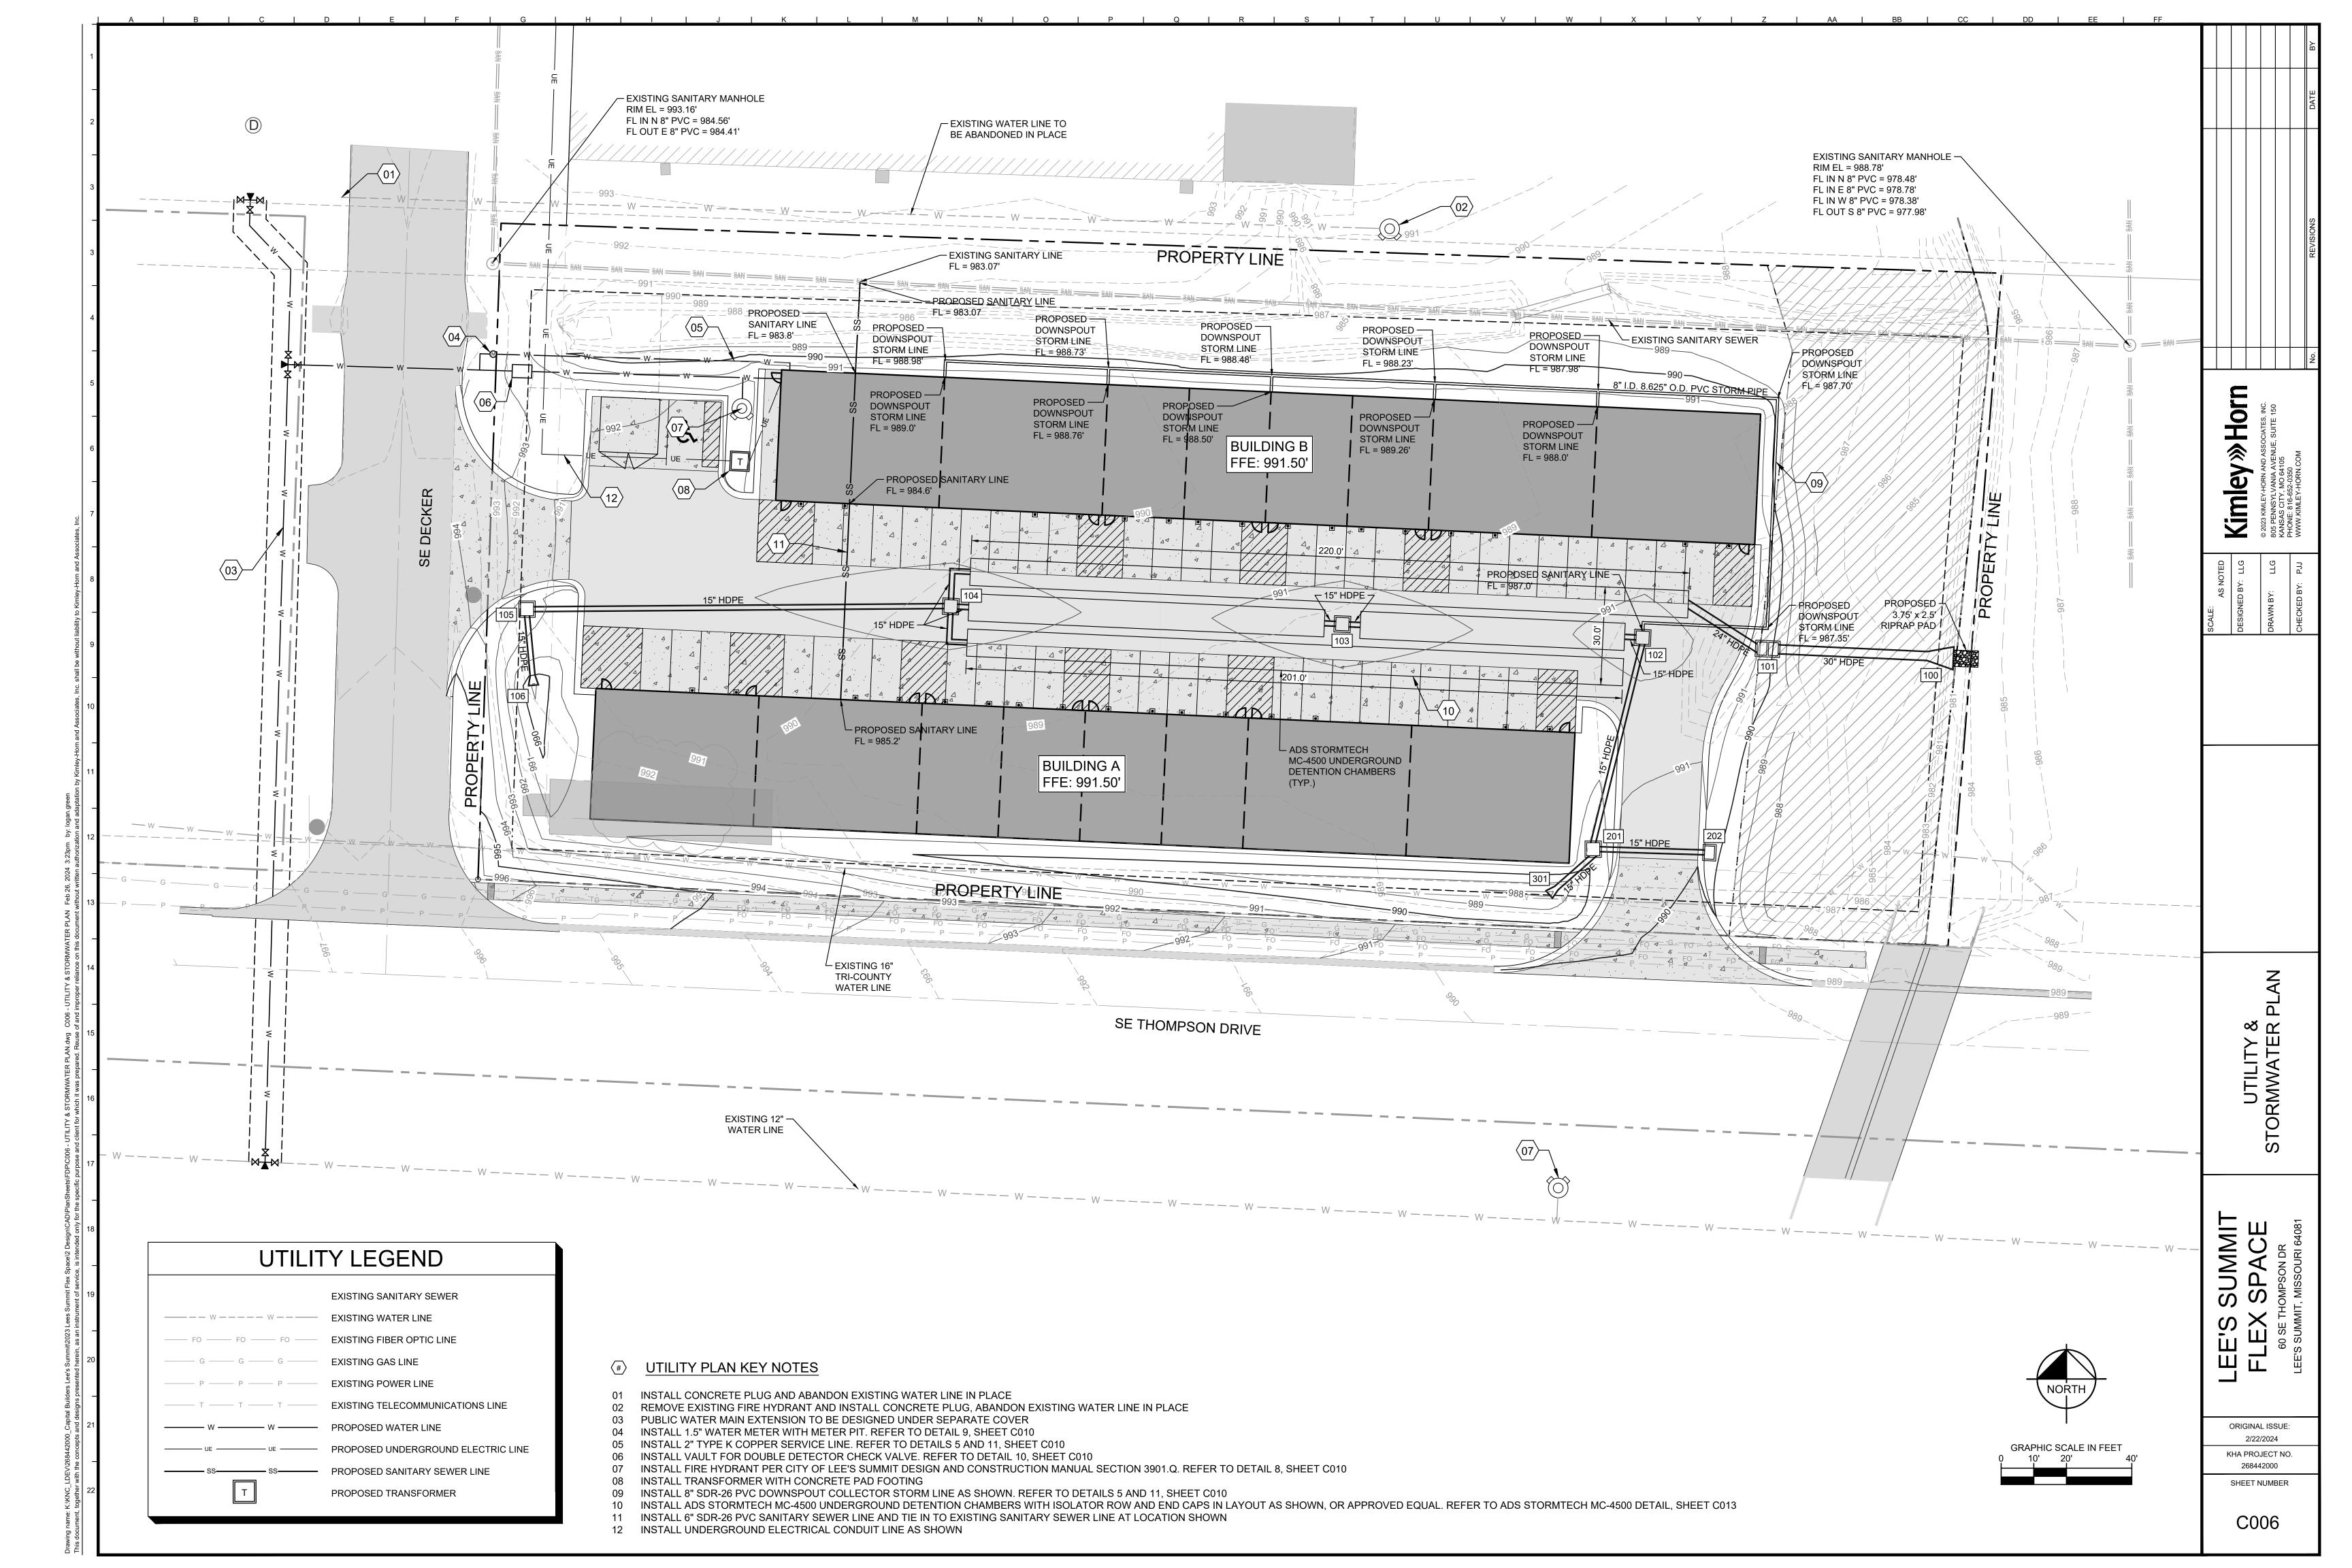

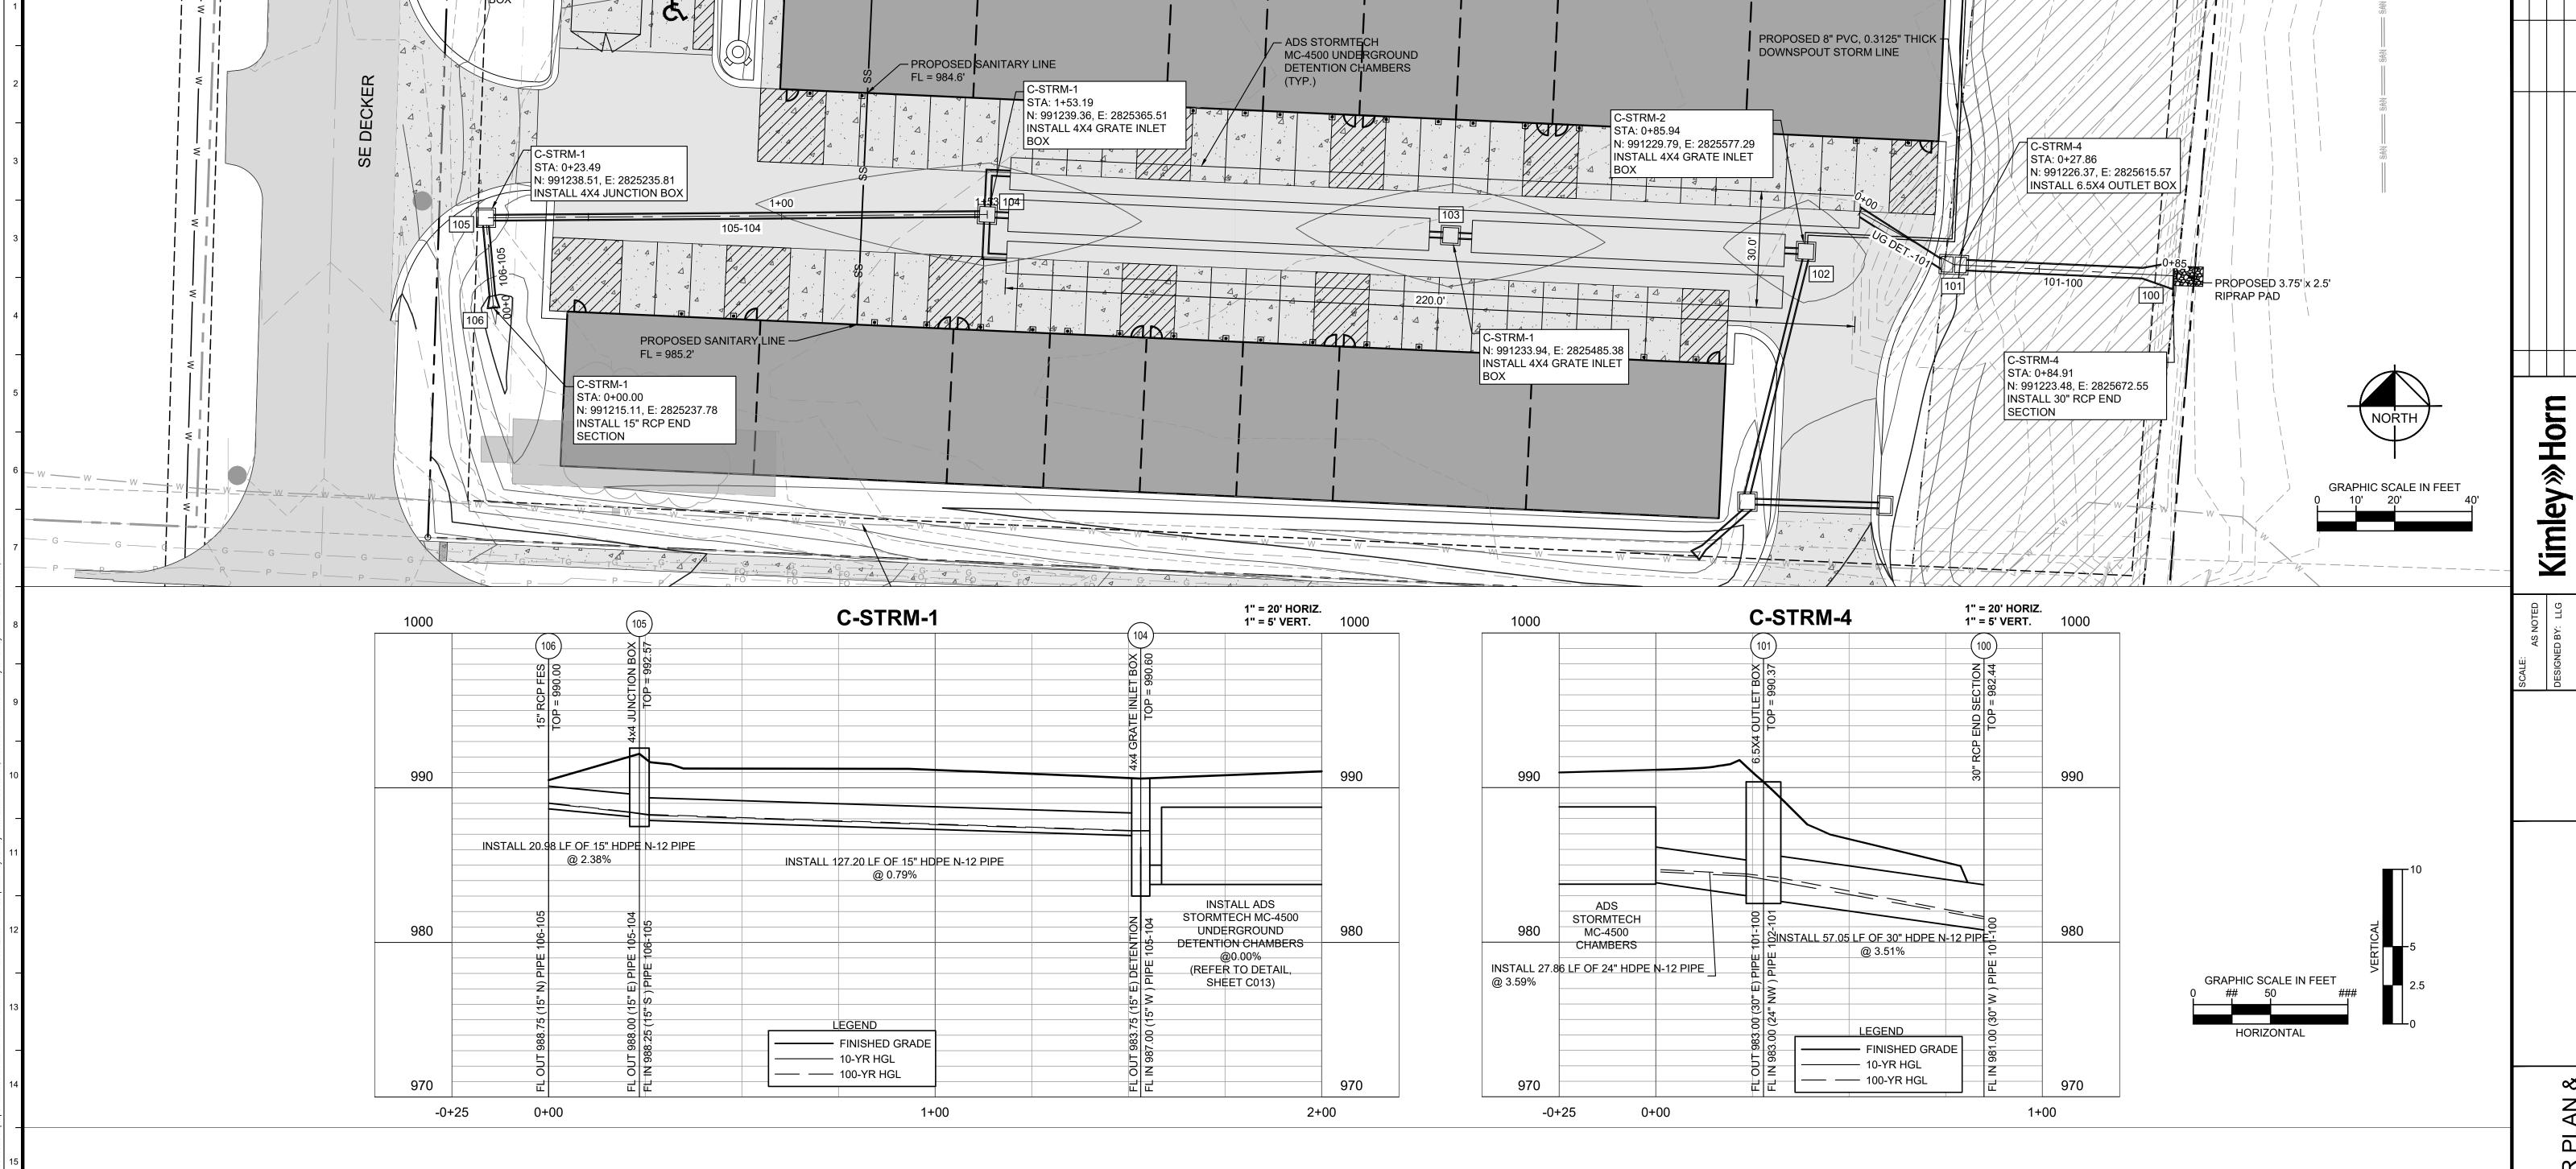

PIPE SIZING CALCULATIONS - 10-YEAR EVENT

BACKFLOW

LineNo.	InletID	RunoffCoeff	DrainageArea	IncrCxA	InletTime	TotalArea	TotalCxA	Тс	iInlet	iSys	IncrQ	FlowRate	LineID	InvertUp	InvertDn	LineLength	LineSlope	LineSize	n-valuePipe	User StaDn	CapacityFull	VelAve	HGLUp	HGLDn
		(C)	(ac)		(min)	(ac)		(min)	(in/hr)	(in/hr)	(cfs)	(cfs)		(ft)	(ft)	(ft)	(%)	(in)		(ft)	(cfs)	(ft/s)	(ft)	(ft)
1	105	0.00	0.00	0	0.0	0.07	0.05	6.1	0.00	6.92	0.00	0.36	PIPE 105-104	988.00	987.00	127.201	0.79	15	0.012	25.99	6.20	2.52	988.23	987.21
2	106	0.75	0.07	0.05	5.0	0.07	0.05	5.0	7.24	7.24	0.38	0.38	PIPE 106-105	988.75	988.25	20.981	2.38	15	0.012	0.00	10.80	3.22	988.99	988.41
3	201	0.00	0.00	0	0.0	0.30	0.27	7.5	0.00	6.59	0.00	1.79	PIPE 201-102	984.94	983.67	63.923	1.99	15	0.012	22.02	9.86	4.85	985.47	984.03
4	301	0.90	0.26	0.23	5.0	0.26	0.23	5.0	7.24	7.24	1.69	1.69	PIPE 301-201	986.62	986.43	19.454	0.98	15	0.012	0.00	6.91	4.10	987.14	986.85
5	202	0.95	0.04	0.04	5.0	0.04	0.04	5.0	7.24	7.24	0.28	0.28	PIPE 202-201	985.00	984.73	33.104	0.82	15	0.012	0.00	6.32	1.25	985.20	985.47
6	101	0.00	0.00	0	0.0	0.82	0.78	5.2	0.00	7.17	1.62	7.57	PIPE 101-100	983.00	981.00	57.000	3.51	30	0.012	0.00	83.22	7.60	983.91	981.51
7	UG DET.	0.95	0.82	0.78	5.0	0.82	0.78	5.0	7.24	7.24	6.01	6.01	PIPE 102-101	983.67	983.50	27.863	0.61	24	0.012	0.00	19.14	5.00	984.54	984.27

PROPOSED SANITARY LINE

FL = 983.8'

PIPE SIZING CALCULATIONS - 100-YEAR EVENT

20	LineNo.	InletID	RunoffCoeff	DrainageArea	IncrCxA	InletTime	TotalArea	TotalCxA	Тс	iInlet	iSys	IncrQ	FlowRate	LineID	InvertUp	InvertDn	LineLength	LineSlope	LineSize	n-valuePipe	User StaDn	CapacityFull	VelAve	HGLUp	HGLDn
			(C)	(ac)		(min)	(ac)		(min)	(in/hr)	(in/hr)	(cfs)	(cfs)		(ft)	(ft)	(ft)	(%)	(in)		(ft)	(cfs)	(ft/s)	(ft)	(ft)
1	1	105	0.00	0.00	0	0.0	0.07	0.05	5.8	0.00	9.55	0.00	0.50	PIPE 105-104	988.00	987.00	127.201	0.79	15	0.012	25.99	6.20	2.77	988.28	987.24
21	2	106	0.75	0.07	0.05	5.0	0.07	0.05	5.0	9.83	9.83	0.52	0.52	PIPE 106-105	988.75	988.25	20.981	2.38	15	0.012	0.00	10.80	3.52	989.03	988.44
	3	201	0.00	0.00	0	0.0	0.30	0.27	6.8	0.00	9.24	0.00	2.51	PIPE 201-102	984.94	983.67	63.923	1.99	15	0.012	22.02	9.86	5.37	985.57	984.10
4	4	301	0.90	0.26	0.23	5.0	0.26	0.23	5.0	9.83	9.83	2.30	2.30	PIPE 301-201	986.62	986.43	19.454	0.98	15	0.012	0.00	6.91	4.48	987.23	986.93
	5	202	0.95	0.04	0.04	5.0	0.04	0.04	5.0	9.83	9.83	0.37	0.37	PIPE 202-201	985.00	984.73	33.104	0.82	15	0.012	0.00	6.32	1.37	985.24	985.57
22	6	101	0.00	0.00	0	0.0	0.82	0.78	5.2	0.00	9.77	4.28	12.39	PIPE 101-100	983.00	981.00	57.051	3.51	30	0.012	0.00	83.19	8.79	984.18	981.65
	7	UG DET.	0.95	0.82	0.78	5.0	0.82	0.78	5.0	9.83	9.83	8.16	8.16	PIPE 102-101	983.67	983.50	27.863	0.61	24	0.012	0.00	19.14	5.47	984.69	984.41

STORM SEWER CONSTRUCTION NOTES

- 1. PIPE LENGTHS SHOWN ARE MEASURED FROM CENTER OF STRUCTURE TO CENTER OF STRUCTURE OR TO THE END OF END SECTION. ALL PIPES SHALL BE FIELD STAKED TO THE
- INSIDE WALL FACE OF THE STRUCTURE. 2. ALL PIPE SHALL BE PLACED IN TRENCH CONDITIONS. PLACE A MINIMUM OF 2 FEET OF FILL OVER PROPOSED PIPE BEFORE TRENCHING AND PIPE INSTALLATION. PROPOSED FILL SHALL BE PLACED IN ACCORDANCE WITH PROJECT REQUIREMENTS.
- 3. UTILITY LINES AND STRUCTURES IN FILL AREAS BELOW PIPE GRADE SHALL NOT BE CONSTRUCTED UNTIL ALL CONSOLIDATION OF THE FILL IS COMPLETE AND SO APPROVED BUY THE ON-SITE GEOTECHNICAL ENGINEER.
- 4. THE DIMENSIONS FOR ALL STRUCTURES ARE FROM INSIDE FACE OF STRUCTURE TO
- INSIDE FACE OF STRUCTURE. 5. STORM SEWER PIPE SHALL BE AS FOLLOWS UNLESS OTHERWISE NOTED:
- A) REINFORCED CONCRETE PIPE (RCP), CLASS III PER ASTM C-76, WITH "O-RING" OR SINGLE OFFSET RUBBER GASKETED JOINT (TYLOX SUPERSEAL OR AN APPROVED EQUAL). 6. ALL REINFORCING STEEL SHALL COMPLY WITH ASTM-615 GRADE 60.
- 7. ALL CURB INLETS AND OTHER STRUCTURES SET AT LOW POINTS ARE TO BE SET LEVEL. ALL OTHER CURB INLETS ARE TO BE SET WITH THE GRADE OF THE TOP OF CURB OR
- 8. ALL HYDRAULIC GRADE LINES (HGL) SHOWN ARE FOR THE 10 AND 100-YEAR STORM. 9. PRECAST STRUCTURES MAY BE USED AT CONTRACTOR'S OPTION. ALL STORM STRUCTURES SHALL HAVE A SMOOTH UNIFORM POURED CONCRETE INVERT FROM
- INVERT IN TO INVERT OUT. 10. THE LIDS OF ALL PRECAST STRUCTURES SHALL BE GROUTED TO THE TOP OF THE WALLS. 11. NORTHING AND EASTINGS SHOWN ARE TO CENTER OF STRUCTURE, OR END OF END
- 12. THE FIRST DIMENSION SHOWN IS THE "L" DIMENSION AND THE SECOND IS THE "W"
- DIMENSION, SEE DETAILS. 13. ALL HDPE PIPE SHALL BE IN ADS N-12, OR APPROVED EQUAL, MEETING AASHTO M294, TYPE S OR ASTM F2306. THE PIPE SHALL HAVE A SMOOTH INTERIOR AND ANNULAR EXTERIOR CORRUGATIONS. PIPE JOINTS SHALL BE JOINED USING A BELL & SPIGOT JOINT MEETING AASHTO M252, AASHTO M294, OR ASTM F2306. THE JOINT SHALL BE WATERTIGHT, ACCORDING TO THE REQUIREMENTS OF ASTM D 3212, AND GASKETS SHALL

MEET THE REQUIREMENTS OF ASTM F477. GASKETS SHALL BE INSTALLED BY THE PIPE

MANUFACTURER AND COVERED WITH A REMOVABLE WRAP TO ENSURE THE GASKET IS

FREE FROM DEBRIS. A JOINT LUBRICANT SUPPLIED BUY THE MANUFACTURER SHALL BE

USED ON THE GASKET AND BELL DURING ASSEMBLY. 14. FITTINGS FOR PLASTIC PIPE SHALL CONFORM TO AASHTO M252, AASHTO M294, OR ASTM F2306. ALL TEES SHALL BE DUAL WALL REDUCING TEES CONSISTENT WITH THE ADS N-12 PIPE WATERTIGHT CONNECTIONS.

╘	Ш
M	AC
S	SP
Щ. S	LEX
	11


TORMWATER I


≫Horn


ORIGINAL ISSUE: 2/22/2024 KHA PROJECT NO. 268442000


C007

SHEET NUMBER

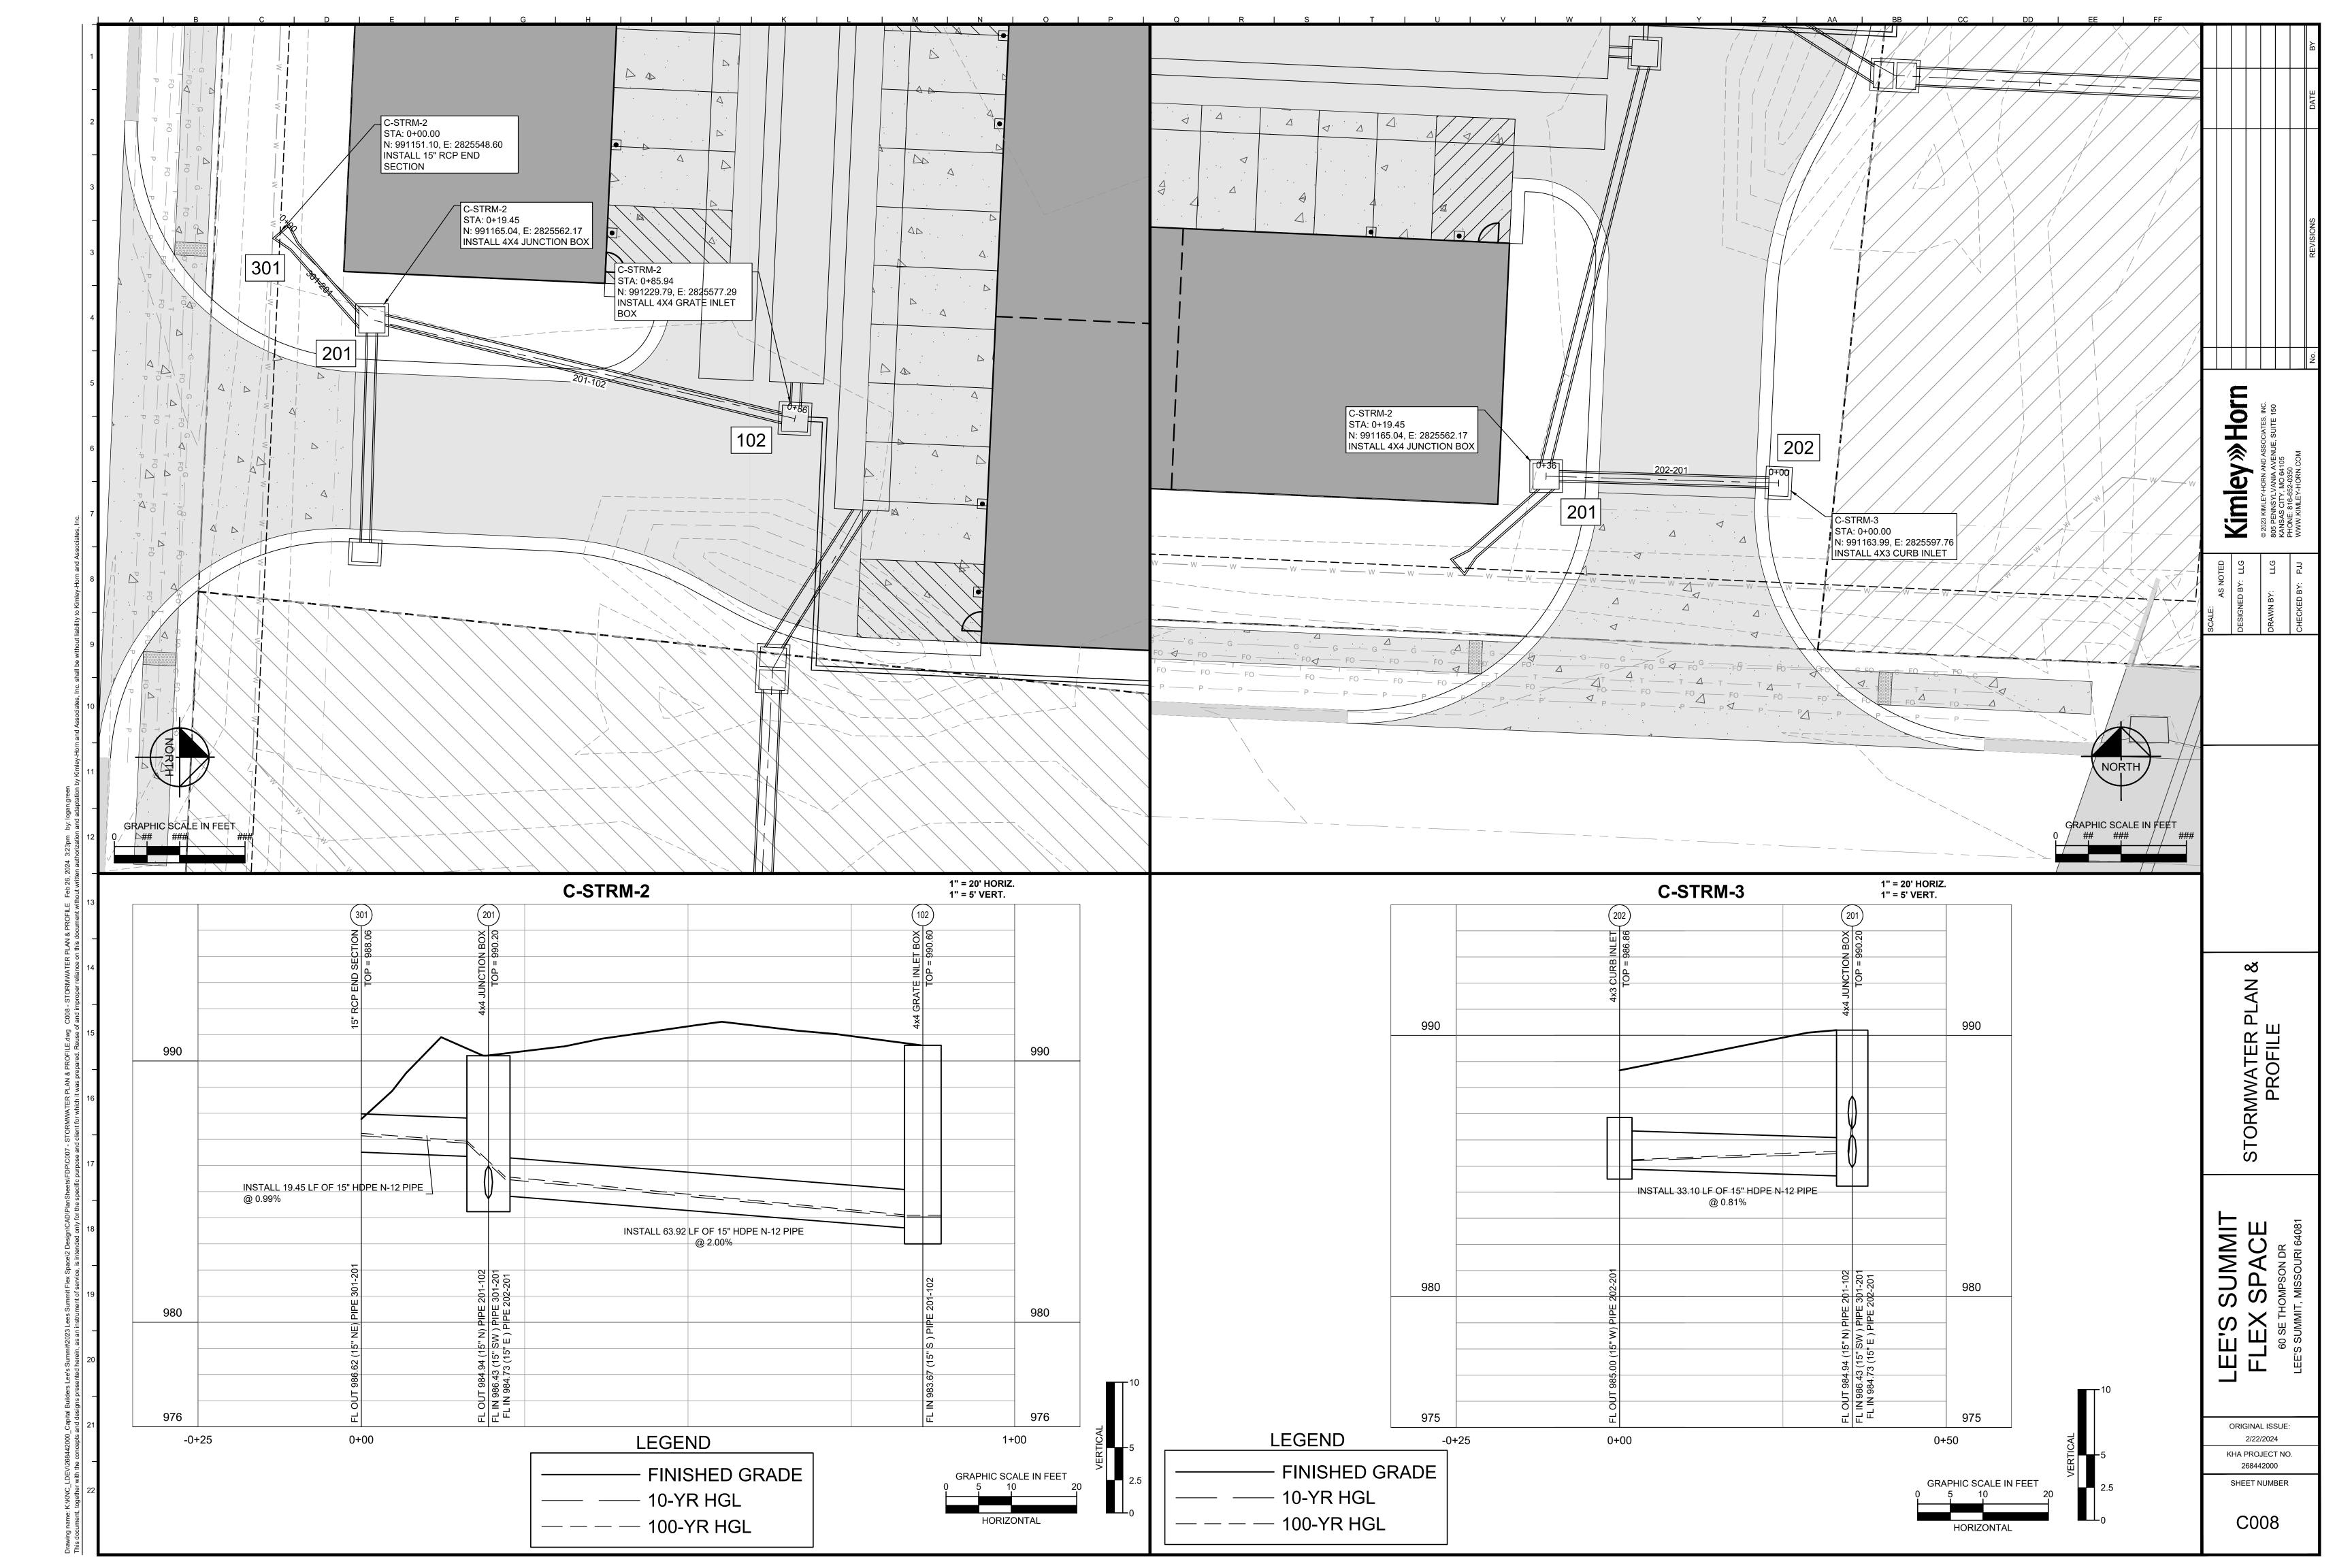

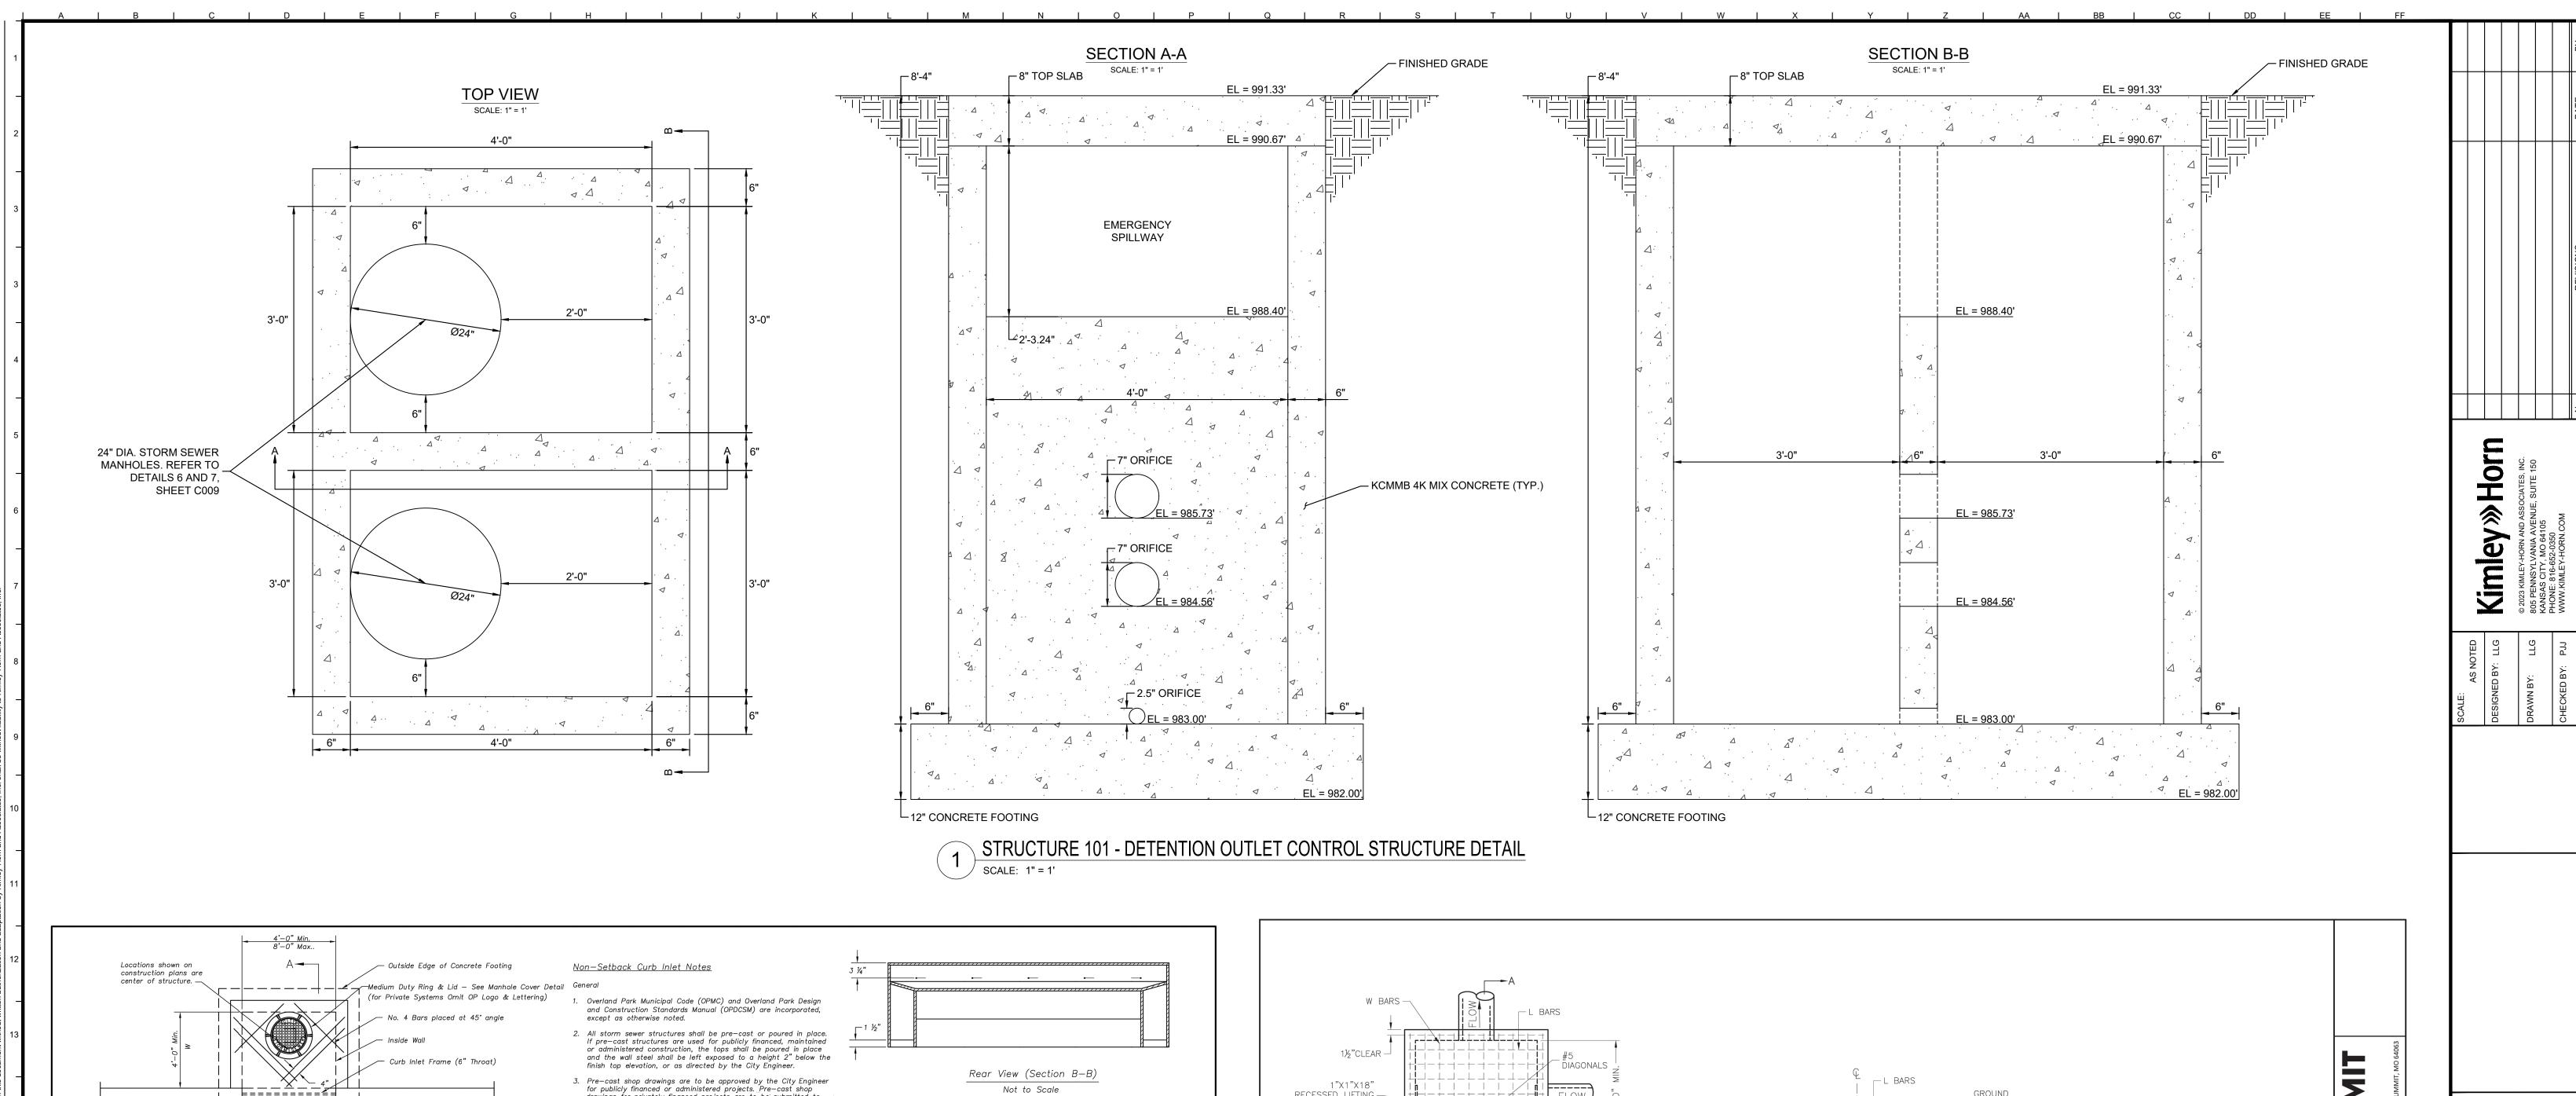

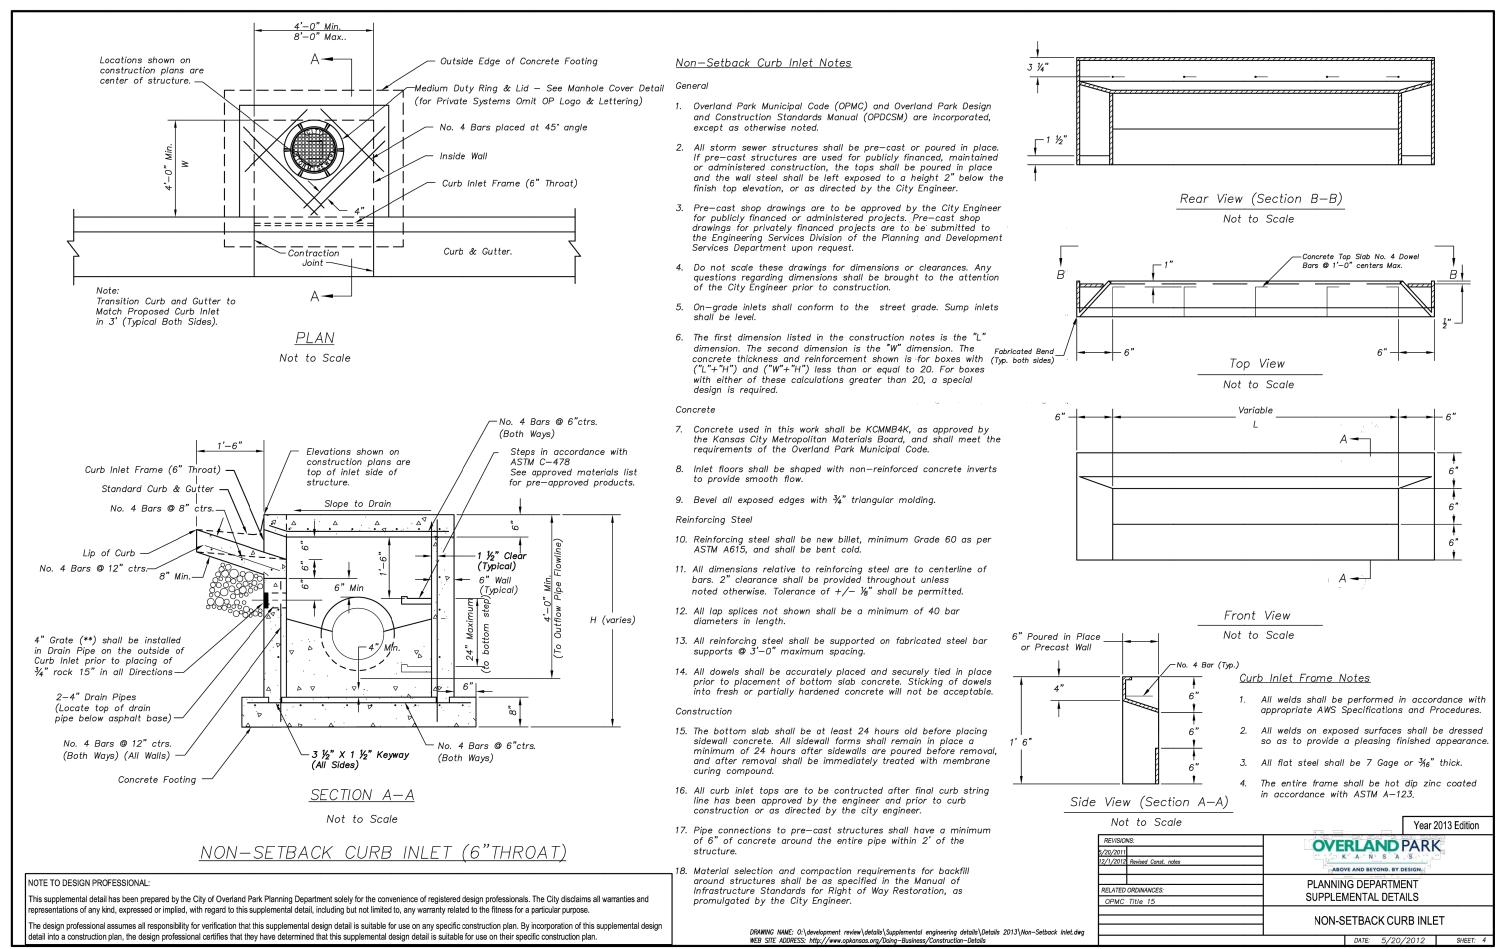

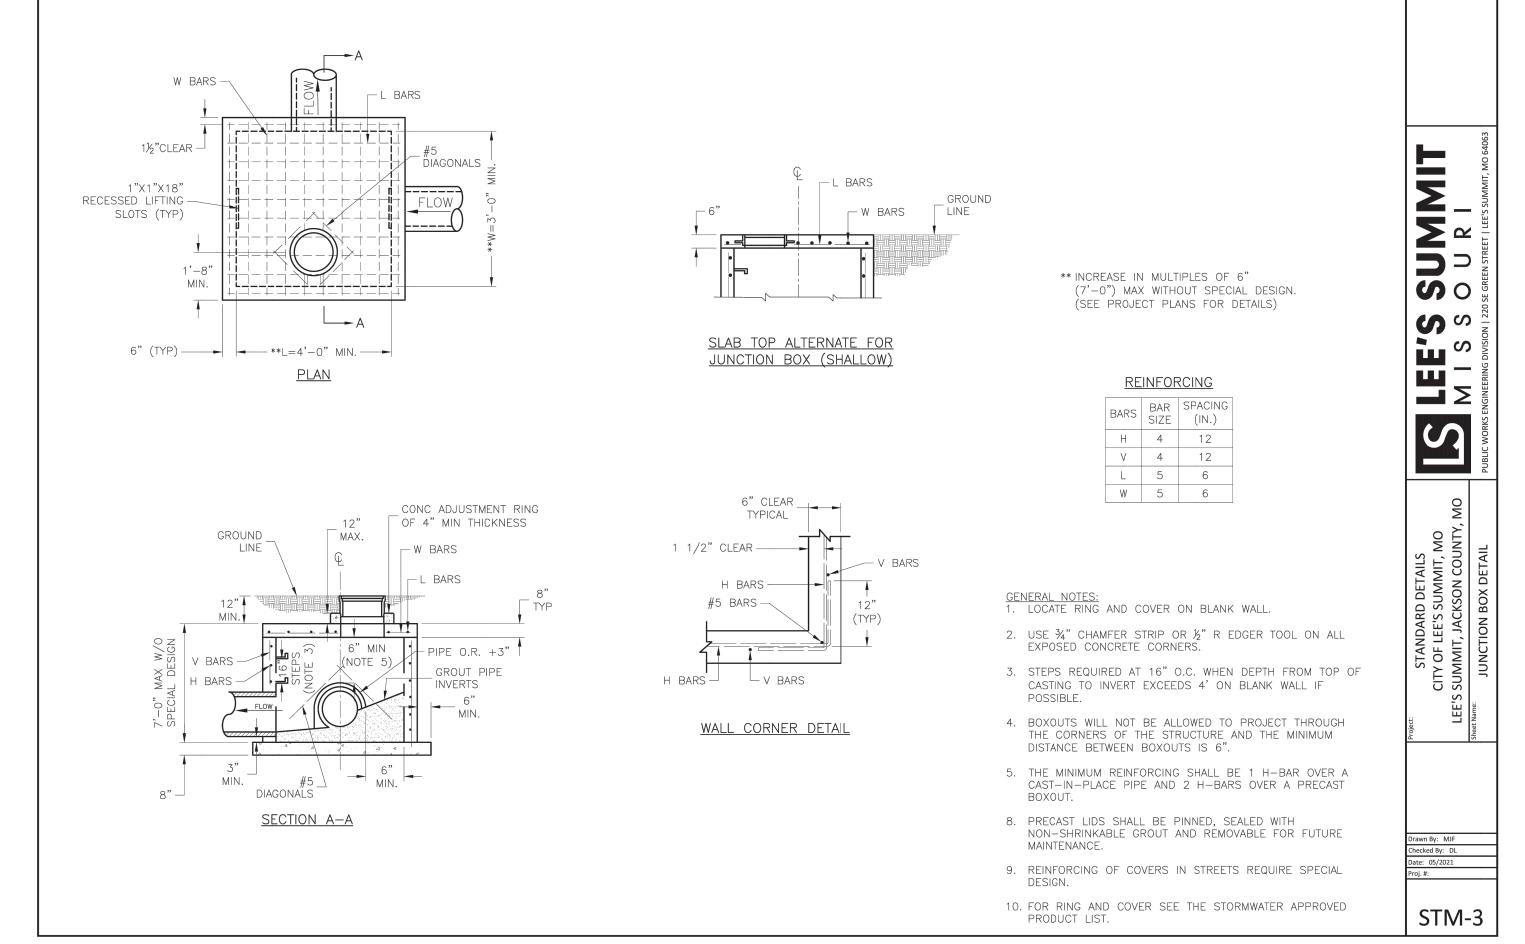

3 JUNCTION BOX DETAIL SCALE: NOT TO SCALE


ORIGINAL ISSUE:
2/22/2024


KHA PROJECT NO.
268442000


SHEET NUMBER

2 NON-SETBACK CURB INLET DETAIL
SCALE: NOT TO SCALE

C009

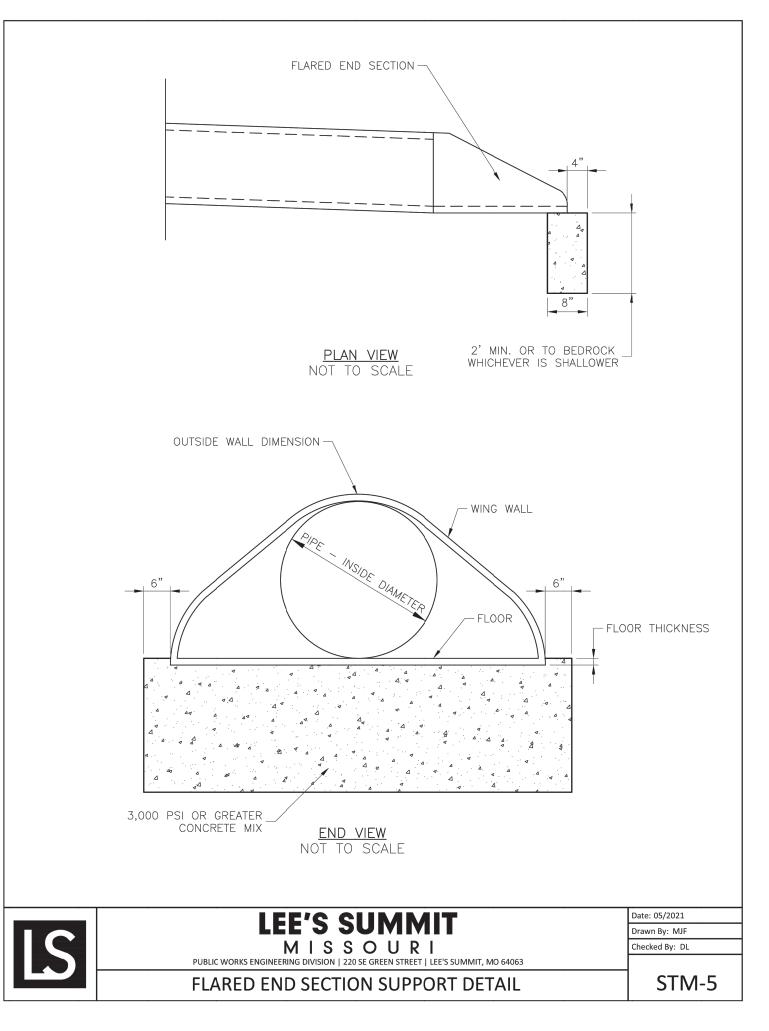


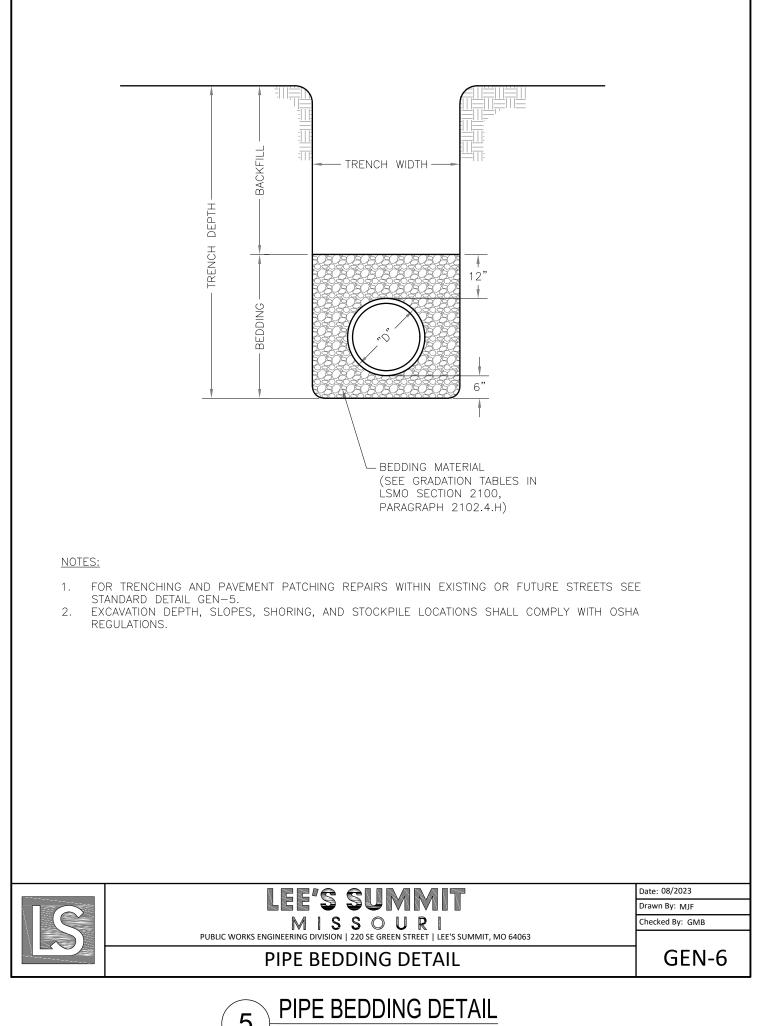

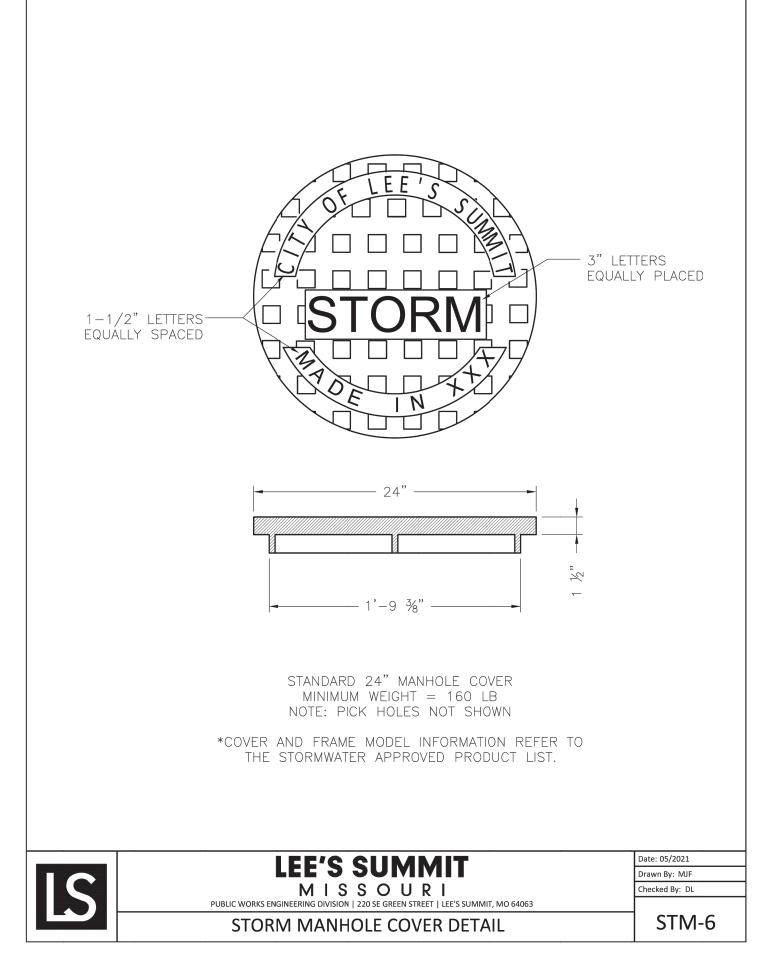

STORM MANHOLE COVER DETAIL

SCALE: NOT TO SCALE

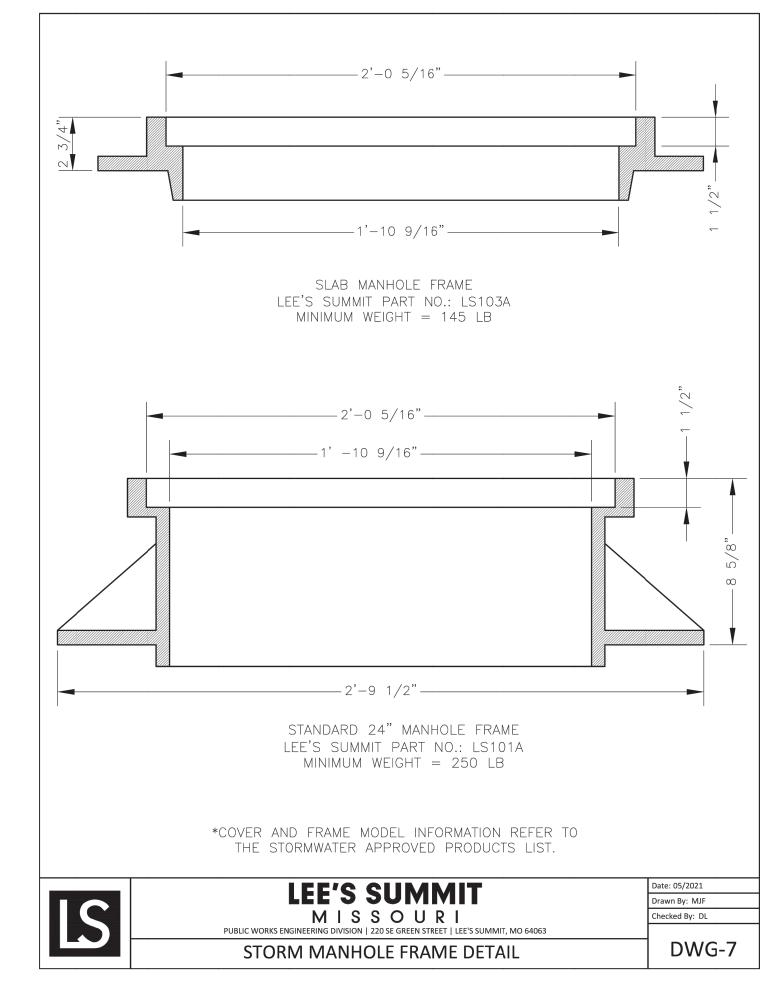

WAT-12


STORM MANHOLE FRAME DETAIL SCALE: NOT TO SCALE


FLARED END SECTION WITH TOE WALL DETAIL SCALE: NOT TO SCALE


SCALE: NOT TO SCALE

- GROUND SURFACE MECHANICAL JOINT (TYP.) THRUST BLOCK (SEE NOTE 1) VALVE LID & COVER -KEEP WEEPHOLE FREE OF CONCRETE AND - UNDISTURBED EARTH 24"X24"X4" SOLID CONCRETE PAD PROVIDE MIN. 1/2 CU. YD. OF 3/4" GRANULAR FILL PER AWWA C600 SEC. 4.2.7.2.4 ANCHOR FITTINGS (SEE NOTES 1 & 2) -THRUST BLOCK - UNDISTURBED EARTH

. WHEN RETAINER GLANDS ARE USED IN LIEU OF ANCHOR FITTINGS, HORIZONTAL THRUST BLOCKS ARE REQUIRED. 2. GATE VALVE MAY BE BOLTED DIRECTLY TO ANCHOR TEE. . SEE APPROVED PRODUCTS LIST FOR WATER UTILITIES FOR FIRE HYDRANT, VALVES, VALVE BOX LID, 4. BOTTOM HYDRANT FLANGE SHALL BE 2" TO 6" ABOVE FINISHED GRADE. 5. FOR STREETS WITHOUT CURBS FIRE HYDRANTS SHALL BE PLACED WITHIN 1 FOOT OF THE R/W LINE, BUT NOT MORE THAN 10' FROM EDGE OF PAVEMENT. FIRE HYDRANT SHALL NOT BE PLACED IN BOTTOM OF DITCH. 6. HYDRANT SHALL BE ROTATED AS DIRECTED BY INSPECTOR. **LEE'S SUMMIT** Drawn By: MJF MISSOURI Checked By: KLY WAT-7 **HYDRANT - STRAIGHT SET**

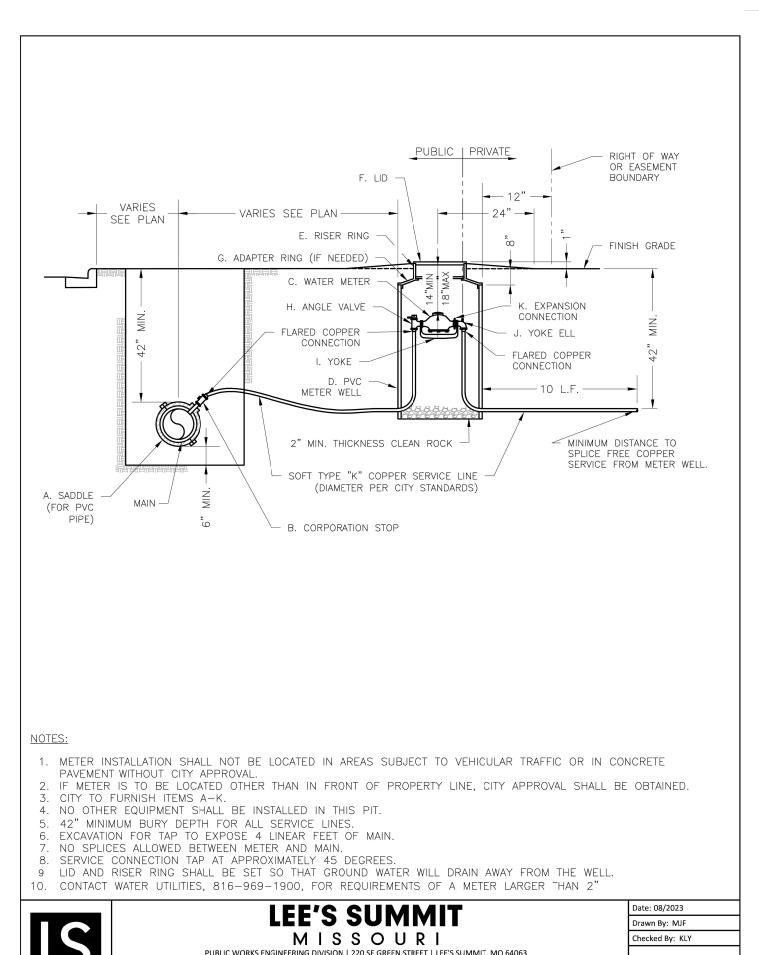

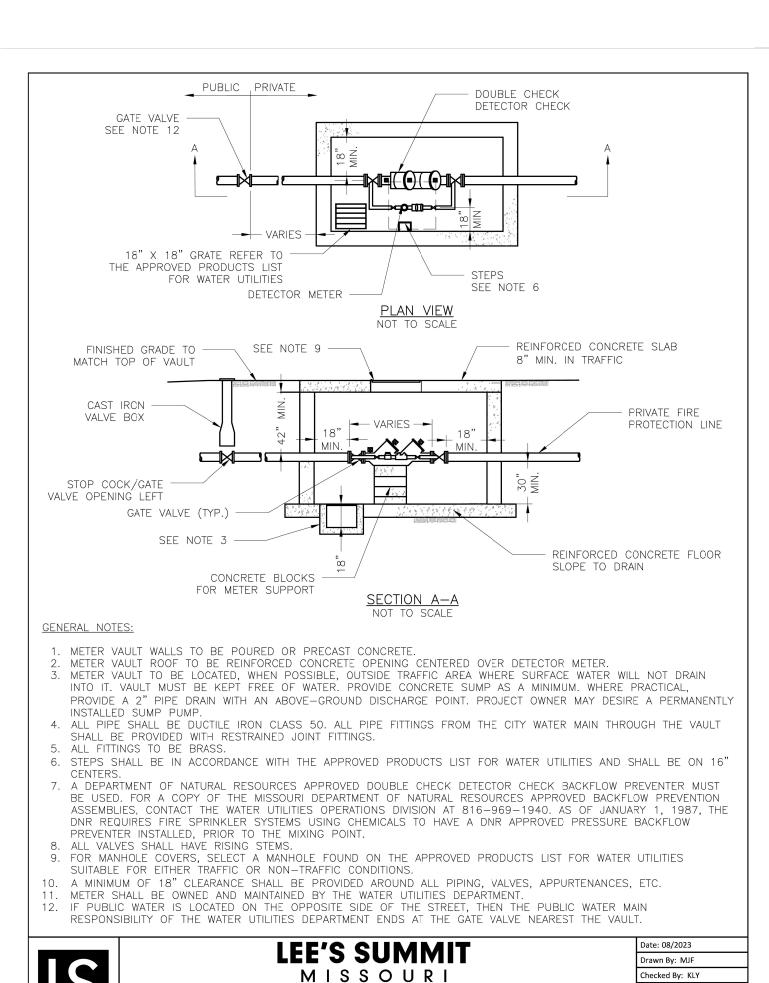

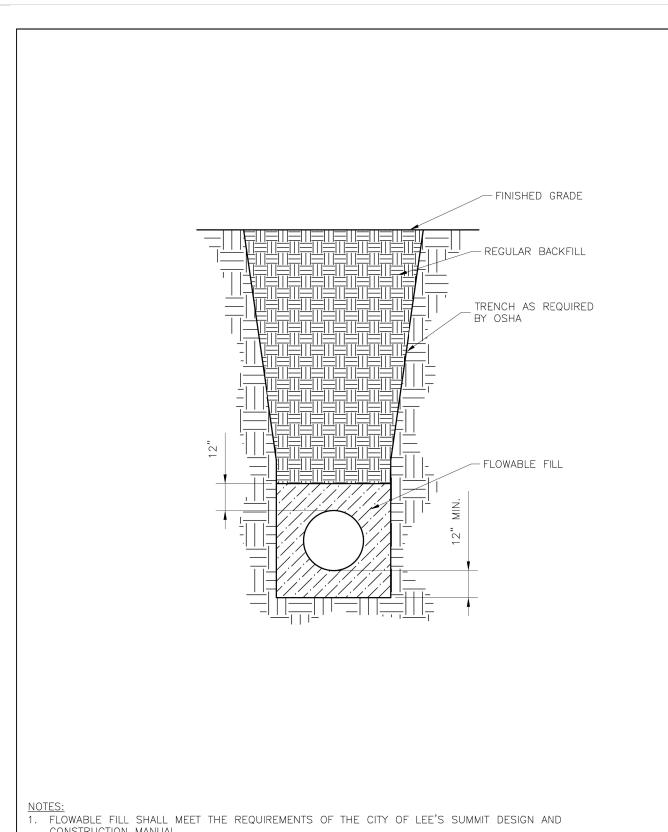

CONSTRUCTION MANUAL. REGULAR BACKFILL ABOVE THE TRENCH CHECK SHALL BE FREE OF DEBRIS, ORGANIC MATTER, AND STONES > 6" IN ANY DIMENSION.

. TOP OF FLOWABLE BACKFILL SHALL EXTEND 12" ABOVE THE TOP OF THE PIPE.

4. LENGTH OF	TRENCH CHECK SHALL BE A MINIMUM OF 12".	
	LEE'S SUMMIT	Date: 08/2023
	LEE 9 30 IVIIVII I	Drawn By: MJF
	MISSOURI	Checked By: KLY
	PUBLIC WORKS ENGINEERING DIVISION 220 SE GREEN STREET LEE'S SUMMIT, MO 64063	
	WATER TRENCH CHECK DETAIL	WAT-6

HYDRANT - STRAIGHT SET DETAIL SCALE: NOT TO SCALE

SERVICE CONNECTION WITH METER WELL DETAIL SCALE: NOT TO SCALE

SERVICE CONNECTION WITH METER WELL

WAT-11

VAULT FOR DOUBLE CHECK DETECTOR CHECK DETAIL SCALE: NOT TO SCALE

VAULT FOR DOUBLE CHECK DETECTOR CHECK

SCALE: NOT TO SCALE

268442000 SHEET NUMBER

ORIGINAL ISSUE:


2/22/2024

KHA PROJECT NO.


C009


Horn


Kimley

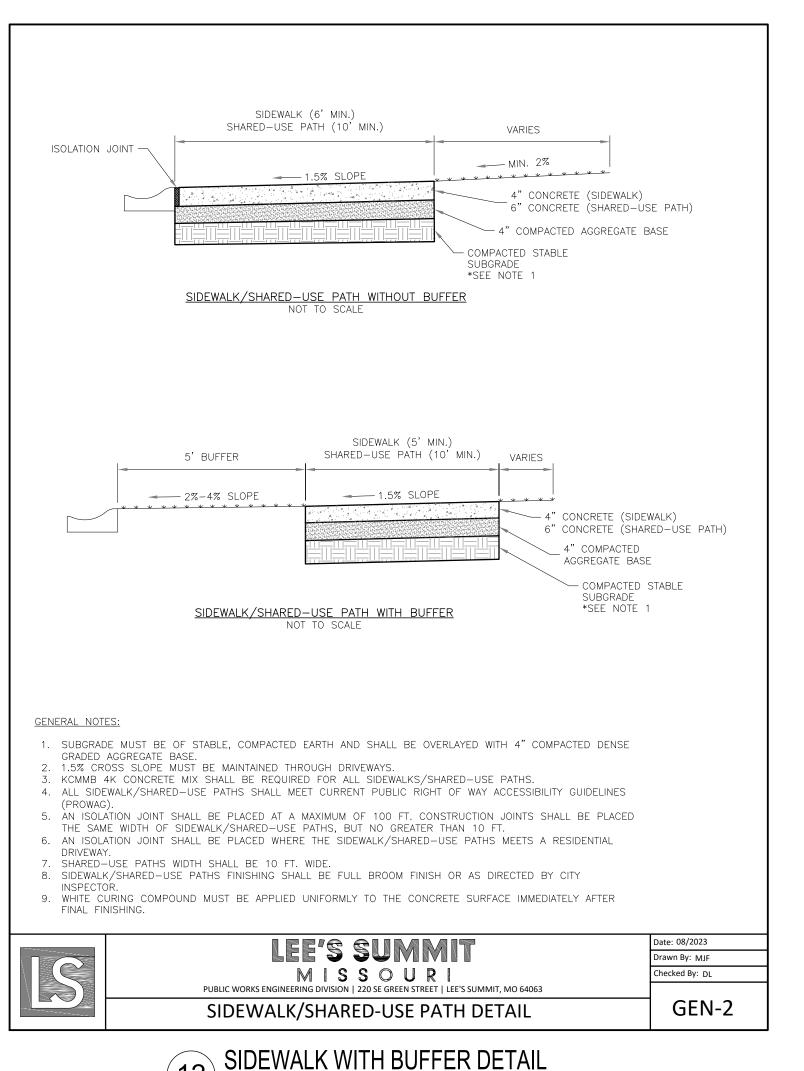



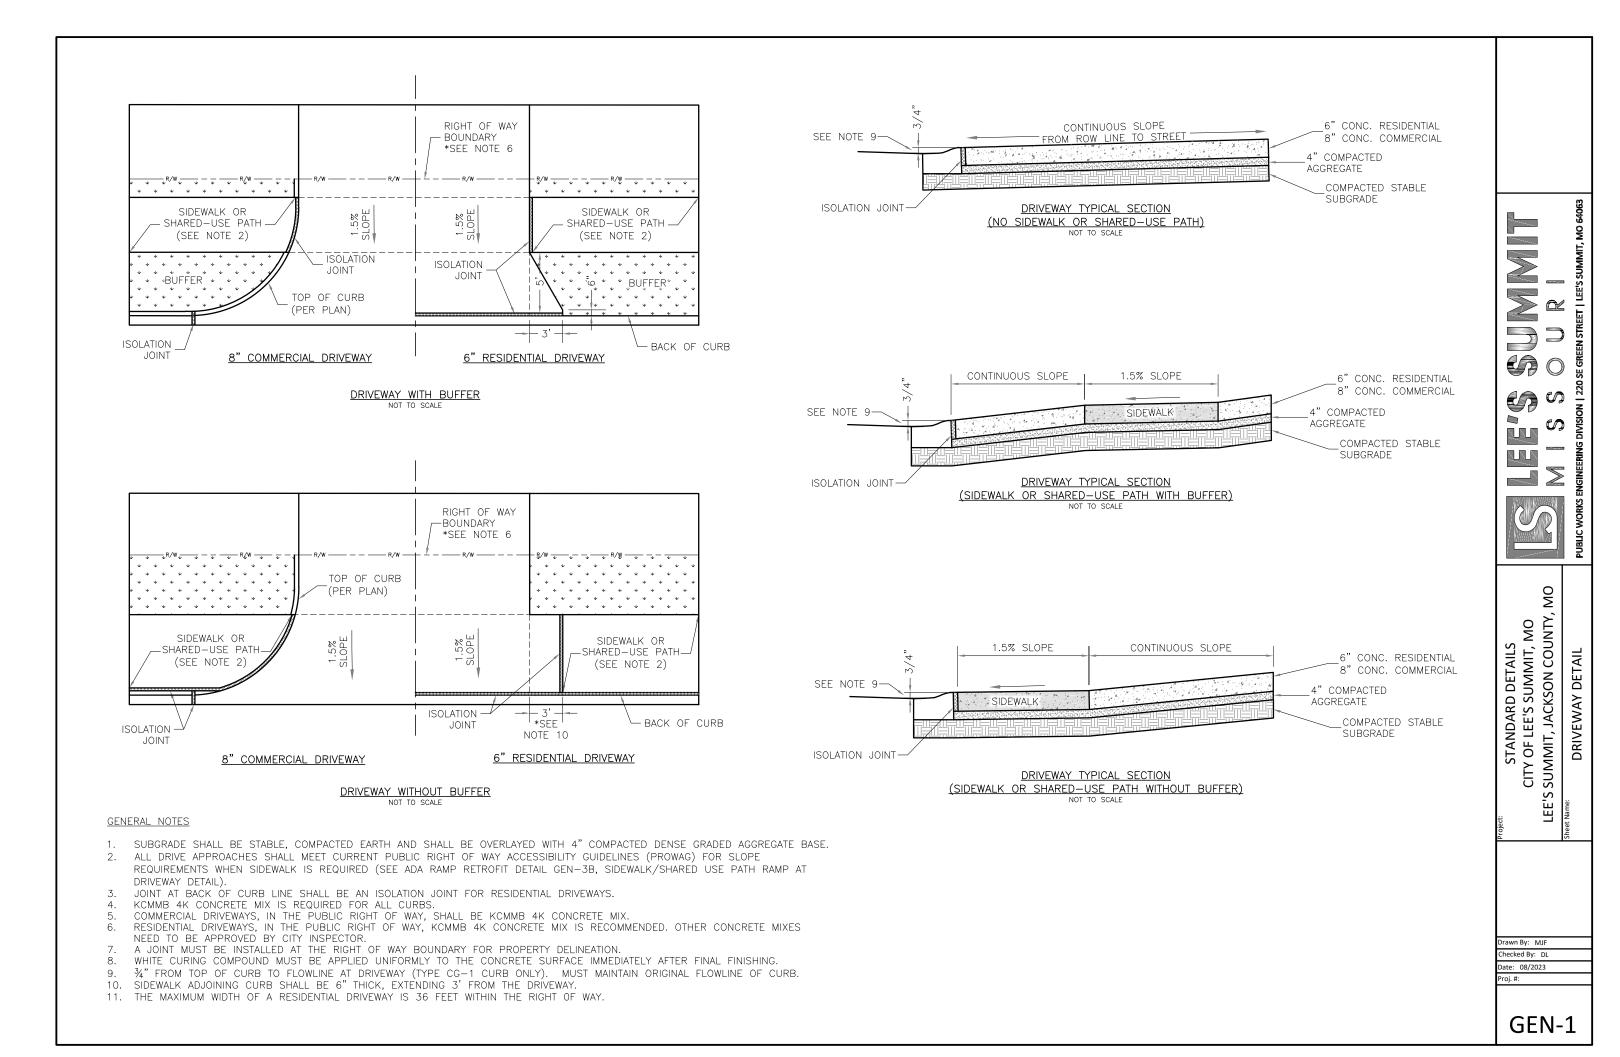

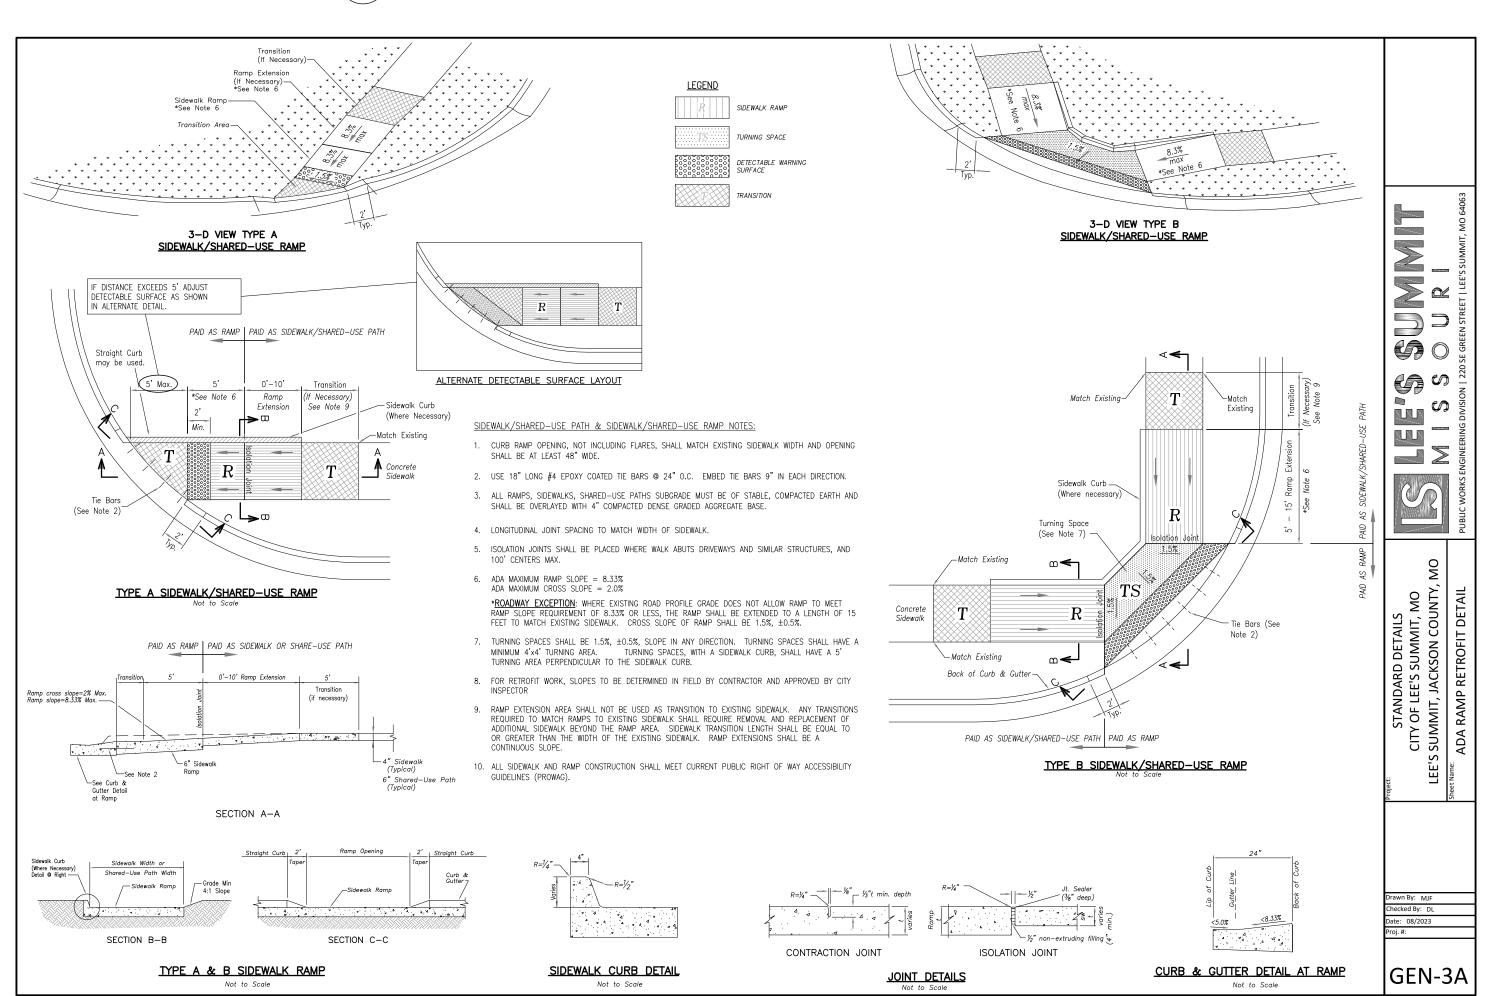

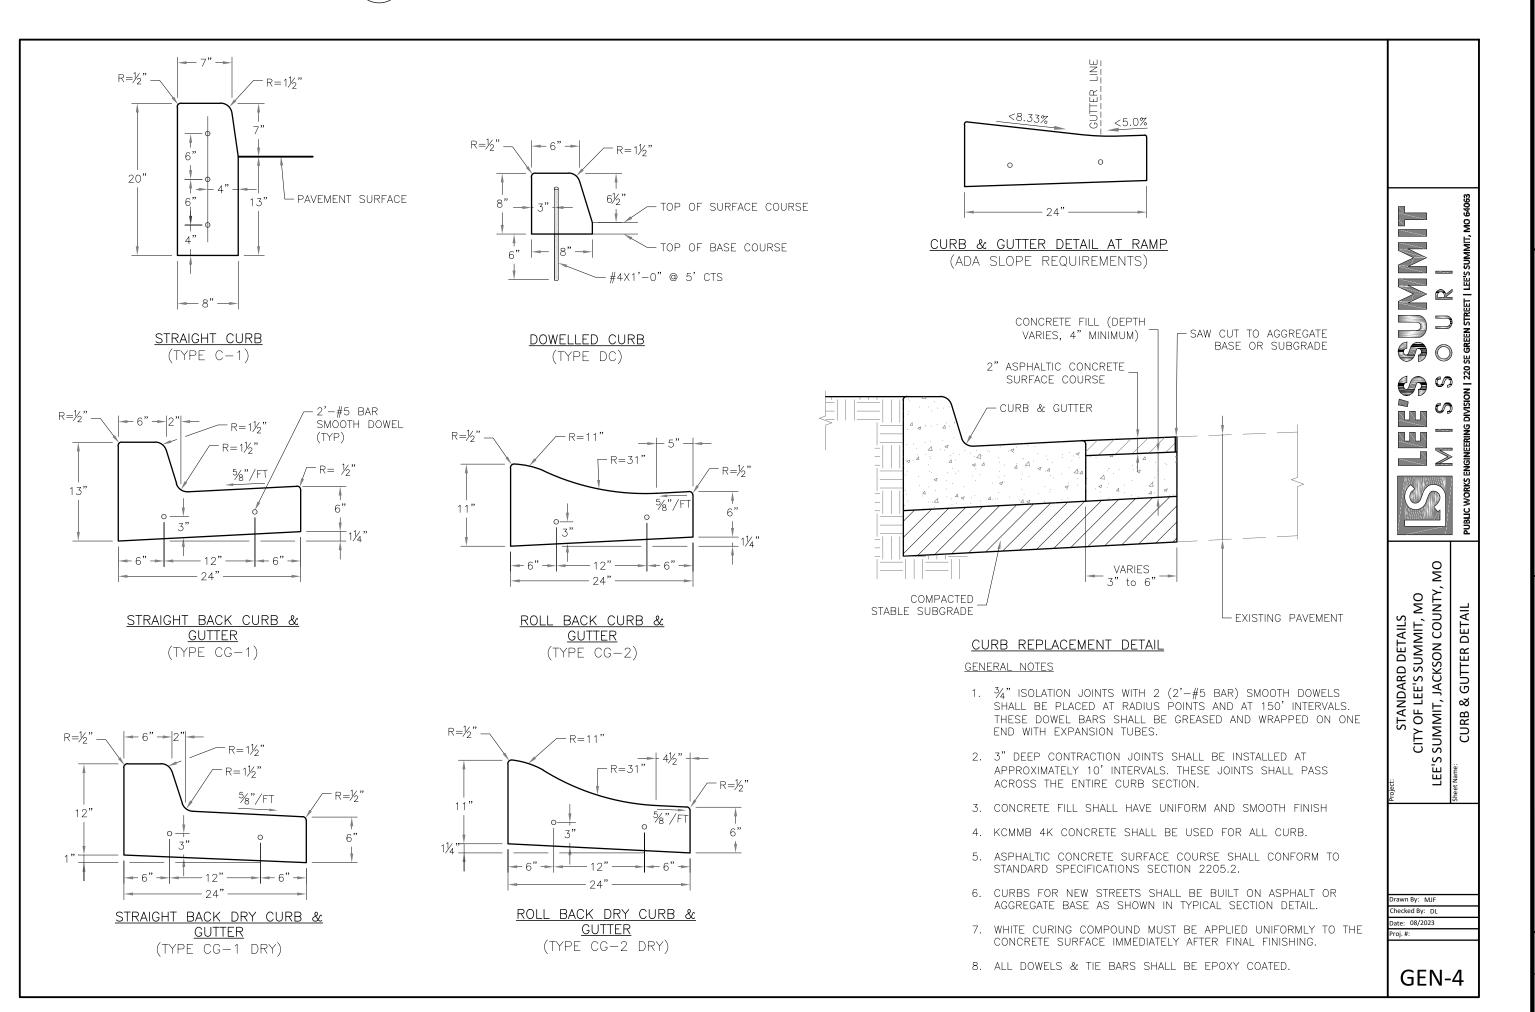

TYPE A SIDEWALK ADA RAMP RETROFIT DETAIL SCALE: NOT TO SCALE

STRAIGHT BACK CURB AND GUTTER DETAIL SCALE: NOT TO SCALE


268442000 SHEET NUMBER


ORIGINAL ISSUE:

2/22/2024

KHA PROJECT NO.

C010

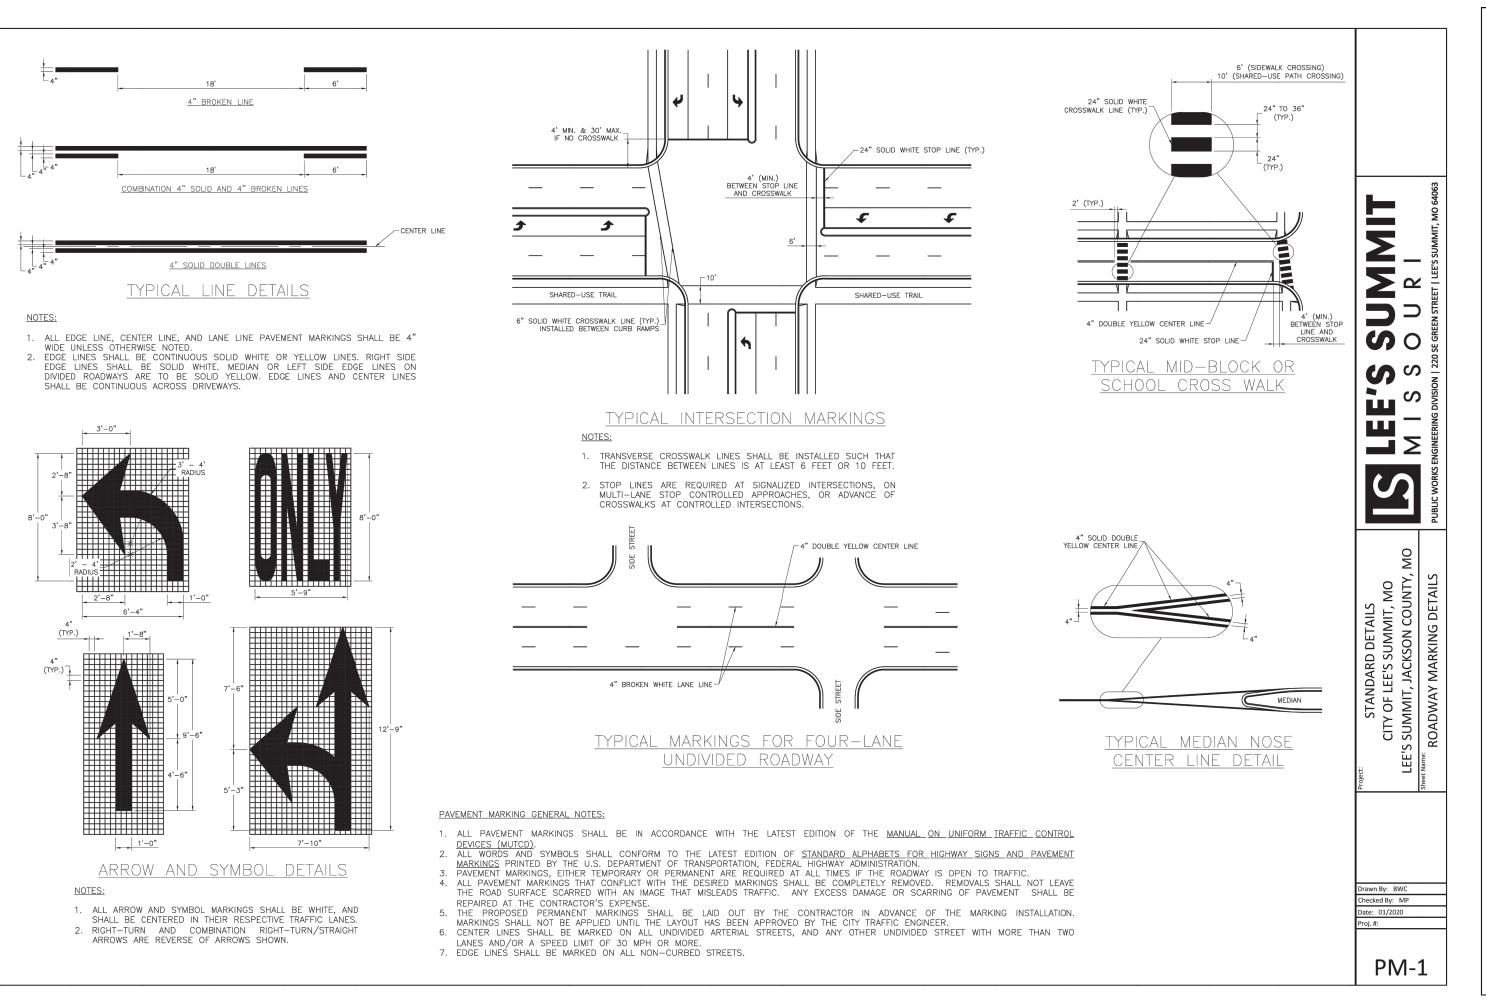


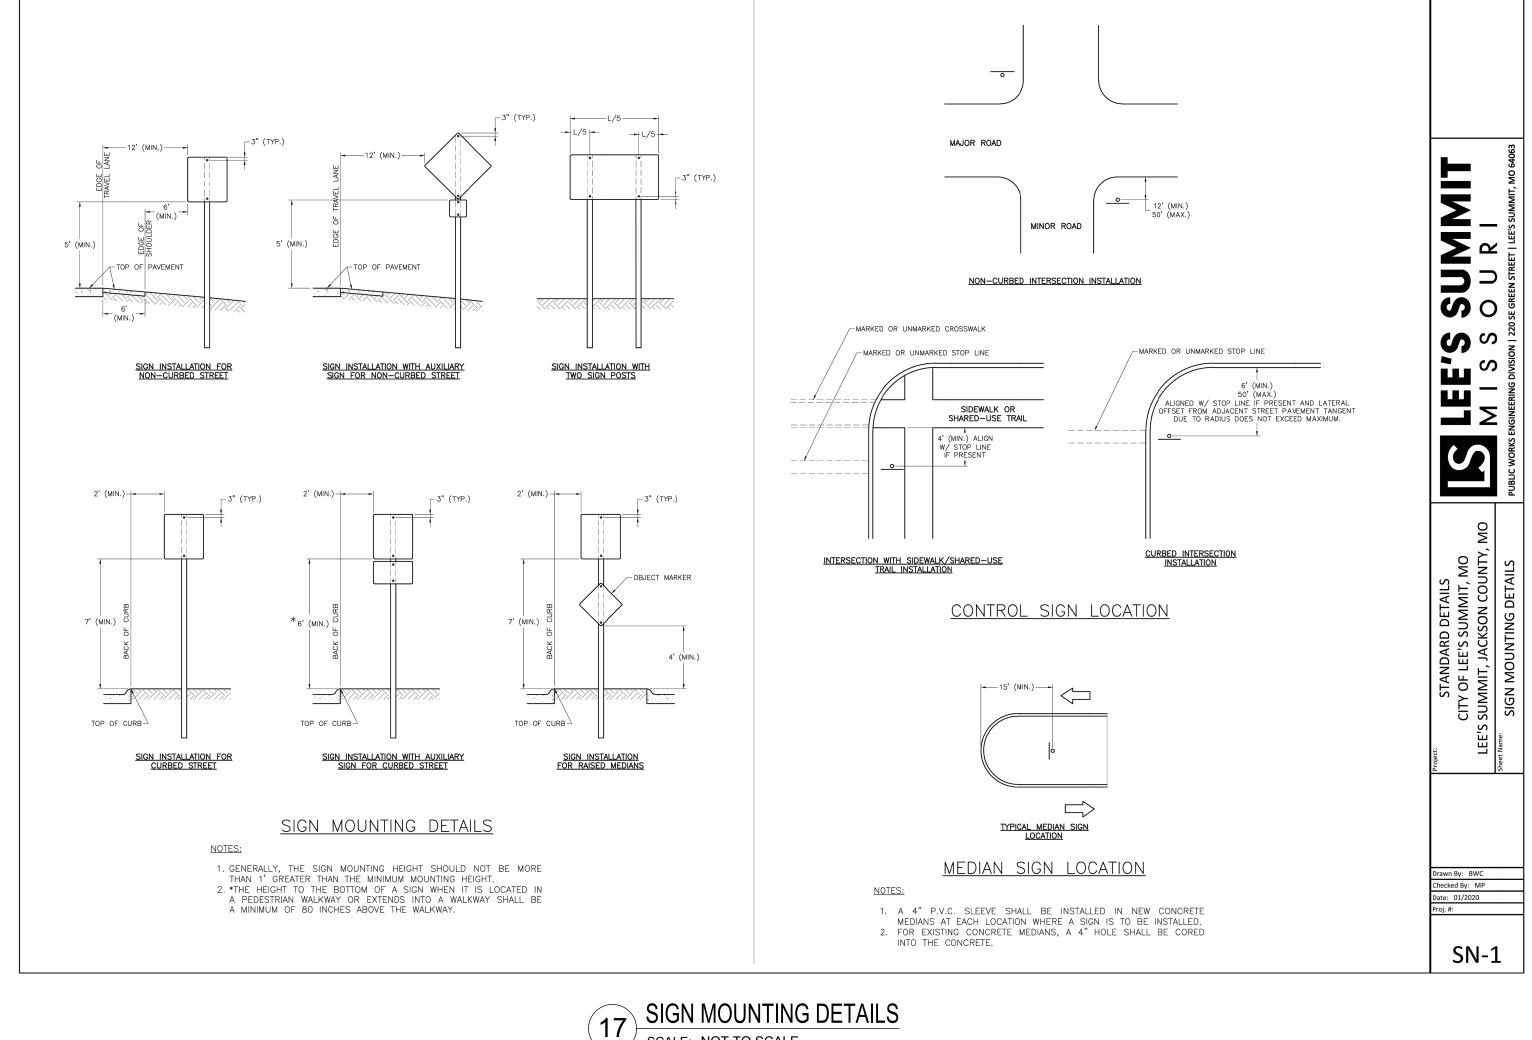



SCALE: NOT TO SCALE

PAVEMENT MARKING ARROW AND SYMBOL DETAILS SCALE: NOT TO SCALE

www.ameristarfence.com

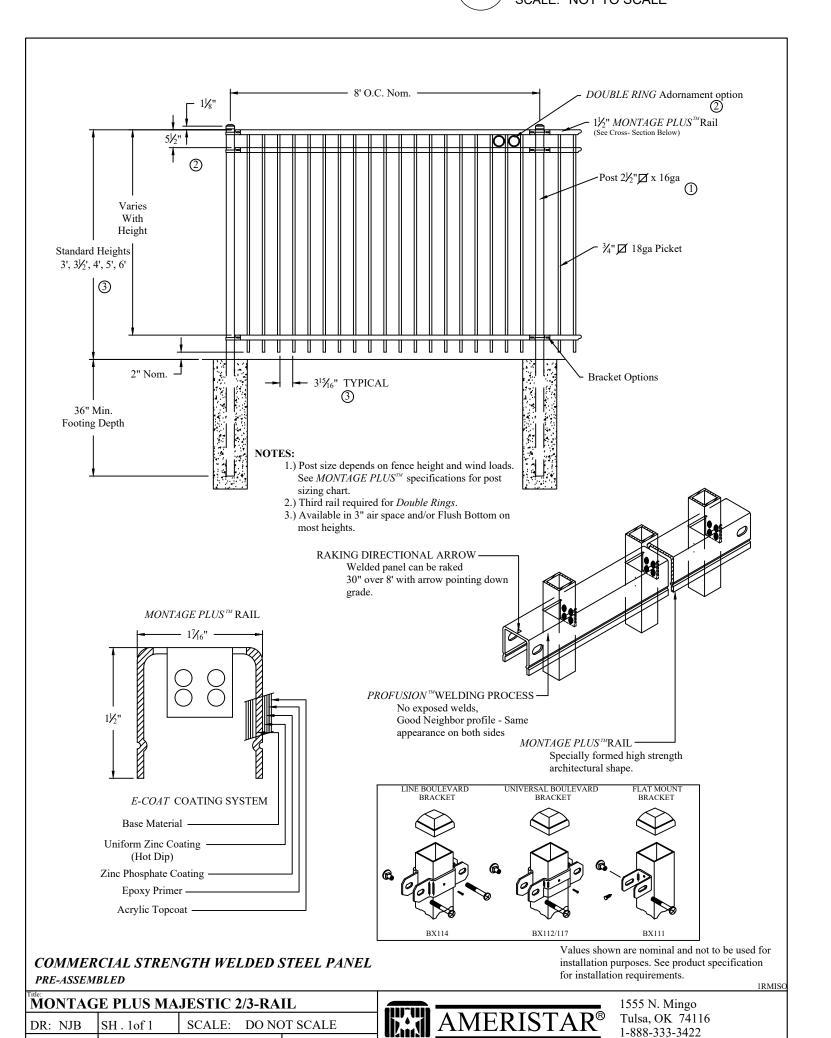

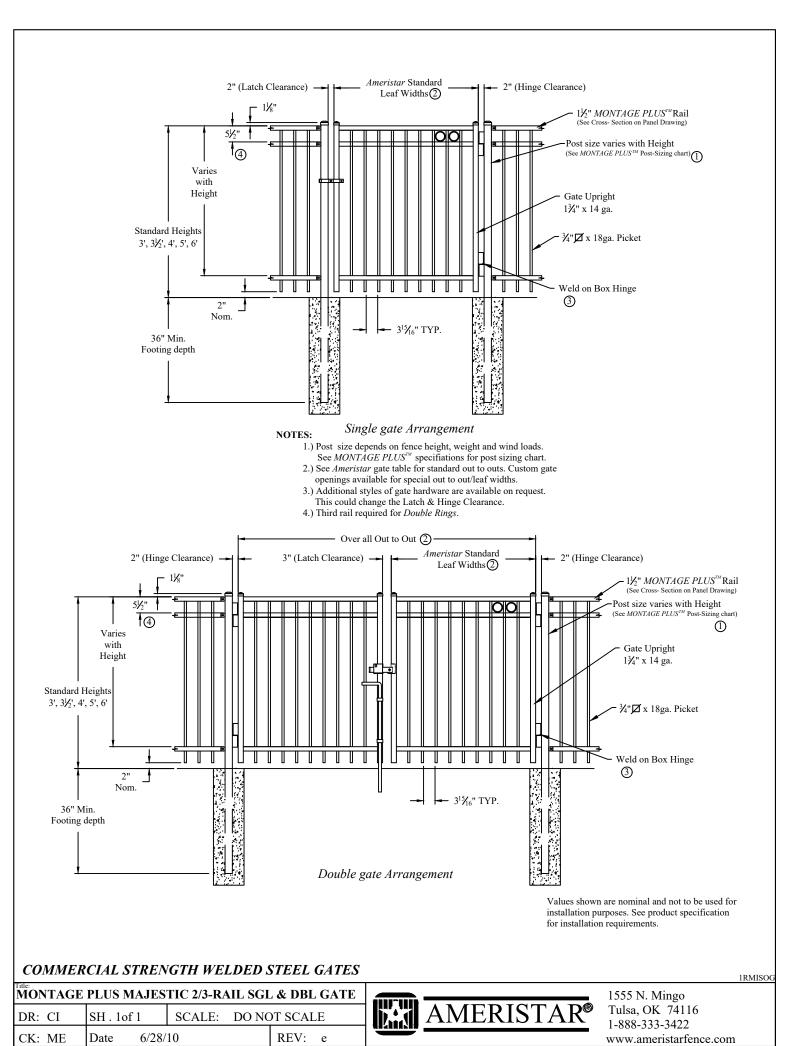

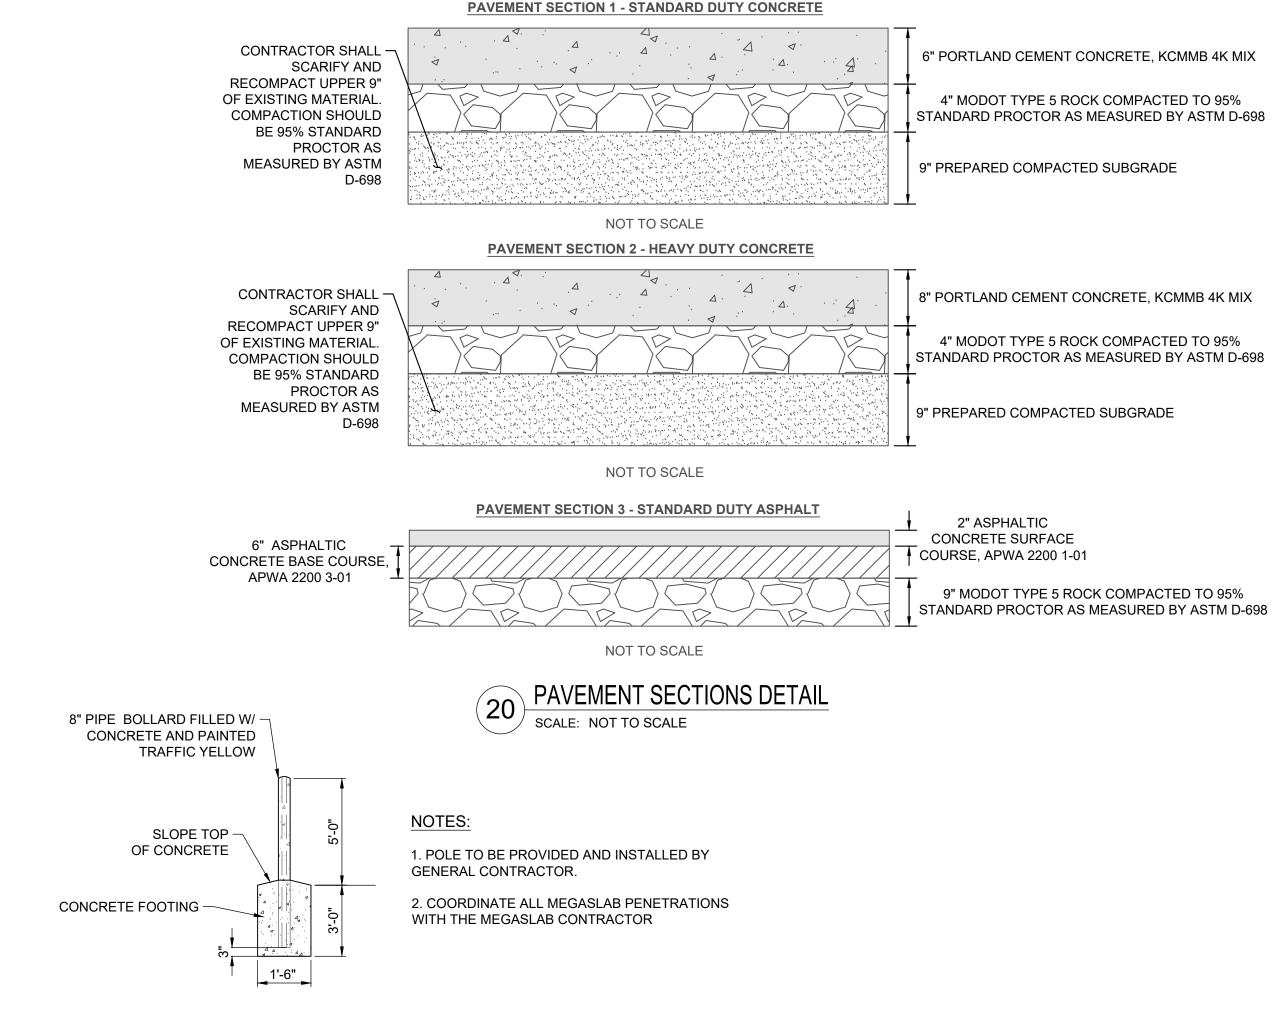

SCALE: NOT TO SCALE

STEEL-ENCASED CONCRETE BOLLARD DETAIL

5


ORIGINAL ISSUE: 2/22/2024 KHA PROJECT NO. 268442000


SHEET NUMBER

C012


REV: e AMERISTAR FENCE DETAIL

AMERISTAR GATE DETAIL

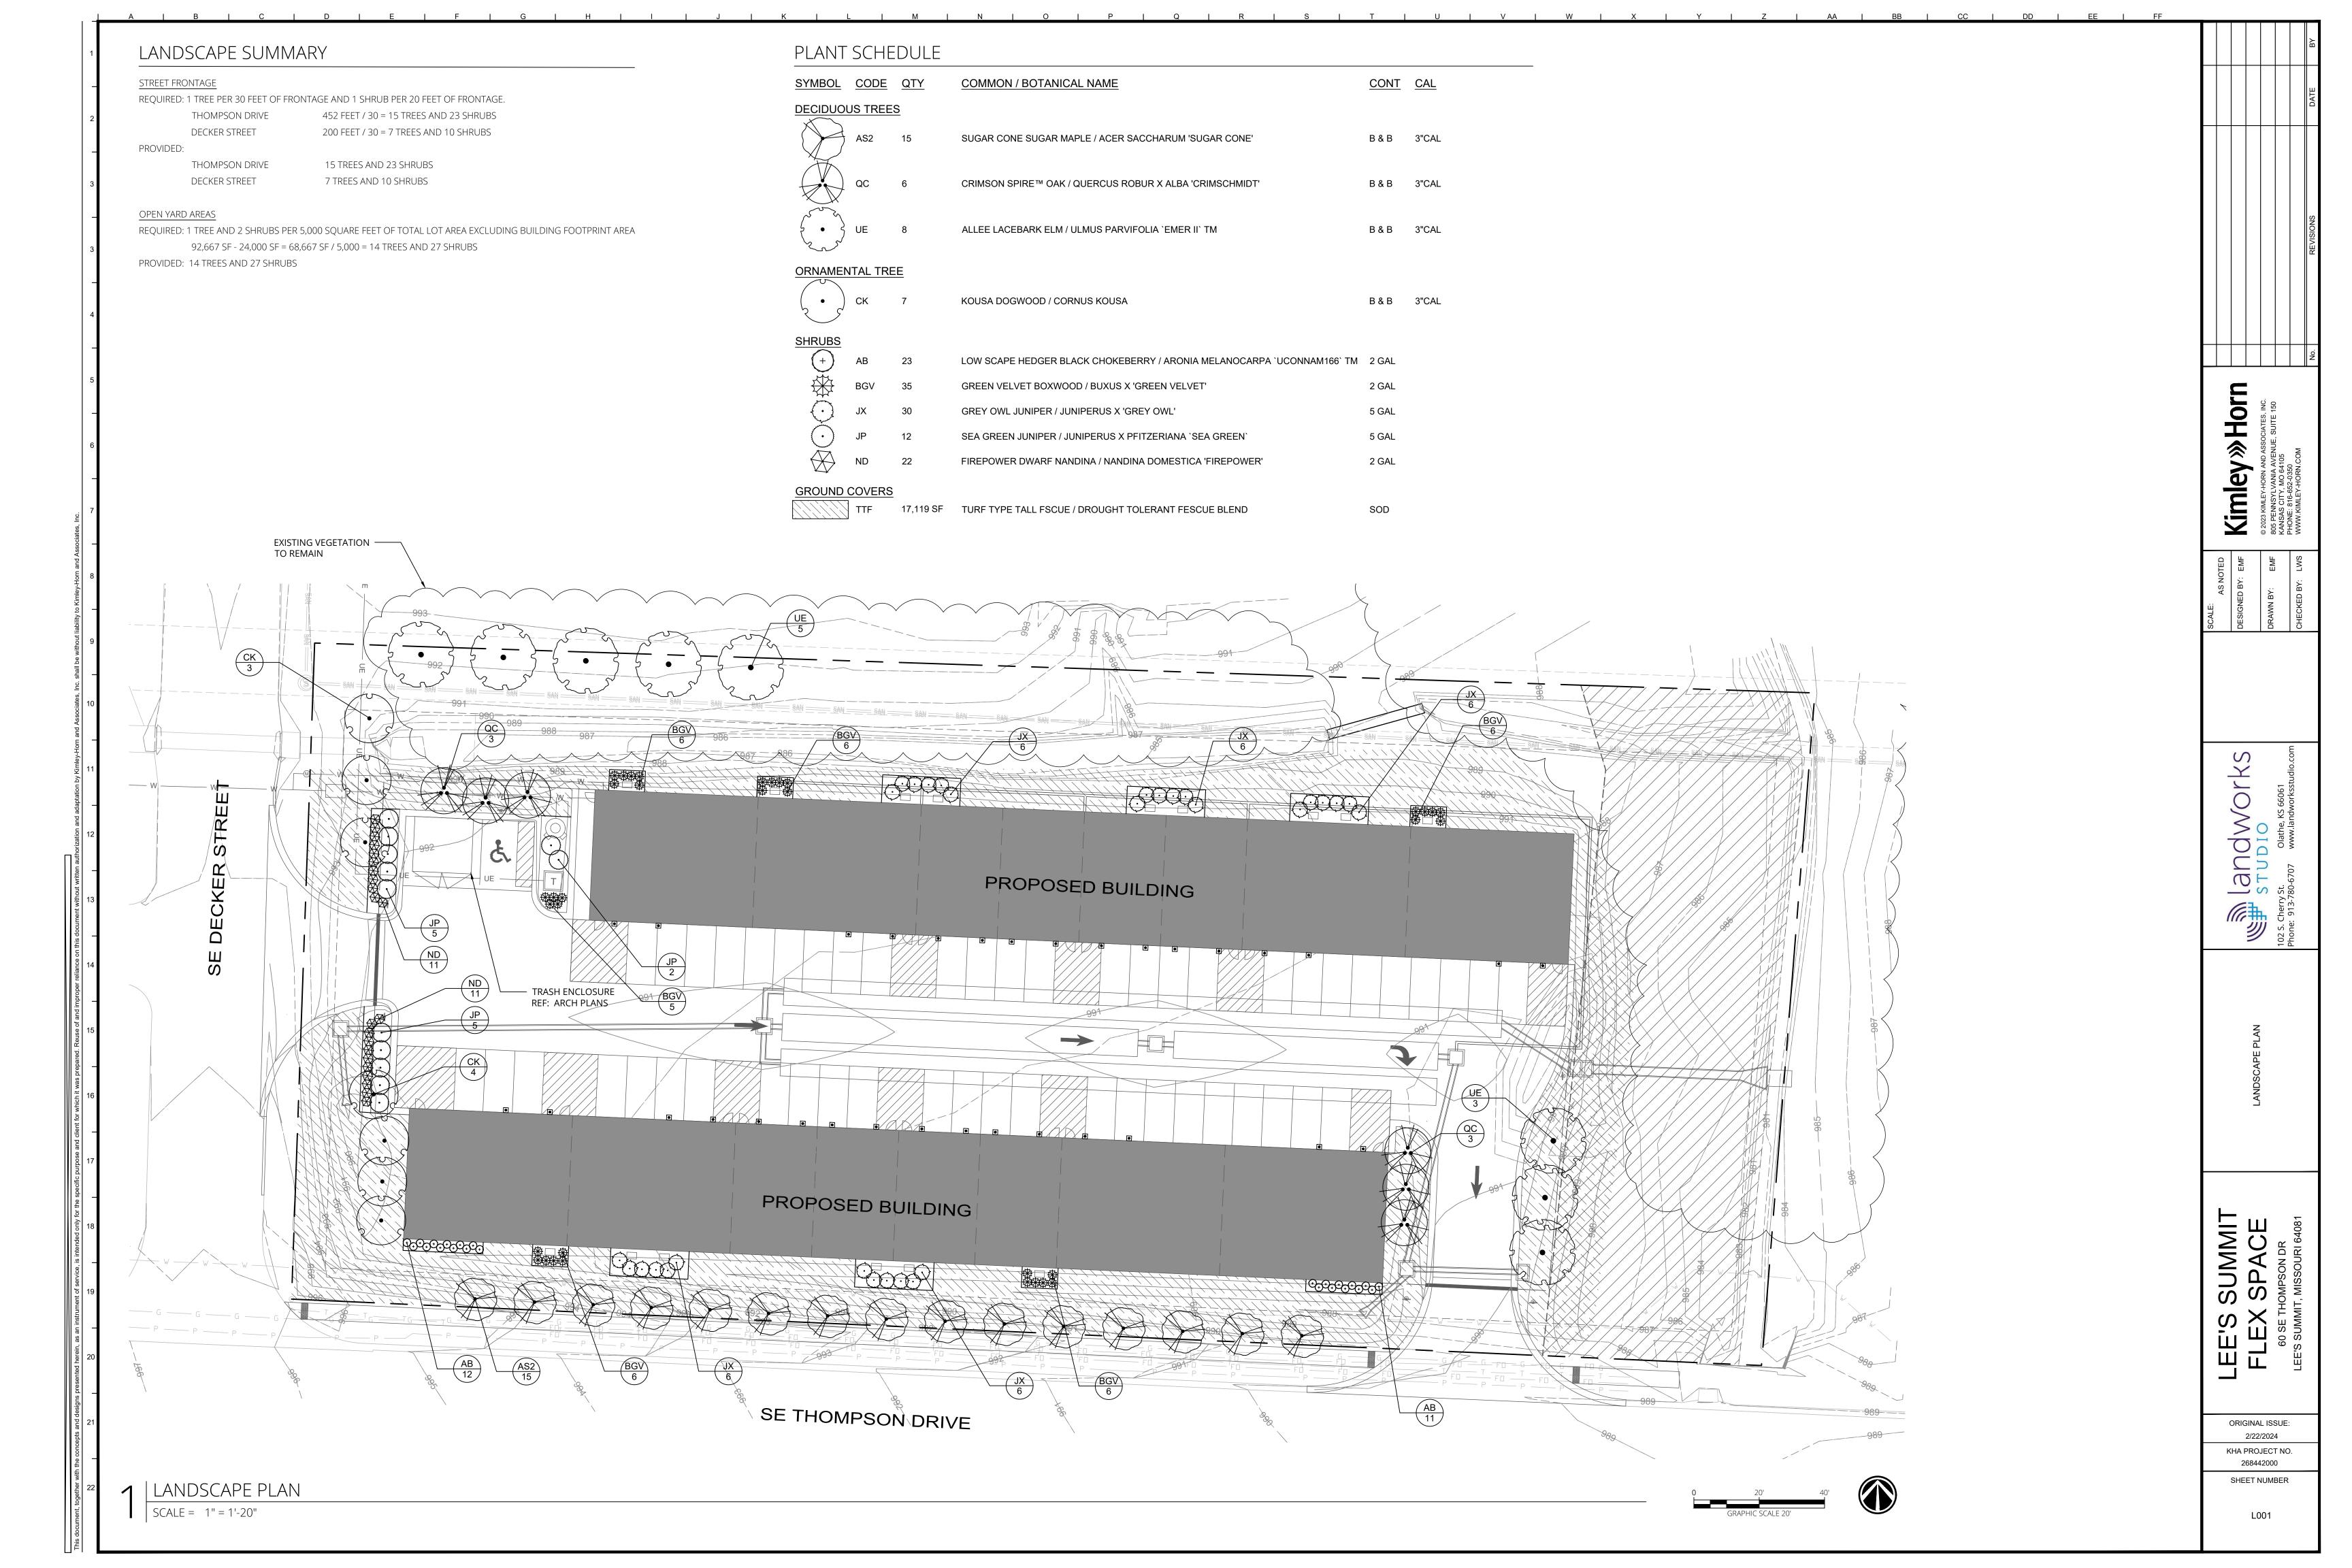

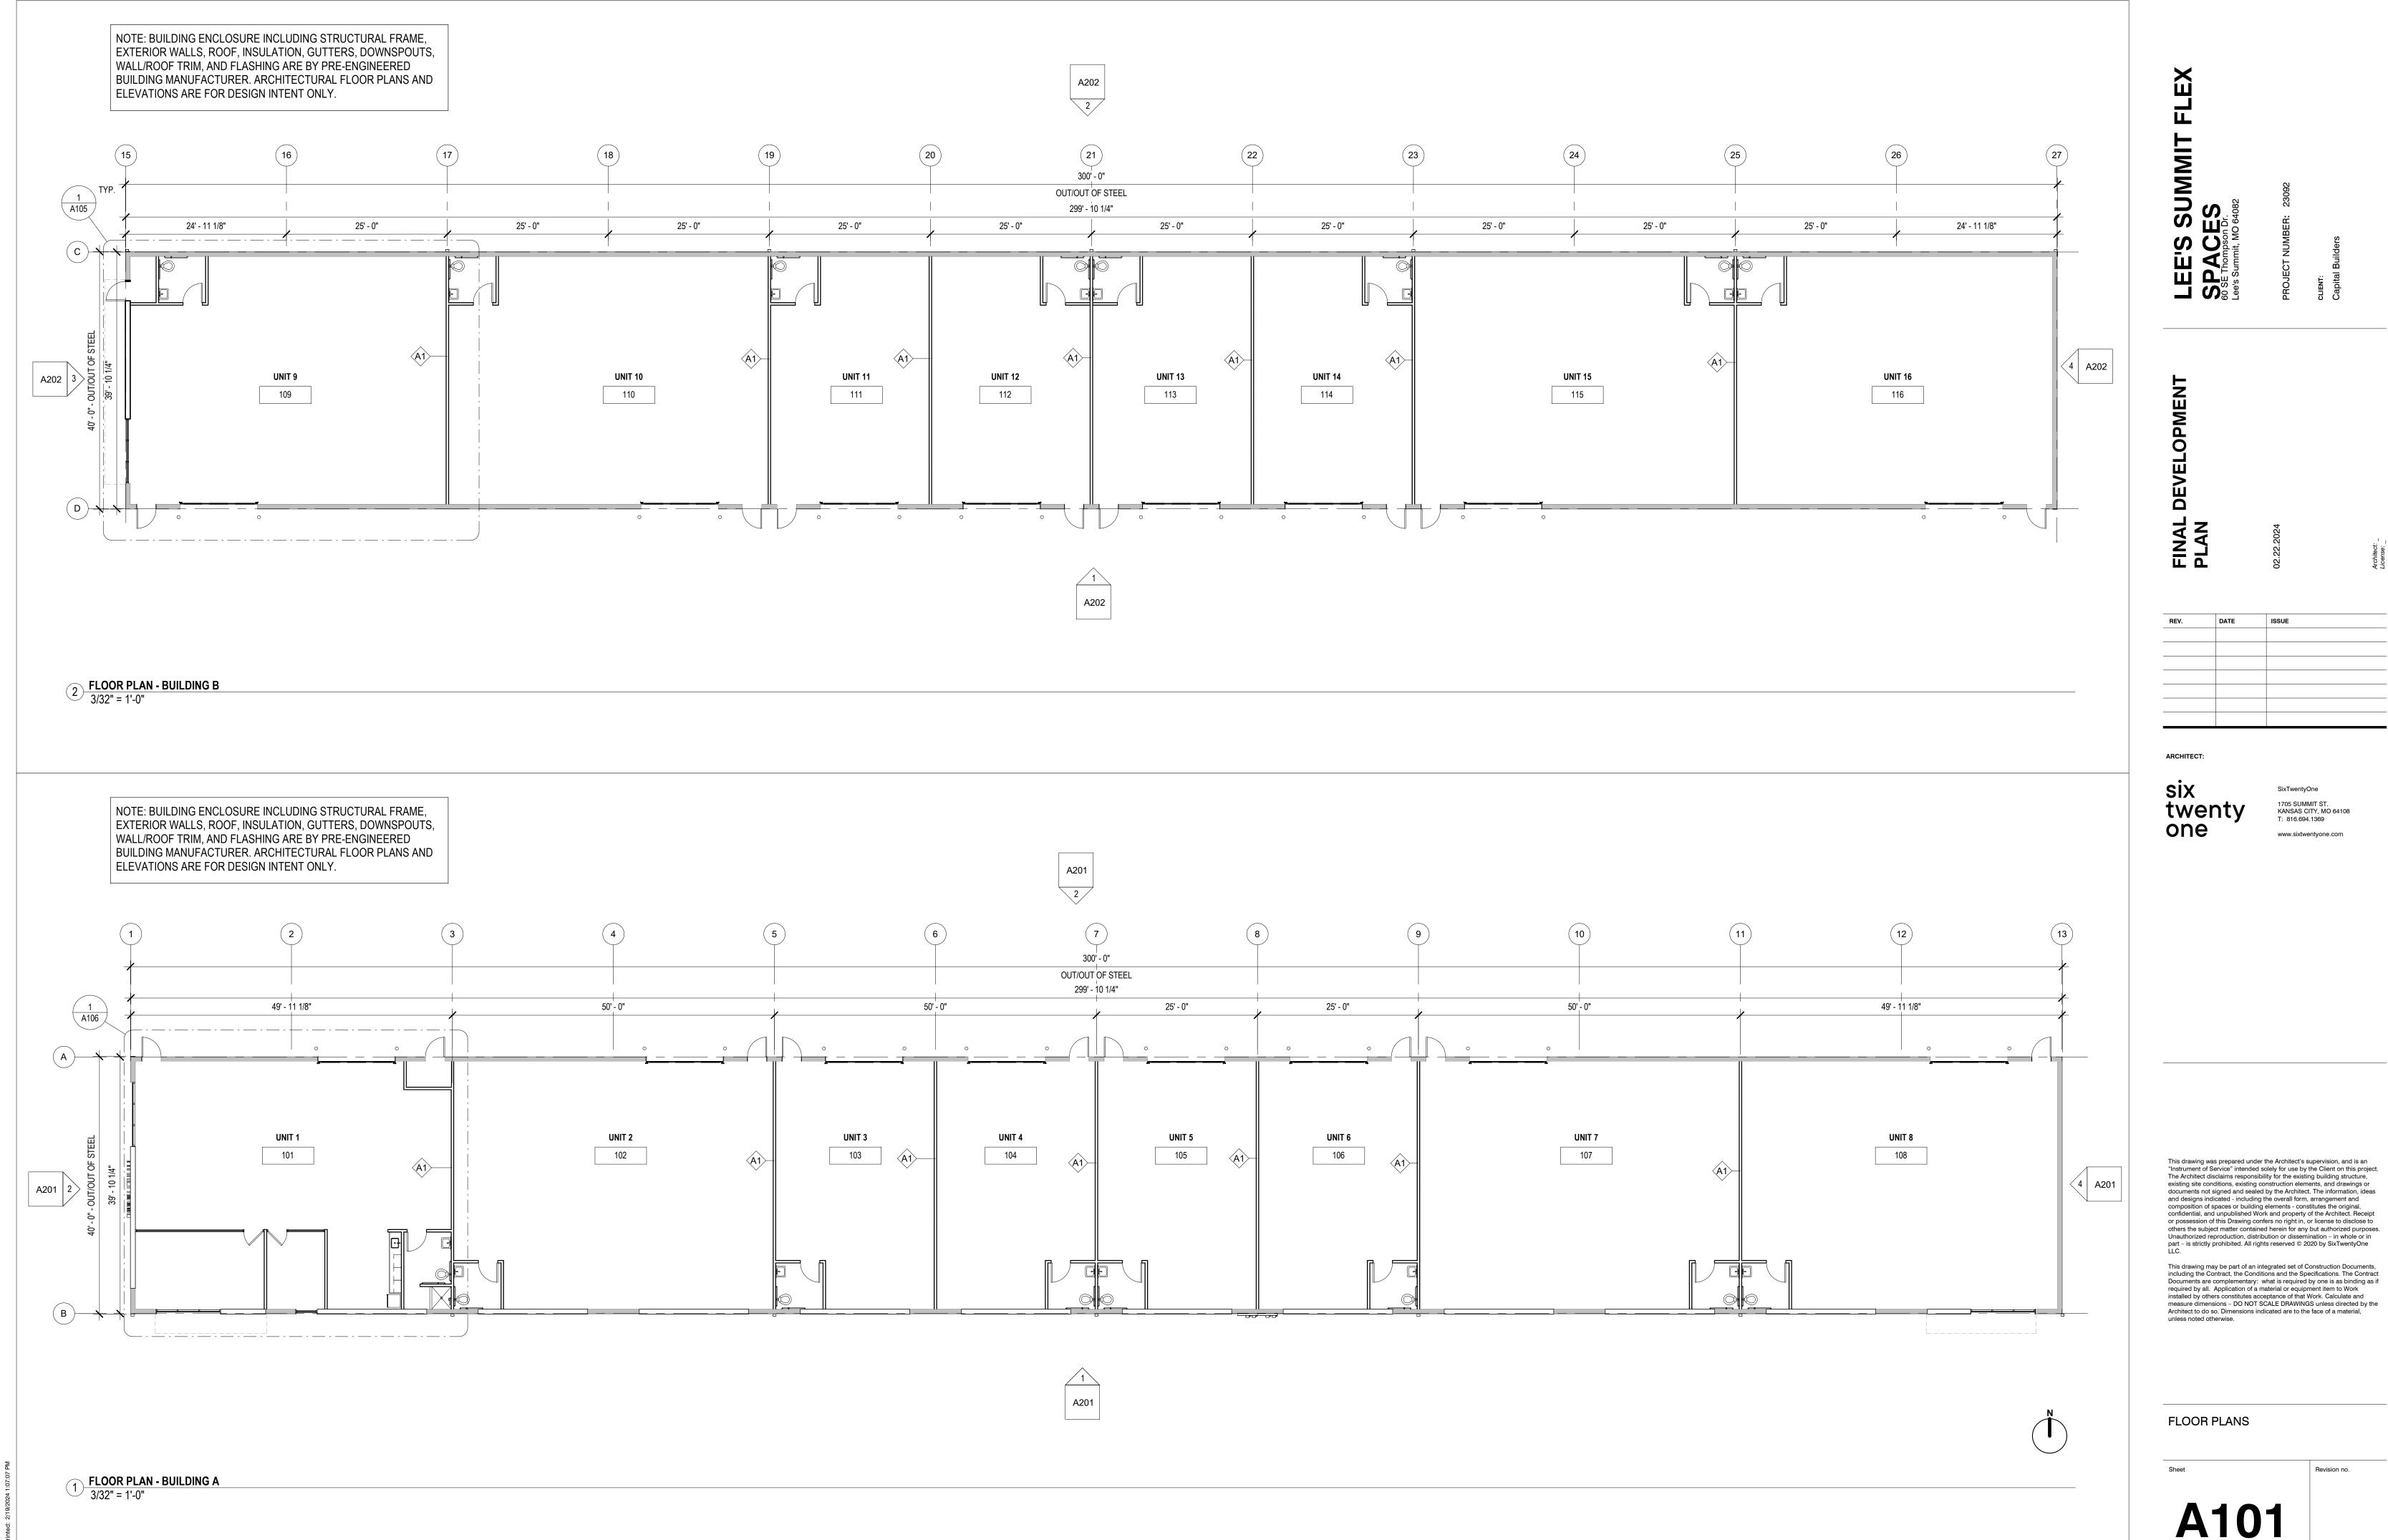

installed by others constitutes acceptance of that Work. Calculate and measure dimensions – DO NOT SCALE DRAWINGS unless directed by the

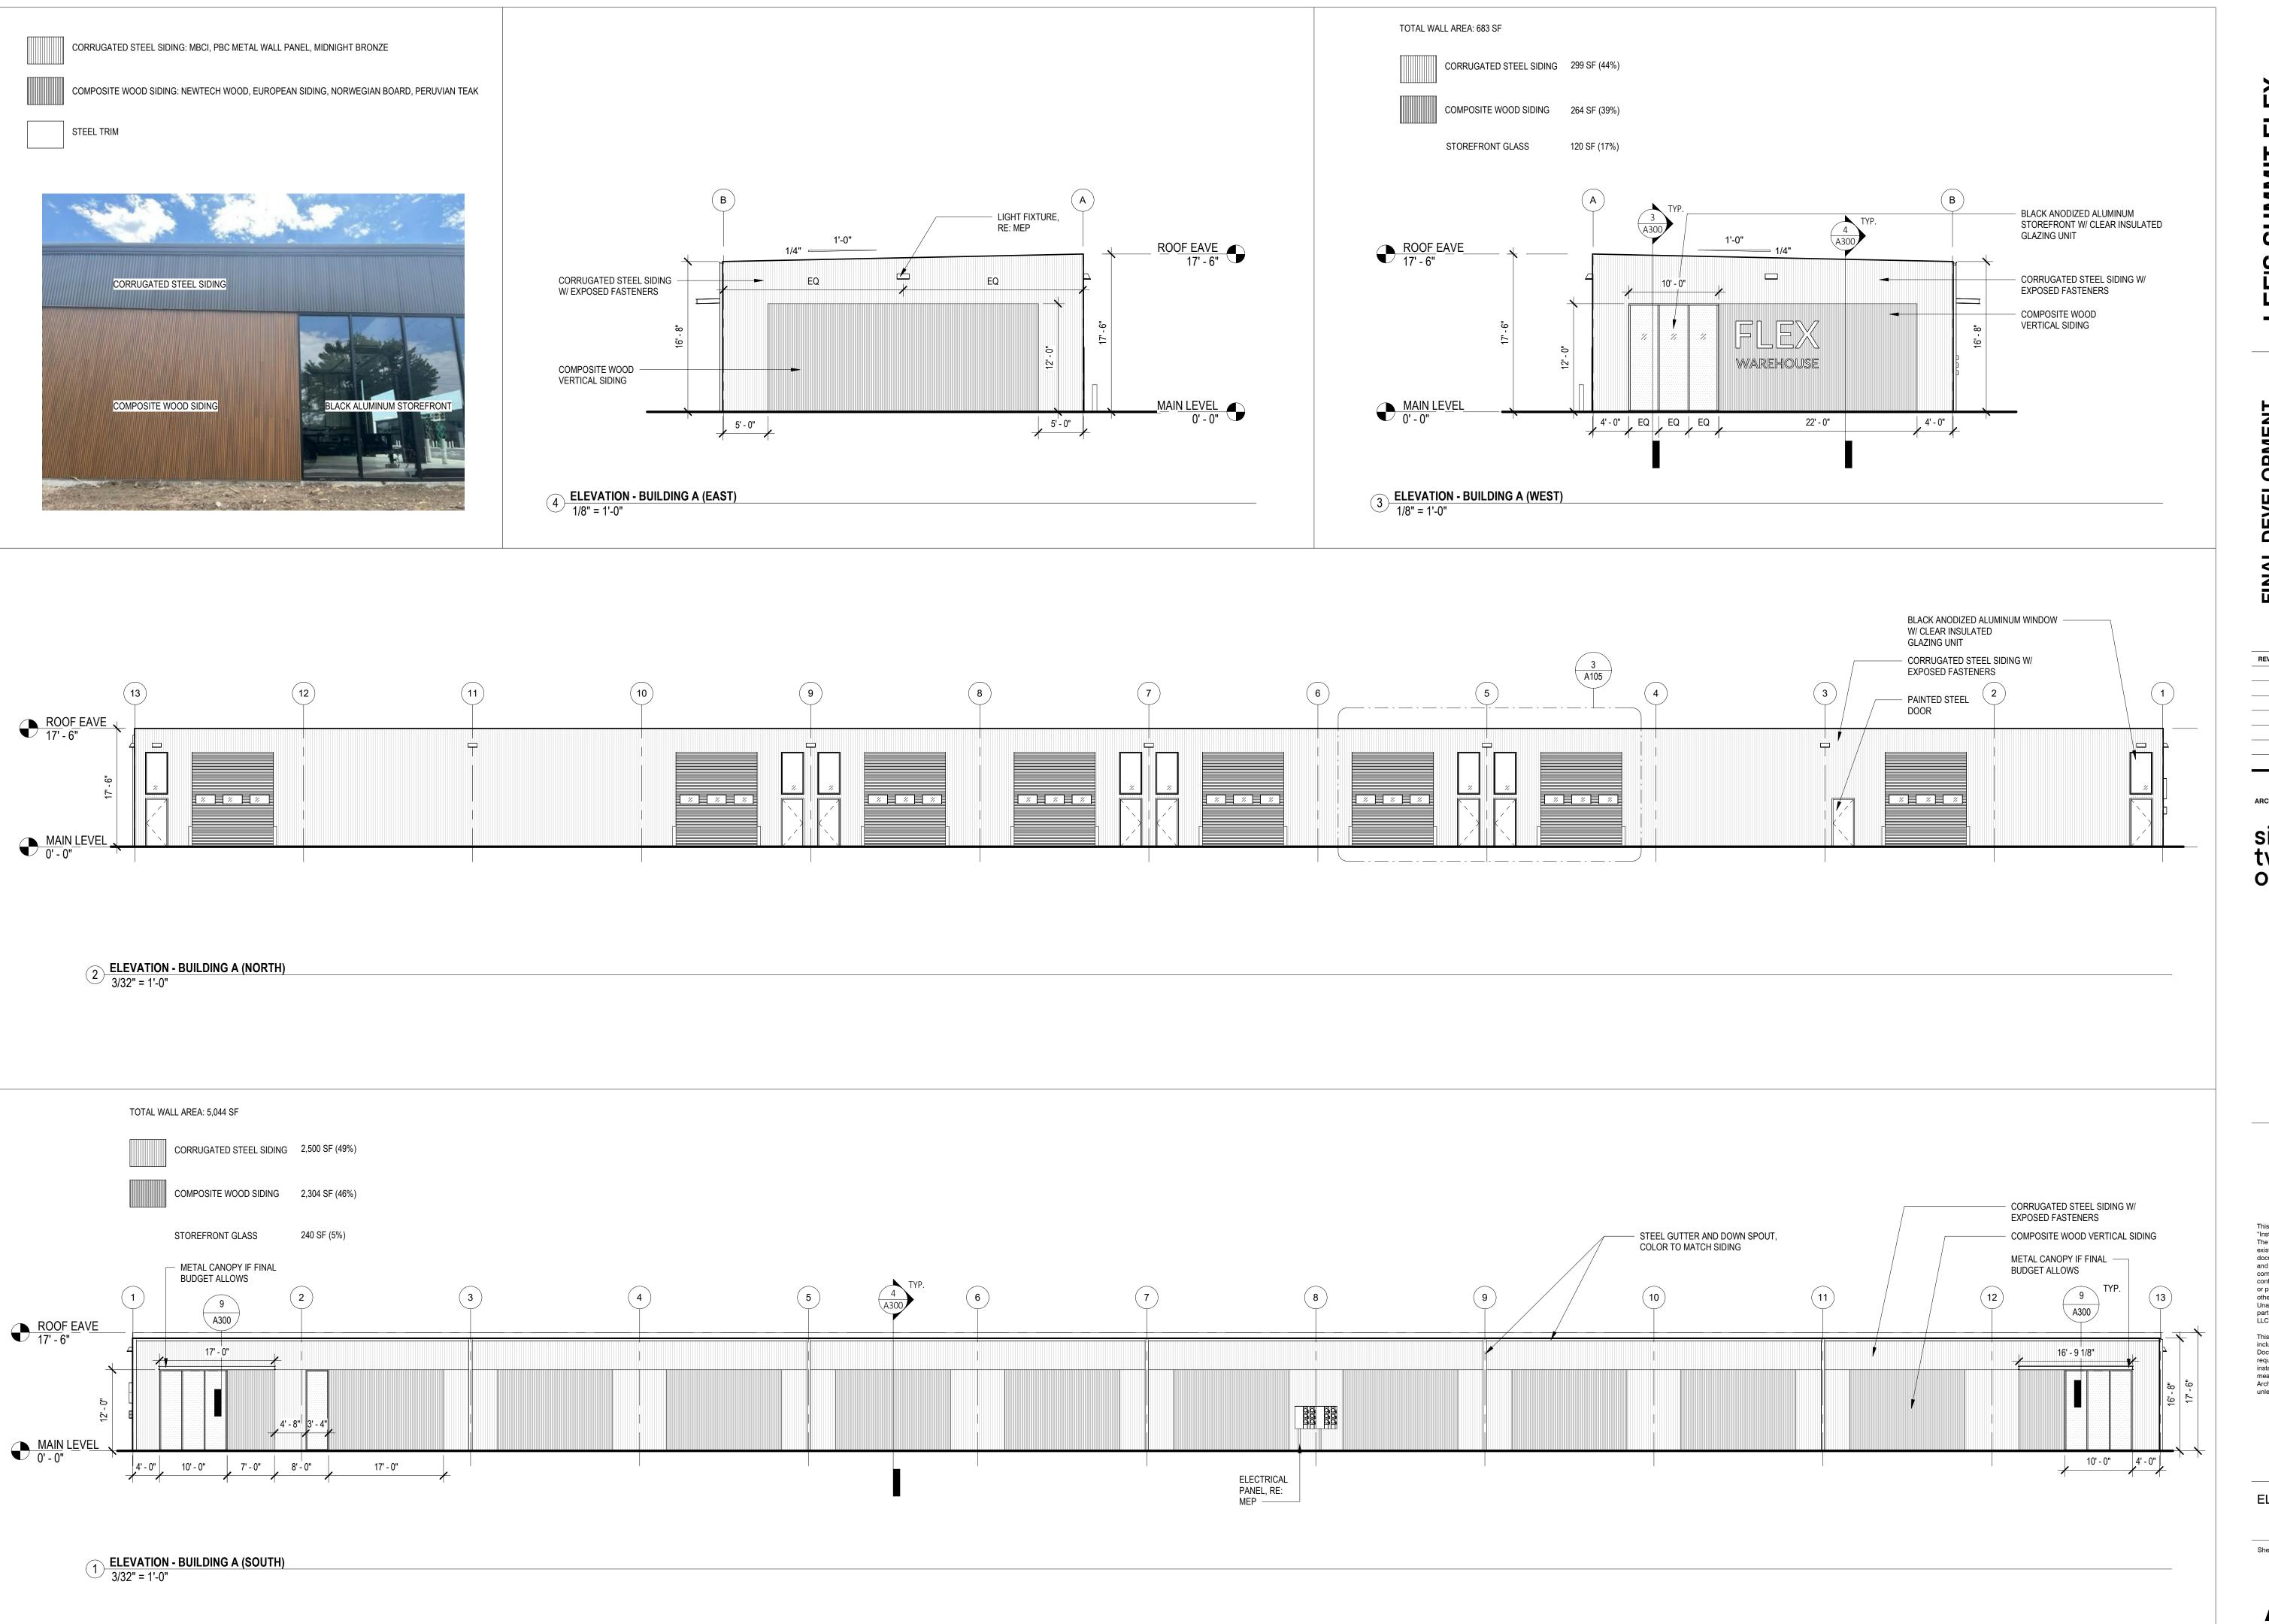

SUMMIT ES

DEVELOPMENT

DATE


twenty

T: 816.694.1369 www.sixtwentyone.com

This drawing was prepared under the Architect's supervision, and is an "Instrument of Service" intended solely for use by the Client on this project. The Architect disclaims responsibility for the existing building structure, existing site conditions, existing construction elements, and drawings or documents not signed and sealed by the Architect. The information, ideas and designs indicated - including the overall form, arrangement and composition of spaces or building elements - constitutes the original, confidential, and unpublished Work and property of the Architect. Receipt or possession of this Drawing confers no right in, or license to disclose to others the subject matter contained herein for any but authorized purposes. Unauthorized reproduction, distribution or dissemination – in whole or in part – is strictly prohibited. All rights reserved © 2020 by SixTwentyOne

This drawing may be part of an integrated set of Construction Documents, including the Contract, the Conditions and the Specifications. The Contract Documents are complementary: what is required by one is as binding as if required by all. Application of a material or equipment item to Work installed by others constitutes acceptance of that Work. Calculate and measure dimensions – DO NOT SCALE DRAWINGS unless directed by the Architect to do so. Dimensions indicated are to the face of a material, unless noted otherwise.

ELEVATIONS - BUILDING A

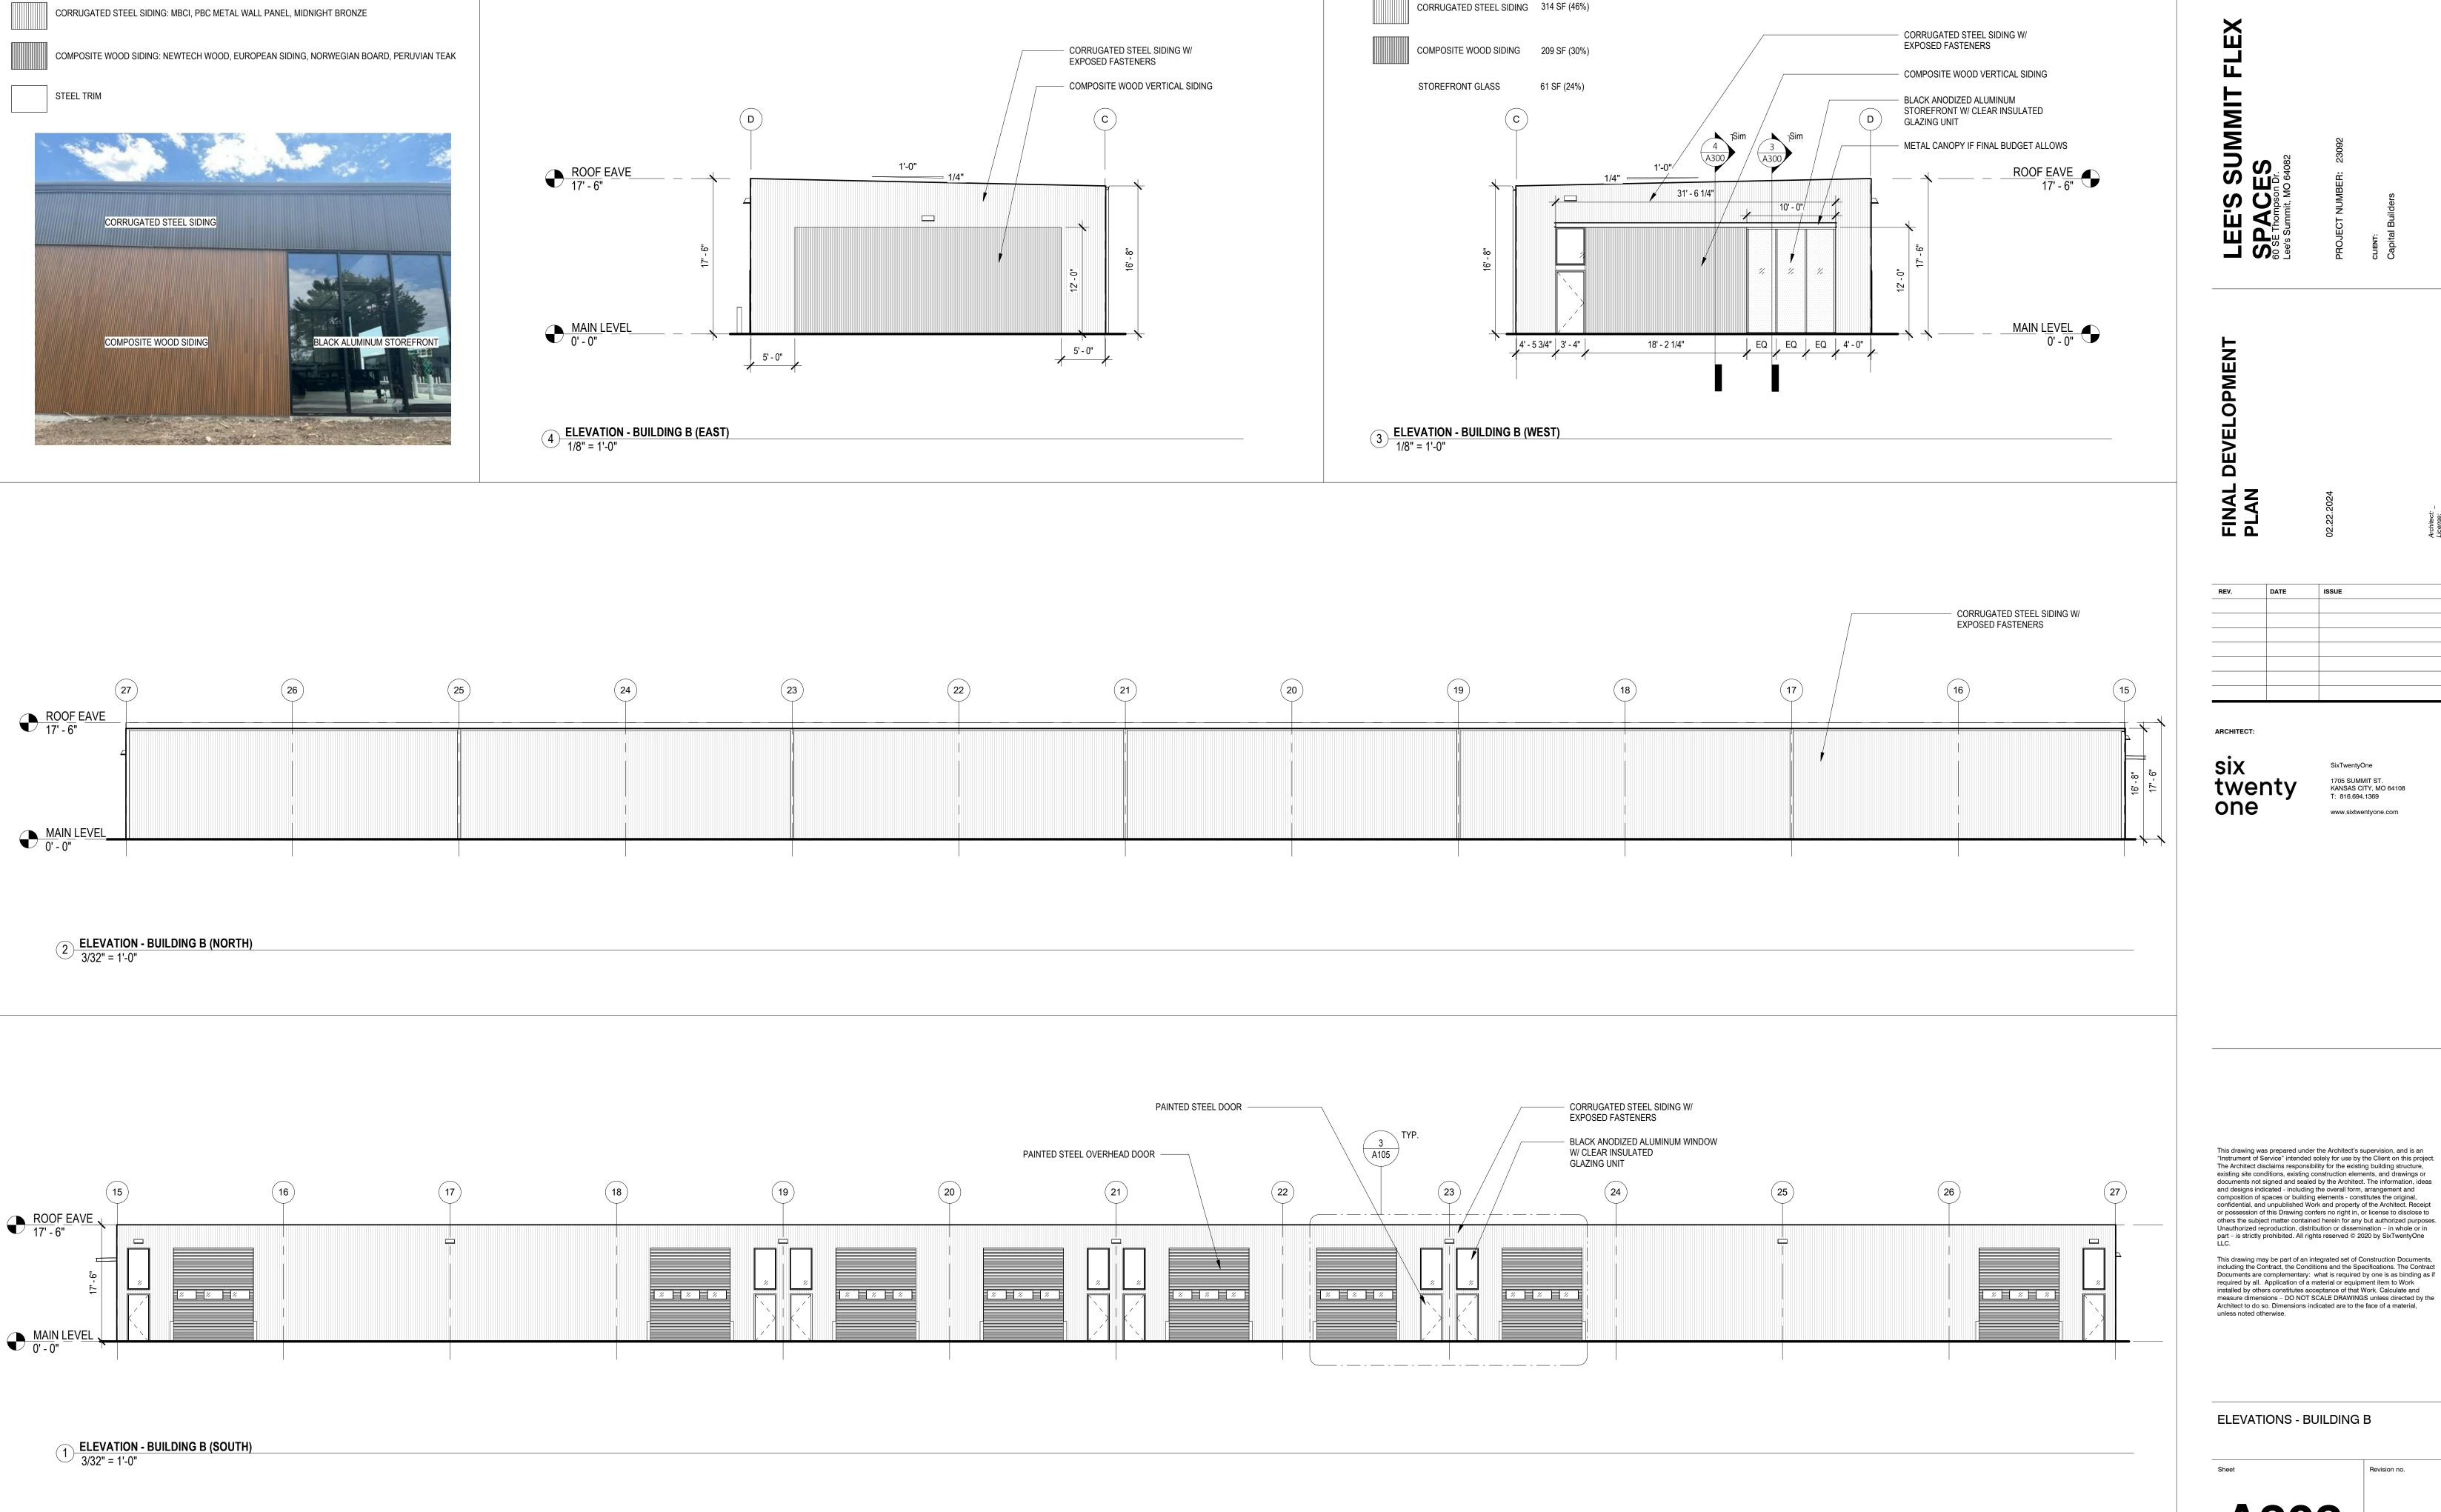

TOTAL WALL AREA: 683 SF


or possession of this Drawing confers no right in, or license to disclose to others the subject matter contained herein for any but authorized purposes.

Unauthorized reproduction, distribution or dissemination – in whole or in part – is strictly prohibited. All rights reserved © 2020 by SixTwentyOne This drawing may be part of an integrated set of Construction Documents, including the Contract, the Conditions and the Specifications. The Contract Documents are complementary: what is required by one is as binding as if required by all. Application of a material or equipment item to Work installed by others constitutes acceptance of that Work. Calculate and measure dimensions – DO NOT SCALE DRAWINGS unless directed by the Architect to do so. Dimensions indicated are to the face of a material, unless noted otherwise.

T: 816.694.1369

www.sixtwentyone.com

ELEVATIONS - BUILDING B

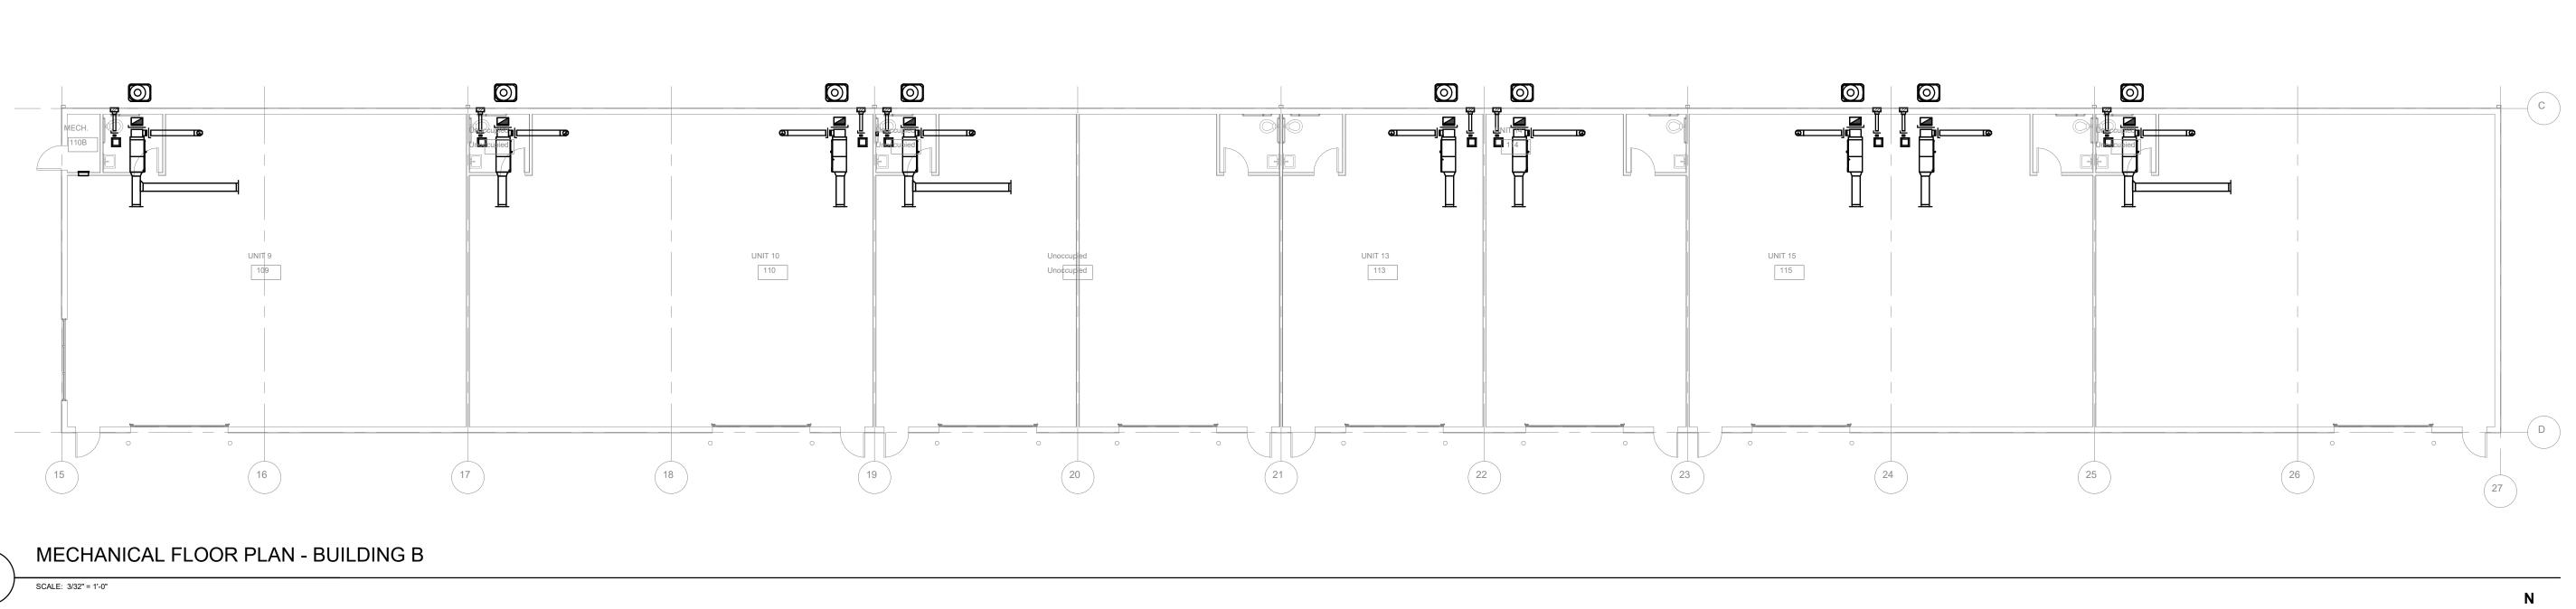

◯ KEYED NOTES

GENERAL NOTES

REPLACE THIS NOTE WITH YOUR SHEET SPECIFIC GENERAL NOTES KEEPING THE SAME FORMAT, WIDTH AND POSITION. DELETE THIS NOTE AND TITLE IF YOU DO NOT HAVE ANY NOTES.

UNIT 6 UNIT 2 UNIT 5 UNIT 7

FLEX SPACES

six twenty one twenty one


CICARVER

4701 Northshore Dr, North Little Rock, AR 72118
501-376-3633
www.garverusa.com

MECHANICAL FLOOR PLANS

M101

MECHANICAL FLOOR PLAN - BUILDING A

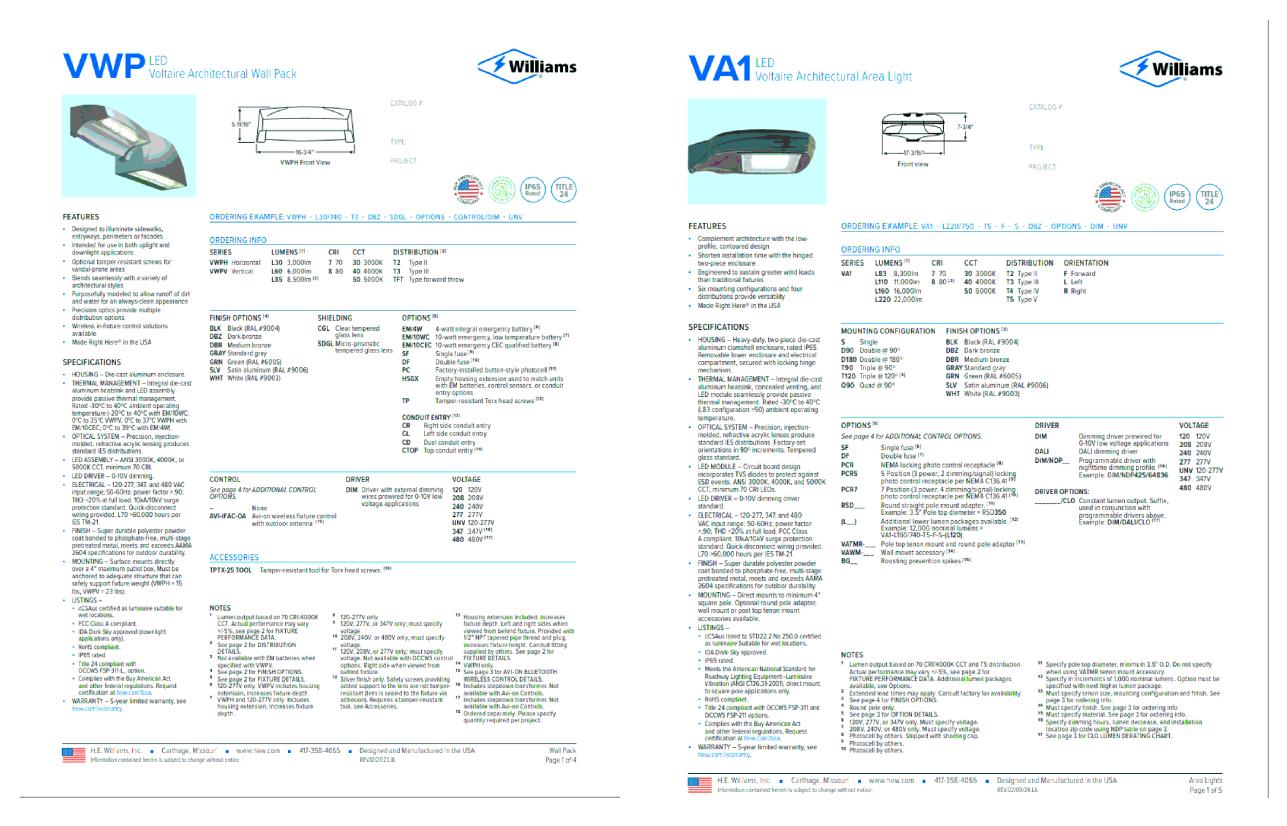

GENERAL NOTES

1. THIS PHOTOMETRIC LAYOUT WAS PRODUCED IN ACCORDANCE WITH THE CITY OF LEE'S SUMMIT, MO UNIFIED DEVELOPMENT ORDINANCE ARTICLE 8, DIVISION I, SUBDIVISION 5 - "LIGHTING STANDARDS". ALL INSTALLATIONS RESULTING FROM THIS DEVELOPMENT PLAN SHALL BE COMPLETED ACCORDING TO THE REQUIREMENTS IN THE LEE'S SUMMIT, MO UNIFIED DEVELOPMENT ORDINANCE AND ANY APPLICABLE SUPPLEMENTS.

© 2023 KIMLEY-HORN AND ASSOCIATES, INC.
805 PENNSYLVANIA AVENUE, SUITE 150
KANSAS CITY, MO 64105
PHONE: 816-652-0350

DESIGNED BY: WPM
© 2023 KIN
805 PENN
KANSAS (PHONE: 8

WESLEY BY MORRIS

NUMBER
PE-2019041526

02,22,2024

5AKVEK, LLC 701 NORTHSHORE DRIVE IORTH LITTLE ROCK, ARKANSAS 72118 101-376-3633 ww.GarverUSA.com

ATIONS

EX SPACE

O SE THOMPSON DR

ORIGINAL ISSUE: 2/22/2024 KHA PROJECT NO.

268442000 SHEET NUMBER

E001


Luminaire Schedule

 
CALCULATION SUMMARY & LUMINAIRE SCHEDULE
SCALE: N/A

LLF Luminaire Luminaire

2 LIGHTING FIXTURE SPECIFICATIONS

SCALE: N/A

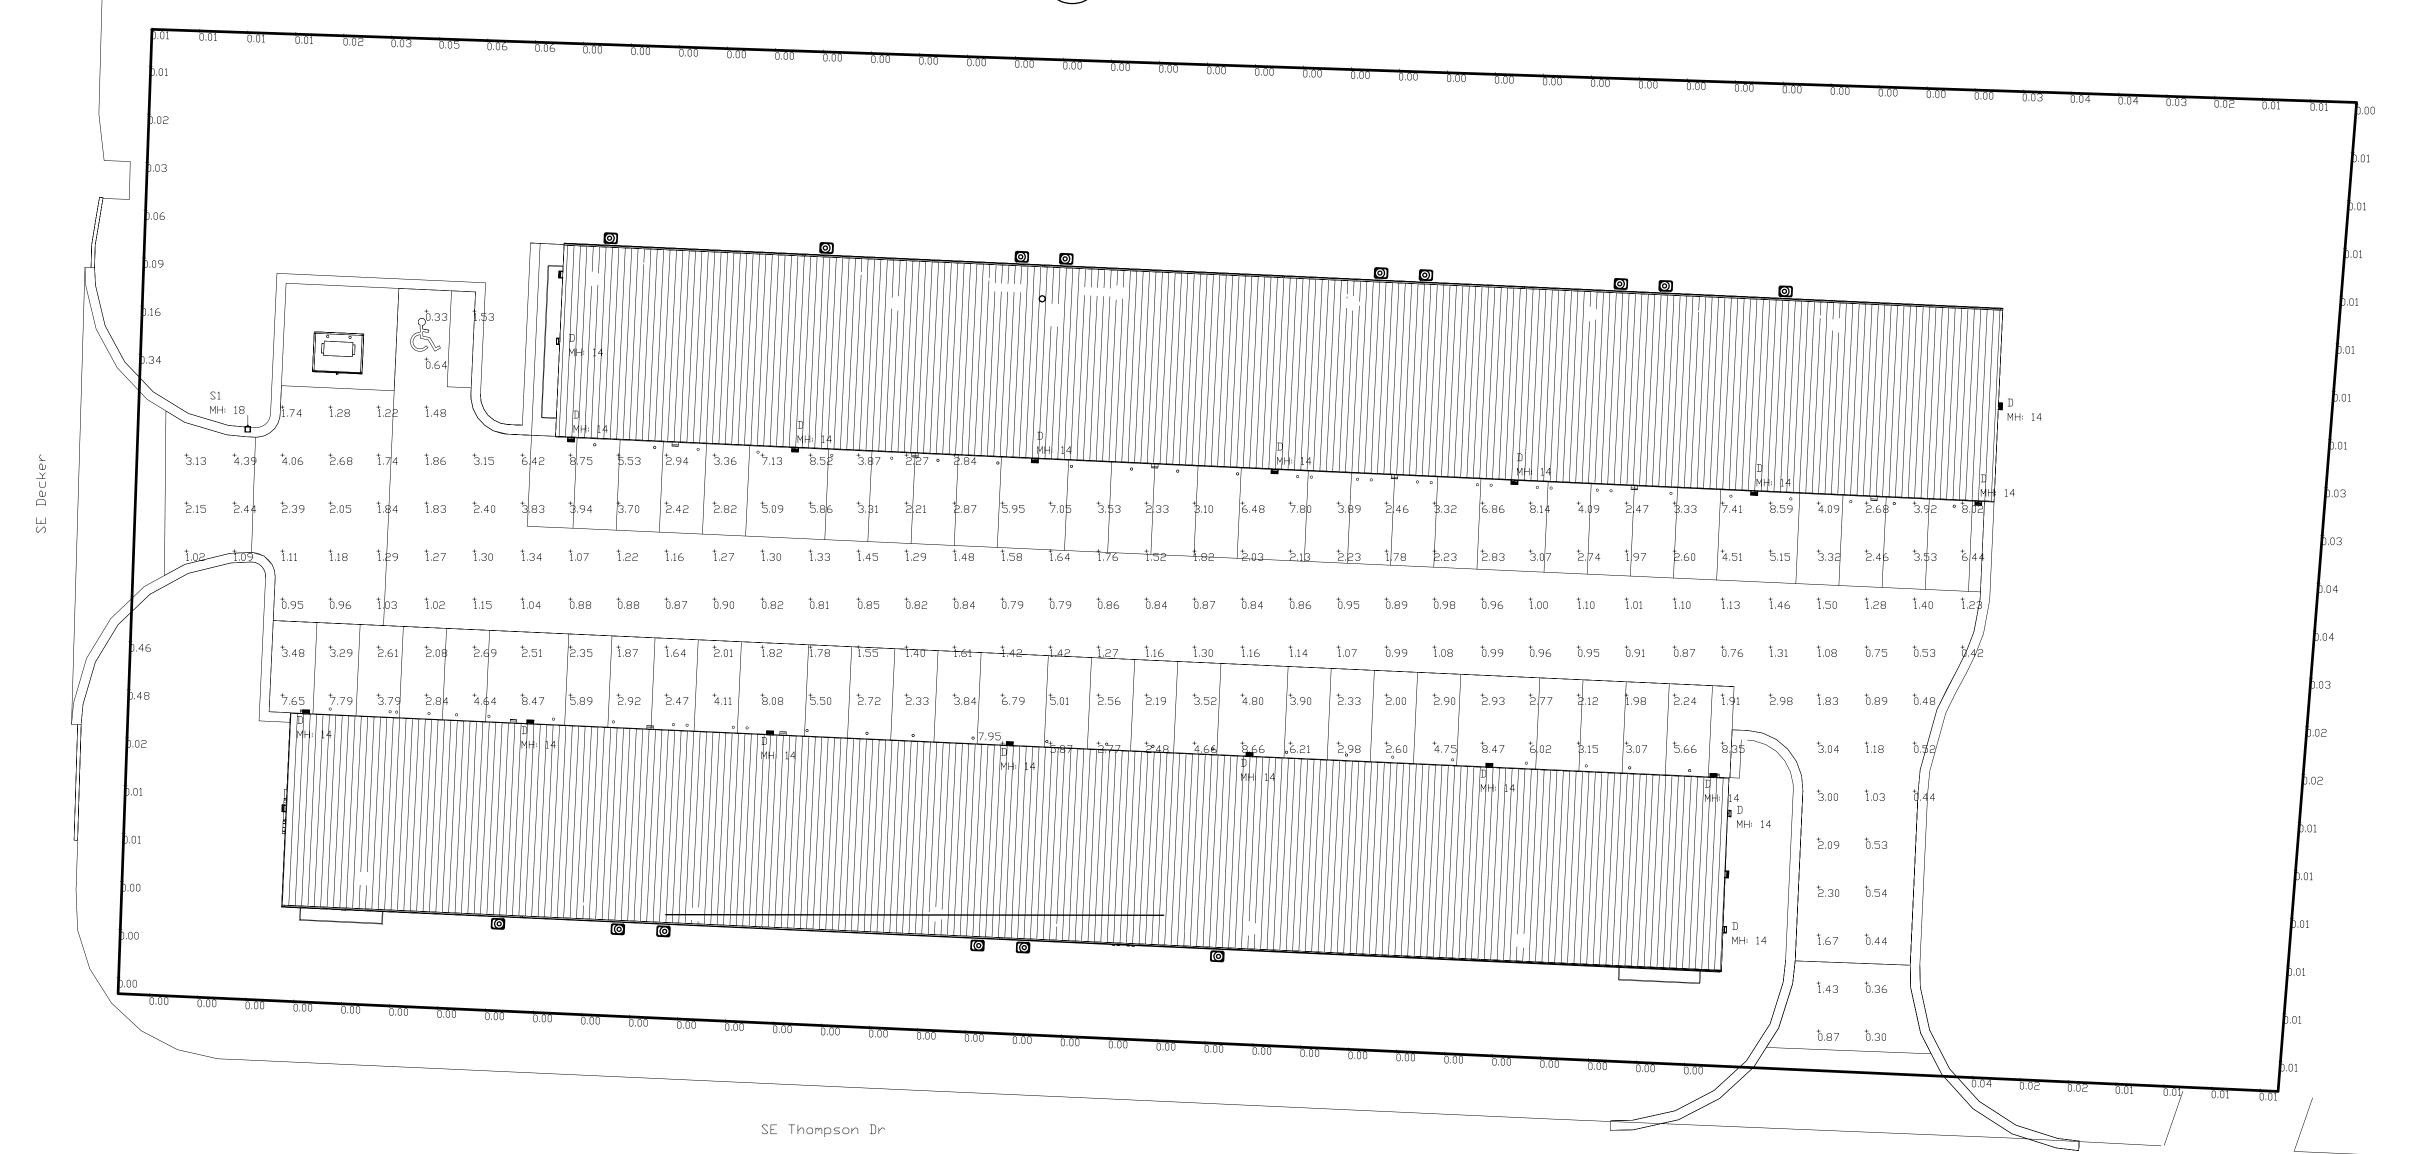



SITE PHOTOMETRIC PLAN

SCALE: 1" = 20'-0"