FINAL DEVELOPMENT PLAN FOR

LEE'S SUMMIT FLEX SPACE 60 SE THOMPSON DR.

PROJECT TEAM

TEL: (816) 609-8633

OWNER:
CAPITAL BUILDERS
1507 NE WALL ST.
LEE'S SUMMIT, MO. 64086
CONTACT: MATT HENDRICKSON
EMAIL: MATT@CAPITALBUILDERSKC.COM

CIVIL ENGINEER:

KIMLEY-HORN AND ASSOCIATES, INC.
805 PENNSYLVANIA AVE. SUITE 150,
KANSAS CITY, MO 64105
CONTACT: PATRICK JOYCE, P.E.
TEL: (785) 550-8994

ARCHITECT:
SIXTWENTYONE
1705 SUMMIT ST.
KANSAS CITY, MO 64108

CONTACT: JACOB LITTRELL, RA, LEED AP BD+C TEL: (816) 694-1369
EMAIL: JACOB@SIXTWENTYONE.COM

LANDSCAPE:
LANDWORKS STUDIO
102 S CHERRY ST.
OLATHE, KS 66061
CONTACT: ERICA FLAD, PLA, LEED GA
TEL: (913) 780-6707

EMAIL: ERICA@LANDWORKSSTUDIO.COM

UTILITY AND GOVERNING AGENCY CONTACTS

SANITARY & WATER:
CITY OF LEE'S SUMMIT
JEFF THORN
1200 SE HAMBLEN RD.
LEE'S SUMMIT, MO 64081

STREETS:
CITY OF LEE'S SUMMIT
MICHAEL PARK
220 SE GREEN ST.
LEE'S SUMMIT, MO 64063
TEL: (8160 969-1800

TEL: (816) 969-1900

TEL: (816) 347-4320

EVERGY:
DOUG DAVIN
1300 SE HAMBLEN RD.
LEE'S SUMMIT, MO 64081

STORMWATER:
CITY OF LEE'S SUMMIT
PUBLIC WORKS
220 SE GREEN ST.
LEE'S SUMMIT, MISSOURI 64063

AT&T:
RONALD GIPFERT
500 E 8TH ST.
KANSAS CITY, MO 64106

TEL: (816) 275-1550

TEL: (816) 969-1800

MISSOURI GAS ENERGY:
RICHARD FROCK
3025 SW CLOVER DR.
LEE'S SUMMIT, MO 64082
TEL: (816) 472-3489

CITY OF LEE'S SUMMIT, JACKSON COUNTY, MISSOURI NW $\frac{1}{4}$, SECTION S17, TOWNSHIP 47N, RANGE 31W

GENERAL NOTES:

- 1. THE CONSTRUCTION COVERED BY THESE PLANS SHALL CONFORM TO ALL APPLICABLE STANDARDS AND SPECIFICATIONS OF THE PUBLIC WORKS DEPARTMENT OF THE CITY OF LEE'S SUMMIT, MISSOURI, IN ALL USAGE AND ALL SUPPLEMENTS THERE TO.
- 2. CONTRACTOR IS RESPONSIBLE FOR ALL PERMITS, BONDS, AND INSURANCE REQUIRED BY THE CITY.
- THE IMPROVEMENTS SHOWN ON THIS PLAN ARE PRIVATE IMPROVEMENTS. COORDINATE WITH CITY FOR REQUIRED PERMITS. BONDS AND INSURANCE.
- LALL WORKMANSHIP AND MATERIALS SHALL BE SUBJECT TO THE INSPECTION AND APPROVAL OF THE ENGINEERING DEPARTMENT OF THE CITY OF LEE'S SUMMIT, MISSOURI.
- 5. THE UTILITY LOCATIONS SHOWN ON THESE PLANS ARE TAKEN FROM UTILITY COMPANY RECORDS AND ARE APPROXIMATE ONLY. THEY DO NOT CONSTITUTE ACTUAL FIELD LOCATIONS. THE CONTRACTOR SHALL VERIFY THE LOCATION AND DEPTH OF ALL UTILITIES PRIOR TO CONSTRUCTION.
- 6. THE DEVELOPER/OWNER SHALL CONTROL EROSION AND SILTATION DURING ALL PHASES OF CONSTRUCTION, AND SHALL KEEP THE STREETS CLEAN OF MUD AND DEBRIS.
- 7. ALL EXCESS MATERIAL SHALL BE REMOVED LEGALLY FROM SITE AND DISPOSED OF OFF SITE.
- 8. TRAFFIC CONTROL AND MAINTENANCE OF TRAFFIC DURING CONSTRUCTION SHALL BE THE RESPONSIBILITY OF THE CONTRACTOR AND SHALL BE IN ACCORDANCE WITH THE REQUIREMENTS OF THE PUBLIC WORKS DEPARTMENT AND MUTCD.
- 9. EROSION CONTROL MEASURES SHALL BE PROVIDED AT ALL LOCATIONS WHERE DRAINAGE IS LEAVING THE PROJECT SITE. THE EROSION CONTROL PLAN SHOWS MINIMUM EROSION CONTROL MEASURES TO BE PROVIDED. ADDITIONAL SITE SPECIFIC MEASURES MAY BE NECESSARY AND SHALL BE PROVIDED BY THE DEVELOPER/OWNER, AT TH CONTRACTOR'S EXPENSE.
- 10. ANY EXISTING OR NEW STORM SEWER INLETS IN USE DURING DEMOLITION, GRADING OR CONSTRUCTION SHALL HAVE INLET PROTECTION AS SPECIFIED.

HISTORIC INFORMATION

THIS STRUCTURE IS NOT LISTED IN THE NATIONAL REGISTER OF HISTORIC PLACES.

THIS SITE IS NOT LOCATED IN A LOCAL HISTORIC DISTRICT PER THE MISSOURI DEPARTMENT OF NATURAL RESOURCES HISTORIC DISTRICTS AND SITES DATABASE, ACCESSED JUNE 27, 2023.

FEMA INFORMATION

THIS SITE IS LOCATED WITHIN ZONE X PER FEMA FIRM MAPS 29095C0438G: EFFECTIVE DATE JANUARY 20, 2017. NO LETTERS OF MAP AMENDMENT OR REVISION ARE BEING PROPOSED.

LEGAL DESCRIPTION

2. KANSAS CITY METRO APWA

LOT 3A, DECKER STREET MINOR PLAT, LOTS 2A AND 3A, A SUBDIVISION IN LEE'S SUMMIT, JACKSON COUNTY, MISSOURI, ACCORDING TO THE PLAT RECORDED AUGUST 6, 2021.

PROJECT SPECIFICATIONS

THE SPECIFICATIONS FOR THIS PROJECT SHALL BE THE FOLLOWING:

1. THE CITY OF LEE'S SUMMIT, MISSOURI

THE STANDARD SPECIFICATIONS THROUGH AND INCLUDING THE LATEST AMENDMENTS SHALL BE PART OF THESE PROJECT DRAWINGS AND SPECIFICATION AND ARE INCORPORATED HEREIN BY REFERENCE. THE MORE STRINGENT OF THESE STANDARD SPECIFICATIONS AND THOSE PREPARED BY THE ENGINEERING PREPARING THESE PLANS SHALL GOVERN.

OIL AND GAS WELL NOTES

NO ABANDONED OIL OR GAS WELLS HAVE BEEN IDENTIFIED WITHIN THE PROPERTY LIMITS OF THE PROPOSED CONSTRUCITON ACTIVITIES, PER THE MISSOURI DEPARTMENT OF NATURAL RESOURCES (MDNR) PERMITTED OIL AND GAS DATABASE, ACCESSED JUNE 27, 2023.

FIRE CODE

ALL ISSUES OERTAINING TO LIFE, SAFETY, AND PROPERTY PROTECTION FROM THE HAZARDS OF FIRE, EXPLOSION OR DANGEROUS CONDITIONS IN NEW AND EXISTING BUILDINGS, STRUCTURES AND PREMISES, AND TO THE SAFETY TO FIRE FIGHTERS AND EMERGENCY RESPONDERS DURING EMERGENCY OPERATIONS, SHALL BE IN ACCORDANCE WITH THE 2018 INTERNATIONAL FIRE CODE.

APPROXIMATE TOTAL ACREAGE: 2.13 AC LIMITS OF DISTURBANCE: 1.81 AC

WATERSHED: BIG CREEK



LOCATION MAP



T	YPICAL LEGEND
	PROPOSED STANDARD DUTY ASPHALT PAVEMENT
A A A A	PROPOSED HEAVY DUTY CONCRETE PAVEMENT
	PROPOSED BUILDING
	EXISTING PUBLIC ROADWAY
	EXISTING 60' STREAM BUFFER
	PROPERTY LINE
	PROPOSED BUILDING OUTLINE
	EASEMENT LINE
<u> </u>	SETBACK LINE
	STANDARD CURB & GUTTER
SAN	EXISTING SANITARY SEWER
w	EXISTING WATER LINE
—— FO ——	EXISTING FIBER OPTIC
——— G ———	EXISTING GAS
—— Р ——	EXISTING POWER
— т —	EXISTING TELECOMMUNICATIONS
w	PROPOSED WATER LINE
UE	PROPOSED UNDERGROUND ELECTRIC
ss	PROPOSED SANITARY SEWER

	Sheet List Table
Sheet Number	Sheet Title
C001	COVER SHEET
C002	EXISTING CONDITIONS
C003	SITE PLAN
C004	GRADING PLAN
C005	ADA RAMPS
C006	UTILITY & STORMWATER PLAN
C007	STORMWATER PLAN & PROFILE
C008	STORMWATER PLAN & PROFILE
C009	DETAILS
C010	DETAILS
C011	DETAILS
C012	DETAILS
C013	ADS DETAILS
L001	LANDSCAPE PLAN
L002	LANDSCAPE DETAILS
A101	FLOOR PLANS
A201	ELEVATIONS - BUILDING A
A202	ELEVATIONS - BUILDING B
A203	RENDERINGS
A204	TRASH ENCLOSURE PLAN & DETAILS
M101	MECHANICAL FLOOR PLANS
E001	SITE PHOTOMETRICS



DIEYWHORN AND ASSOCIATES, INC.
SYLVANIA AVENUE, SUITE 150
16-652-0350
ILEY-HORN.COM

| ED BY: LLG | © 2023 KIMLEY-HORN AND ASSOCIA 805 PENNSYLVANIA AVENUE, SU KANSAS CITY, MO 64105 PHONE: 816-652-0350

PATRICK I
JOYCE
NUMBER
PE-2009030032

PITAL BUILDER

VER SHEET


LEX SPACE
60 SE THOMPSON DR
'S SUMMIT, MISSOURI 64081


ORIGINAL ISSUE: 3/28/2024 KHA PROJECT NO. 268442000

C001

SHEET NUMBER



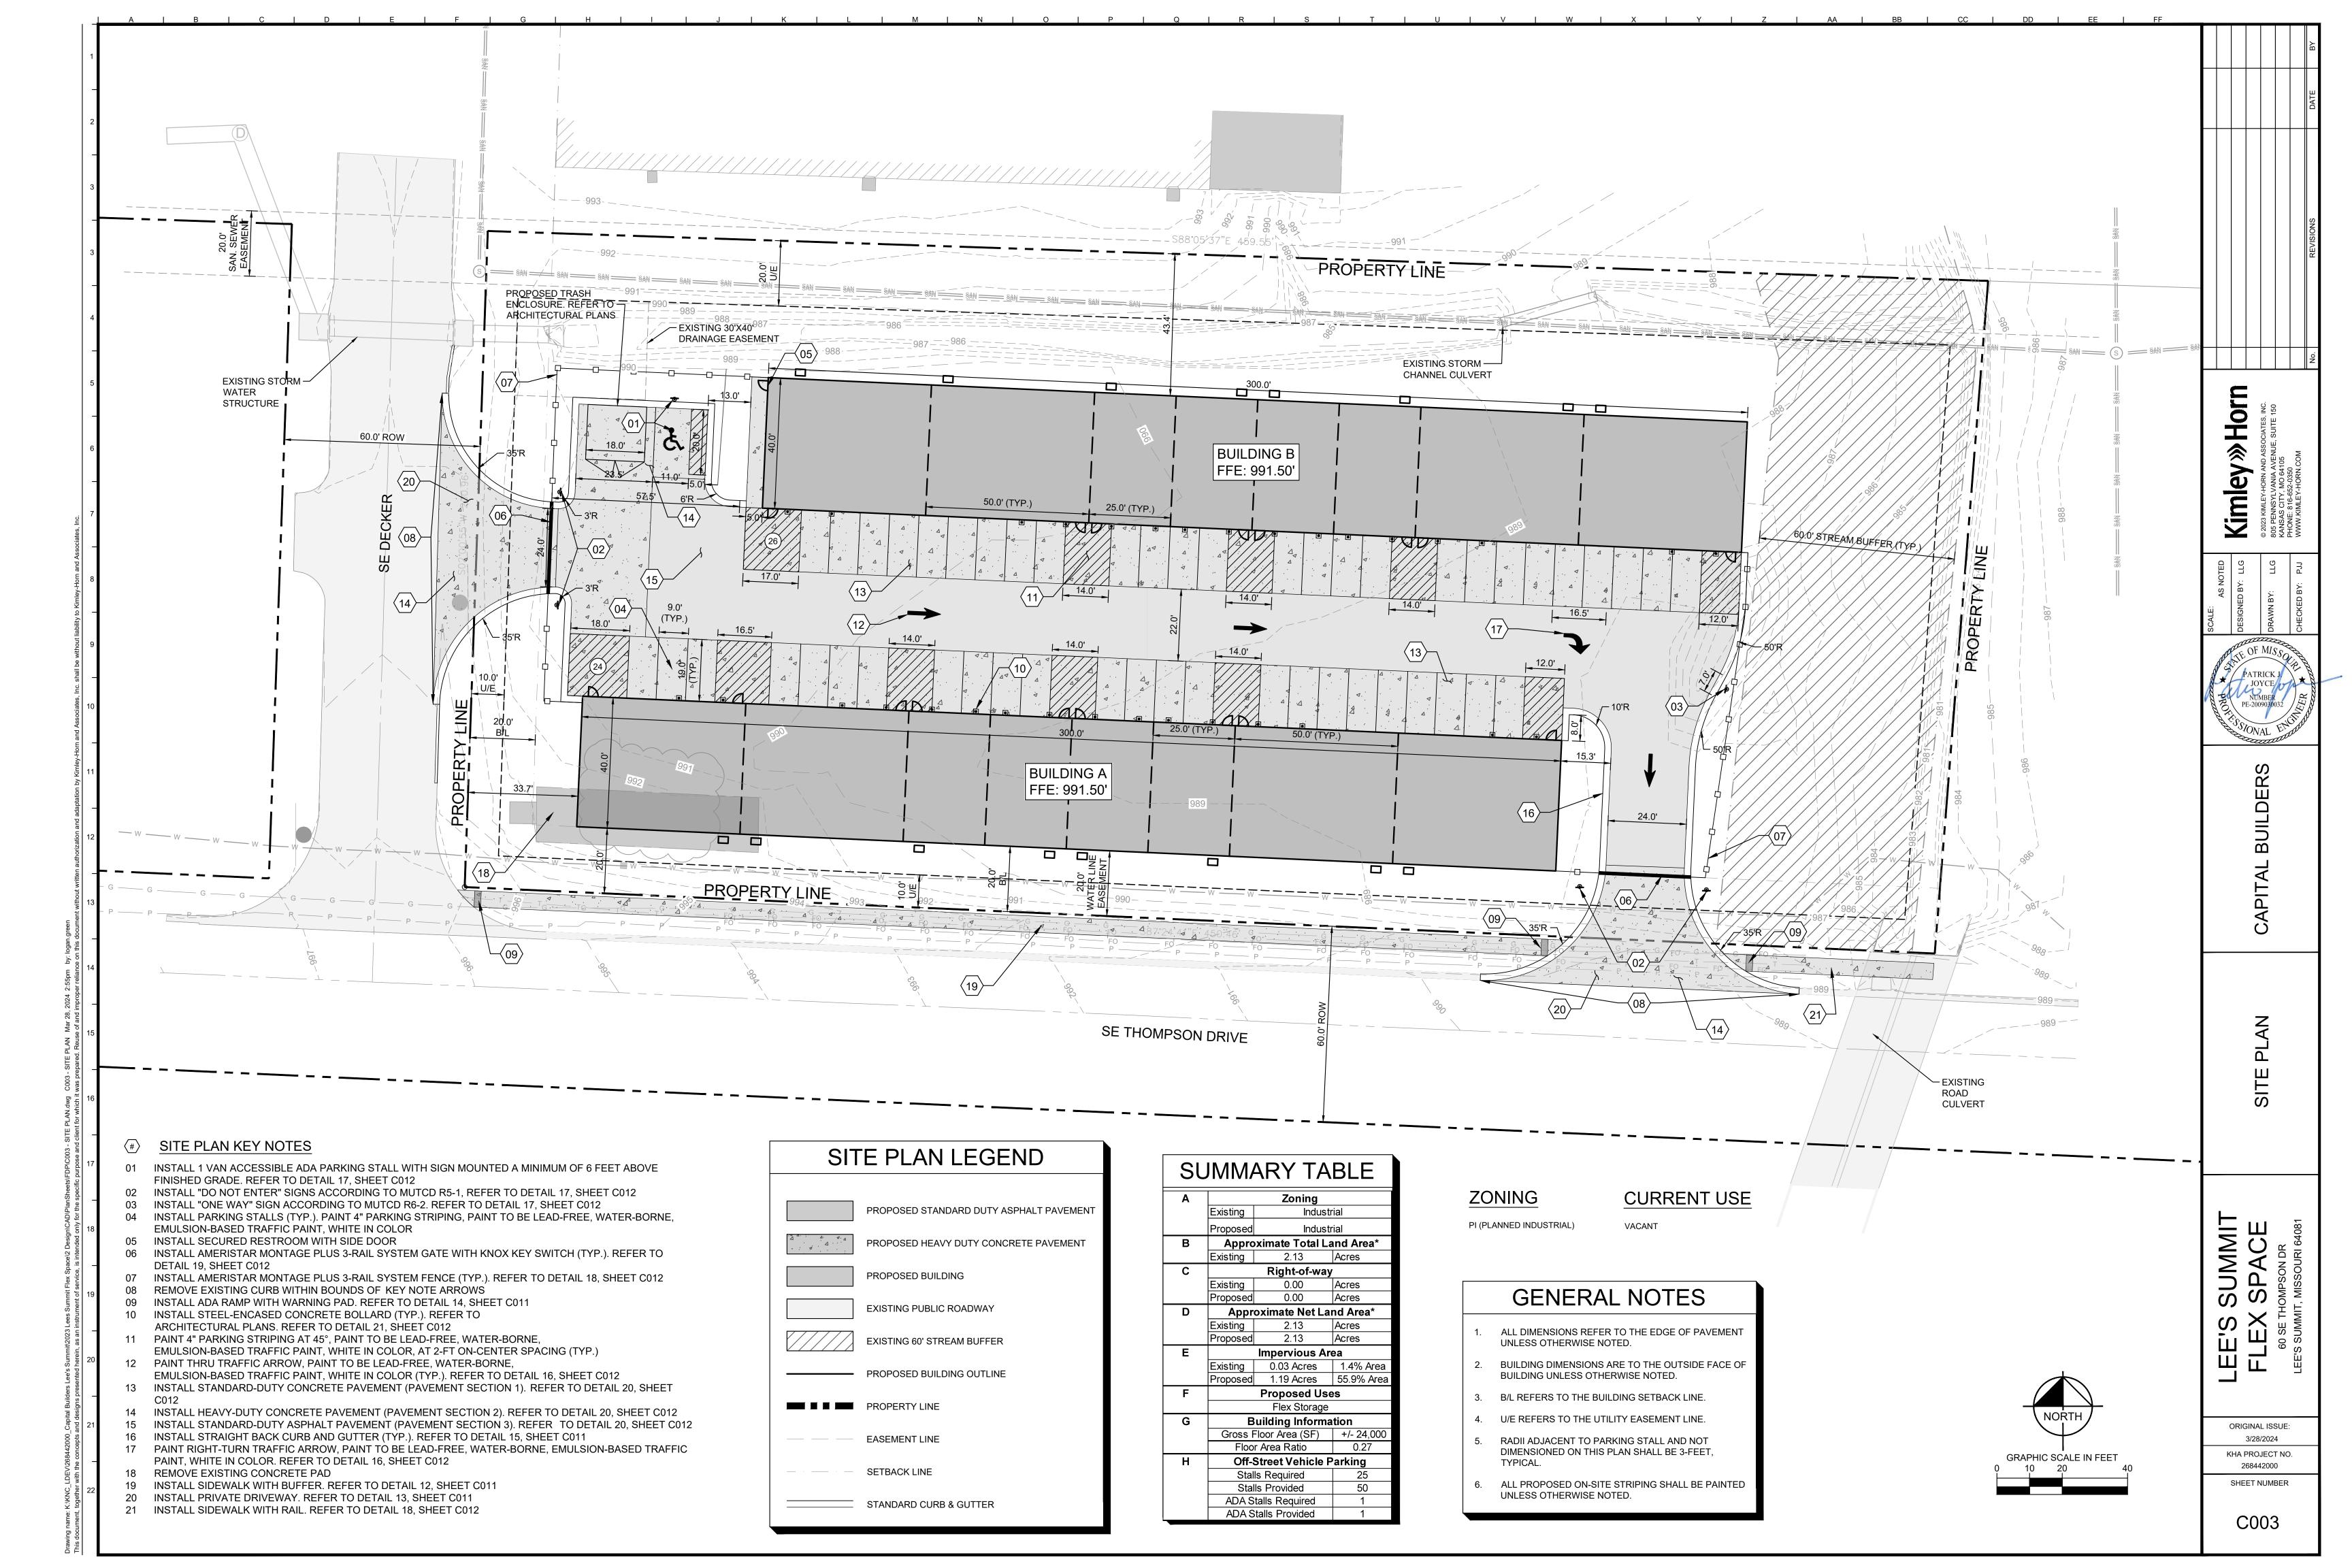

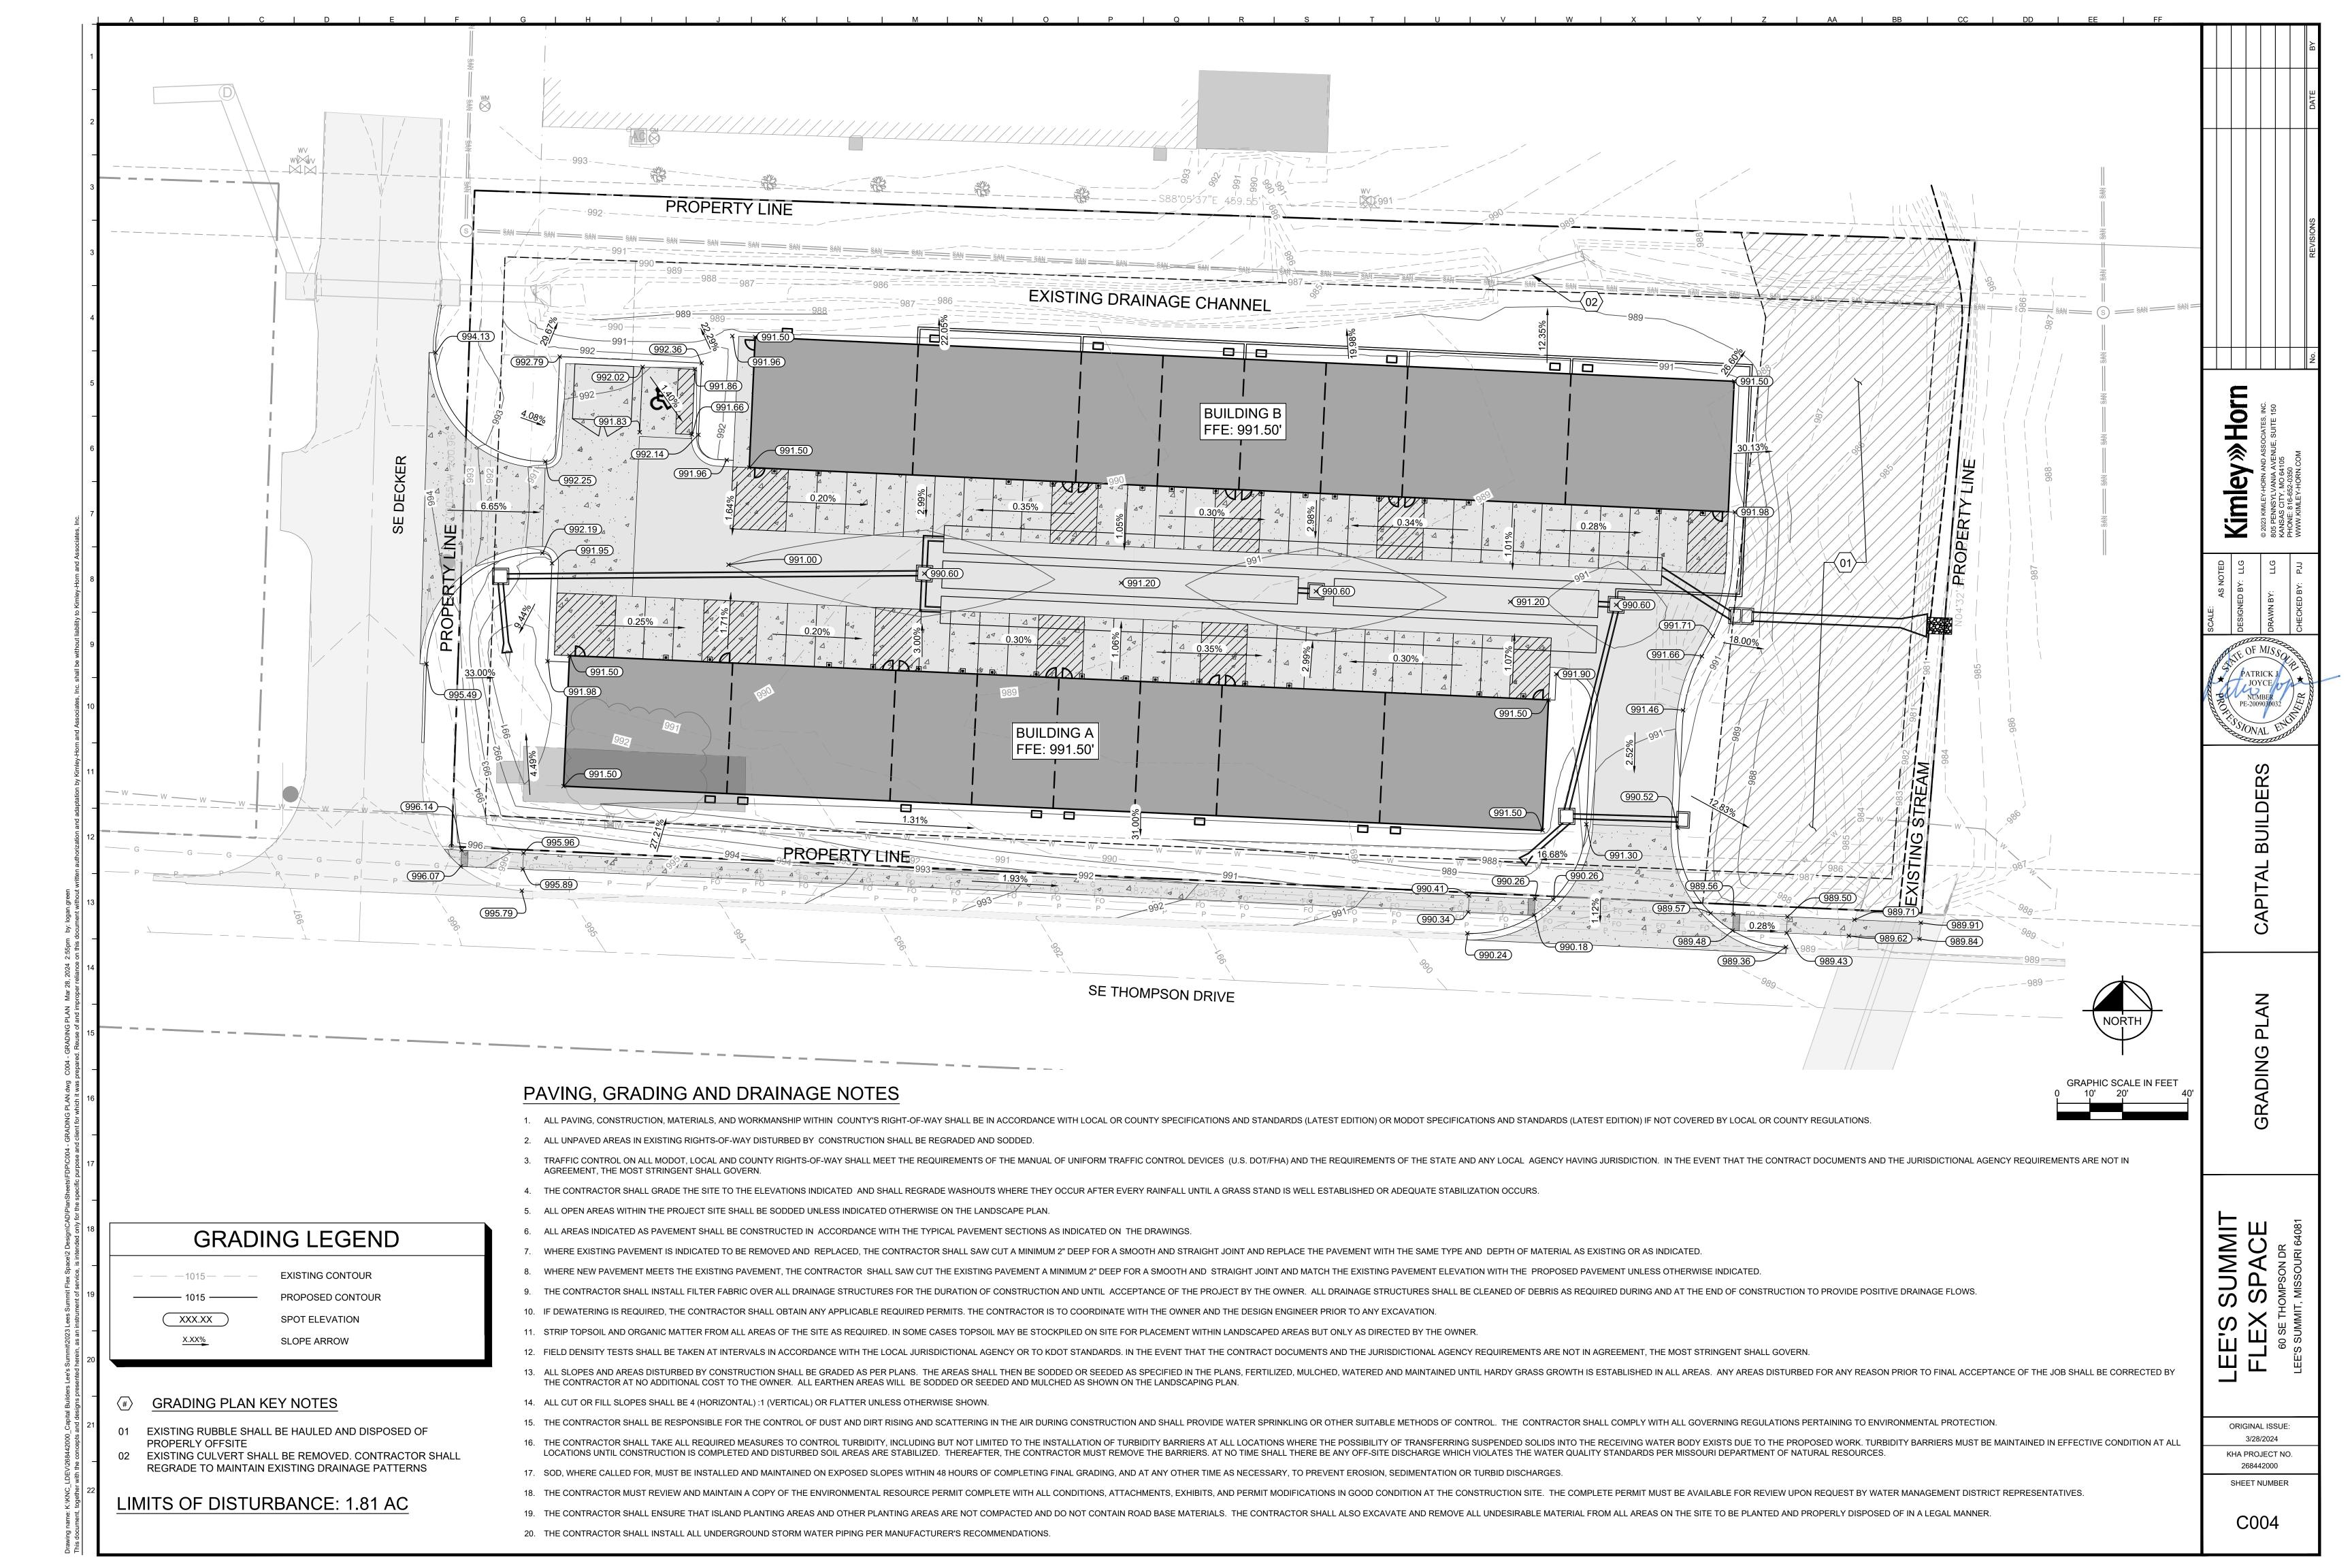

ADA RAMP 1 ADA RAMP 2 **Kimley** » Horn ADA WARNING PAD-990.41 996.14 990.26 ADA WARNING PAD 995.96 1.91% 995.97 0.10% 0.75% 0.97% 1.90% 990.26 SIDEWALK TRANSITION ZONE -SIDEWALK TRANSITION ZONE 990.34 990.18 996.07 995.89 ADA RAMP -ADA RAMP ADA RAMP 3 -ADA WARNING PAD 989.50 989.57 **GRADING LEGEND** 0.30% 1.00% SPOT ELEVATION XXX.XX TRANSITION ZONE SLOPE ARROW

989.48

GRADING PLAN KEY NOTES

01 INSTALL ADA SIDEWALK RAMP WITH WARNING PAD. REFER TO DETAIL 14, SHEET C011

02 INSTALL SIDEWALK WITH BUFFER. REFER TO DETAIL 12, SHEET C011

989.43

ADA RAMP

-SIDEWALK

FLEX SPACE

60 SE THOMPSON DR


EE'S SUMMIT, MISSOURI 64081


ORIGINAL ISSUE:

3/28/2024 KHA PROJECT NO.

268442000 SHEET NUMBER

C005

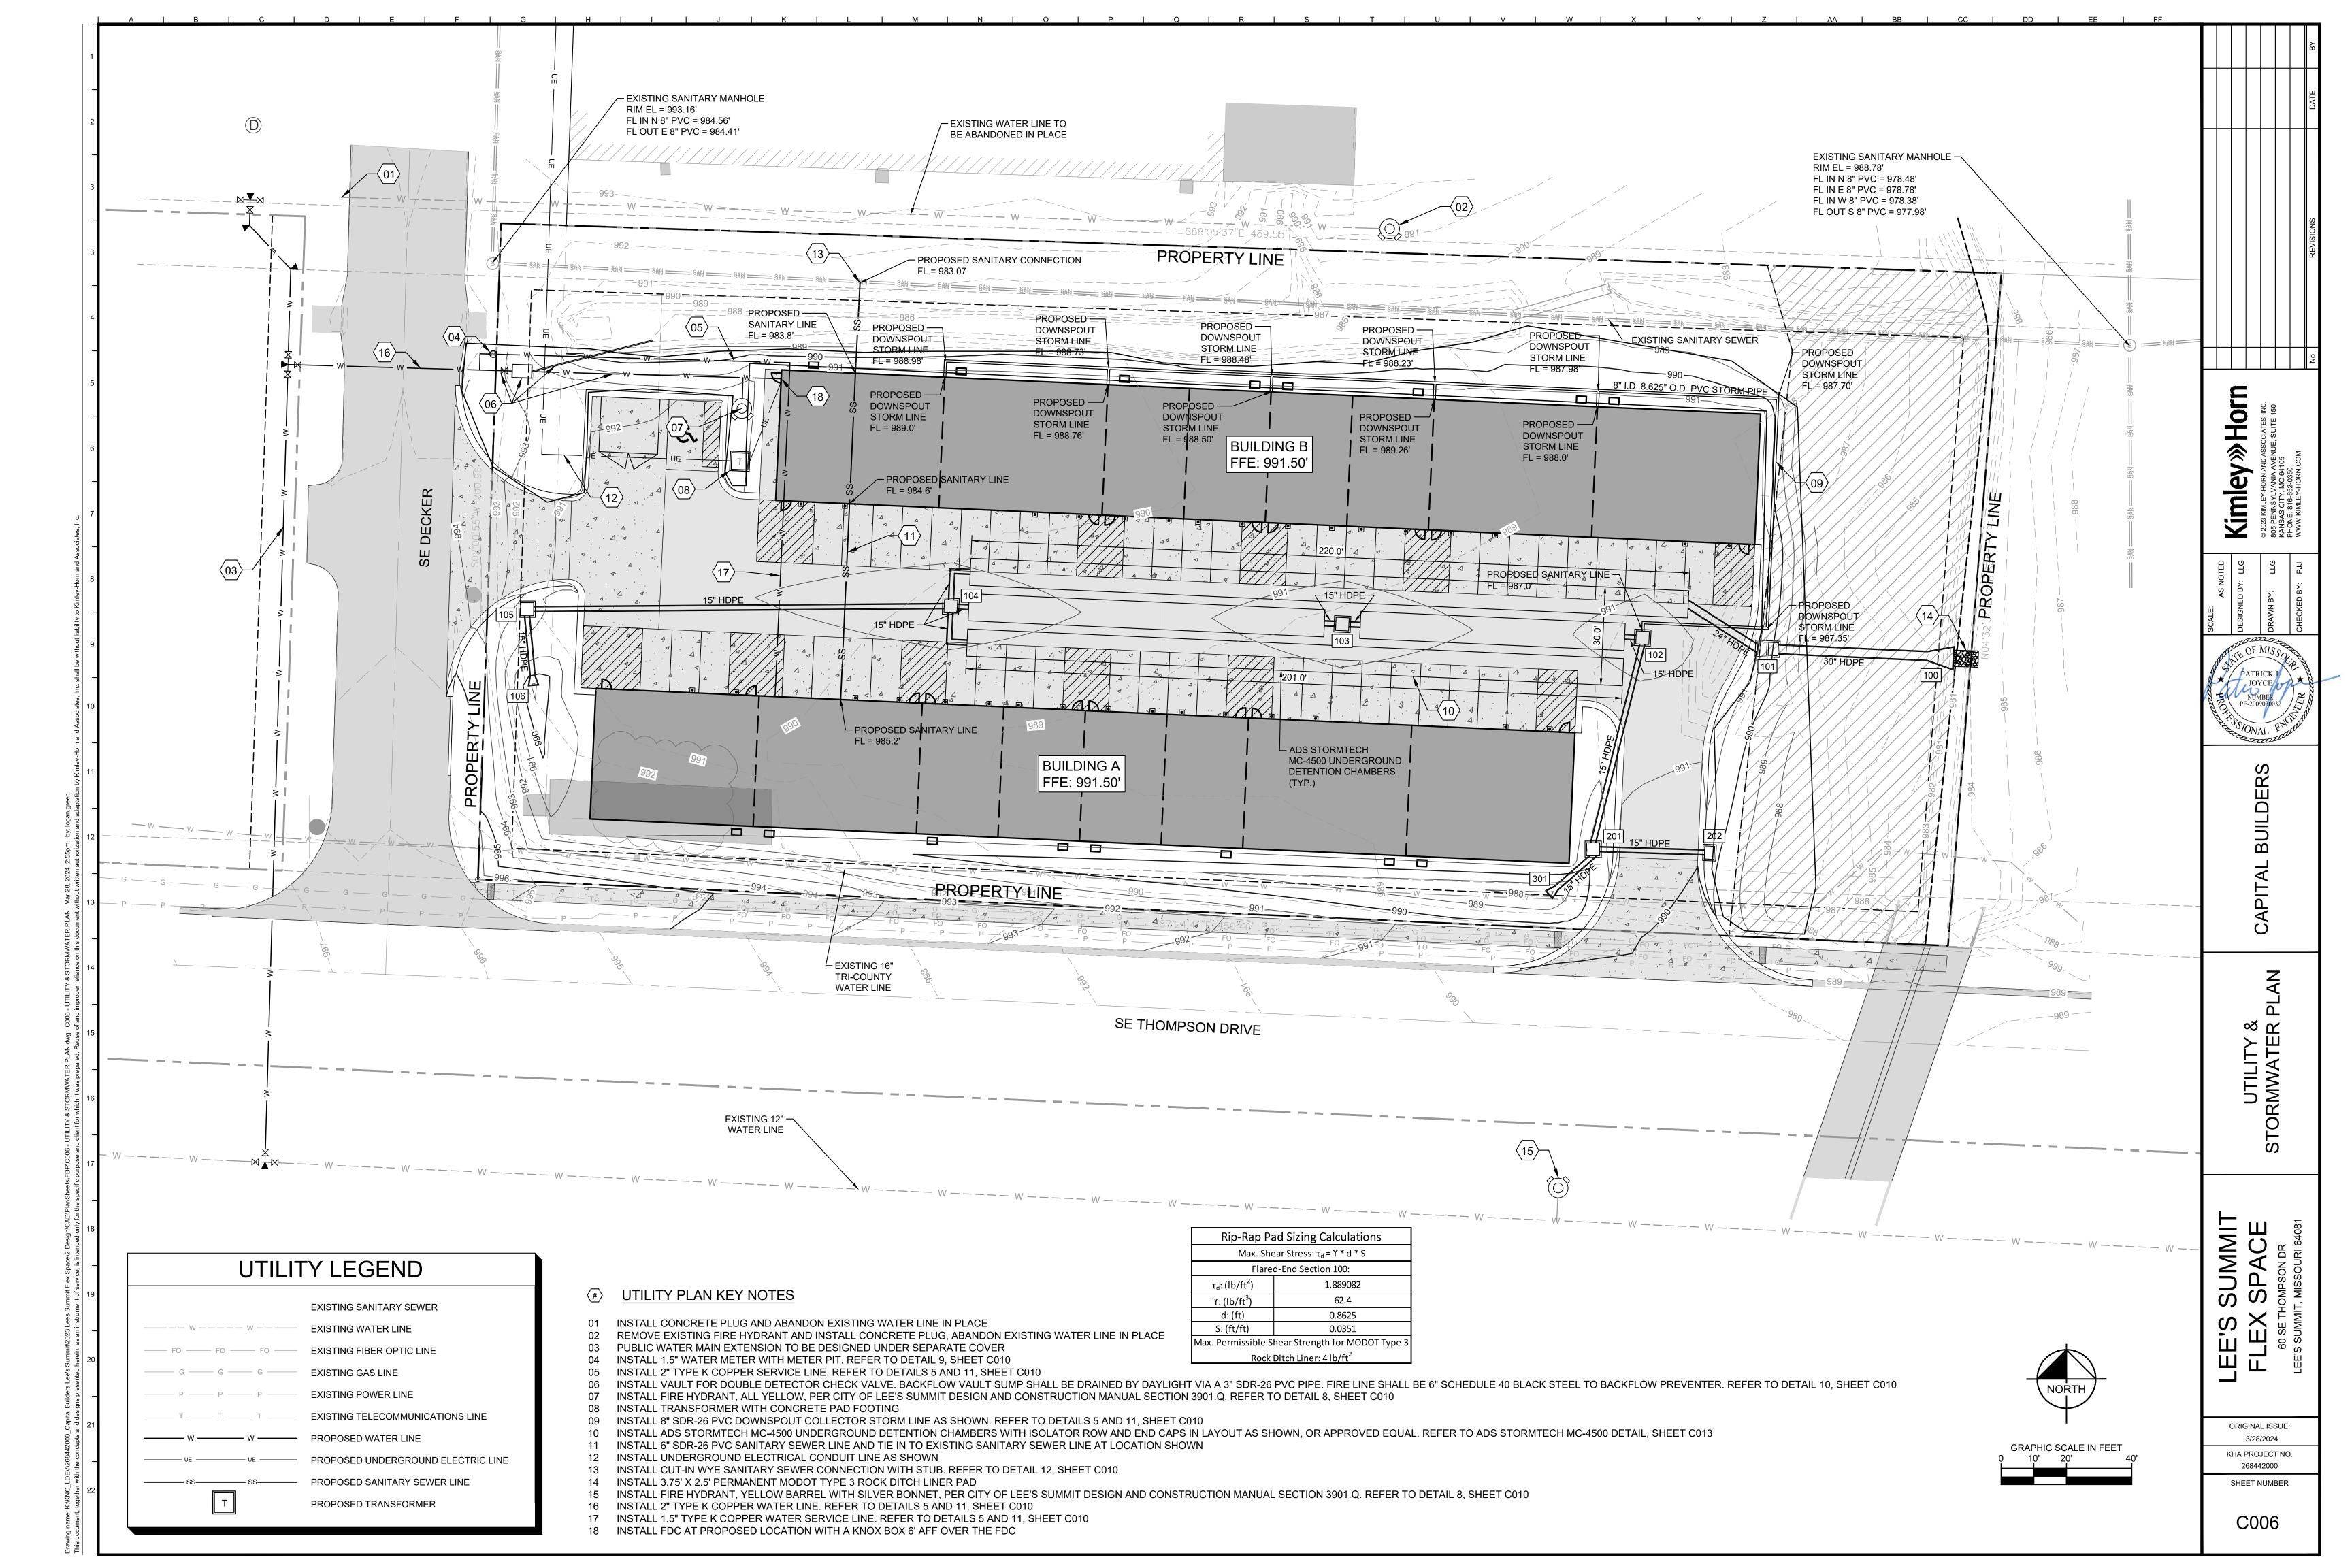

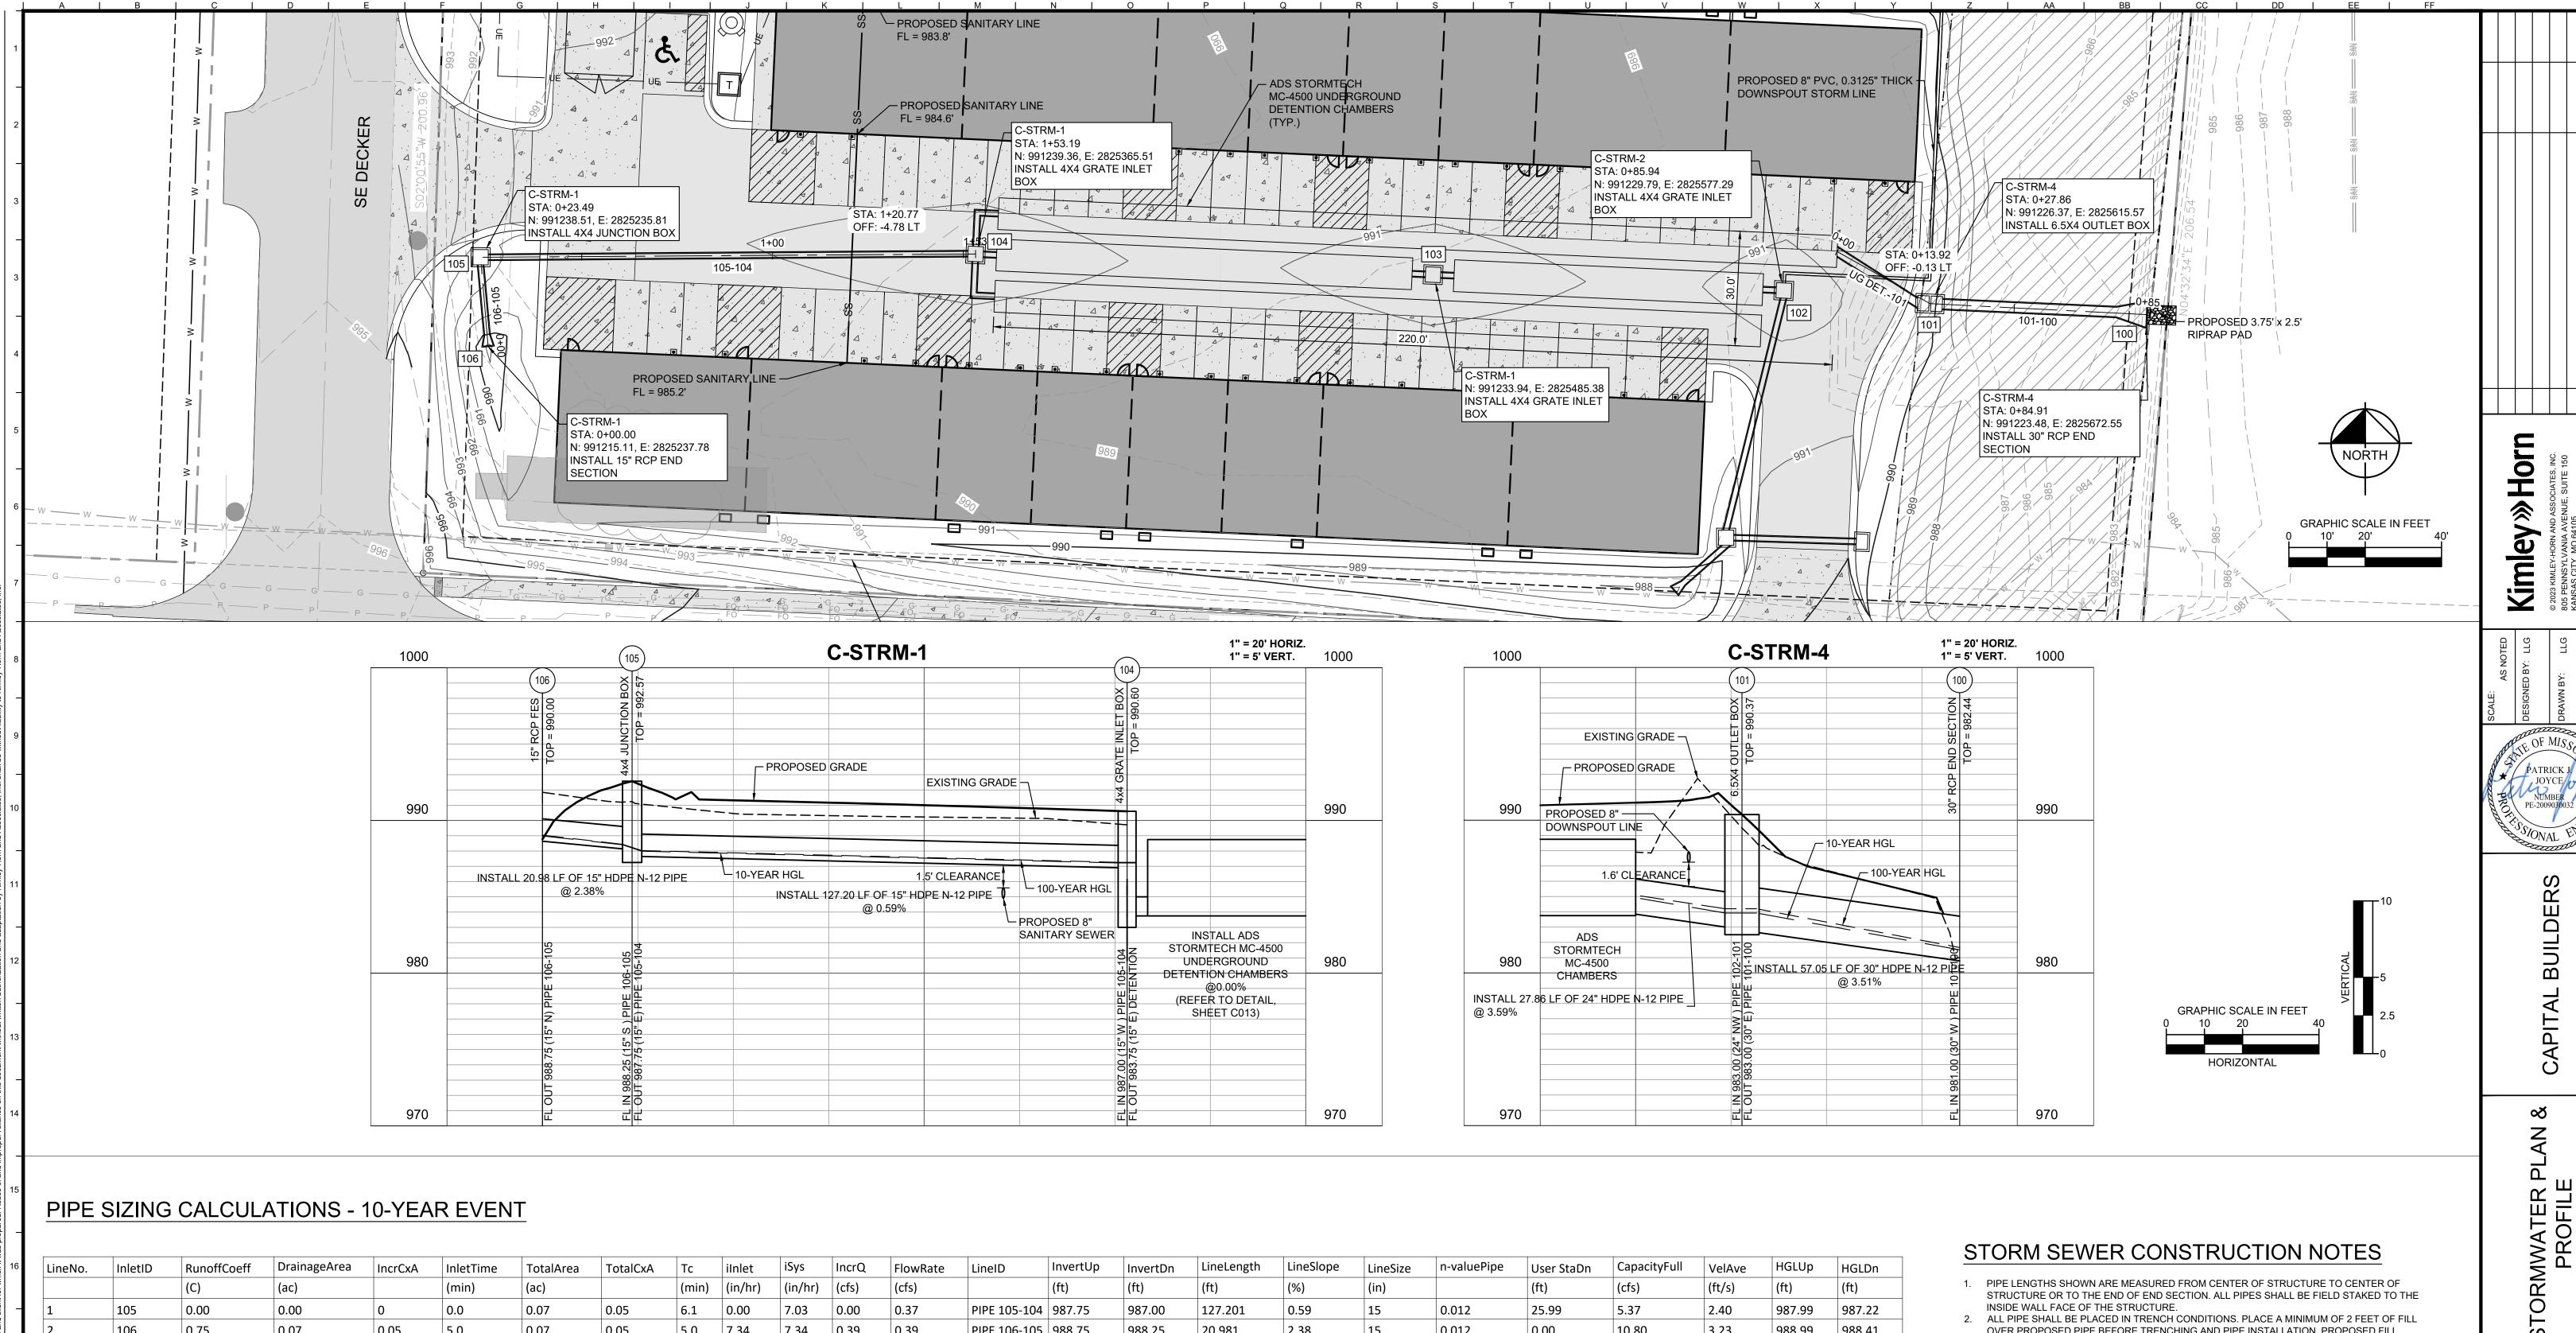

PIPE SIZING CALCULATIONS - 10-YEAR EVENT

LineNo.	InletID	RunoffCoeff	DrainageArea	IncrCxA	InletTime	TotalArea	TotalCxA	Тс	iInlet	iSys	IncrQ	FlowRate	LineID	InvertUp	InvertDn	LineLength	LineSlope	LineSize	n-valuePipe	User StaDn	CapacityFull	VelAve	HGLUp	HGLDn
		(C)	(ac)		(min)	(ac)		(min)	(in/hr)	(in/hr)	(cfs)	(cfs)		(ft)	(ft)	(ft)	(%)	(in)		(ft)	(cfs)	(ft/s)	(ft)	(ft)
1	105	0.00	0.00	0	0.0	0.07	0.05	6.1	0.00	7.03	0.00	0.37	PIPE 105-104	987.75	987.00	127.201	0.59	15	0.012	25.99	5.37	2.40	987.99	987.22
2	106	0.75	0.07	0.05	5.0	0.07	0.05	5.0	7.34	7.34	0.39	0.39	PIPE 106-105	988.75	988.25	20.981	2.38	15	0.012	0.00	10.80	3.23	988.99	988.41
3	201	0.00	0.00	0	0.0	0.30	0.27	7.4	0.00	6.69	0.00	1.82	PIPE 201-102	984.94	983.67	63.923	1.99	15	0.012	22.02	9.88	4.88	985.48	984.03
4	202	0.90	0.26	0.23	5.0	0.26	0.23	5.0	7.34	7.34	1.72	1.72	PIPE 202-201	986.62	986.43	19.454	0.98	15	0.012	0.00	6.91	4.11	987.14	986.86
5	301	0.95	0.04	0.04	5.0	0.04	0.04	5.0	7.34	7.34	0.28	0.28	PIPE 301-201	987.00	986.34	33.104	1.99	15	0.012	0.00	9.88	2.83	987.20	986.48
6	101	0.00	0.00	0	0.0	0.82	0.78	5.2	0.00	7.27	1.62	7.66	PIPE 101-100	983.00	981.00	57.051	3.51	30	0.012	0.00	83.19	7.62	983.92	981.51
7	UG DET.	0.95	0.82	0.78	5.0	0.82	0.78	5.0	7.34	7.34	6.09	6.09	PIPE 102-101	984.00	983.00	27.863	3.59	24	0.012	0.00	46.42	4.48	984.87 j	983.92

PIPE SIZING CALCULATIONS - 100-YEAR EVENT

LineNo	Inlet	tID	RunoffCoeff	DrainageArea	IncrCxA	InletTime	TotalArea	TotalCxA	Тс	iInlet	iSys	IncrQ	FlowRate	LineID	InvertUp	InvertDn	LineLength	LineSlope	LineSize	n-valuePipe	User StaDn	CapacityFull	VelAve	HGLUp	HGLDn
		((C)	(ac)		(min)	(ac)		(min)	(in/hr)	(in/hr)	(cfs)	(cfs)		(ft)	(ft)	(ft)	(%)	(in)		(ft)	(cfs)	(ft/s)	(ft)	(ft)
1	105		0.00	0.00	0	0.0	0.07	0.05	5.8	0.00	10.02	0.00	0.53	PIPE 105-104	987.75	987.00	127.201	0.59	15	0.012	25.99	5.37	2.66	988.03	987.26
1 2	106		0.75	0.07	0.05	5.0	0.07	0.05	5.0	10.32	10.32	0.54	0.54	PIPE 106-105	988.75	988.25	20.981	2.38	15	0.012	0.00	10.80	3.57	989.04	988.44
3	201		0.00	0.00	0	0.0	0.30	0.27	6.7	0.00	9.69	0.00	2.64	PIPE 201-102	984.94	983.67	63.923	1.99	15	0.012	22.02	9.88	5.45	985.59	984.11
4	202		0.90	0.26	0.23	5.0	0.26	0.23	5.0	10.32	10.32	2.41	2.41	PIPE 202-201	986.62	986.43	19.454	0.98	15	0.012	0.00	6.91	4.55	987.24	986.94
5	301		0.95	0.04	0.04	5.0	0.04	0.04	5.0	10.32	10.32	0.39	0.39	PIPE 301-201	987.00	986.34	33.104	1.99	15	0.012	0.00	9.88	3.13	987.24	986.51
6	101		0.00	0.00	0	0.0	0.82	0.78	5.2	0.00	10.25	4.28	12.77	PIPE 101-100	983.00	981.00	57.051	3.51	30	0.012	0.00	83.19	8.87	984.20	981.66
7	UG D	DET.	0.95	0.82	0.78	5.0	0.82	0.78	5.0	10.32	10.32	8.54	8.54	PIPE 102-101	984.00	983.00	27.863	3.59	24	0.012	0.00	46.42	4.75	985.04 j	984.20

STORM SEWER CONSTRUCTION NOTES

1. PIPE LENGTHS SHOWN ARE MEASURED FROM CENTER OF STRUCTURE TO CENTER OF STRUCTURE OR TO THE END OF END SECTION. ALL PIPES SHALL BE FIELD STAKED TO THE INSIDE WALL FACE OF THE STRUCTURE.

2. ALL PIPE SHALL BE PLACED IN TRENCH CONDITIONS. PLACE A MINIMUM OF 2 FEET OF FILL


- OVER PROPOSED PIPE BEFORE TRENCHING AND PIPE INSTALLATION. PROPOSED FILL SHALL BE PLACED IN ACCORDANCE WITH PROJECT REQUIREMENTS. 3. UTILITY LINES AND STRUCTURES IN FILL AREAS BELOW PIPE GRADE SHALL NOT BE
- CONSTRUCTED UNTIL ALL CONSOLIDATION OF THE FILL IS COMPLETE AND SO APPROVED BUY THE ON-SITE GEOTECHNICAL ENGINEER. 4. THE DIMENSIONS FOR ALL STRUCTURES ARE FROM INSIDE FACE OF STRUCTURE TO
- INSIDE FACE OF STRUCTURE. 5. STORM SEWER PIPE SHALL BE AS FOLLOWS UNLESS OTHERWISE NOTED:
- A) REINFORCED CONCRETE PIPE (RCP), CLASS III PER ASTM C-76, WITH "O-RING" OR SINGLE OFFSET RUBBER GASKETED JOINT (TYLOX SUPERSEAL OR AN APPROVED EQUAL).
- 6. ALL REINFORCING STEEL SHALL COMPLY WITH ASTM-615 GRADE 60. 7. ALL CURB INLETS AND OTHER STRUCTURES SET AT LOW POINTS ARE TO BE SET LEVEL. ALL OTHER CURB INLETS ARE TO BE SET WITH THE GRADE OF THE TOP OF CURB OR
- 8. ALL HYDRAULIC GRADE LINES (HGL) SHOWN ARE FOR THE 10 AND 100-YEAR STORM. 9. PRECAST STRUCTURES MAY BE USED AT CONTRACTOR'S OPTION. ALL STORM
- INVERT IN TO INVERT OUT. 10. THE LIDS OF ALL PRECAST STRUCTURES SHALL BE GROUTED TO THE TOP OF THE WALLS. 11. NORTHING AND EASTINGS SHOWN ARE TO CENTER OF STRUCTURE, OR END OF END


STRUCTURES SHALL HAVE A SMOOTH UNIFORM POURED CONCRETE INVERT FROM


- 12. THE FIRST DIMENSION SHOWN IS THE "L" DIMENSION AND THE SECOND IS THE "W" DIMENSION, SEE DETAILS.
- 13. ALL HDPE PIPE SHALL BE IN ADS N-12, OR APPROVED EQUAL, MEETING AASHTO M294, TYPE S OR ASTM F2306. THE PIPE SHALL HAVE A SMOOTH INTERIOR AND ANNULAR EXTERIOR CORRUGATIONS. PIPE JOINTS SHALL BE JOINED USING A BELL & SPIGOT JOINT MEETING AASHTO M252, AASHTO M294, OR ASTM F2306. THE JOINT SHALL BE WATERTIGHT, ACCORDING TO THE REQUIREMENTS OF ASTM D 3212, AND GASKETS SHALL MEET THE REQUIREMENTS OF ASTM F477. GASKETS SHALL BE INSTALLED BY THE PIPE MANUFACTURER AND COVERED WITH A REMOVABLE WRAP TO ENSURE THE GASKET IS FREE FROM DEBRIS. A JOINT LUBRICANT SUPPLIED BUY THE MANUFACTURER SHALL BE USED ON THE GASKET AND BELL DURING ASSEMBLY.
- 14. FITTINGS FOR PLASTIC PIPE SHALL CONFORM TO AASHTO M252, AASHTO M294, OR ASTM F2306. ALL TEES SHALL BE DUAL WALL REDUCING TEES CONSISTENT WITH THE ADS N-12 PIPE WATERTIGHT CONNECTIONS.


ORIGINAL ISSUE: 3/28/2024 KHA PROJECT NO. 268442000 SHEET NUMBER

C007

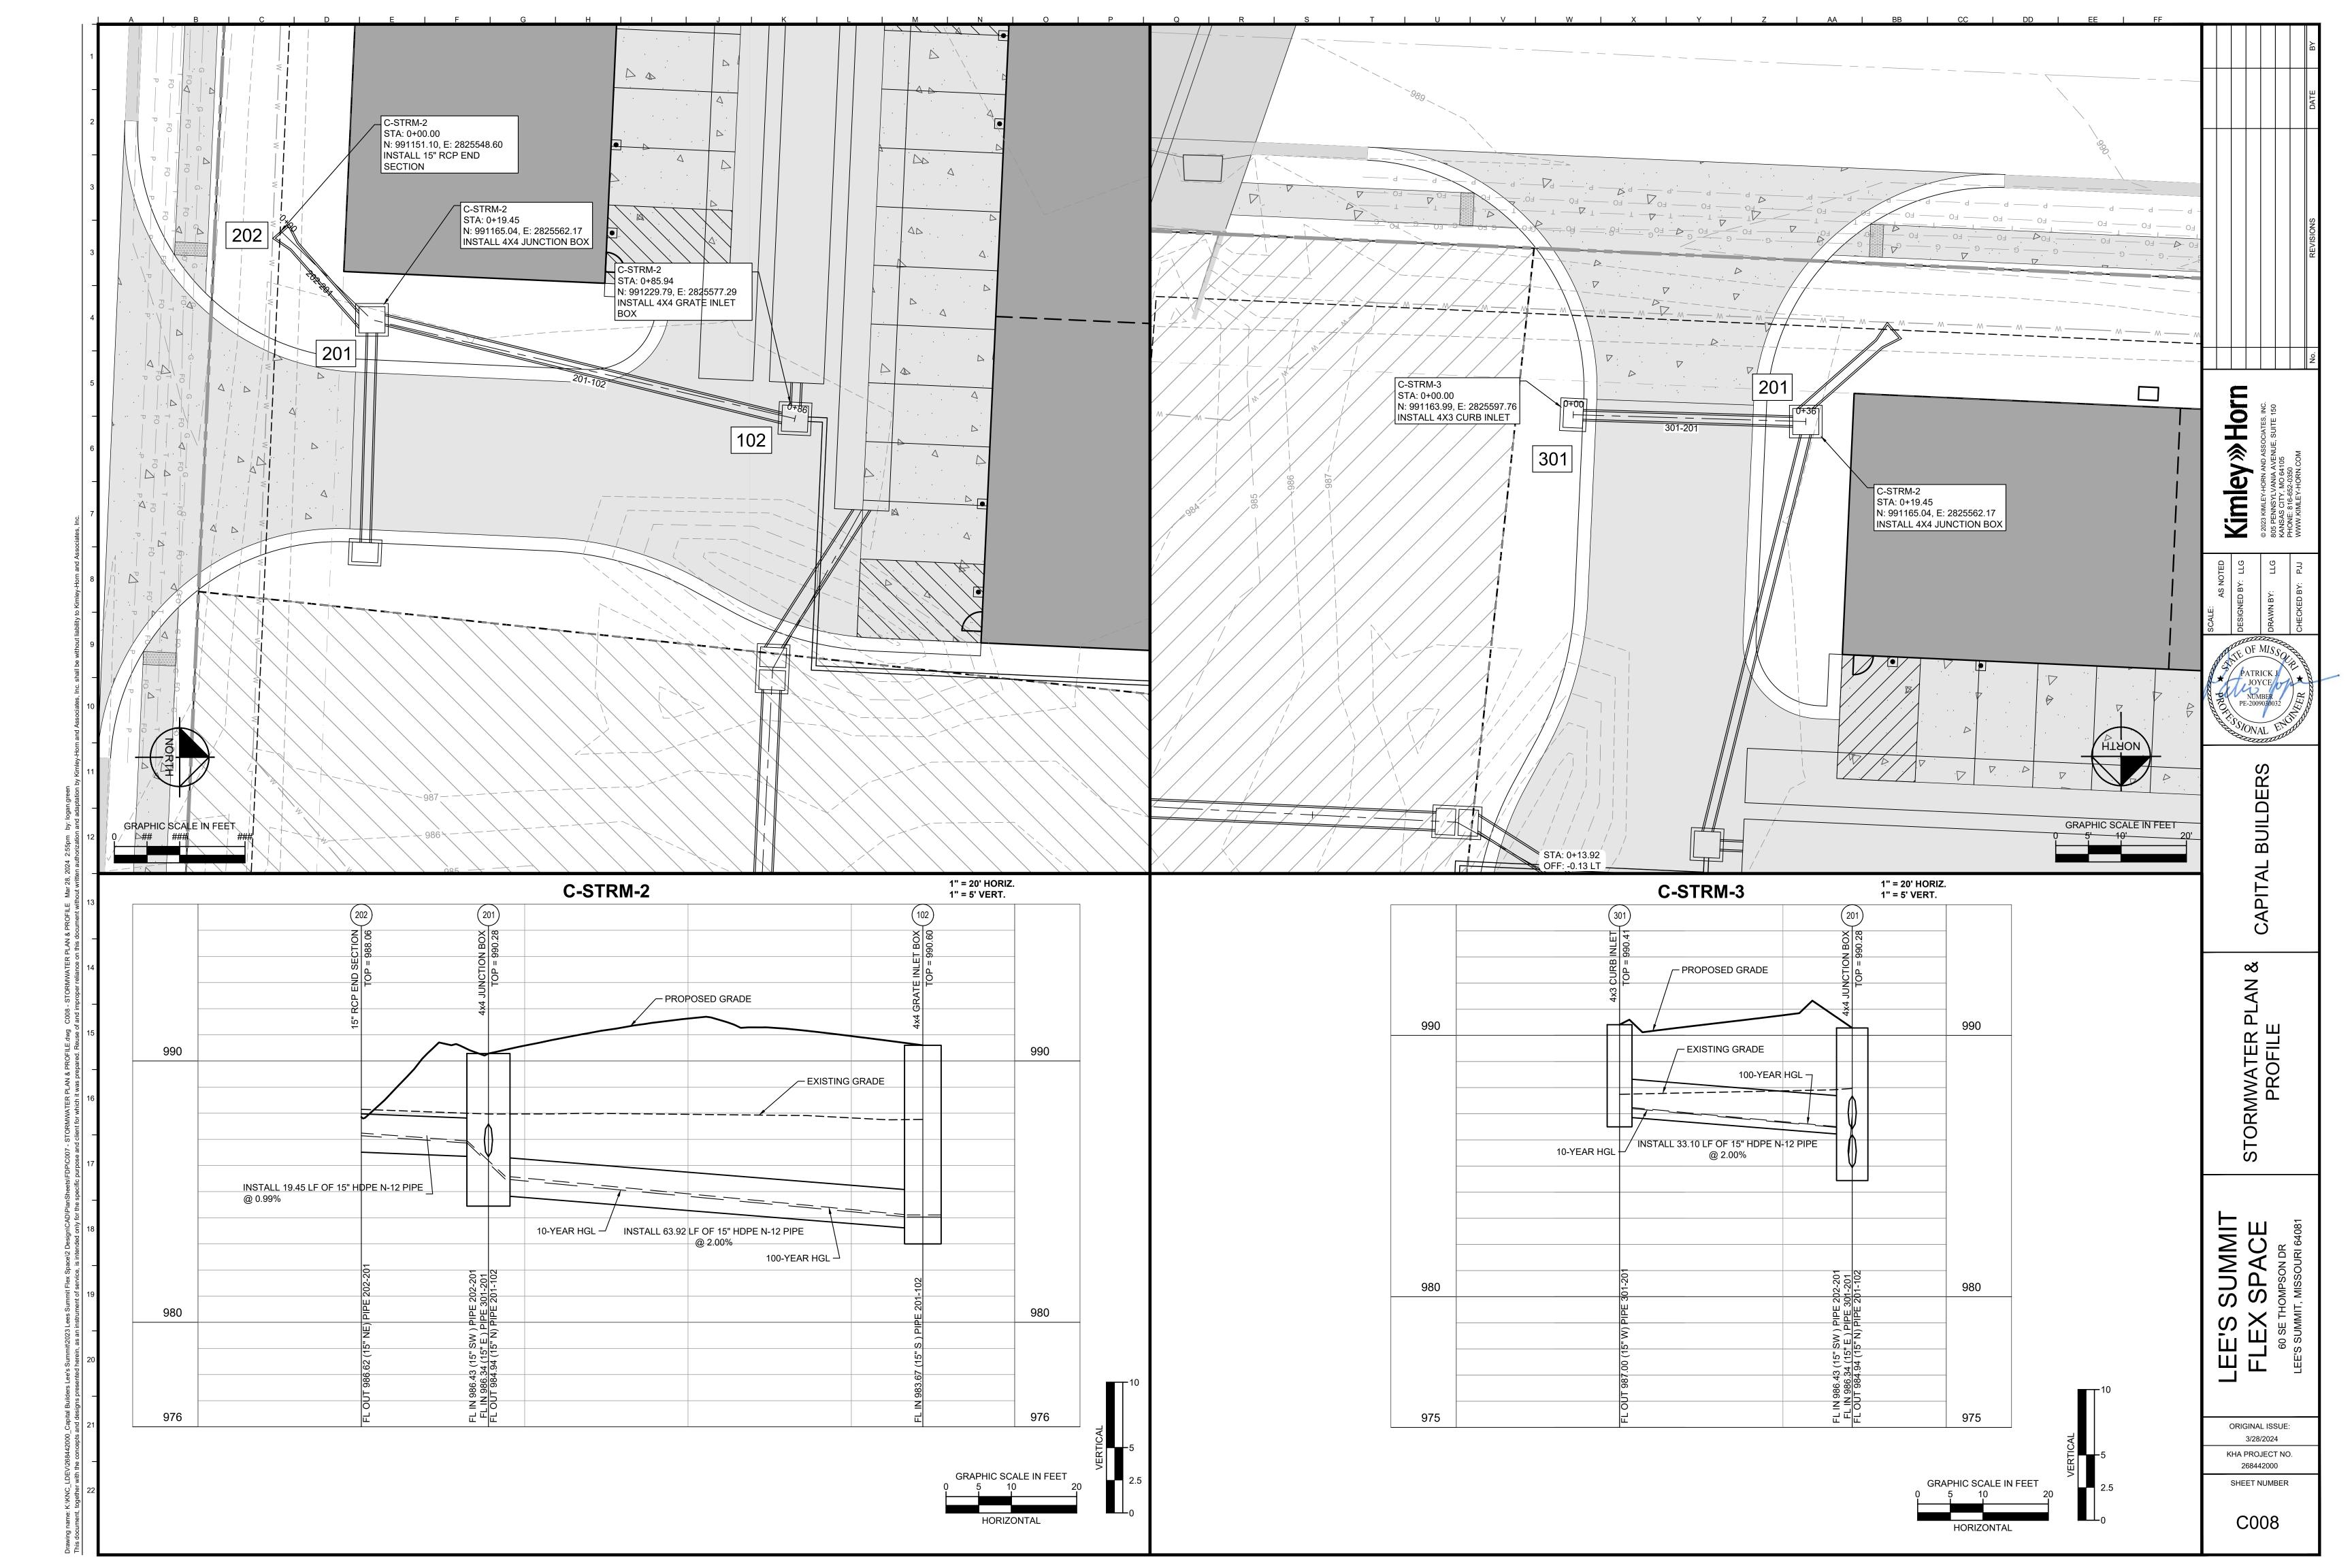

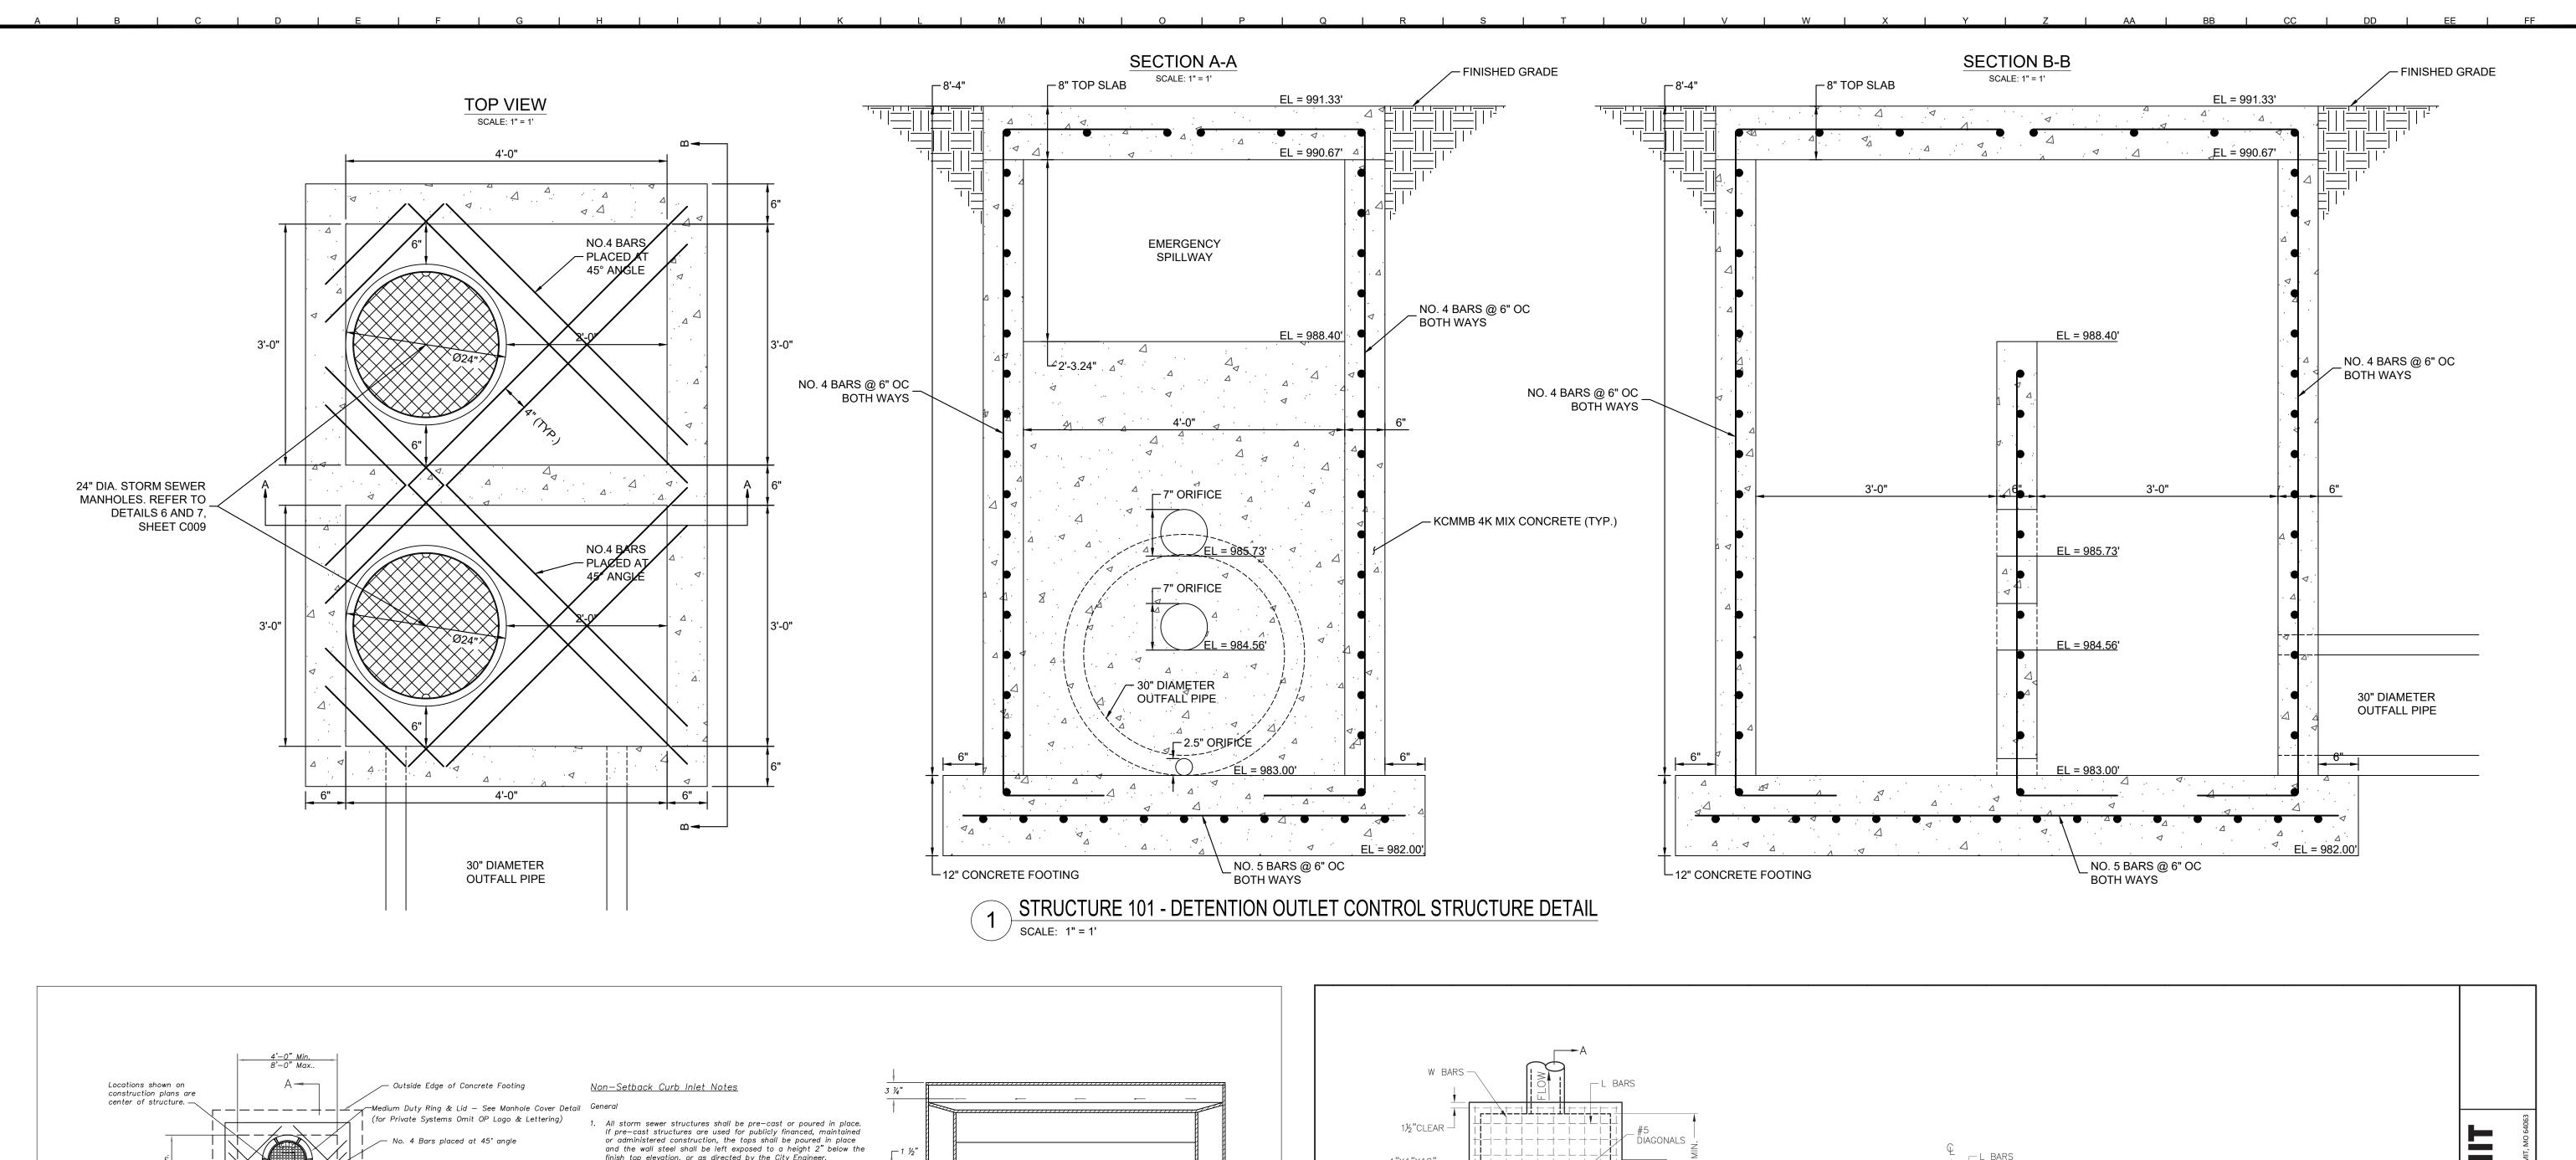

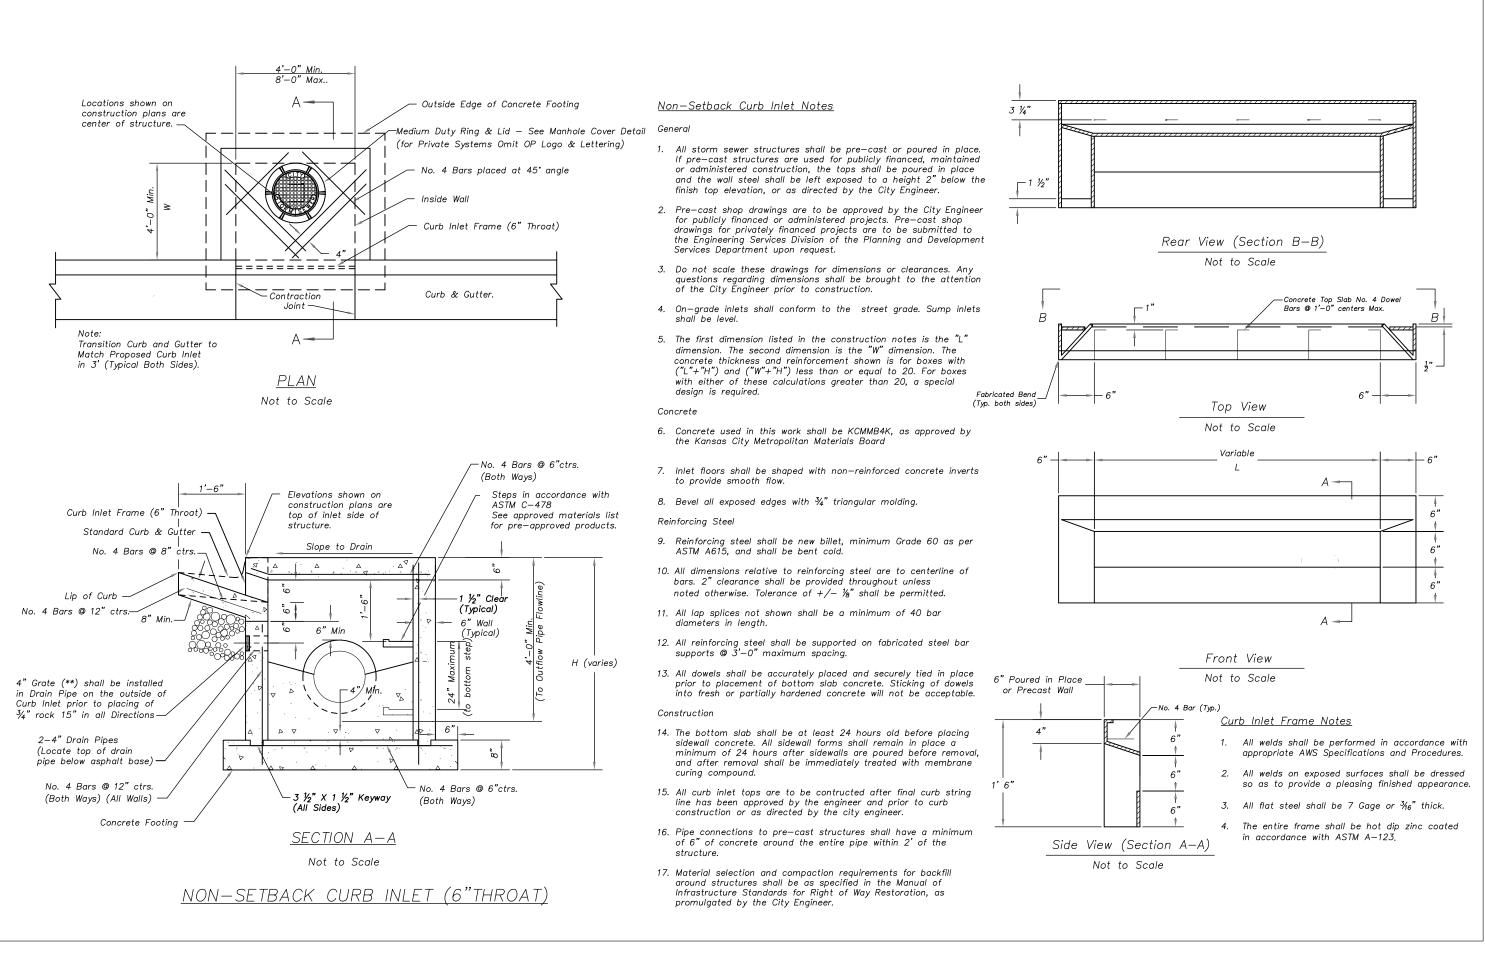

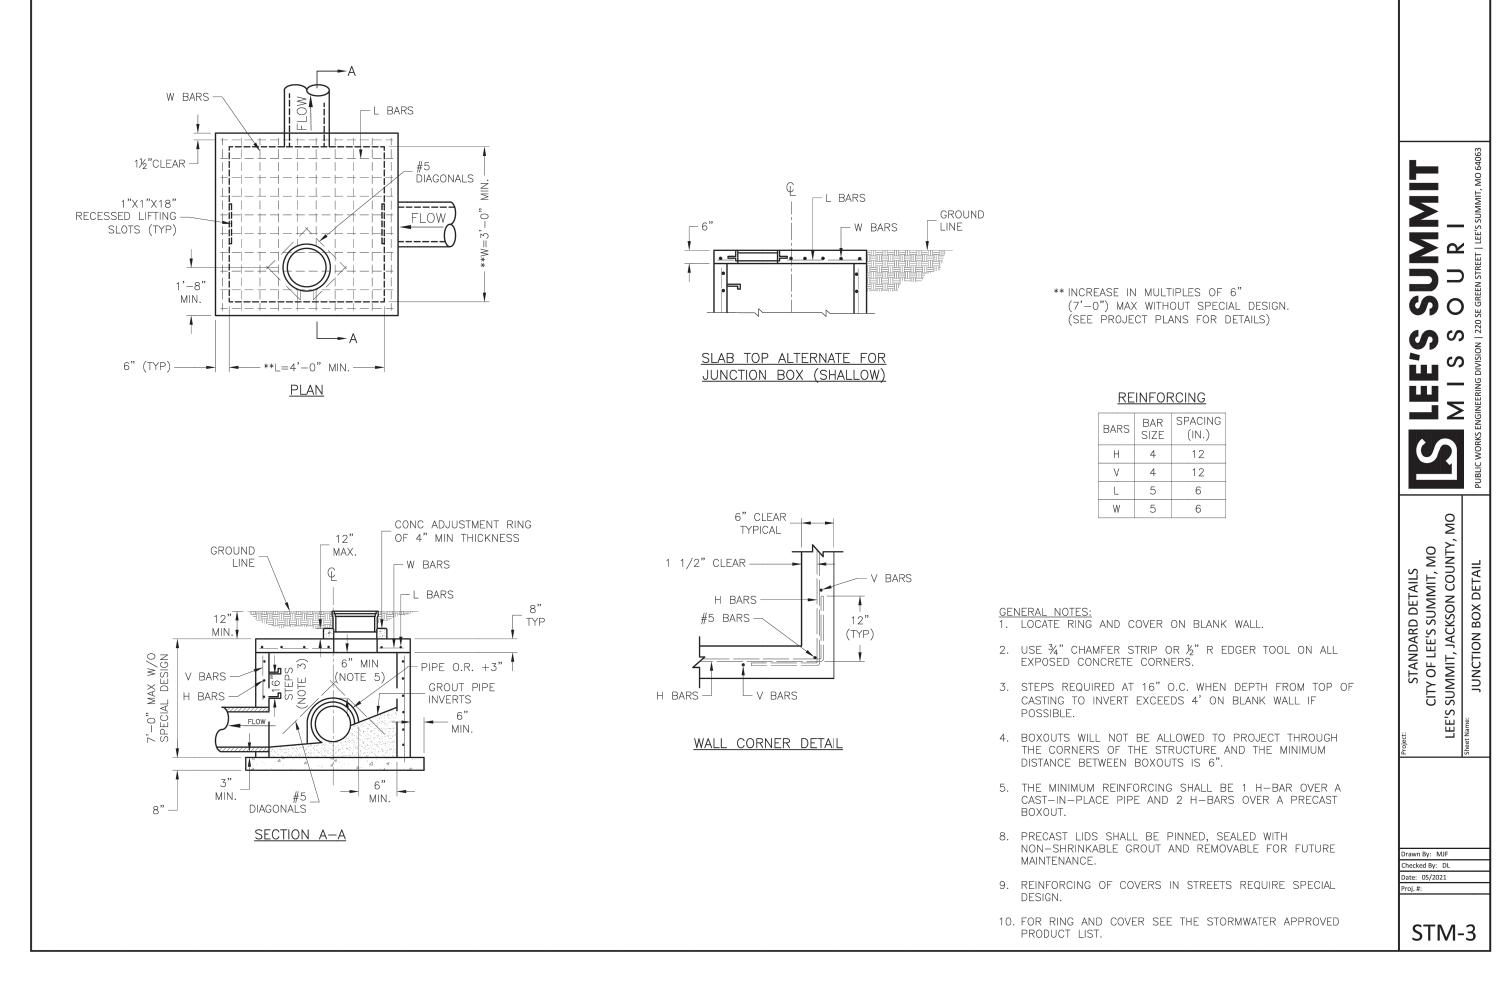

NON-SETBACK CURB INLET DETAIL

SCALE: NOT TO SCALE

3 JUNCTION BOX DETAIL
SCALE: NOT TO SCALE


ORIGINAL ISSUE:
3/28/2024


KHA PROJECT NO.
268442000


SHEET NUMBER


Kimley » Horn

C009

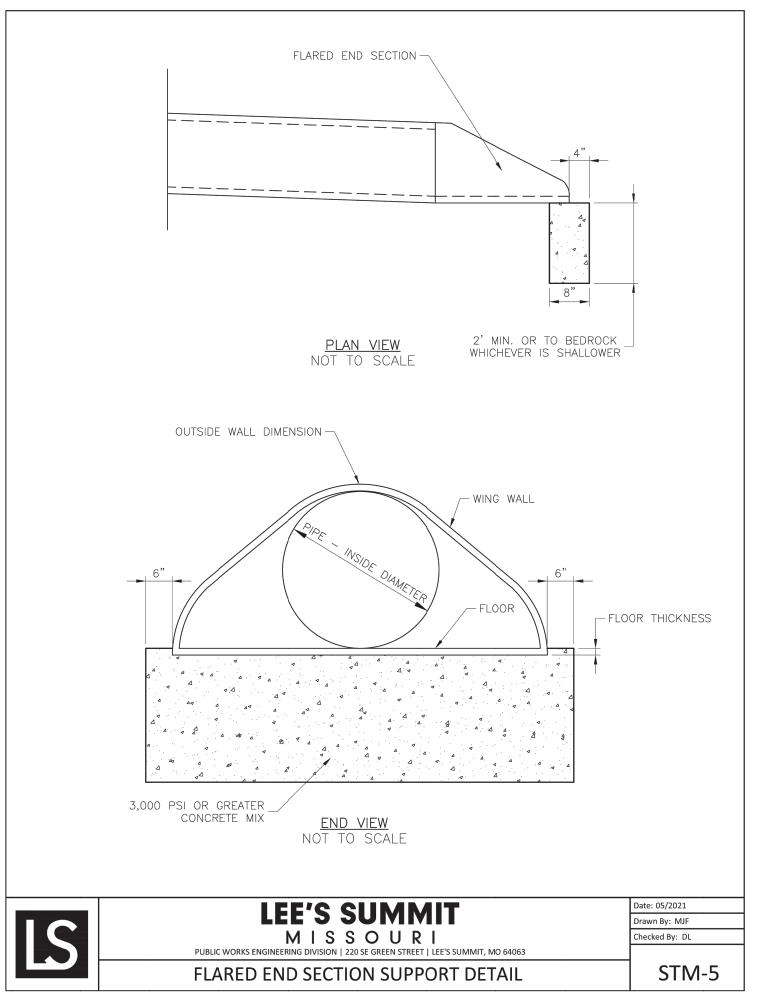

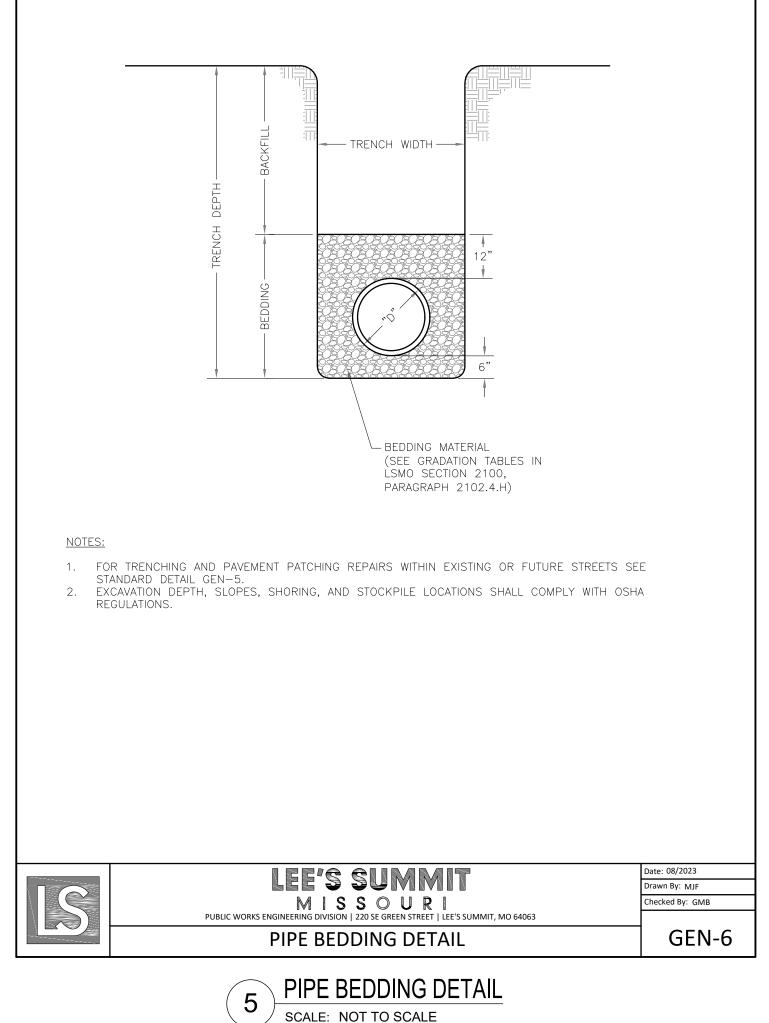

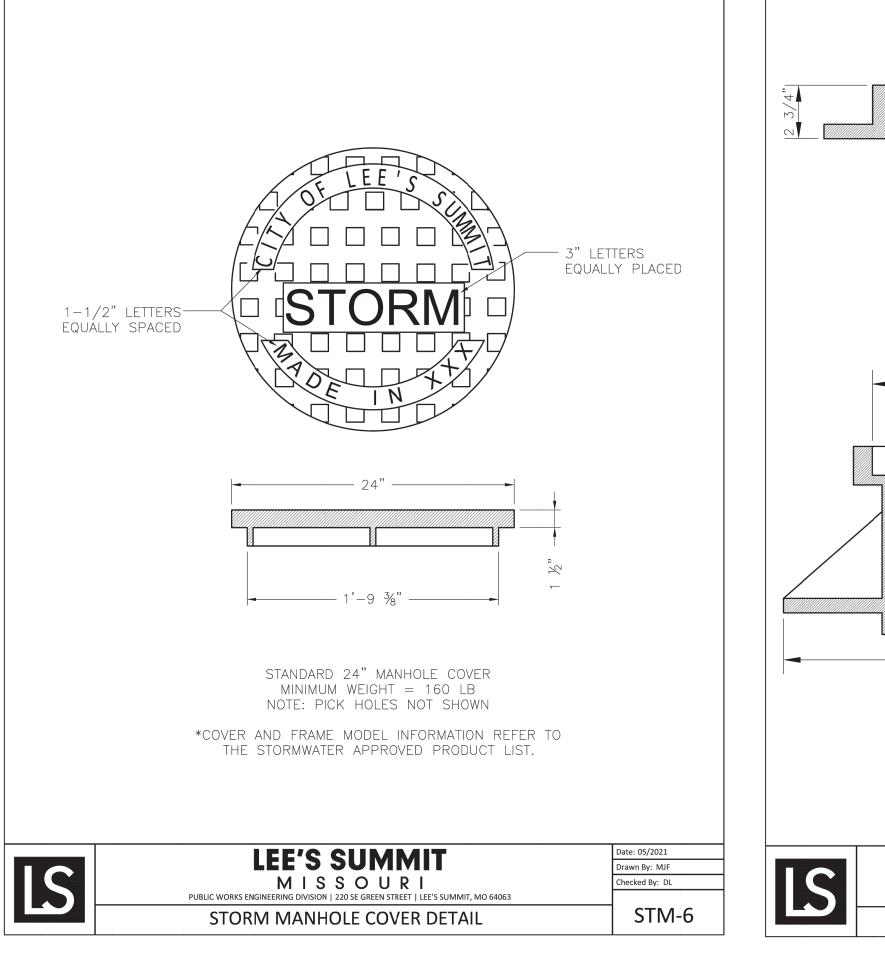

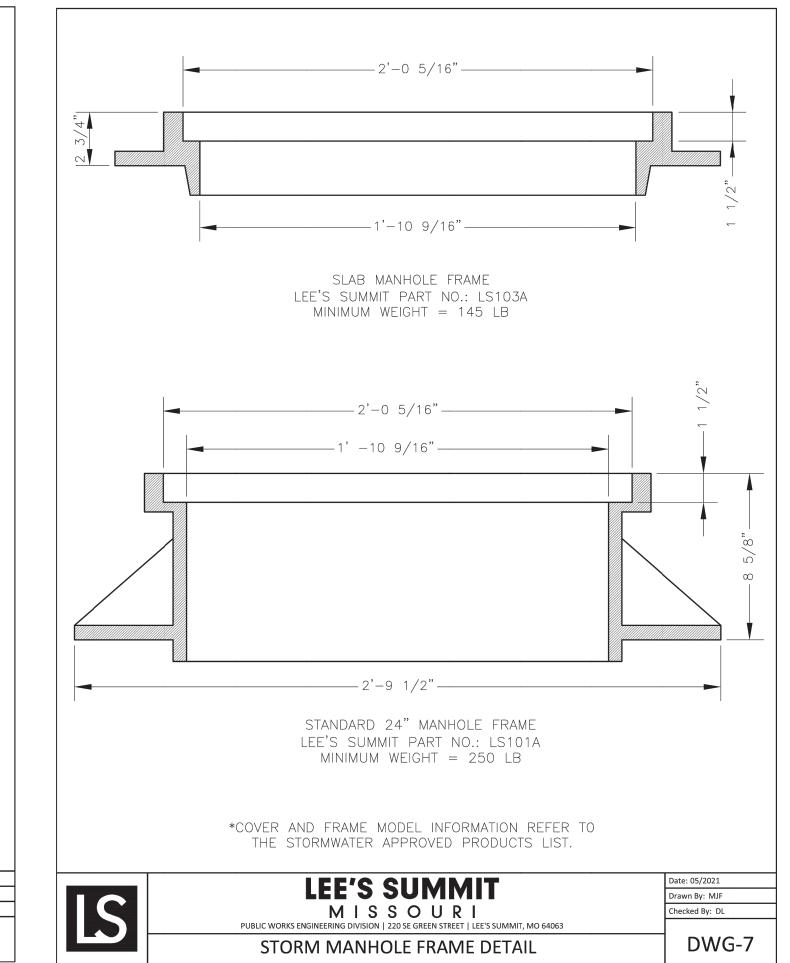

STORM MANHOLE COVER DETAIL SCALE: NOT TO SCALE






1-1/8 (45°) BEND -

TRACER WIRE

COMPACTED BACKFILL

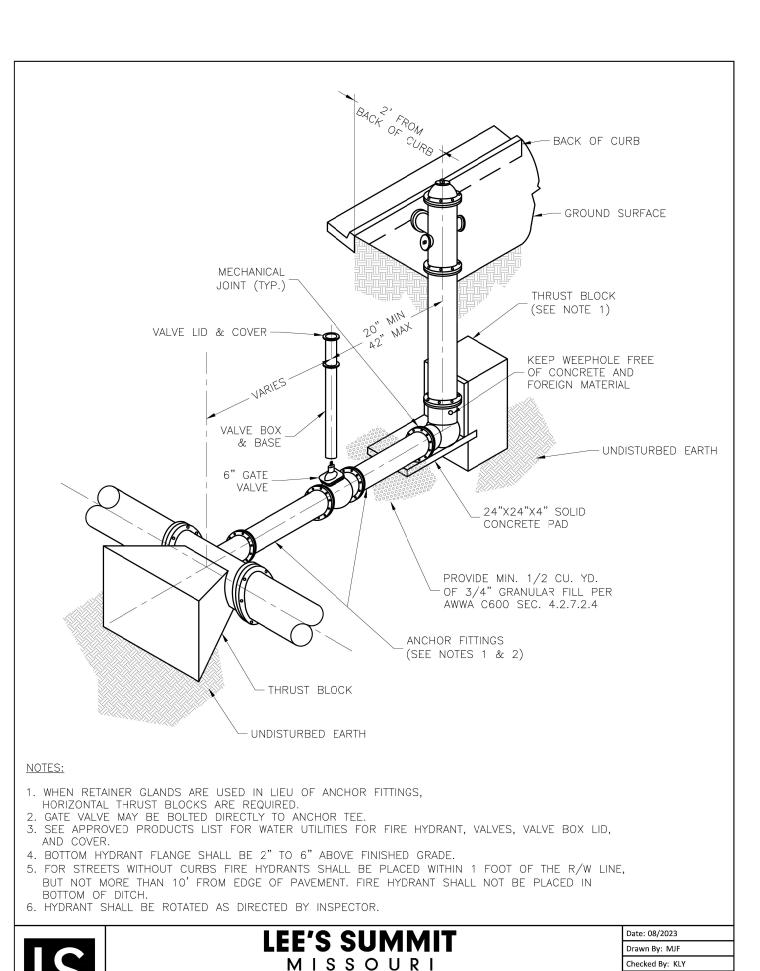


HYDRANT - STRAIGHT SET


\ HYDRANT - STRAIGHT SET DETAIL


SCALE: NOT TO SCALE

FLARED END SECTION WITH TOE WALL DETAIL

SCALE: NOT TO SCALE

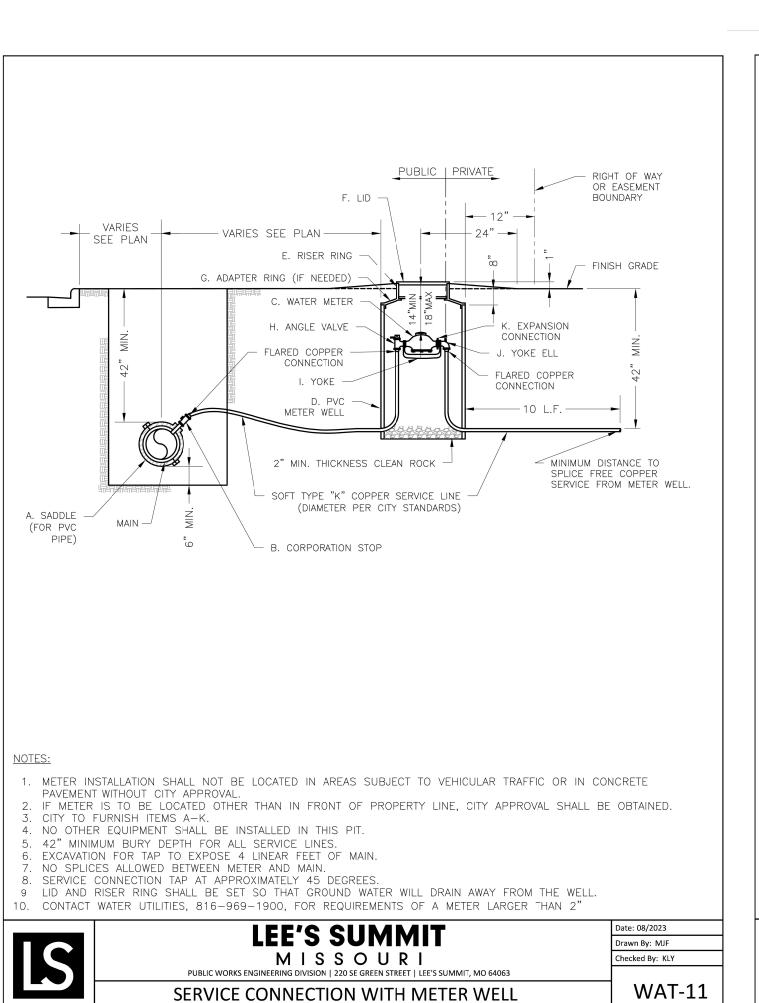

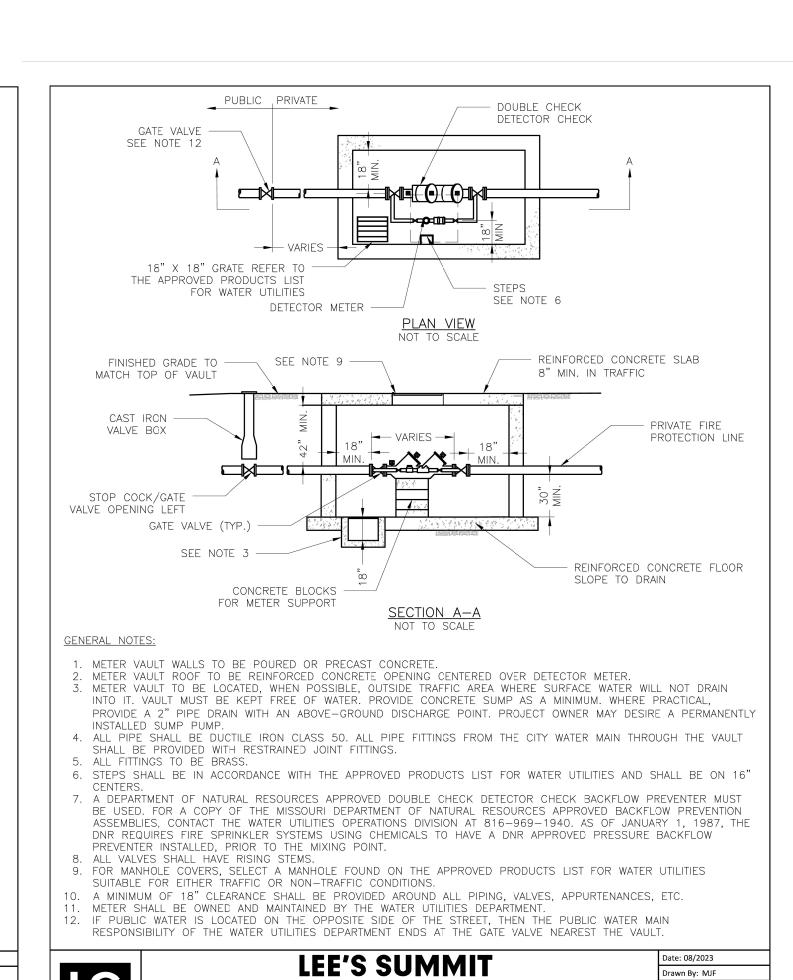

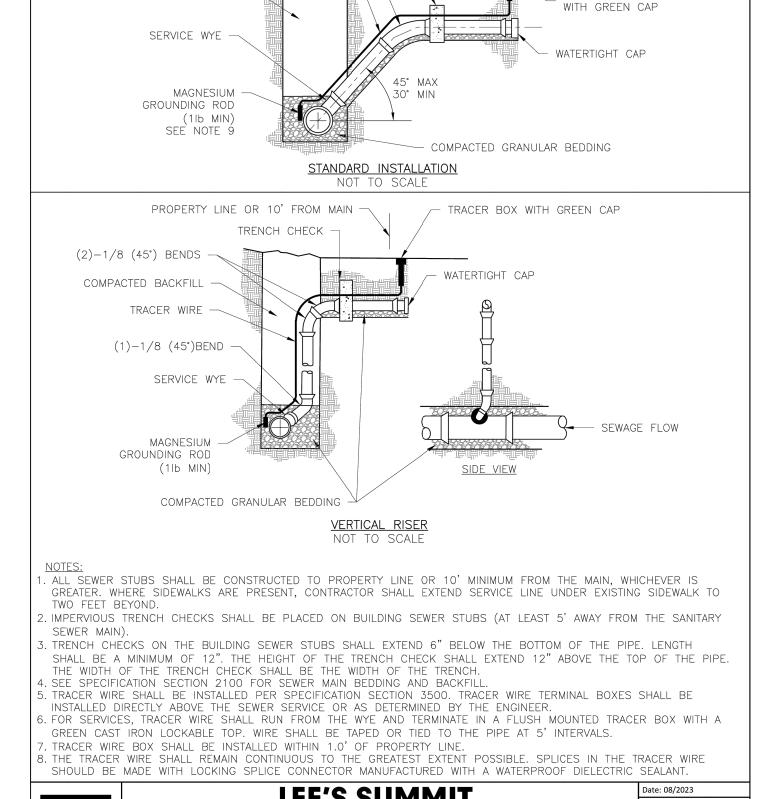

TRENCH CHECK

PROPERTY LINE OR

10' FROM MAIN

TRACER BOX



SERVICE CONNECTION WITH METER WELL DETAIL SCALE: NOT TO SCALE

VAULT FOR DOUBLE CHECK DETECTOR CHECK DETAIL SCALE: NOT TO SCALE

MISSOURI

VAULT FOR DOUBLE CHECK DETECTOR CHECK

Checked By: KLY

SCALE: NOT TO SCALE

Horn

Kimley

Ш


C010

ORIGINAL ISSUE:


3/28/2024


KHA PROJECT NO.


268442000 SHEET NUMBER

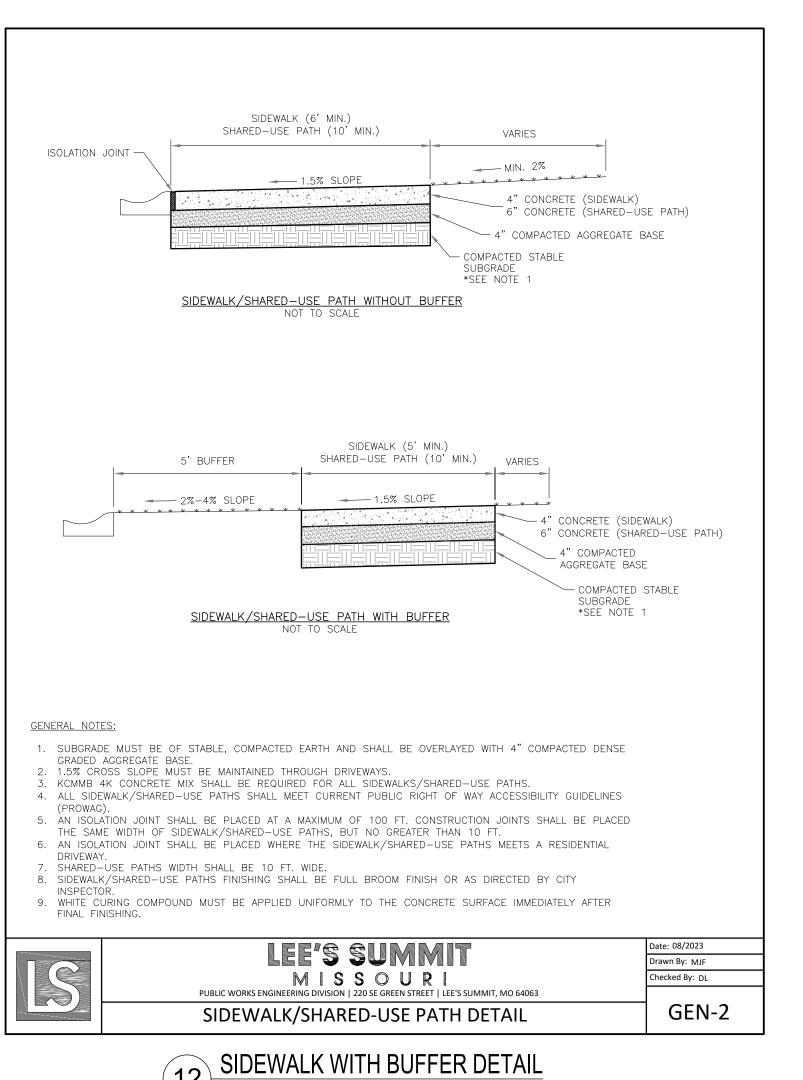



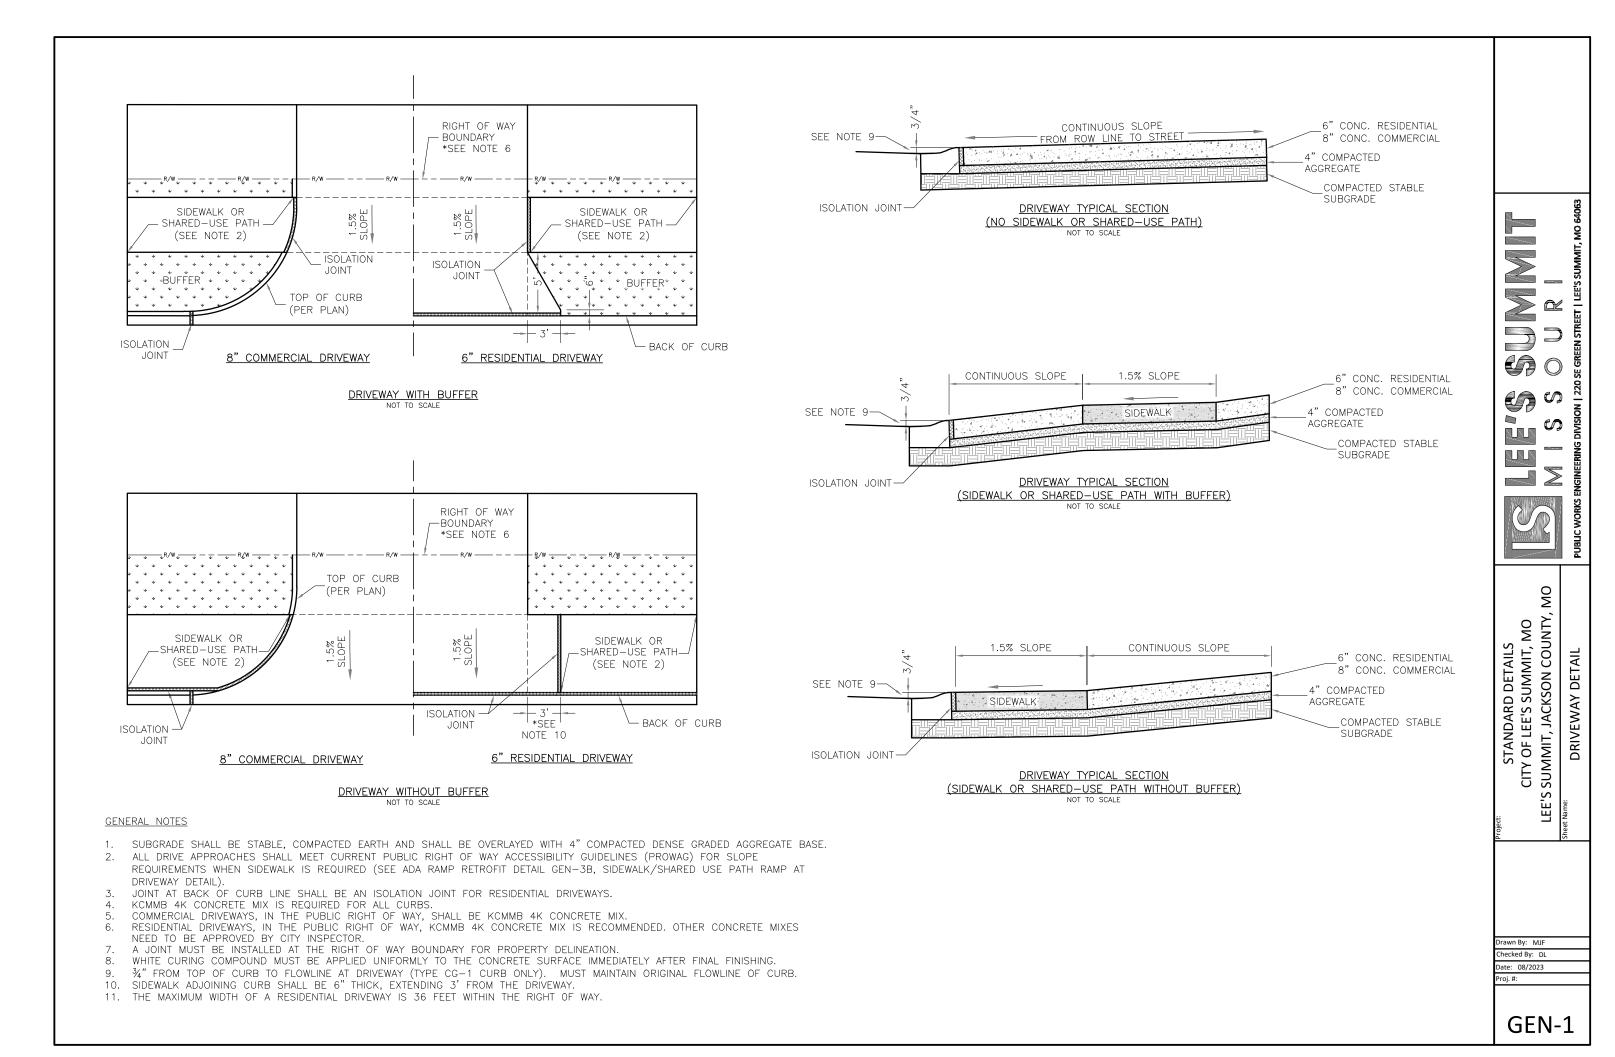

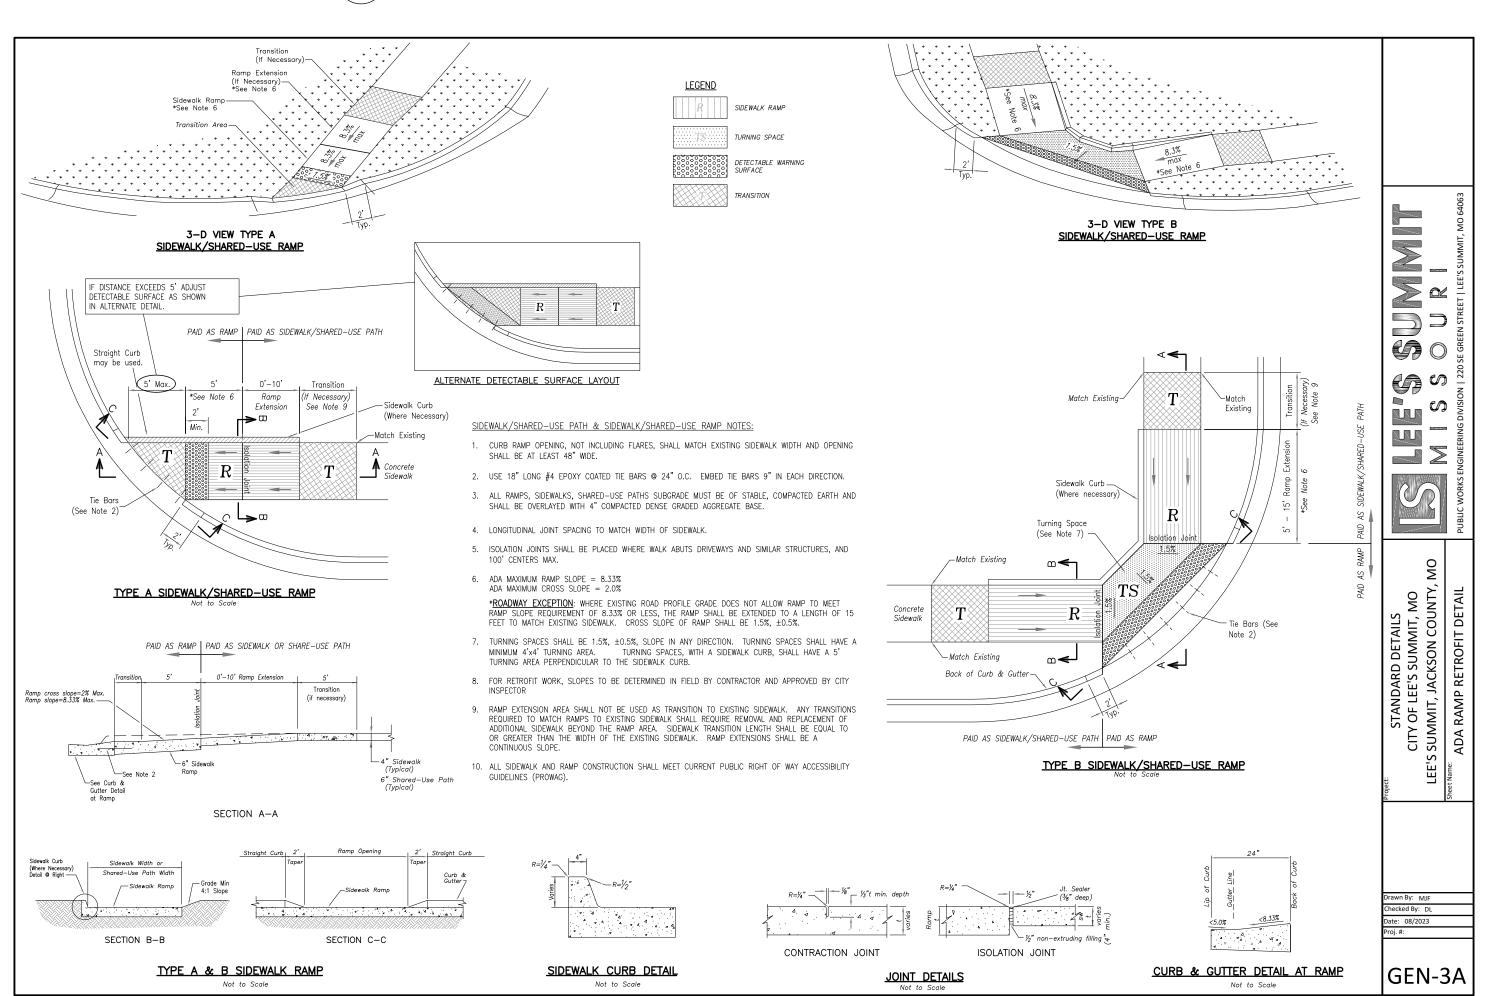

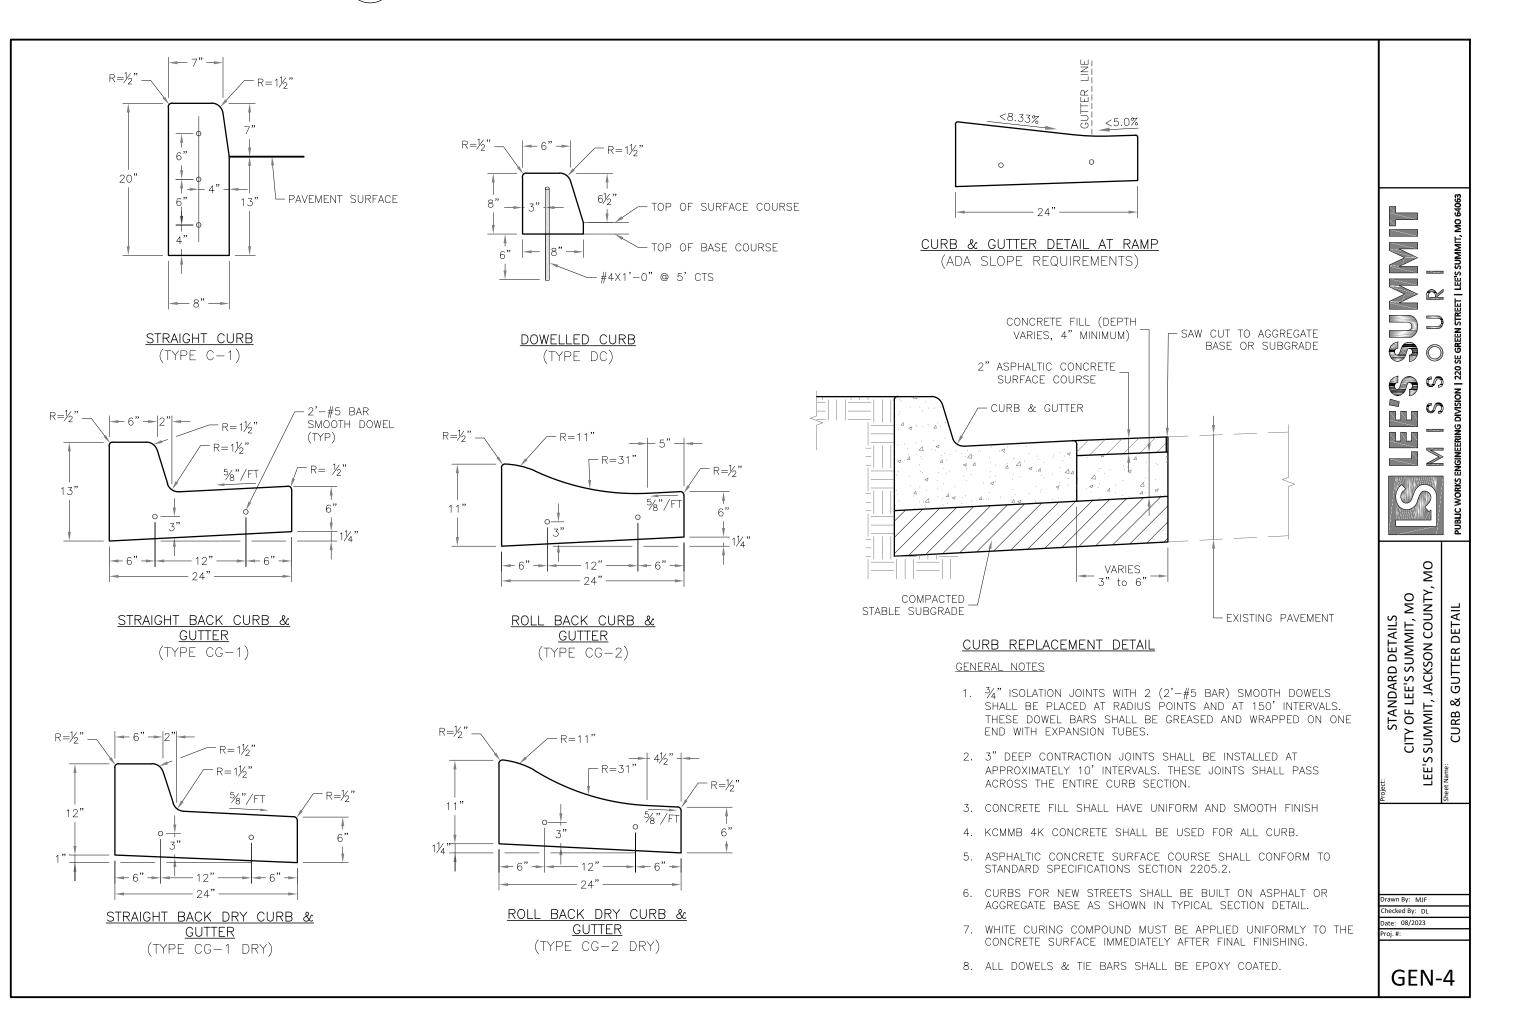


TYPE A SIDEWALK ADA RAMP RETROFIT DETAIL SCALE: NOT TO SCALE


STRAIGHT BACK CURB AND GUTTER DETAIL SCALE: NOT TO SCALE

ORIGINAL ISSUE: 3/28/2024 KHA PROJECT NO. 268442000 SHEET NUMBER


PATRICK J

Ш

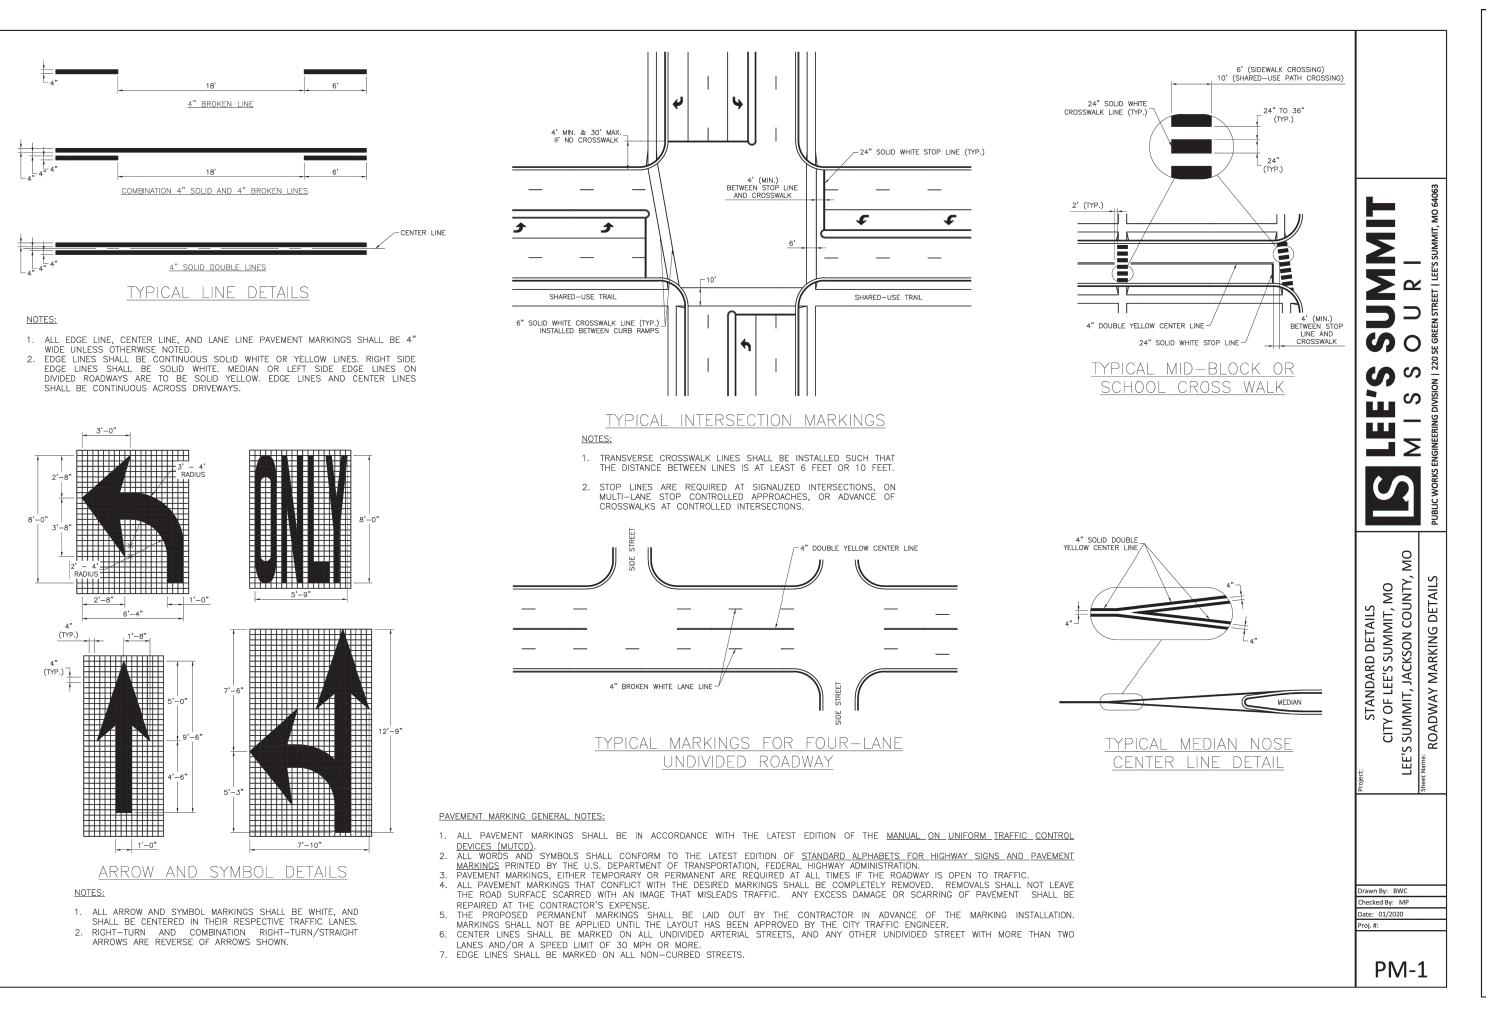


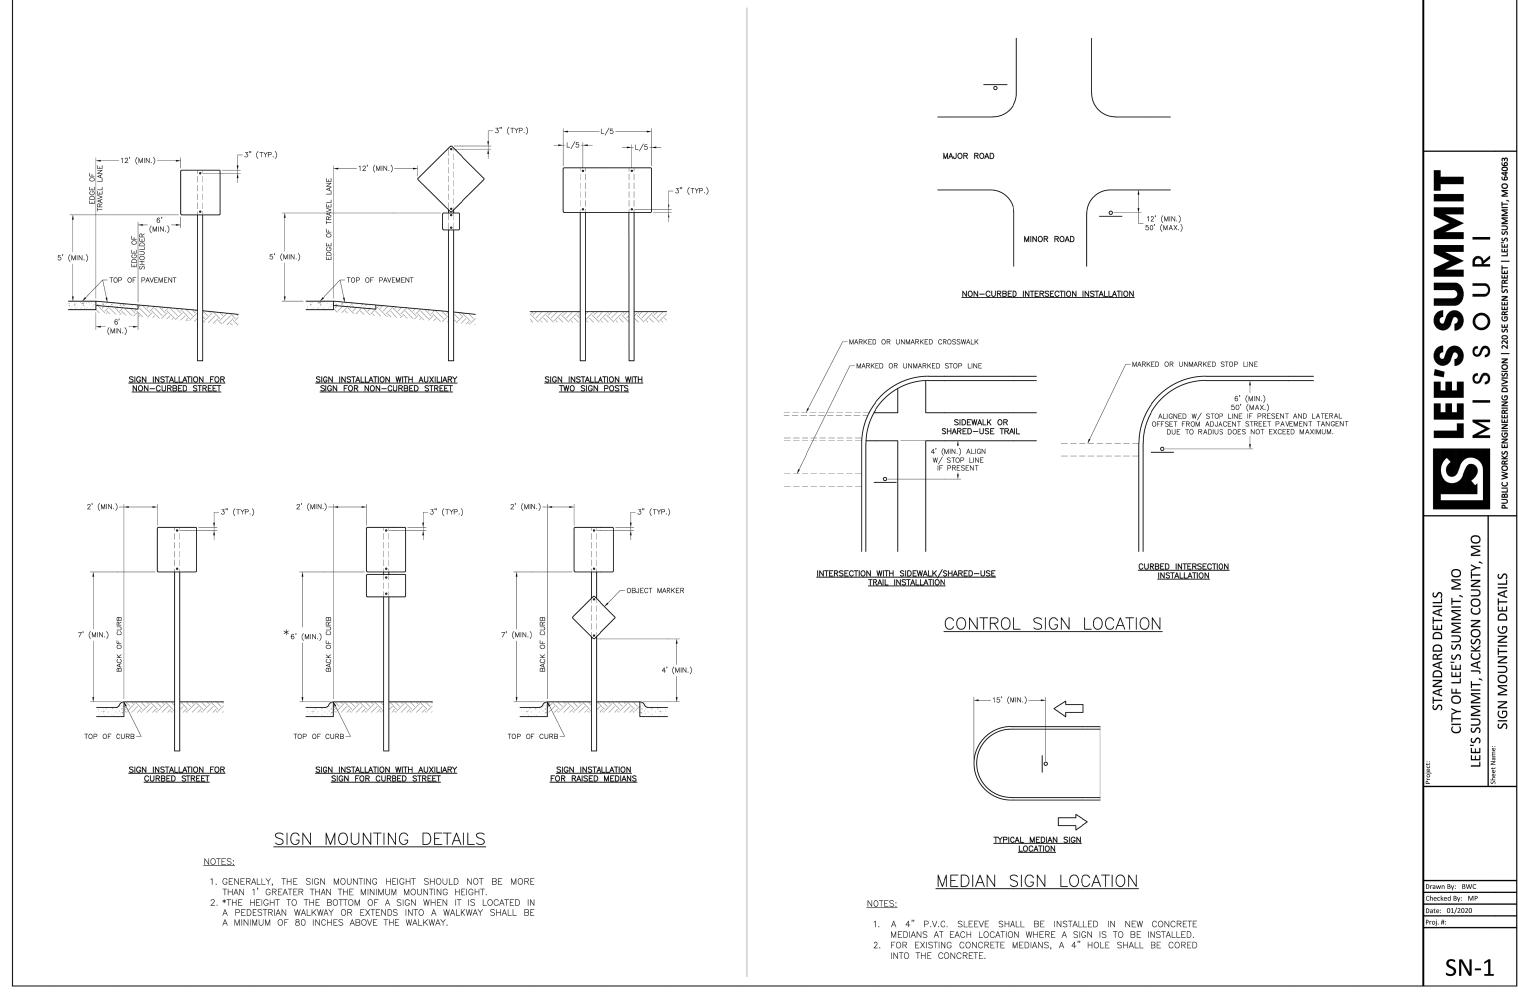


16 PAVEMENT MARKING ARROW AND SYMBOL DETAILS

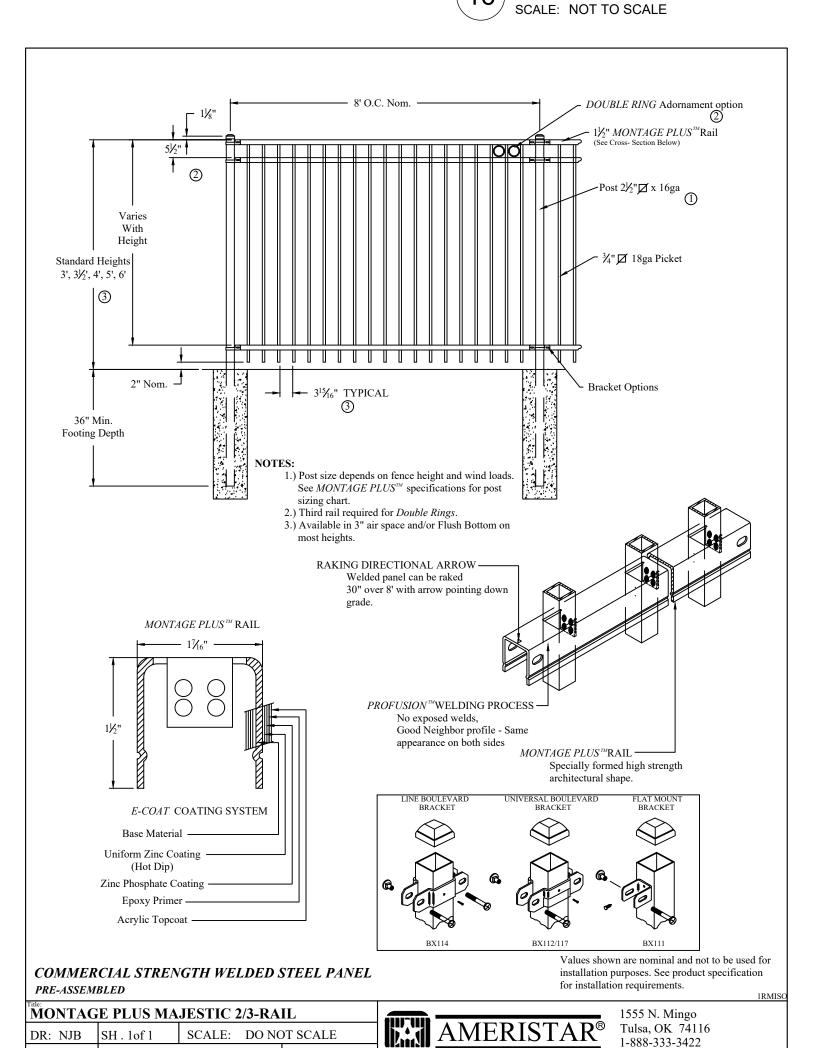

REV: e

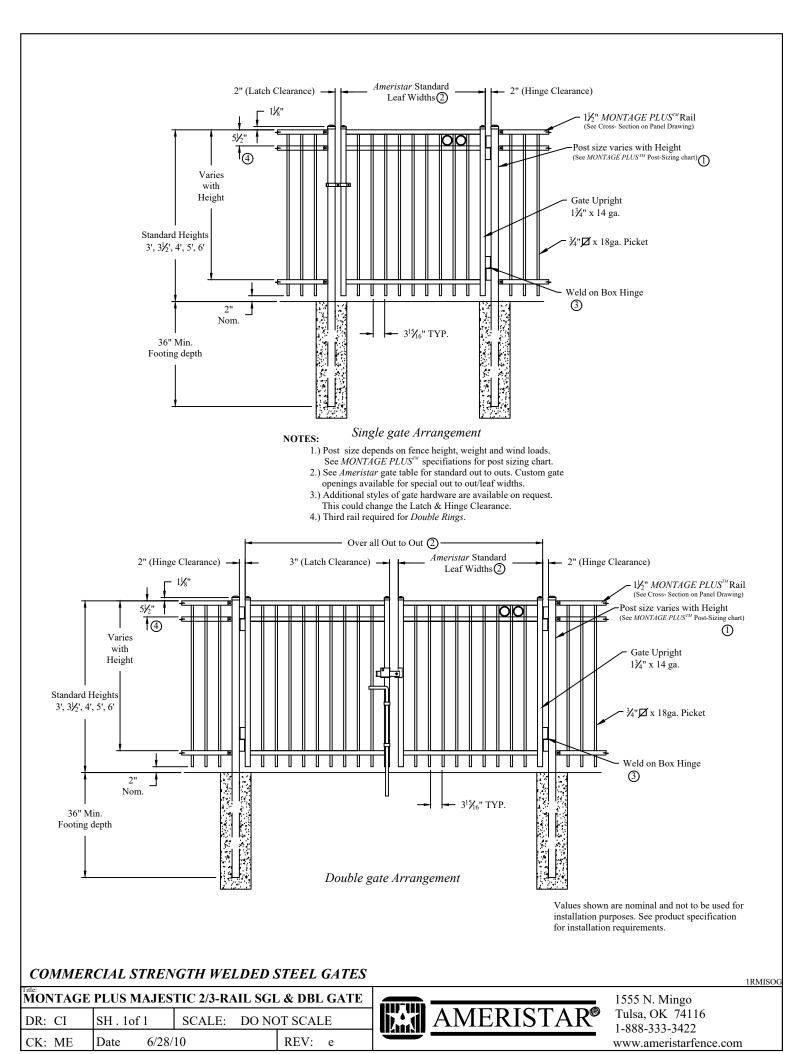

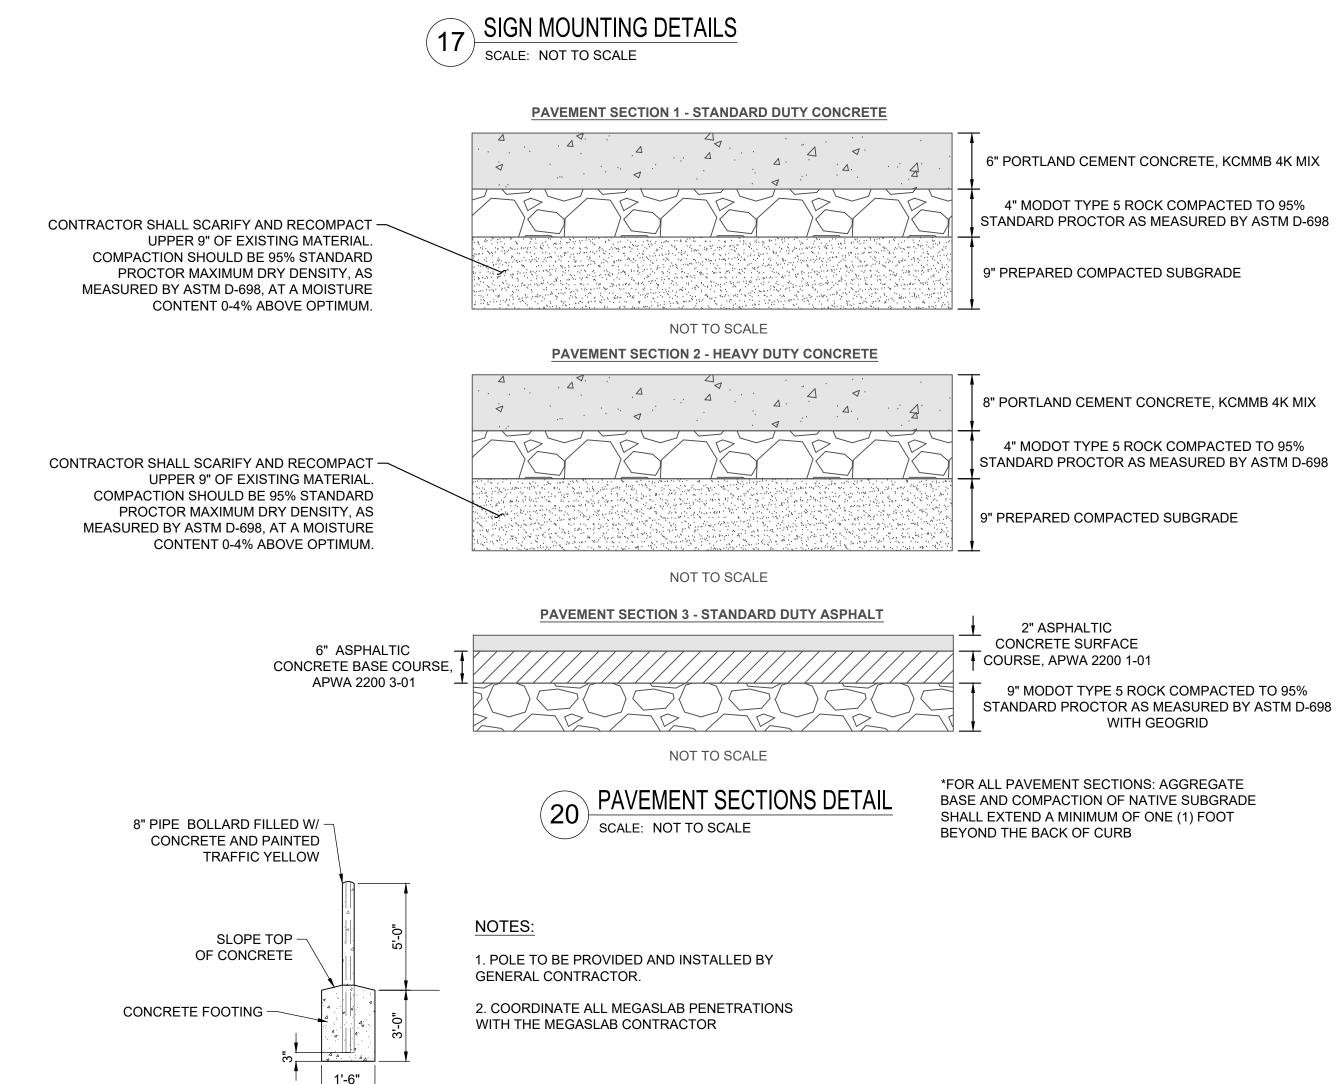

AMERISTAR FENCE DETAIL
SCALE: NOT TO SCALE

www.ameristarfence.com

19 AMERISTAR GATE DETAIL
SCALE: NOT TO SCALE

STEEL-ENCASED CONCRETE BOLLARD DETAIL
SCALE: NOT TO SCALE

ORIGINAL ISSUE:
3/28/2024

KHA PROJECT NO.
268442000

SHEET NUMBER

C012

SUMI SPA(

5

PATRICK J.

Ш



- OPTIONAL INSPECTION PORT



MC-4500 STORMTECH CHAMBER SPECIFICATIONS

- CHAMBERS SHALL BE STORMTECH MC-4500.
- CHAMBERS SHALL BE ARCH-SHAPED AND SHALL BE MANUFACTURED FROM VIRGIN, IMPACT-MODIFIED POLYPROPYLENE
- CHAMBERS SHALL MEET THE REQUIREMENTS OF ASTM F2418, "STANDARD SPECIFICATION FOR POLYPROPYLENE (PP) CORRUGATED WALL STORMWATER COLLECTION CHAMBERS" CHAMBER CLASSIFICATION 60x101.
- CHAMBER ROWS SHALL PROVIDE CONTINUOUS, UNOBSTRUCTED INTERNAL SPACE WITH NO INTERNAL SUPPORTS THAT WOULD IMPEDE FLOW OR LIMIT ACCESS FOR INSPECTION.
- THE STRUCTURAL DESIGN OF THE CHAMBERS. THE STRUCTURAL BACKFILL. AND THE INSTALLATION REQUIREMENTS SHAL ENSURE THAT THE LOAD FACTORS SPECIFIED IN THE AASHTO LRFD BRIDGE DESIGN SPECIFICATIONS, SECTION 12.12, ARE MET FOR: 1) LONG-DURATION DEAD LOADS AND 2) SHORT-DURATION LIVE LOADS, BASED ON THE AASHTO DESIGN TRUCK WITH CONSIDERATION FOR IMPACT AND MULTIPLE VEHICLE PRESENCES.
- CHAMBERS SHALL BE DESIGNED. TESTED AND ALLOWABLE LOAD CONFIGURATIONS DETERMINED IN ACCORDANCE WITH ASTM F2787, "STANDARD PRACTICE FOR STRUCTURAL DESIGN OF THERMOPLASTIC CORRUGATED WALL STORMWATER COLLECTION CHAMBERS". LOAD CONFIGURATIONS SHALL INCLUDE: 1) INSTANTANEOUS (<1 MIN) AASHTO DESIGN TRUCK LIVE LOAD ON MINIMUM COVER 2) MAXIMUM PERMANENT (75-YR) COVER LOAD AND 3) ALLOWABLE COVER WITH PARKED (1-WEEK) AASHTO
- REQUIREMENTS FOR HANDLING AND INSTALLATION

SITE DESIGN ENGINEER 24" [600 mm] MIN RECOMMENDED)

- TO MAINTAIN THE WIDTH OF CHAMBERS DURING SHIPPING AND HANDLING, CHAMBERS SHALL HAVE INTEGRAL.
- TO ENSURE A SECURE JOINT DURING INSTALLATION AND BACKFILL, THE HEIGHT OF THE CHAMBER JOINT SHALL NOT BE
- TO ENSURE THE INTEGRITY OF THE ARCH SHAPE DURING INSTALLATION. a) THE ARCH STIFFNESS CONSTANT SHALL BE GREATER THAN OR EQUAL TO 450 LBS/FT/%. THE ASC IS DEFINED IN SECTION 6.2.8 OF ASTM F2418. AND b) TO RESIST CHAMBER DEFORMATION DURING INSTALLATION AT ELEVATED TEMPERATURES (ABOVE 73° F / 23° C), CHAMBERS SHALL BE PRODUCED FROM REFLECTIVE GOLD OR YELLOW COLORS.
- ONLY CHAMBERS THAT ARE APPROVED BY THE SITE DESIGN ENGINEER WILL BE ALLOWED. UPON REQUEST BY THE SITE DESIGN ENGINEER OR OWNER, THE CHAMBER MANUFACTURER SHALL SUBMIT A STRUCTURAL EVALUATION FOR APPROVAL BEFORE DELIVERING CHAMBERS TO THE PROJECT SITE AS FOLLOWS: THE STRUCTURAL EVALUATION SHALL BE SEALED BY A REGISTERED PROFESSIONAL ENGINEER.
- THE STRUCTURAL EVALUATION SHALL DEMONSTRATE THAT THE SAFETY FACTORS ARE GREATER THAN OR EQUAL TO 1.95 FOR DEAD LOAD AND 1.75 FOR LIVE LOAD, THE MINIMUM REQUIRED BY ASTM F2787 AND BY SECTIONS 3 AND 12.12 OF THE AASHTO LRFD BRIDGE DESIGN SPECIFICATIONS FOR THERMOPLASTIC PIPE.
- THE TEST DERIVED CREEP MODULUS AS SPECIFIED IN ASTM F2418 SHALL BE USED FOR PERMANENT DEAD LOAD DESIGN EXCEPT THAT IT SHALL BE THE 75-YEAR MODULUS USED FOR DESIGN.
- 9. CHAMBERS AND END CAPS SHALL BE PRODUCED AT AN ISO 9001 CERTIFIED MANUFACTURING FACILITY.

IMPORTANT - NOTES FOR THE BIDDING AND INSTALLATION OF MC-4500 CHAMBER SYSTEM

- STORMTECH MC-4500 CHAMBERS SHALL NOT BE INSTALLED UNTIL THE MANUFACTURER'S REPRESENTATIVE HAS COMPLETED A PRE-CONSTRUCTION MEETING WITH THE INSTALLERS.
- STORMTECH MC-4500 CHAMBERS SHALL BE INSTALLED IN ACCORDANCE WITH THE "STORMTECH MC-3500/MC-4500 CONSTRUCTION GUIDE".
- CHAMBERS ARE NOT TO BE BACKFILLED WITH A DOZER OR EXCAVATOR SITUATED OVER THE CHAMBERS.
- STONESHOOTER LOCATED OFF THE CHAMBER BED BACKFILL AS ROWS ARE BUILT USING AN EXCAVATOR ON THE FOUNDATION STONE OR SUBGRADE. BACKFILL FROM OUTSIDE THE EXCAVATION USING A LONG BOOM HOE OR EXCAVATOR.
- 4. THE FOUNDATION STONE SHALL BE LEVELED AND COMPACTED PRIOR TO PLACING CHAMBERS.
- 5. JOINTS BETWEEN CHAMBERS SHALL BE PROPERLY SEATED PRIOR TO PLACING STONE
- 6. MAINTAIN MINIMUM 9" (230 mm) SPACING BETWEEN THE CHAMBER ROWS.
- 7. INLET AND OUTLET MANIFOLDS MUST BE INSERTED A MINIMUM OF 12" (300 mm) INTO CHAMBER END CAPS.
- 8. EMBEDMENT STONE SURROUNDING CHAMBERS MUST BE A CLEAN, CRUSHED, ANGULAR STONE MEETING THE AASHTO M43
- STONE SHALL BE BROUGHT UP EVENLY AROUND CHAMBERS SO AS NOT TO DISTORT THE CHAMBER SHAPE. STONE DEPTHS SHOULD NEVER DIFFER BY MORE THAN 12" (300 mm) BETWEEN ADJACENT CHAMBER ROWS.
- 10. STONE MUST BE PLACED ON THE TOP CENTER OF THE CHAMBER TO ANCHOR THE CHAMBERS IN PLACE AND PRESERVE ROW

11. THE CONTRACTOR MUST REPORT ANY DISCREPANCIES WITH CHAMBER FOUNDATION MATERIAL BEARING CAPACITIES TO THE

12. ADS RECOMMENDS THE USE OF "FLEXSTORM CATCH IT" INSERTS DURING CONSTRUCTION FOR ALL INLETS TO PROTECT THE SUBSURFACE STORMWATER MANAGEMENT SYSTEM FROM CONSTRUCTION SITE RUNOFF.

NOTES FOR CONSTRUCTION EQUIPMENT

STORMTECH RECOMMENDS 3 BACKFILL METHODS:

- 1. STORMTECH MC-4500 CHAMBERS SHALL BE INSTALLED IN ACCORDANCE WITH THE "STORMTECH MC-3500/MC-4500
- THE USE OF EQUIPMENT OVER MC-4500 CHAMBERS IS LIMITED:
- NO EQUIPMENT IS ALLOWED ON BARE CHAMBERS. • NO RUBBER TIRED LOADER, DUMP TRUCK, OR EXCAVATORS ARE ALLOWED UNTIL PROPER FILL DEPTHS ARE REACHED IN ACCORDANCE WITH THE "STORMTECH MC-3500/MC-4500 CONSTRUCTION GUIDE".
- WEIGHT LIMITS FOR CONSTRUCTION EQUIPMENT CAN BE FOUND IN THE "STORMTECH MC-3500/MC-4500 CONSTRUCTION

3. FULL 36" (900 mm) OF STABILIZED COVER MATERIALS OVER THE CHAMBERS IS REQUIRED FOR DUMP TRUCK TRAVEL OR DUMPING. USE OF A DOZER TO PUSH EMBEDMENT STONE BETWEEN THE ROWS OF CHAMBERS MAY CAUSE DAMAGE TO CHAMBERS AND IS NOT AN ACCEPTABLE BACKFILL METHOD. ANY CHAMBERS DAMAGED BY USING THE "DUMP AND PUSH" METHOD ARE NOT COVERED UNDER THE STORMTECH STANDARD WARRANTY.

CONTACT STORMTECH AT 1-888-892-2694 WITH ANY QUESTIONS ON INSTALLATION REQUIREMENTS OR WEIGHT LIMITS FOR

INSPECT ISOLATOR ROW PLUS FOR SEDIMENT

INSERTA-TEE SIDE INLET DETAIL INSPECTION & MAINTENANCE

STORMTECH

CHAMBERS

STORMTECH

A. INSPECTION PORTS (IF PRESENT) A.1. REMOVE/OPEN LID ON NYLOPLAST INLINE DRAIN

REMOVE AND CLEAN FLEXSTORM FILTER IF INSTALLED


- USING A FLASHLIGHT AND STADIA ROD, MEASURE DEPTH OF SEDIMENT AND RECORD ON MAINTENANCE LOG LOWER A CAMERA INTO ISOLATOR ROW PLUS FOR VISUAL INSPECTION OF SEDIMENT LEVELS
- A.5. IF SEDIMENT IS AT, OR ABOVE, 3" (80 mm) PROCEED TO STEP 2. IF NOT, PROCEED TO STEP 3.
- B. ALL ISOLATOR PLUS ROWS REMOVE COVER FROM STRUCTURE AT UPSTREAM END OF ISOLATOR ROW PLUS
- USING A FLASHLIGHT, INSPECT DOWN THE ISOLATOR ROW PLUS THROUGH OUTLET PIPE MIRRORS ON POLES OR CAMERAS MAY BE USED TO AVOID A CONFINED SPACE ENTRY) FOLLOW OSHA REGULATIONS FOR CONFINED SPACE ENTRY IF ENTERING MANHOLE
- IF SEDIMENT IS AT, OR ABOVE, 3" (80 mm) PROCEED TO STEP 2. IF NOT, PROCEED TO STEP 3. STEP 2) CLEAN OUT ISOLATOR ROW PLUS USING THE JETVAC PROCESS


A. A FIXED CULVERT CLEANING NOZZLE WITH REAR FACING SPREAD OF 45" (1.1 m) OR MORE IS

- APPLY MULTIPLE PASSES OF JETVAC UNTIL BACKFLUSH WATER IS CLEAN VACUUM STRUCTURE SUMP AS REQUIRED
- STEP 3) REPLACE ALL COVERS, GRATES, FILTERS, AND LIDS; RECORD OBSERVATIONS AND ACTIONS.
- STEP 4) INSPECT AND CLEAN BASINS AND MANHOLES UPSTREAM OF THE STORMTECH SYSTEM.

- 1. INSPECT EVERY 6 MONTHS DURING THE FIRST YEAR OF OPERATION. ADJUST THE INSPECTION INTERVAL BASED ON PREVIOUS OBSERVATIONS OF SEDIMENT ACCUMULATION AND HIGH WATER ELEVATIONS.
- 2. CONDUCT JETTING AND VACTORING ANNUALLY OR WHEN INSPECTION SHOWS THAT MAINTENANCE IS

MC-4500 ISOLATOR ROW PLUS DETAIL

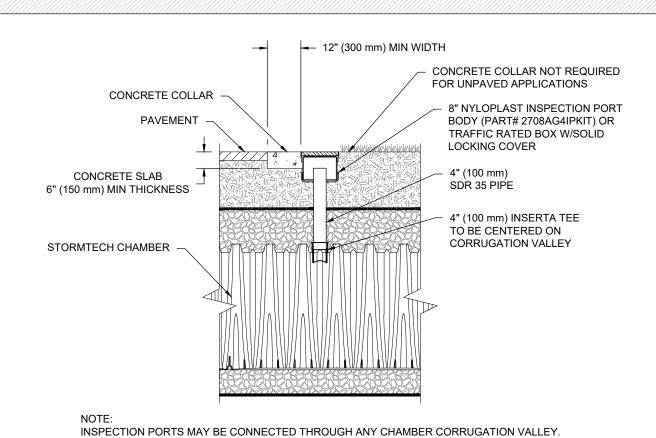

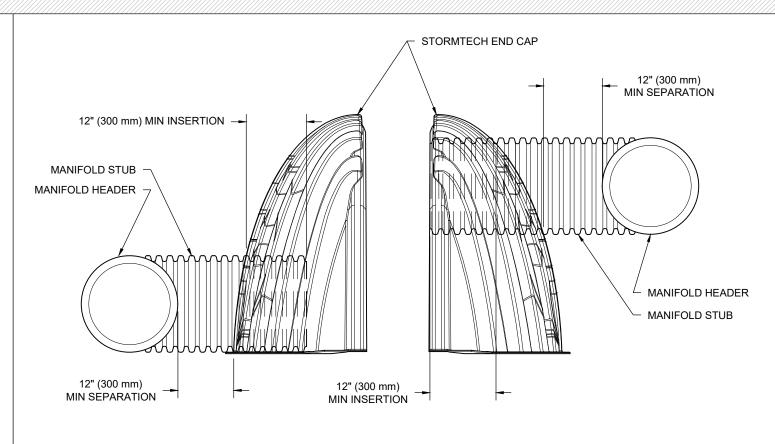

END CAP FOUNDATION STONE BENEATH CHAMBERS ADS GEOSYNTHETICS 601T **SECTION A-A** NON-WOVEN GEOTEXTILE PERFORATED HDPE STORMTECH UNDERDRAIN END CAP FOUNDATION STONE BENEATH CHAMBERS ADS GEOSYNTHETICS 601T NON-WOVEN GEOTEXTILE NUMBER AND SIZE OF UNDERDRAINS PER SITE DESIGN ENGINEER 4" (100 mm) TYP FOR SC-310 & SC-160LP SYSTEMS SECTION B-B 6" (150 mm) TYP FOR SC-740, DC-780, MC-3500, MC-4500 & MC-7200 SYSTEMS UNDERDRAIN DETAIL DO NOT INSTALI **INSERTA-TEE AT** CONVEYANCE PIPE MATERIAL MAY VARY

STORMTECH -

(PVC, HDPE, ETC.) **INSERTA TEE** CONNECTION INSERTA TEE TO BE INSTALLED, CENTERED OVER CORRUGATION PLACE ADSPLUS WOVEN GEOTEXTILE (CENTERED ON INSERTA-TEE INLET) OVER BEDDING STONE FOR SCOUR PROTÉCTION AT SIDE INLET CONNECTIONS, GEOTEXTILE MUST EXTEND 6" (150 mm) PAST CHAMBER PART NUMBERS WILL VARY BASED ON INLET PIPE MATERIALS. CONTACT STORMTECH FOR MORE

(CENTERED ON INSERTA-TEE INLET) OVER BEDDING STONE FOR SCOUR PROTECTION AT SIDE INLET CONNECTIONS. GEOTEXTILE	SECTION A-A	SIDE V	<u>/IEW</u>
MUST EXTEND 6" (150 mm) PAST CHAMBER FOOT	CHAMBER	MAX DIAMETER OF INSERTA TEE	HEIGHT FROM BASE OF CHAMBER (X)
	SC-310	6" (150 mm)	4" (100 mm)
	SC-740	10" (250 mm)	4" (100 mm)
	DC-780	10" (250 mm)	4" (100 mm)
DTES: PART NUMBERS WILL VARY BASED ON INLET PIPE	MC-3500	12" (300 mm)	6" (150 mm)
MATERIALS. CONTACT STORMTECH FOR MORE	MC-4500	12" (300 mm)	8" (200 mm)
INFORMATION.	MC-7200	12" (300 mm)	8" (200 mm)
CONTACT ADS ENGINEERING SERVICES IF INSERTA TEE INLET MUST BE RAISED AS NOT ALL INVERTS ARE POSSIBLE.		GS AVAILABLE FOR SDR 20 WELD, N-12, HP STORM, (

100.0" (2540 mm) ⇔ BUILD ROW IN THIS DIRECTION (833 mm) 52.0" INSTALLED (1227 mm) INSTALLED NOMINAL CHAMBER SPECIFICATIONS SIZE (W X H X INSTALLED LENGTH) 100.0" X 60.0" X 48.3" (2540 mm X 1524 mm X 1227 mm) CHAMBER STORAGE 106.5 CUBIC FEET (3.01 m³) MINIMUM INSTALLED STORAGE* 162.6 CUBIC FEET (4.60 m³) WEIGHT (NOMINAL) 125.0 lbs. (56.7 kg) NOMINAL END CAP SPECIFICATIONS SIZE (W X H X INSTALLED LENGTH) 90.0" X 61.0" X 32.8" (2286 mm X 1549 mm X 833 mm) END CAP STORAGE 39.5 CUBIC FEET (1.12 m³) MINIMUM INSTALLED STORAGE* 115.3 CUBIC FEET WEIGHT (NOMINAL) (40.8 kg)*ASSUMES 12" (305 mm) STONE ABOVE, 9" (229 mm) STONE FOUNDATION AND BETWEEN CHAMBERS, 12" (305 mm) STONE PERIMETER IN FRONT OF END CAPS AND 40% STONE POROSITY. PARTIAL CUT HOLES AT BOTTOM OF END CAP FOR PART NUMBERS ENDING WITH "B" PARTIAL CUT HOLES AT TOP OF END CAP FOR PART NUMBERS ENDING WITH "T" END CAPS WITH A PREFABRICATED WELDED STUB END WITH "W" PART# 42.54" (1081 mm) MC4500IEPP06T 6" (150 mm) 0.86" (22 mm) MC4500IEPP06B 40.50" (1029 mm) MC4500IEPP08T 8" (200 mm) MC4500IEPP08B 1.01" (26 mm) 38.37" (975 mm) MC4500IEPP10T 10" (250 mm) MC4500IEPP10B 35.69" (907 mm MC4500IEPP12 12" (300 mm) 1.55" (39 mm) MC4500IEPP12E 32.72" (831 mm) MC4500IEPP157 15" (375 mm) 1.70" (43 mm) MC4500IEPP15B MC4500IEPP18T 29.36" (746 mm) CUSTOM PREFABRICATED INVERTS MC4500IEPP18TW 18" (450 mm) ARE AVAILABLE UPON REQUEST. MC4500IFPP18B INVENTORIED MANIFOLDS INCLUDE 1.97" (50 mm) MC4500IEPP18BW 12-24" (300-600 mm) SIZE ON SIZE MC4500IEPP24T AND 15-48" (375-1200 mm) 23.05" (585 mm) MC4500IEPP24TW ECCENTRIC MANIFOLDS. CUSTOM

2.95" (75 mm)

3.25" (83 mm)

3.55" (90 mm)

MC-4500 TECHNICAL SPECIFICATIONS

NOTE: ALL DIMENSIONS ARE NOMINAL

MC4500IFPP24B

MC4500IEPP24BW

MC4500IEPP36BW

MC4500IEPP42BW

24" (600 mm)

36" (900 mm)

42" (1050 mm)

STIFFENING RIB

UPPER JOINT CORRUGATION

STIFFENING

CREST


CORRUGATION

ACCEPTABLE FILL MATERIALS: STORMTECH MC-4500 CHAMBER SYSTEMS

	MATERIAL LOCATION	DESCRIPTION	AASHTO MATERIAL CLASSIFICATIONS	COMPACTION / DENSITY REQUIREMENT
D	FINAL FILL: FILL MATERIAL FOR LAYER 'D' STARTS FROM THE TOP OF THE 'C' LAYER TO THE BOTTOM OF FLEXIBLE PAVEMENT OR UNPAVED FINISHED GRADE ABOVE. NOTE THAT PAVEMENT SUBBASE MAY BE PART OF THE 'D' LAYER	ANY SOIL/ROCK MATERIALS, NATIVE SOILS, OR PER ENGINEER'S PLANS. CHECK PLANS FOR PAVEMENT SUBGRADE REQUIREMENTS.	N/A	PREPARE PER SITE DESIGN ENGINEER'S PLANS. PAVED INSTALLATIONS MAY HAVE STRINGENT MATERIAL AND PREPARATION REQUIREMENTS.
С	INITIAL FILL: FILL MATERIAL FOR LAYER 'C' STARTS FROM THE TOP OF THE EMBEDMENT STONE ('B' LAYER) TO 24" (600 mm) ABOVE THE TOP OF THE CHAMBER. NOTE THAT PAVEMENT SUBBASE MAY BE A PART OF THE 'C' LAYER.	GRANULAR WELL-GRADED SOIL/AGGREGATE MIXTURES, <35% FINES OR PROCESSED AGGREGATE. MOST PAVEMENT SUBBASE MATERIALS CAN BE USED IN LIEU OF THIS LAYER.	AASHTO M145 ¹ A-1, A-2-4, A-3 OR AASHTO M43 ¹ 3, 357, 4, 467, 5, 56, 57, 6, 67, 68, 7, 78, 8, 89, 9, 10	BEGIN COMPACTIONS AFTER 24" (600 mm) OF MATERIAL OVER THE CHAMBERS IS REACHED. COMPACT ADDITIONAL LAYERS IN 12" (300 mm) MAX LIFTS TO A MIN. 95% PROCTOR DENSITY FOR WELL GRADED MATERIAL AND 95% RELATIVE DENSITY FOR PROCESSED AGGREGATE MATERIALS.
В	EMBEDMENT STONE: FILL SURROUNDING THE CHAMBERS FROM THE FOUNDATION STONE ('A' LAYER) TO THE 'C' LAYER ABOVE.	CLEAN, CRUSHED, ANGULAR STONE	AASHTO M43 ¹ 3, 4	NO COMPACTION REQUIRED.
А	FOUNDATION STONE: FILL BELOW CHAMBERS FROM THE SUBGRADE UP TO THE FOOT (BOTTOM) OF THE CHAMBER.	CLEAN, CRUSHED, ANGULAR STONE	AASHTO M43 ¹ 3, 4	PLATE COMPACT OR ROLL TO ACHIEVE A FLAT SURFACE. ^{2,3}

PLEASE NOTE: THE LISTED AASHTO DESIGNATIONS ARE FOR GRADATIONS ONLY. THE STONE MUST ALSO BE CLEAN, CRUSHED, ANGULAR. FOR EXAMPLE, A SPECIFICATION FOR #4 STONE WOULD STATE: "CLEAN, CRUSHED, ANGULAR NO. 4 (AASHTO M43) STONE" STORMTECH COMPACTION REQUIREMENTS ARE MET FOR 'A' LOCATION MATERIALS WHEN PLACED AND COMPACTED IN 9" (230 mm) (MAX) LIFTS USING TWO FULL COVERAGES WITH A VIBRATORY COMPACTOR

WHERE INFILTRATION SURFACES MAY BE COMPROMISED BY COMPACTION, FOR STANDARD DESIGN LOAD CONDITIONS, A FLAT SURFACE MAY BE ACHIEVED BY RAKING OR DRAGGING WITHOUT COMPACTION EQUIPMENT. FOR SPECIAL LOAD DESIGNS, CONTACT STORMTECH FOR 4. ONCE LAYER 'C' IS PLACED, ANY SOIL/MATERIAL CAN BE PLACED IN LAYER 'D' UP TO THE FINISHED GRADE. MOST PAVEMENT SUBBASE SOILS CAN BE USED TO REPLACE THE MATERIAL REQUIREMENTS OF LAYER 'C' OR 'D' AT THE SITE DESIGN ENGINEER'S DISCRETION.

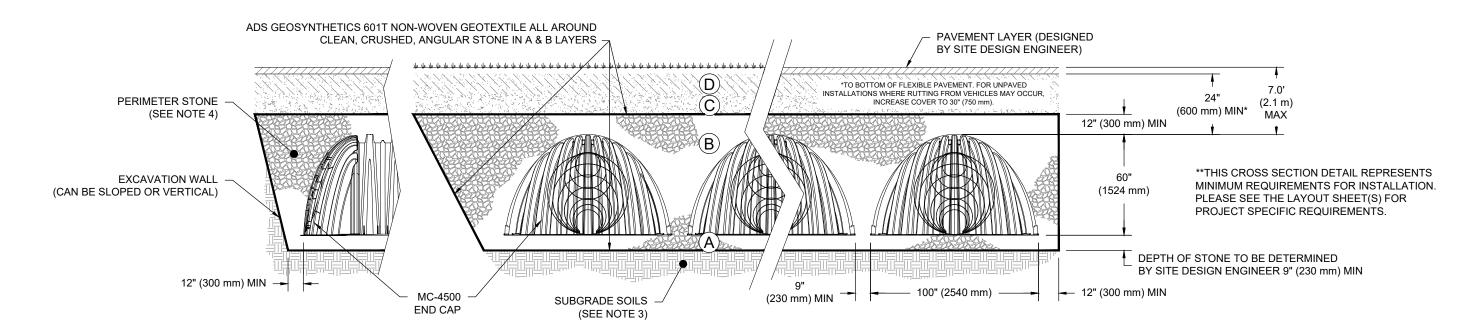

NOTES:

- CHAMBERS SHALL MEET THE REQUIREMENTS OF ASTM F2418. "STANDARD SPECIFICATION FOR POLYPROPYLENE (PP) CORRUGATED WALL STORMWATER COLLECTION CHAMBERS" CHAMBER CLASSIFICATION 60x101
- MC-4500 CHAMBERS SHALL BE DESIGNED IN ACCORDANCE WITH ASTM F2787 "STANDARD PRACTICE FOR STRUCTURAL DESIGN OF THERMOPLASTIC CORRUGATED WALL STORMWATER COLLECTION CHAMBERS". THE SITE DESIGN ENGINEER IS RESPONSIBLE FOR ASSESSING THE BEARING RESISTANCE (ALLOWABLE BEARING CAPACITY) OF THE SUBGRADE SOILS AND THE DEPTH OF FOUNDATION STONE WITH CONSIDERATION FOR THE RANGE OF EXPECTED SOIL MOISTURE CONDITIONS
- 4. PERIMETER STONE MUST BE EXTENDED HORIZONTALLY TO THE EXCAVATION WALL FOR BOTH VERTICAL AND SLOPED EXCAVATION WALLS.
- TO MAINTAIN THE WIDTH OF CHAMBERS DURING SHIPPING AND HANDLING, CHAMBERS SHALL HAVE INTEGRAL, INTERLOCKING STACKING LUGS. TO ENSURE A SECURE JOINT DURING INSTALLATION AND BACKFILL, THE HEIGHT OF THE CHAMBER JOINT SHALL NOT BE LESS THAN 3".
- TO ENSURE THE INTEGRITY OF THE ARCH SHAPE DURING INSTALLATION, a) THE ARCH STIFFNESS CONSTANT AS DEFINED IN SECTION 6.2.8 OF ASTM F2418 SHALL BE GREATER THAN OR EQUAL TO 500 LBS/FT/%.
- AND b) TO RESIST CHAMBER DEFORMATION DURING INSTALLATION AT ELEVATED TEMPERATURES (ABOVE 73° F / 23° C), CHAMBERS SHALL BE PRODUCED FROM REFLECTIVE GOLD OR YELLOW COLORS.

TAIL

0

INVERT LOCATIONS ON THE MC-4500

END CAP CUT IN THE FIELD ARE NOT

RECOMMENDED FOR PIPE SIZES

GREATER THAN 10" (250 mm). THE

ARE THE HIGHEST POSSIBLE FOR

INVERT LOCATION IN COLUMN 'B'

THE PIPE SIZE.

SHEET


4" PVC INSPECTION PORT DETAIL (MC SERIES CHAMBER)


MC-SERIES END CAP INSERTION DETAIL

NOTE: MANIFOLD STUB MUST BE LAID HORIZONTAL

FOR A PROPER FIT IN END CAP OPENING.

MC-4500 CROSS SECTION DETAIL

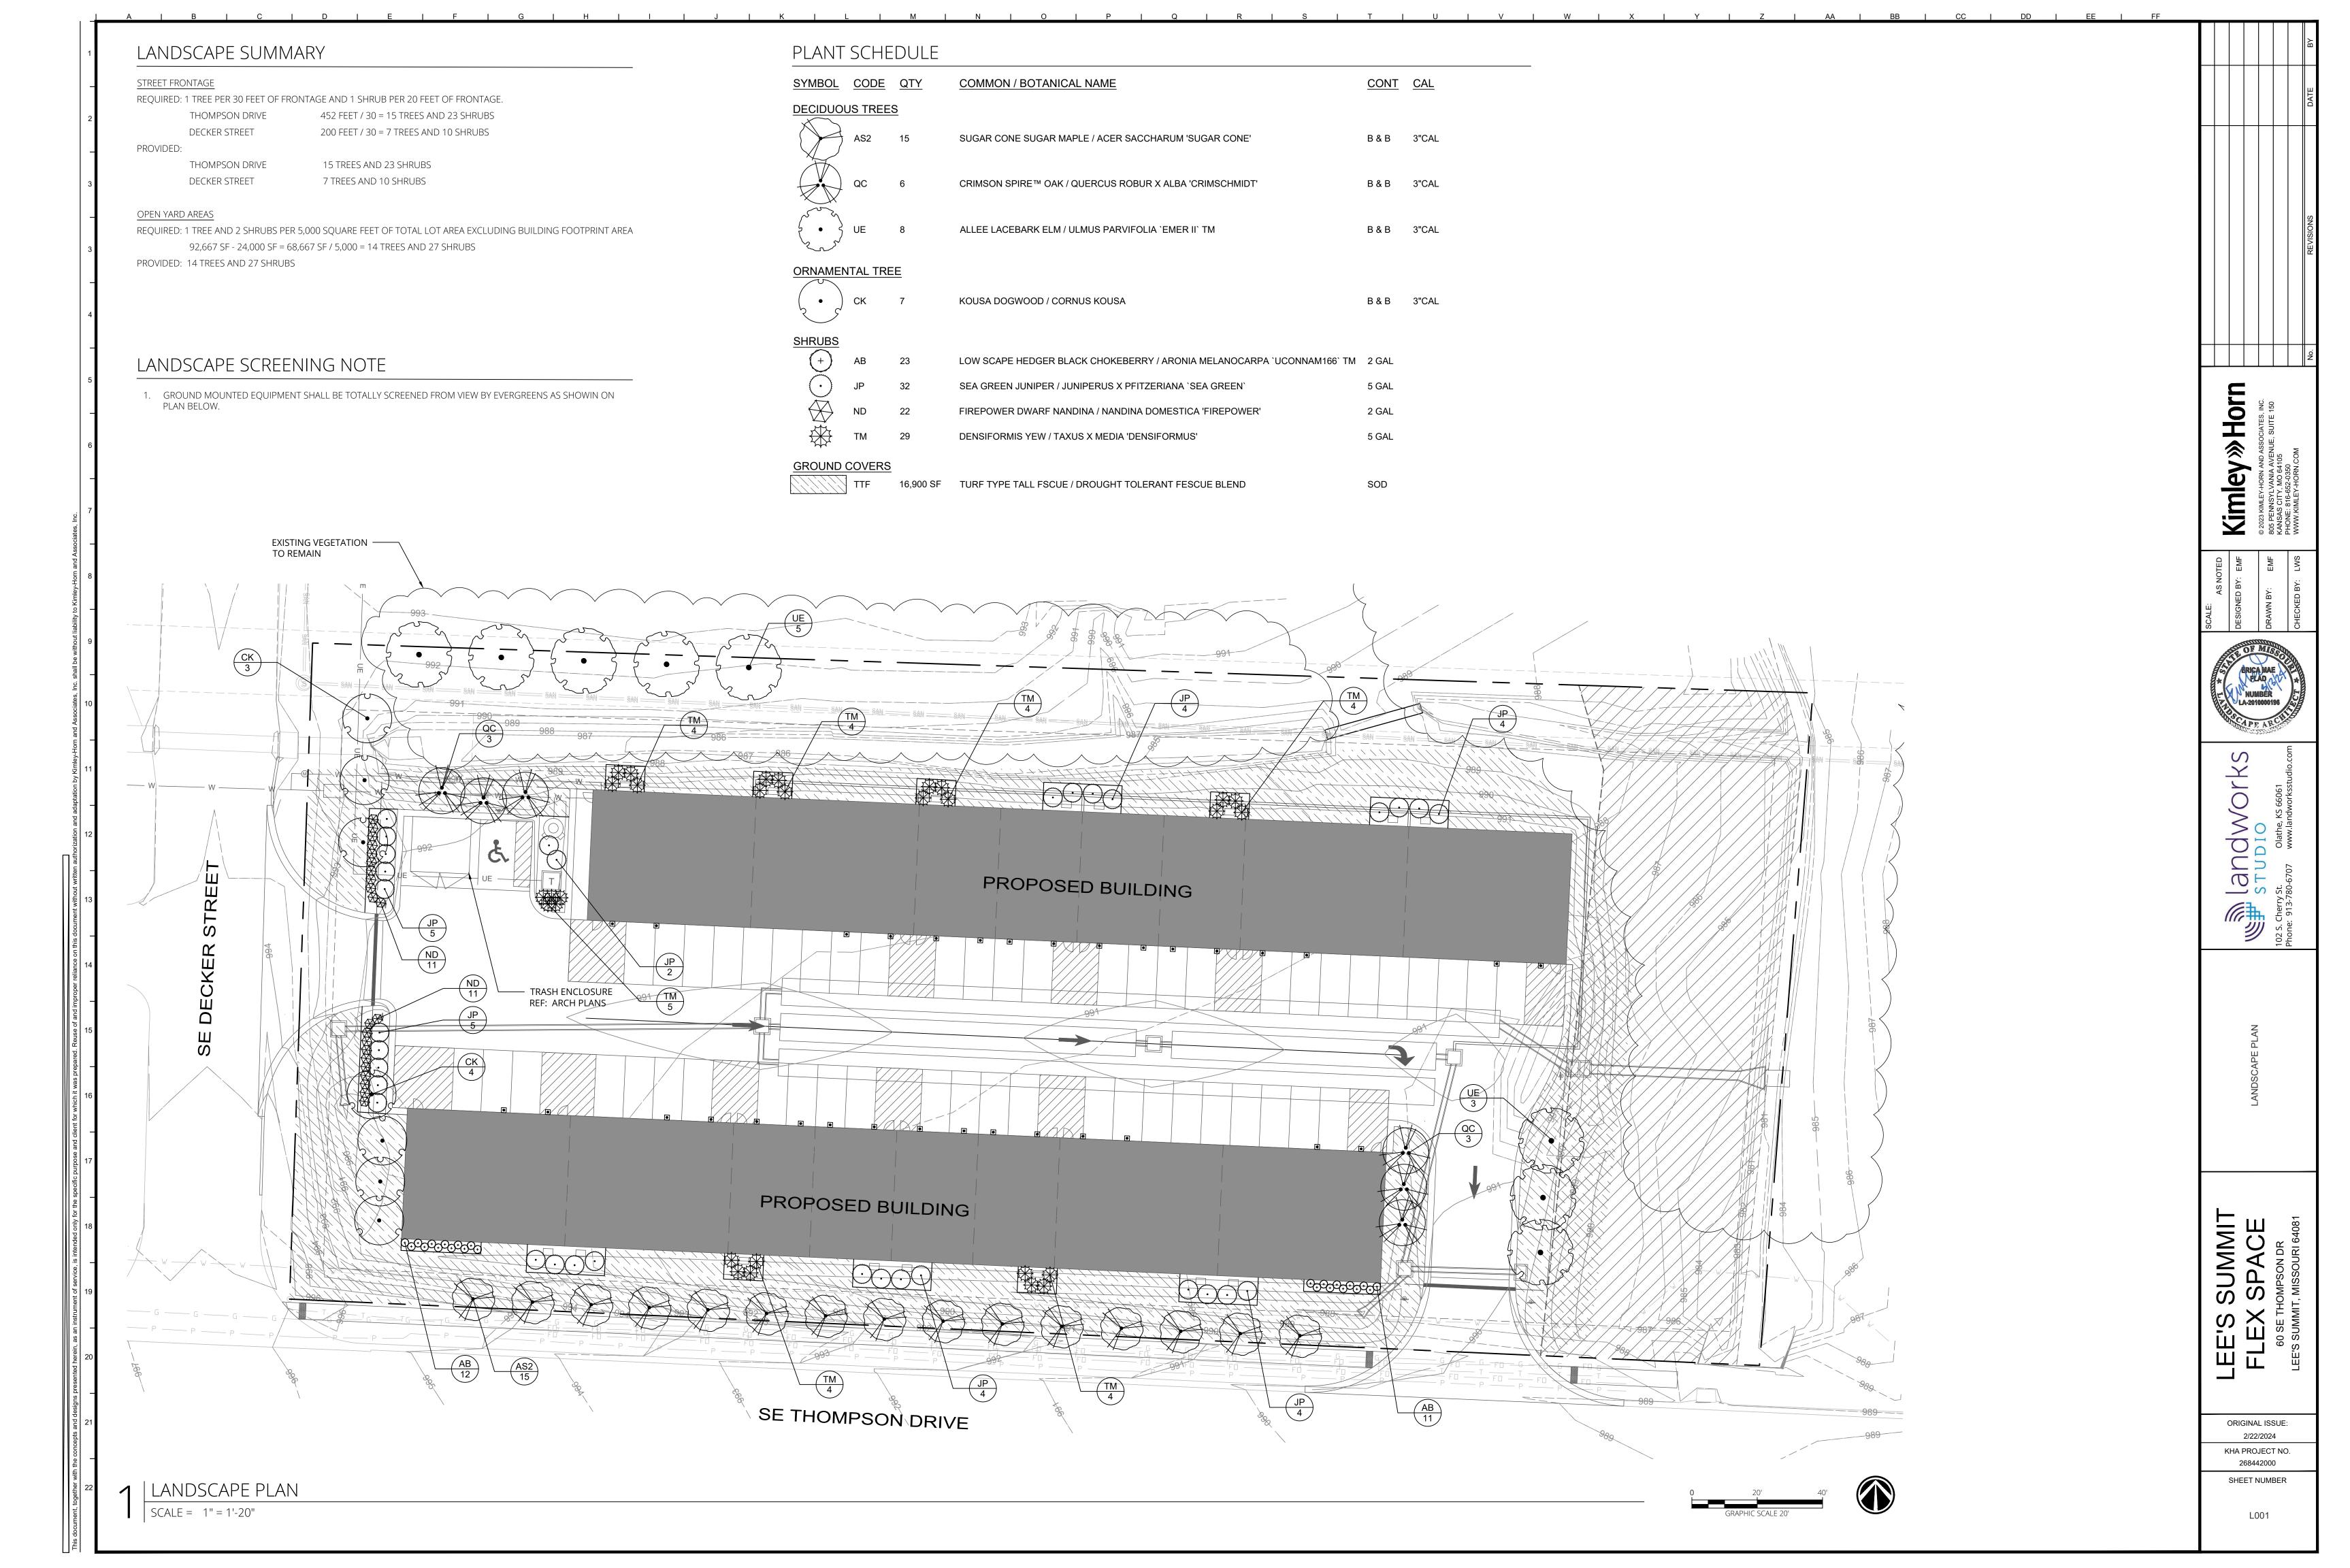


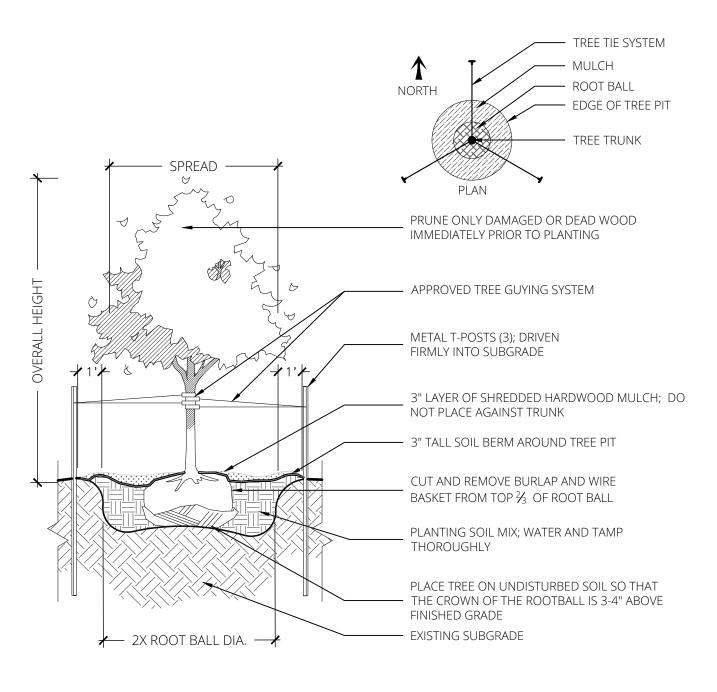


— PLACE SHRUB IN UPRIGHT POSITION - 3" LAYER OF SHREDDED HARDWOOD MULCH; DO NOT PLACE AGAINST — NON-WOVEN GEOTEXTILE FILTER FABRIC — 3" TALL SOIL BERM AROUND SHRUB PIT - REMOVE CONTAINER COMPLETELY AND PLACE SHRUB IN UPRIGHT POSITION - PLANTING SOIL MIX; WATER AND TAMP THOROUGHLY UNDISTURBED SOIL 24" LARGER THAN CONTAINER

| DECIDOUS TREE PLANTING

SCALE = 1/4" = 1'-0"

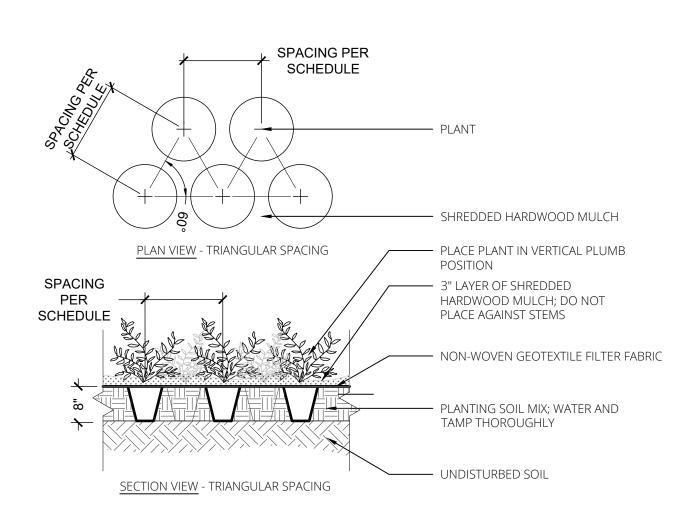

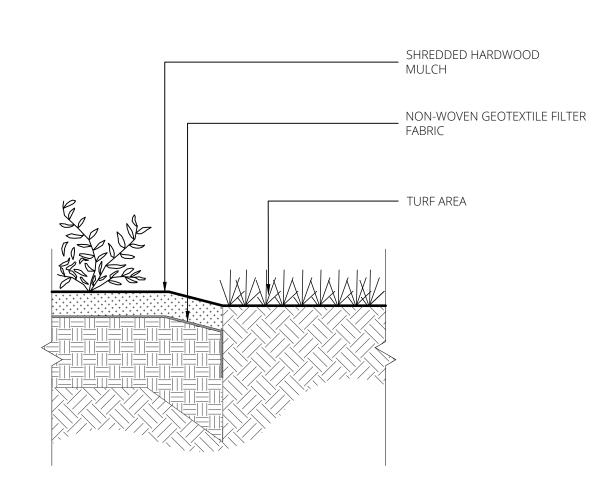

SCALE = 1/2" = 1'-0"

PLANTING NOTES

 CONTRACTOR SHALL LOCATE ALL UTILITIES BEFORE COMMENCING WORK. NOTIFY THE KANSAS ONE CALL SYSTEM AT 800-344-7233, OR 811. CONTRACTOR SHALL BE RESPONSIBLE FOR THE REPAIR OF ANY DAMAGE TO UTILITIES RESULTING FROM LANDSCAPE OPERATIONS. ANY UTILITIES SHOWN ON PLAN ARE FOR REFERENCE ONLY AND MAY OR MAY NOT DEPICT THE ACTUAL LOCATION OF SERVICES.

2. NO MATERIAL SUBSTITUTIONS SHALL BE MADE WITHOUT LANDSCAPE ARCHITECT'S APPROVAL. ALTERNATE MATERIALS OF SIMILAR SIZE AND CHARACTER MAY BE CONSIDERED IF SPECIFIED PLANT MATERIALS CANNOT BE OBTAINED. LANDSCAPE ARCHITECT RESERVES THE RIGHT TO REVISE PLANT LIST AS DEEMED NECESSARY.

3. QUANTITIES OF MATERIALS SHOWN ON THE PLANTING PLAN TAKE PRECEDENCE OVER QUANTITIES SHOWN ON THE PLANT MATERIAL SCHEDULE. CONTRACTOR SHALL BE

RESPONSIBLE FOR VERIFYING ALL QUANTITIES ON THE PLANTING PLAN PRIOR TO BIDDING. REPORT ANY DISCREPANCIES IN THE PLANTING PLAN TO THE LANDSCAPE ARCHITECT, PRIOR TO PURCHASING MATERIALS OR STARTING CONSTRUCTION.

 ALL DISTURBED AREAS NOT COVERED BY BUILDING, PAVEMENT, OR PLANTING BED SHALL BE BROUGHT TO FINISH GRADE AND PLANTED IN TURF-TYPE TALL FESCUE OR OTHER.

6. CONTRACTOR SHALL PROVIDE OWNER'S REPRESENTATIVE WITH SOIL TEST ANALYSIS REPORTS FOR EACH SAMPLE OF EXISTING SOIL, TOPSOIL, COMPOST, AND PLANTING SOIL MIX PRIOR TO PLANTING PREPARATION. ANALYSES SHALL INCLUDE, BUT NOT BE LIMITED TO, THE FOLLOWING PARAMETERS: PARTICLE SIZE ANALYSIS (% DRY WEIGHT), USDA SOIL TEXTURE, pH AND BUFFER pH, ORGANIC CONTENT (% DRY WEIGHT), MOISTURE CONTENT (% WET WEIGHT), PHYSICAL CONTAMINANTS (% DRY WEIGHT), AND NUTRIENT LEVELS (NITROGEN, PHOSPHORUS

7. ALL PLANTING BEDS SHALL BE AMENDED WITH A PLANTING SOIL MIX CONSISTING OF EXISTING SOIL, TOPSOIL, AND COMPOST TO MAKE A NEW SOIL THAT MEETS THE PROJECT GOALS FOR THE INDICATED PLANTING AREAS. REFER TO SPECIFICATION SECTION 32 91 13 - SOIL PREPARATION.

8. PLANT PIT BACKFILL FOR TREES AND SHRUBS SHALL BE PLANTING SOIL MIX, AS DESCRIBED IN ABOVE NOTE.

9. MOUND ALL PLANTING BEDS NOT ADJACENT TO BUILDINGS. PROVIDE POSITIVE DRAINAGE AROUND ALL PLANTING BEDS.

PLANTING MATERIALS

 ALL PLANT MATERIAL SHALL BE WELL-FORMED AND DEVELOPED IN GOOD CONDITION, HEALTHY AND DISEASE-FREE, AND BE TYPICAL OF THE SPECIES. PLANTS SHALL COMPLY WITH ACCEPTABLE STANDARDS AS SET FORTH IN THE AMERICAN HORT "AMERICAN STANDARD OF

11. ALL PLANT MATERIALS SHALL BE PROTECTED FROM THE DRYING ACTION OF THE SUN AND WIND AFTER BEING DUG, WHILE BEING TRANSPORTED, AND WHILE AWAITING PLANTING. BALLS OF PLANTS WHICH CANNOT BE PLANTED IMMEDIATELY SHALL BE PROTECTED FROM DRYING ACTION BY COVERING THEM WITH MOIST MULCH. PERIODICALLY, APPLY WATER TO MULCH-COVERED BALLS TO KEEP MOIST. IF PLANTING SHOULD OCCUR DURING GROWING SEASON, APPLY ANTI-DESSICANT TO LEAVES BEFORE TRANSPORT TO REDUCE LIKELIHOOD OF WINDBURN. REAPPLY ANTI-DESSICANT AFTER PLANTING TO REDUCE TRANSPIRATION.

12. PLANTS DESIGNATED AS CONTAINER GROWN SHALL HAVE BEEN GROWN IN POTS, CANS OR BOXES FOR A MINIMUM OF SIX MONTHS AND A MAXIMUM OF TWO YEARS. THESE PLANTS SHALL BE REMOVED FROM CONTAINERS BEFORE PLANTING. PLANTS THAT APPEAR ROOT-BOUND SHALL BE REJECTED.

13. ALL PLANT LOCATIONS ARE APPROXIMATE, ADJUST AS NECESSARY TO AVOID CONFLICTS. THE FOLLOWING APPLIES FOR GENERAL PLANT LOCATIONS:

- a. CREEPING GROUNDCOVER SHALL BE LOCATED A MINIMUM OF 6 INCHES FROM EDGE
- b. ALL SHRUBS SHALL BE LOCATED A MINIMUM OF 2 FEET FROM EDGE OF PAVEMENT
- AND 4 FEET FROM BUILDINGS.
- c. ALL TREES SHALL BE LOCATED A MINIMUM OF 2.5 FEET FROM EDGE OF PAVEMENT. d. EQUALLY SPACE ALL PLANTS OF THE SAME SPECIES FOR BEST VIEWING.

PLANTING SOIL MIX

15. A MIX OF EXISTING SOIL, TOPSOIL, AND COMPOST TO MAKE A NEW SOIL THAT MEETS THE PROJECT GOALS FOR THE INDICATED PLANTING AREAS. THESE WILL BE MIXED ON-SITE, AND WILL CONSIST OF THE MIX COMPONENTS AND IN THE PROPORTIONS AS INDICATED:

A MIX OF EXISTING SOIL, TOPSOIL, AND COMPOST IN THE FOLLOWING RATIO:

MIX COMPONENT % BY MOIST VOLUME

EXISTING SOIL

TOPSOIL (UNSCREENED) 25-30%

COMPOST a. FINAL TESTED ORGANIC MATTER BETWEEN 2.75 AND 4% (BY DRY WEIGHT).

b. MIX THE TOPSOIL AND COMPOST TOGETHER FIRST AND THEN ADD TO THE EXISTING SOIL. MIX WITH A LOADER BUCKET TO LOOSELY INCORPORATE THE TOPSOIL/COMPOST MIX INTO THE EXISTING SOIL.

c. AT THE TIME OF FINAL GRADING, ADD LIME OR OTHER INORGANIC AMENDMENTS, ONLY IF REQUIRED, AT RATES RECOMMENDED BY THE TESTING RESULTS FOR THE PLANTS TO BE GROWN.

d. PROVIDE A TWO-GALLON SAMPLE WITH TESTING DATA THAT INCLUDES RECOMMENDATIONS FOR CHEMICAL ADDITIVES FOR THE TYPES OF PLANTS TO BE GROWN. SAMPLES AND TESTING DATA SHALL BE SUBMITTED AT THE SAME TIME.

COMPOST: BLENDED AND GROUND LEAF, WOOD AND OTHER PLANT-BASED MATERIAL, COMPOSTED FOR A MINIMUM OF 9 MONTHS AND AT TEMPERATURES ENOUGH TO BREAK DOWN ALL WOODY FIBERS, SEEDS AND LEAF STRUCTURES, FREE OF TOXIC MATERIAL AT LEVELS THAT ARE HARMFUL TO PLANTS OR HUMANS. SOURCE MATERIAL SHALL BE YARD WASTE TRIMMINGS BLENDED WITH OTHER PLANT OR MANURE-BASED MATERIAL DESIGNED TO PRODUCE COMPOST HIGH IN FUNGAL MATERIAL. COMPOST SHALL BE COMMERCIALLY PREPARED COMPOST AND MEET US COMPOST COUNCIL STA/TMECC CRITERIA OR AS MODIFIED IN THIS SECTION FOR "COMPOST AS A LANDSCAPE BACKFILL MIX COMPONENT".

a. COMPOST SHALL COMPLY WITH THE FOLLOWING PARAMETERS:

a.a. PH: 5.5 - 8.0.

- a.b. SOIL SALT (ELECTRICAL CONDUCTIVITY): MAXIMUM 5 DS/M (MMHOS/CM).
- a.c. MOISTURE CONTENT %, WET WEIGHT BASIS: 30 60.
- a.d. PARTICLE SIZE, DRY WEIGHT BASIS: 98% PASS THROUGH 3/4 INCH SCREEN OR
- a.e. STABILITY CARBON DIOXIDE EVOLUTION RATE: MG CO_2 -C/ G OM/ DAY < 2.
- a.f. SOLVITA MATURITY TEST: >6.
- a.g. PHYSICAL CONTAMINANTS (INERTS), %, DRY WEIGHT BASIS: <1%.
- a.h. CHEMICAL CONTAMINANTS, MG/KG (PPM): MEET OR EXCEED US EPA CLASS A STANDARD, 40CFR § 503.13, TABLES 1 AND 3 LEVELS.
- a.i. BIOLOGICAL CONTAMINANTS SELECT PATHOGENS FECAL COLIFORM BACTERIA, OR SALMONELLA, MEET OR EXCEED US EPA CLASS A STANDARD, 40 CFR § 503.32(A) LEVEL REQUIREMENTS.

17. PROVIDE A ONE QUART SAMPLE WITH MANUFACTURER'S LITERATURE AND MATERIAL CERTIFICATION THAT THE PRODUCT MEETS THE REQUIREMENTS.

18. INORGANIC SOIL AMENDMENTS

- a. LIME: ASTM C 602, AGRICULTURAL LIMING MATERIAL CONTAINING A MINIMUM OF 80 PERCENT CALCIUM CARBONATE EQUIVALENT AND AS FOLLOWS:
- a.a. CLASS: T, WITH A MINIMUM OF 99 PERCENT PASSING THROUGH A NO. 8 SIEVE
- AND A MINIMUM OF 75 PERCENT PASING THROUGH A NO. 60 SIEVE. a.b. FORM: PROVIDE LIME IN FORM OF GROUND DOLOMITIC LIMESTONE.

19. SOIL TESTING FOR TOPSOIL, EXISTING SOIL, COMPOST, PLANTING MIXES

a. SUBMIT SOIL TEST ANALYSIS REPORT FOR EACH SAMPLE OF TOPSOIL. EXISTING SOIL. COMPOST AND PLANTING SOIL FROM AN APPROVED SOIL-TESTING LABORATORY, AS FOLLOWS: SUBMIT TOPSOIL, EXISTING SOIL, AND COMPOST FOR TESTING AT LEAST 8 WEEKS BEFORE SCHEDULED INSTALLATION OF PLANTING SOIL MIXES. SUBMIT PLANTING SOIL MIX TEST NO MORE THAN 2 WEEKS AFTER THE APPROVAL OF THE TOPSOIL, EXISTING SOIL, AND COMPOST. DO NOT SUBMIT PLANTING SOIL MIXES TO THE TESTING LABORATORY FOR TESTING UNTIL ALL TOPSOIL, EXISTING SOIL, AND COMPOST RESULTS HAVE BEEN APPROVED. IF TESTS FAIL TO MEET THE SPECIFICATIONS, OBTAIN OTHER SOURCES OF MATERIAL, RETEST AND RESUBMIT UNTIL ACCEPTED BY THE OWNER'S REPRESENTATIVE. ALL SOIL TESTING WILL BE AT THE EXPENSE OF THE CONTRACTOR.

20. FOR EACH TOPSOIL, EXISTING SOIL, AND PLANTING SOIL MIX SAMPLE, SUBMIT THE FOLLOWING ANALYSES:

a. PARTICLE SIZE ANALYSIS (% DRY WEIGHT)

b. USDA SOIL TEXTURE c. PH AND BUFFER PH.

d. PERCENT ORGANIC CONTENT BY OVEN DRIED WEIGHT.

e. NUTRIENT LEVELS BY PARTS PER MILLION INCLUDING: PHOSPHORUS, POTASSIUM, MAGNESIUM, MANGANESE, IRON, ZINC AND CALCIUM. NUTRIENT TEST SHALL INCLUDE THE TESTING LABORATORY RECOMMENDATIONS FOR SUPPLEMENTAL ADDITIONS TO THE SOIL FOR OPTIMUM GROWTH OF THE PLANTINGS SPECIFIED.

f. SOLUBLE SALT BY ELECTRICAL CONDUCTIVITY OF A 1:2 SOIL WATER SAMPLE MEASURED IN MILLIOHM PER CM.

g. CATION EXCHANGE CAPACITY (CEC).

21. FOR EACH COMPOST PRODUCT, SUBMIT THE FOLLOWING ANALYSES:

b. SALT CONCENTRATION (ELECTRICAL CONDUCTIVITY)

c. MOISTURE CONTENT %, WET WEIGHT BASIS

d. PARTICLE SIZE % PASSING A SELECTED MESH SIZE, DRY WEIGHT BASIS

e. STABILITY CARBON DIOXIDE EVOLUTION RATE MG CO2-C PER G OM PER DAY f. PHYSICAL CONTAMINANTS (INERTS) %, DRY WEIGHT BASIS

g. US EPA CLASS A STANDARD, 40CFR § 503.13, TABLES 1 AND 3 LEVELS CHEMICAL

CONTAMINANTS MG/KG (PPM)

22. IT IS THE RESPONSIBILITY OF THE CONTRACTOR TO BE AWARE OF ALL SURFACE AND SUBSURFACE CONDITIONS, AND TO NOTIFY THE OWNER'S REPRESENTATIVE, IN WRITING, OF ANY CIRCUMSTANCES THAT WOULD NEGATIVELY IMPACT THE HEALTH OF PLANTINGS. DO NOT PROCEED WITH WORK UNTIL UNSATISFACTORY CONDITIONS HAVE BEEN CORRECTED.

23. SHOULD SUBSURFACE DRAINAGE OR SOIL CONDITIONS BE ENCOUNTERED WHICH WOULD BE DETRIMENTAL TO GROWTH OR SURVIVAL OF PLANT MATERIAL, THE CONTRACTOR SHALL NOTIFY THE OWNER'S REPRESENTATIVE IN WRITING, STATING THE CONDITIONS AND SUBMIT A PROPOSAL COVERING COST OF CORRECTIONS. IF THE CONTRACTOR FAILS TO NOTIFY THE OWNER'S REPRESENTATIVE OF SUCH CONDITIONS, THEY SHALL REMAIN RESPONSIBLE FOR PLANT MATERIAL UNDER THE WARRANTEE CLAUSE OF THE SPECIFICATIONS.

24. DELIVERY, STORAGE, AND HANDLING

a. WEATHER: DO NOT MIX, DELIVER, PLACE OR GRADE SOILS WHEN FROZEN OR WITH MOISTURE ABOVE FIELD CAPACITY.

b. PROTECT SOIL AND SOIL STOCKPILES, INCLUDING THE STOCKPILES AT THE SOIL BLENDER'S YARD, FROM WIND, RAIN AND WASHING THAT CAN ERODE SOIL OR SEPARATE FINES AND COARSE MATERIAL, AND CONTAMINATION BY CHEMICALS, DUST AND DEBRIS THAT MAY BE DETRIMENTAL TO PLANTS OR SOIL DRAINAGE. COVER STOCKPILES WITH PLASTIC SHEETING OR FABRIC AT THE END OF EACH WORKDAY.

c. ALL MANUFACTURED PACKAGED PRODUCTS AND MATERIAL SHALL BE DELIVERED TO THE SITE IN UNOPENED CONTAINERS AND STORED IN A DRY ENCLOSED SPACE SUITABLE FOR THE MATERIAL AND MEETING ALL ENVIRONMENTAL REGULATIONS. BIOLOGICAL ADDITIVES SHALL BE PROTECTED FROM EXTREME COLD AND HEAT. ALL PRODUCTS SHALL BE FRESHLY MANUFACTURED AND DATED FOR THE YEAR IN WHICH THE PRODUCTS ARE

d. DELIVER ALL CHEMICAL AMENDMENTS IN ORIGINAL, UNOPENED CONTAINERS WITH ORIGINAL LABELS INTACT AND LEGIBLE, WHICH STATE THE GUARANTEED CHEMICAL ANALYSIS. STORE ALL CHEMICALS IN A WEATHER PROTECTED ENCLOSURE.

25. EDGING: ALL PLANT BEDS AND TURF AREAS MUST BE SEPARATED WITH A CULTIVATED EDGE, AS SHOWN IN THE DETAIL ON THIS SHEET.

26. MULCH: APPLY A 3" LAYER OF SHREDDED HARDWOOD BARK MULCH IN PLANTING BEDS AND AROUND TREES. MULCH SHALL CONSIST OF PURE WOOD, BROWN IN COLOR AND BE FREE OF ALL FOREIGN SUBSTANCES. PROVIDE AND INSTALL PRE-EMERGENT HERBICIDE PRIOR TO MULCH INSTALLATION PER MANUFACTURERS INSTRUCTIONS.

27. TREE TIES: CONTRACTOR SHALL USE AN APPROVED TREE TIE SYSTEM. TREE GUYING TO BE FLAT WOVEN POLYPROPYLENE MATERIAL, 3/4-INCH-WIDE, WITH A TENSILE STRENGTH OF 900 LBS. HOSE AND WIRE WILL NOT BE ACCEPTED. SUBJECT TO COMPLIANCE WITH THESE REQUIREMENTS, PROVIDE ONE OF THE FOLLOWING PRODUCTS, OR APPROVED EQUAL:

"ARBORTIE GREEN" MANUFACTURED BY DEEP ROOT PARTNERS, LP

"LEONARD TREE TIE WEBBING GREEN" MANUFACTURED BY A.M. LEONARD. INC. MAINTENANCE AND CLEAN-UP

28. THE CONTRACTOR SHALL PROVIDE ALL WATER, WATERING DEVICES AND LABOR NEEDED TO IRRIGATE PLANT MATERIALS UNTIL PROVISIONAL ACCEPTANCE OF THE PROJECT. THE CONTRACTOR SHALL SUPPLY ENOUGH WATER TO MAINTAIN THE PLANT'S HEALTHY CONDITION.

29. REMOVE ALL RUBBISH, EQUIPMENT, AND MATERIAL AND LEAVE THE AREA IN A NEAT, CLEAN CONDITION EACH DAY. MAINTAIN PAVED AREAS UTILIZED FOR HAULING EQUIPMENT AND MATERIALS BY OTHER TRADES IN A CLEAN AND UNOBSTRUCTED CONDITION AT ALL TIMES. REMOVE SOIL OR DIRT THAT ACCUMULATES DUE TO PLANTING OPERATIONS EACH DAY.


INSPECTION, WARRANTIES AND GUARANTEE

30. AT THE COMPLETION OF PLANTING OPERATIONS, ALL PLANTS SHALL BE INSPECTED BY A LICENSED LANDSCAPE ARCHITECT TO VERIFY THAT ALL LANDSCAPING HAS BEEN INSTALLED IN ACCORDANCE WITH THE APPROVED PLANTING PLAN AND IS IN A HEALTHY CONDITION. CONTRACTOR SHALL REPLACE IMMEDIATELY ANY PLANTS NOT IN HEALTHY AND VIGOROUS CONDITION AT THAT TIME AT NO EXPENSE TO THE OWNER. ONCE IT CAN BE VERIFIED THAT ALL PLANTINGS CONFORM TO THE APPROVED PLAN AND ARE FOUND TO BE HEALTHY, THE LANDSCAPE ARCHITECT SHALL PREPARE AN AFFIDAVIT TESTIFYING TO THESE FACTS AND THE OWNER SHALL SUBMIT IT TO CITY STAFF.

31. OWNER'S REPRESENTATIVE RESERVES THE RIGHT TO REJECT AT ANY TIME OR PLACE PRIOR TO FINAL ACCEPTANCE OF WORK, ANY AND ALL PLANTS WHICH, IN THEIR OPINION, FAIL TO MEET THESE SPECIFICATION REQUIREMENTS.

32. CONTRACTOR SHALL GUARANTEE TREES, SHRUBS, PERENNIALS AND TURF FOR ONE CALENDAR YEAR FOLLOWING PROVISIONAL ACCEPTANCE OF THE OVERALL PROJECT. DURING THE GUARANTEE PERIOD, PLANTS THAT DIE DUE TO NATURAL CAUSES OR THAT ARE UNHEALTHY OR UNSIGHTLY IN CONDITION, SHALL BE REPLACED BY THE CONTRACTOR. PLANTS USED FOR THE REPLACEMENT SHALL BE OF THE SAME VARIETY AND SIZE AS ORIGINALLY SPECIFIED IN THE PLANT SCHEDULE. REPLACEMENTS SHALL BE MADE WITHIN ONE WEEK OF REQUEST PENDING FAVORABLE SEASONAL PLANTING CONDITIONS. GUARANTEE WILL NOT BE ENFORCED SHOULD THE PLANT MATERIAL DIE DUE TO VANDALISM, OVER OR UNDER WATERING BY THE OWNER, IMPROPER MAINTENANCE PROCEDURES CARRIED OUT BY THE OWNER INVOLVING LAWN MOWER DAMAGE, OVER FERTILIZATION, ACTS NOT RELATED TO CONTRACTUAL RESPONSIBILITIES OF CONTRACTOR OR SIMILAR CIRCUMSTANCES BEYOND THE CONTROL OF THE CONTRACTOR.

0

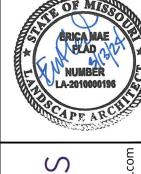

Q F


ORIGINAL ISSUE: 2/22/2024

KHA PROJECT NO.


268442000

田田

SHEET NUMBER

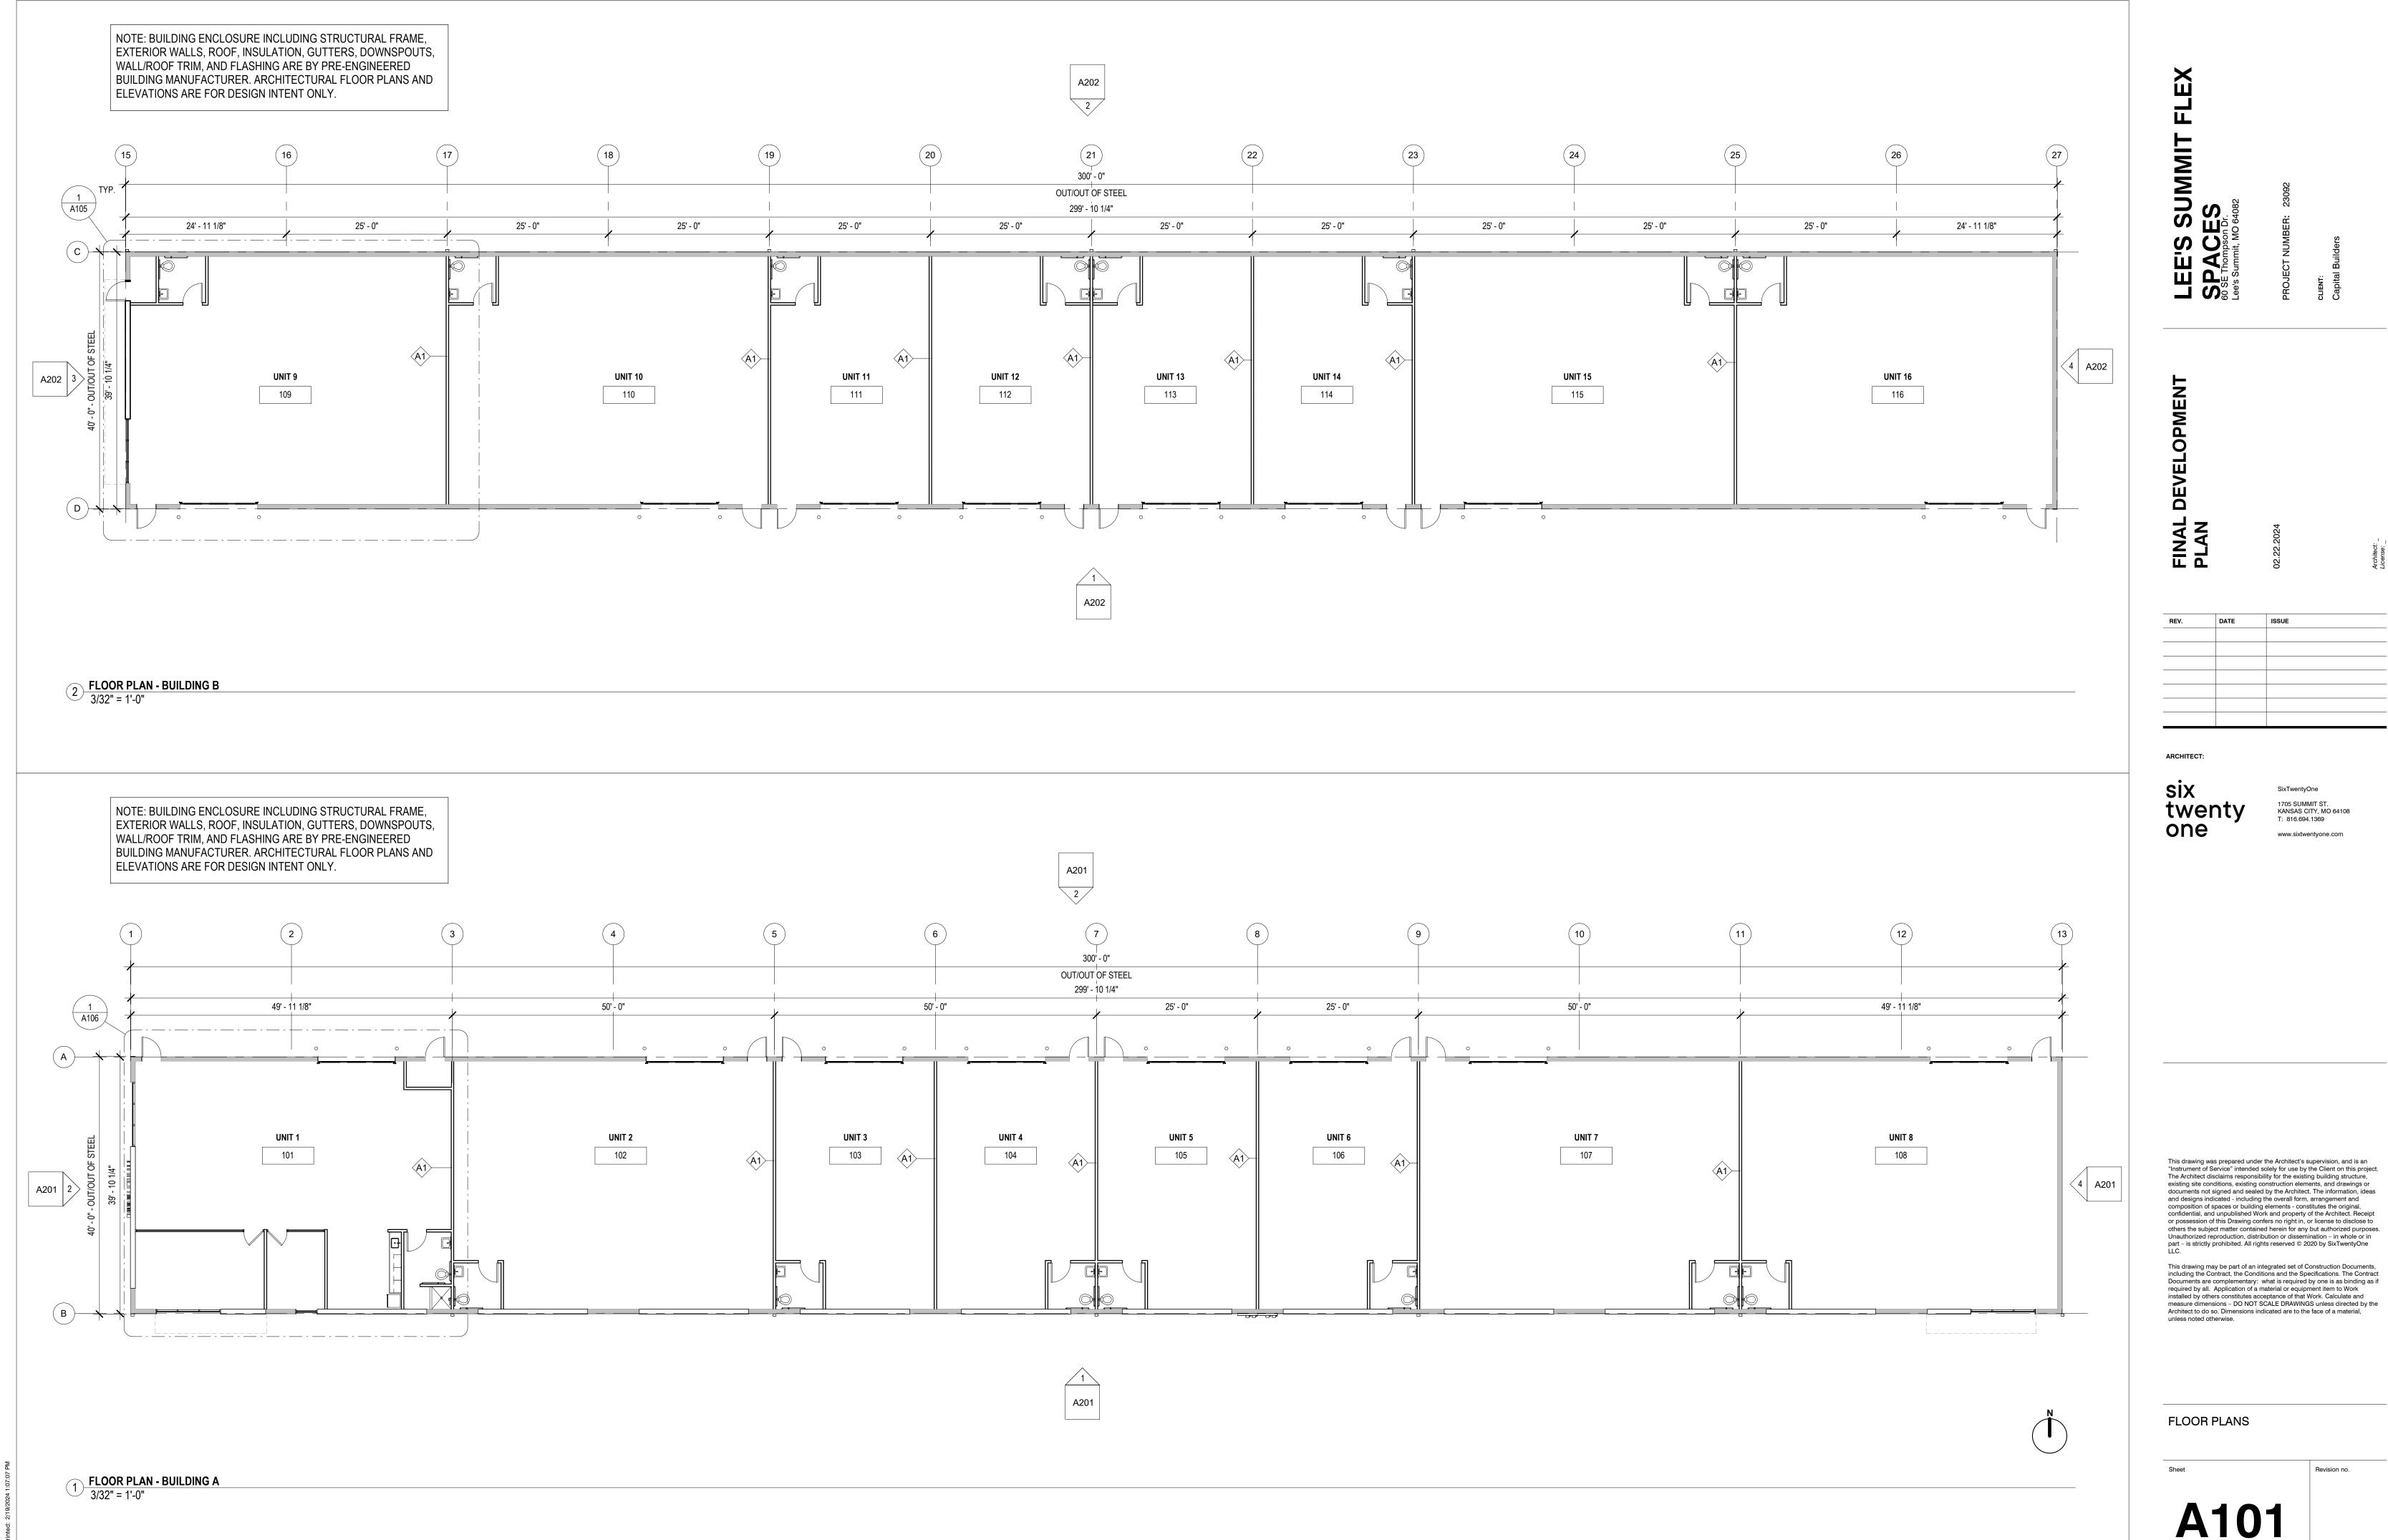

installed by others constitutes acceptance of that Work. Calculate and measure dimensions – DO NOT SCALE DRAWINGS unless directed by the

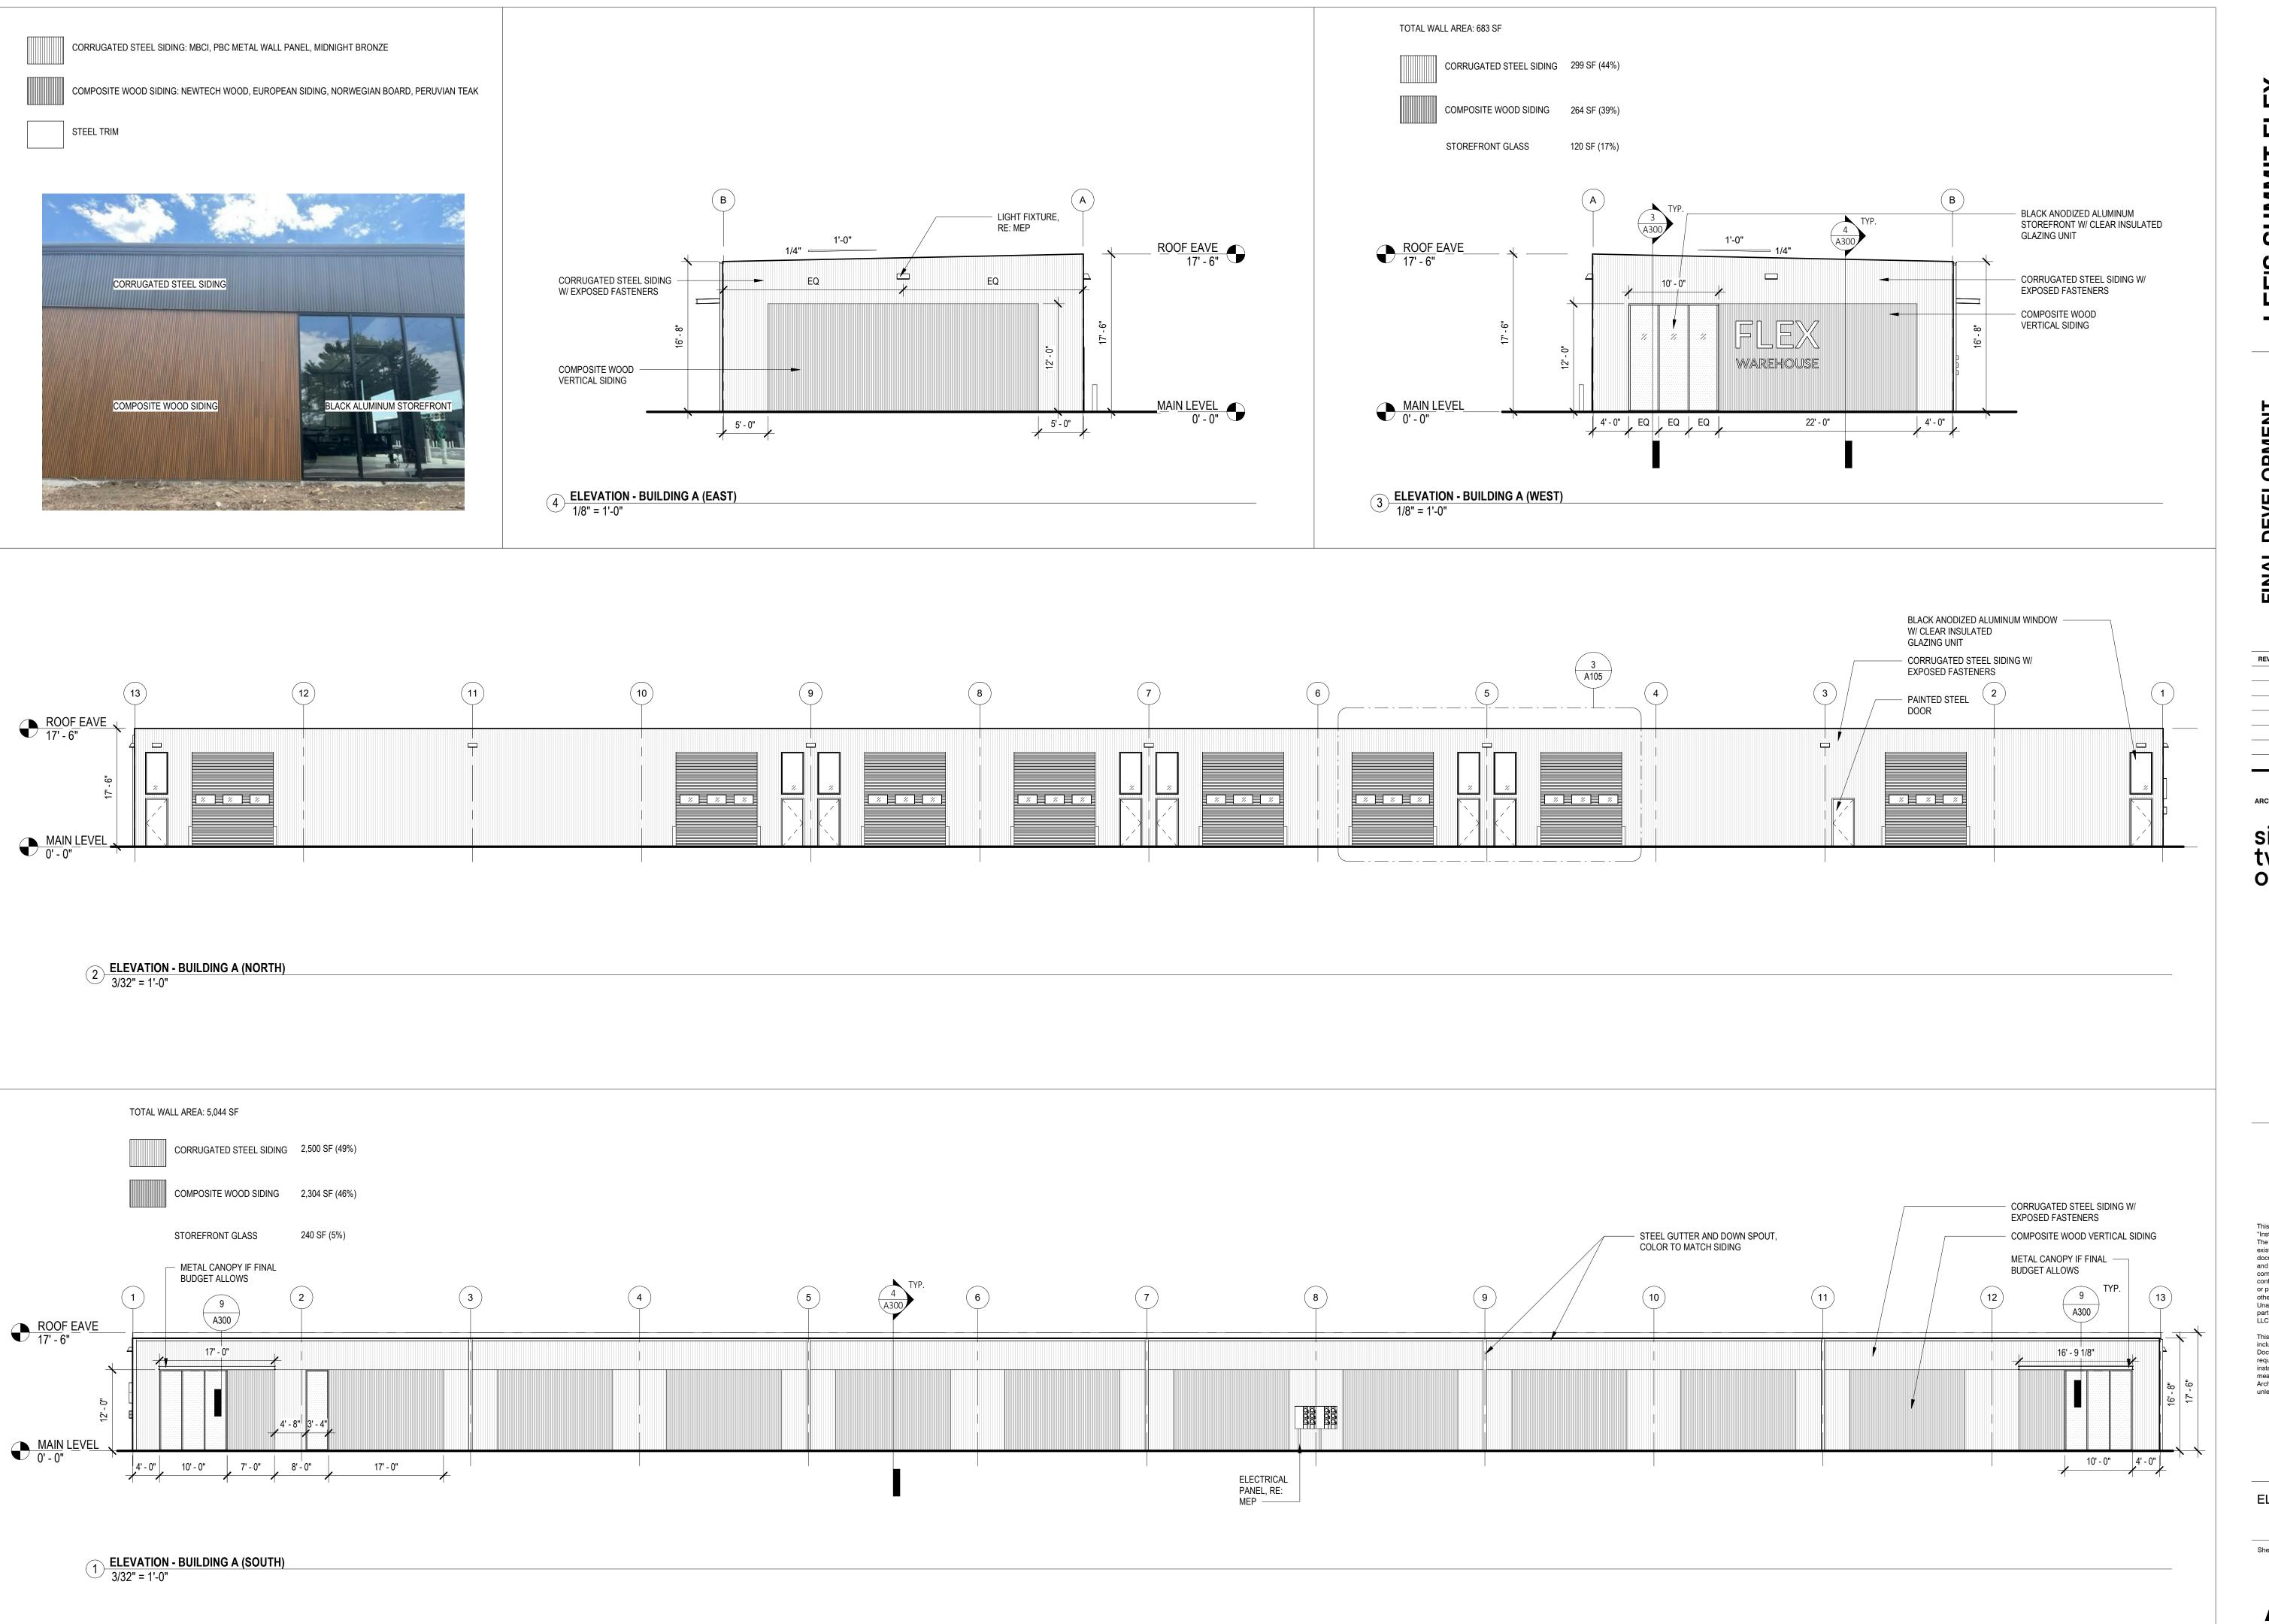

SUMMIT ES

DEVELOPMENT

DATE


twenty

T: 816.694.1369 www.sixtwentyone.com

This drawing was prepared under the Architect's supervision, and is an "Instrument of Service" intended solely for use by the Client on this project. The Architect disclaims responsibility for the existing building structure, existing site conditions, existing construction elements, and drawings or documents not signed and sealed by the Architect. The information, ideas and designs indicated - including the overall form, arrangement and composition of spaces or building elements - constitutes the original, confidential, and unpublished Work and property of the Architect. Receipt or possession of this Drawing confers no right in, or license to disclose to others the subject matter contained herein for any but authorized purposes. Unauthorized reproduction, distribution or dissemination – in whole or in part – is strictly prohibited. All rights reserved © 2020 by SixTwentyOne

This drawing may be part of an integrated set of Construction Documents, including the Contract, the Conditions and the Specifications. The Contract Documents are complementary: what is required by one is as binding as if required by all. Application of a material or equipment item to Work installed by others constitutes acceptance of that Work. Calculate and measure dimensions – DO NOT SCALE DRAWINGS unless directed by the Architect to do so. Dimensions indicated are to the face of a material, unless noted otherwise.

ELEVATIONS - BUILDING A

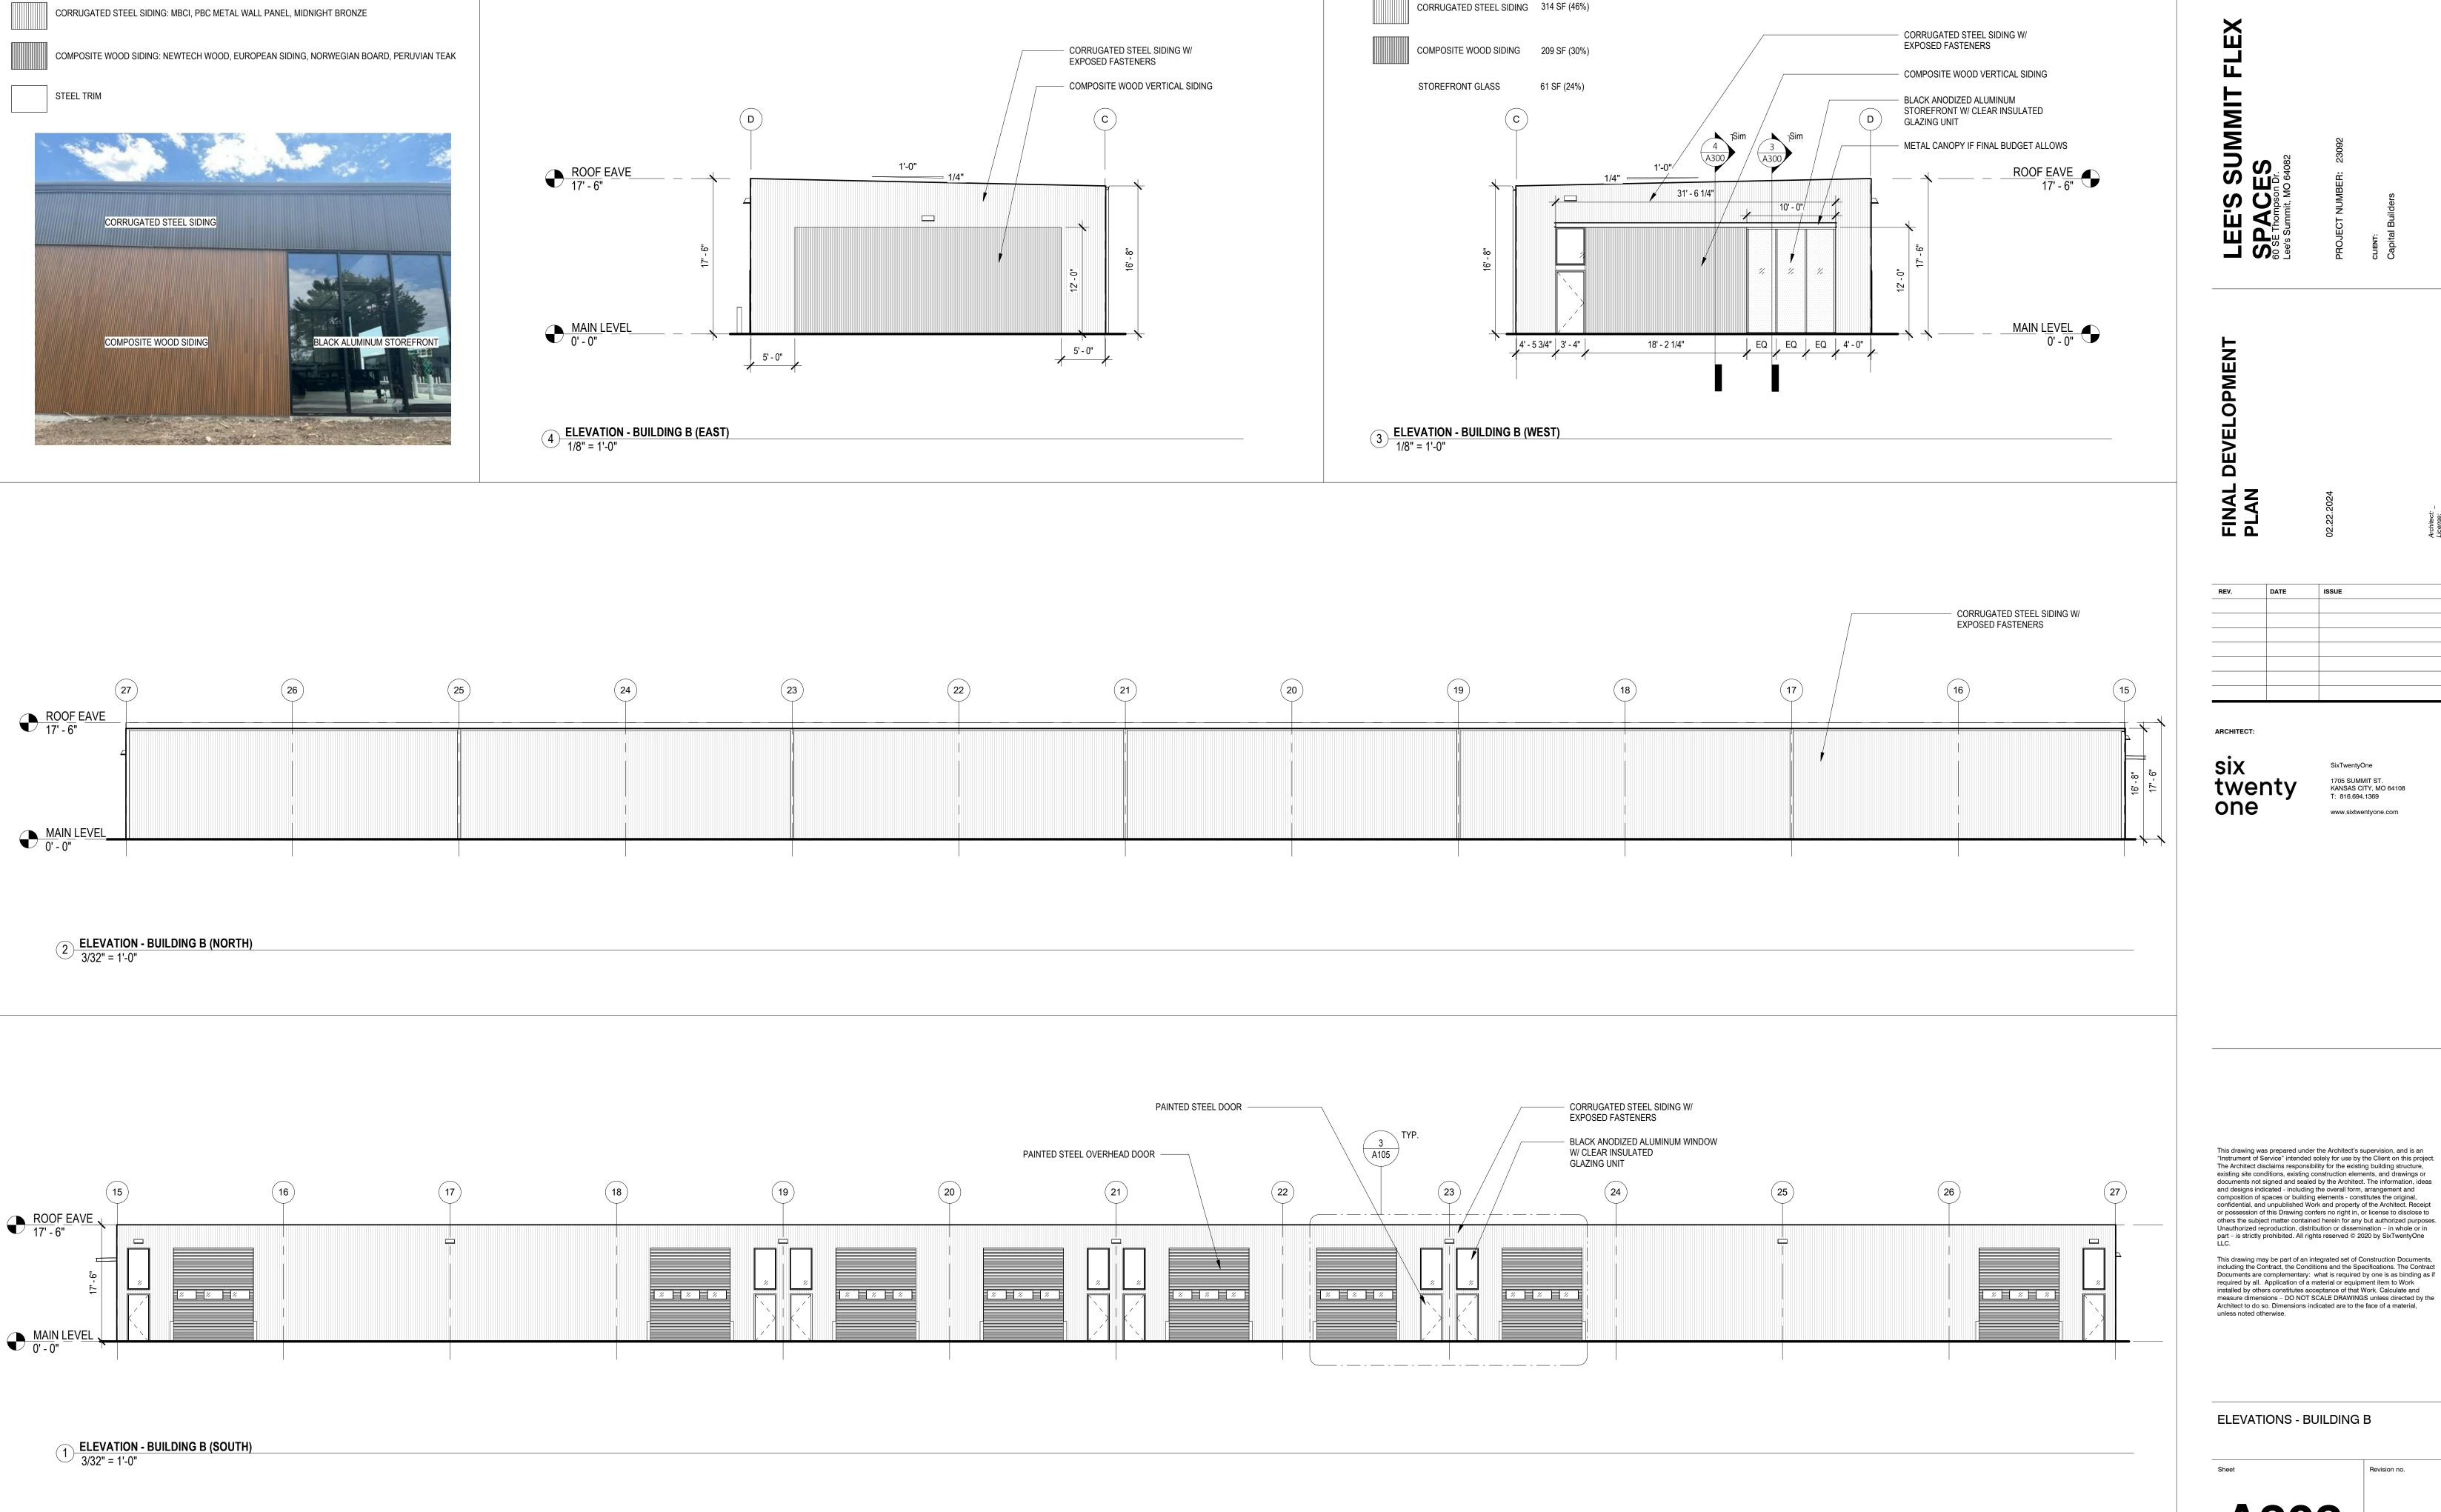

TOTAL WALL AREA: 683 SF

or possession of this Drawing confers no right in, or license to disclose to others the subject matter contained herein for any but authorized purposes.

Unauthorized reproduction, distribution or dissemination – in whole or in part – is strictly prohibited. All rights reserved © 2020 by SixTwentyOne This drawing may be part of an integrated set of Construction Documents, including the Contract, the Conditions and the Specifications. The Contract Documents are complementary: what is required by one is as binding as if required by all. Application of a material or equipment item to Work installed by others constitutes acceptance of that Work. Calculate and measure dimensions – DO NOT SCALE DRAWINGS unless directed by the Architect to do so. Dimensions indicated are to the face of a material, unless noted otherwise.

T: 816.694.1369

www.sixtwentyone.com

ELEVATIONS - BUILDING B





BUILDING A - EAST AND NORTH ELEVATIONS



BUILDING B - WEST AND SOUTH ELEVATIONS



BUILDING B - SOUTH AND EAST ELEVATIONS

LEE'S SUMMIT F SPACES 60 SE Thompson Dr.

DEVELOPMENT FINAL PLAN

REV.	DATE	ISSUE


twenty one

KANSAS CITY, MO 64108 T: 816.694.1369 www.sixtwentyone.com

This drawing was prepared under the Architect's supervision, and is an "Instrument of Service" intended solely for use by the Client on this project. The Architect disclaims responsibility for the existing building structure, existing site conditions, existing construction elements, and drawings or documents not signed and sealed by the Architect. The information, ideas and designs indicated - including the overall form, arrangement and composition of spaces or building elements - constitutes the original, confidential, and unpublished Work and property of the Architect. Receipt or possession of this Drawing confers no right in, or license to disclose to others the subject matter contained herein for any but authorized purposes. Unauthorized reproduction, distribution or dissemination – in whole or in part – is strictly prohibited. All rights reserved © 2020 by SixTwentyOne LLC.

This drawing may be part of an integrated set of Construction Documents, including the Contract, the Conditions and the Specifications. The Contract Documents are complementary: what is required by one is as binding as if required by all. Application of a material or equipment item to Work installed by others constitutes acceptance of that Work. Calculate and measure dimensions – DO NOT SCALE DRAWINGS unless directed by the Architect to do so. Dimensions indicated are to the face of a material, unless noted otherwise.

RENDERINGS

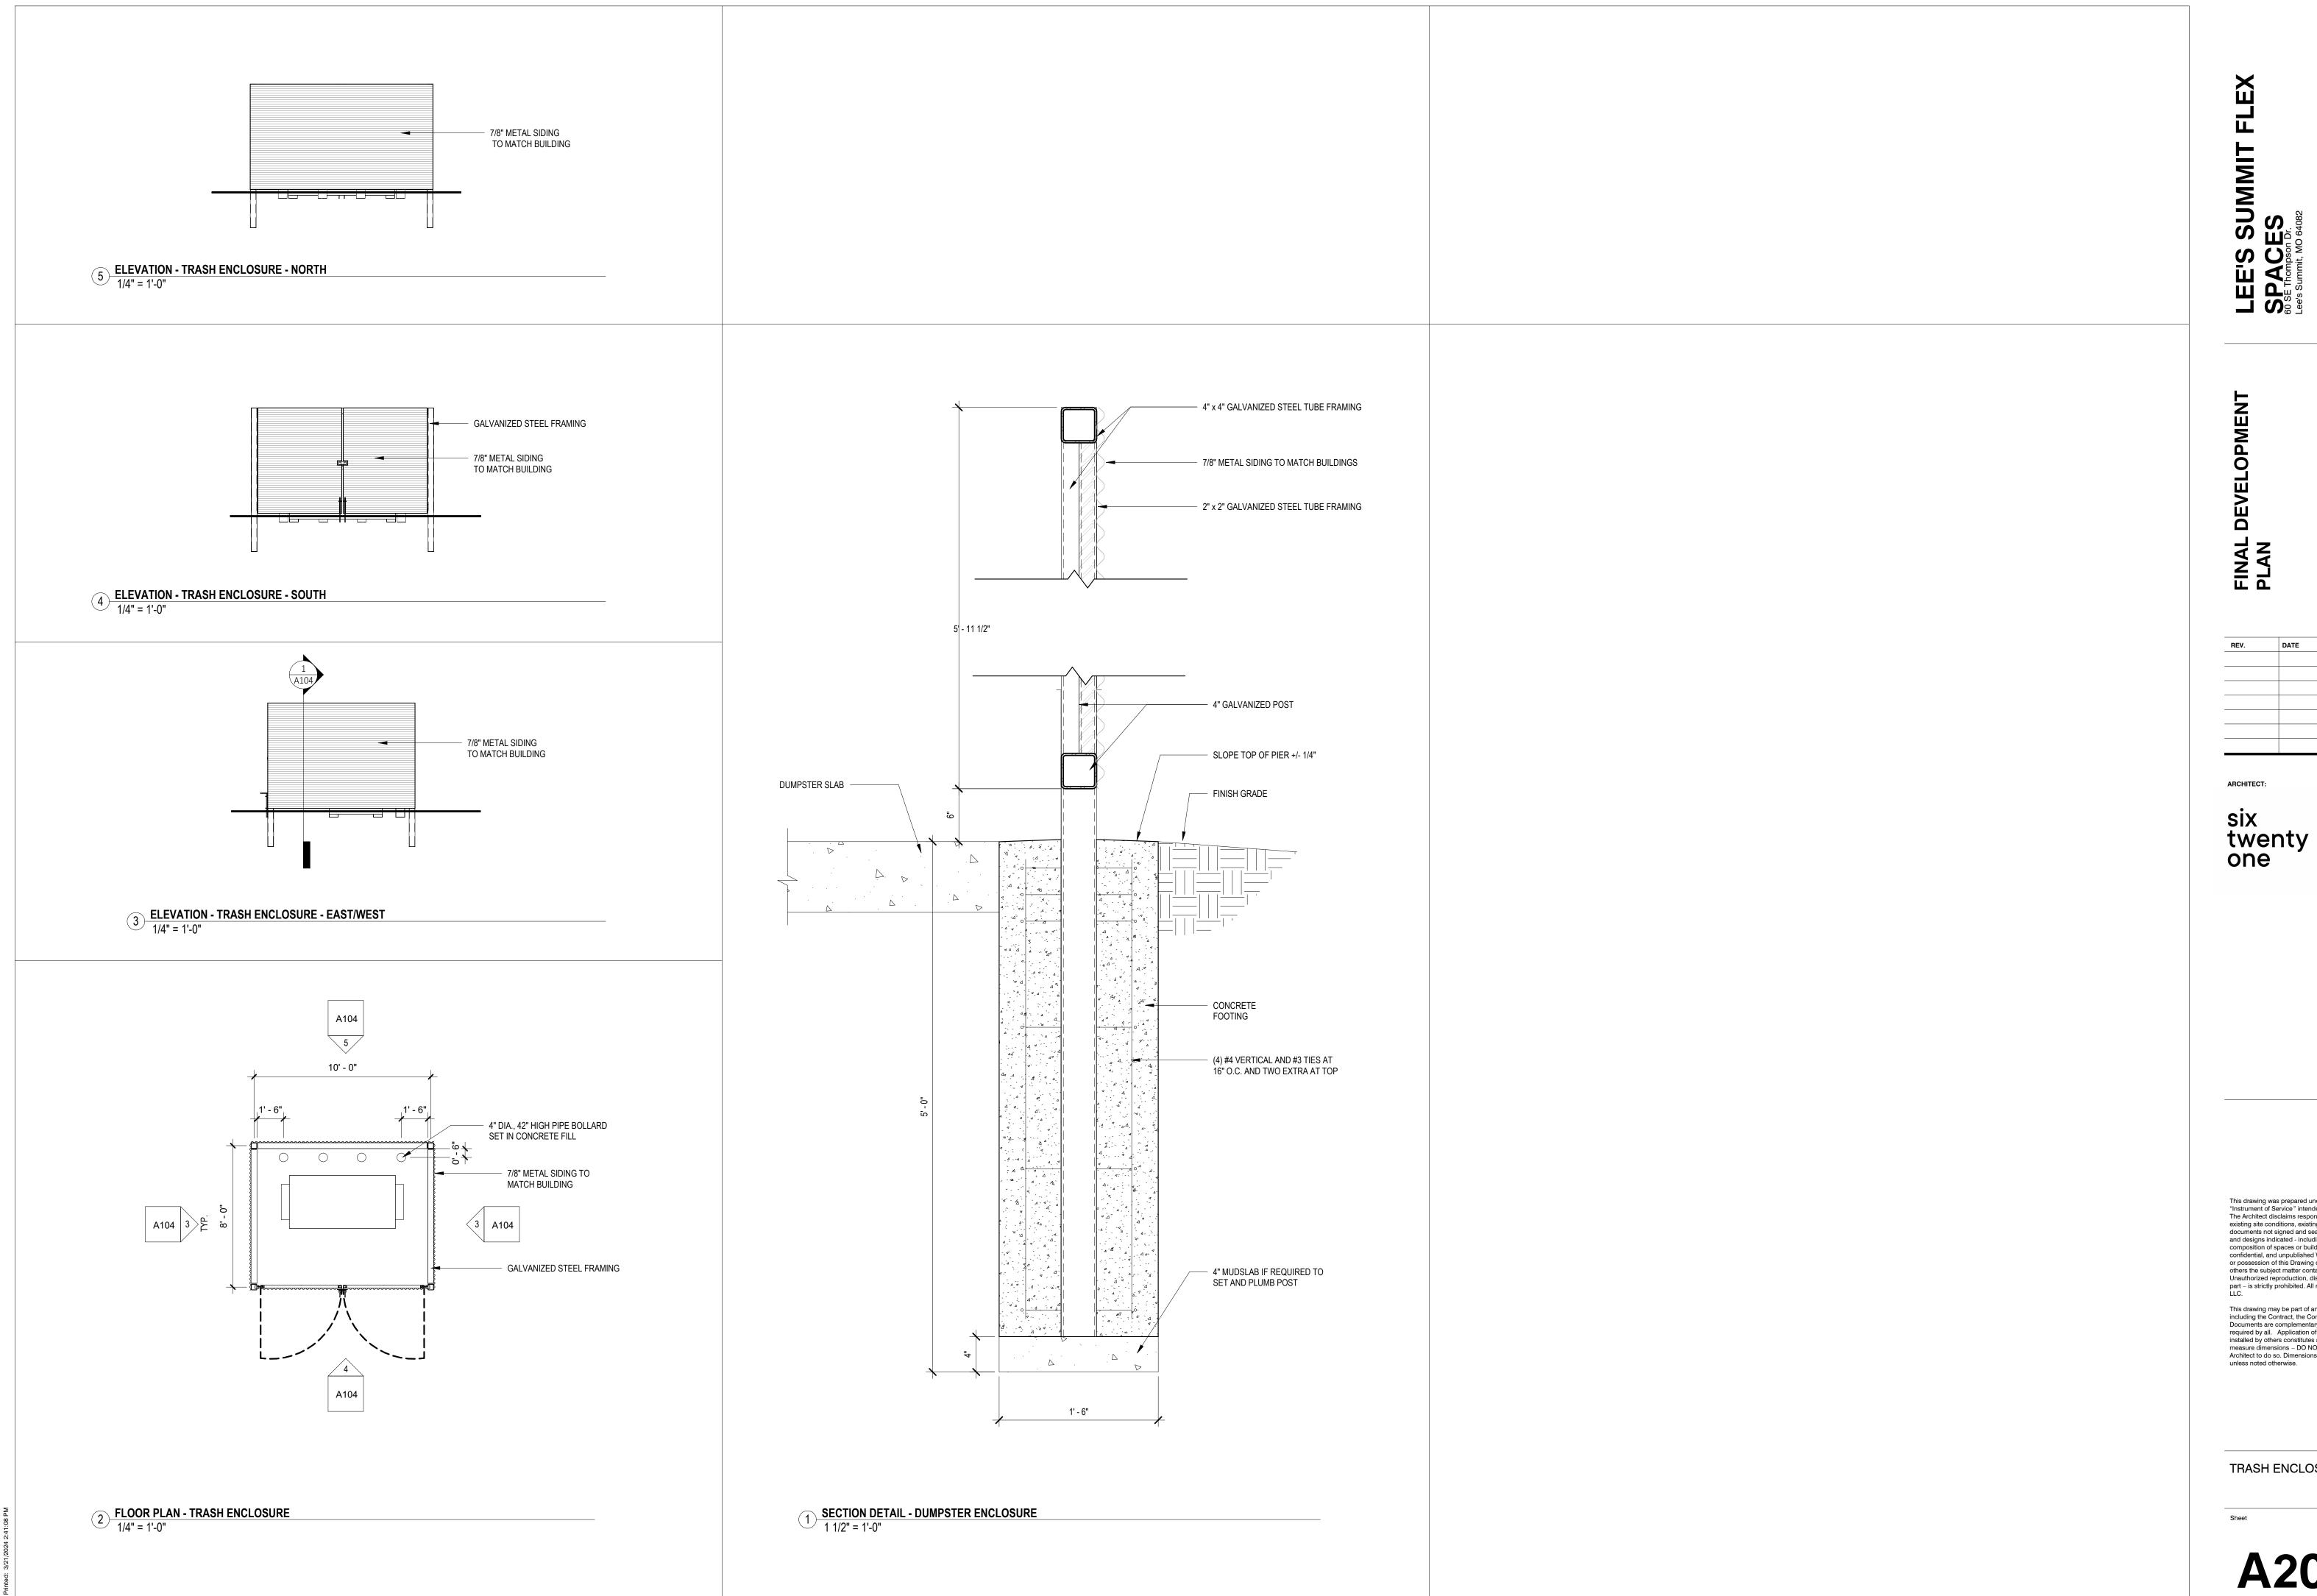

KANSAS CITY, MO 64108 T: 816.694.1369 www.sixtwentyone.com


This drawing was prepared under the Architect 's supervision, and is an "Instrument of Service" intended solely for use by the Client on this project.

The Architect disclaims responsibility for the existing building structure, existing site conditions, existing construction elements, and drawings or documents not signed and sealed by the Architect. The information, ideas and designs indicated - including the overall form, arrangement and composition of spaces or building elements - constitutes the original, confidential, and unpublished Work and property of the Architect. Receipt or possession of this Drawing confers no right in, or license to disclose to others the subject matter contained herein for any but authorized purposes. Unauthorized reproduction, distribution or dissemination – in whole or in part – is strictly prohibited. All rights reserved © 2020 by SixTwentyOne

This drawing may be part of an integrated set of Construction Documents, including the Contract, the Conditions and the Specifications. The Contract Documents are complementary: what is required by one is as binding as if required by all. Application of a material or equipment item to Work installed by others constitutes acceptance of that Work. Calculate and measure dimensions – DO NOT SCALE DRAWINGS unless directed by the Architect to do so. Dimensions indicated are to the face of a material, unless noted otherwise.

TRASH ENCLOSURE PLAN & DETAILS

Revision no.

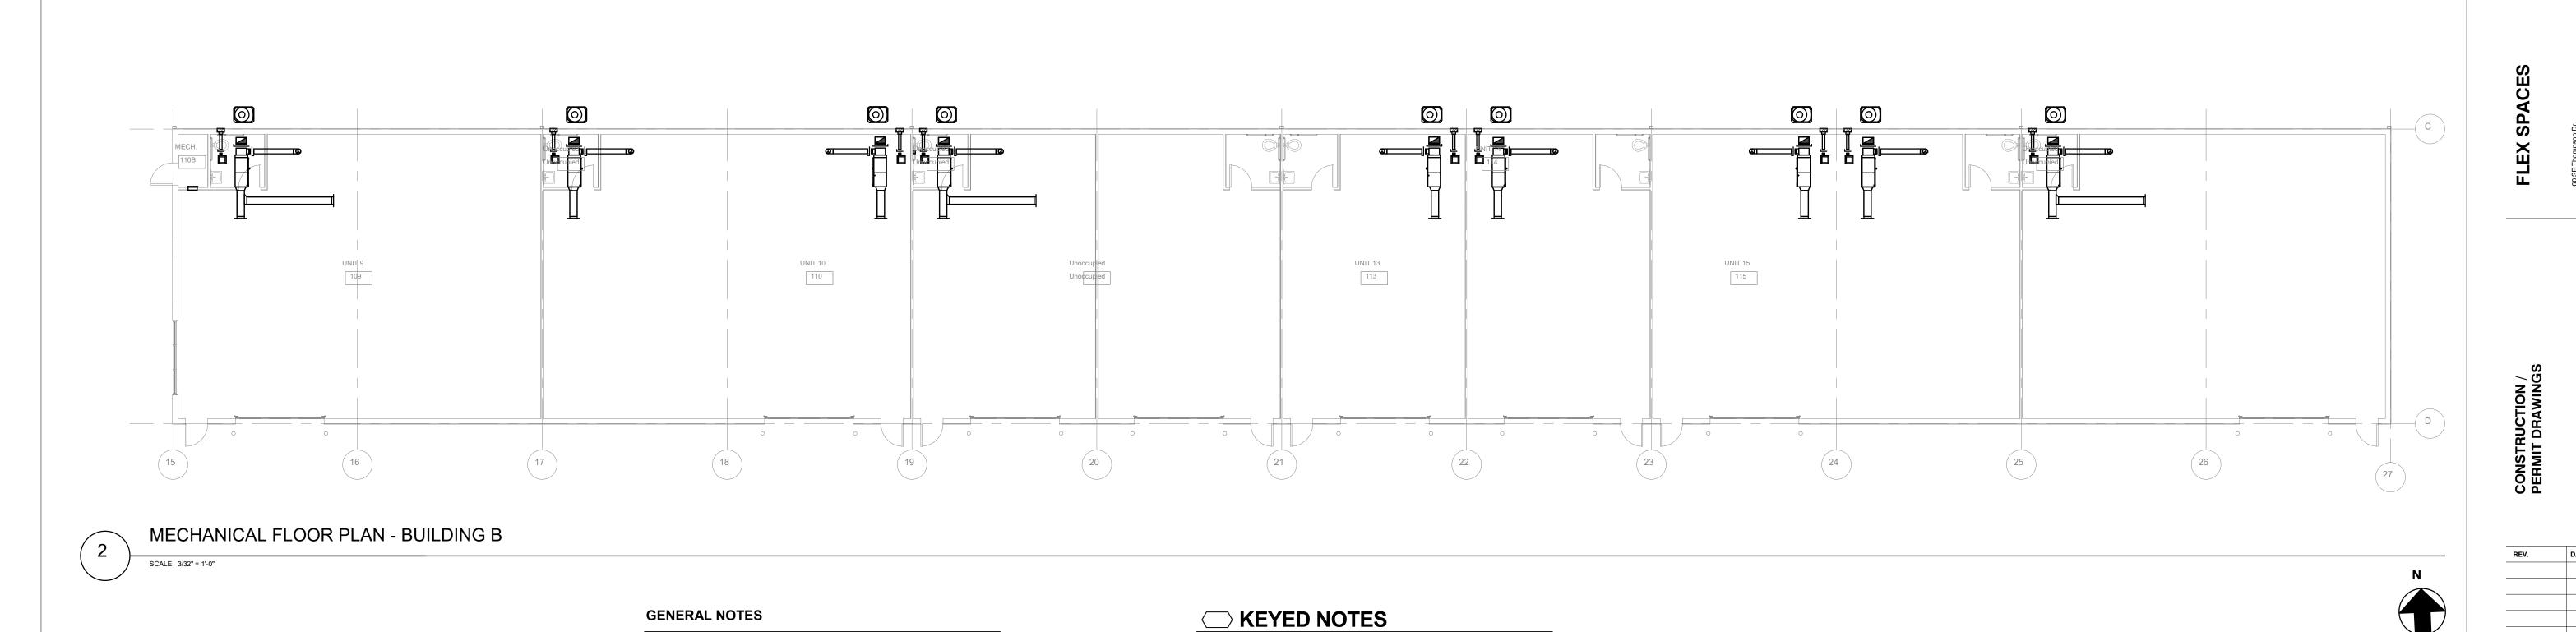

REPLACE THIS NOTE WITH YOUR SHEET SPECIFIC GENERAL NOTES KEEPING THE SAME FORMAT, WIDTH AND POSITION. DELETE THIS NOTE AND TITLE IF YOU DO NOT HAVE ANY NOTES.

six twenty one

1705 SUMMIT ST.
KANSAS CITY, MO
64108
T: 816.694.1369
www.sixtwentyone.com

Six TwentyOne
1705 SUMMIT ST.
KANSAS CITY, MO
64108
T: 816.694.1369
www.sixtwentyone.com

This drawing was prepared under the Architect's supervision, and is an 'Instrument of Service' intended solely for use by the Client on this project. The Architect disclaims responsibility for the existing building structure, existing site conditions, existing construction elements, and drawings or documents not signed and sealed by the Architect. The Information, ideas and designs indicated—including the overall form, arrangement and composition of spaces or building elements—constitutes the original, confidential, and unpublished Work and property of the Architect. Receipt or possession of this Drawing confers no right in, or license to disclose to others the subject matter contained herein for any but authorized purposes. Unauthorized reproduction, distribution or dissemination—in whole or in part—is strictly prohibited, All rights reserved © 2020 by Six TwentyOne LLC.

This drawing may be part of an integrated set of Construction Documents, including the Contract, the Conditions and the Specifications. The Contract Documents are complementary. what is required by one is as binding as if required by all. Application of a material or equipment ten to Work installed


MECHANICAL FLOOR PLANS

M101

MECHANICAL FLOOR PLAN - BUILDING A

SCALE: 3/32" = 1'-0"

nted: 2/22/2024 1:52:05 PM

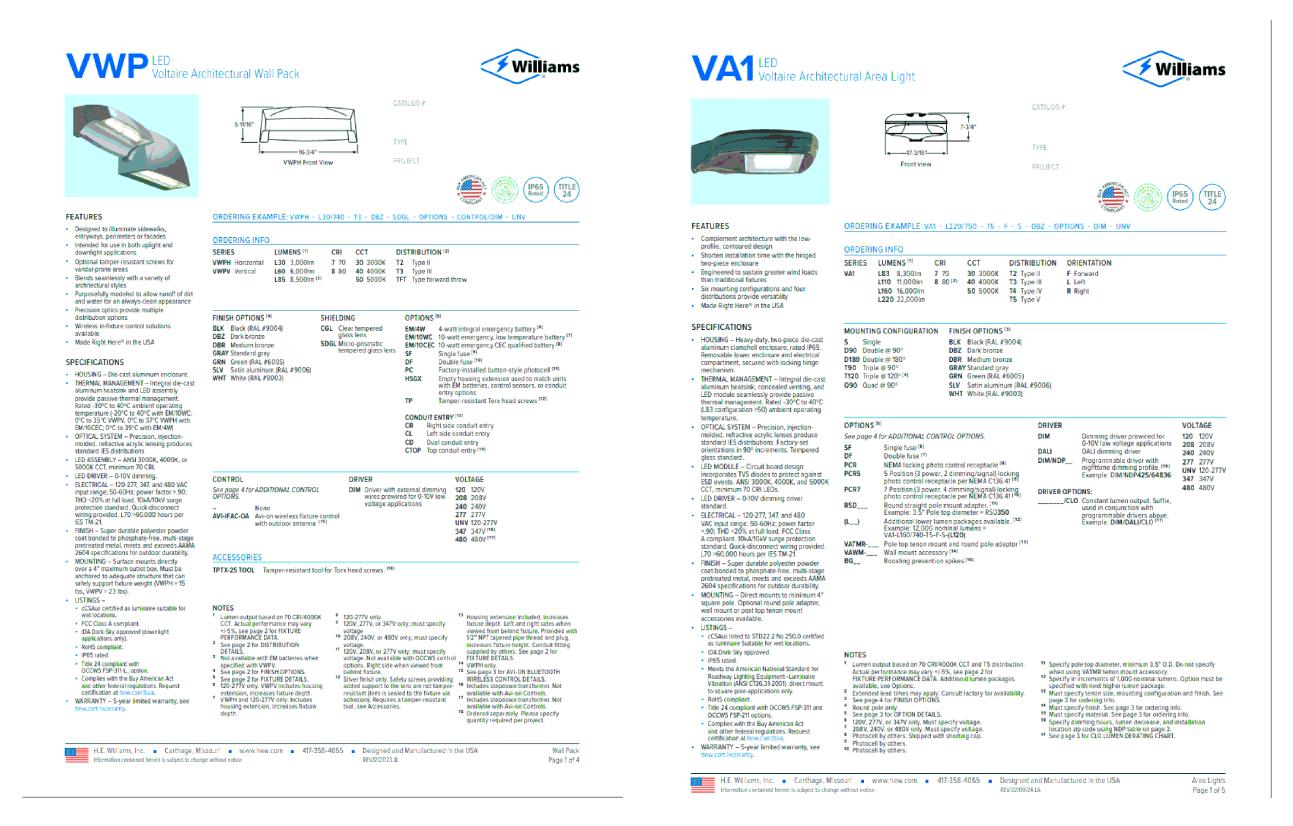

GENERAL NOTES

1. THIS PHOTOMETRIC LAYOUT WAS PRODUCED IN ACCORDANCE WITH THE CITY OF LEE'S SUMMIT, MO UNIFIED DEVELOPMENT ORDINANCE ARTICLE 8, DIVISION I, SUBDIVISION 5 - "LIGHTING STANDARDS". ALL INSTALLATIONS RESULTING FROM THIS DEVELOPMENT PLAN SHALL BE COMPLETED ACCORDING TO THE REQUIREMENTS IN THE LEE'S SUMMIT, MO UNIFIED DEVELOPMENT ORDINANCE AND ANY APPLICABLE SUPPLEMENTS.

© 2023 KIMLEY-HORN AND ASSOCIATES, INC.
805 PENNSYLVANIA AVENUE, SUITE 150
KANSAS CITY, MO 64105
PHONE: 816-652-0350

DESIGNED BY: WPM

DRAWN BY: WPM

805

KAN

WESLEY BY MORRIS

NUMBER
PE-2019041526

02,22,2024

GARVER, LLC 4701 NORTHSHORE DRIVE NORTH LITTLE ROCK, ARKANSAS 72118 501-376-3633 www.GarverUSA.com

CULATIONS

FLEX SPACE
60 SE THOMPSON DR

ORIGINAL ISSUE:
2/22/2024

KHA PROJECT NO.

268442000 SHEET NUMBER


E001


Tag	Description		LLF	Luminaire	Luminair
				Lumens	Watts
S1	VA1-L83-730-	-T3-F-S-xxx-DIM-UN	0.900	7870	67
D	\/\/Pv=L60=73	0-T3-xxx-CGL-DIM-U	1V 0,900	6147	49
Д	V WT X E00 73	0-13-XXX-CGE-DIM-0	0,500	6147	47
Calculation Summary	1				
	Units	Avg Max	Min	Avg/Min	Max/Min
Calculation Summary	1				

CALCULATION SUMMARY & LUMINAIRE SCHEDULE

2 LIGHTING FIXTURE SPECIFICATIONS

 SCALE: N/A

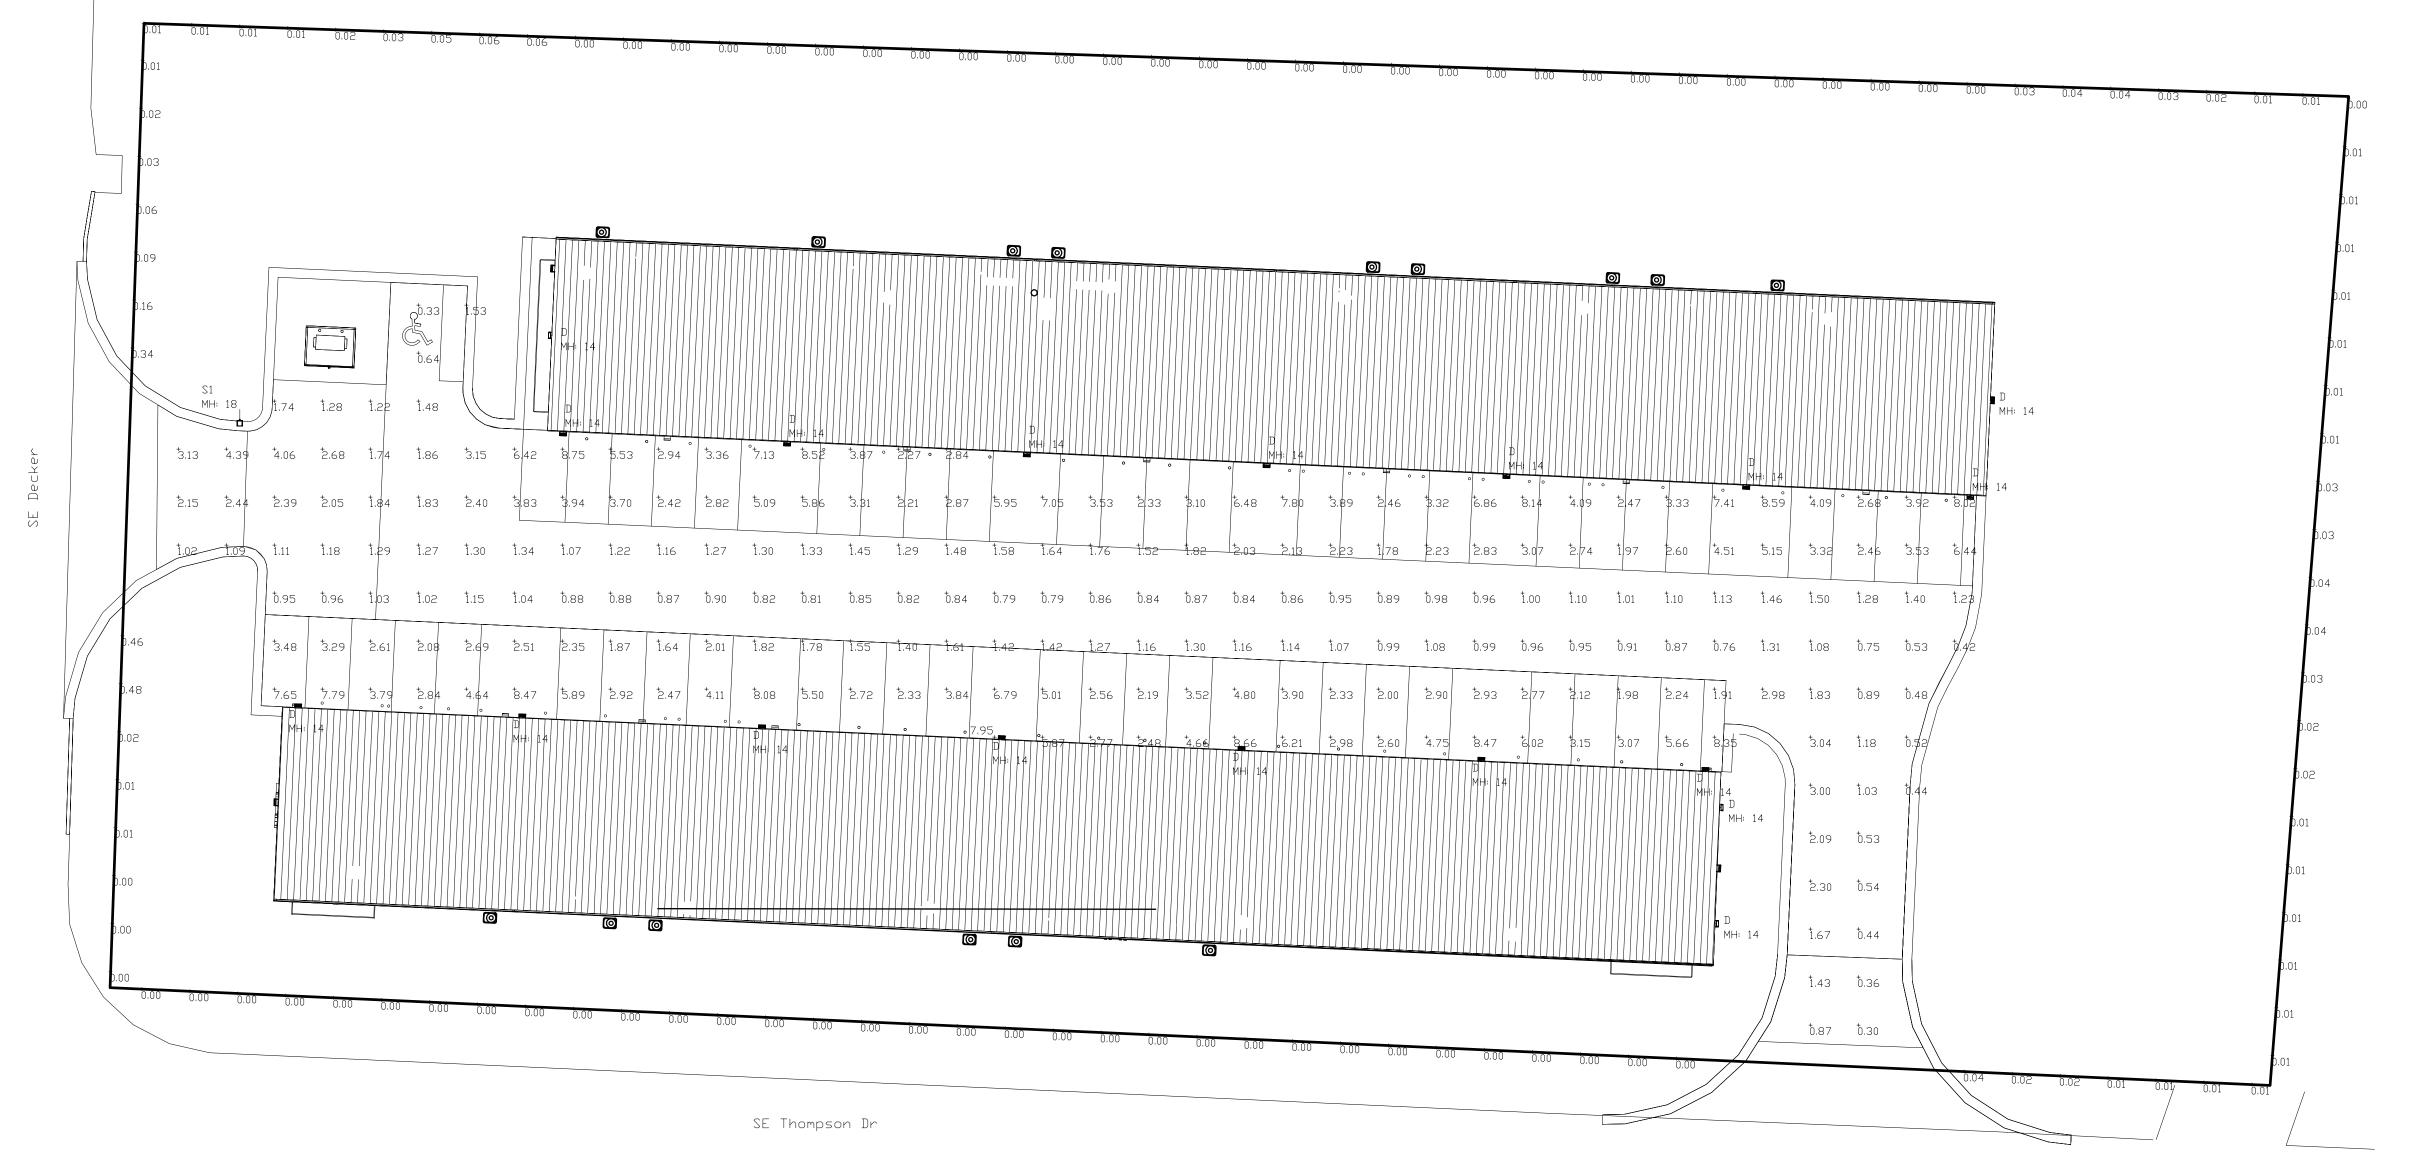



SITE PHOTOMETRIC PLAN

SCALE: 1" = 20'-0"