


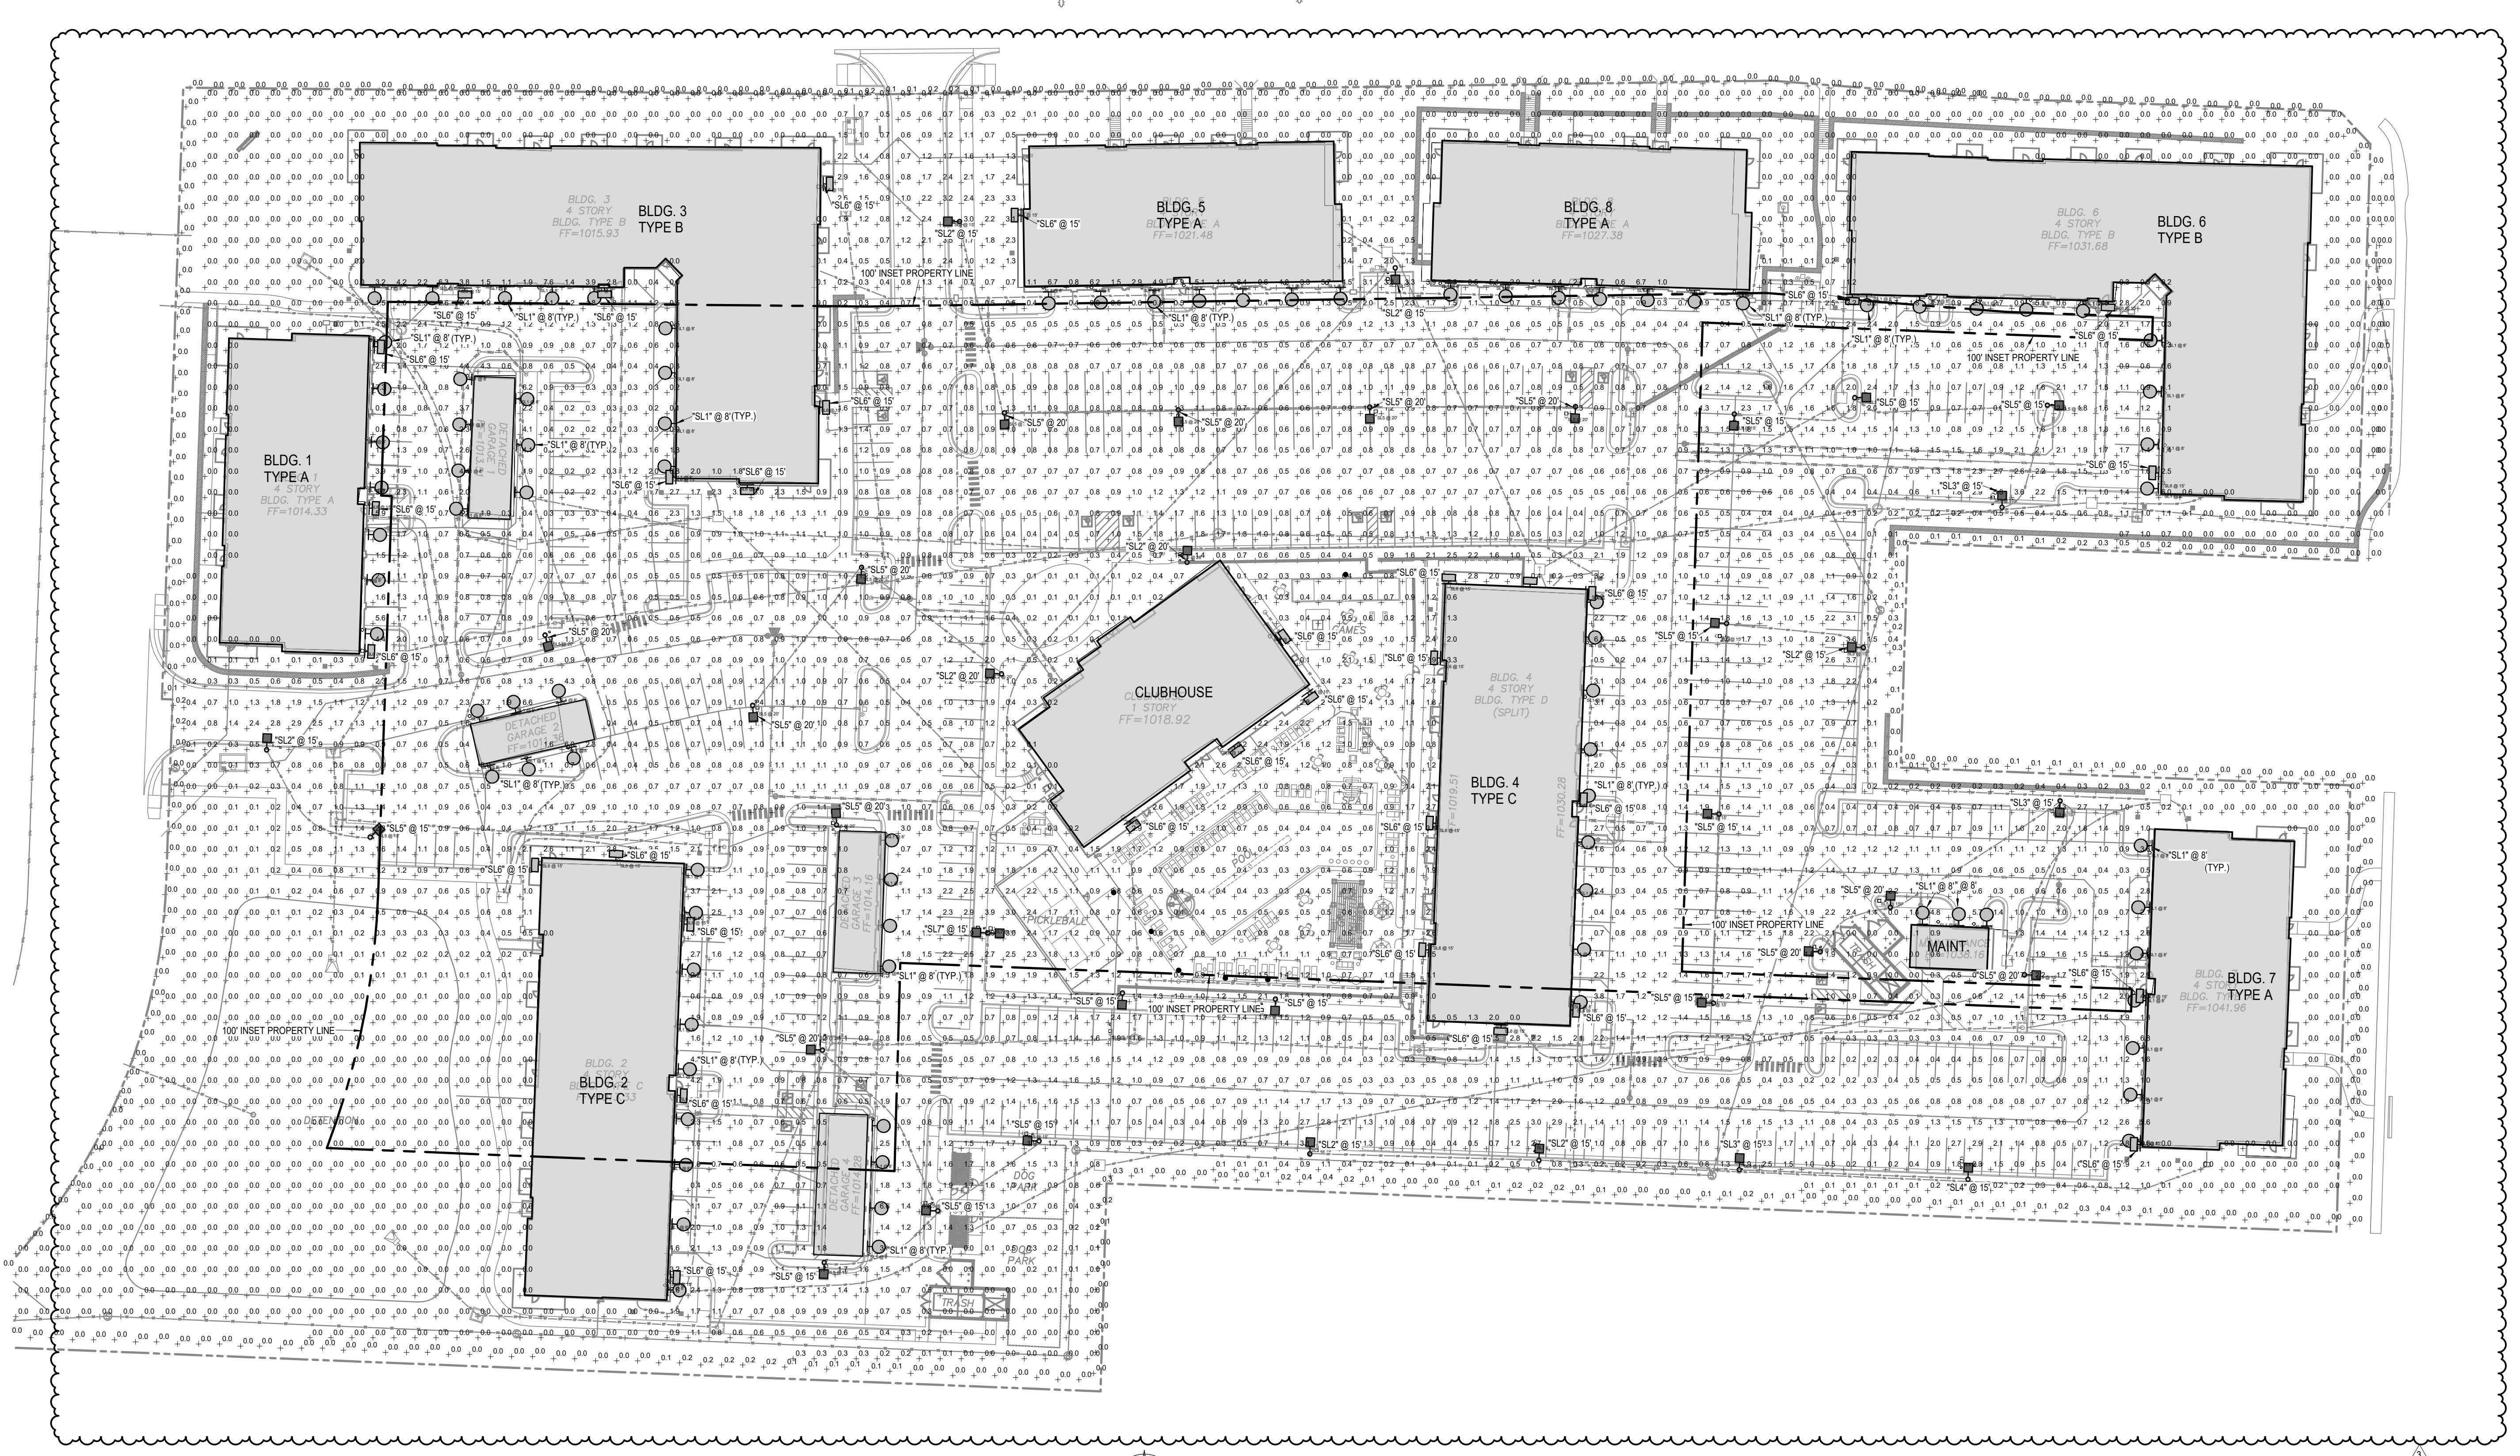

10/29/2024

A NEW MULTI-FAMILY PROJECT:
EVREN APARTMENTS

LEE'S SUMMIT, MISSOURI


DRAWING RELEASE LOG
05.16.24 PERMIT SET

SITE LIGHT FIXTURE SCHEDULE										
MARK	MANUFACTURE	MODEL NUMBER	MOUNTING			LAMPS			REMARKS	
			RECESS	SURFACE	WALL	LED	FLOUR.	HID		
SL 1	PRESCOLITE	1152-962			X	BLACK	X	8W PAR 30 LED	1	1
SL 2	MCGRAW-EDISON	GLEON-SA1A-740-U-T2			POLE	BLACK	X	4,787LUM/34W	1	2, 3
SL 3	MCGRAW-EDISON	GLEON-SA1A-740-U-SL3			POLE	BLACK	X	4,879LUM/34W	1	2, 3
SL 4	MCGRAW-EDISON	GLEON-SA1A-740-U-SL4			POLE	BLACK	X	4,637LUM/34W	1	2, 3
SL 5	MCGRAW-EDISON	GLEON-SA1B-740-U-5WQ			POLE	BLACK	X	6,303LUM/44W	1	2, 3
SL 6	MCGRAW-EDISON	GWC-SA1A-740-U-SL4			POLE	BLACK	X	4,729LUM/34W	1	2
SL 7	MCGRAW-EDISON	GLEON-SA1B-740-U-5WQ			POLE	BLACK	X	6,303LUM/44W	1	2, 3, 4


REMARKS:
1 MOUNT AT 8' AFG.
2 VERIFY MOUNTING HEIGHT WITH PLAN.
3 MOUNT ON SSS POLE.
4 DUAL HEAD

NOTES:
1 FIXTURE/POLE HEIGHTS NOTED ARE FROM GRADE INCLUDING BASE

STATISTICS					
Description	Avg	Max	Min	Max/Min	Avg/Min
Parking Lot	1.1 fc	8.8 fc	0.2 fc	44.0:1	5.5:1
Property Line	0.0 fc	0.5 fc	0.0 fc	N/A	N/A

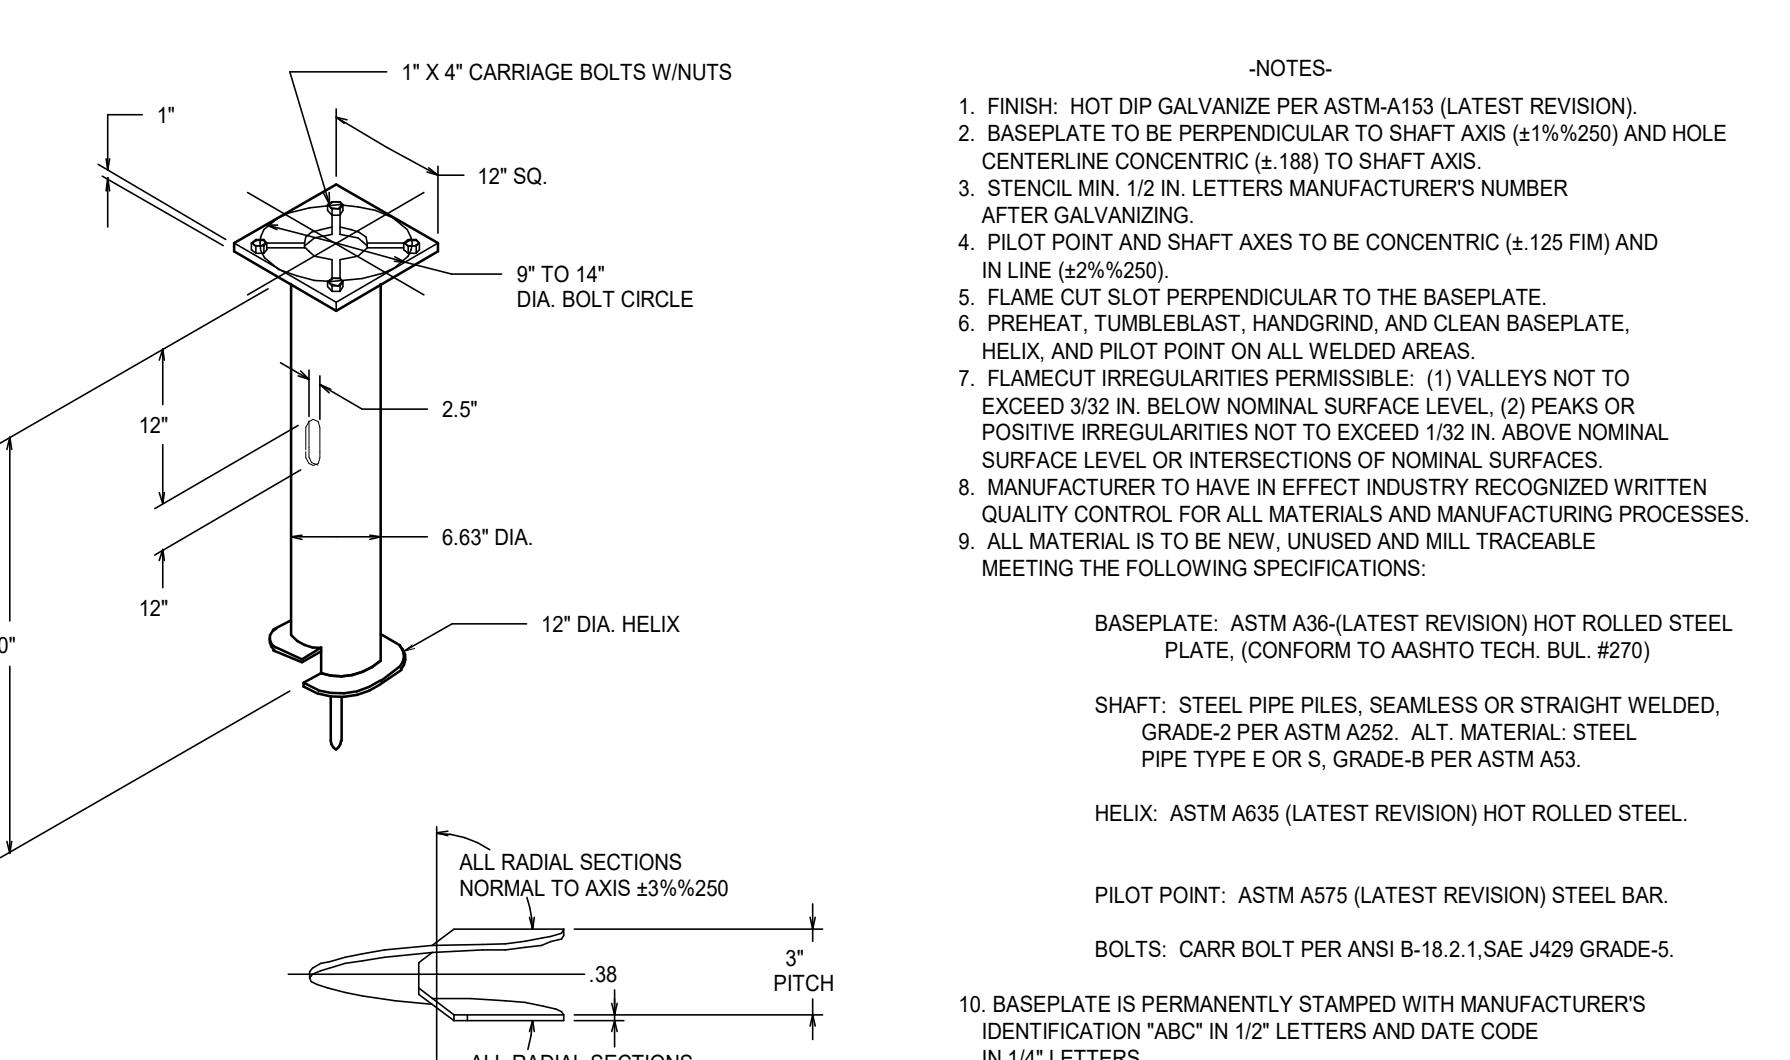

2 LIGHT POLE FOUNDATION
1/8" = 1'-0"

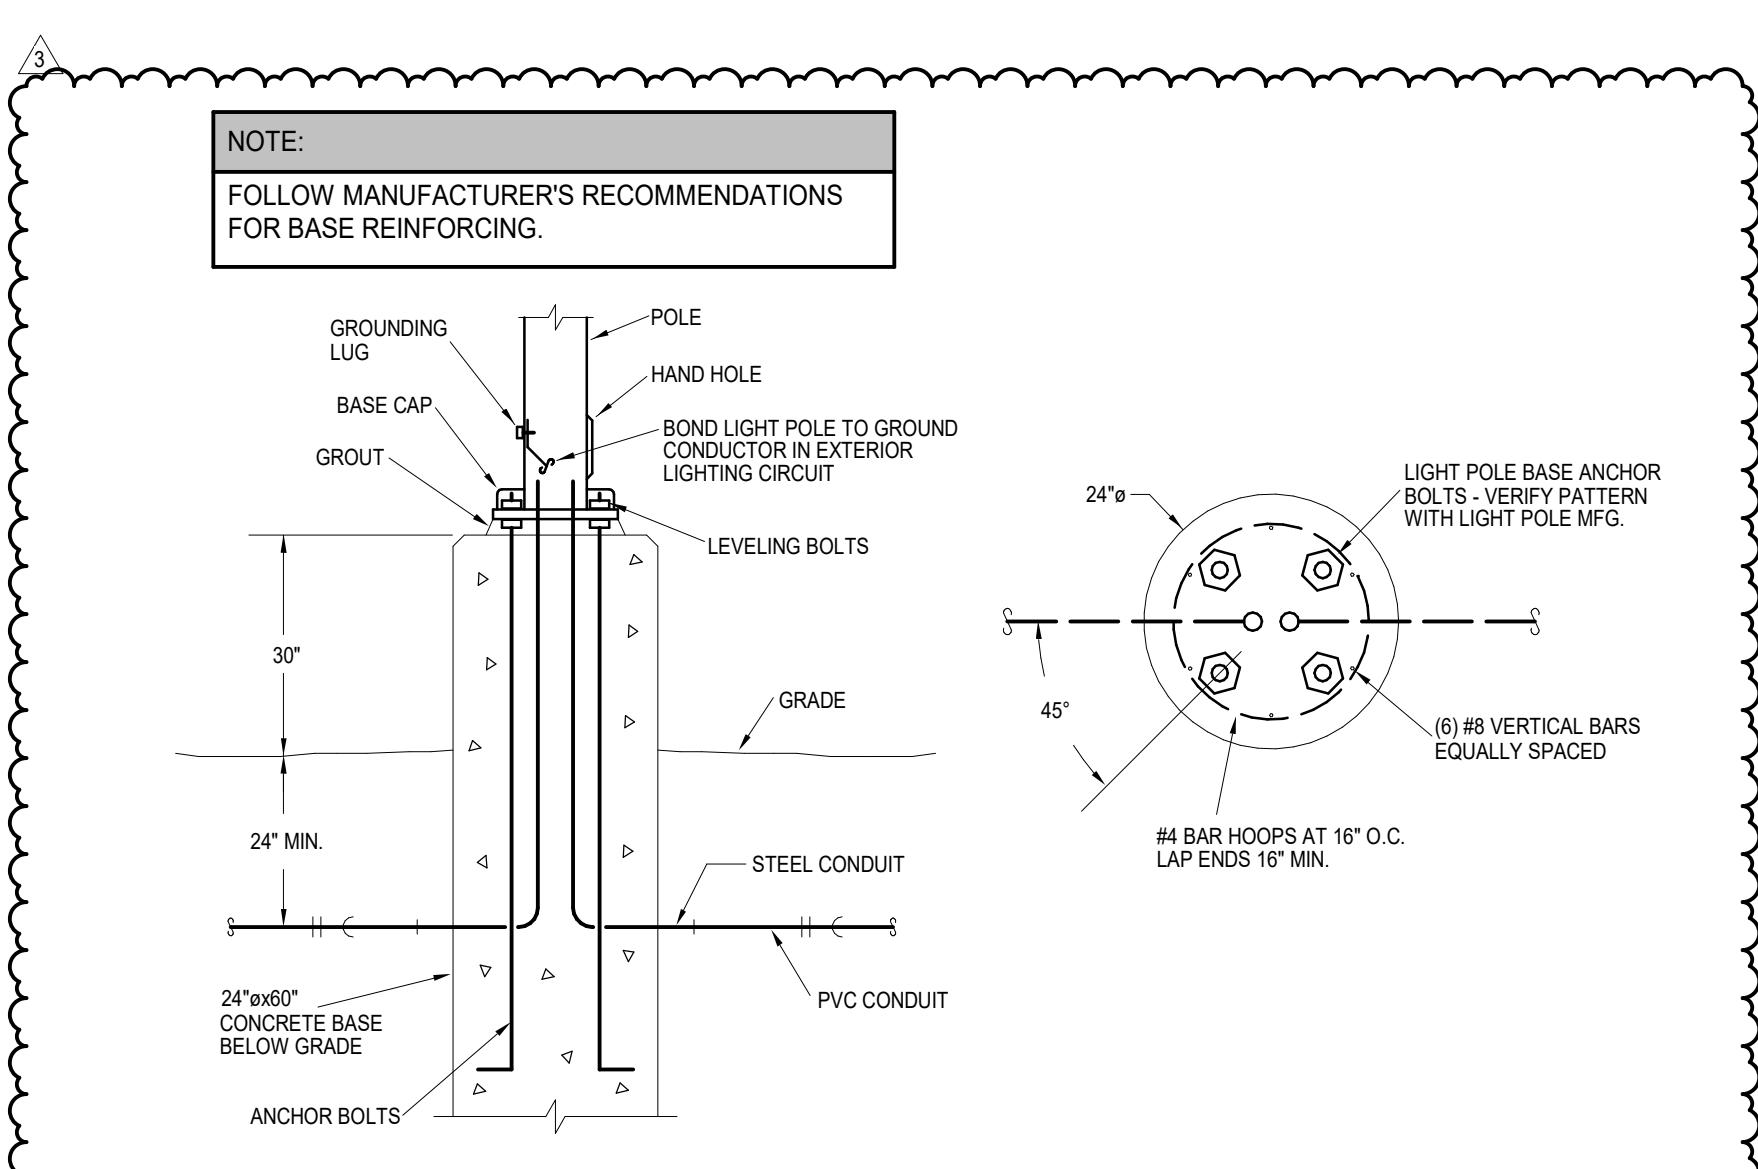

3 30" ABOVE GRADE - LIGHT POLE BASE DETAIL
NOT TO SCALE

JOB NO.
720522
DATE
09.16.2024
DRAWN BY
Author
PERMIT SET

SHEET NAME
SITE PLAN - PHOTOMETRICSHEET NO.
E0.01

LS&A
CONSULTING ENGINEERS
3639 SW Summerfield Drive, Suite A
Topeka, Kansas 6614-3974
One College Station, Suite 102
Overland Park, Kansas 66212
Telephone: (785) 233-3232
Email: lsap@lsap.com
LSA PROJECT NO. 2404027