



BLANCHARD AE GROUP, LLC  
 Laura Blanchard, P.E.  
 Professional Engineer no: 17229  
 1425 Wakarusa Dr. Ste. B  
 Lawrence, KS 66049  
 Ph: 785-993-0300  
 AEGroup@BAE Group

**FALK**  
 ARCHITECTS

© 2009 Falk Architects Inc  
 802 SW 6th Ave. #1  
 Topeka, KS 66603  
 785-338-4920


REVISIONS:

**LIGHT FIXTURE SCHEDULE**

| MARK | MANUF.       | MODEL                           | TYPE      | VOLTS   | MOUNTING    | TOTAL WATTS | FINISH | DESCRIPTION            | NOTES |
|------|--------------|---------------------------------|-----------|---------|-------------|-------------|--------|------------------------|-------|
| T    | LSI LIGHTING | MRM LED'SILFTAL/R'DIM 50 70 BRZ | LED 5000K | 120-277 | POLE D180   | 314         | BRONZE | OUTDOOR LED AREA LIGHT | 1     |
| U    | LSI LIGHTING | MRM LED'SIL5W'DIM 50 70 BRZ     | LED 5000K | 120-277 | POLE D180   | 314         | BRONZE | OUTDOOR LED AREA LIGHT | 1     |
| V    | LSI LIGHTING | MRM LED'SILFT'DIM 50 70 BRZ     | LED 5000K | 120-277 | POLE SINGLE | 314         | BRONZE | OUTDOOR LED AREA LIGHT | 1     |
| W    | LSI LIGHTING | XFLM HF LED 49 HO CW BRZ        | LED 5000K | 120-277 | AT GRADE    | 64          | BRONZE | LED INGROUND LIGHT     | 2     |
| X    | LSI LIGHTING | XWM FT LED 08 50 BRZ            | LED 5000K | 120-277 | WALL MOUNT  | 64          | BRONZE | MIRADA WALL SCONCE     | 2,3   |

NOTES:  
 1. PROVIDE 22' STEEL SQUARE POLE  
 2. CONTRACTOR SHALL PROVIDE ALL COMPONENTS FOR A WATER TIGHT INSTALLATION.  
 3. RECOMMENDED MOUNTING HEIGHT OF 15'-0" A.F.G. COORDINATE WITH THE ARCHITECT.

GENERAL NOTES:  
 A. ALL FIXTURES SHALL BE 4000 K. UNLESS NOTED OTHERWISE.  
 B. PROVIDE ALL REQUIRED ACCESSORIES FOR A COMPLETE INSTALLATION.  
 C. ALL EXTERIOR LIGHTS SHALL HAVE LIGHTING REDUCTION AFTER BUSINESS HOURS, MAINTAIN LIGHTING LEVEL ADEQUATE FOR SECURITY CONCERNS.

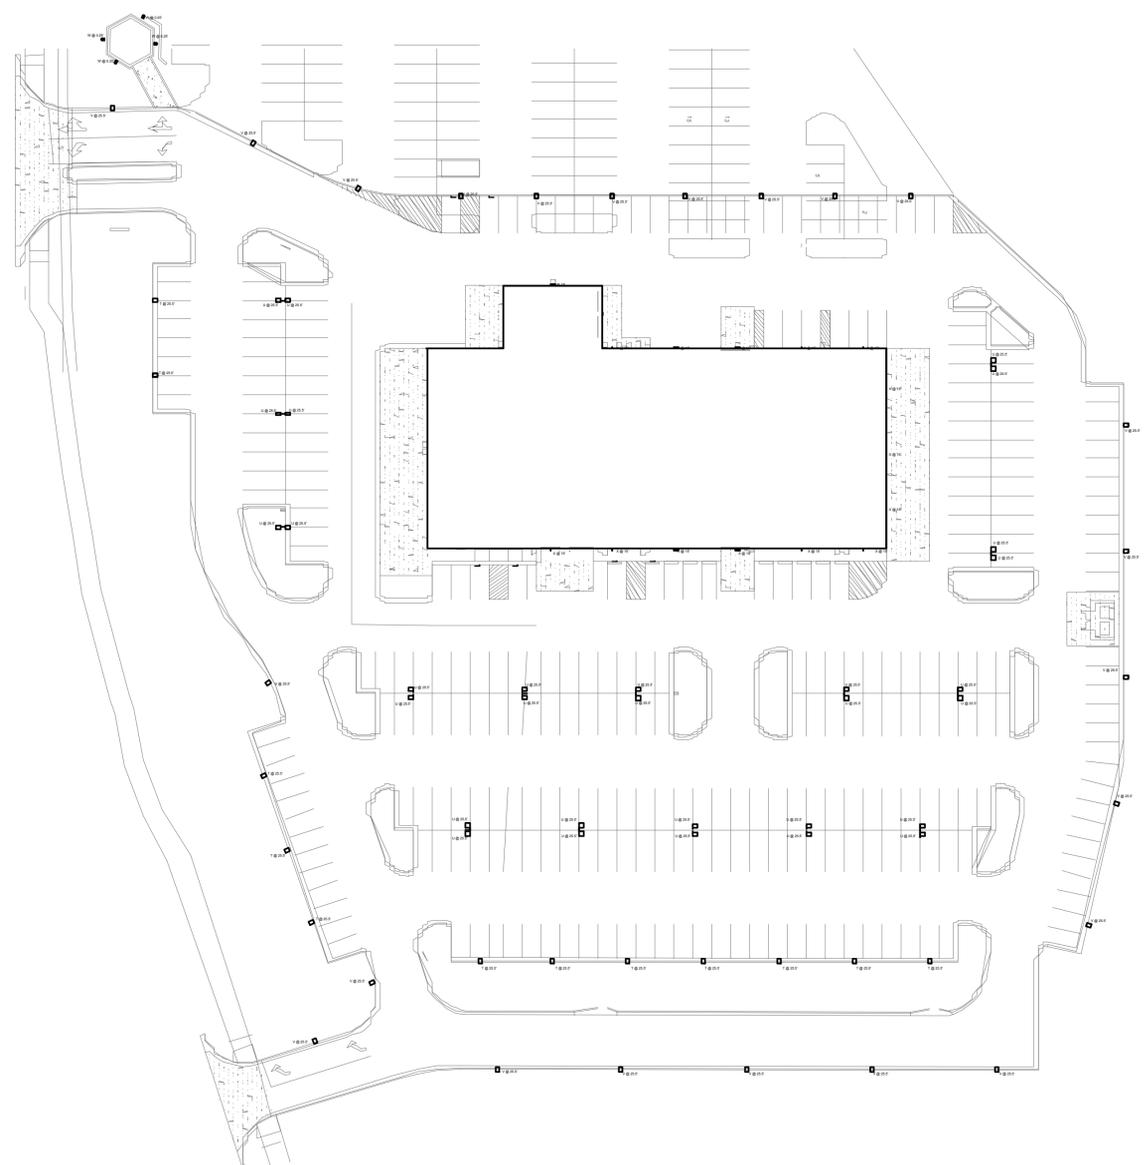

LEE'S SUMMIT HYUNDAI

(NW BLUE PKWY & NW WARD RD) LOT 1A,  
 LEE'S SUMMIT, MO 64086

ENGINEER OF RECORD  
 Laura Blanchard, P.E. - License No. 17229  
 PHONE: 785-993-0300

ISSUE DATE: 01-10-2025  
 JOB NUMBER: 241099  
 DRAWN BY: RTI/BML  
 CHECKED BY: LMB

LIGHTING SITE PLAN

**MEP2.2**

BID SET

01 Lighting Site Plan  
 Scale: 1"=40'